


LEGEND : (Plumbing)

S.No.	SYMBOL	DESCRIPTION
1.		150Ø YARD HYDRANT PIPE
2.		YH YARD HYDRANT

18 M WIDE ROAD

SITE PLAN

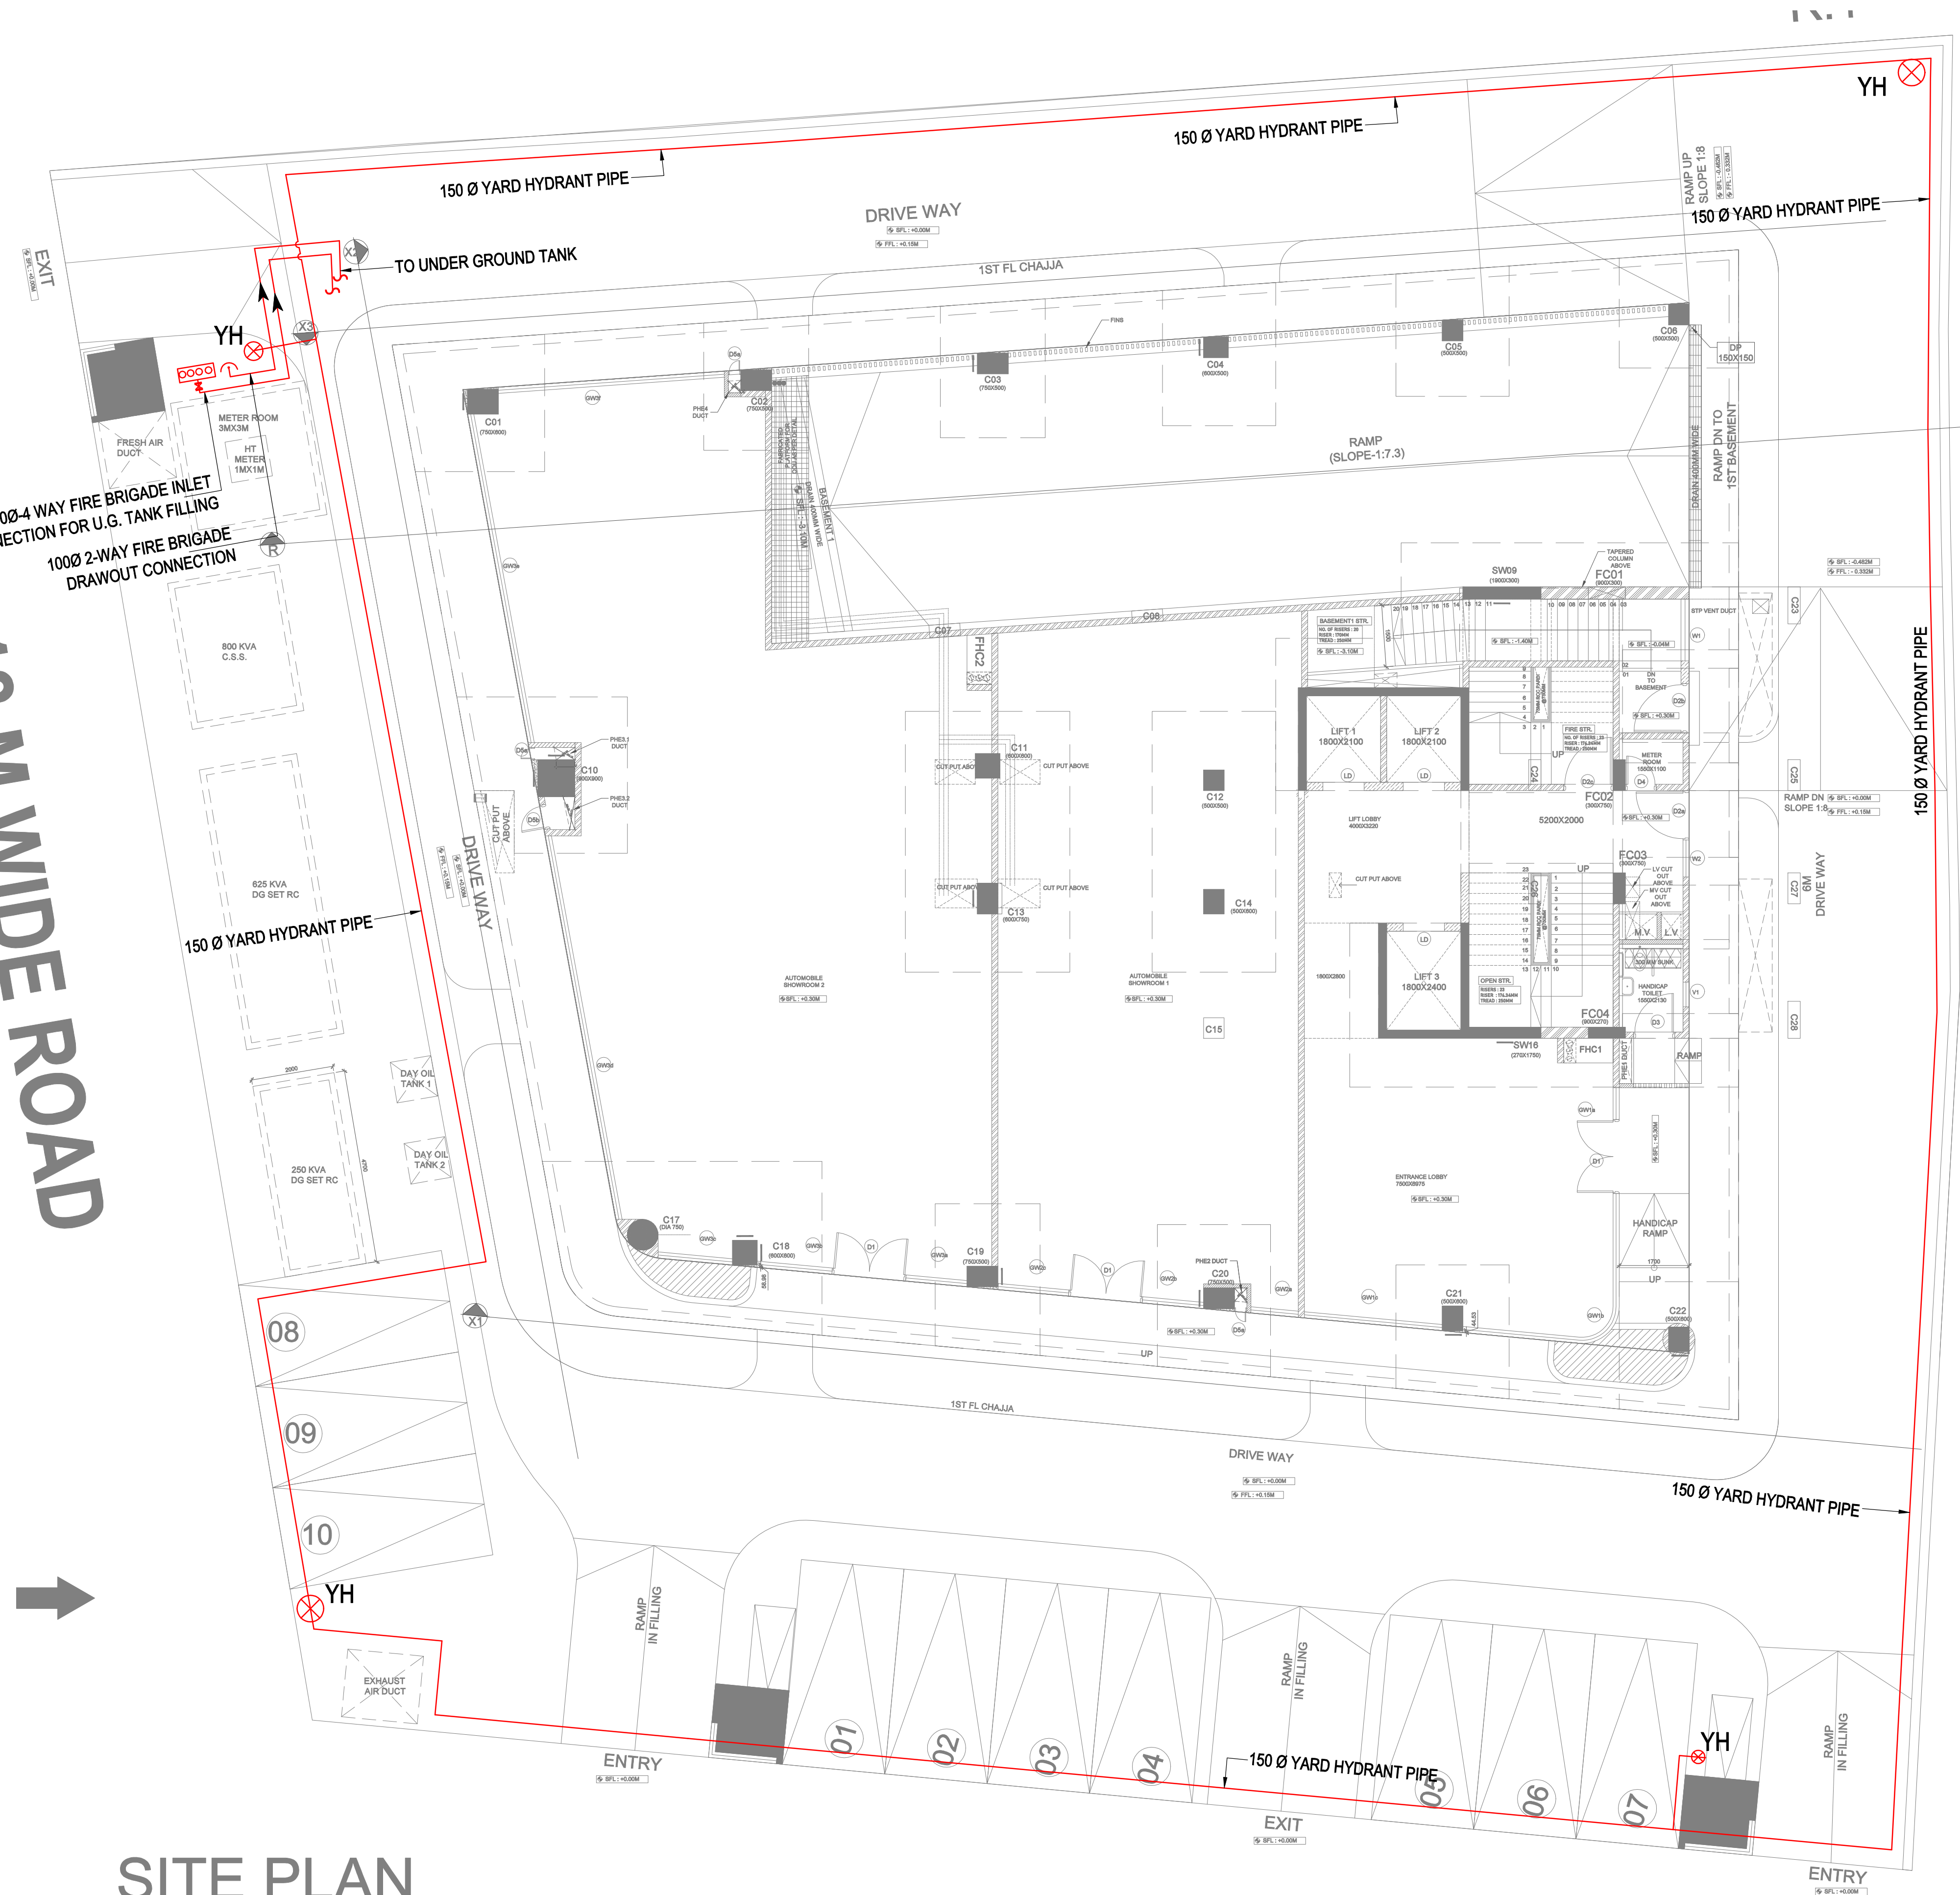

01.	09.01.2025	As Per New Architect Plan
Rev. no.	Date	Revision
Project:- MAHIMA PRIMUS PLOT NO. 03, AERO CITY, TONK ROAD JAIPUR		
Architect:- 		
MEP Consultants :- P.K. Kalra Consultants ENGINEERING+ENVIRONMENT+ISO F-67, Green Park Main, New Delhi-110 016, INDIA Tel. : 011- 41618888, 43045477 e-mail : pkkalraconsultants@gmail.com		
Drawing Title :- FIRE FIGHTING		
Subtitle :- SITE PLAN FIRE FIGHTING LAYOUT		
Drawing Released for :- ☐ SCHEMATIC DRAWING ☐ TENDER ☐ APPROVAL ☒ SUBMISSION ☐ CONSTRUCTION ☐ ADVANCE COPY		
Drq . no :- PKKC/ MAC / SP / EFF-01	Drawn by :- Sameer	
Scale :- 1:90 @ A1	Checked by :- Rohan Dixit	
Date :- 16.09.2023	Approved by :- P.K. Kalra	
Rev :- R - 01	North 	