


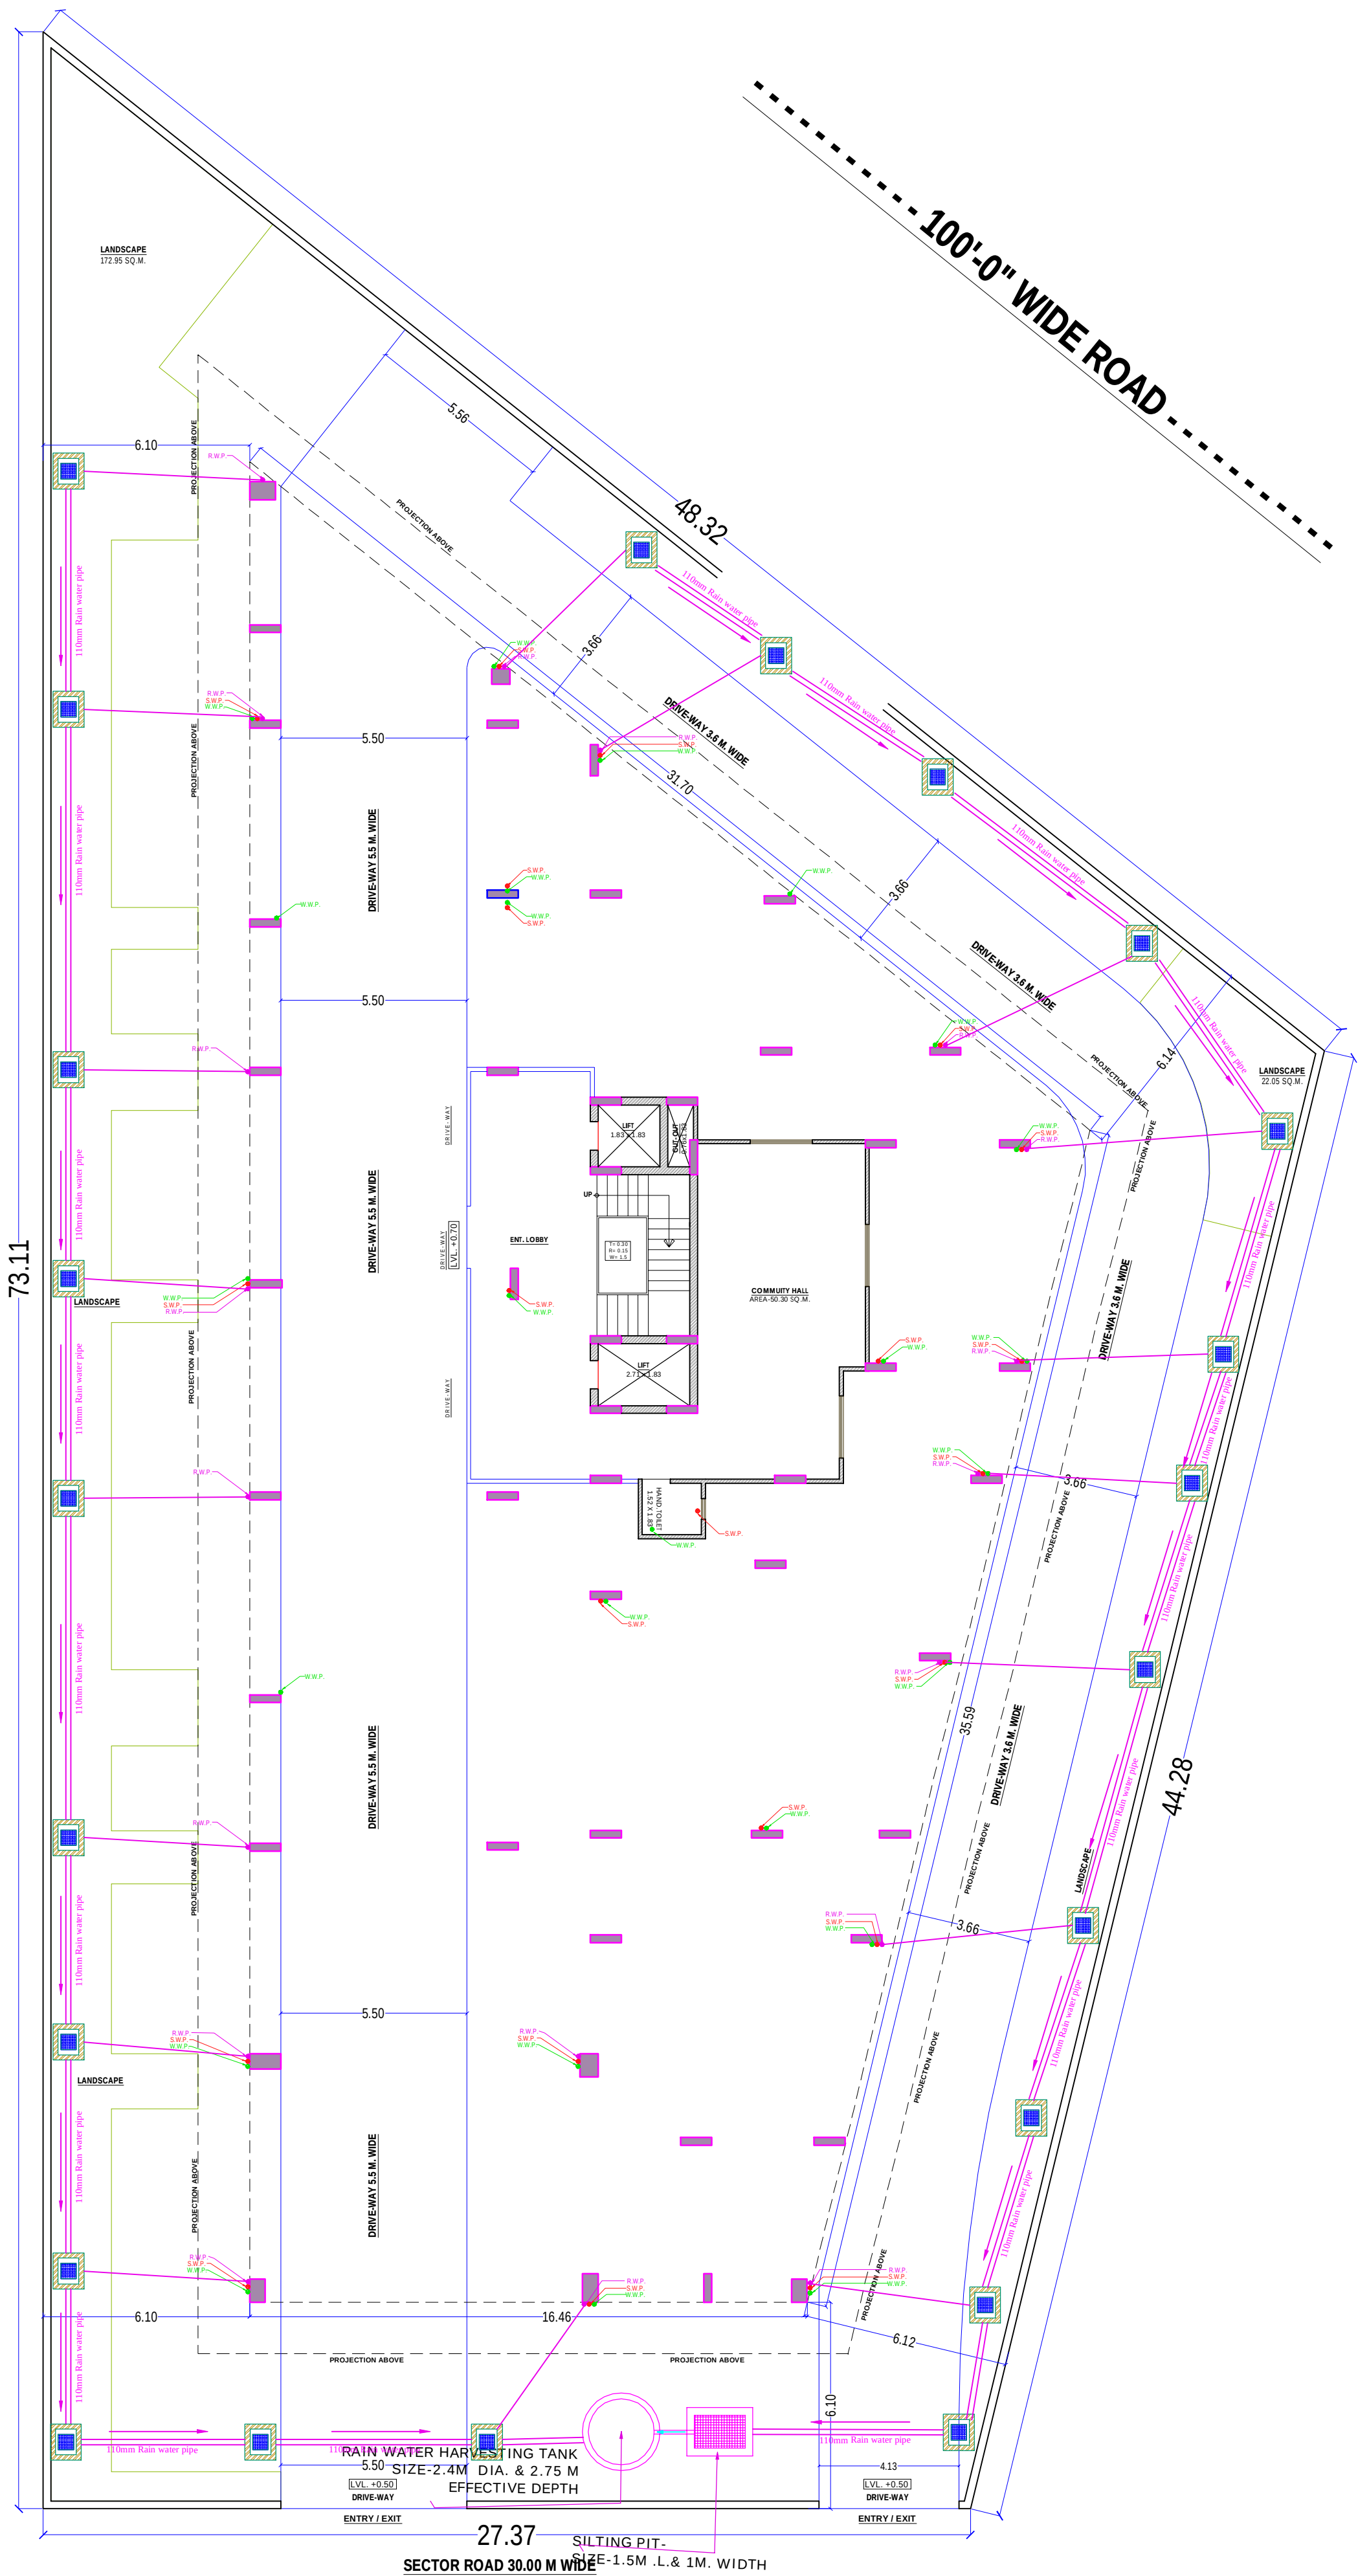

STILT FLOOR PLAN

SECTOR ROAD 30.00 M WIDE

LEGENDS:-	
	WASTE WATER MANHOLE 450X450MM DEPTH- 300MM
	SEWERAGE MANHOLE 900 mm Dia
	MANHOLE 900X800MM
	SEWERAGE MANHOLE 600X600MM
SYMBOL	DESCRIPTION
	110 mm Soil Waste Water Pipe
	110 mm Waste Water Pipe
	110 mm Rain Water Pipe
	FOLLOW DIRECTION

PROJECT:

THE PEAK
PROPOSED RESIDENTIAL BUILDING AT
KHASRA NO. - 29/1, AT VILLAGE -
GRIDHARIPURA, JAIPUR.

DRAWING:

**RAIN WATER
HARVENSTING LAYOUT PLAN**

ARCHITECT:

ARCHITECTS, INTERIOR DESIGNERS AND ENGINEERS

SERVICES CONSULTANT:

Naman Yadav
B.Tech (Service Consultant)

344,Mansarovar plaza,Jaipur


WORKING LAYOUT PLAN


PROPOSAL PLAN

SH.NO.01SCALE: NTS

NOTE

THIS DRAWING IS THE SOLE PROPERTY OF
SPACE EDGE ARCHITECTS AND IS NOT TO
BE COPIED, USED OR REPRODUCED FOR
ANY PURPOSE OTHER THAN FOR WHICH IT
HAS BEEN LOANED.

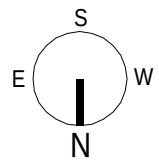

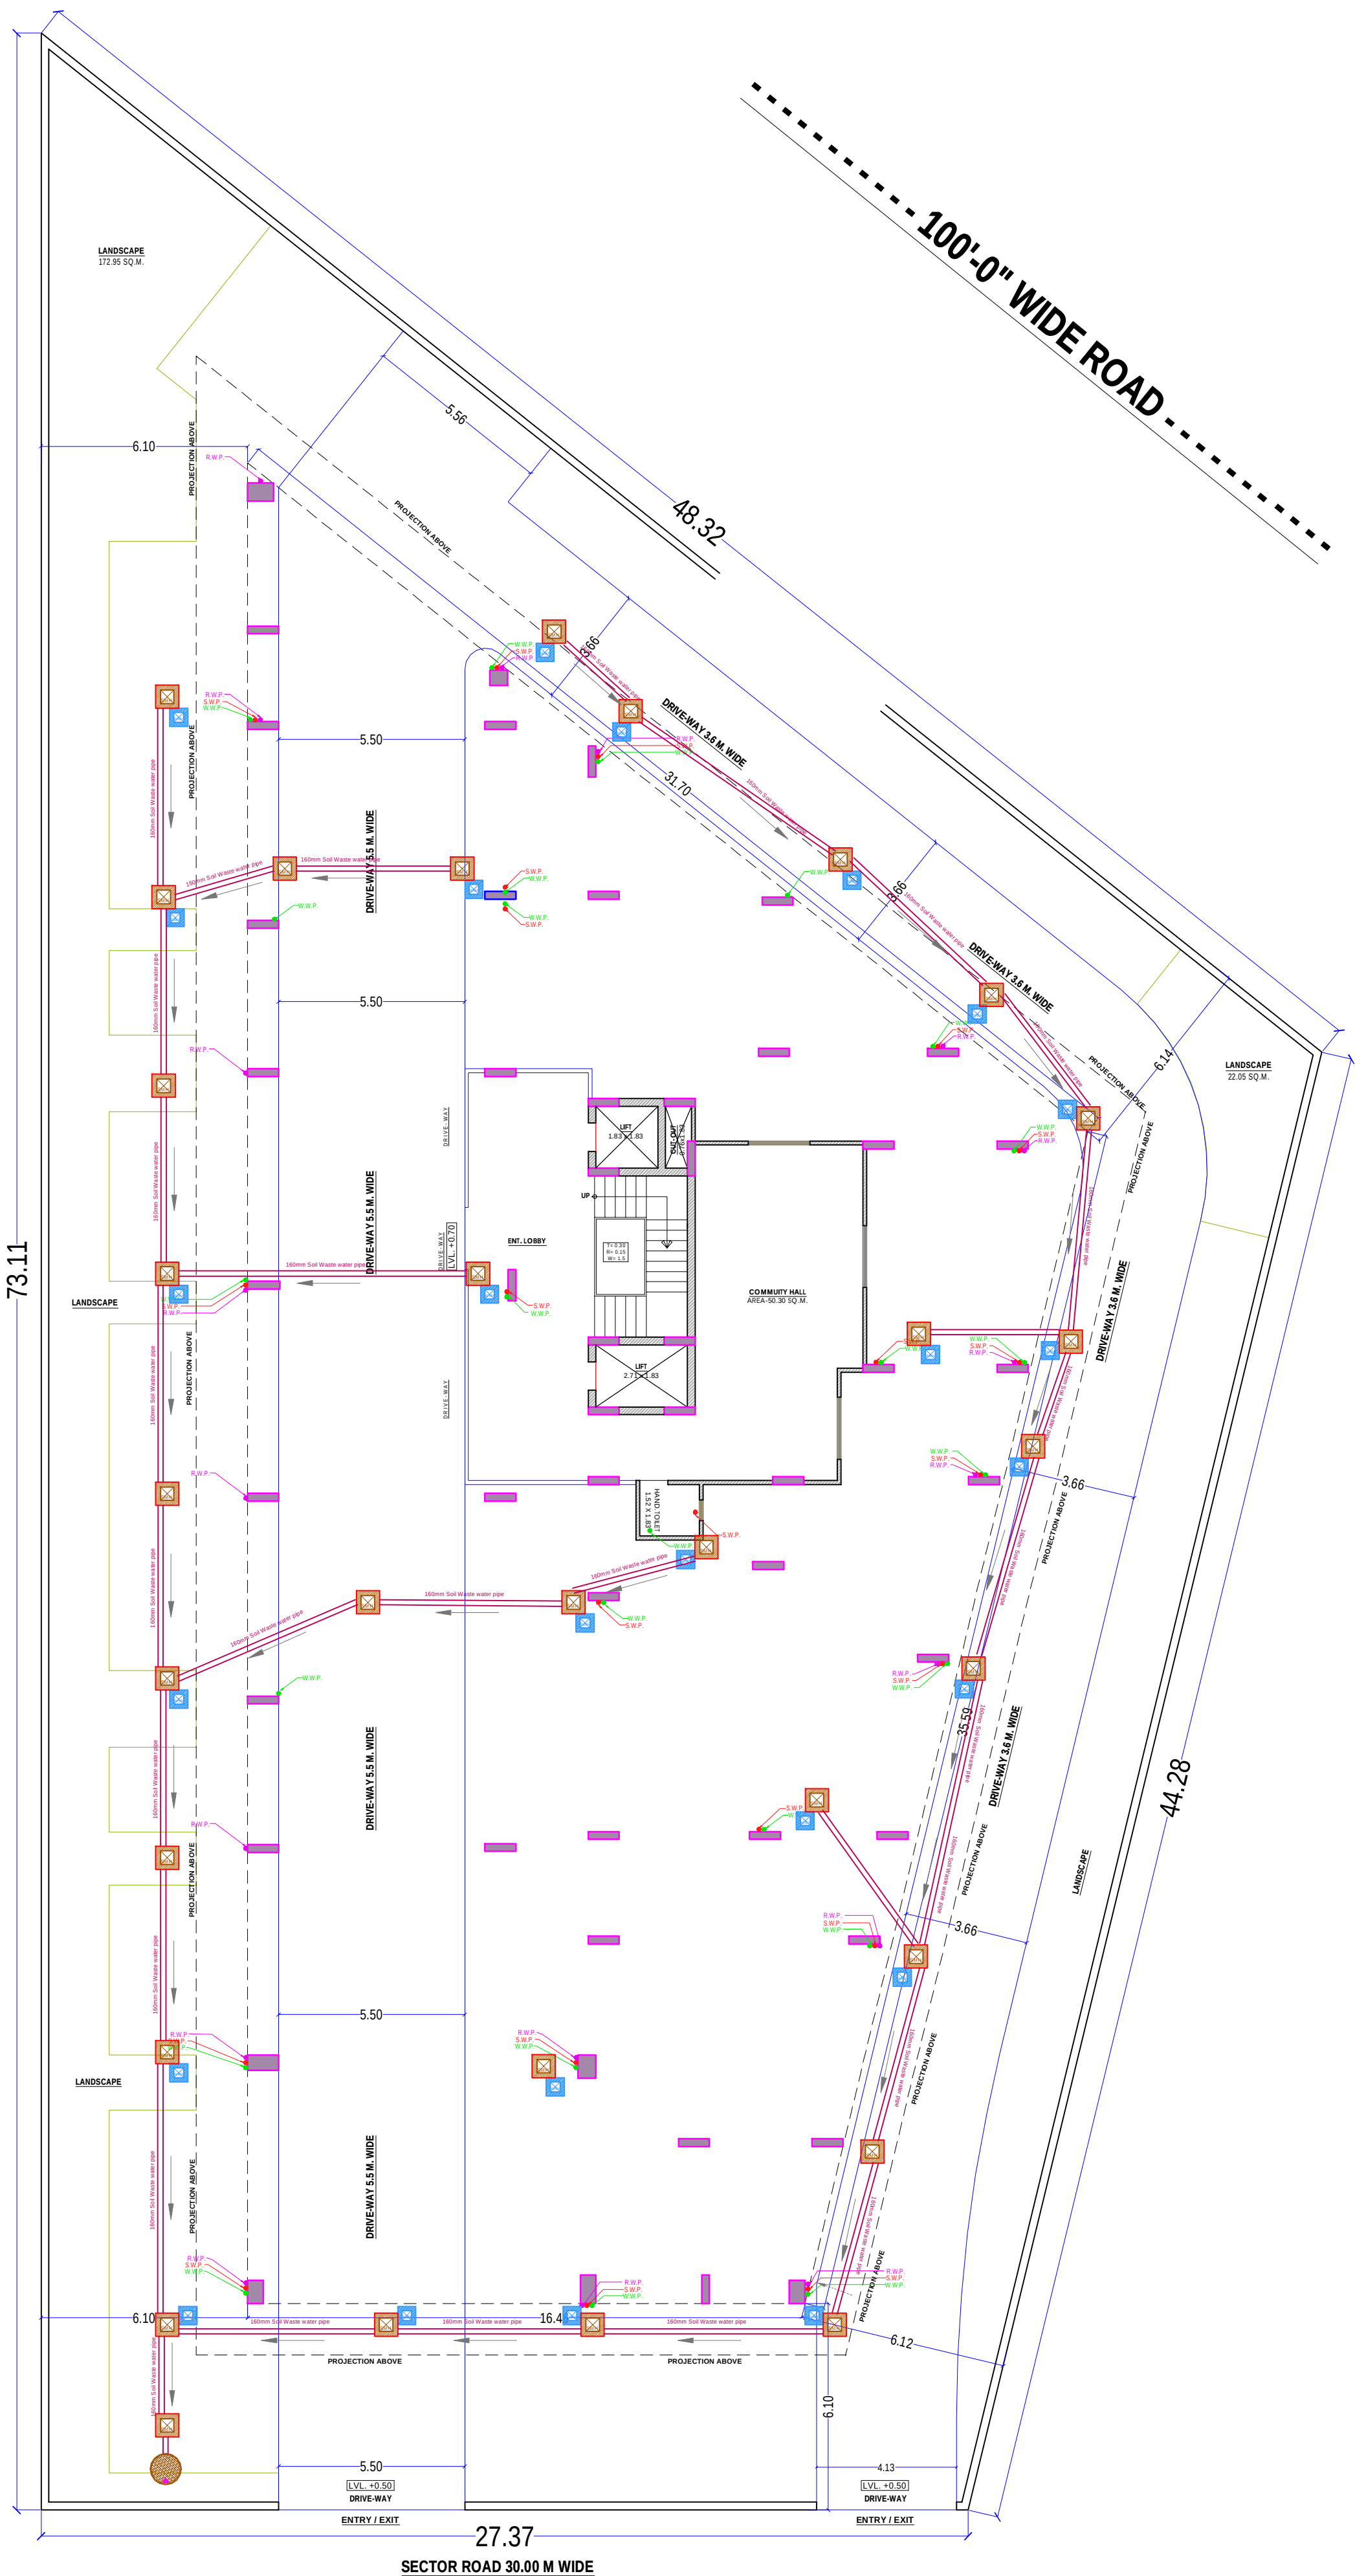

STILT FLOOR PLAN

SECTOR ROAD 30.00 M WIDE

LEGENDS:-	
	WASTE WATER MANHOLE 450X450MM DEPTH- 300MM
	SEWERAGE MANHOLE 900 mm Dia
	MANHOLE 900X800MM
	SEWERAGE MANHOLE 600X600MM
SYMBOL	DESCRIPTION
	110 mm Soil Waste Water Pipe
	110 mm Waste Water Pipe
	110 mm Rain Water Pipe
	FOLLOW DIRECTION

PROJECT:	
THE PEAK PROPOSED RESIDENTIAL BUILDING AT KHASRA NO. - 29/1, AT VILLAGE - GRIDHARIPURA, JAIPUR.	
DRAWING:	
STILT FLOOR EXTERNAL SEWER CHAMBER & PIPES ROUTE PLAN	
ARCHITECT:	
 space edgeArchitects ARCHITECTS, INTERIOR DESIGNERS AND ENGINEERS	
SERVICES CONSULTANT:	
 Naman Yadav B.Tech (Service Consultant)	
344,Mansarovar plaza,Jaipur	
WORKING LAYOUT PLAN	
PROPOSAL PLAN SH.NO. 01 SCALE: NTS S E W N	
NOTE	

THIS DRAWING IS THE SOLE PROPERTY OF
SPACE EDGE ARCHITECTS AND IS NOT TO
BE COPIED, USED OR REPRODUCED FOR
ANY PURPOSE OTHER THAN FOR WHICH IT
HAS BEEN LOANED.