

DRIVEWAY 18'4" WIDE


F.F. LVL. +0.30M

DRIVEWAY 18'4" WIDE

F.F. LVL. +0.30M

DROP OFF

F.F. LVL. +0.30M

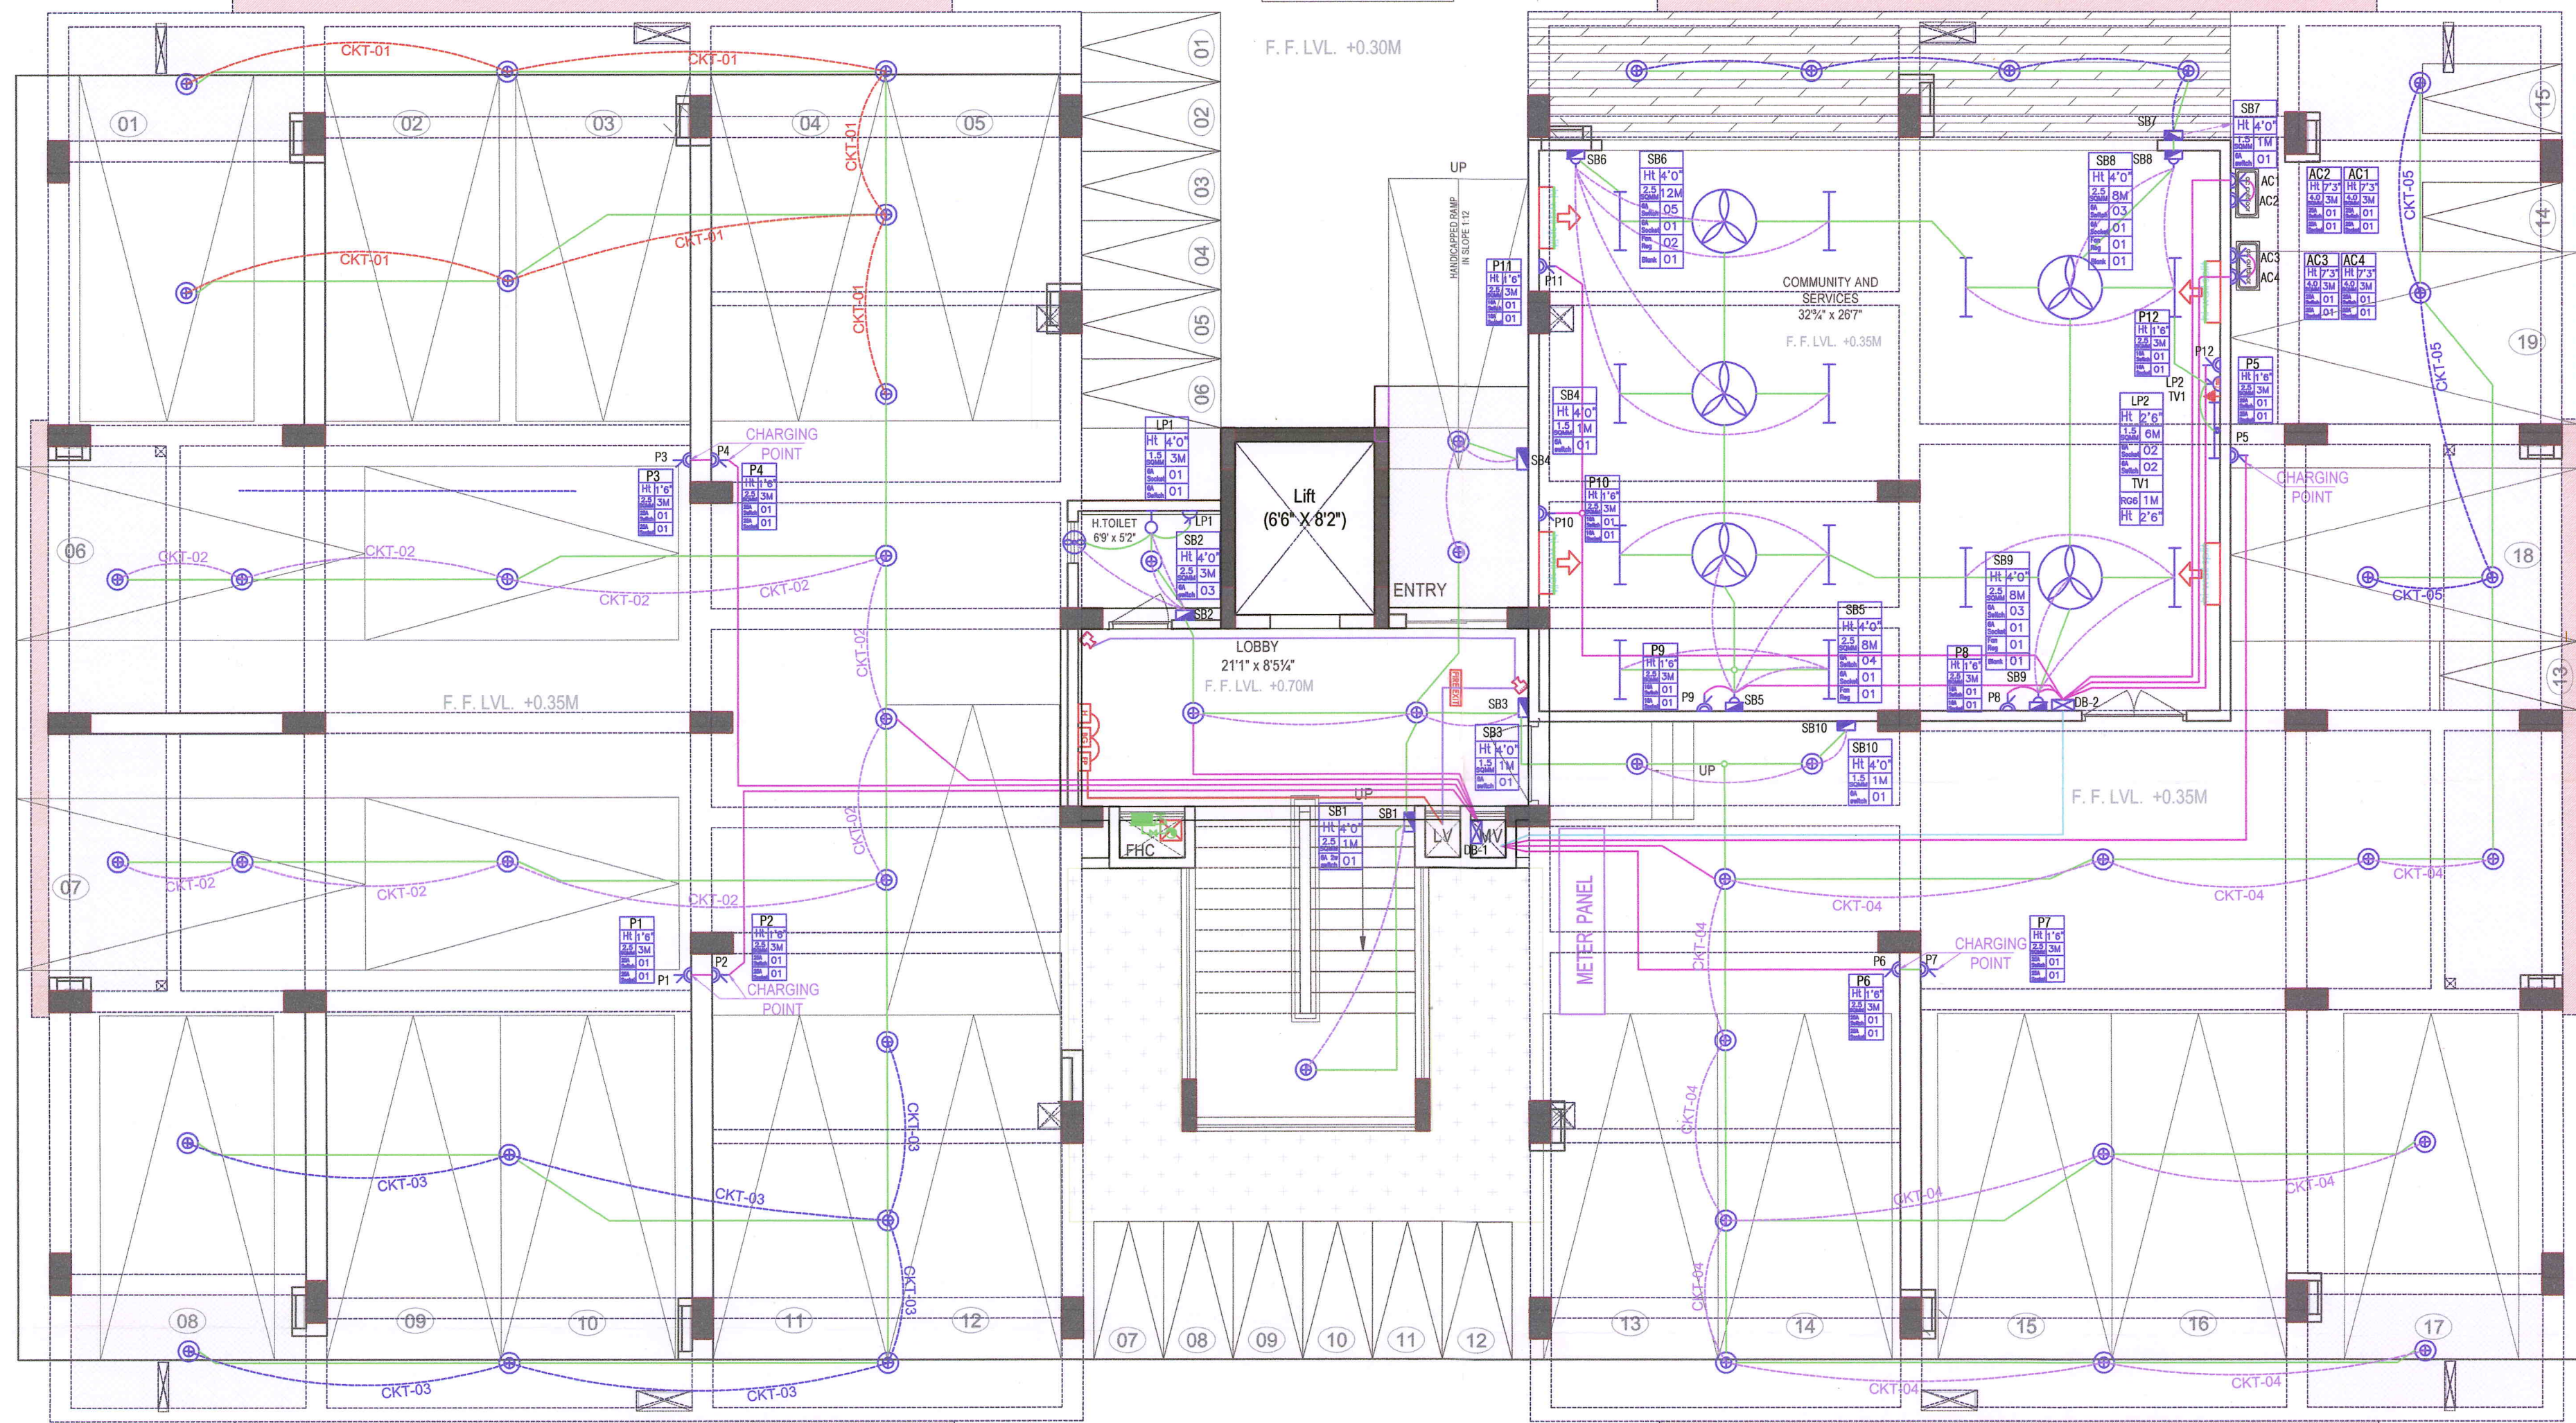

DRIVEWAY 18'4" WIDE

PLOT-03

PRAVEEN KUMAR
BTECH (ELECT.)

Ar. Balwant Prem Singh Rathore
B. Arch.
CA/2014/64848

For AKSHAT APARTMENTS PVT. LTD.

SUNIL JAIN
Director
DIN: 00155259

LEGEND			
NO	DESCRIPTION	SYMBOL	QTY
1.	HEAT DETECTOR		NIL
2.	SMOKE DETECTOR		NIL
3.	MANUAL CALL POINT		01 NOS
4.	HOOTER		01 NOS
5.	FIRE PANEL		01 NOS
6.	25MM MS CONDUIT		
7.	SELF LUMINOUS GLOW SIGN BOARD		01 NOS
8.	FIRE HYDRANT		01 NOS

PROJECT :
AKSHAT KANOTA ESTATES, JAIPUR.

ELECTRICAL CONSULTANT:
SRAJAN ASSOCIATES
C-SCHEME, JAIPUR
Email :- snajaipur@hotmail.com

ARCHITECTS:-
m | a | r | c | h | i | t | e | c | t | s | p | v | t | . | l | t | d .
Jaipur - Bangalore - Hyderabad
Plot No.-1, greenwoods, Lal Kothi Scheme,
Jaipur-302001
Tel : 91 141 4299999
email - studio@maarchitects.in
web - www.maarchitects.in

LEGEND		
1.	CEILING FAN	CEILING
2.	EXHAUST	6'-0"
3.	WALL FAN POINT	6'-0"
4.	A.C. POINT (WINDOW AC)	1'-0"
5.	A.C. POINT (SPLIT AC)	AS PER SITE
6.	3 PHASE POINT	AS PER SITE
7.	A.C. SOCKET	AS PER SITE
8.	16 AMP POWER PLUG POINT (GENERAL)	1'-0"
9.	GYSER SOCKET 16 AMP	6'-0"
10.	16 AMP POWER PLUG POINT (KITCHEN)	TOP ABOVE KITCHEN SLAB
11.	16 AMP SOCKET	AS PER SITE
12.	6 AMP SOCKET (BED ROOM)	2'-6"
13.	6 AMP SOCKET (CLOSET)	7'-0"
14.	6 AMP SOCKET	AS PER SITE
15.	2 NO. 6 AMP POWER PLUG POINT (TV)	1'-6"/4'-6"
16.	2 NO. 6 AMP SOCKET	1'-6"/4'-6"
17.	6 AMP PLUG POINT (GENERAL)	1'-0"
18.	NIGHT LAMP	1'-6"
19.	METER BOARD	5'-0"
20.	INVERTOR SOCKET	1'-6"
21.	SWITCH BOARDS WITH G.F. & AMP POINT	4'-0"
22.	SWITCH BOARDS WITH G.F. & AMP POINT	4'-0"
23.	BELL RING	4'-0"
24.	GYSER SWITCH 16 AMP	4'-0"
25.	PROJECTOR POINT	3'-6"
26.	TELEPHONE POINT (BED ROOM)	2'-6"
27.	TELEPHONE POINT (GENERAL)	1'-0"
28.	TV POINT (GENERAL)	2'-6"
29.	LAN POINT	2'-6"
30.	CEILING LIGHT EXT	CEILING
31.	CEILING LIGHT	CEILING
32.	CHANDLIER	CEILING
33.	40W TUBE LIGHT ON CEILING	CEILING
34.	BUILD HOLDER ON SIDE WALL	7'-0"
35.	TUBE LIGHT ON WALL	7'-0"
36.	RELEASER FOR RAMP	2'-6"
37.	DISTRIBUTION BOX	5'-0"
38.	BELL	7'-0"
39.	CONDUIT CIRCUIT (25MM)	CEILING
40.	CONDUIT POINT WIRING (25MM)	CEILING
41.	CONDUIT SUB MAIN WIRING (25MM)	CEILING
42.	CONDUIT CCTV WIRING (25MM)	CEILING
43.	CCTV CAMERA	AS PER SITE

DRG BY :
SAMEER

CHECKED BY :
AK

DATE :
01-06-2022

NORTH:

SCALE :
1:100

Drawing Title :
AKSHAT KANOTA PLOT NO.-02
GROUND FLOOR
ELECTRICAL PLAN

PROJECT NO :
TS-5105

REV. NO.
01

Drawing No.
SA/MA/22/154

PROJECT :
**AKSHAT KANOTA
ESTATES.JAIPUR.**

ELECTRICAL CONSULTANT:

SRAJAN ASSOCIATES
C-SCHEME, JAIPUR
Email :- snajaipur@hotmail.com

ARCHITECTS:-
m | a | r | c | h | i | t | e | c | t | s | p | v | t | . | l | t | d .

Jaipur - Bangalore - Hyderabad
Plot No. -1, Greenwoods, Lal Kothi Scheme,
Jaipur-302001
Tel : 91 141 4299999
email - studio@maarchitects.in
web - www.maarchitects.in

LEGEND		
1.	CEILING FAN	CEILING
2.	EXHAUST	6"-0"
3.	WALL FAN POINT	6"-0"
4.	A.C. POINT (WINDOW AC)	1'-0"
5.	A.C. POINT (SPLIT AC)	AS PER SITE
6.	3 PHASE POINT	AS PER SITE
7.	A.C. SOCKET	AS PER SITE
8.	16 AMP POWER PLUG POINT (GENERAL)	1'-0"
9.	GYSER SOCKET 16 AMP	6"-0"
10.	16 AMP POWER PLUG POINT (CCTV)	TOP ABOVE KITCHEN SLAB
11.	16 AMP SOCKET	AS PER SITE
12.	6 AMP PLUG POINT (BED ROOM)	2'-6"
13.	6 AMP SOCKET (CHINA)	7'-0"
14.	6 AMP SOCKET	AS PER SITE
15.	2 NOS 6 AMP SOCKET	1'-6" x 6"
16.	6 AMP PLUG POINT (GENERAL)	1'-0"
17.	NIGHT LAMP	1'-6"
18.	METER BOARD	5'-0"
19.	INVERTER SOCKET	1'-6"
20.	SWITCH BOARD WITH OUT 6 AMP POINT	4'-0"
21.	SWITCH BOARD WITH 6 AMP POINT	4'-0"
22.	BELL	4'-0"
23.	GYSER SWITCH 16 AMP	4'-0"
24.	PROJECTOR POINT	3'-6"
25.	TELEPHONE PORT (BOTH SIDE)	2'-6"
26.	TELEPHONE POINT (GENERAL)	1'-0"
27.	TV POINT (GENERAL)	2'-6"
28.	LAN POINT	2'-6"
29.	CEILING LIGHT FIX	CEILING
30.	CEILING LIGHT	CEILING
31.	CHANDLIER	CEILING
32.	4W TUBE LIGHT ON CEILING	CEILING
33.	BULB HOLDER ON SIDE WALL	7'-0"
34.	TUBE LIGHT ON WALL	7'-0"
35.	BALCONY FLOOR	2'-6"
36.	DISTRIBUTION BOX	5'-0"
37.	BELL	7'-0"
38.	CONDUIT CIRCUIT (25MM)	CEILING
39.	CONDUIT POINT WIRING (25MM)	CEILING
40.	CONDUIT MAIN WIRING (25MM)	CEILING
41.	CONDUIT SUB WIRING (25MM)	CEILING
42.	CCTV CAMERA	AS PER SITE

LEGEND		
NO.	DESCRIPTION	QTY.
1.	NO. FIRE HYDRANT MAIN	AS PER SITE
2.	EXTERNAL FIRE HYDRANT	NIL
3.	2 WAY FIRE BRASS/VALVE	NIL
4.	INTERNAL FIRE HYDRANT	01 Nos

DRG BY : **RAHMAN**

CHECKED BY : **AK**

DATE : **23-09-2022**

NORTH : 


SCALE : **1:100**

Drawing Title :
**AKSHAT KANOTA PLOT NO.-02
TYPICAL FLOOR FIRE
& ELE. PLAN**

PROJECT NO : **TS-5105**

REV. NO : **01**

Drawing No. : **SA/MA/22/340**

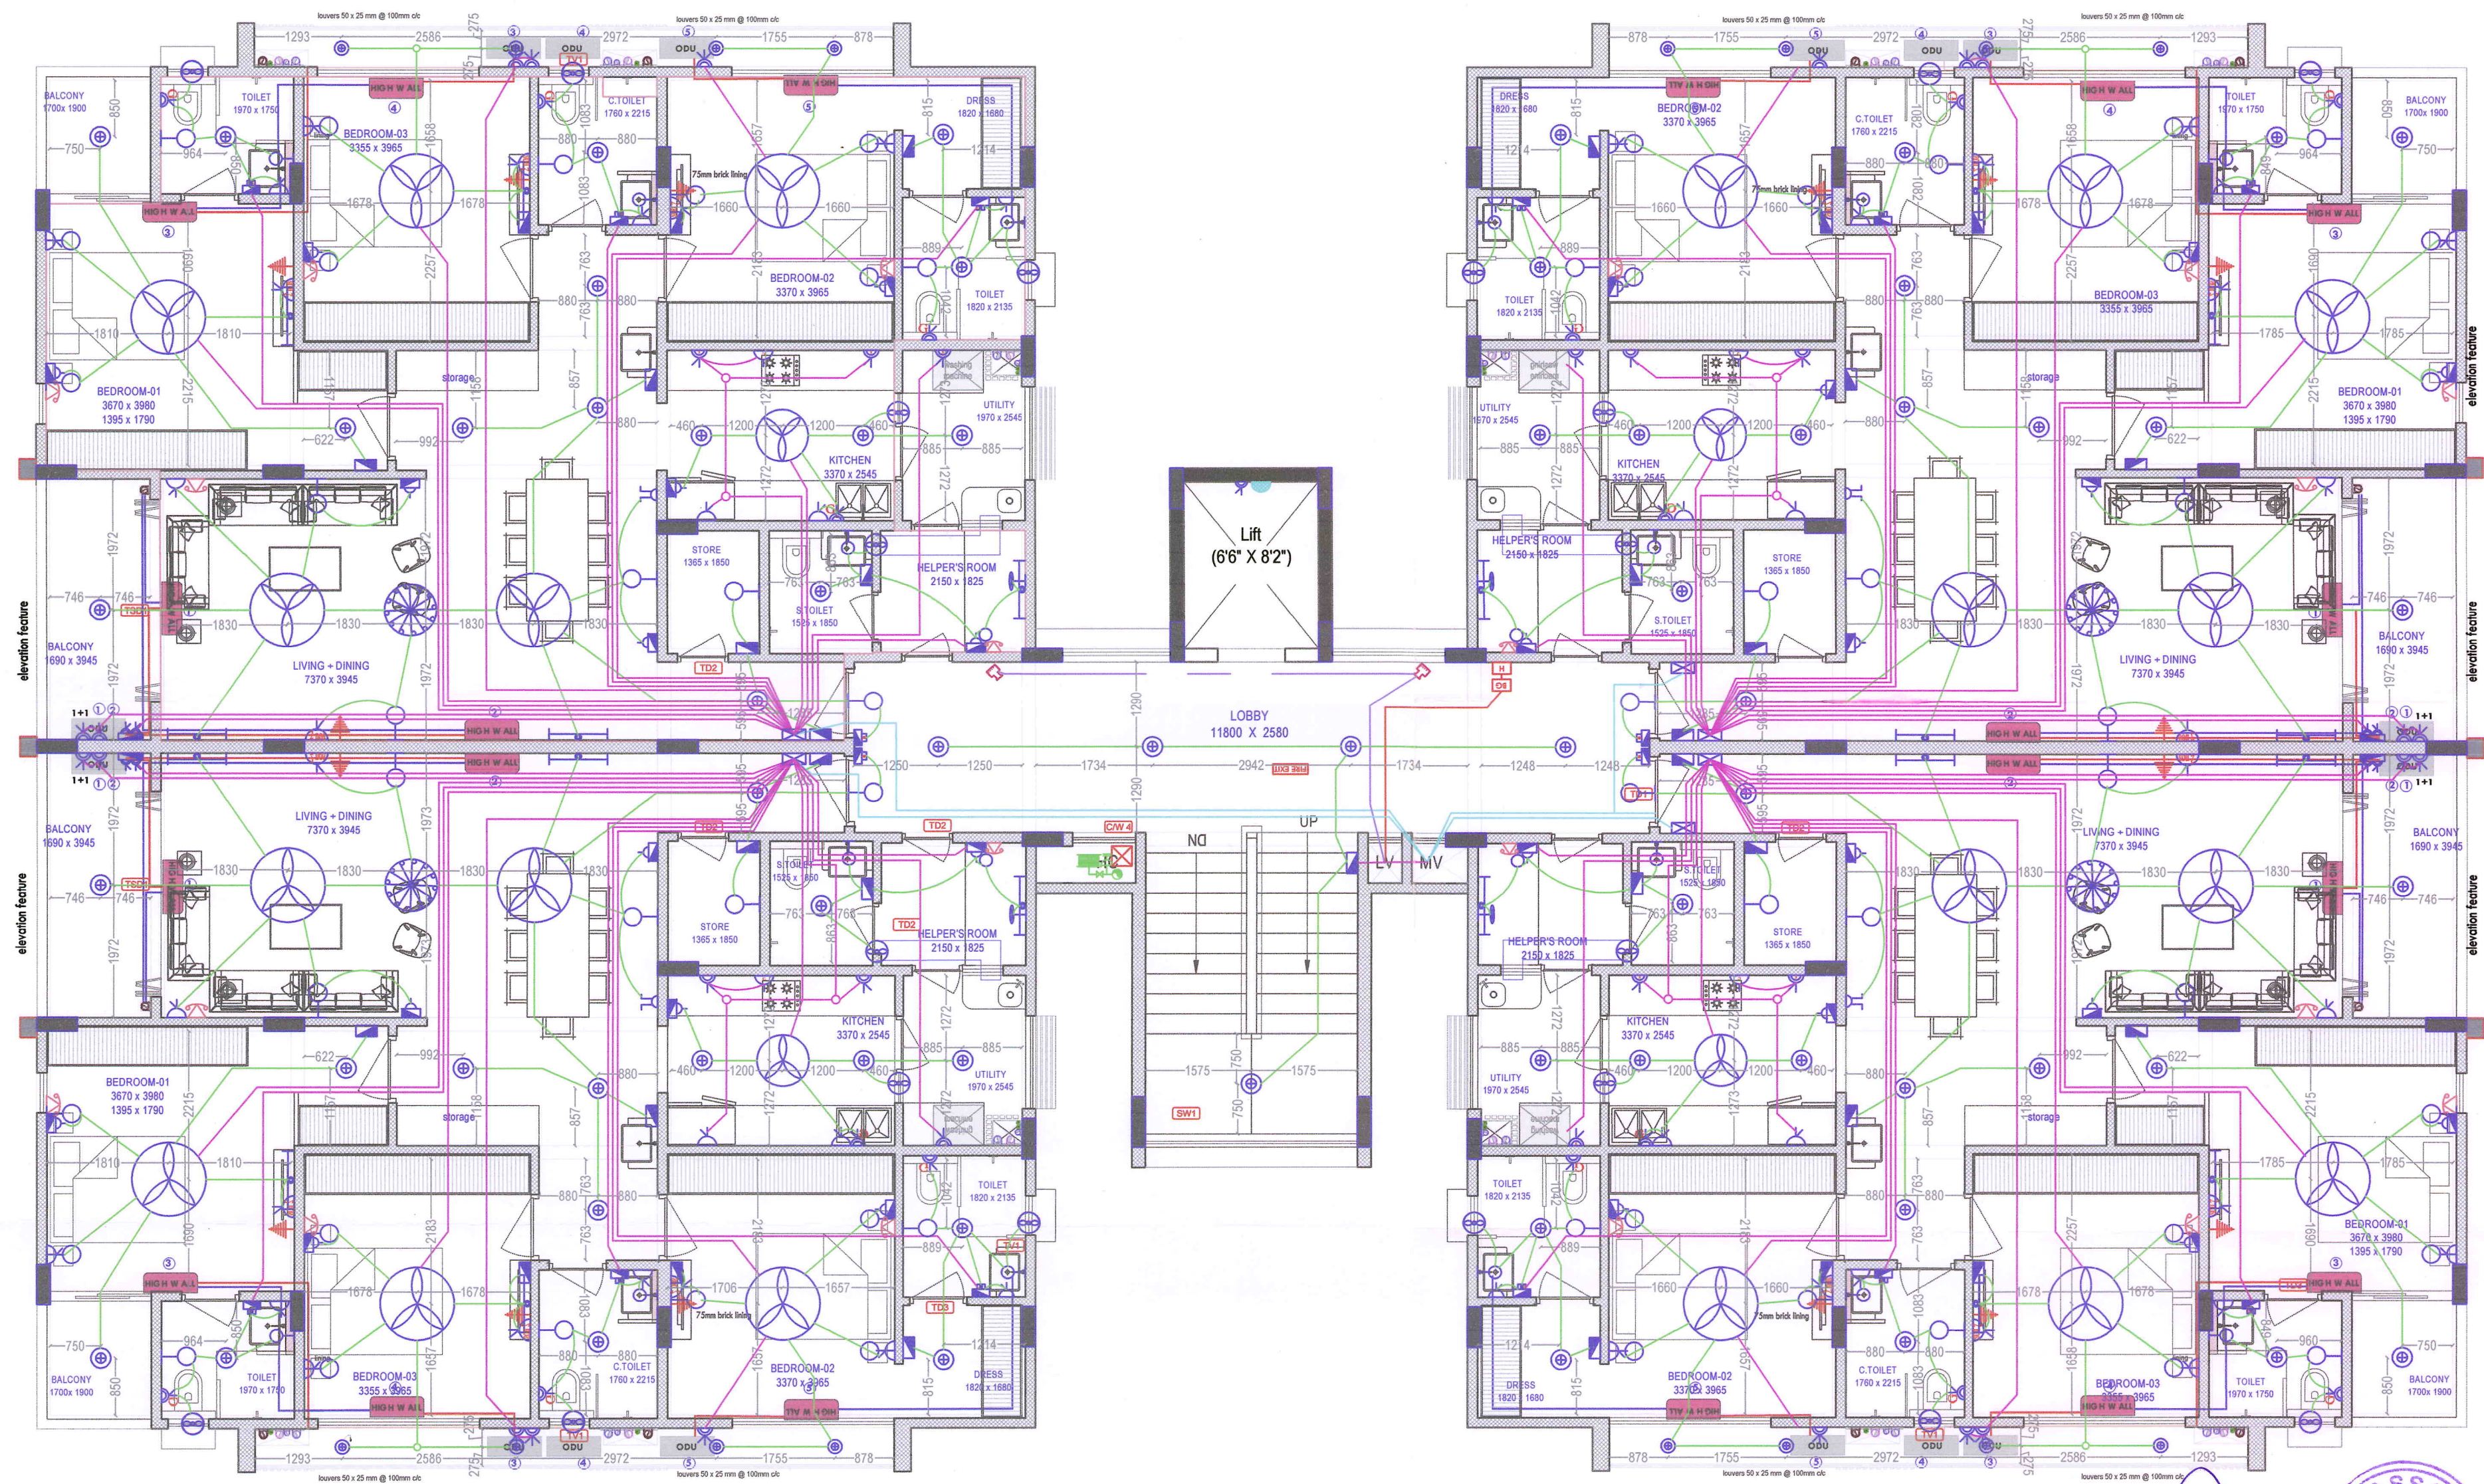

Praveen
PRAVEEN KUMAR
BTECH (ELECT.)

Ar. Balwant Prem Singh Rathore
Ar. Balwant Prem Singh Rathore
B. Arch.
CA/2014/64848

For AKSHAT APARTMENTS PVT. LTD.
(SUNIL JAIN)
(SUNIL JAIN)
Director
DIN: 00155259



PROJECT :
**AKSHAT KANOTA
ESTATES.JAIPUR.**

ELECTRICAL CONSULTANT:

SRAJAN ASSOCIATES
C-SCHEME, JAIPUR
Email :- snajaipur@hotmail.com

ARCHITECTS:-
m|a|r|c|h|i|t|e|c|t|s|p|v|t|.l|t|d.
Jaipur - Bangalore - Hyderabad
Plot No.-1, greenwoods, Lal Kothi Scheme,
Jaipur-302001
Tel: 91 141 4299999
email - studio@maarchitects.in
web - www.maarchitects.in

LEGEND		
1.	CEILING FAN	CEILING
2.	EXHAUST	6'-0"
3.	WALL FAN POINT	6'-0"
4.	A.C. POINT (WINDOW AC)	1'-0"
5.	A.C. POINT (SPLIT AC)	AS PER SITE
6.	3 PHASE POINT	AS PER SITE
7.	A.C. SOCKET	AS PER SITE
8.	16 AMP POWER PLUG POINT (GENERAL)	1'-0"
9.	GYSER SOCKET 16 AMP	6'-0"
10.	16 AMP POWER PLUG POINT (KITCHEN)	AS PER SITE
11.	16 AMP SOCKET	AS PER SITE
12.	6 AMP PLUG POINT (BED ROOM)	2'-6"
13.	6 AMP SOCKET (CHIMNEY)	7'-0"
14.	6 AMP SOCKET	AS PER SITE
15.	2 NOS 6 AMP POWER PLUG POINT (BATH)	1'-6"
16.	2 NOS 6 AMP SOCKET	1'-6"
17.	6 AMP PLUG POINT (GENERAL)	1'-0"
18.	NIGHT LAMP	1'-6"
19.	METER BOARD	5'-0"
20.	INVERTOR SOCKET	1'-6"
21.	SWITCH BOARD WITH OUT 6 AMP POINT	4'-0"
22.	SWITCH BOARD WITH 6 AMP POINT	4'-0"
23.	BELL	4'-0"
24.	GYSER SWITCH 16 AMP	4'-0"
25.	PROJECTOR POINT	3'-6"
26.	TELEPHONE POINT (BED ROOM)	2'-6"
27.	TELEPHONE POINT (GENERAL)	1'-0"
28.	TV POINT (GENERAL)	2'-6"
29.	LAN POINT	2'-6"
30.	CEILING LIGHT TV	CEILING
31.	CEILING LIGHT	CEILING
32.	CHANDILLER	CEILING
33.	40W TUBE LIGHT ON CEILING	CEILING
34.	BULB HOLDER ON SIDE WALL	7'-0"
35.	TUBE LIGHT ON WALL	7'-0"
36.	BELIEAD FOR RAMP	2'-6"
37.	DISTRIBUTION BOX	5'-0"
38.	BELL	7'-0"
39.	CONDUIT CIRCUIT (25MM)	CEILING
40.	CONDUIT POINT WIRING (25MM)	CEILING
41.	CONDUIT SUB MAIN WIRING (25MM)	CEILING
42.	CONDUIT CCTV WIRING (25MM)	CEILING
43.	CCTV CAMERA	AS PER SITE

LEGEND		
NO	DESCRIPTION	QTY.
1.	NO PIPE FOR HYDRANT MAIN	AS PER SITE
2.	EXTERNAL FIRE HYDRANT	NIL
3.	2 WAY FIRE BRASS INLET	NIL
4.	INTERNAL FIRE HYDRANT	05 Nos

DRG BY: **RAHMAN**

CHECKED BY: **AK**

DATE: **23-07-2022**


SCALE: **1:100**

Drawing Title :
**AKSHAT KANOTA PLOT NO.-02
PENT HOUSE FLOOR
FIRE & ELE. PLAN**

PROJECT NO: **TS-5105**

REV. NO: **01**

Drawing No. **SA/MA/22/154**

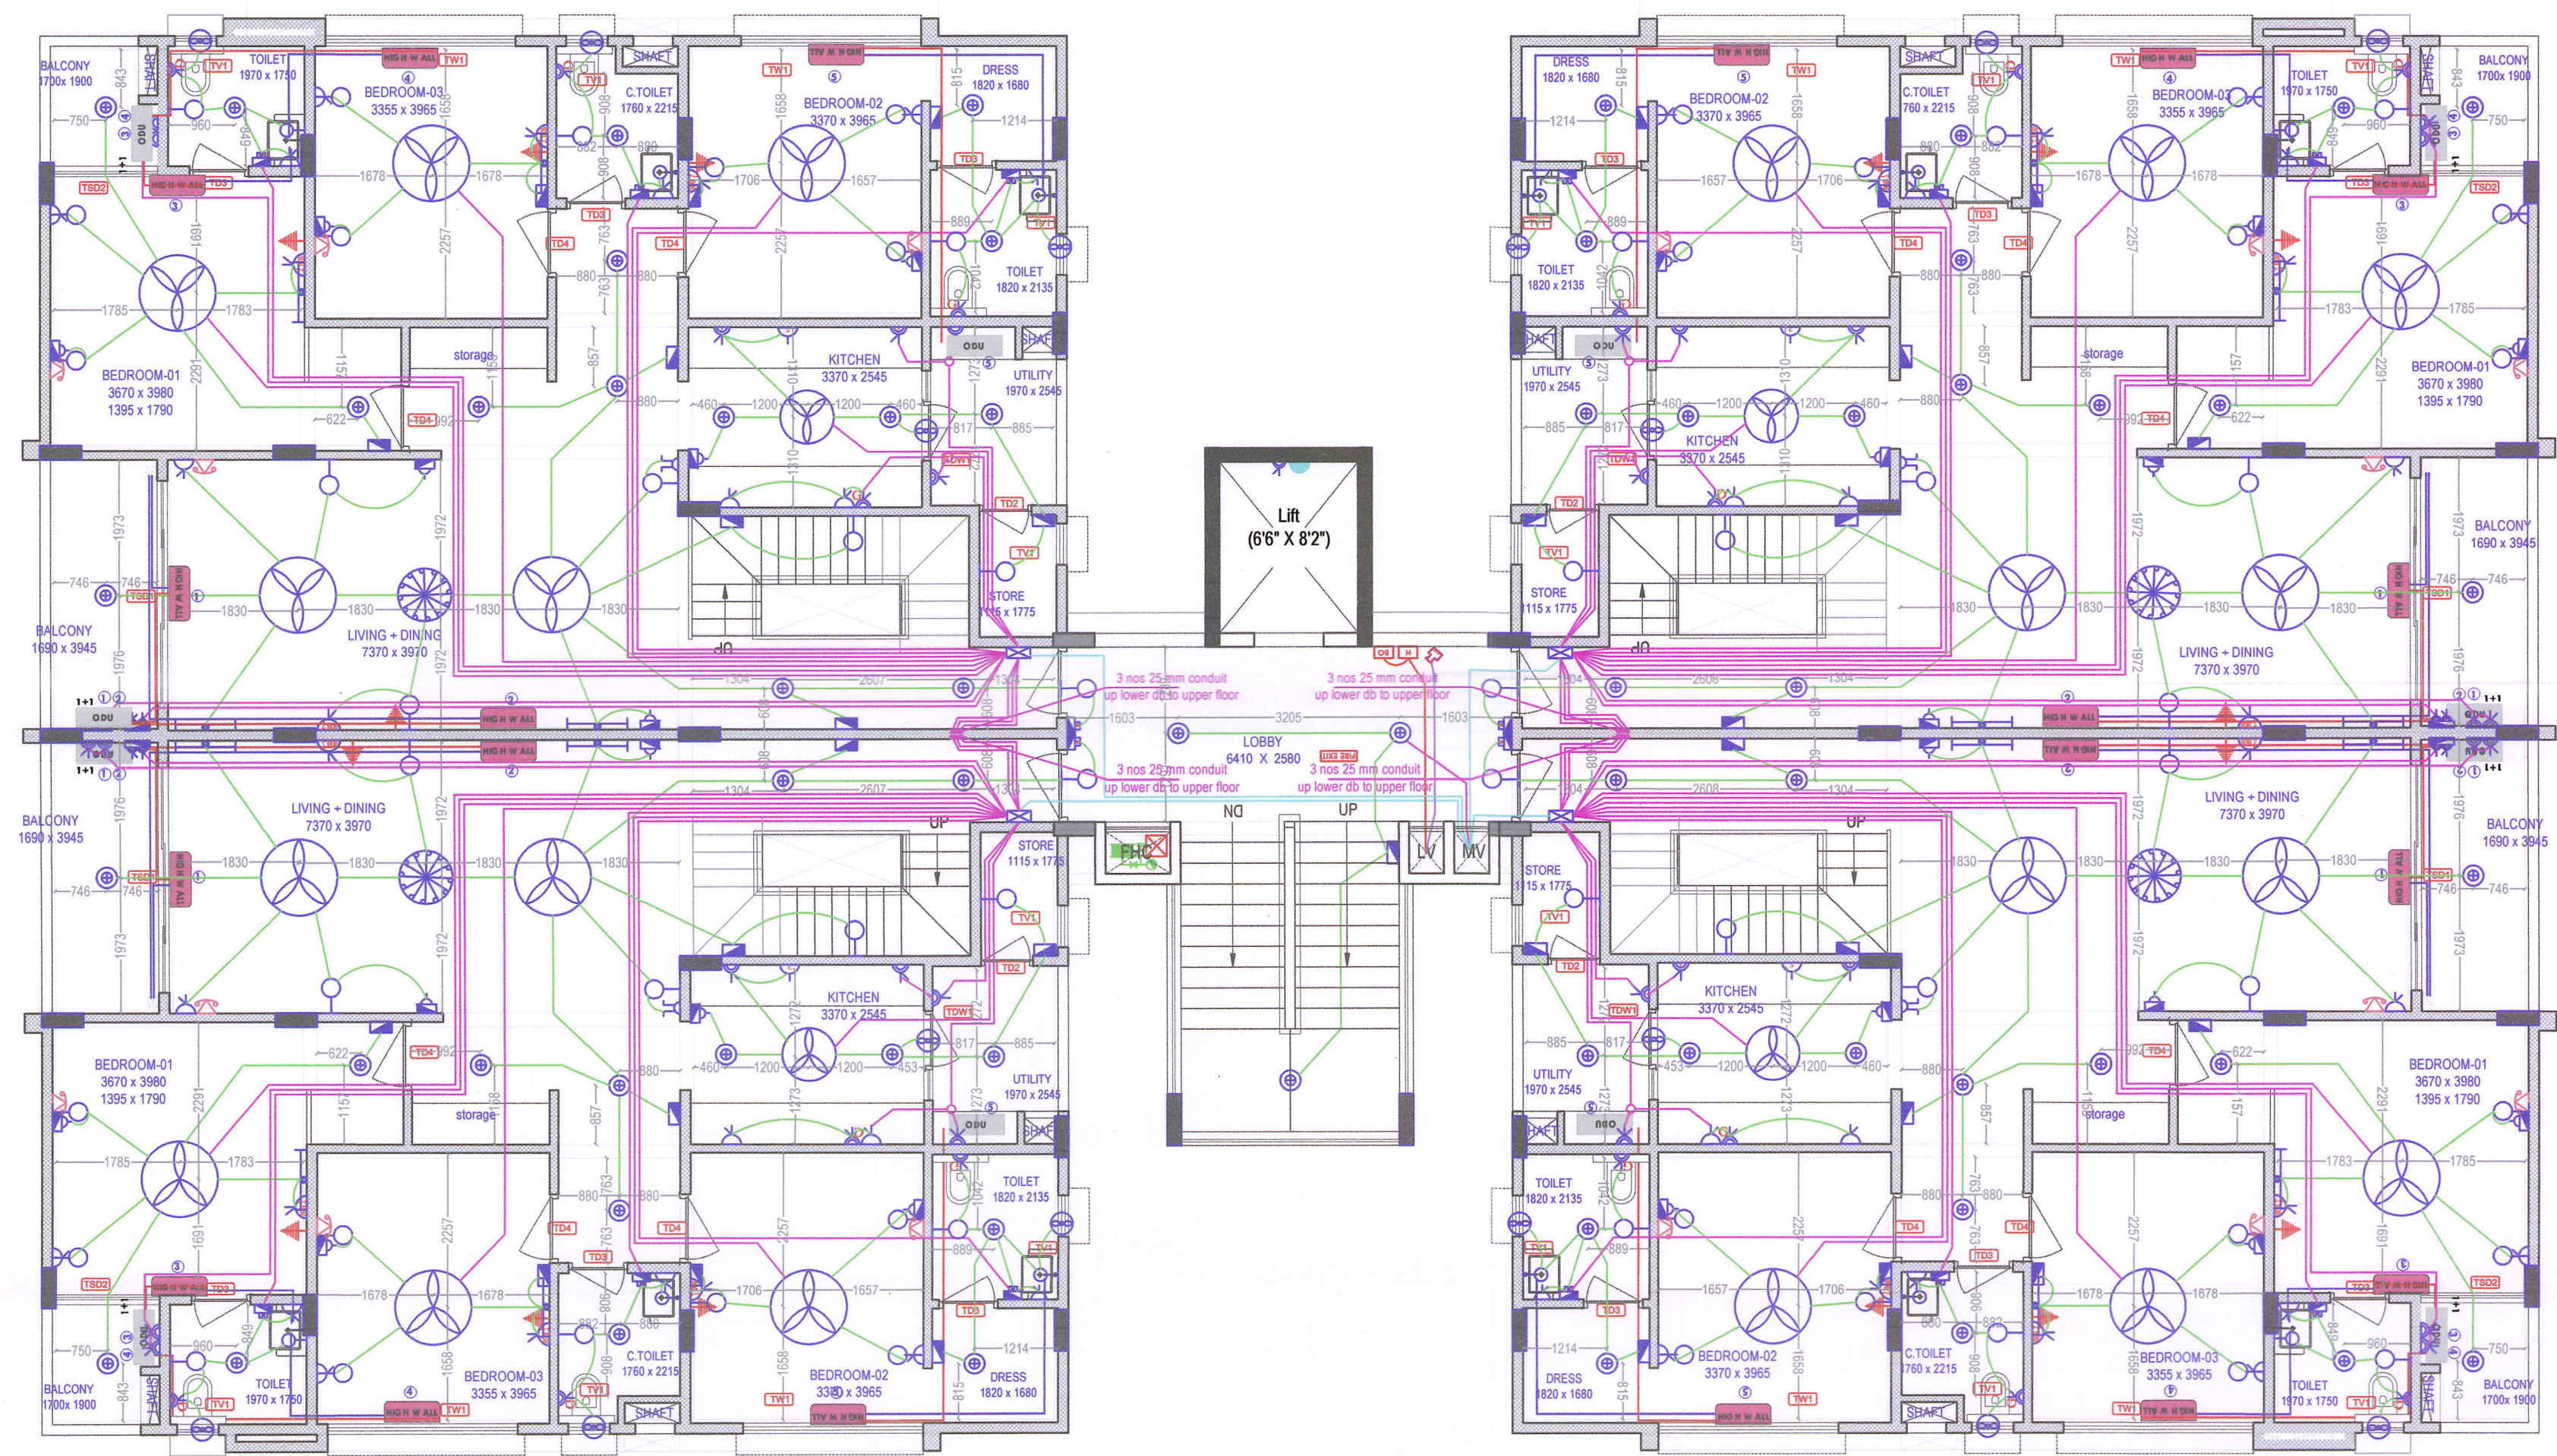

Praveen
PRAVEEN KUMAR
BTECH (ELECT.)

Ar. Balwant Prem Singh Rathore
B. Arch.
CA/2014/64848

For AKSHAT APARTMENTS PVT. LTD.
(SUNIL JAIN)
Director
DIN: 00155259



