


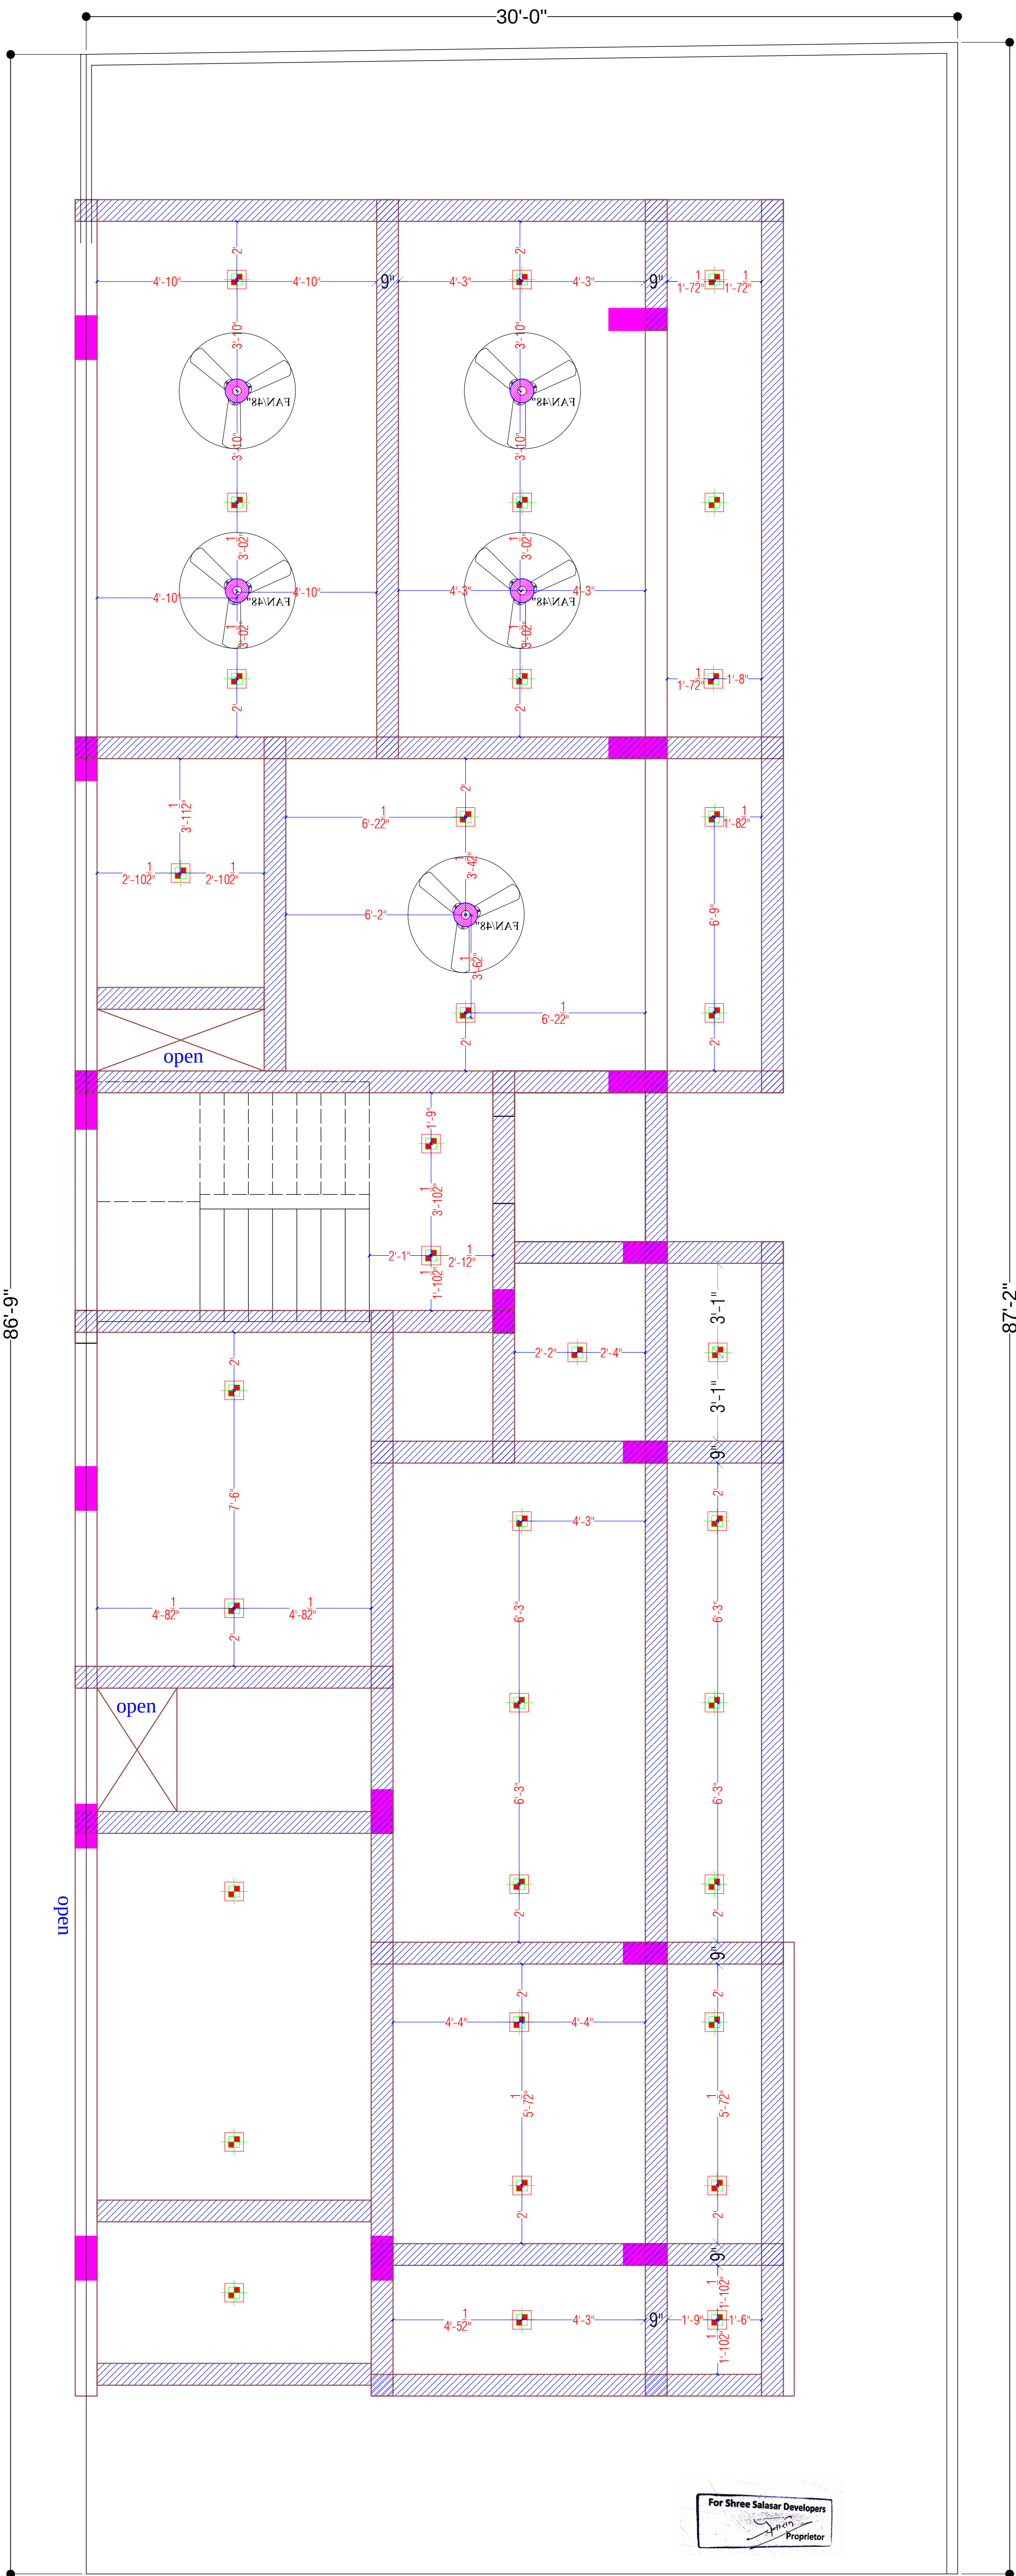

LEGENDS:				
Mounting Height	No.	I D	Symbol	Description
IN FLOOR				CONTROL WIRING
IN CONDUIT				CONTROL WIRING
IN CONDUIT				AC CONTROL WIRING
IN CONDUIT				GEYSER CONTROL WIRING
IN CONDUIT				BUIZZER CONTROL WIRING
CEILING	FAN 48"			CEILING FAN 48"
CEILING	FAN 30"			CEILING FAN 30"
+90"	TL			1X40W WALL TUBELIGHT
+90"	BULB			WALL BRACKETS AS DESIGN LIGHT
+90"	GL			WALL BRACKETS AS DESIGN FOR GANESH LIGHT
	GL			WALL BRACKETS AS DESIGN FOR GATE LIGHT
CEILING	CFL			CFL CEILING LIGHT
+21"	FL			FOOT LIGHT
+48"	SB			SWITCH BOARD
+70"	ML			1 X 11 W CFL MIRROR LIGHT
VENTILATOR HT.	CR			CEILING ROSE
VENTILATOR HT.	EXF			9" DIA FRESH AIR FAN
+24"	TEL			TELEPHONE POINT
+27"	TV			TV COAXIAL POINT
+27"	LP TV			G A PLUG POINT FOR TV
+72"	LP CH			G A PLUG POINT FOR CHIMNEY
+102"	SAC			SPLIT AC
+102"	PP SAC			25 A POWER POINT FOR SPLIT AC
+42"	PP MIX			15 A POWER POINT FOR MIXER
+78"	PP G			15 A POWER POINT FOR GEYSER
+54"	PP F			15 A POWER POINT FOR FRIDGE
+78"	PP WP			15 A POWER POINT FOR WATER PURIFIER
+48"	PP WM			15 A POWER POINT FOR WASHING MACHINE
+42"	BP			BELL PUSH SWITCH
+90"	BZ			BUIZZER POINT
+48"	AC			AC STARTER
+60"	MCB DB			MCB DISTRIBUTION BOARD

Krishna
KRISHNA KUMAR
B. Tech. (Mechanical)
M.E.P Consultant

WARNING

1. This drawing is the sole copyright of Architects VISTAAR and should be used for the purpose expressly issued.

GENERAL NOTES

- All dimensions are in feet and inches.
- Do not scale this drawing follow written dimensions only.
- This drawing should be read in conjunction with other architectural and structural drawings.
- Any discrepancy in the drawing should be immediately brought to the notice of architect.

PROJECT TITLE

SALASAR RESIDENCY
BUILDING AT PLOT-57,SUMER NAGAR
VISTAR-Q BLOCK,JAIPUR

DRAWING TITLE

STILT FLOOR CEILING ELECTRICAL
PLAN

ARCHITECTS :

VISTAAR ARCHITECTS &
PLANNERS

Architects :: Interior Designers
B-2/12, Chitrkoot scheme,
main Gandhi Path,Opp mall of jaipur,Jaipur
PH.- 0141-4116461,09001010366

PATH :

DRN.

DATE

REV.

NORTH

MANDU


KUMAWAT

25-06-2024

SCALE

ROB NO.


NTS

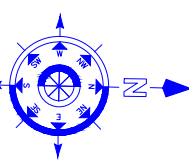

For Shree Salasar Developers
Proprietor



PATH:-			
DRN.	DATE	REV.	NORTH
MAMU KUMAWAT	25-06-2024		
SCALE	JOB NO.		
N.T.S			

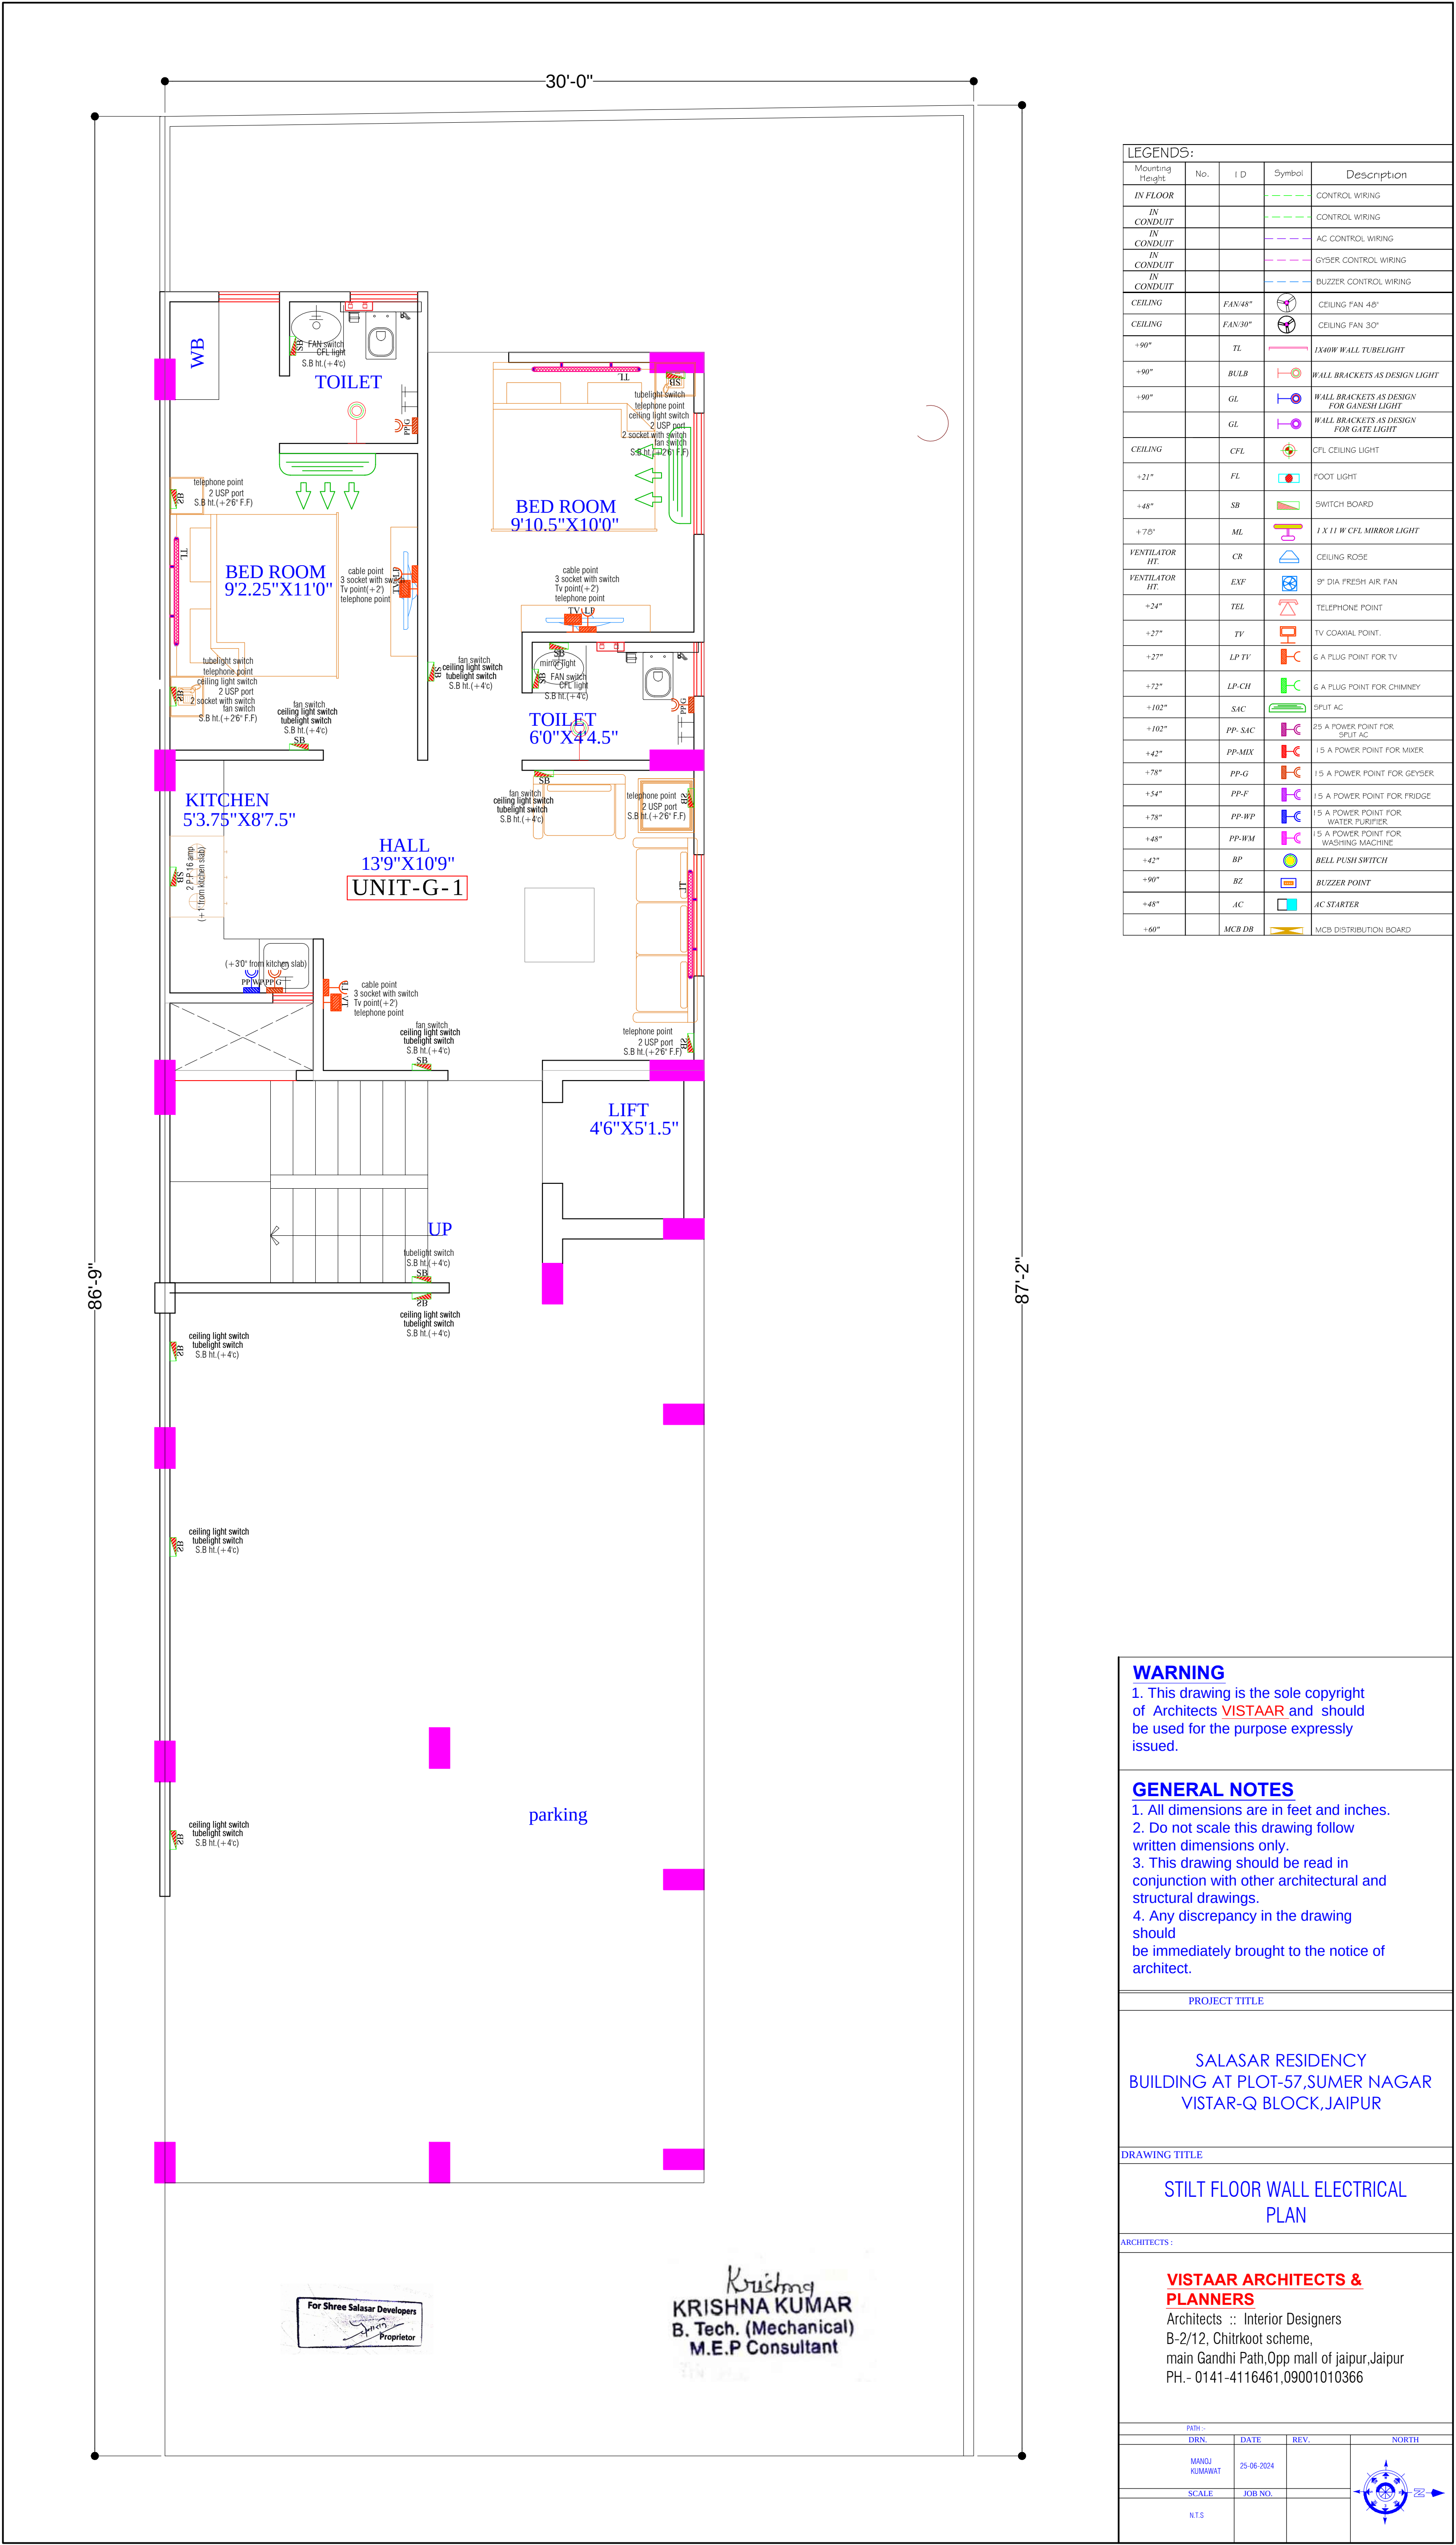

LEGENDS:				
Mounting Height	No.	I.D	Symbol	Description
IN FLOOR				CONTROL WIRING
IN CONDUIT				CONTROL WIRING
IN CONDUIT				AC CONTROL WIRING
IN CONDUIT				GYSER CONTROL WIRING
IN CONDUIT				BUIZZER CONTROL WIRING
CEILING	FAN/48"			CEILING FAN 48"
CEILING	FAN/30"			CEILING FAN 30"
+90"	TL			1X40W WALL TUBELIGHT
+90"	BULB			WALL BRACKETS AS DESIGN LIGHT
+90"	GL			WALL BRACKETS AS DESIGN FOR GANESH LIGHT
	GL			WALL BRACKETS AS DESIGN FOR GATE LIGHT
CEILING	CFL			CFL CEILING LIGHT
+21"	FL			FOOT LIGHT
+48"	SB			SWITCH BOARD
+70"	ML			1 X 11 W CFL MIRROR LIGHT
VENTILATOR HT.	CR			CEILING ROSE
VENTILATOR HT.	EXF			9" DIA FRESH AIR FAN
+24"	TEL			TELEPHONE POINT
+27"	TV			TV COAXIAL POINT
+27"	LP TV			6 A PLUG POINT FOR TV
+72"	LP/CH			6 A PLUG POINT FOR CHIMNEY
+103"	SAC			SPUT AC
+103"	PP-SAC			25 A POWER POINT FOR SPUT AC
+42"	PP-MIX			15 A POWER POINT FOR MIXER
+78"	PP-G			15 A POWER POINT FOR GEYSER
+54"	PP-F			15 A POWER POINT FOR FRIDGE
+78"	PP-WP			15 A POWER POINT FOR WATER PURIFIER
+48"	PP-WM			15 A POWER POINT FOR WASHING MACHINE
+42"	BP			BELL PUSH SWITCH
+90"	BZ			BUIZZER POINT
+48"	AC			AC STARTER
+60"	MCB DB			MCB DISTRIBUTION BOARD

WARNING

1. This drawing is the sole copyright of Architects **VISTAAR** and should be used for the purpose expressly issued.

GENERAL NOTES

1. All dimensions are in feet and inches.
2. Do not scale this drawing follow written dimensions only.
3. This drawing should be read in conjunction with other architectural and structural drawings.
4. Any discrepancy in the drawing should be immediately brought to the notice of architect.

PROJECT TITLE

SALASAR RESIDENCY
BUILDING AT PLOT-57,SUMER NAGAR
VISTAR-Q BLOCK,JAIPUR


DRAWING TITLE


STILT FLOOR WALL ELECTRICAL
PLAN

ARCHITECTS :

VISTAAR ARCHITECTS & PLANNERS
Architects :: Interior Designers
B-2/12, Chitrkoot scheme,
main Gandhi Path,Opp mall of jaipur,Jaipur
PH. - 0141-4116461,09001010366

PAIR:	DATE	REV.	NORTH
MANDI KUMAR	25-06-2024		
SCALE	JOB NO.		
NTS			

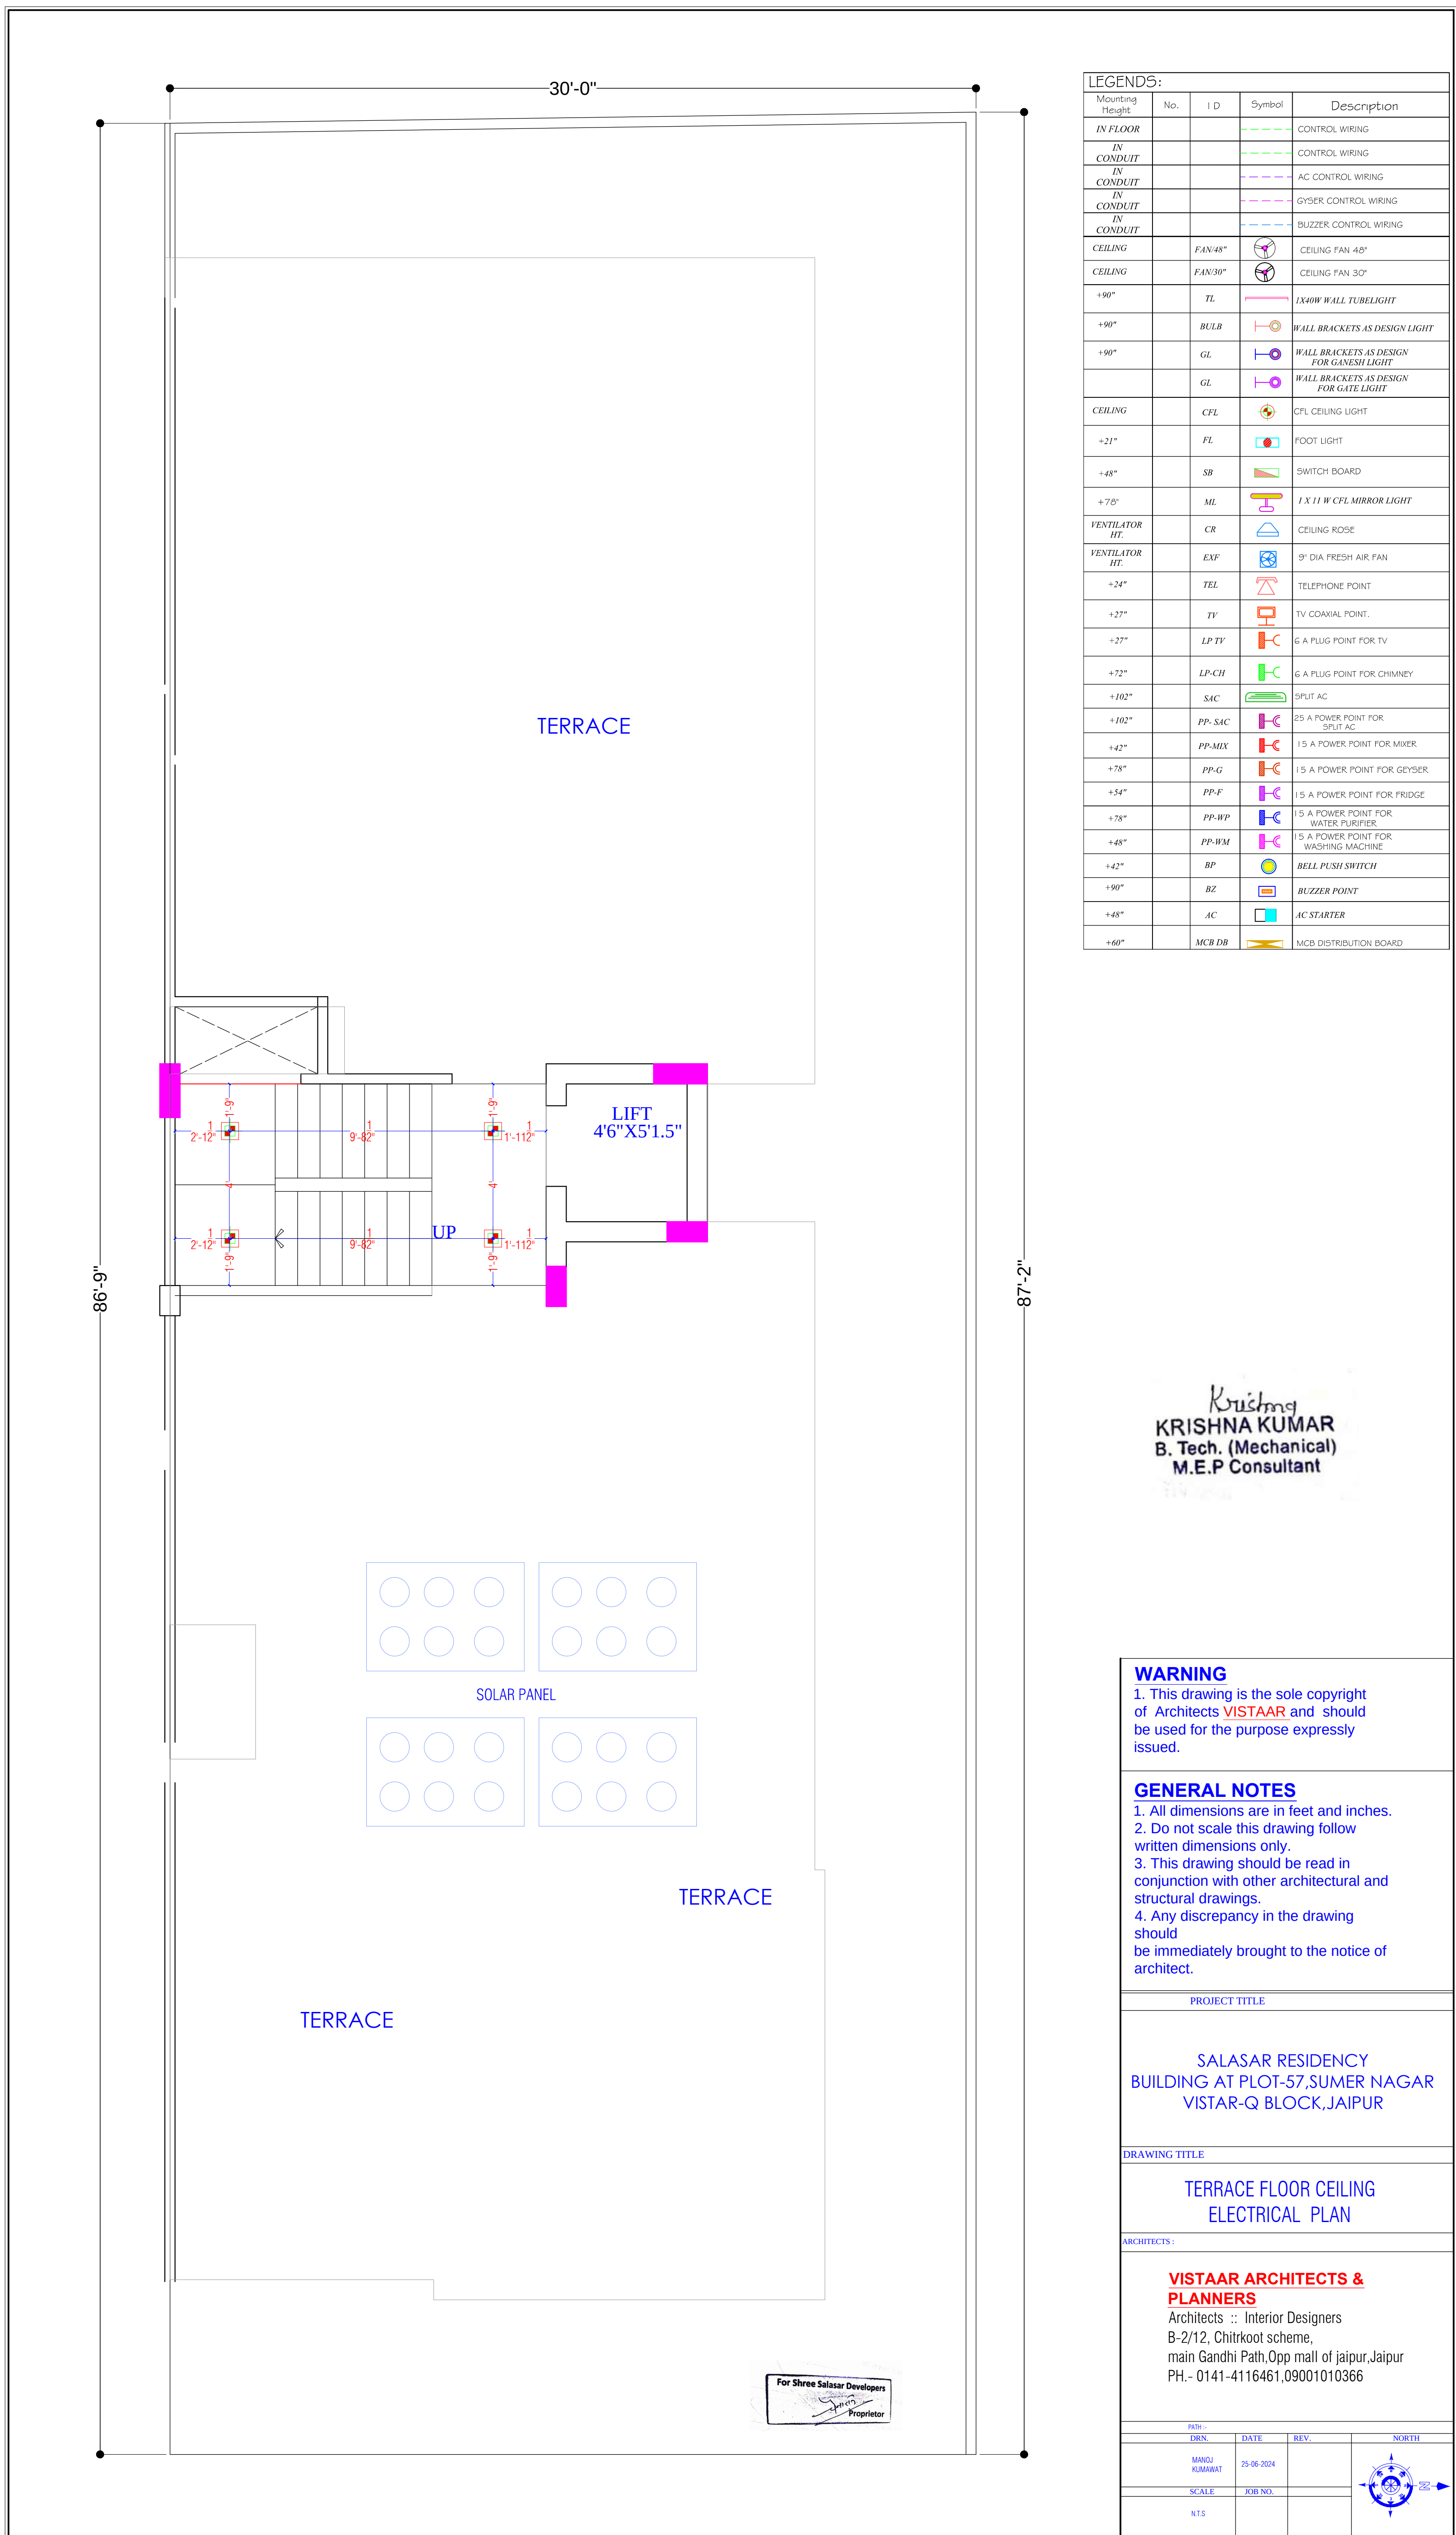

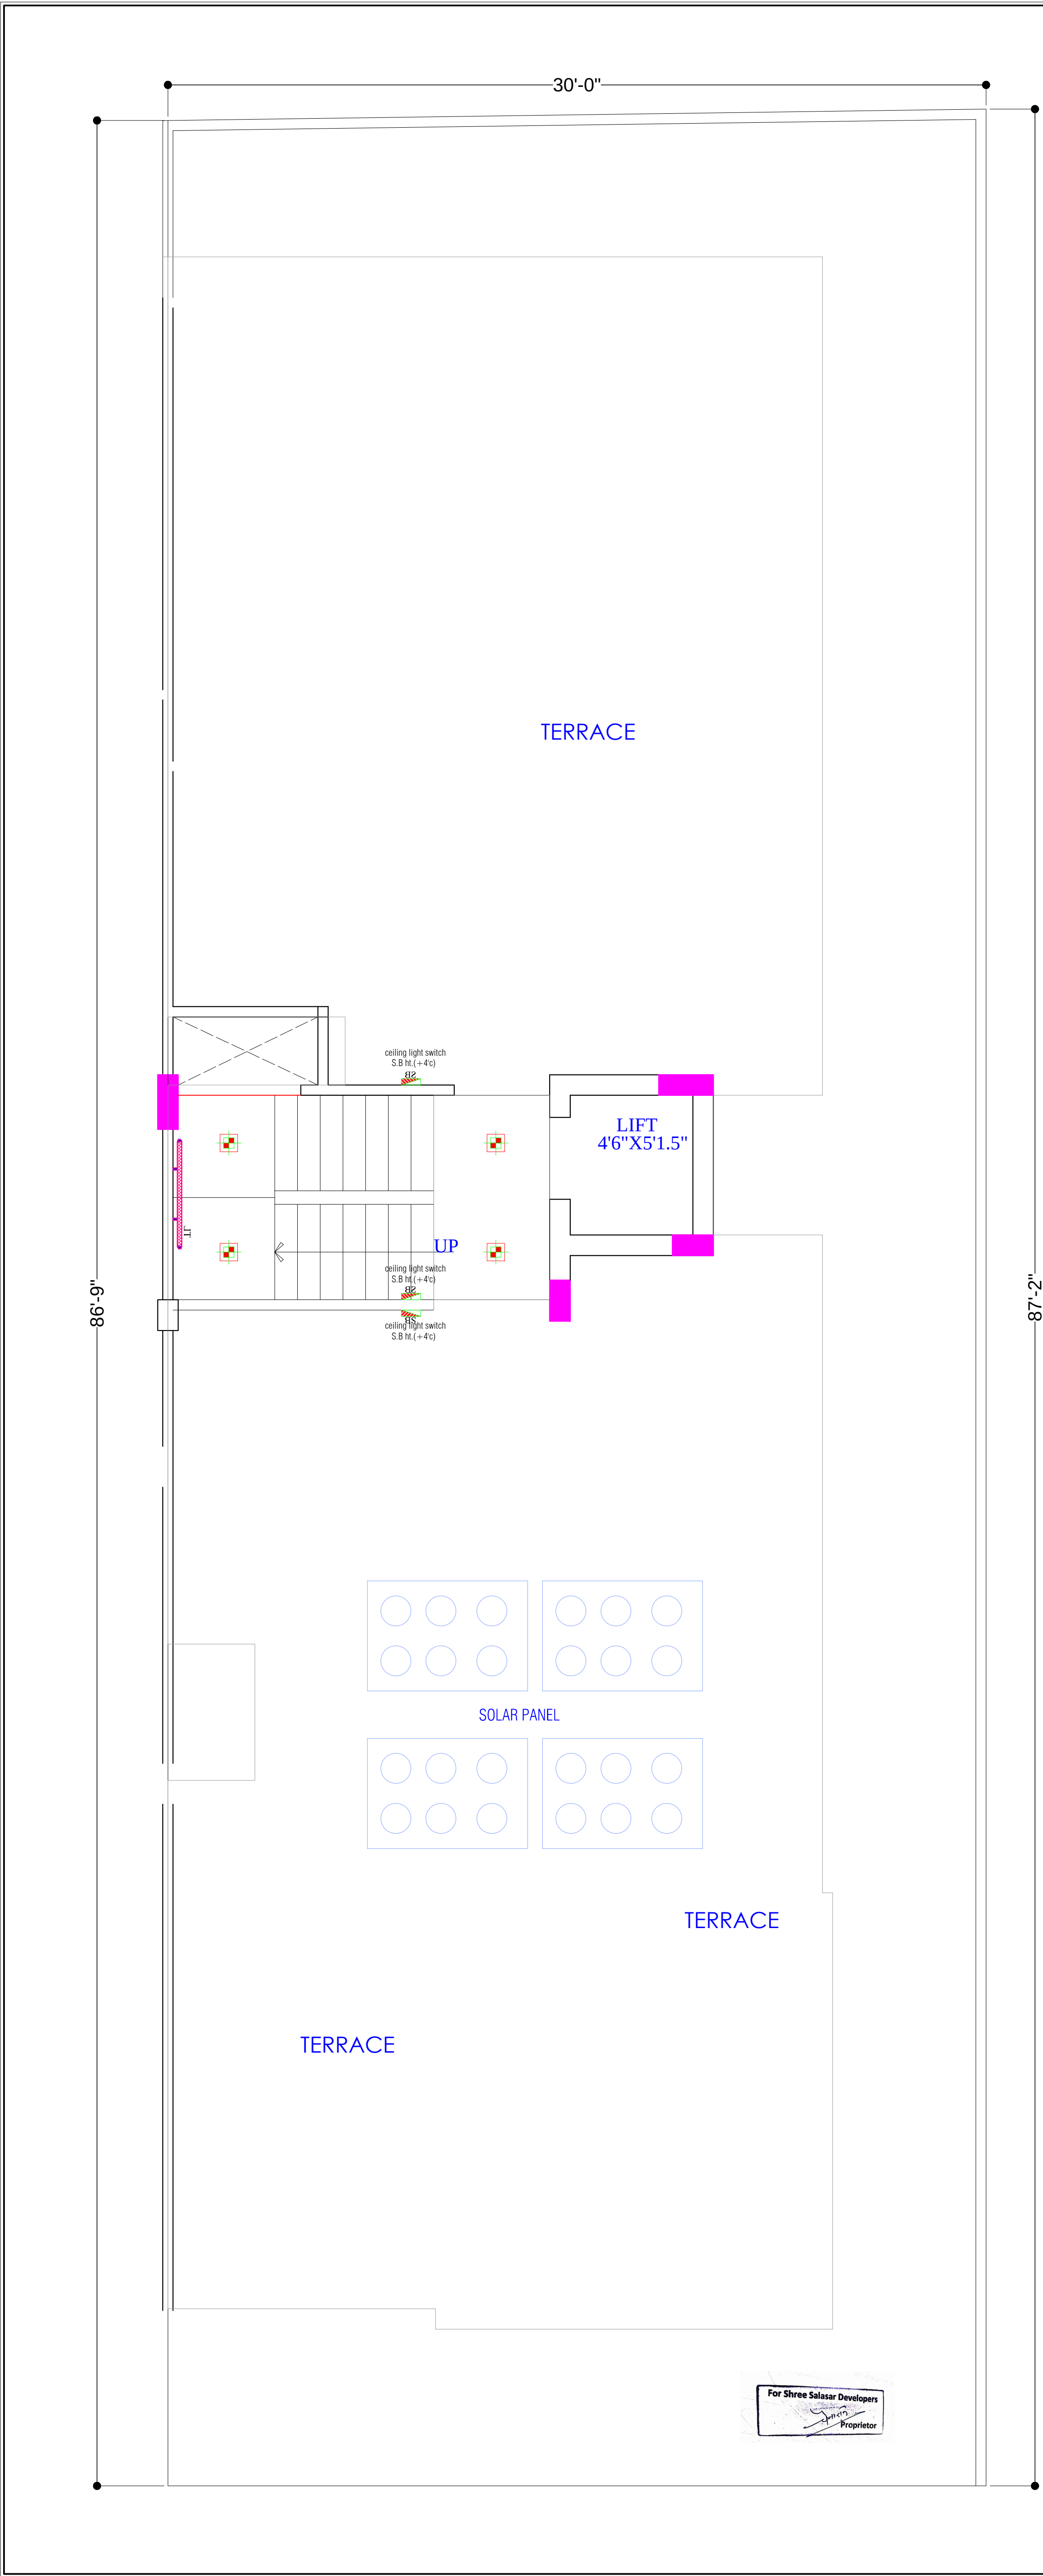

LEGENDS:				
Mounting Height	No.	I D	Symbol	Description
IN FLOOR				CONTROL WIRING
IN CONDUIT				CONTROL WIRING
IN CONDUIT				AC CONTROL WIRING
IN CONDUIT				GEYSER CONTROL WIRING
IN CONDUIT				BUZZER CONTROL WIRING
CEILING	FAN/48"			CEILING FAN 48"
CEILING	FAN/30"			CEILING FAN 30"
+90"	TL			1X40W WALL TUBELIGHT
+90"	BULB			WALL BRACKETS AS DESIGN LIGHT
+90"	GL			WALL BRACKETS AS DESIGN FOR GANESH LIGHT
	GL			WALL BRACKETS AS DESIGN FOR GATE LIGHT
CEILING	CFL			CFL CEILING LIGHT
+21"	FL			FOOT LIGHT
+48"	SB			SWITCH BOARD
+70"	ML			1 X 11 W CFL MIRROR LIGHT
VENTILATOR HT	CR			CEILING ROSE
VENTILATOR HT	EXF			9" DIA FRESH AIR FAN
+24"	TEL			TELEPHONE POINT
+27"	TV			TV COAXIAL POINT
+27"	LP TV			6 A PLUG POINT FOR TV
+72"	LP-CH			6 A PLUG POINT FOR CHIMNEY
+103"	SAC			SPLIT AC
+102"	PP-SAC			25 A POWER POINT FOR SPLIT AC
+42"	PP-MIX			15 A POWER POINT FOR MIXER
+78"	PP-G			15 A POWER POINT FOR GEYSER
+54"	PP-F			15 A POWER POINT FOR FRIDGE
+78"	PP-WP			15 A POWER POINT FOR WATER PURIFIER
+48"	PP-WM			15 A POWER POINT FOR WASHING MACHINE
+42"	BP			BELL PUSH SWITCH
+90"	BZ			BUZZER POINT
+48"	AC			AC STARTER
+60"	MCB DB			MCB DISTRIBUTION BOARD

Krishna
KRISHNA KUMAR
B. Tech. (Mechanical)
M.E.P Consultant

WARNING
1. This drawing is the sole copyright of Architects **VISTAAR** and should be used for the purpose expressly issued.

GENERAL NOTES
1. All dimensions are in feet and inches.
2. Do not scale this drawing follow written dimensions only.
3. This drawing should be read in conjunction with other architectural and structural drawings.
4. Any discrepancy in the drawing should be immediately brought to the notice of architect.

PROJECT TITLE

SALASAR RESIDENCY
BUILDING AT PLOT-57,SUMER NAGAR
VISTAR-Q BLOCK,JAIPUR

DRAWING TITLE

TERRACE FLOOR WALL ELECTRICAL
PLAN

ARCHITECTS :

VISTAAR ARCHITECTS & PLANNERS
Architects :: Interior Designers
B-2/12, Chitrkoot scheme,
main Gandhi Path,Opp mall of jaipur,Jaipur
PH.- 0141-4116461,09001010366

PATH :-		DATE	REV.	NORTH
DRN.	MANOJ KUMAWAT	25-08-2024		
SCALE		JOB NO.		
NTS				

TERRACE


3rd. FLOOR

2nd. FLOOR


1st. FLOOR

GROUND.
FLOOR

STILT
FLOOR

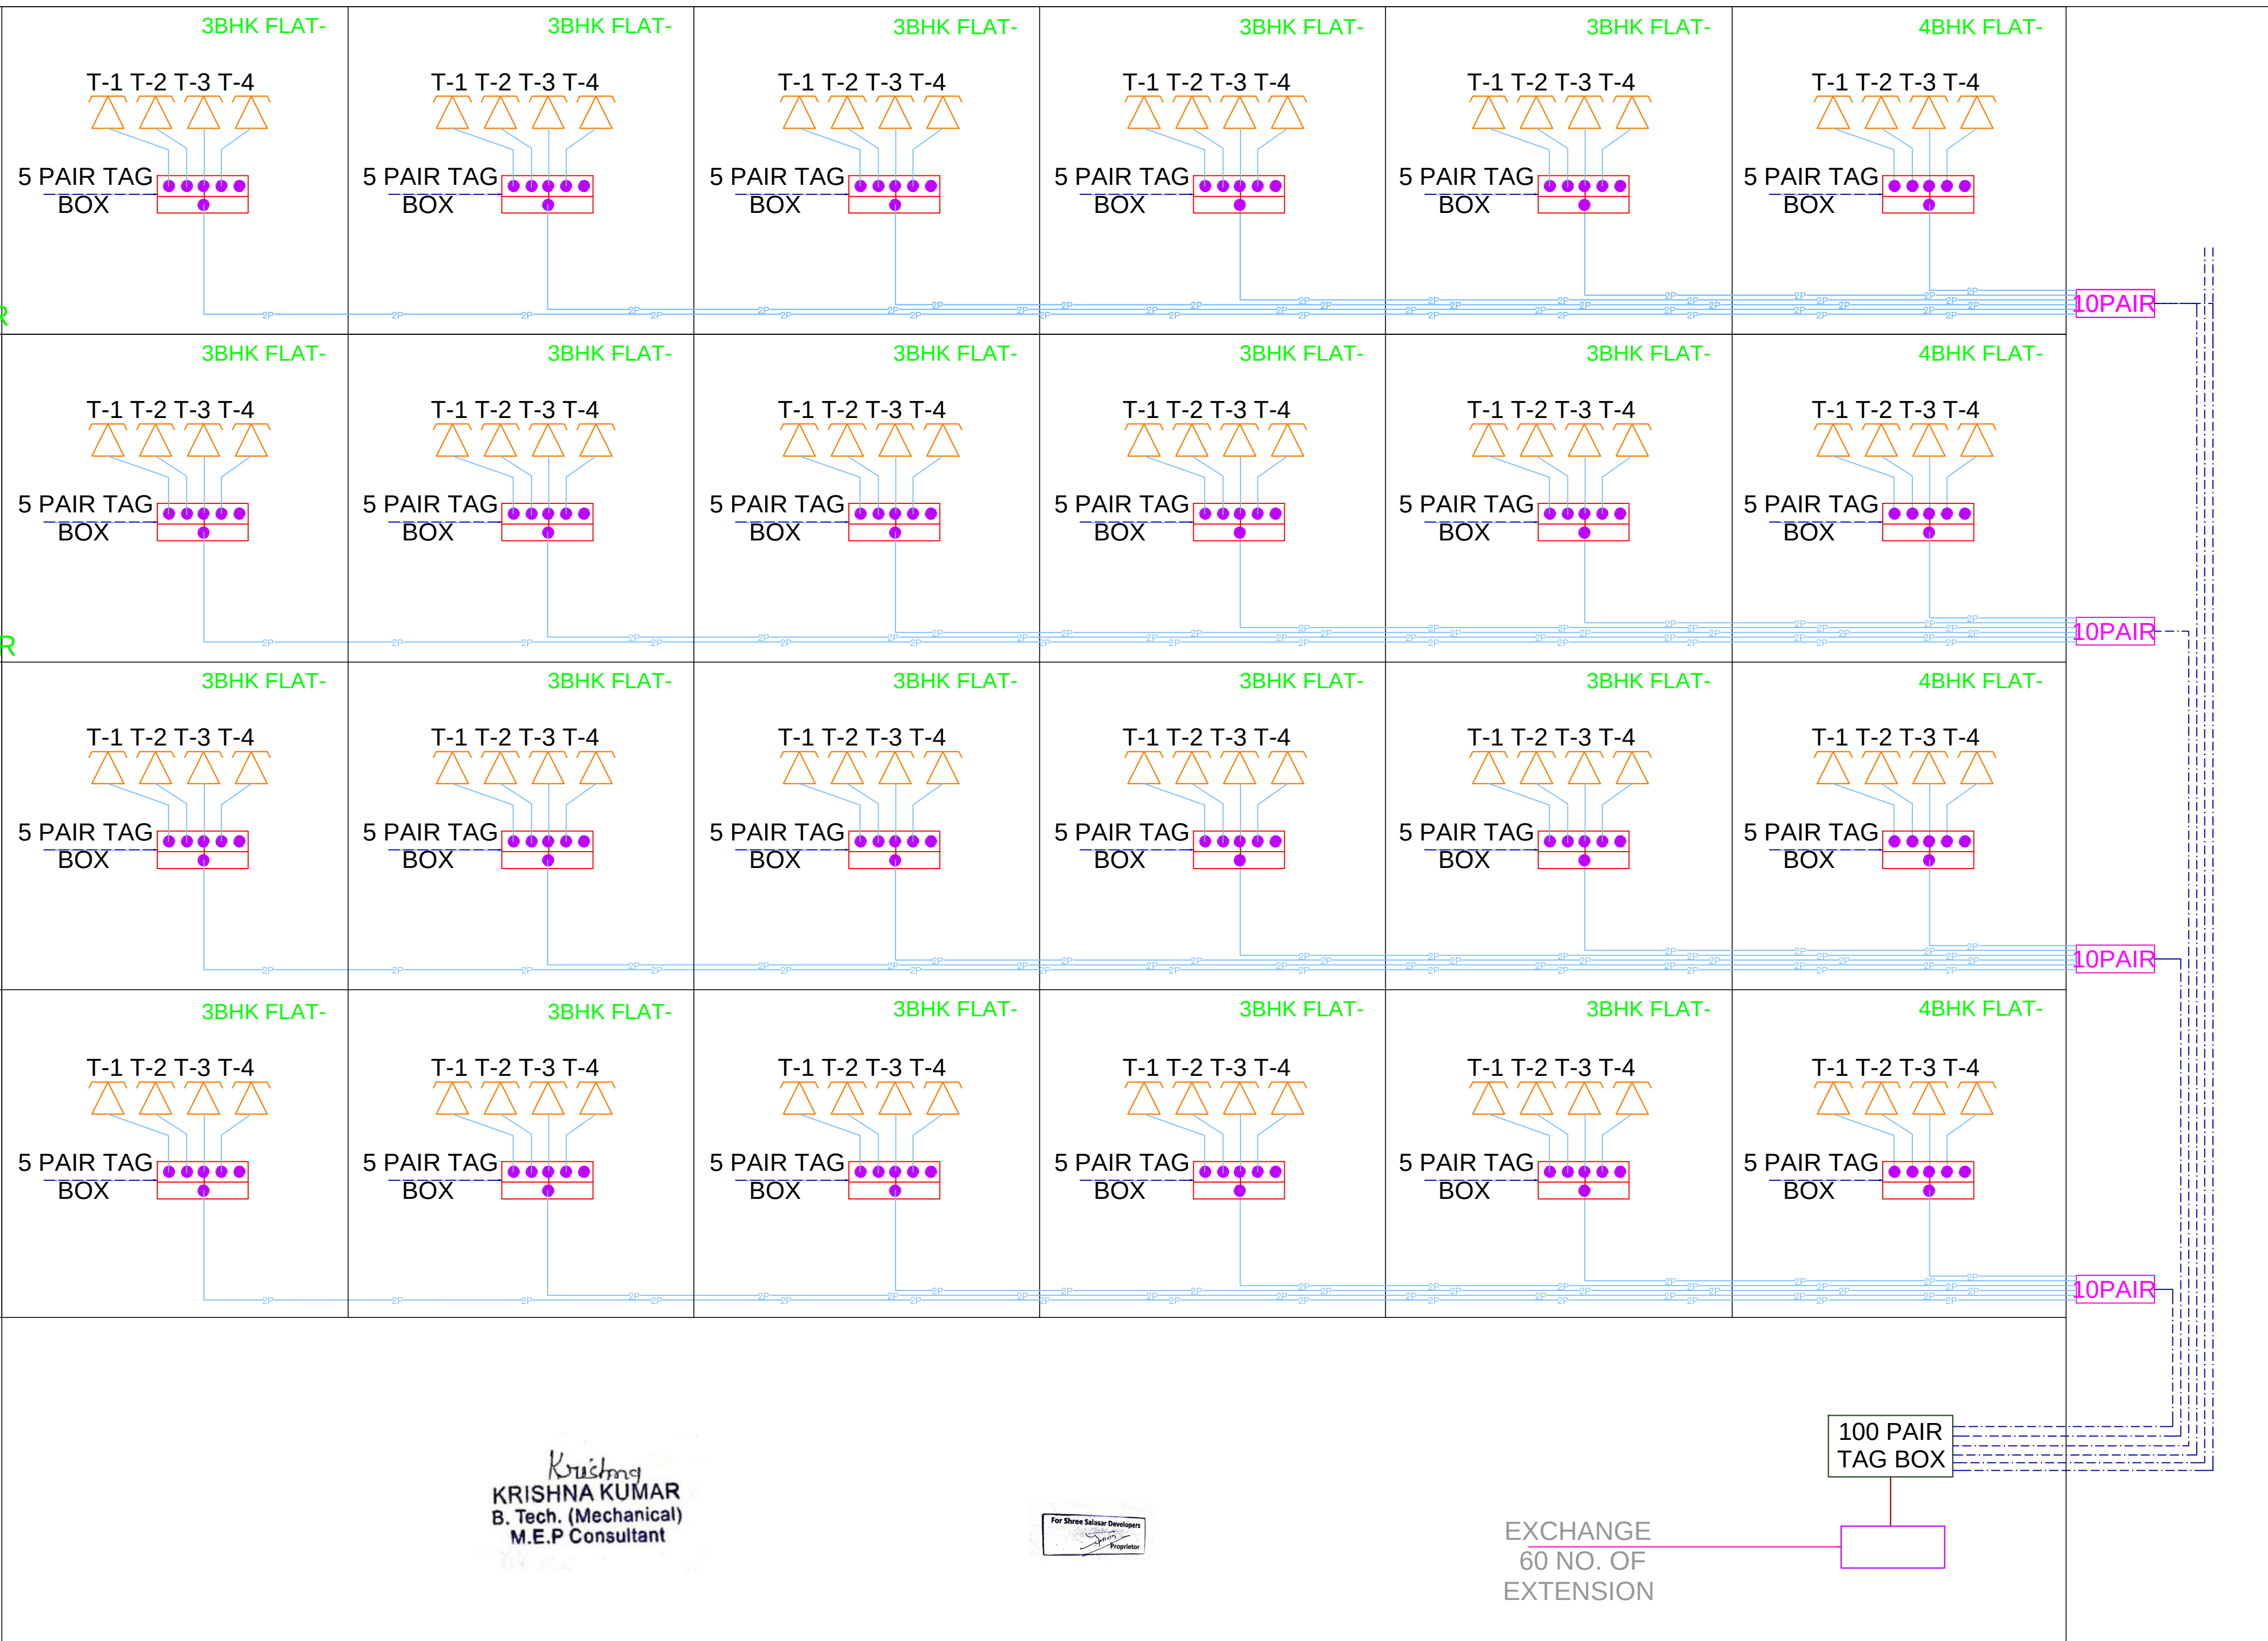

 Krishna
KRISHNA KUMAR
B. Tech. (Mechanical)
M.E.P Consultant



EXCHANGE
60 NO. OF
EXTENSION

100 PAIR
TAG BOX

WARNING

1. This drawing is the sole copyright of Architects
VISTAAR and should be used for the purpose
expressly issued.

GENERAL NOTES

1. All dimensions are in feet and inches.
2. Do not scale this drawing follow written dimensions only.
3. This drawing should be read in conjunction with other architectural and structural drawings.
4. Any discrepancy in the drawing should be immediately brought to the notice of architect.

PROJECT TITLE

SALASAR RESIDENCY
BUILDING AT
PLOT-57,SUMER NAGAR
VISTAR-Q BLOCK,JAIPUR

DRAWING TITLE

TELEPHONE
SINGLE LINE DIAGRAM

ARCHITECTS:

**VISTAAR ARCHITECTS &
PLANNERS**
Architects - Interior Designers
B-2/12, Chitrkoot scheme,
main Gandhi Path Opp mail of jaipur,Jaipur
PH - 0141-4116461,09001010366

DATE:

23-05-2024

SCALE:

AS SHOWN

NTS

AS SHOWN

DATE:

23-05-2024

SCALE:

AS SHOWN

NTS

AS SHOWN

DATE:

23-05-2024

SCALE:

AS SHOWN

NTS

AS SHOWN

DATE:

23-05-2024

SCALE:

AS SHOWN

NTS

AS SHOWN

DATE:

23-05-2024

SCALE:

AS SHOWN

NTS

AS SHOWN

DATE:

23-05-2024

SCALE:

AS SHOWN

NTS

AS SHOWN

DATE:

23-05-2024

SCALE:

AS SHOWN

NTS

AS SHOWN

DATE:

23-05-2024

SCALE:

AS SHOWN

NTS

AS SHOWN

DATE:

23-05-2024

SCALE:

AS SHOWN

NTS

AS SHOWN

DATE:

23-05-2024

SCALE:

AS SHOWN

NTS

AS SHOWN

DATE:

23-05-2024

SCALE:

AS SHOWN

NTS

AS SHOWN

DATE:

23-05-2024

SCALE:

AS SHOWN

NTS

AS SHOWN

DATE:

23-05-2024

SCALE:

AS SHOWN

NTS

AS SHOWN

DATE:

23-05-2024

SCALE:

AS SHOWN

NTS

AS SHOWN

DATE:

23-05-2024

SCALE:

AS SHOWN

NTS

AS SHOWN

DATE:

23-05-2024

SCALE:

AS SHOWN

NTS

AS SHOWN

DATE:

23-05-2024

SCALE:

AS SHOWN

NTS

AS SHOWN

DATE:

23-05-2024

SCALE:

AS SHOWN

NTS

AS SHOWN

DATE:

23-05-2024

SCALE:

AS SHOWN

NTS

AS SHOWN

DATE:

23-05-2024

SCALE:

AS SHOWN

NTS

AS SHOWN

DATE:

23-05-2024

SCALE:

AS SHOWN

NTS

AS SHOWN

DATE:

23-05-2024

SCALE:

AS SHOWN

NTS

AS SHOWN

DATE:

23-05-2024

SCALE:

AS SHOWN

NTS

AS SHOWN

DATE:

23-05-2024

SCALE:

AS SHOWN

NTS

AS SHOWN

DATE:

23-05-2024

SCALE:

AS SHOWN

NTS

AS SHOWN

DATE:

23-05-2024

SCALE:

AS SHOWN

NTS

AS SHOWN

DATE:

23-05-2024

SCALE:

AS SHOWN

NTS

AS SHOWN

DATE:

23-05-2024

SCALE:

AS SHOWN

NTS

AS SHOWN

DATE:

23-05-2024

SCALE:

AS SHOWN

NTS

AS SHOWN

DATE:

23-05-2024

SCALE:

AS SHOWN

NTS

AS SHOWN

DATE:

23-05-2024

SCALE:

AS SHOWN

NTS

AS SHOWN

DATE:

23-05-2024

SCALE:

AS SHOWN

NTS

AS SHOWN

DATE:

23-05-2024

SCALE:

AS SHOWN

NTS

AS SHOWN

DATE:

23-05-2024

SCALE:

AS SHOWN

NTS

AS SHOWN

DATE:

23-05-2024

SCALE:

AS SHOWN

NTS

AS SHOWN

DATE:

23-05-2024

SCALE:

AS SHOWN

NTS

AS SHOWN

DATE:

23-05-2024

SCALE:

AS SHOWN

NTS

AS SHOWN

DATE:

23-05-2024

SCALE:

AS SHOWN

NTS

AS SHOWN

DATE:

23-05-2024

SCALE:

AS SHOWN

NTS

AS SHOWN

DATE:

23-05-2024

SCALE:

AS SHOWN

NTS

AS SHOWN

DATE:

23-05-2024

SCALE:

AS SHOWN

NTS

AS SHOWN

DATE:

23-05-2024

SCALE:

AS SHOWN

NTS

AS SHOWN

DATE:

23-05-2024

SCALE:

AS SHOWN

NTS

AS SHOWN

DATE:

23-05-2024

SCALE:

AS SHOWN


NTS


AS SHOWN

DATE:

23-05-2024

SCALE:

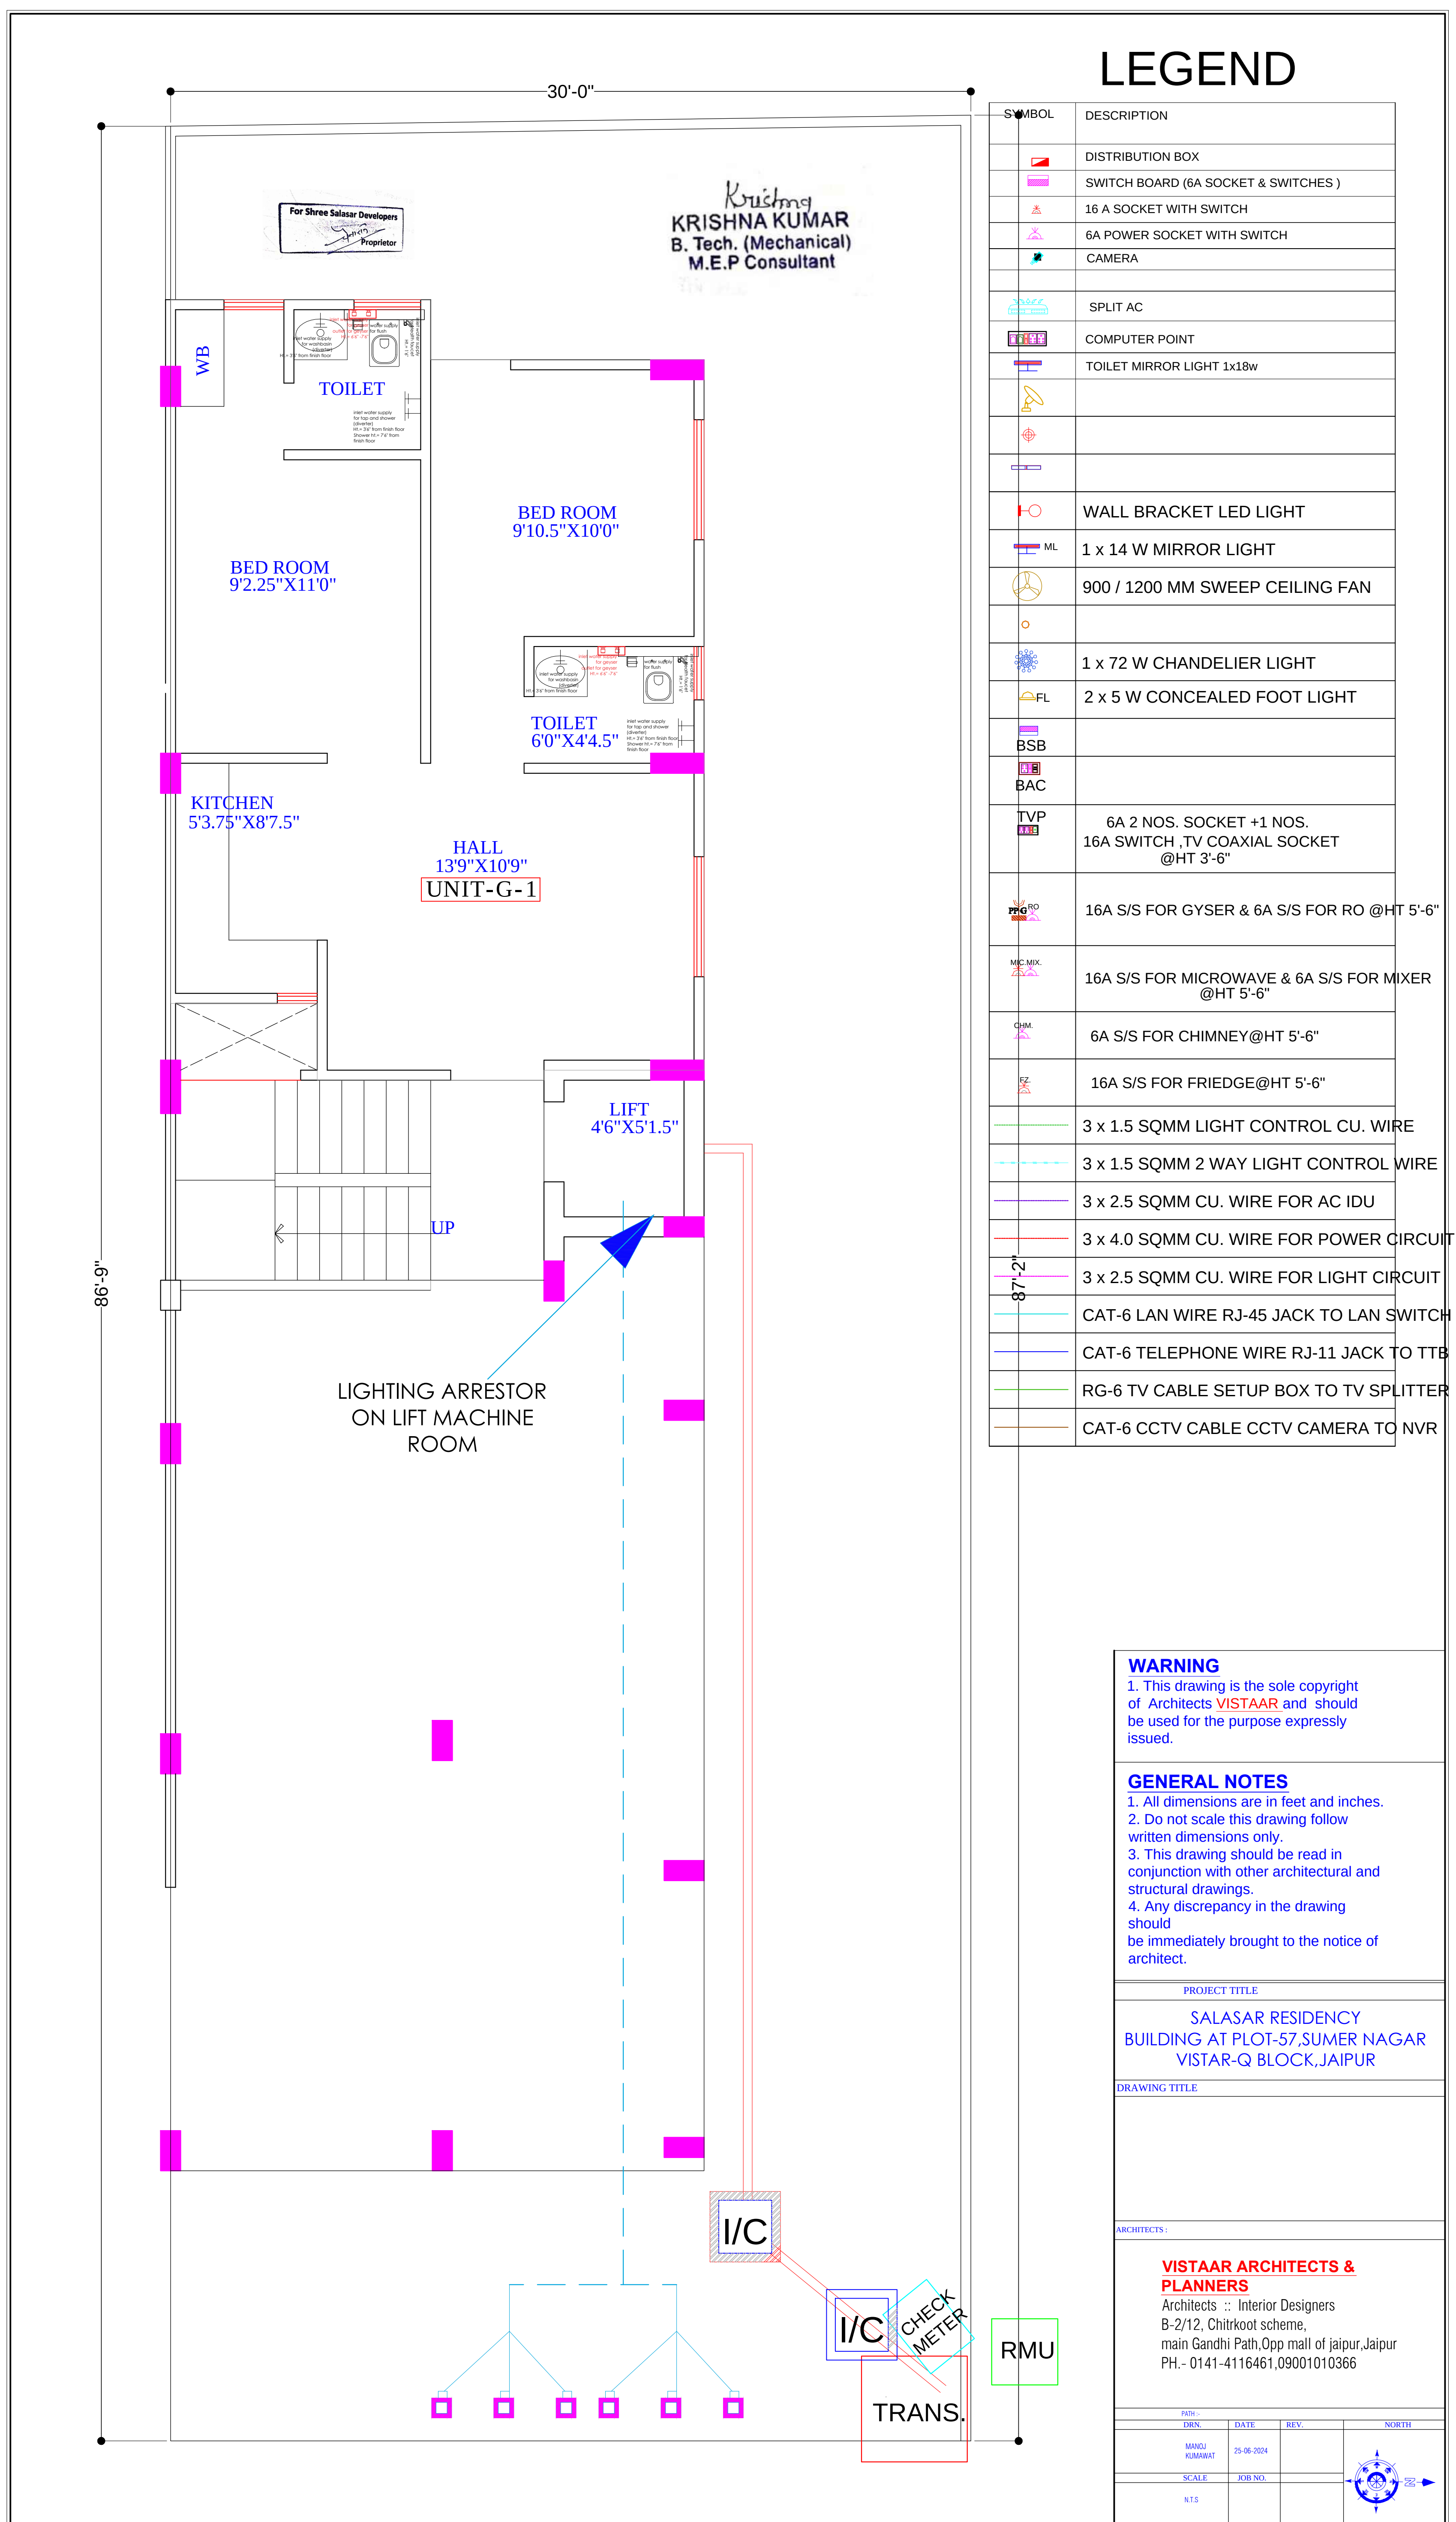

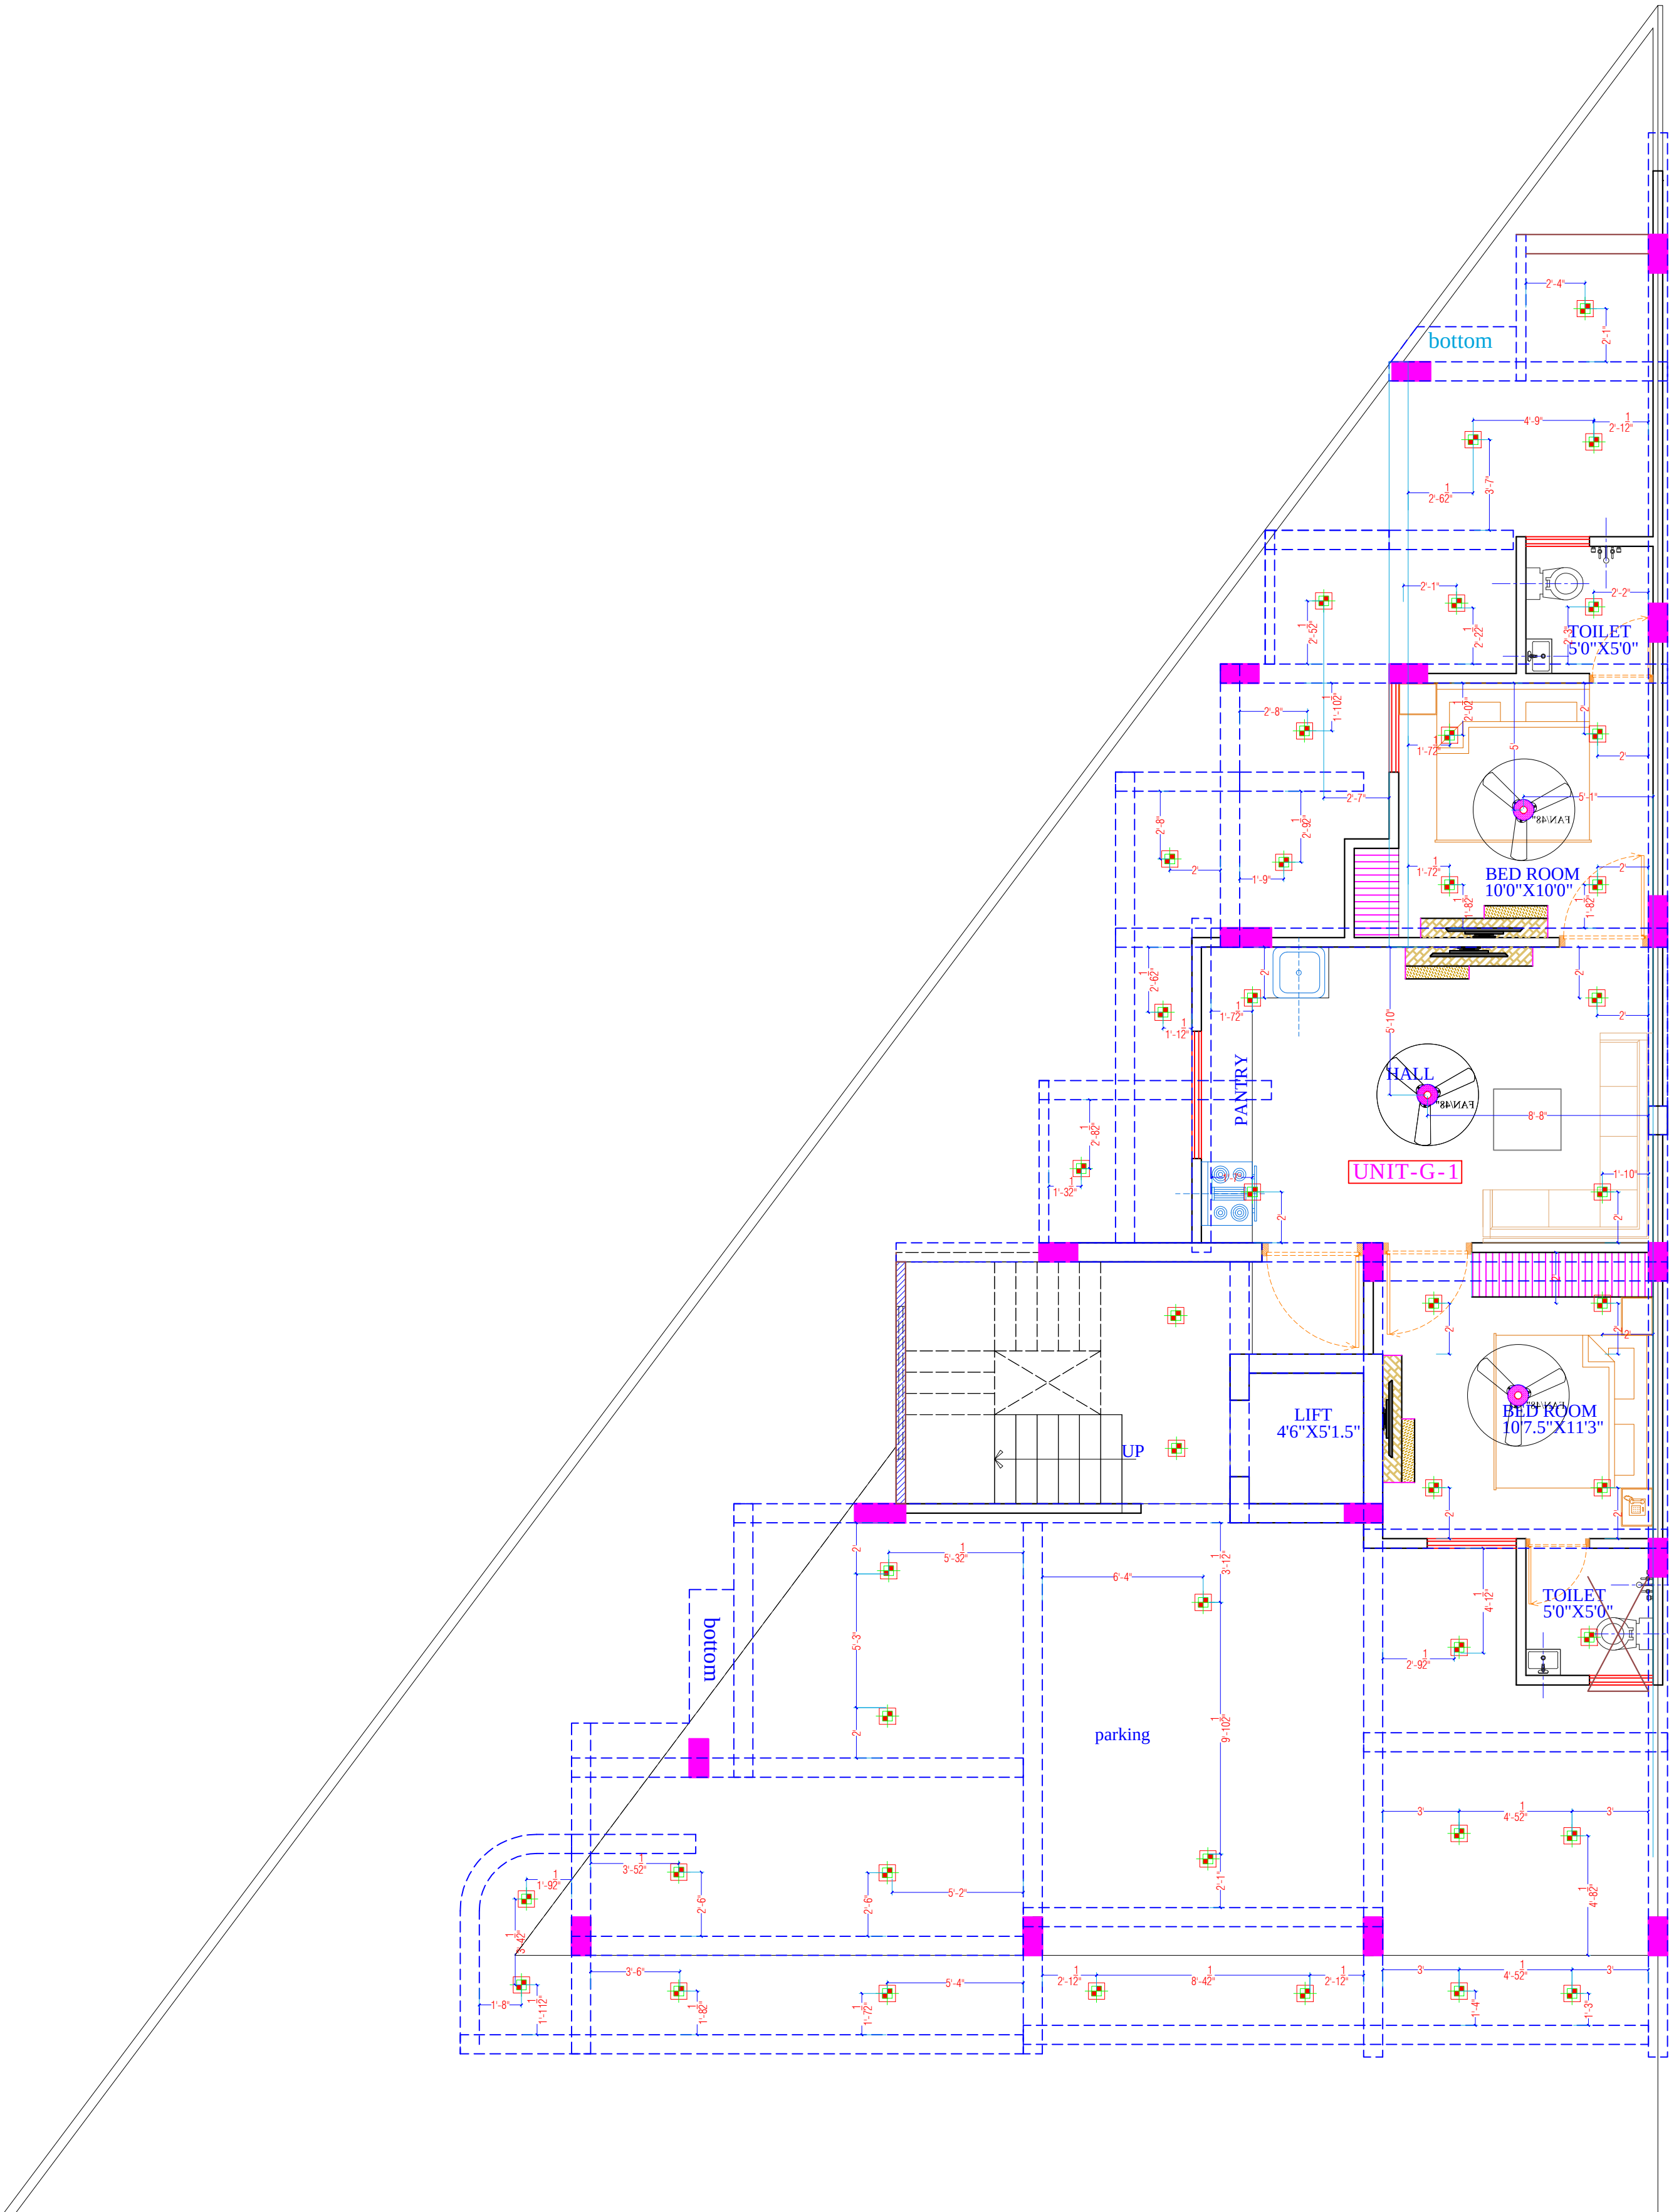

For Shree Salasar Designers
Proprietor

Krishna
KRISHNA KUMAR
B. Tech. (Mechanical)
M.E.P Consultant

LEGENDS:				
Mounting Height	No.	I D	Symbol	Description
IN FLOOR				
IN CONDUIT				CONTROL WIRING
IN CONDUIT				CONTROL WIRING
IN CONDUIT				AC CONTROL WIRING
IN CONDUIT				GYSER CONTROL WIRING
IN CONDUIT				BUIZZER CONTROL WIRING
CEILING	FAN/48"			CEILING FAN 48"
CEILING	FAN/30"			CEILING FAN 30"
+90"	TL			1X10W WALL TUBELIGHT
+90"	BULB			WALL BRACKETS AS DESIGN LIGHT
+90"	GL			WALL BRACKETS AS DESIGN FOR GANESH LIGHT
	GL			WALL BRACKETS AS DESIGN FOR GATE LIGHT
CEILING	CFL			CFL CEILING LIGHT
+21"	FL			FOOT LIGHT
+48"	SB			SWITCH BOARD
+70"	ML			1 X 11 W CFL MIRROR LIGHT
VENTILATOR HT.	CR			CEILING ROSE
VENTILATOR HT.	EXF			8" DIA FRESH AIR FAN
+24"	TEL			TELEPHONE POINT
+27"	TV			TV COAXIAL POINT
+27"	LP-TV			6 A PLUG POINT FOR TV
+72"	LP-CH			6 A PLUG POINT FOR CHIMNEY
+102"	SAC			SPLIT AC
+102"	PP-SAC			25 A POWER POINT FOR SPLIT AC
+42"	PP-MIX			15 A POWER POINT FOR MIXER
+78"	PP-G			15 A POWER POINT FOR GEYSER
+54"	PP-F			15 A POWER POINT FOR FRIDGE
+78"	PP-WP			15 A POWER POINT FOR WATER PURIFIER
+48"	PP-WM			15 A POWER POINT FOR WASHING MACHINE
+42"	BP			BELL PUSH SWITCH
+90"	BZ			BUIZZER POINT
+48"	AC			AC STARTER
+60"	MCB DB			MCB DISTRIBUTION BOARD

WARNING

1. This drawing is the sole copyright of Architects VISTAAR and should be used for the purpose expressly issued.

GENERAL NOTES

- All dimensions are in feet and inches.
- Do not scale this drawing follow written dimensions only.
- This drawing should be read in conjunction with other architectural and structural drawings.
- Any discrepancy in the drawing should be immediately brought to the notice of architect.

PROJECT TITLE

SALASAR RESIDENCY
BUILDING AT PLOT-58,SUMER NAGAR
VISTAR-Q BLOCK,JAIPUR


DRAWING TITLE

STILT FLOOR CEILING ELECTRICAL PLAN

ARCHITECTS :

VISTAAR ARCHITECTS &
PLANNERS
Architects :: Interior Designers
B-2/12, Chaitrakoot scheme,
main Gandhi Path,Opp mall of jaipur,Jaipur
PH - 0141-4116461,09001010366

PANEL		DATE	REV.	NORTH
DEN	MARKU	23-05-2022		
SCALE	JOB NO.			
NTS				

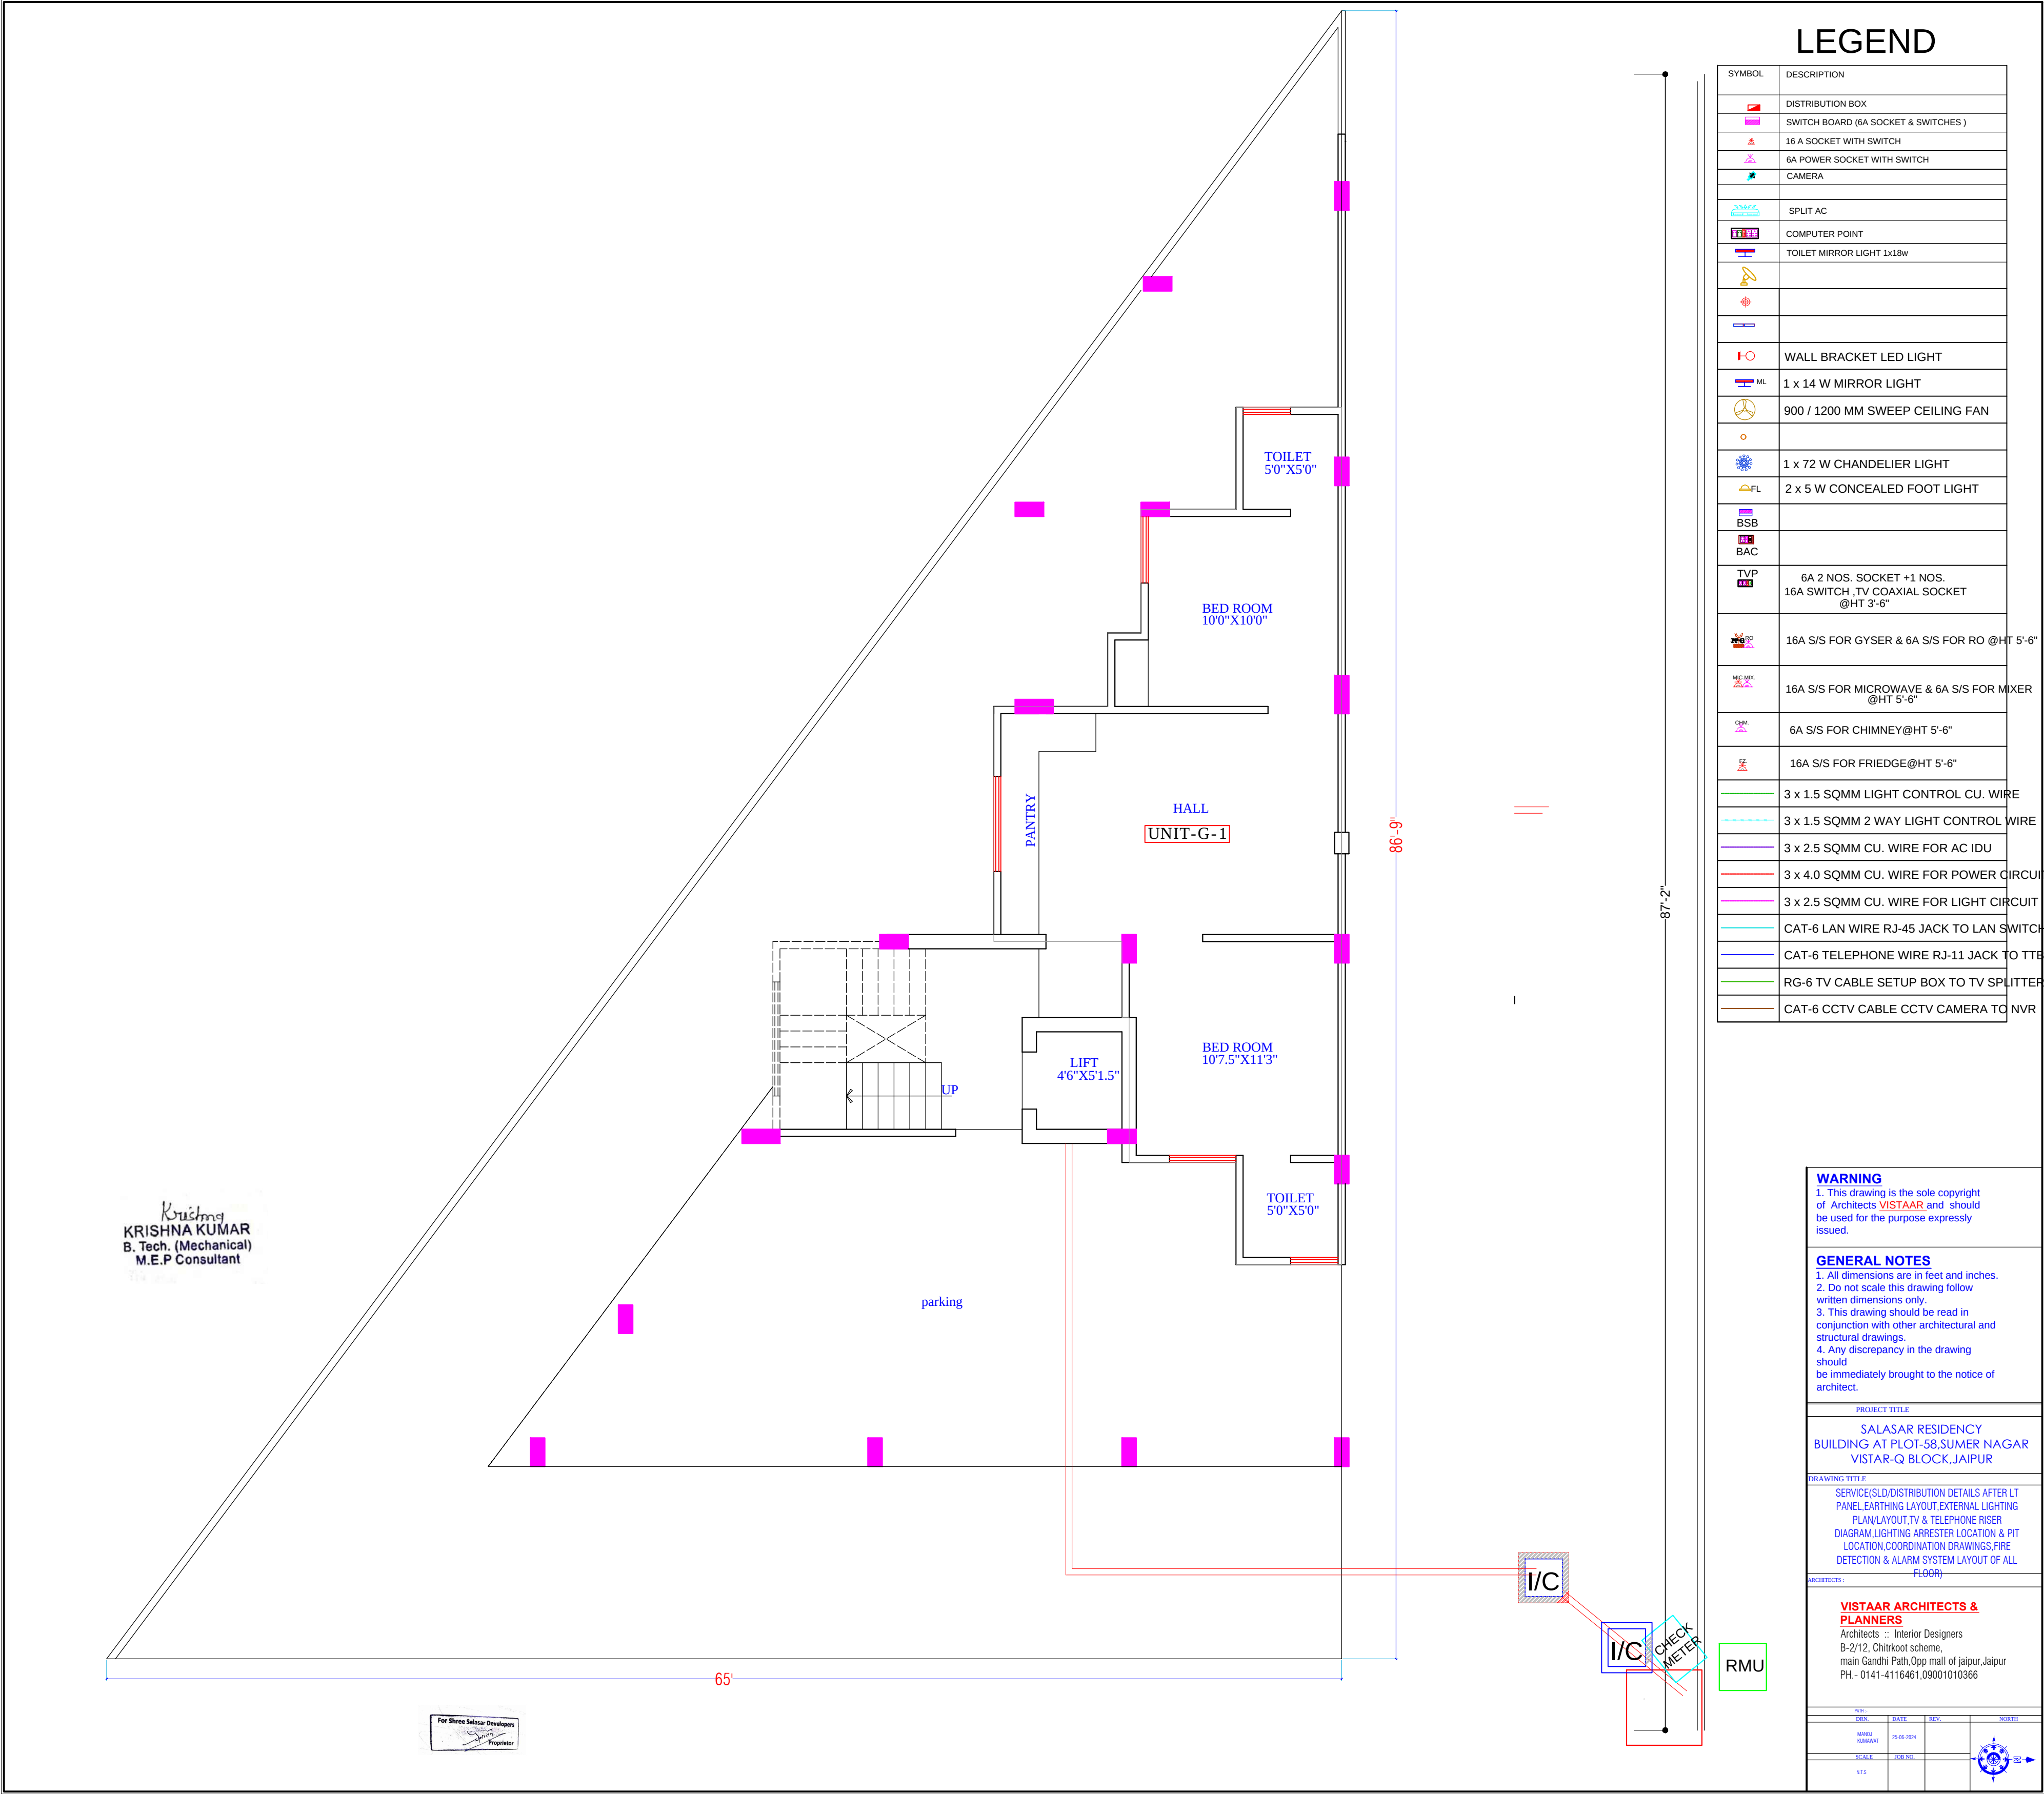

LEGEND

SYMBOL	DESCRIPTION
	DISTRIBUTION BOX
	SWITCH BOARD (6A SOCKET & SWITCHES)
	16 A SOCKET WITH SWITCH
	6A POWER SOCKET WITH SWITCH
	CAMERA
	SPLIT AC
	COMPUTER POINT
	TOILET MIRROR LIGHT 1x18w
	WALL BRACKET LED LIGHT
	1 x 14 W MIRROR LIGHT
	900 / 1200 MM SWEEP CEILING FAN
	1 x 72 W CHANDELIER LIGHT
	2 x 5 W CONCEALED FOOT LIGHT
	BSB
	BAC
	TVP
	6A 2 NOS. SOCKET +1 NOS. 16A SWITCH ,TV COAXIAL SOCKET @HT 3'-6"
	16A S/S FOR GYSER & 6A S/S FOR RO @HT 5'-6"
	16A S/S FOR MICROWAVE & 6A S/S FOR MIXER @HT 5'-6"
	6A S/S FOR CHIMNEY@HT 5'-6"
	16A S/S FOR FRIDGE@HT 5'-6"
	3 x 1.5 SQMM LIGHT CONTROL CU. WIRE
	3 x 1.5 SQMM 2 WAY LIGHT CONTROL WIRE
	3 x 2.5 SQMM CU. WIRE FOR AC IDU
	3 x 4.0 SQMM CU. WIRE FOR POWER CIRCUIT
	3 x 2.5 SQMM CU. WIRE FOR LIGHT CIRCUIT
	CAT-6 LAN WIRE RJ-45 JACK TO LAN SWITCH
	CAT-6 TELEPHONE WIRE RJ-11 JACK TO TTB
	RG-6 TV CABLE SETUP BOX TO TV SPLITTER
	CAT-6 CCTV CABLE CCTV CAMERA TO NVR


WARNING
1. This drawing is the sole copyright of Architects VISTAAR and should be used for the purpose expressly issued.

GENERAL NOTES
1. All dimensions are in feet and inches.
2. Do not scale this drawing follow written dimensions only.
3. This drawing should be read in conjunction with other architectural and structural drawings.
4. Any discrepancy in the drawing should be immediately brought to the notice of architect.

PROJECT TITLE			
SALASAR RESIDENCY BUILDING AT PLOT-58,SUMER NAGAR VISTAR-Q BLOCK,JAIPUR			
DRAWING TITLE			
SERVICE(S)DISTRIBUTION DETAILS AFTER LT PANEL,EARTHING LAYOUT,EXTERNAL LIGHTING PLAN,LAYOUT,TV & TELEPHONE RISER DIAGRAM,LIGHTING ARRESTER LOCATION & PIT LOCATION,COORDINATION DRAWINGS,FIRE DETECTION & ALARM SYSTEM LAYOUT OF ALL FLOOR(S)			
ARCHITECTS			
VISTAAR ARCHITECTS & PLANNERS Architects :: Interior Designers B-2/12, Chitrkoot scheme, main Gandhi Path Opp mall of Jaipur,Jaipur PH - 0141-4116451,09001010366			
DATE	DATE	DATE	DATE
25-06-2024			
SCALE	DATE		
1/12			

Krishna
KRISHNA KUMAR
B. Tech. (Mechanical)
M.E.P Consultant

For Shree Salasar Developers
Project Manager

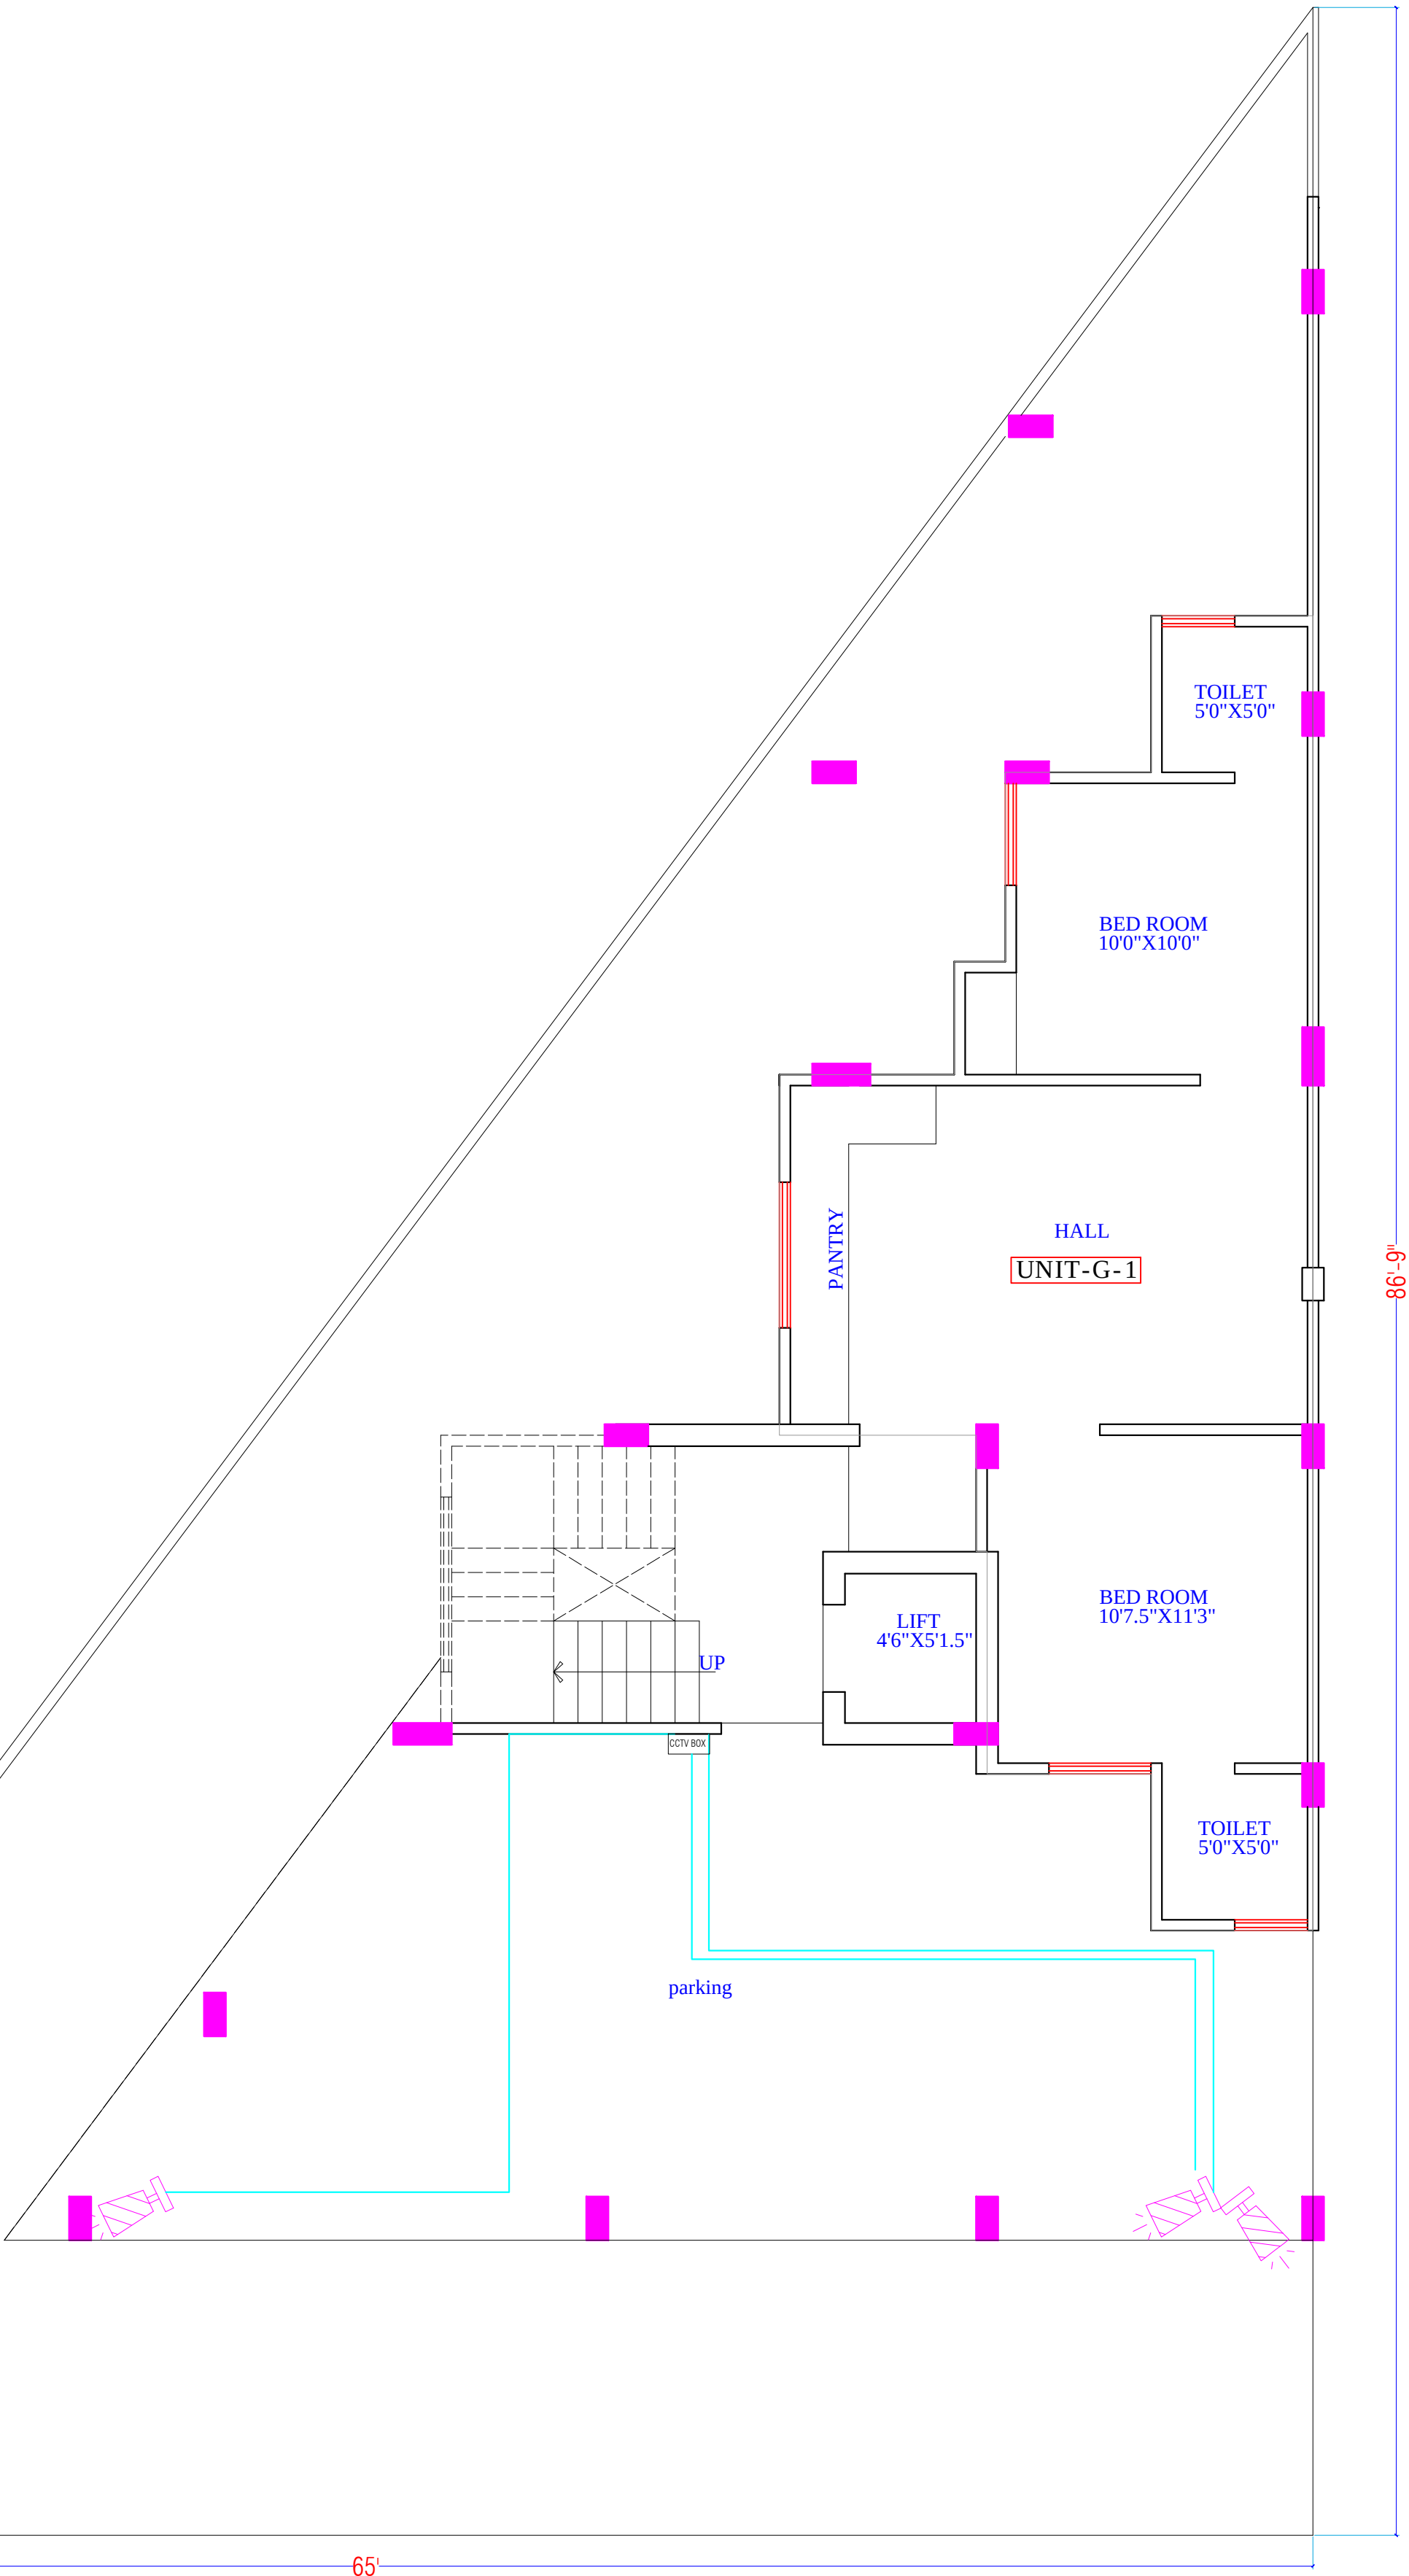

WARNING
1. This drawing is the sole copyright of Architects **VISTAAR** and should be used for the purpose expressly issued.


GENERAL NOTES
1. All dimensions are in feet and inches.
2. Do not scale this drawing follow written dimensions only.
3. This drawing should be read in conjunction with other architectural and structural drawings.
4. Any discrepancy in the drawing should be immediately brought to the notice of architect.


PROJECT TITLE
**SALASAR RESIDENCY
BUILDING AT PLOT-58,SUMER NAGAR
VISTAR-Q BLOCK,JAIPUR**

DRAWING TITLE
CCTV PLAN

ARCHITECTS :
**VISTAAR ARCHITECTS &
PLANNERS**
Architects :: Interior Designers
B-2/12, Chitrkoot scheme,
main Gandhi Path,Opp mall of jaipur,Jaipur
Ph.- 0141-4116461,09001010366

DATE	DATE	REV.	NORTH
29-05-2022			
SCALE	JOB NO.		
NTS			

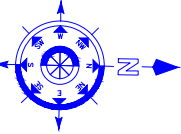

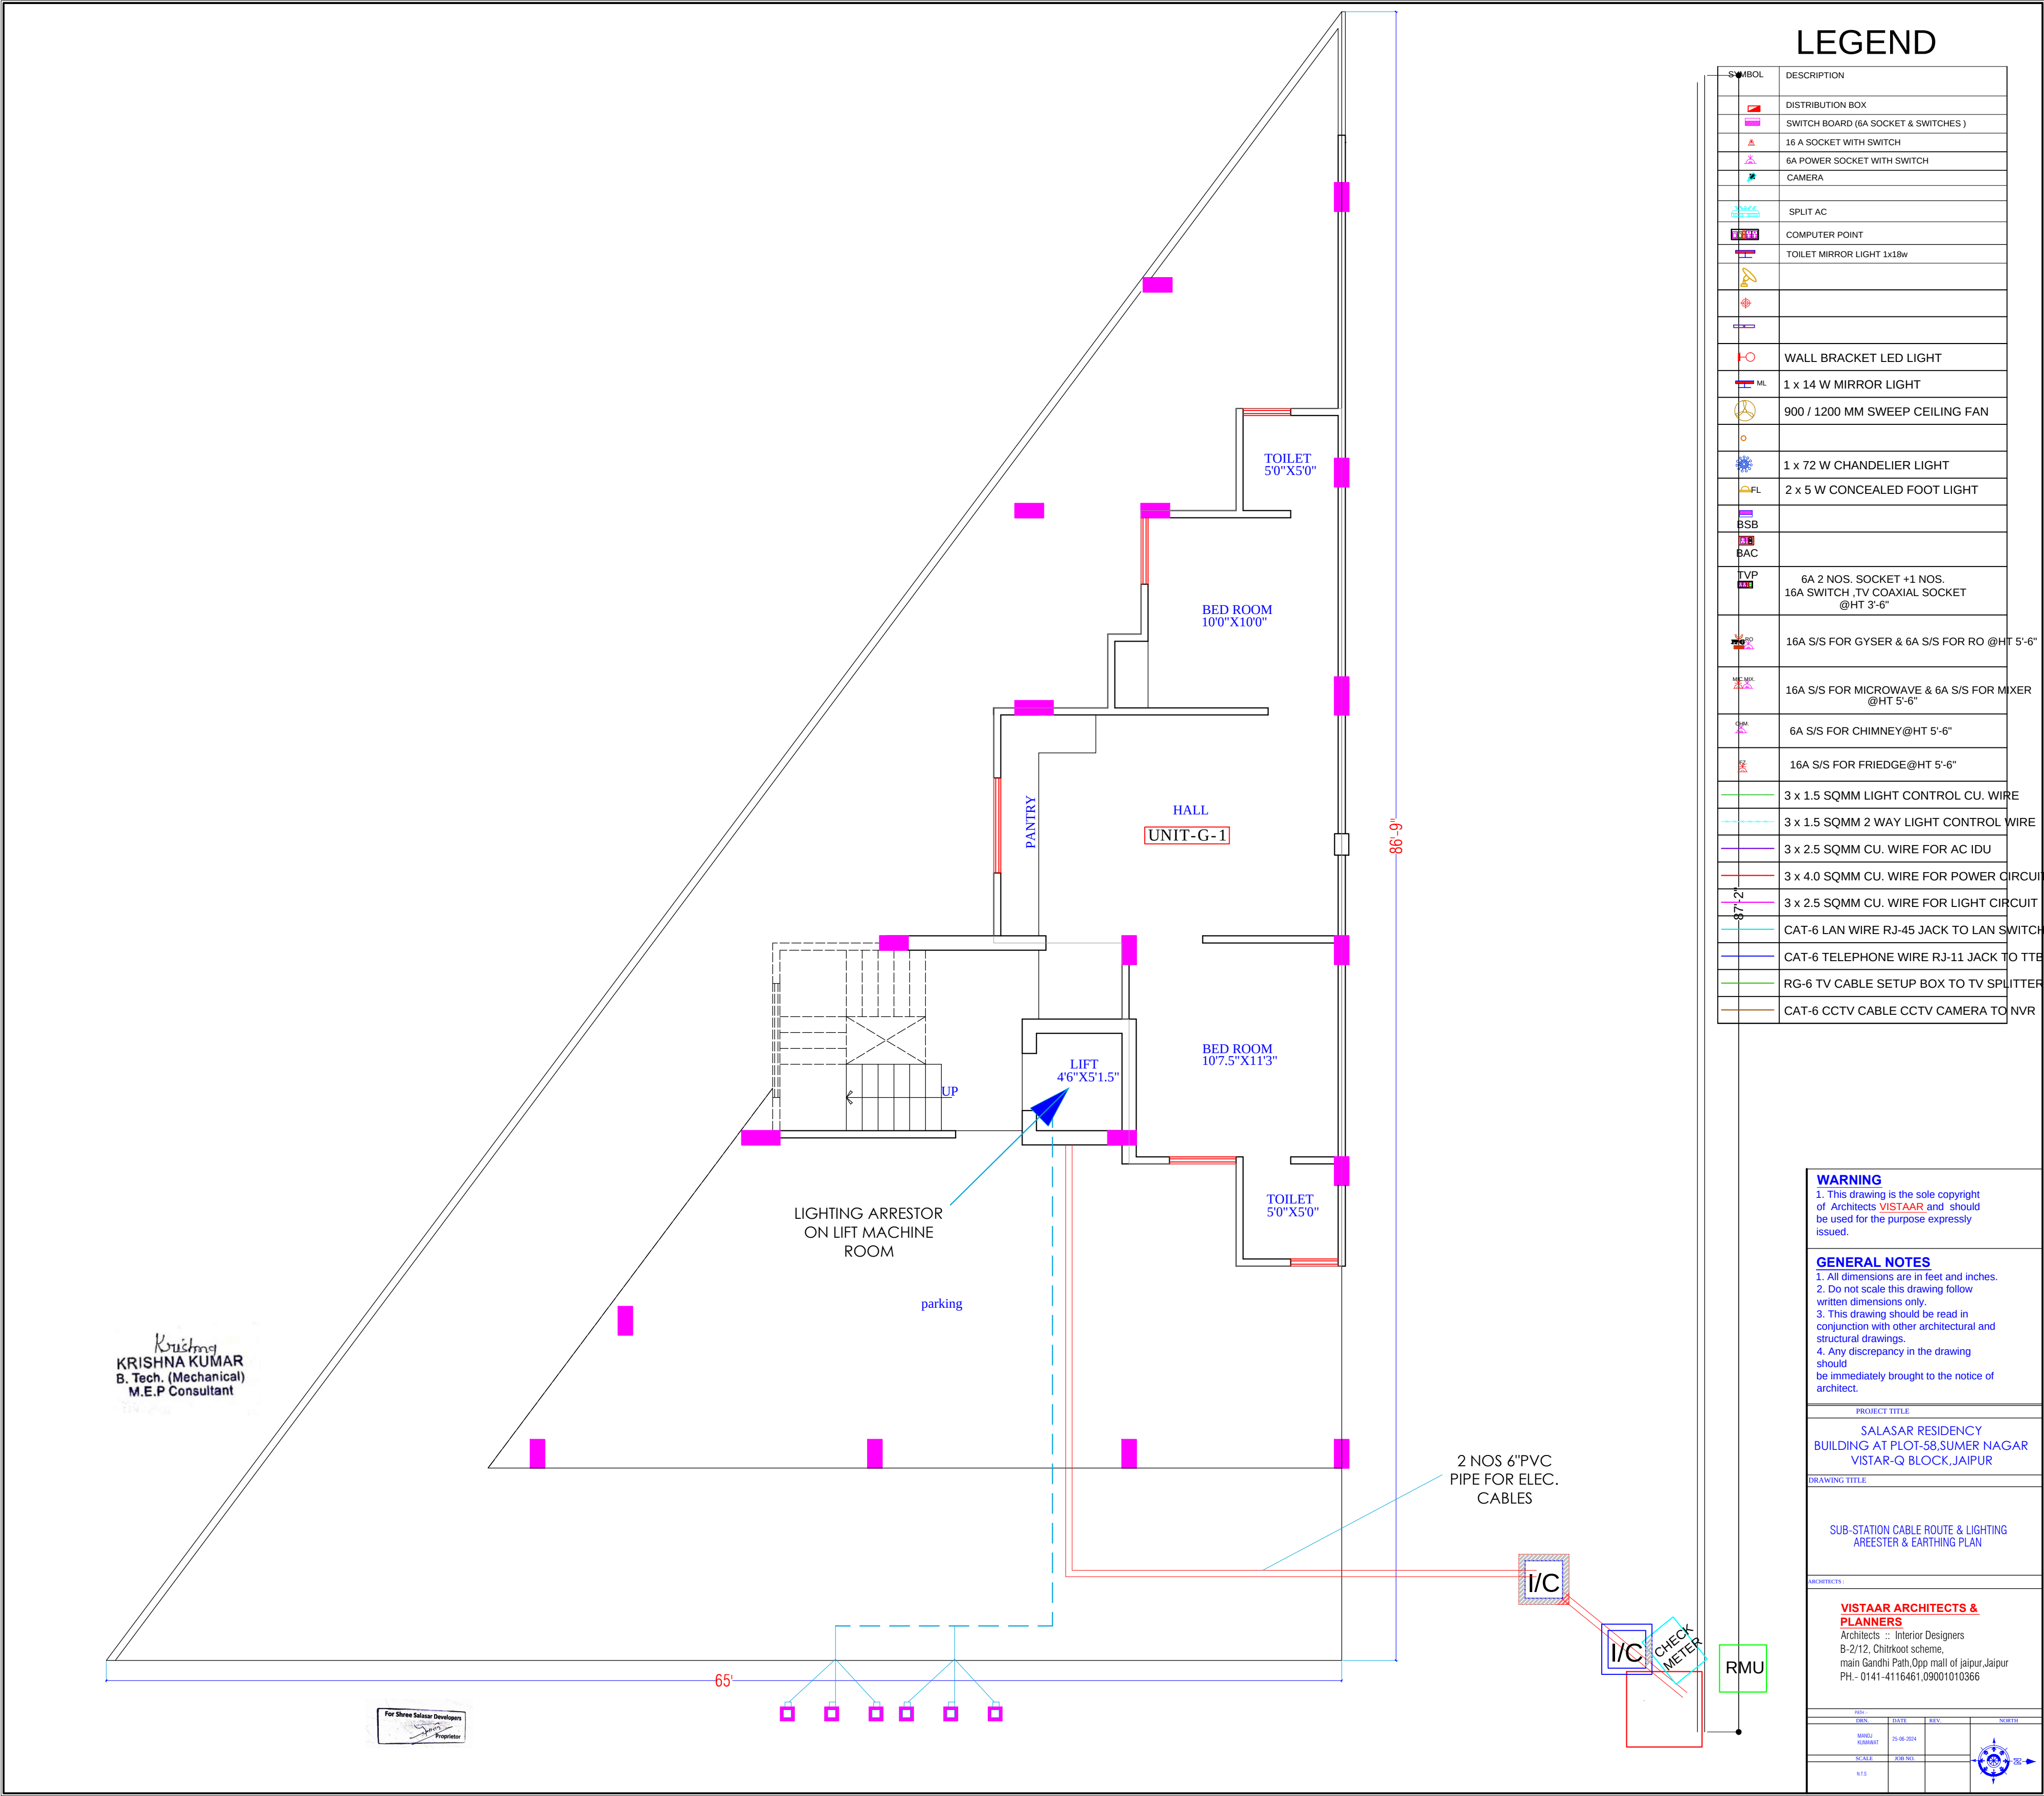


LEGEND

SYMBOL	DESCRIPTION
	DISTRIBUTION BOX
	SWITCH BOARD (6A SOCKET & SWITCHES)
	16 A SOCKET WITH SWITCH
	6A POWER SOCKET WITH SWITCH
	CAMERA
	SPLIT AC
	COMPUTER POINT
	TOILET MIRROR LIGHT 1x18w
	WALL BRACKET LED LIGHT
	1 x 14 W MIRROR LIGHT
	900 / 1200 MM SWEEP CEILING FAN
	1 x 72 W CHANDELIER LIGHT
	2 x 5 W CONCEALED FOOT LIGHT
	BSB
	BAC
	6A 2 NOS. SOCKET +1 NOS. 16A SWITCH ,TV COAXIAL SOCKET @HT 3'-6"
	16A S/S FOR GYSER & 6A S/S FOR RO @HT 5'-6"
	16A S/S FOR MICROWAVE & 6A S/S FOR MIXER @HT 5'-6"
	6A S/S FOR CHIMNEY@HT 5'-6"
	16A S/S FOR FRIEDGE@HT 5'-6"
	3 x 1.5 SQMM LIGHT CONTROL CU. WIRE
	3 x 1.5 SQMM 2 WAY LIGHT CONTROL WIRE
	3 x 2.5 SQMM CU. WIRE FOR AC IDU
	3 x 4.0 SQMM CU. WIRE FOR POWER CIRCUIT
	3 x 2.5 SQMM CU. WIRE FOR LIGHT CIRCUIT
	CAT-6 LAN WIRE RJ-45 JACK TO LAN SWITCH
	CAT-6 TELEPHONE WIRE RJ-11 JACK TO TTE
	RG-6 TV CABLE SETUP BOX TO TV SPLITTER
	CAT-6 CCTV CABLE CCTV CAMERA TO NVR

WARNING
1. This drawing is the sole copyright of Architects **VISTAAR** and should be used for the purpose expressly issued.

GENERAL NOTES
1. All dimensions are in feet and inches.
2. Do not scale this drawing follow written dimensions only.
3. This drawing should be read in conjunction with other architectural and structural drawings.
4. Any discrepancy in the drawing should be immediately brought to the notice of architect.

PROJECT TITLE			
SALASAR RESIDENCY BUILDING AT PLOT-58,SUMER NAGAR VISTAR-Q BLOCK,JAIPUR			
DRAWING TITLE			
SUB-STATION CABLE ROUTE & LIGHTING ARRESTER & EARTHING PLAN			
ARCHITECTS			
VISTAAR ARCHITECTS & PLANNERS Architects :: Interior Designers B-2/12, Chitrkoot scheme, main Gandhi Path,Opp mall of jaipur,Jaipur PH - 0141-4116461,09001010366			
REV.	DATE	REV.	NOTES
01	24-06-2024		
02	24-06-2024		
03			

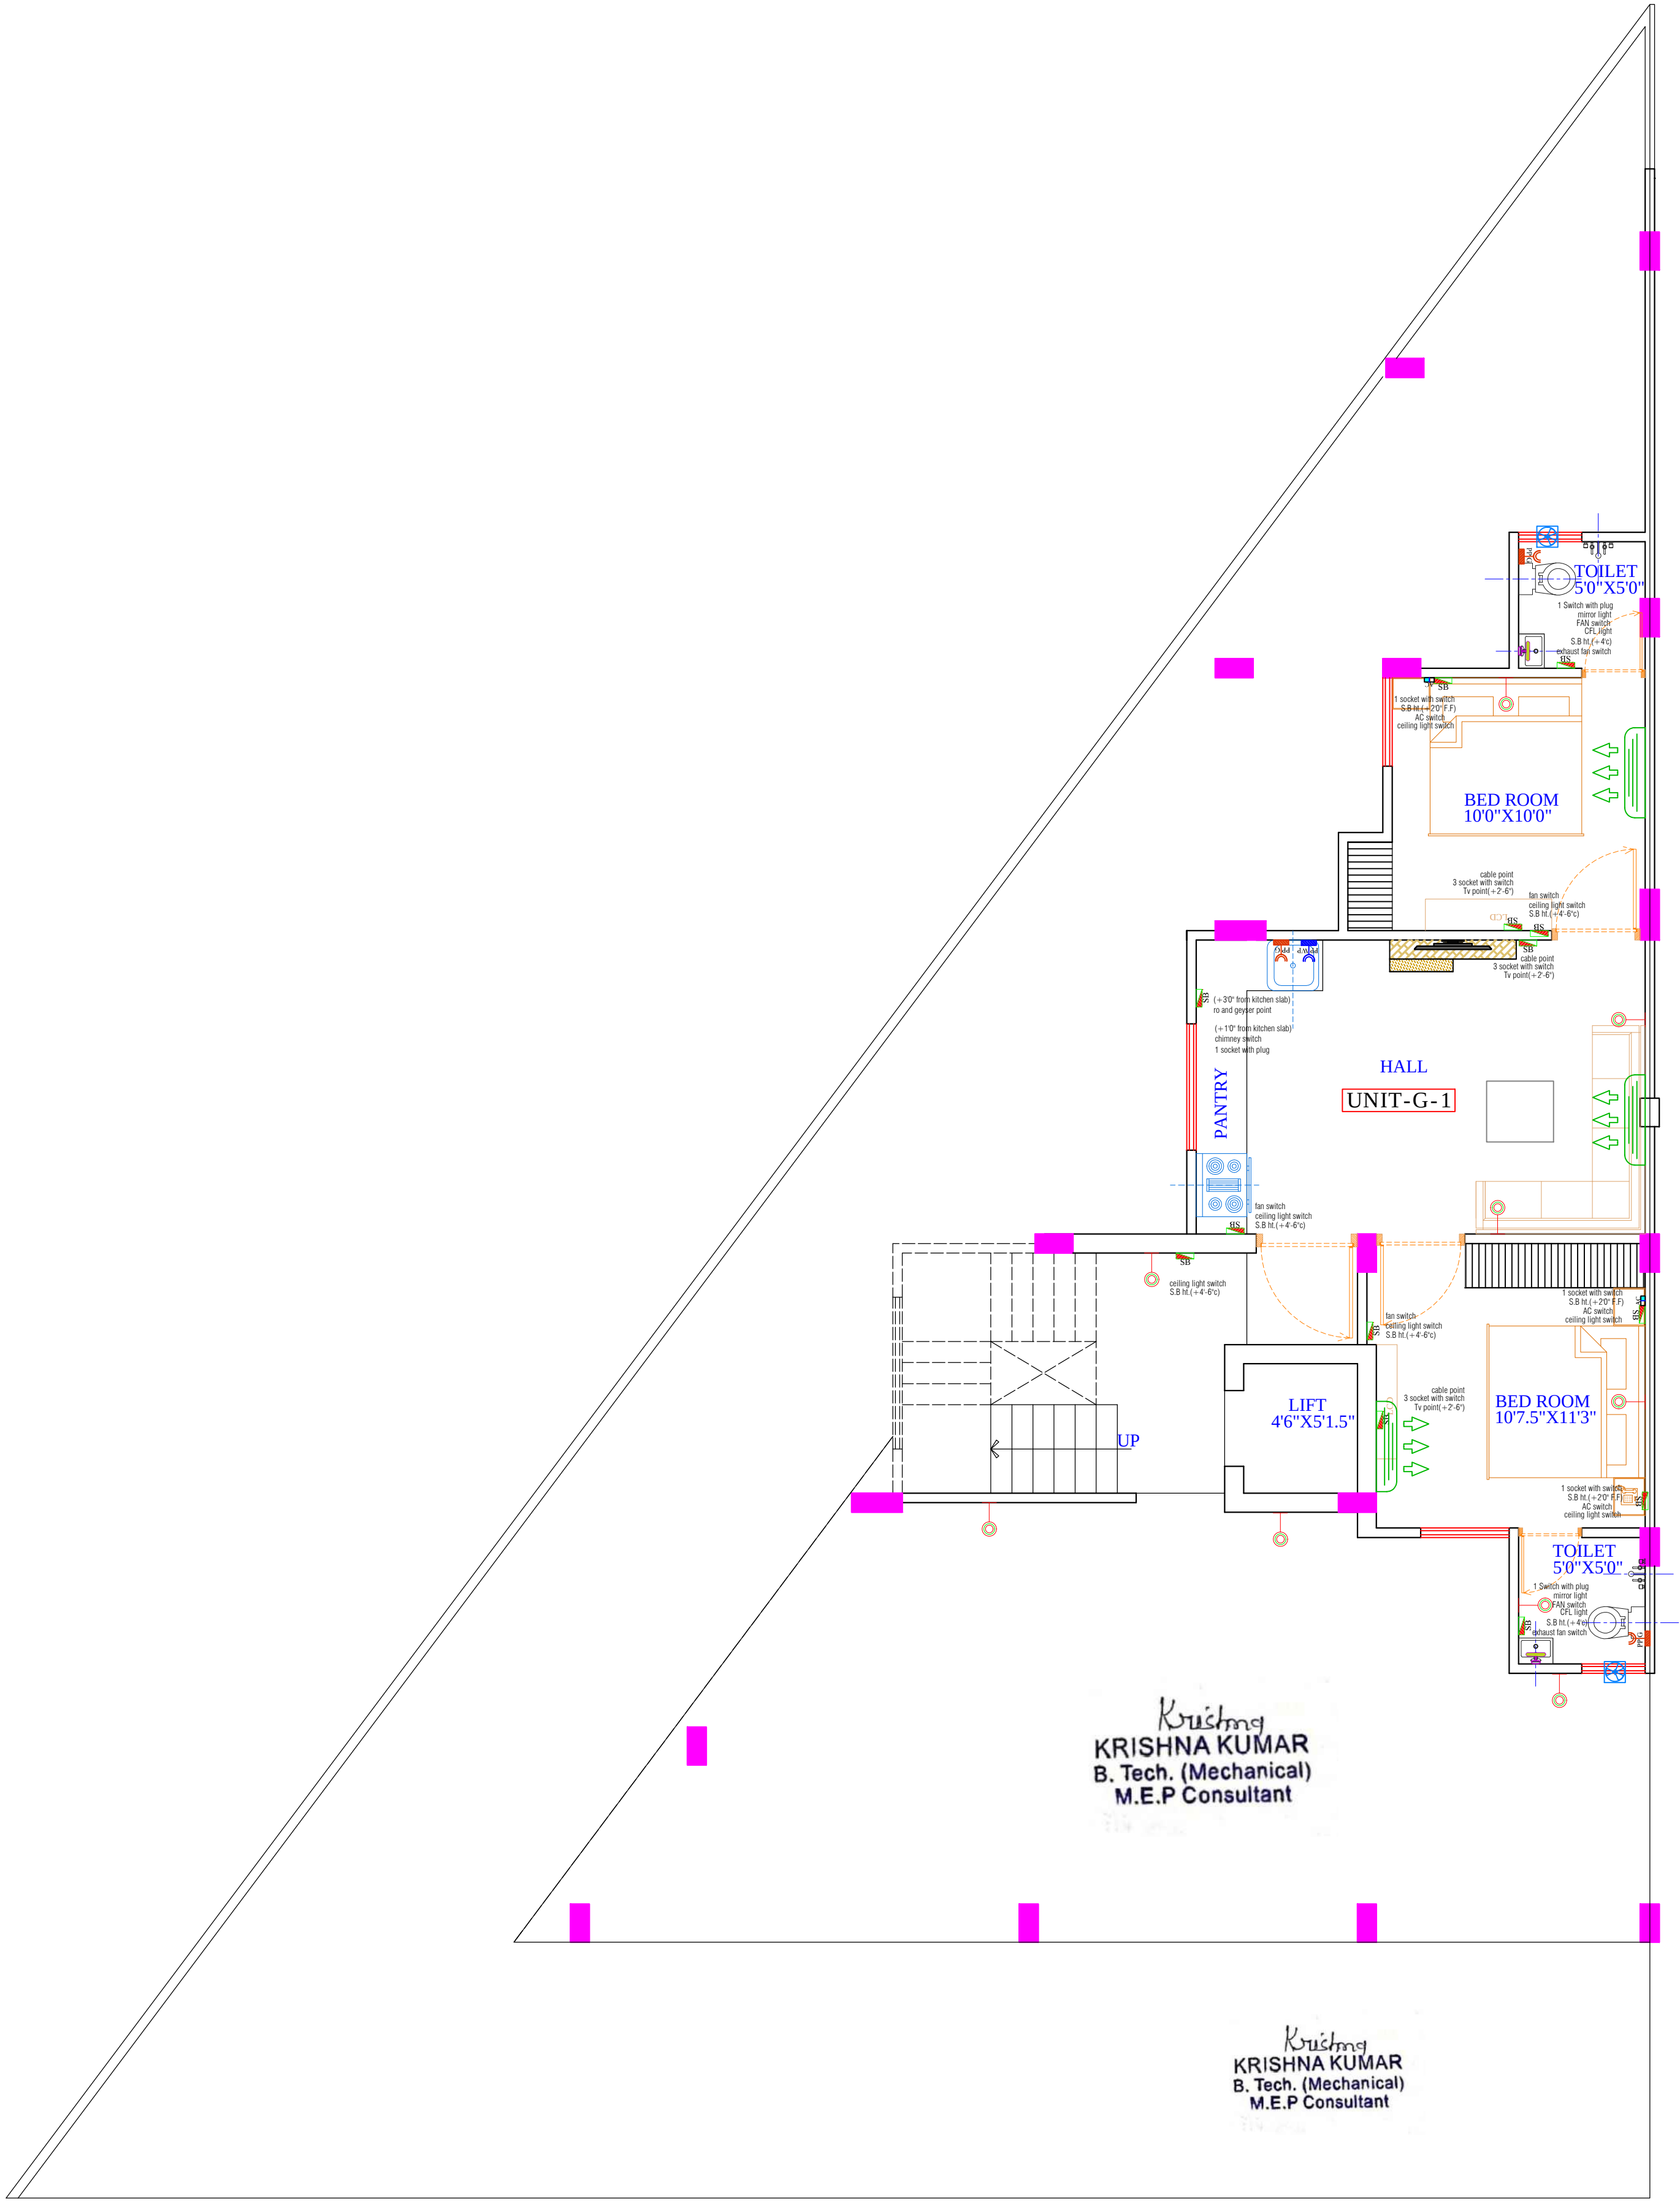

LEGENDS:-				
Mounting Height	No.	I D	Symbol	Description
IN FLOOR				CONTROL WIRING
IN CONDUIT				CONTROL WIRING
IN CONDUIT				AC CONTROL WIRING
IN CONDUIT				GEYSER CONTROL WIRING
IN CONDUIT				BUZZER CONTROL WIRING
Ceiling	FAN/40"			CEILING FAN 40"
Ceiling	FAN/30"			CEILING FAN 30"
+90"	TL			EXHHAUST WALL TUBELIGHT
+90"	BULB			WALL BRACKETS AS DESIGN LIGHT
+90"	GL			WALL BRACKETS AS DESIGN FOR GYSESER LIGHT
	GL			WALL BRACKETS AS DESIGN FOR GATE LIGHT
Ceiling	CFL			CFL CEILING LIGHT
+20"	FL			FOOT LIGHT
+48"	SB			SWITCH BOARD
+70"	ML			1 X 1 X 1 W CFL MIRROR LIGHT
VENTILATION RT.	CR			CEILING RIDGE
VENTILATION RT.	EXP			9" DIA FRESH AIR FAN
+24"	TEL			TELEPHONE POINT
+22"	TV			TV COWAL POINT
+23"	LP TV			6 A PLUG POINT FOR TV
+72"	LP CH			6 A PLUG POINT FOR CHIMNEY
+100"	SAC			SPILT AC
+100"	PP-SAC			25 A POWER POINT FOR SPILT AC
+42"	PP-MIX			15 A POWER POINT FOR MIXER
+78"	PP-G			15 A POWER POINT FOR GEYSER
+54"	PP-F			15 A POWER POINT FOR FRIDGE
+78"	PP-WP			15 A POWER POINT FOR WATER PURIFIER
+68"	PP-WM			15 A POWER POINT FOR WASHING MACHINE
+42"	BP			BELL PUSH SWITCH
	BZ			BELL PUSHSWITCH
+48"	AC			AC STARTER
+60"	NACB DB			NACB DISTRIBUTION BOARD

WARNING
1. This drawing is the sole copyright of Architects VISTAAR and should be used for the purpose expressly issued.

GENERAL NOTES
1. All dimensions are in feet and inches.
2. Do not scale this drawing follow written dimensions only.
3. This drawing should be read in conjunction with other architectural and structural drawings.
4. Any discrepancy in the drawing should be immediately brought to the notice of architect.

PROJECT TITLE

SALASAR RESIDENCY
BUILDING AT PLOT-58,SUMER NAGAR
VISTAR-Q BLOCK,JAIPUR

DRAWING TITLE

STILT FLOOR WALL ELECTRICAL PLAN
SERVICE(SLD/DISTRIBUTION DETAILS AFTER LT PANEL,EARTHING
LAYOUT,EXTERNAL LIGHTING PLAN/LAYOUT,TV & TELEPHONE
RISER DIAGRAM,LIGHTING ARRESTER LOCATION & PIT
LOCATION,COORDINATION DRAWINGS,FIRE DETECTION & ALARM
SYSTEM LAYOUT OF ALL FLOOR)

ARCHITECTS:-

VISTAAR ARCHITECTS & PLANNERS
Architects :- Interior Designers
B-2/12, Chitrakoot scheme,
main Gandhi Path Opp mall of jaipur,Jaipur
PH- 0141-4116461,09001010366

DATE

23-05-2022

REV.

NORTH

SCALE

1:1

DATE


23-05-2022

REV.

NORTH

SCALE

1:1

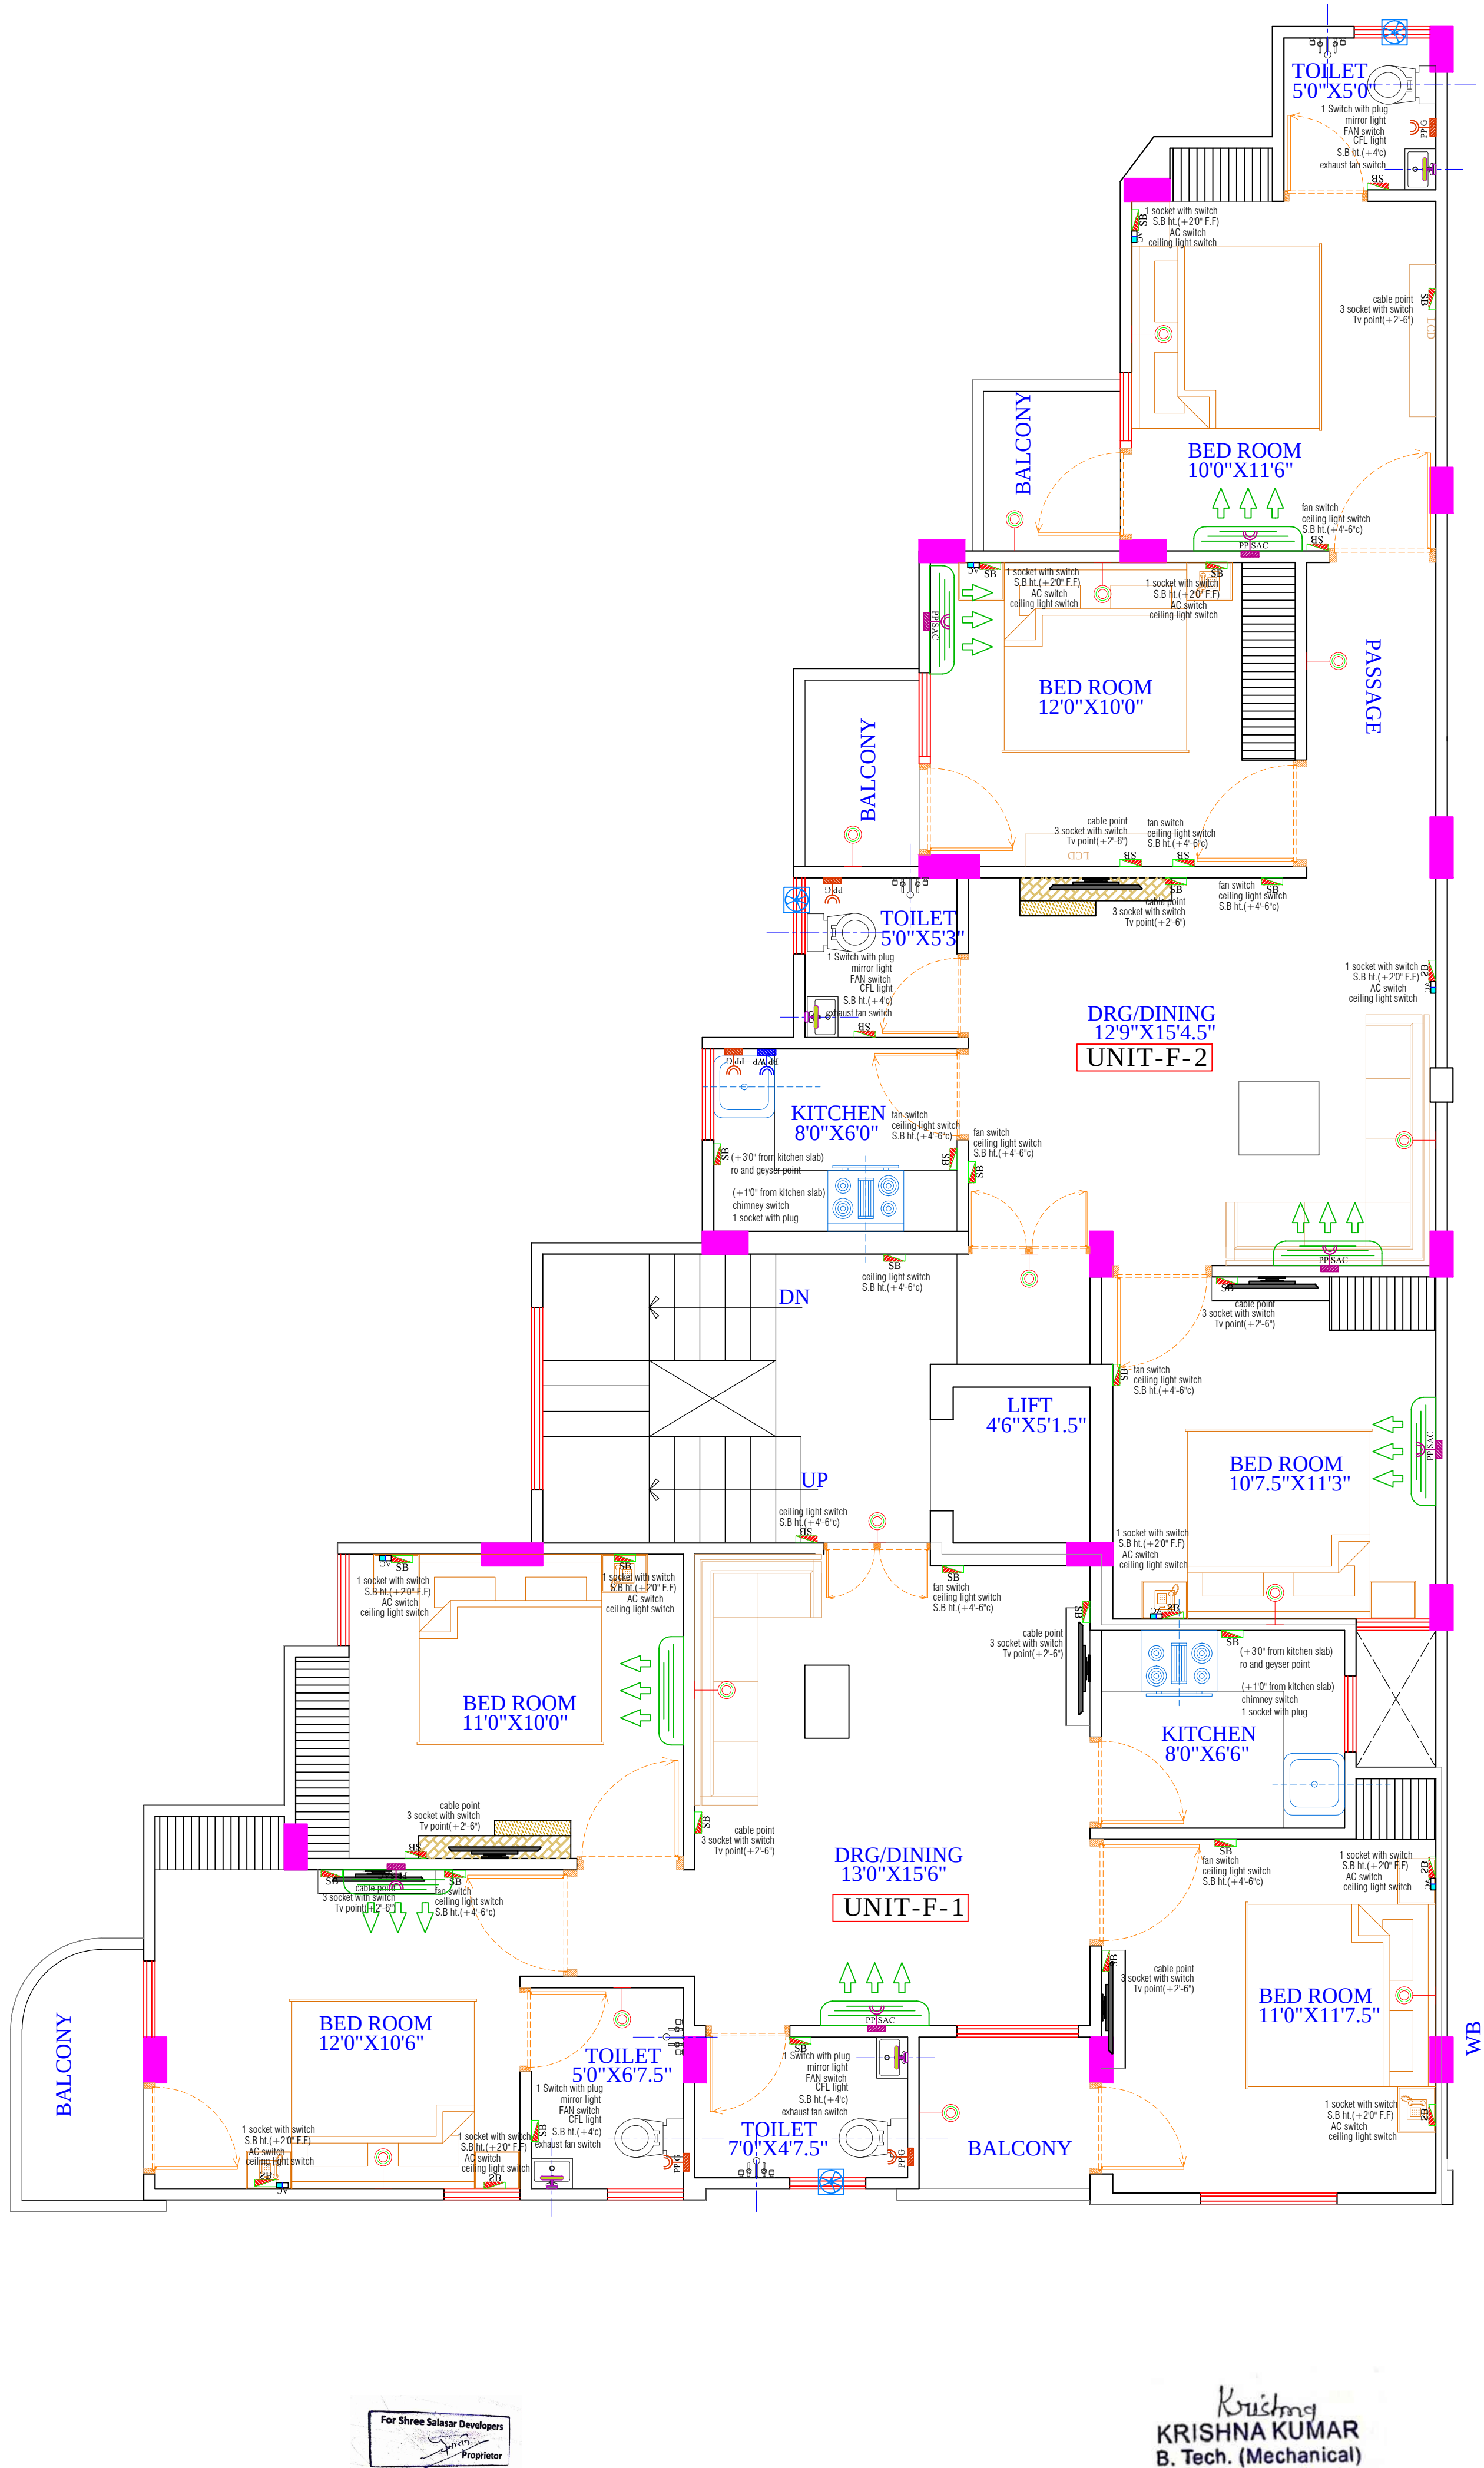

LEGENDS:				
Mounting Height	No.	I D	Symbol	Description
IN FLOOR				CONTROL WIRING
IN CONDUIT				CONTROL WIRING
IN CONDUIT				AC CONTROL WIRING
IN CONDUIT				GYSER CONTROL WIRING
IN CONDUIT				BUZZER CONTROL WIRING
CEILING	FAN/48"			CEILING FAN 48"
CEILING	FAN/30"			CEILING FAN 30"
+90"	TL			1X40W WALL TUBELIGHT
+90"	BULB			WALL BRACKETS AS DESIGN LIGHT
+90"	GL			WALL BRACKETS AS DESIGN FOR GANESH LIGHT
	GL			WALL BRACKETS AS DESIGN FOR GATE LIGHT
CEILING	CFL			CFL CEILING LIGHT
+21"	FL			FOOT LIGHT
+48"	SB			SWITCH BOARD
+78"	ML			1 X 11 W CFL MIRROR LIGHT
VENTILATOR HT.	CR			CEILING ROSE
VENTILATOR HT.	EXF			9" DIA FRESH AIR FAN
+24"	TEL			TELEPHONE POINT
+27"	TV			TV COAXIAL POINT.
+27"	LP TV			6 A PLUG POINT FOR TV
+72"	LP-CH			6 A PLUG POINT FOR CHIMNEY
+102"	SAC			SPLIT AC
+102"	PP- SAC			25 A POWER POINT FOR SPLIT AC
+42"	PP-MIX			15 A POWER POINT FOR MIXER
+78"	PP-G			15 A POWER POINT FOR GEYSER
+54"	PP-F			15 A POWER POINT FOR FRIDGE
+78"	PP-WP			15 A POWER POINT FOR WATER PURIFIER
+48"	PP-WM			15 A POWER POINT FOR WASHING MACHINE
+42"	BP			BELL PUSH SWITCH
+90"	BZ			BUZZER POINT
+48"	AC			AC STARTER
+60"	MCB DB			MCB DISTRIBUTION BOARD

WARNING
1. This drawing is the sole copyright of Architects **VISTAAR** and should be used for the purpose expressly issued.

GENERAL NOTES
1. All dimensions are in feet and inches.
2. Do not scale this drawing follow written dimensions only.
3. This drawing should be read in conjunction with other architectural and structural drawings.
4. Any discrepancy in the drawing should be immediately brought to the notice of architect.


PROJECT TITLE
**SALASAR RESIDENCY
BUILDING AT PLOT-58,SUMER NAGAR
VISTAR-Q BLOCK,JAIPUR**

DRAWING TITLE
GROUND TO 3TH FLOOR WALL ELECTRICAL PLAN

SERVICE(SLD/DISTRIBUTION DETAILS AFTER LT PANEL,EARTHING
LAYOUT,EXTERNAL LIGHTING PLAN/LAYOUT,TV & TELEPHONE
RISER DIAGRAM,LIGHTING ARRESTER LOCATION & PIT
LOCATION,COORDINATION DRAWINGS,FIRE DETECTION & ALARM
SYSTEM LAYOUT OF ALL FLOOR)

ARCHITECTS :
**VISTAAR ARCHITECTS &
PLANNERS**
Architects :: Interior Designers
B-2/12, Chitrkoot scheme,
main Gandhi Path,Opp mall of jaipur,Jaipur
PH.- 0141-4116461,09001010366

PATH.	DATE	REV.	NORTH
DRN.	23-05-2022		
MANOJ KUMAWAT			
SCALE	JOB NO.		
N.T.S			

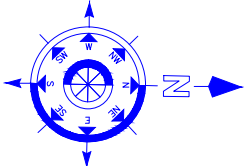



WARNING
1. This drawing is the sole copyright of Architects VISTAAR and should be used for the purpose expressly issued.

GENERAL NOTES
1. All dimensions are in feet and inches.
2. Do not scale this drawing follow written dimensions only.
3. This drawing should be read in conjunction with other architectural and structural drawings.
4. Any discrepancy in the drawing should be immediately brought to the notice of architect.

PROJECT TITLE

SALASAR RESIDENCY
BUILDING AT
PLOT-58,SUMER NAGAR
VISTAR-Q BLOCK,JAIPUR


DRAWING TITLE

TELEPHONE
SINGLE LINE DIAGRAM

ARCHITECTS :

VISTAAR ARCHITECTS &
PLANNERS
Architects :: Interior Designers
B-2/12, Chitrkoot scheme,
main Gandhi Path,Opp mall of jaipur,Jaipur
PH. - 0141-4116461,09001010366

PRJ.	DATE	REV.	NORTH
MANU KUMAR	23-05-2022		
SCALE	JOB NO.		
NTS			

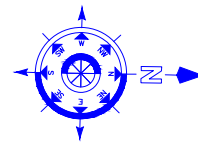

Krishna
KRISHNA KUMAR
B. Tech. (Mechanical)
M.E.P Consultant