


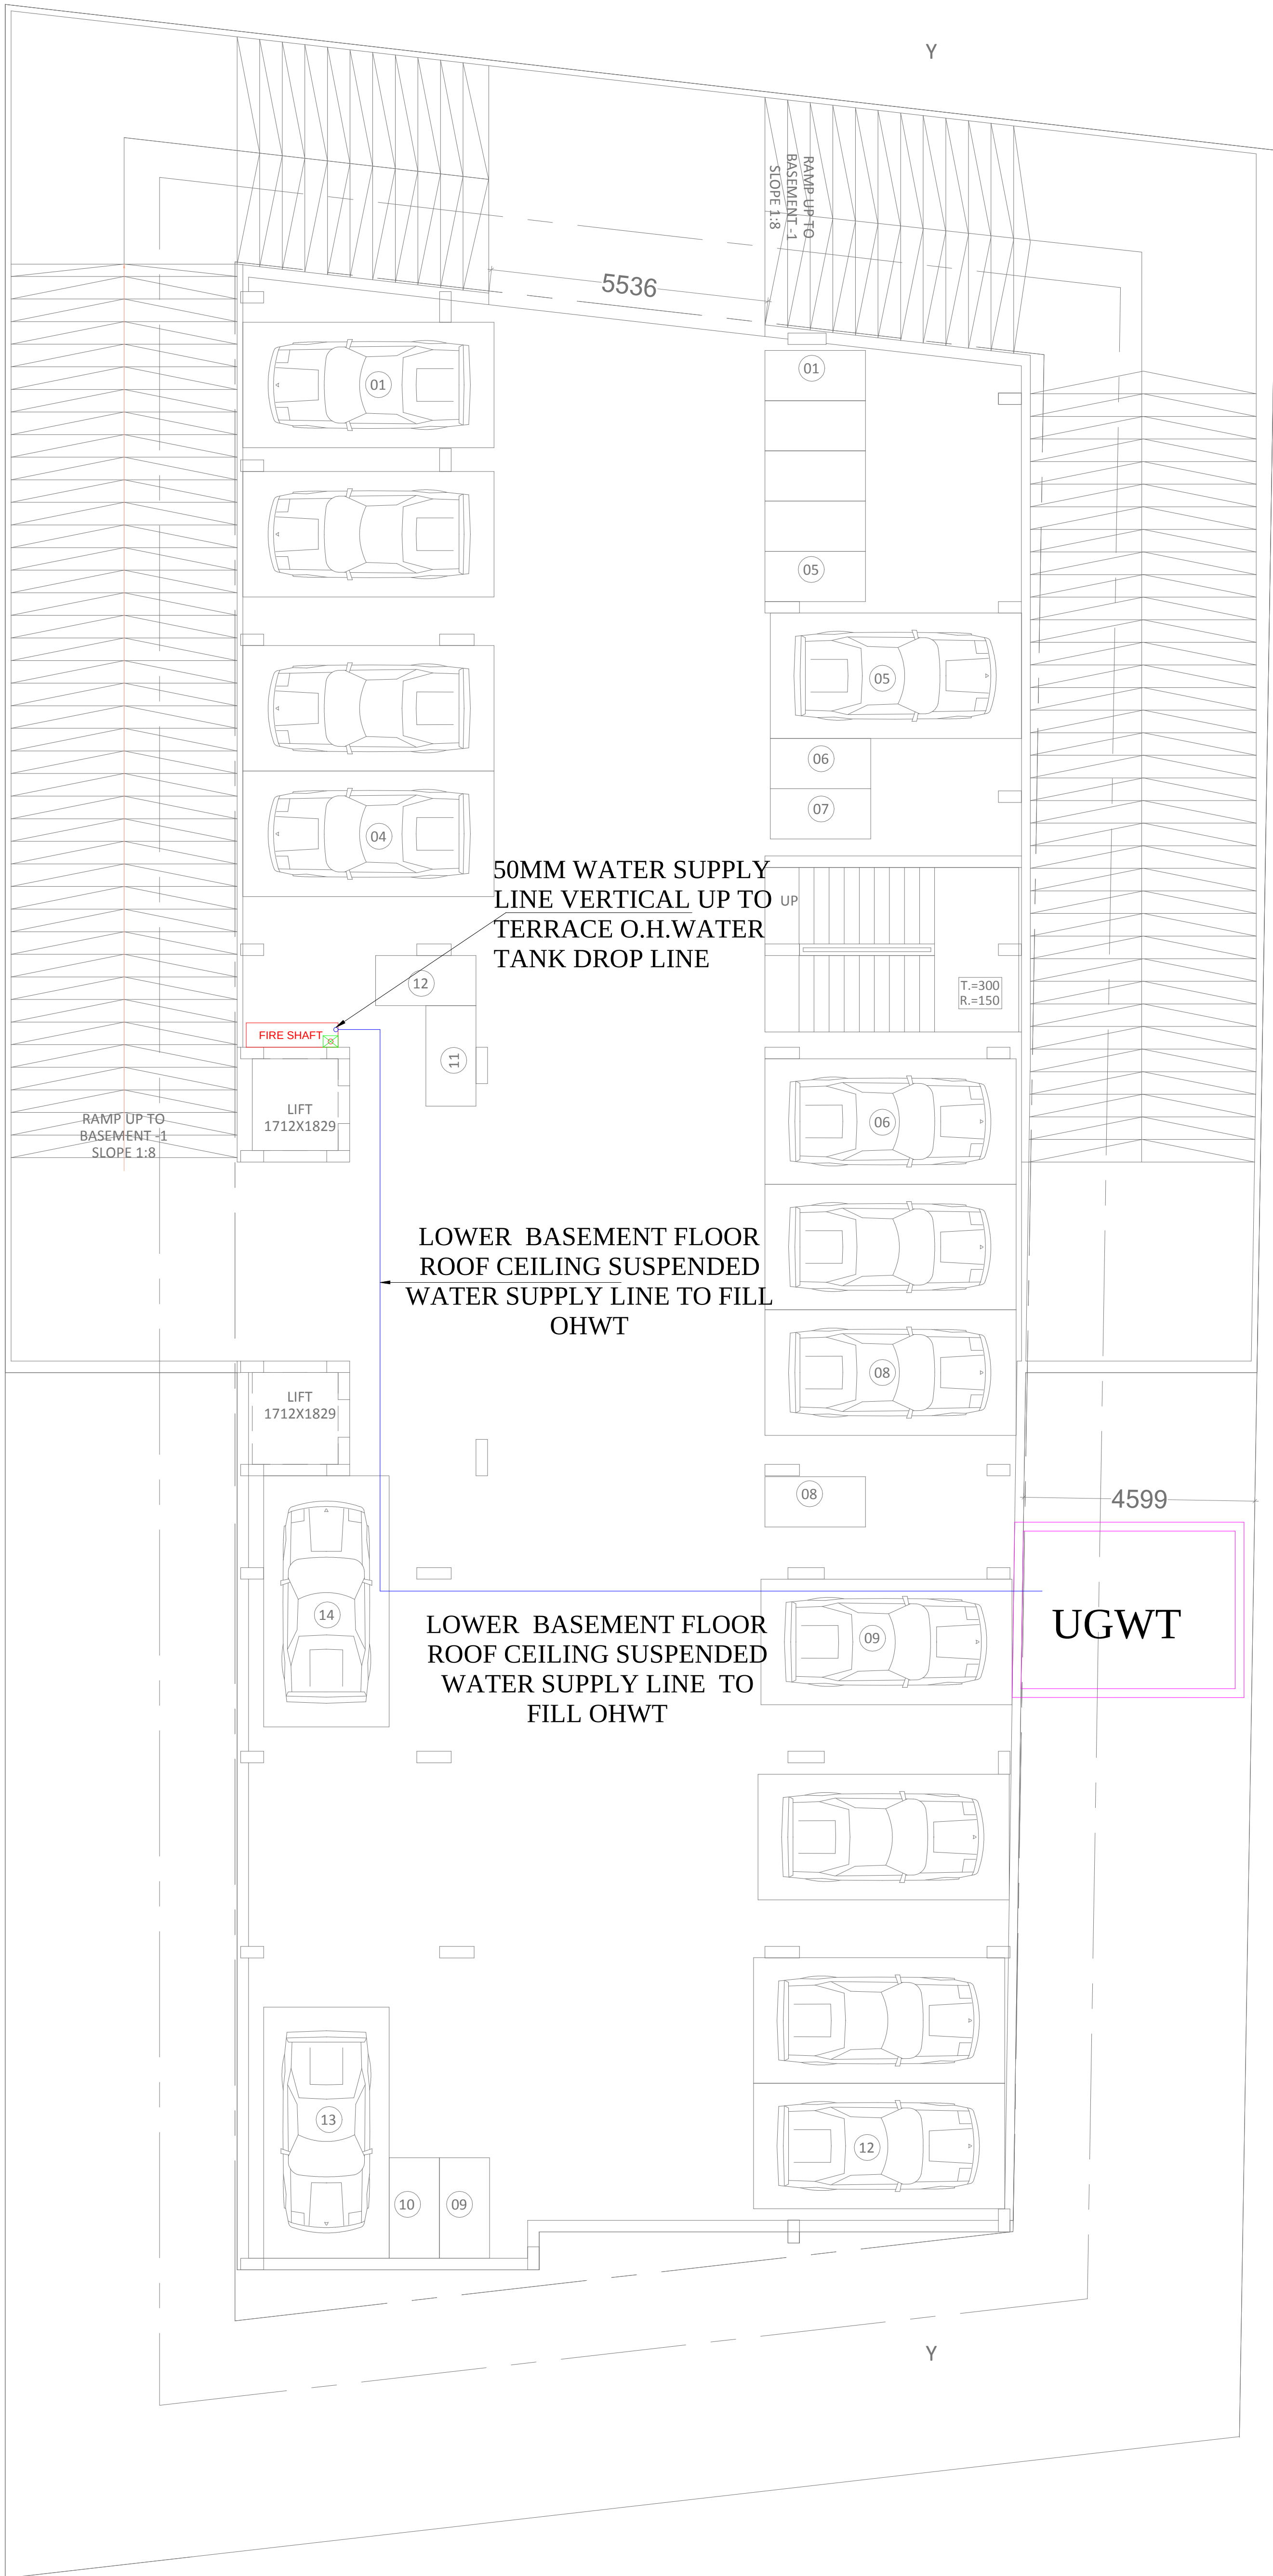

LOWER BASEMENT FLOOR PLAN

Vipul
VIPUL AGARWAL
M.E.P. CONSULTANT
B.E. ELECTRICAL

SERVICES CONSULTANT:
ASHI ASSOCIATES
F 9 / 440 , Keshav Marg Chitrakut Scheme,Jaipur
PH:91-0-93146-10438 ,0141-2440946 Mail:vipul8599@yahoo.com

ARCHITECTS :

GENESIS DESIGN CONSORTIUM,
49, HANUMAN VATIKA, PHASE-I, OPP.
COUNTRY CLUB,
HIRAPURA CROSSING, AJMER ROAD,
JAIPUR- 302024.,Tel. +91 141 2176301
PROJECT NAME :- **RAMAA PRIME-1ST**
PROJECT ADDRESS :-
PLOT NO.E-68(NORTH & SOUTH PART)
HANUMAN NAGAR,VAISHALI NAGAR ,JAIPUR
DEVELOPERS NAME :-
Krishnaa Balram
Residency Pvt Ltd

DRAWN BY: VIJESH/PAWAN
CHECKED BY: SANJAY
APPD. BY: VIPUL AGARWAL
PROJECT NO.:
SHEET TITLE:

UGWT TO OHT FILLING
LINE ROUTE PLAN

DATE	19-07-2024	NORTH:
DRAWING NO.	PL-01	
SHEET NO.	00	STAMP:
REVISION	00	
SCALE	1:50 U.N.O.	

