


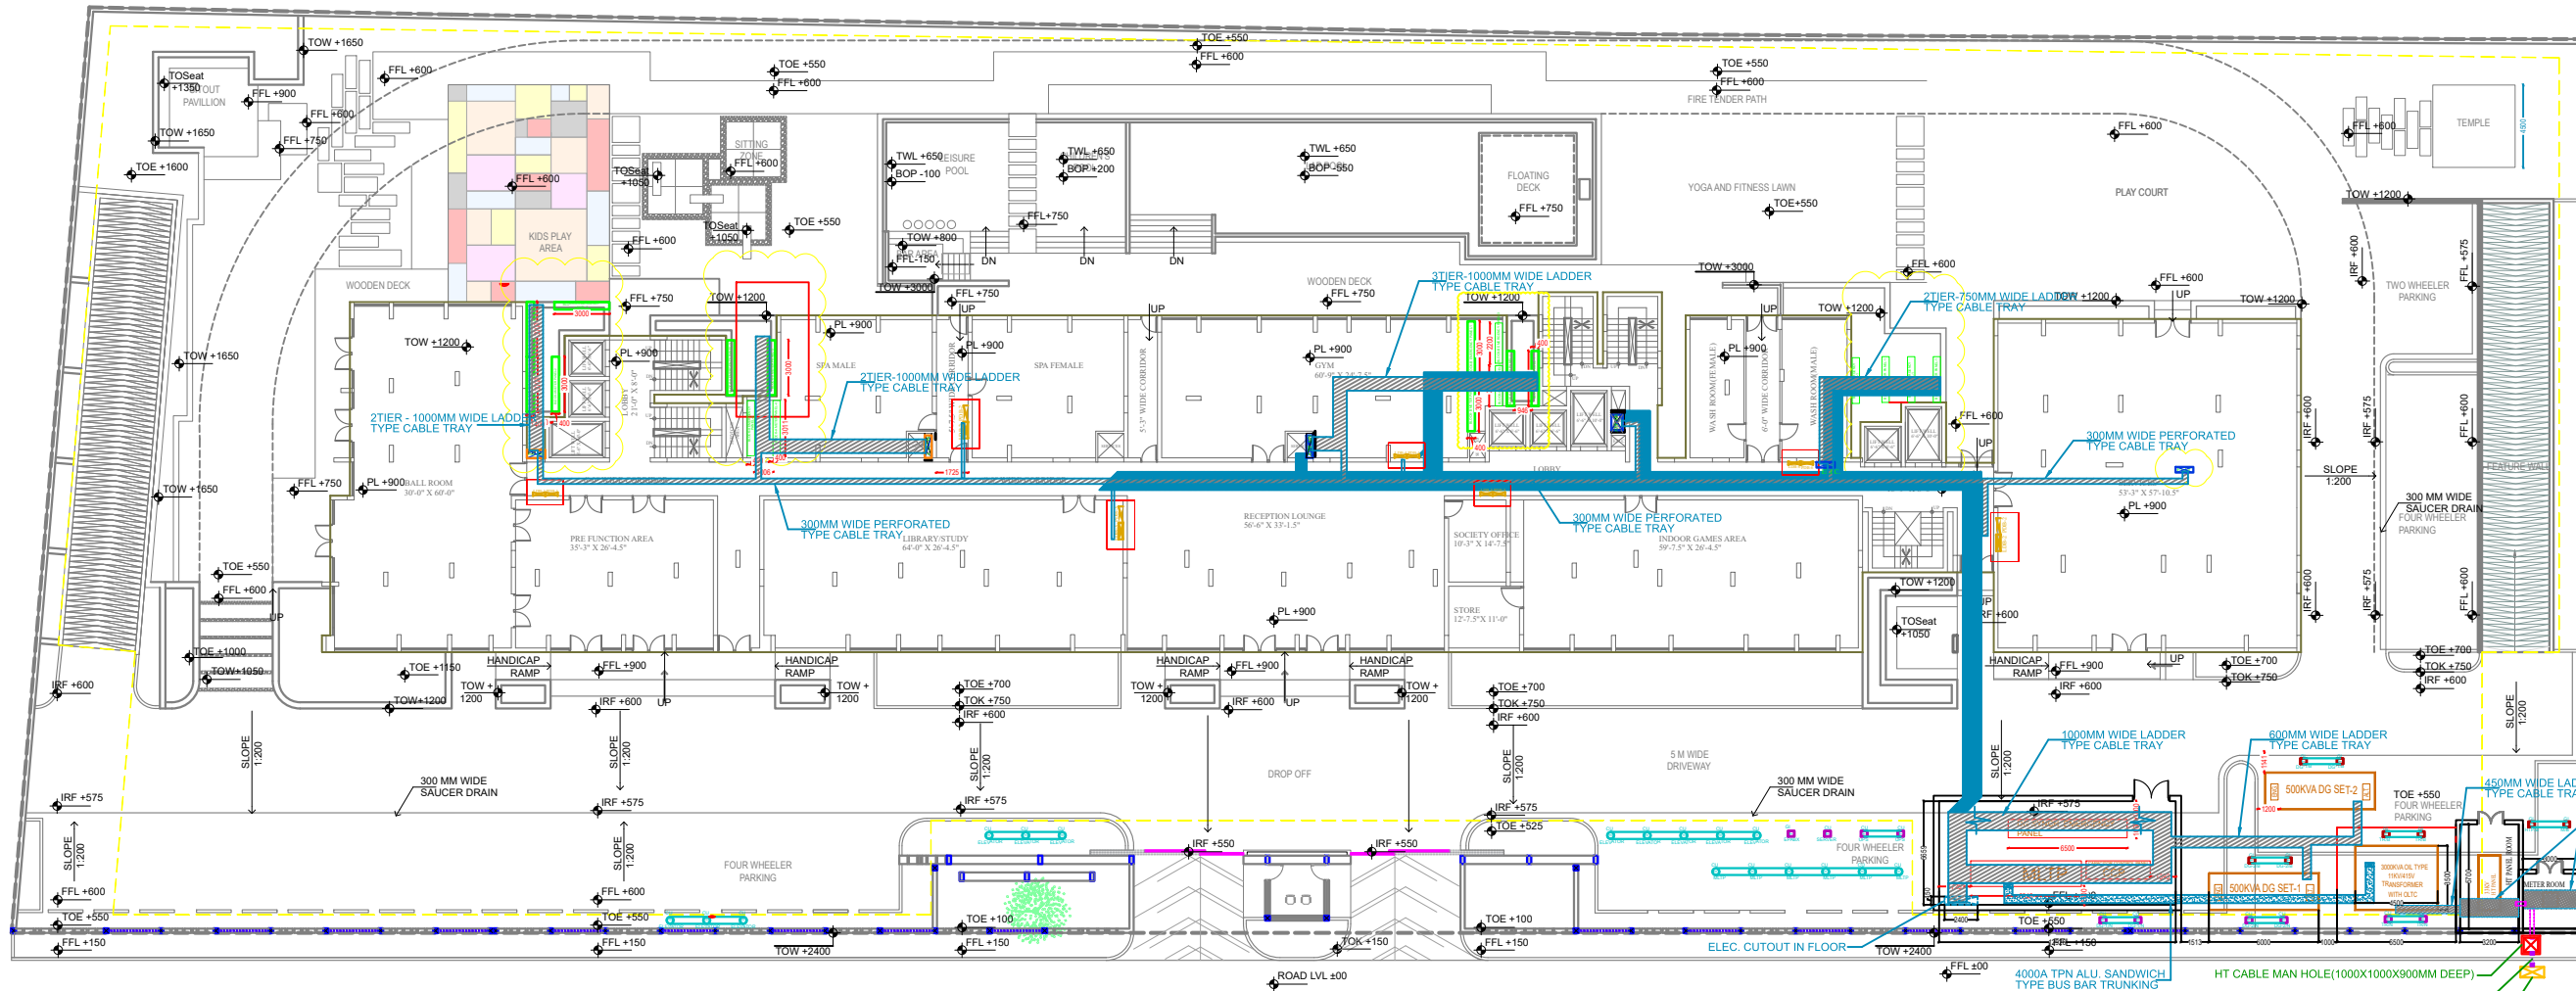

NOTE: AS PER NBC-2016, HT METER, HT PANEL, TRANSFORMER & DG SETS ARE NOT RECOMMENDED TO PLACE ABOVE THE STP / ANY WATER STORAGE. 2.0 TRANSFORMER & DG SHOULD BE PLACED ON MOTHER EARTH. 3.0 EARTHING MUST BE REQUIRED MOTHER EARTH. 4.0 ARCHITECT CAN SUGGEST ALTERNATIVE LOCATION OF ANY ELECTRICAL EQUIPMENTS AS PER SITE CONDITION.





LEGEND & INVENTORY				
S. NO.	SYMBOL	DESCRIPTION	HT INMM	QTY.
1.		600X600X15MM COPPER PLATE EARTH STATION		
2.		600X600X30MM GI PLATE EARTH STATION		
3.		COPPER COATED MAINTENANCE FREE EARTH STATION		
4.		COPPER COATED MAINTENANCE FREE EARTH STATION		
5.		COPPER COATED MAINTENANCE FREE EARTH STATION		
6.		COPPER COATED MAINTENANCE FREE EARTH STATION		
7.		HT CABLE TRENCH		
8.		CABLE TRAY		
9.		BUS BAR TRUNKING		
10.		150MM DIA SLEEVE		
11.		HT CABLE		
12.		25MM DIA HDPE PIPE FOR LT CABLE		
13.		150MM DIA HDPE PIPE FOR COMMUNICATION CABLE		
14.		750X750X750MM DEEP COMMUNICATION CABLE MAN HOLE		
15.		1000X1000X1000MM DEEP LT CABLE MAN HOLE		
16.		1000X1000X1000MM DEEP HT CABLE MAN HOLE		

NO.	REVISION	DATE
PROJECT TITLE:		
PROPOSED GROUP HOUSING AT PLOT NO. 4 SCHEME : KUBER COMPLEX AT VILLAGE BEED KHATIPURA, IN KHASRA NO.193&193/248 ON GANDHI PATH, TEHSIL-JAIPUR, DIST. - JAIPUR		
ARCHITECTS:		
IDEAS 124, HIMMAT NAGAR, TONK ROAD, JAIPUR PHONE : 0141-2706227, 2712377 email: ideasjaipur@gmail.com, web: www.ideasjaipur.com		
SERVICES CONSULTANT:		
INFINITY DESIGN SERVICES PLOT NO. 24/15, SECOND FLOOR SHARDA PATEL MANABARWA JAIPUR, RAJASTHAN 302009 EMAIL: vikas@infinitydesigns.in		
TITLE: 33KV SUB-STATION, DG SETS, CABLE TRAY & EARTHING LAYOUT OF GROUND FLOOR PLAN		
SCALE	DATE	DRAWN
N.T.S.	23.09.22	NASIR
DRAWING NO.	EL-02	APP.

CU COATED MF EARTH STATION FOR
EXTERNAL LIGHTING

CU COATED MF EARTH STATION FOR
EXTERNAL LIGHTING

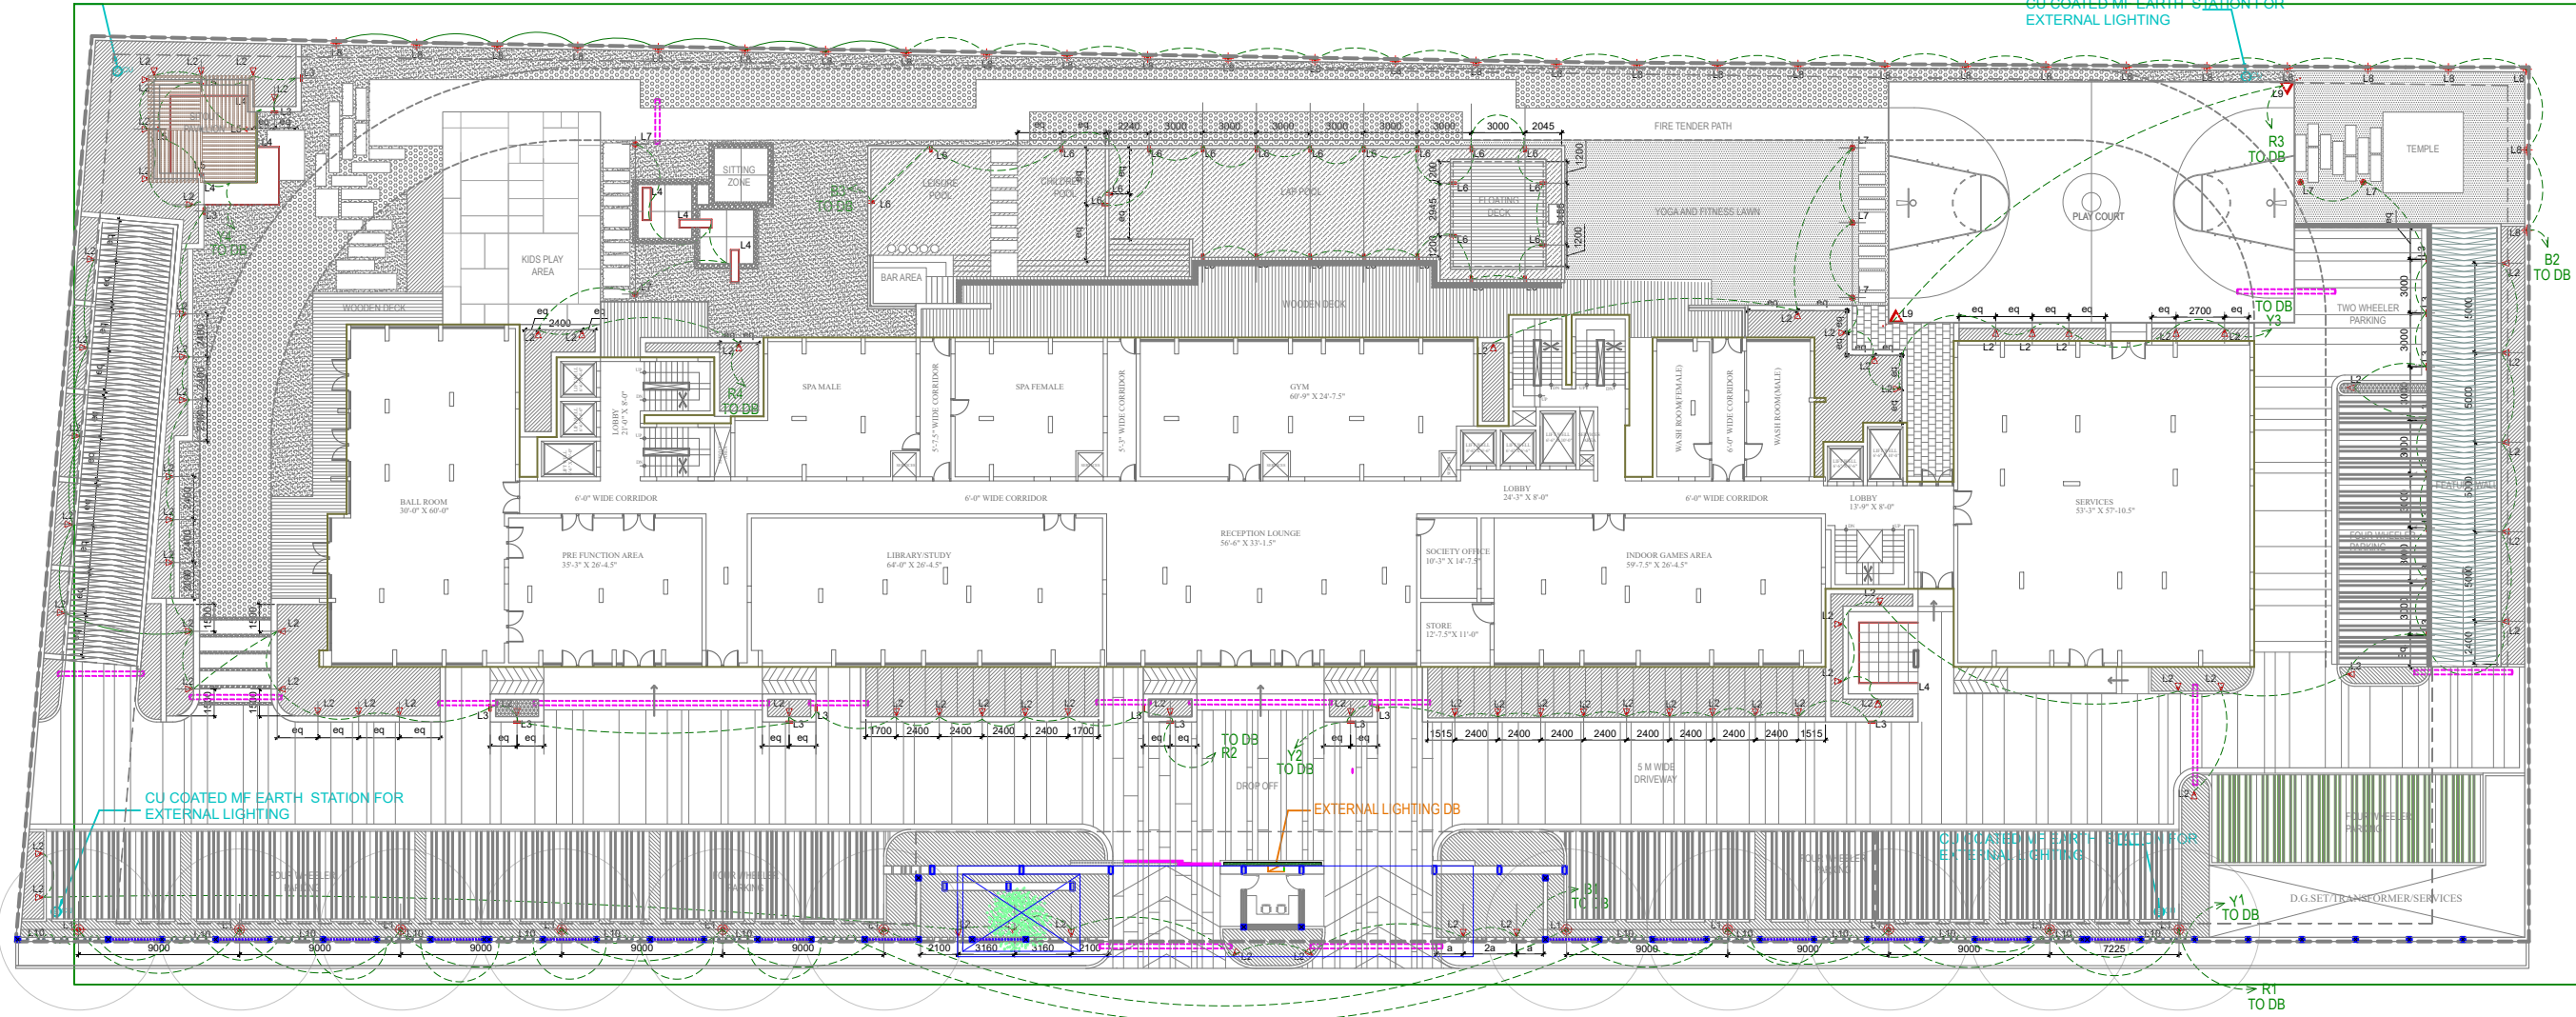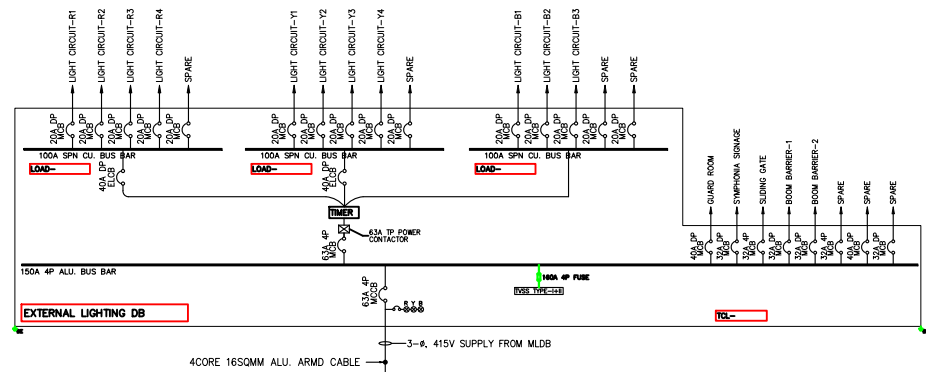

NOTE:-

- R1,Y1,B1... FOR LIGHT CIRCUIT NO.
- LIGHTING LOOPING/ 3C 6SQMM CU. ARMD CABLE

LIGHTING LEGEND

SYMBOL	DESCRIPTION	LOCATION	HEIGHT	LAMP WATT	COLOR	QTY.
R1	POST TOP LIGHT	PARKING	4.5 M	50 W	WARM WHITE	11
L2	SPKED UPLIGHTER	PLANTERS	-	7W	WARM WHITE	81
L3	NICHE LIGHT	PLANTERS & RAMP WALL	-	6 W	WARM WHITE	20
L4	LED STRIP LIGHT	SEATS AND PEDESTALS	-	3 W	WARM WHITE	4788 W
L5	UP AND DOWN LIGHT	PERGOLA	-	40 W	WARM WHITE	4
L6	UNDERWATER LIGHT	WATER BODY	-	4 x 2W LED	WARM WHITE	24
L7	BOLLARD LIGHT	WALKWAY	0.3M	9 W	WARM WHITE	67
L8	POST TOP LIGHT	PLANTERS	4.5 M	30 W	WARM WHITE	30
L9	FLOOD LIGHT	PLAY COURT	6M	2 x 60W LED	WARM WHITE	2
L10	UP LIGHT	FRONT BOUNDARY WALL	-	1 W	WARM WHITE	88

LEGEND & INVENTORY

SYMBOL	DESCRIPTION	HT IN MM	QTY.
CU	CU PLATE EARTH STATION FOR EXTERNAL LIGHTING		
EL	EXTERNAL LIGHTING DISTRIBUTION BOARD	1200	
150MM	150MM DIA HUME PIPE FOR ROAD CROSSING OF EXTERNAL LIGHTING LT CABLES		

ARCHITECT



124, HIMMAT NAGAR, TONK ROAD, JAIPUR
PHONE - 0141-2706227, 2712377
email: ideasjaipur@gmail.com, web: www.ideasjaipur.com

CONSULTANTS

LANDSCAPE ARCHITECT:-

DESIGN ACCORD ? CONSULTANTS ?
301 & 302, U.S. Complex, 120 Mathura Road, ?
Opp Apollo Hospital, New Delhi-110076
Ph: 011-26397203, Web: www.designaccord.net

STRUCTURE CONSULTANT :-



Vijaytech Consultants Pvt. Ltd.
CONSULTING ENGINEERS
4-71, GAUTAM MARG, SHYAM NAGAR, JAIPUR-30 INDIA
Phone : 91-141 2294432, 3257592, Fax : 91-141-4023189
E-mail : vijaytech.pr@gmail.com

MEP CONSULTANT :-

INFINITY DESIGN SERVICES
PLOT NO. 24/153, SECOND FLOOR
SWARN PATH, MANSAROVAR
JAIPUR, RAJASTHAN 302020
EMAIL: vikas@infinitydesignmep.in


NOTES :-

1. THIS DRAWING IS PROPERTY OF INFINITY DESIGN SERVICES, JAIPUR
2. UNAUTHORIZED USE OF THIS DRAWING WITHOUT PERMISSION IS
STRICTLY PROHIBITED
3. ALL DIMENSIONS ARE IN FEET & INCHES, UNLESS NOTED OTHERWISE
4. ANY DISCREPANCY ARISING SHOULD BE INFORMED TO THE ARCHITECT
IMMEDIATELY

REVISIONS:-

S.No.	DATE	REMARKS

KEY PLAN :-

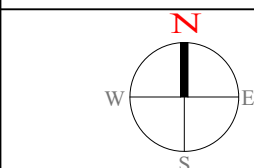

PROJECT:-

'SYMPHONIA'
AT GANDHI PATH, JAIPUR

CLIENT:- PURPLE GROUP

DRAWING TITLE OUTER LANDSCAPE LIGHTING PLAN

DATE:- 26-02-2023 DRG.NO.

CHECKED BY:- NASIR EL-09

DEALT BY:- VIKAS

DRAWN BY:- JITENDRA

