

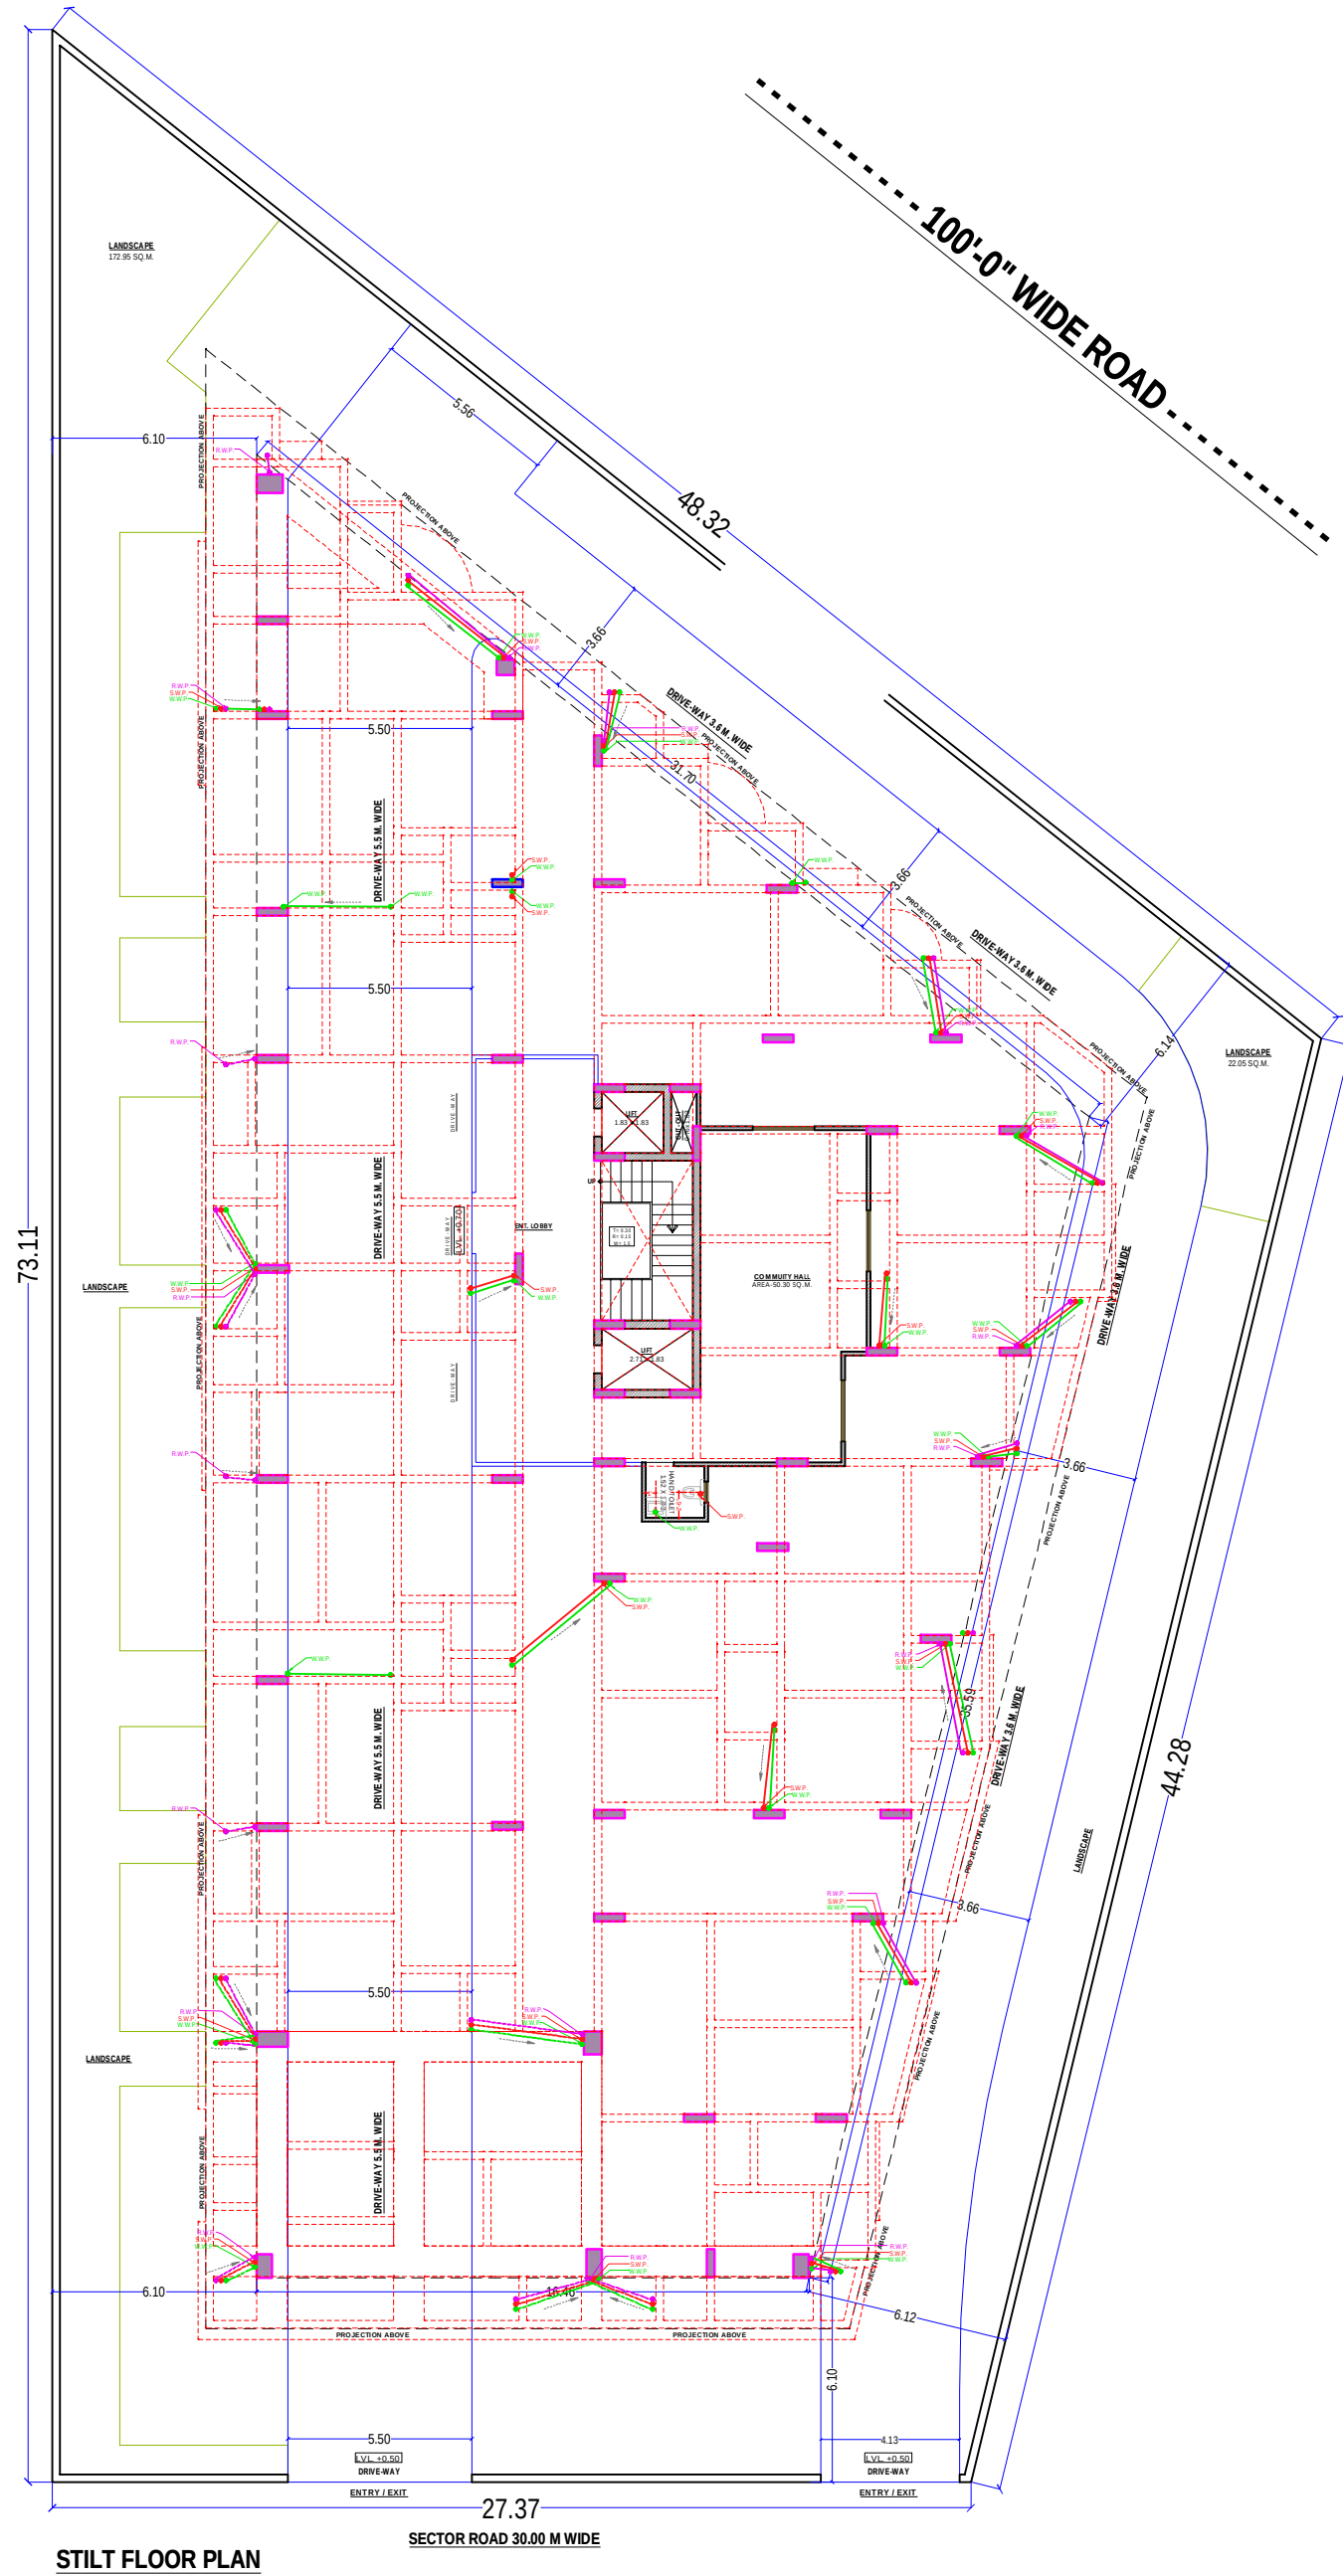


LEGENDS:-	
	WASTE WATER MANHOLE 450X450MM DEPTH- 300MM
	SEWERAGE MANHOLE 900 mm Dia
	MANHOLE 900X800MM
	SEWERAGE MANHOLE 600X600MM
SYMBOL	DESCRIPTION
	110 mm Soil Waste Water Pipe
	110 mm Waste Water Pipe
	110 mm Rain Water Pipe
	FOLLOW DIRECTION

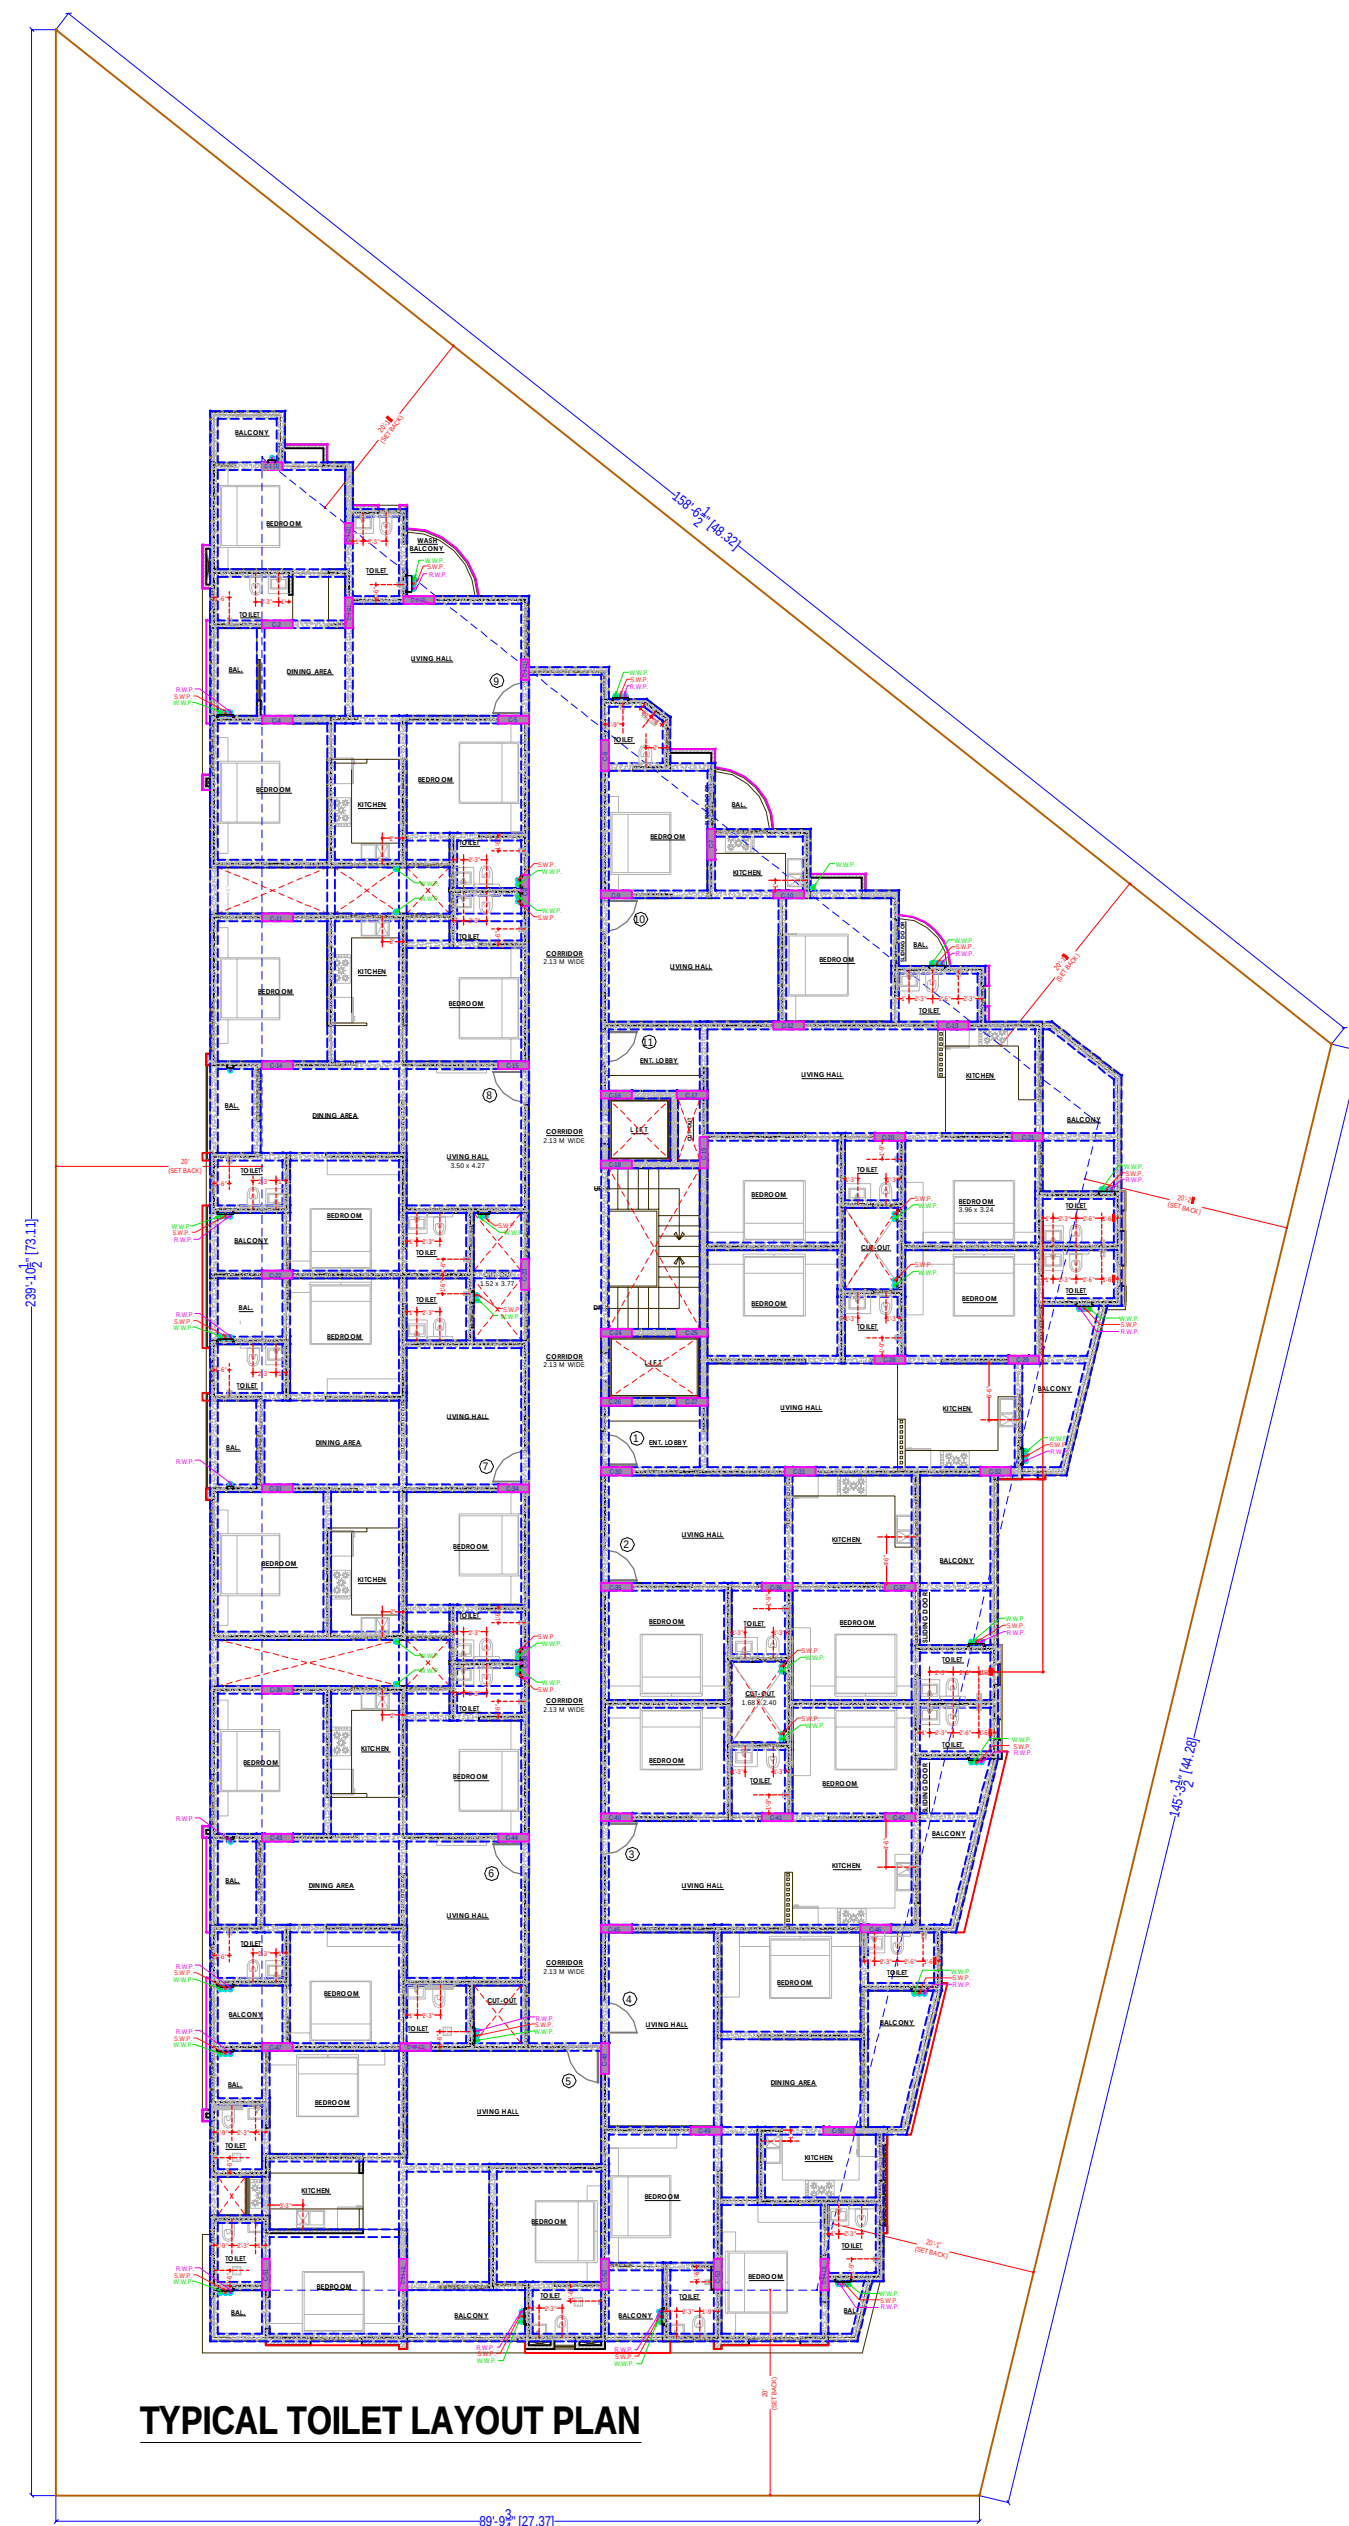

 
FLOOR SANITARY PLAN


PROJECT:-
THE PEAK
PROPOSED RESIDENTIAL BUILDING AT
KHASRA NO. - 29/1, AT VILLAGE - GRIDHARIPURA, JAIPUR.

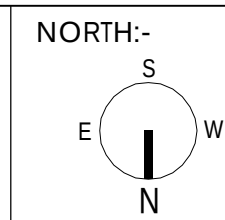

ARCHITECT:-

B-6, GANESH KRIPA, MOTI MARG,
BAPU NAGAR JAIPUR - 302015.
TEL. 9314510603, 0141-4062903

SERVICES CONSULTANT:

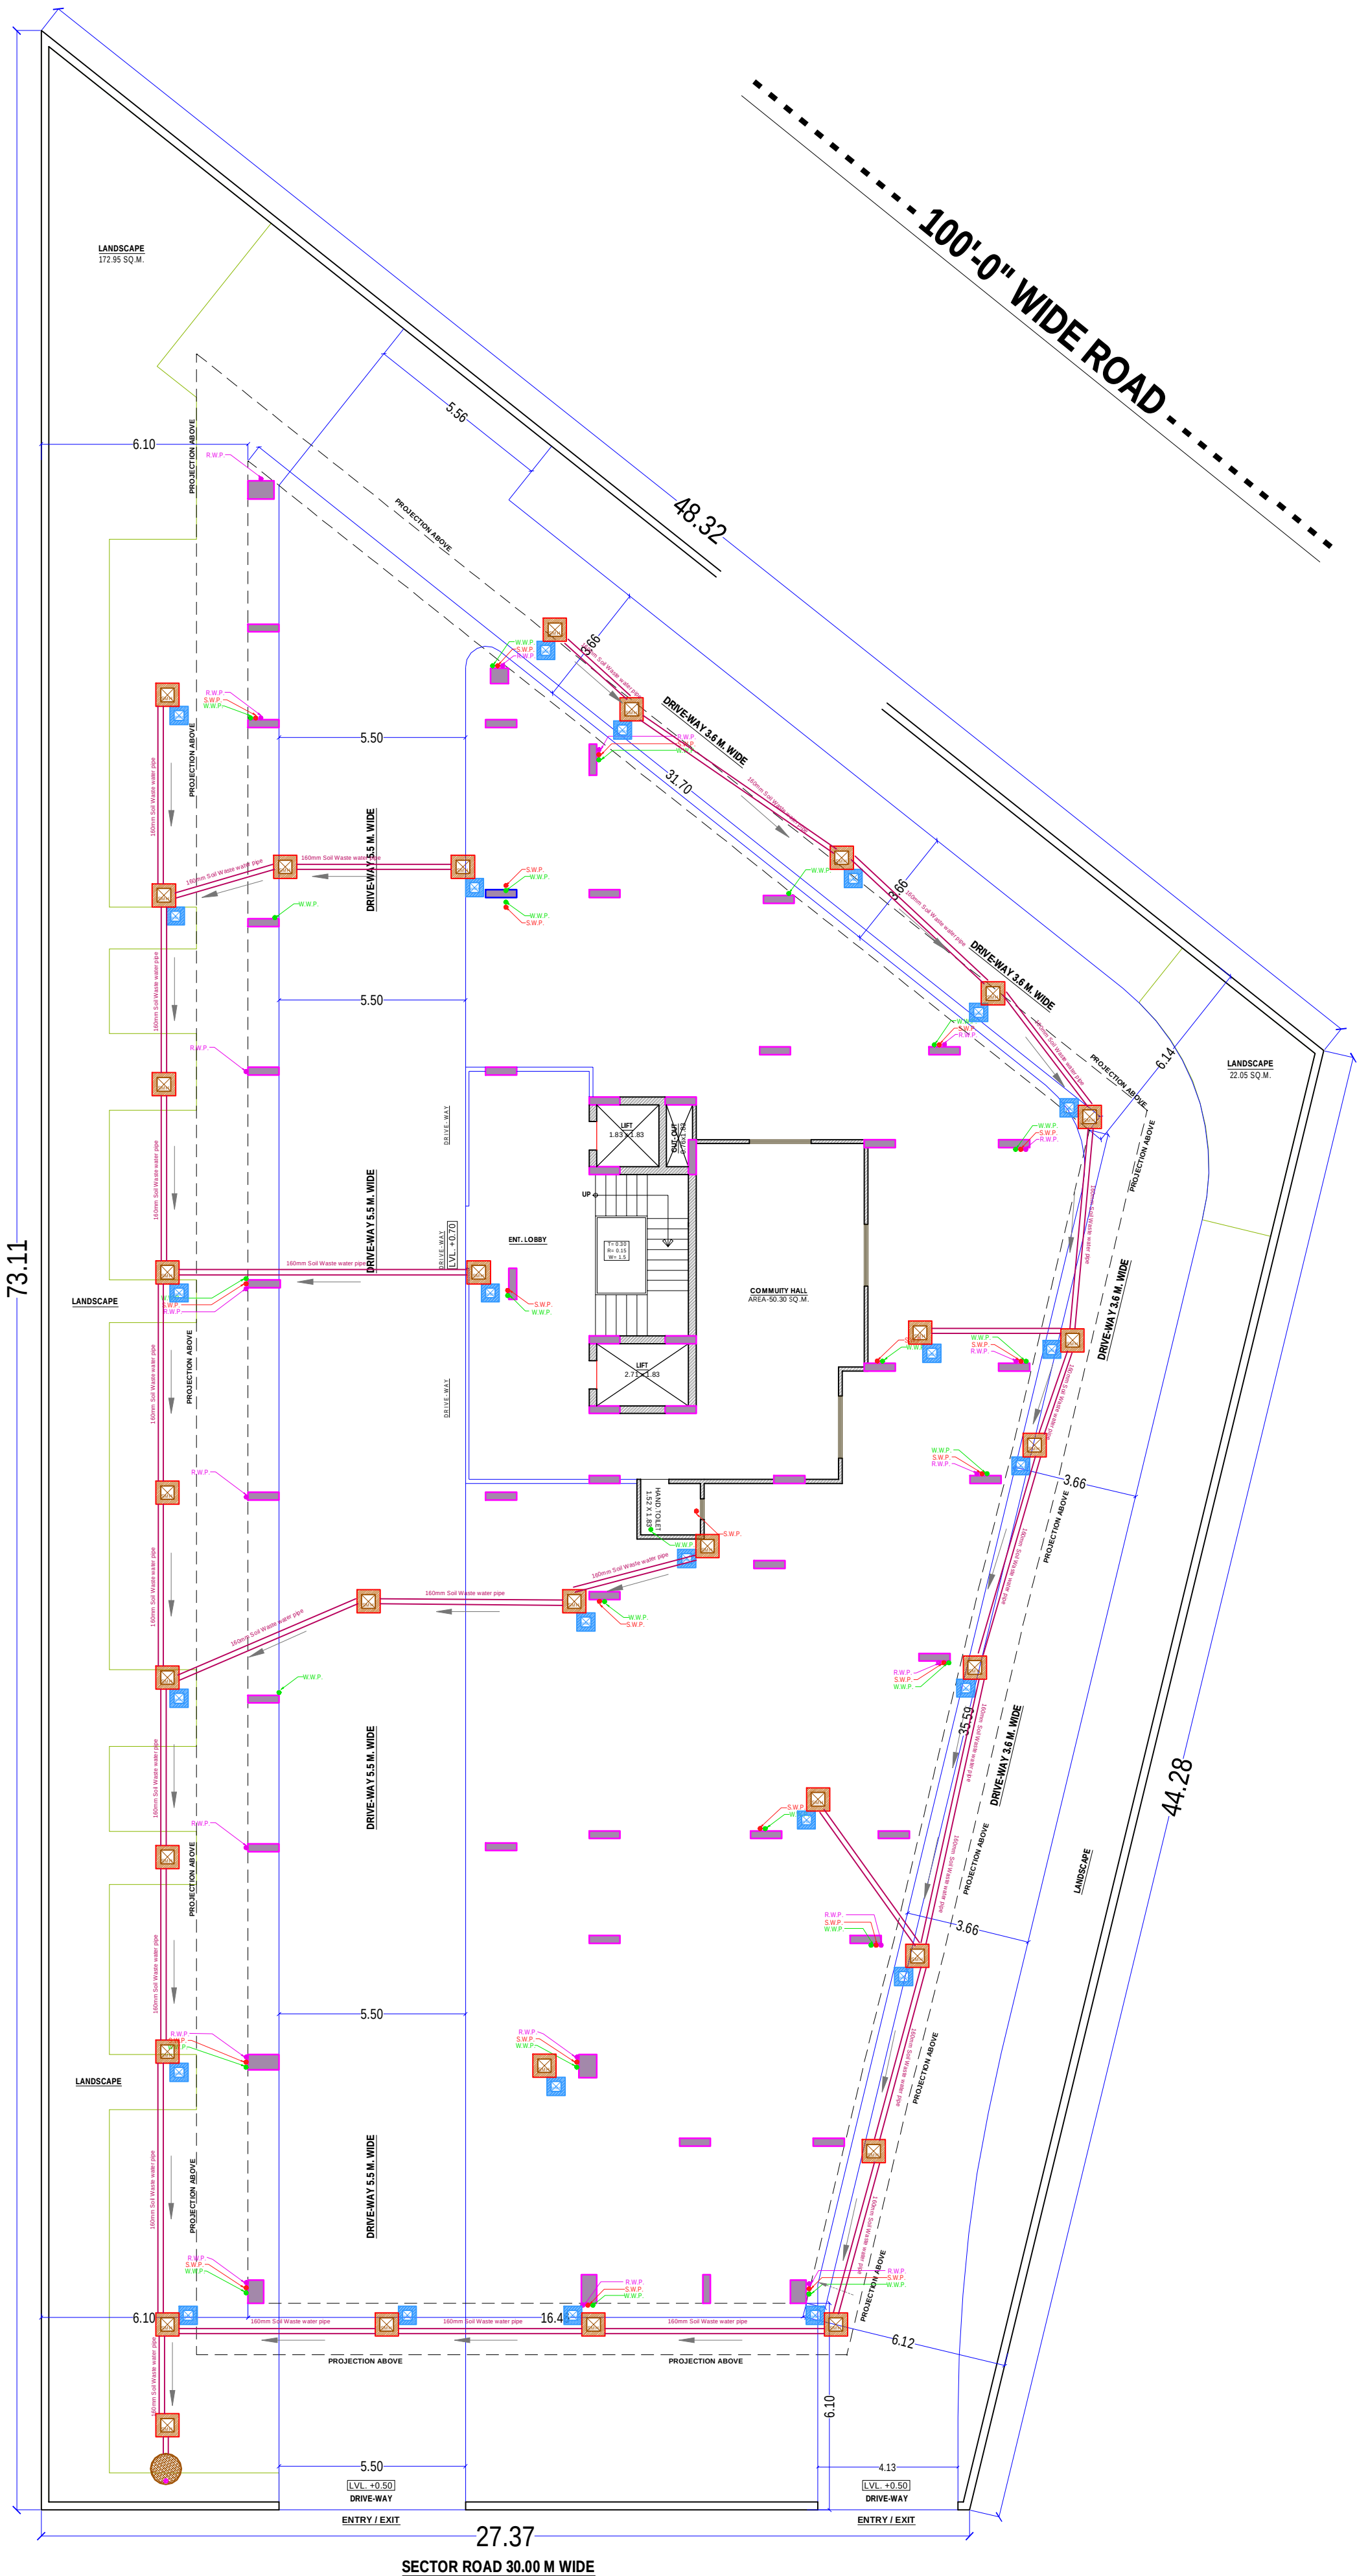B.Tech (Service Consultant)
344, Mansarovar plaza, Jaipur



STILT FLOOR PLAN

SECTOR ROAD 30.00 M WIDE

LEGENDS:-	
	WASTE WATER MANHOLE 450X450MM DEPTH- 300MM
	SEWERAGE MANHOLE 900 mm Dia
	MANHOLE 900X800MM
	SEWERAGE MANHOLE 600X600MM
SYMBOL	DESCRIPTION
	110 mm Soil Waste Water Pipe
	110 mm Waste Water Pipe
	110 mm Rain Water Pipe
	FOLLOW DIRECTION

PROJECT:	
<div>THE PEAK</div> <div>PROPOSED RESIDENTIAL BUILDING AT KHASRA NO. - 29/1, AT VILLAGE - GRIDHARIPURA, JAIPUR.</div>	
DRAWING:	
<div>STILT FLOOR</div> <div>EXTERNAL SEWER CHAMBER & PIPES ROUTE PLAN</div>	
ARCHITECT:	
<div><div></div><div>space edgeArchitects</div><div>ARCHITECTS, INTERIOR DESIGNERS AND ENGINEERS</div></div>	
SERVICES CONSULTANT:	
<div><div></div><div>Naman Yadav B.Tech (Service Consultant)</div></div>	
344,Mansarovar plaza,Jaipur	
WORKING LAYOUT PLAN	
<div>PROPOSAL PLAN</div> <div><div><div>SH.NO.</div><div>01</div></div><div>SCALE: NTS</div></div> <div><div>S</div><div>E</div><div>W</div><div>N</div></div>	
NOTE	

THIS DRAWING IS THE SOLE PROPERTY OF SPACE EDGE ARCHITECTS AND IS NOT TO BE COPIED, USED OR REPRODUCED FOR ANY PURPOSE OTHER THAN FOR WHICH IT HAS BEEN LOANED.