

GROUND FLOOR GH-3 CABLE ROUTE LAYOUT

GH-3 PANEL CONNECTING DETAIL


PANEL NO.	GROUND FLOOR	FIRST FL. TO FIFTH FL.	SIXTH FL. TO TENTH FL.
BLOCK-A			
PANEL A,B			F-1 TO F-8, C-DB-4
PANEL C,D	G-1 TO G-8, C-DB-4	F-1 TO F-8, C-DB-4	
PANEL E,F	G-9,G-10, S-1 TO S-4, C-DB-3, CM-1	F-9 TO F-16, C-DB-3	
PANEL G,H			F-9 TO F-16, C-DB-3
BLOCK-B			
PANEL I,J	G-1, G-10, C-DB-2, S-1 TO S-4, CM-2	F-1,F-10 TO F-16, C-DB-2	
PANEL K,L			F-1,F-10 TO F-16, C-DB-2
PANEL M,N			F-2 TO F-9, C-DB-1
PANEL O,P	G-2 TO G-9, C-DB-1	F-2 TO F-9, C-DB-1	


LEGEND

SYMBOL	DESCRIPTION
	DISTRIBUTION BOX
	SWITCH BOARD
	16 A SOCKET WITH SWITCH
	6A POWER SOCKET WITH SWITCH
	TUBE LIGHT 1x28 W
	WALL CFL 1x15 W
	WALL CFL 1x15 W
	CAMERA
	TOILET MIRROR LIGHT 1x18w
	CEILING FAN 1200 MM SWEEP
	BOLLARD LIGHT
	POLE LIGHT
	3x4.0 SQMM CU. WIRE
	RG-6 TV CABLE
	ELECTRICAL INSPECTION CHAMBER 750x750MM

MEP CONSULTANT : --
cube consultant
A-8, PATH NO. 4, JAMUNA NAGAR,
SODALA, JAIPUR-302006
MAIL: - cubemep@gmail.com
PH. NO. +91 141 2221089, 9214308430,
9351802227

DEALT BY YOGESH	REVISION	DATE: 11.02.2021
DWG NO		

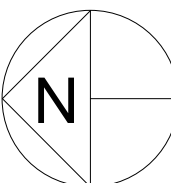1.		
NO.	DATE	DESCRIPTION
REVISIONS		
Sector-7 (GH-3) Indra Gandhi Nagar,Jaipur		
2628,2629,2631,2631/3026, I.G Nagar Sanganer Jaipur		
CLIENT: RAJASTHAN HOUSING BOARD		
ARCHITECT: ADS	ARCHITECTURAL DESIGN & SERVICES E-6B, HANUMAN PATH, SHYAM NAGAR NEW SANGANER ROAD, JAIPUR. Ph.: 0141-4013343, 4043343 e-mail: adsdesign07@yahoo.co.in	
DRG.TITLE : COMPLETE ELECTRICAL LAYOUT		
CHKD BY : LOKESH JOSHI		
DRN BY : G.S.CHAUHAN		
FILE NAME : D/EXT./RHB/GH-3		
SCALE : N T S	DRG.No.	
DATE : 02/03/2021	NORTH	

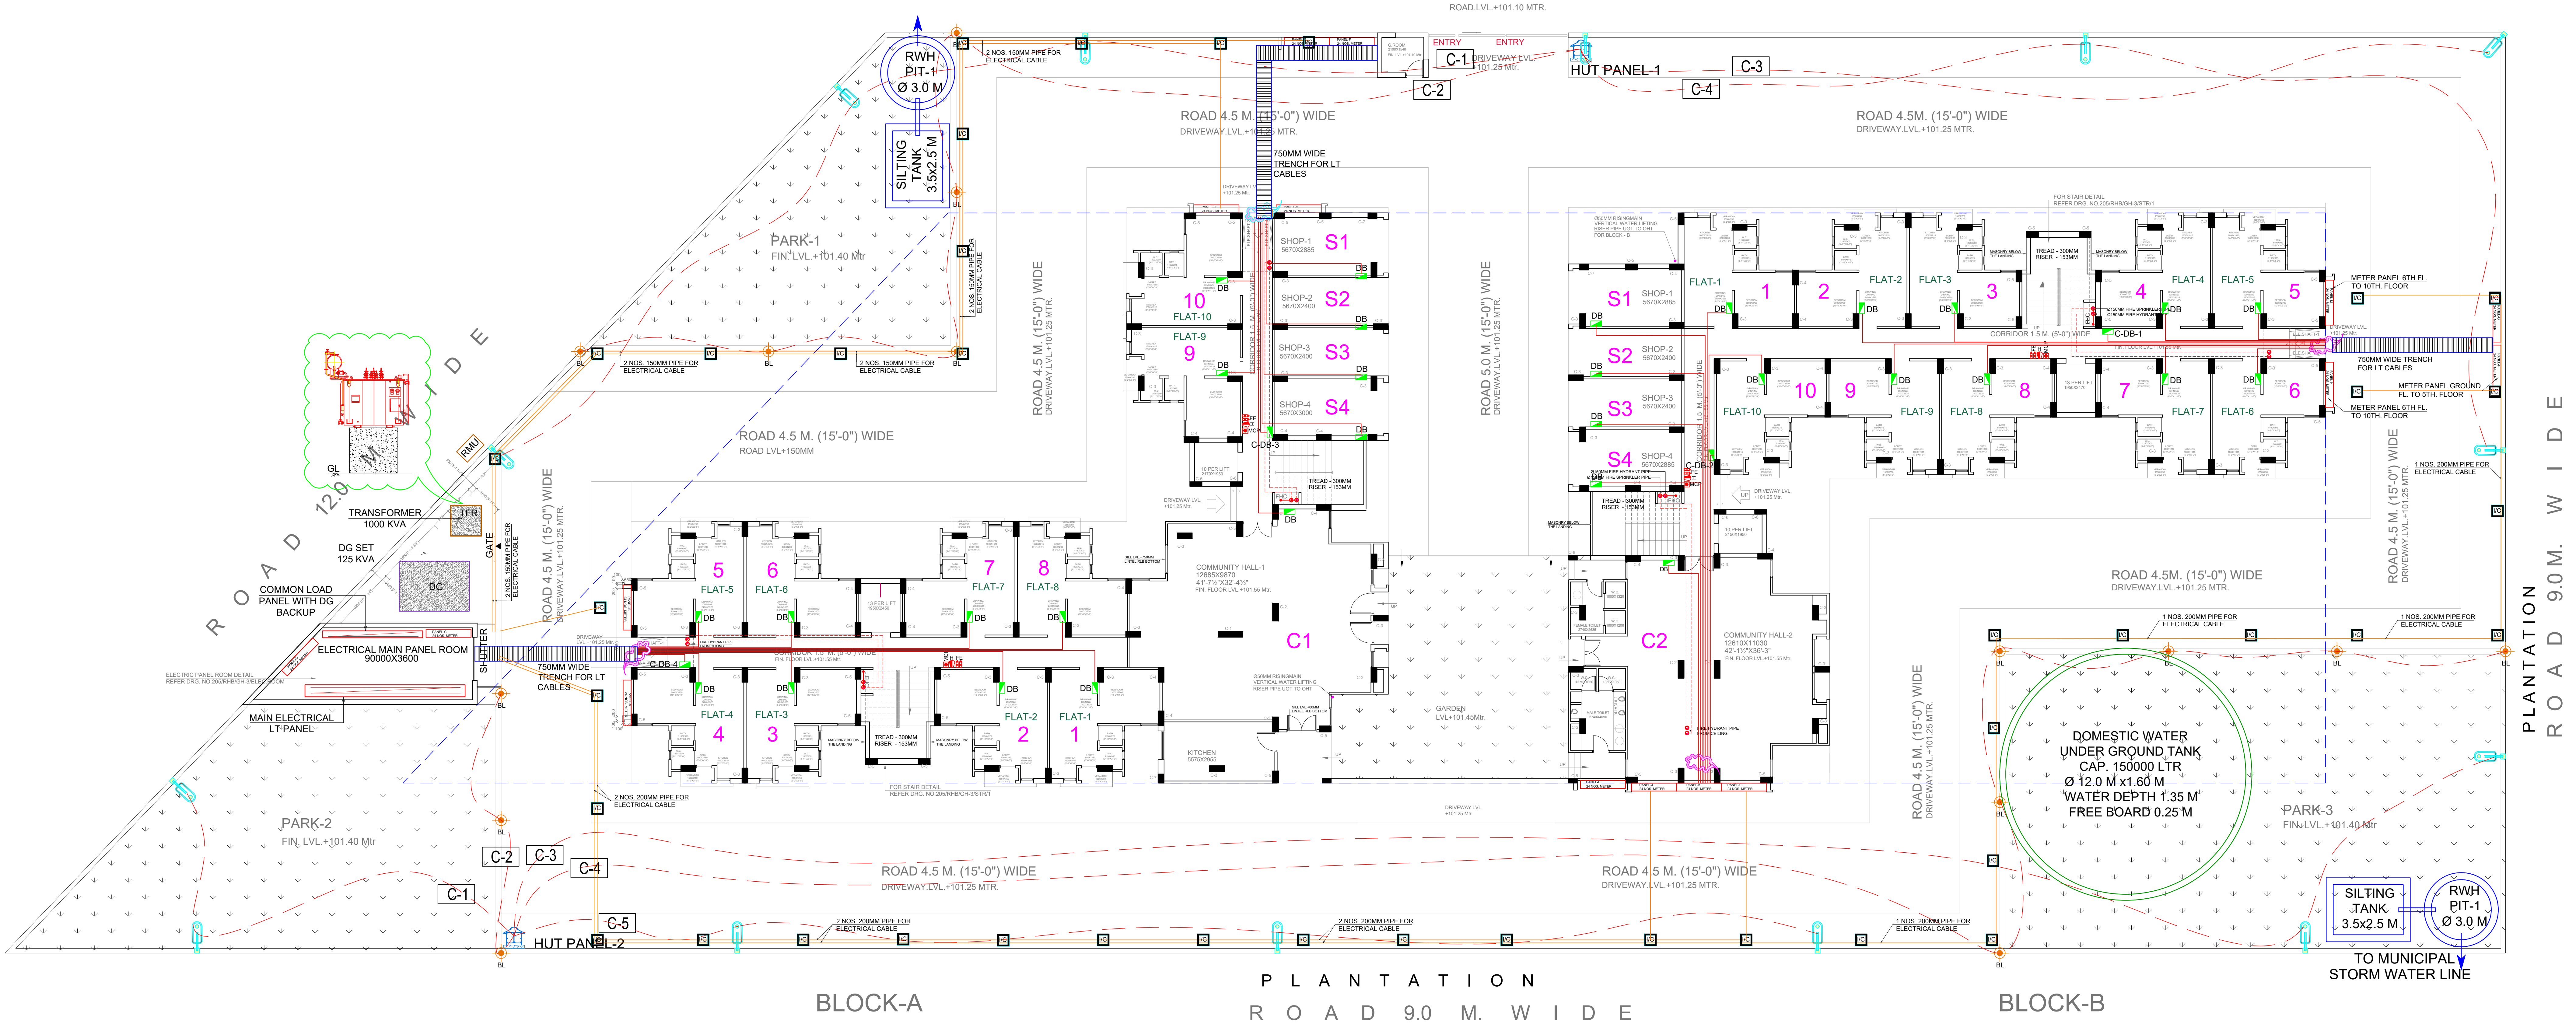

अश्विनी
जापुर - विविध
राजस्थान म.वा.स.न.स.स.स.
क.प.स.स.

(Signature)
LOKESH JOSHI
ARCHITECT
EA/97/21993