 




Vipul
VIPUL AGARWAL
M.E.P. CONSULTANT
B.E. ELECTRICAL

LEGENDS:			
Qty.	ID	Symbol	Description
11	PL		STREET LIGHT

SERVICES CONSULTANT:
ASHI ASSOCIATES
F 9 / 440 , Keshav Marg Chitrakut Scheme,Jaipur
PH:91-0-93146-10438 ,0141-2440946 Mail:vipul8599@yahoo.com


ARCHITECTS:-
 **SPACE GRID**
C-49,VIDYA
APARTMENT,PARAS MARG,
BAPU NAGAR,NEAR JANTA
STORE CIRCLE, JAIPUR-302015
PH-09314918766,0141-4005506 (O)
Email:-info.spacegrid@gmail.com


PROJECT NAME:-
FRANKFURT BY R. R. HOMES

FIRM:-
**RAJ RAJESHWARI
REAL ESTATES LLP**

PROJECT ADDRESS:-
**PROPOSED RESIDENTIAL
BUILDING AT PLOT NO. 05, "R R
HOMES KANAKPURA-III", JAIPUR**

DRAWING:-
**STILT FLOOR
EXTERNAL STREET
LIGHTING MARKED PLAN**

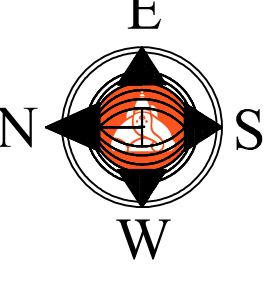SCALE:-		
DATE:-	1:100	
REV.:-	28-08-2024	
	00	

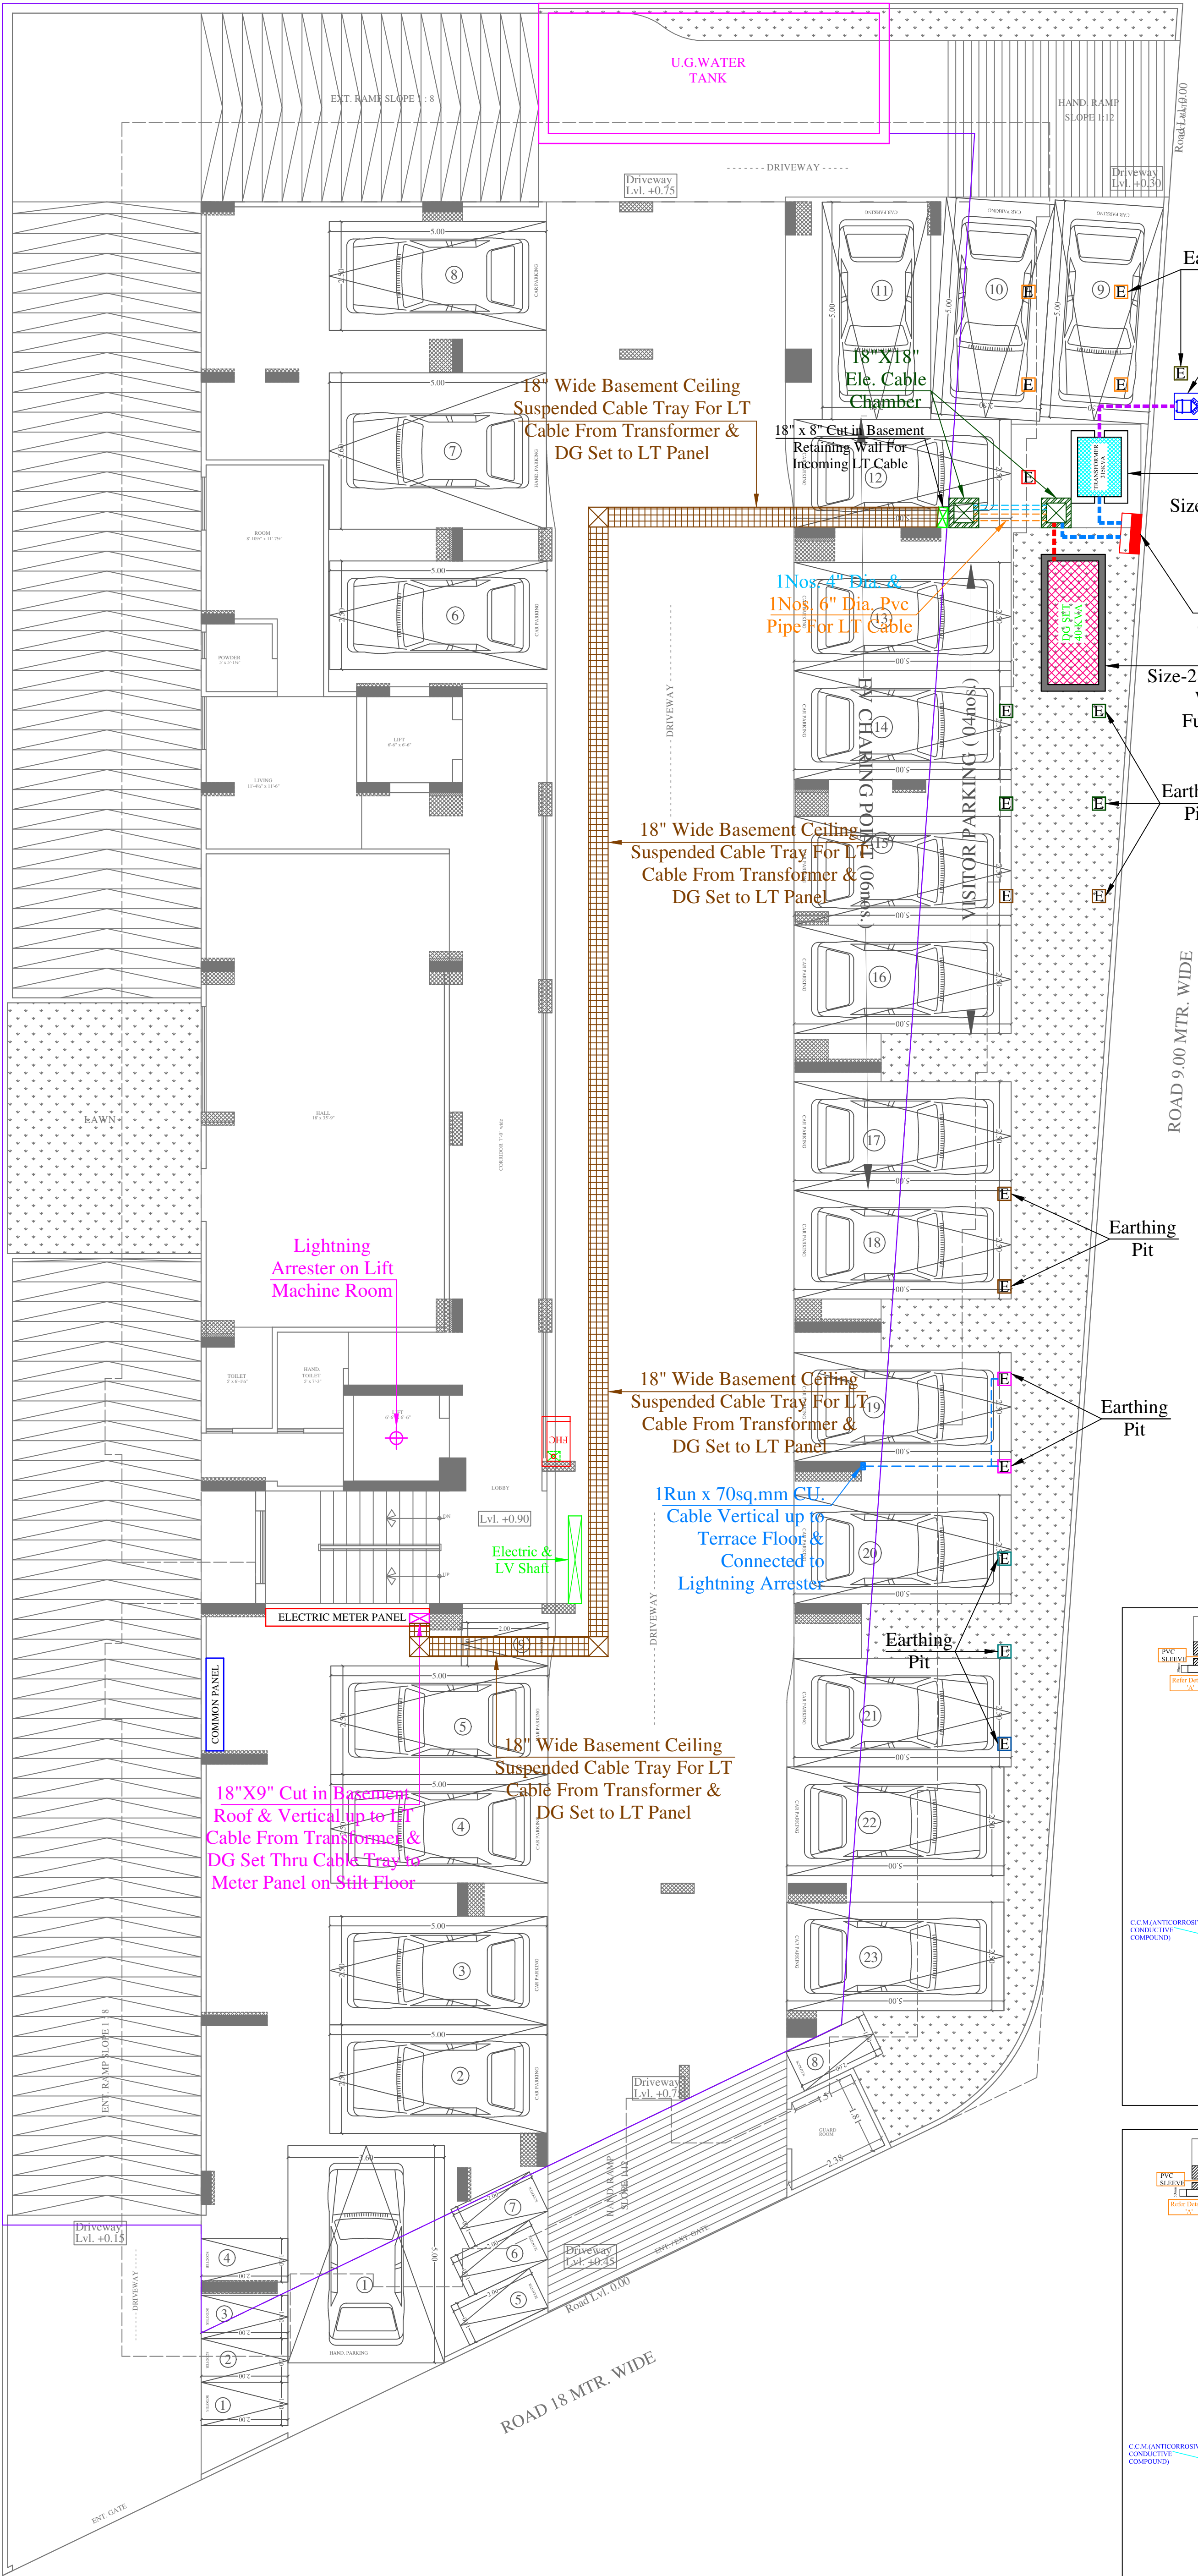

Lightning
Arrester

Model: Stormaster –
ESE - 50 (Level
2/Medium Protection)
(Protection radius - 35M,
Mast Height -2 Mtr)

VIPUL
VIPUL AGARWAL
M.E.P. CONSULTANT
B.E. ELECTRICAL

EARTHING DETAILS			
01		50MM PIPE(2METER)	3WAY HT RMU BODY EARTH
01		50MM PIPE(2METER)	CT CHECK METER BOX BODY EARTH
02		50MM PIPE(2METER)	TRANSFORMER BODY EARTH
02		80MM PIPE(3METER)	TRANSFORMER NEUTRAL EARTH
02		50MM PIPE(2METER)	DG SET BODY EARTH
02		80MM PIPE(3METER)	DG SET NEUTRAL EARTH
02		50MM PIPE(2METER)	LIGHTNING ARRESTER BODY EARTH
02		50MM PIPE(2METER)	ELECTRIC PANEL BODY EARTH
01		50MM PIPE(2METER)	TELEPHONE EXCH. BODY EARTH
04		50MM PIPE(2METER)	LIFT PANEL BODY EARTH

NOTES:
1. ALL NEUTRAL EARTHS TO BE CONNECTED 50 X 3 GI EARTH STRIP FROM EARTH PIT TO EQUIPMENT.
2. ALL BODY EARTHS TO BE CONNECTED 25 X 3 GI EARTH STRIP FROM EARTH PIT TO EQUIPMENT.

SERVICES CONSULTANT:
ASHI ASSOCIATES
F 9 / 440 , Keshav Marg Chitrakut Scheme,Jaipur
PH-91-0-93146-10438 .0141-2440946 Mail:vipul8599@yahoo.co

ARCHITECTS:-
SPACE GRID
C-49,VIDYA
APARTMENT,PARAS MARG,
BAPU NAGAR,NEAR JANTA
STORE CIRCLE, JAIPUR-302015
PH-09314918766,0141-4005506 (O)
Email:-info.spacegrid@gmail.com

PROJECT NAME:-
FRANKFURT BY R. R. HOMES

FIRM:-
**RAJ RAJESHWARI
REAL ESTATES LLP**

PROJECT ADDRESS:-
**PROPOSED RESIDENTIAL
BUILDING AT PLOT NO. 05, "R R
HOMES KANAKPURA-III", JAIPUR**

DRAWING:-
**STILT FLOOR
ELECTRIC SUB STATION,
CABLE CHAMBER PIPE ROUTE
& LIGHTNING ARRESTER PLAN**

SCALE:-	1:100	
DATE:-	28-08-2024	
REV.:-	00	

SERVICES CONSULTANT:
ASHI ASSOCIATES
F 9 / 440 , Keshav Marg Chitrakut Scheme,Jaipur
PH:91-0-93146-10438 ,0141-2440946 Mail:vipul8599@yahoo.com

PROJECT NAME:-
FRANKFURT BY R. R. HOMES

FIRM:-
RAJ RAJESHWARI
REAL ESTATES LLP




PROJECT ADDRESS:-


PROPOSED RESIDENTIAL
BUILDING AT PLOT NO. 05, "R R
HOMES KANAKPURA-III", JAIPUR

DRAWING:-

ALL DISTRIBUTION
PANEL
SINGLE LINE DIAGRAM

DATE:- 29-08-2024	REV.:- 00
DRAWN BY:- VICKY YADAV	CHECKED BY :- VIPUL AGARWAL

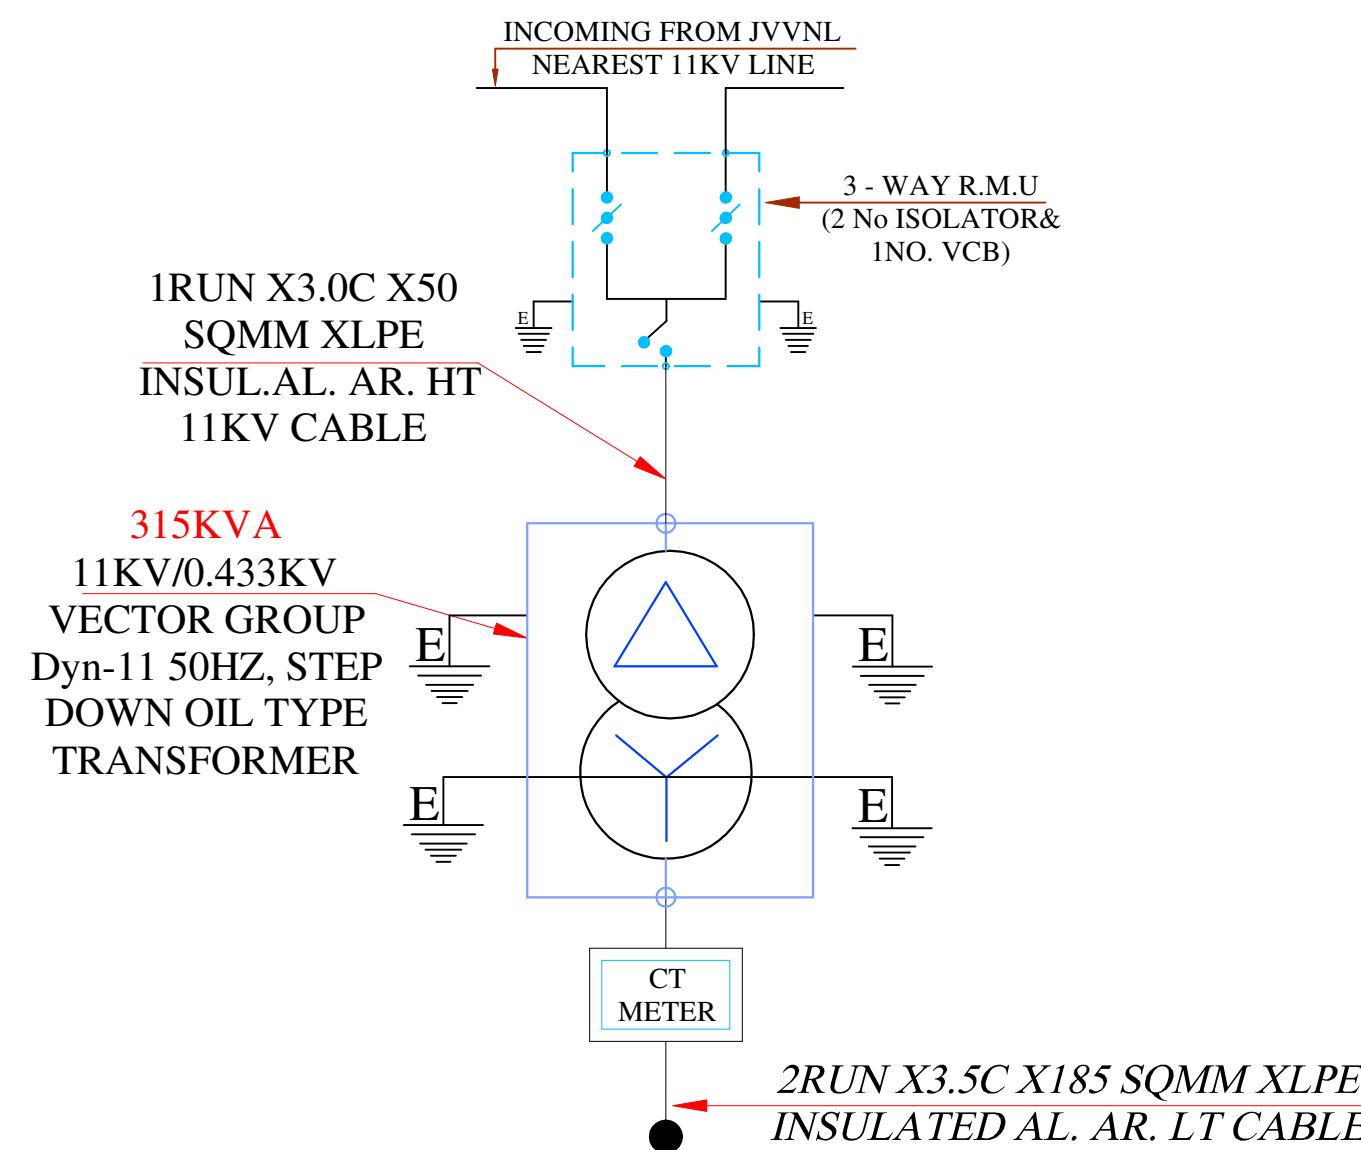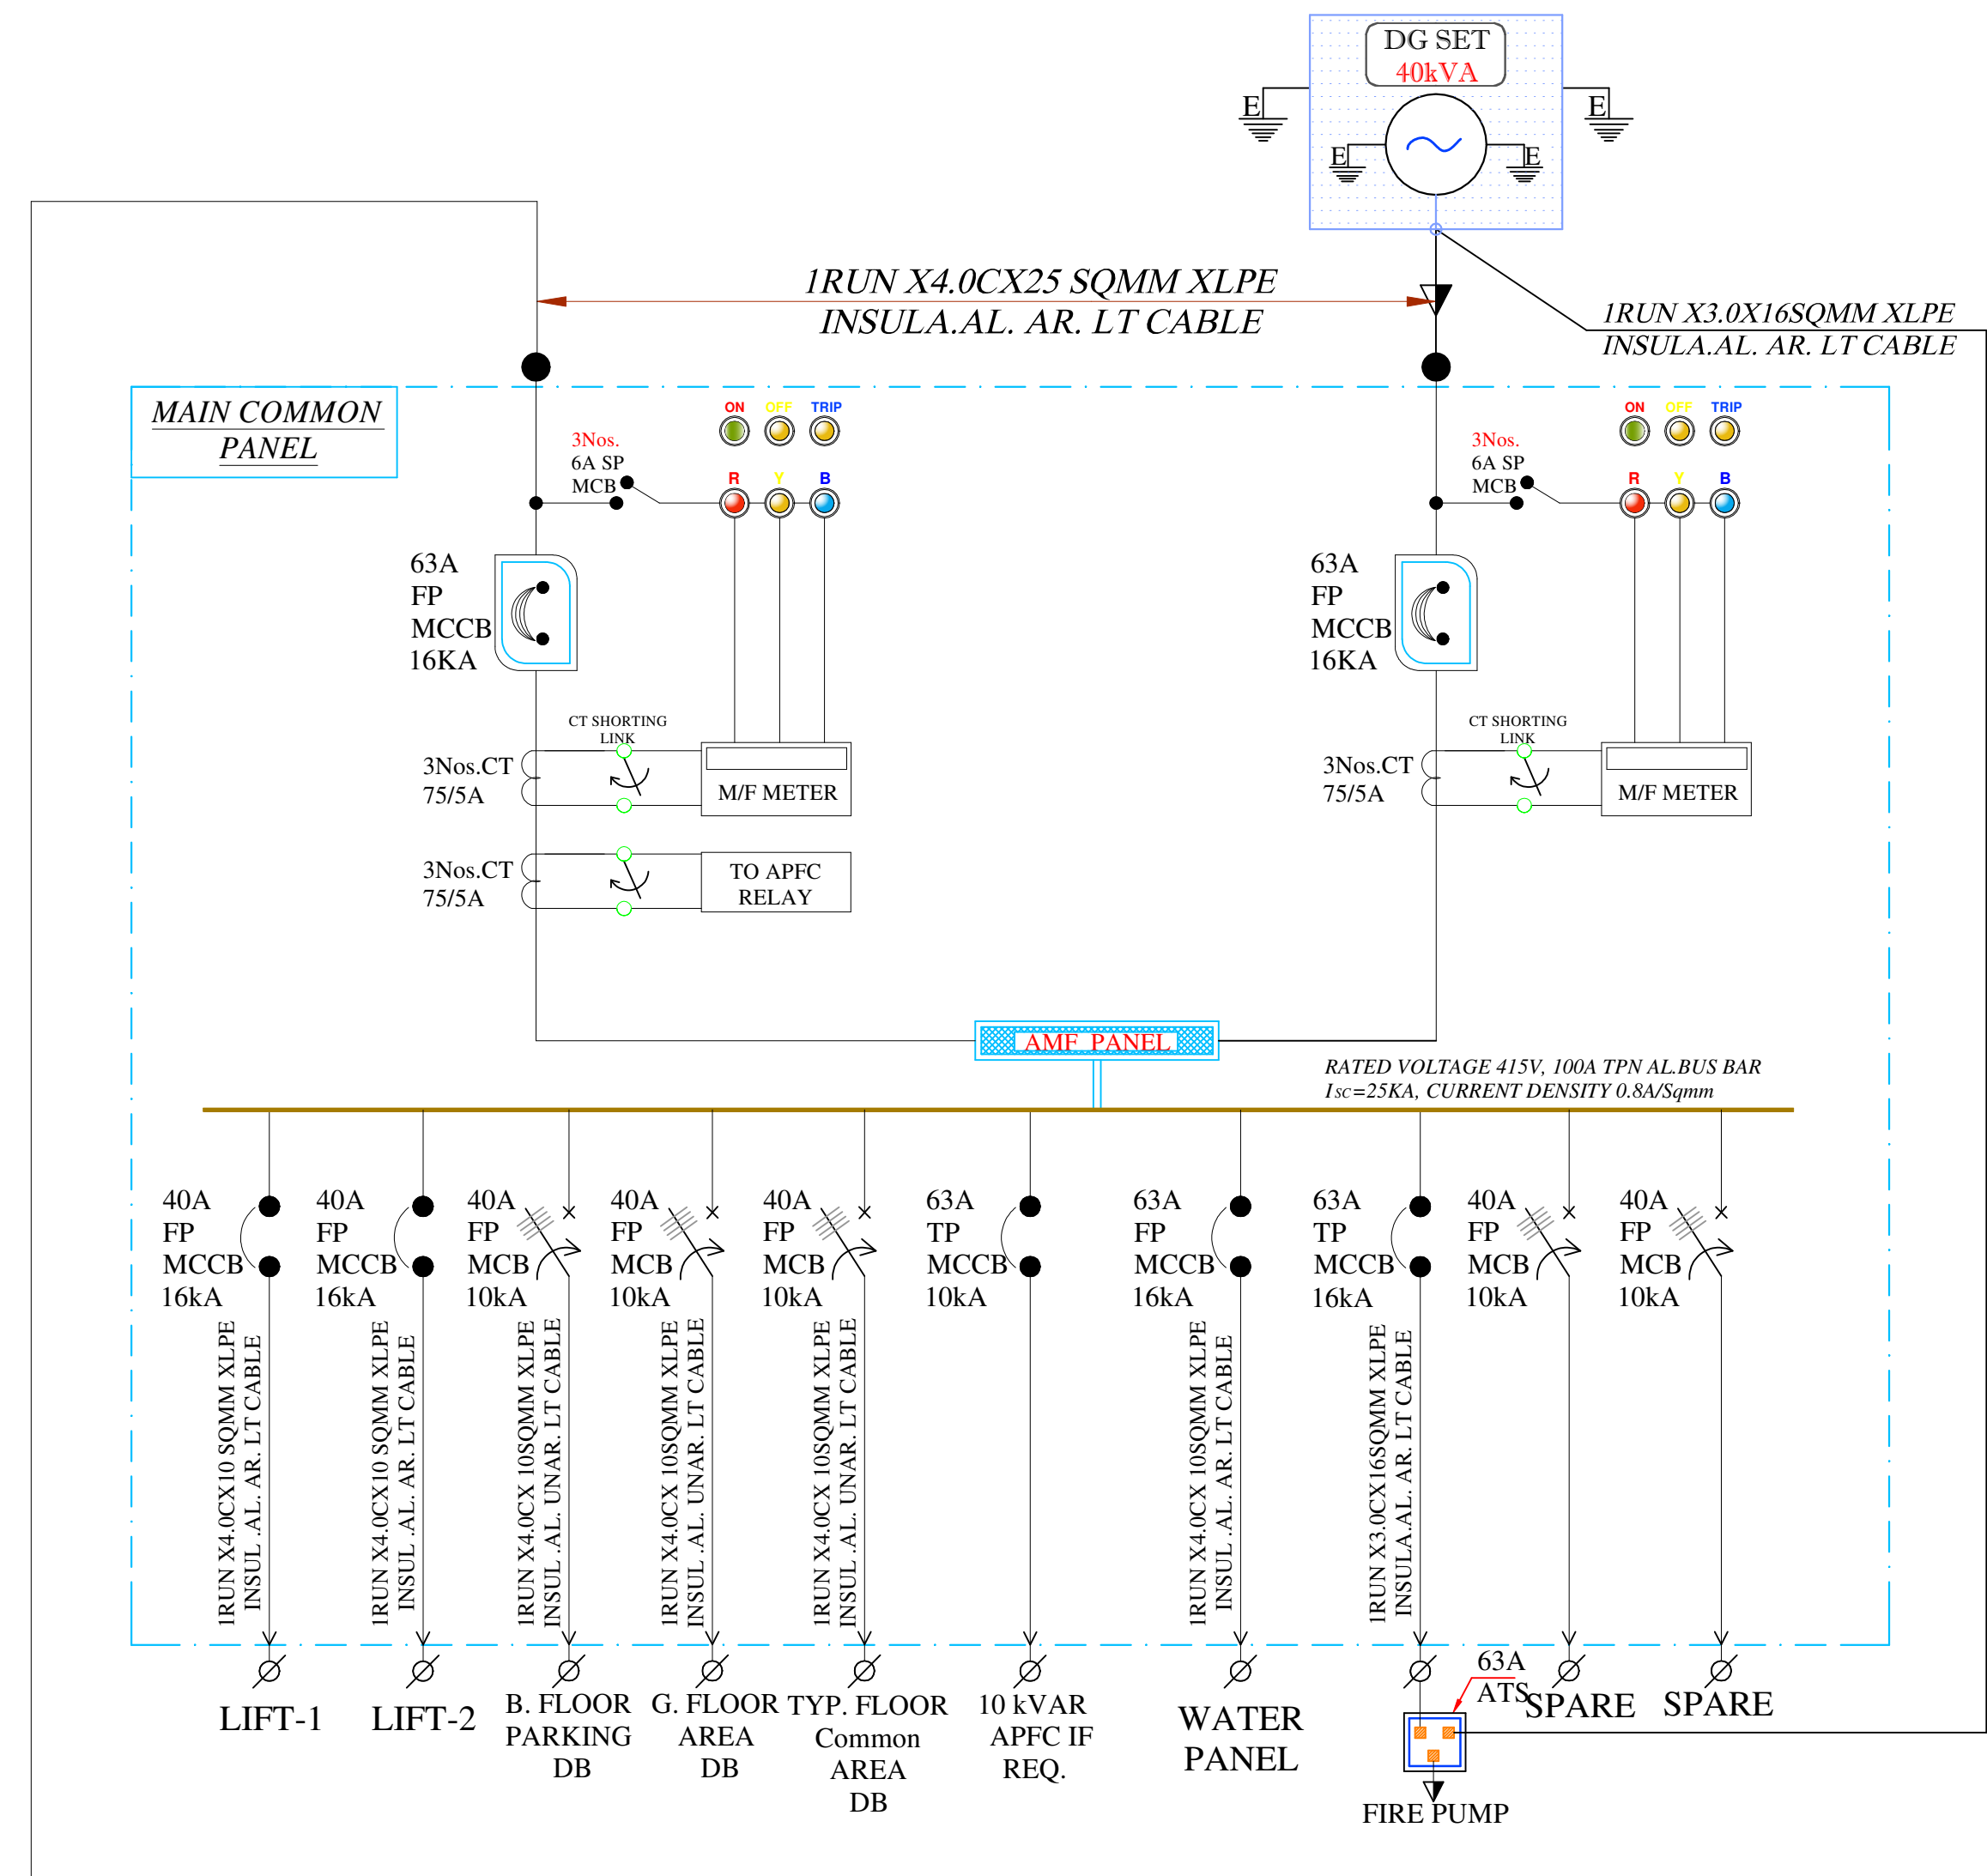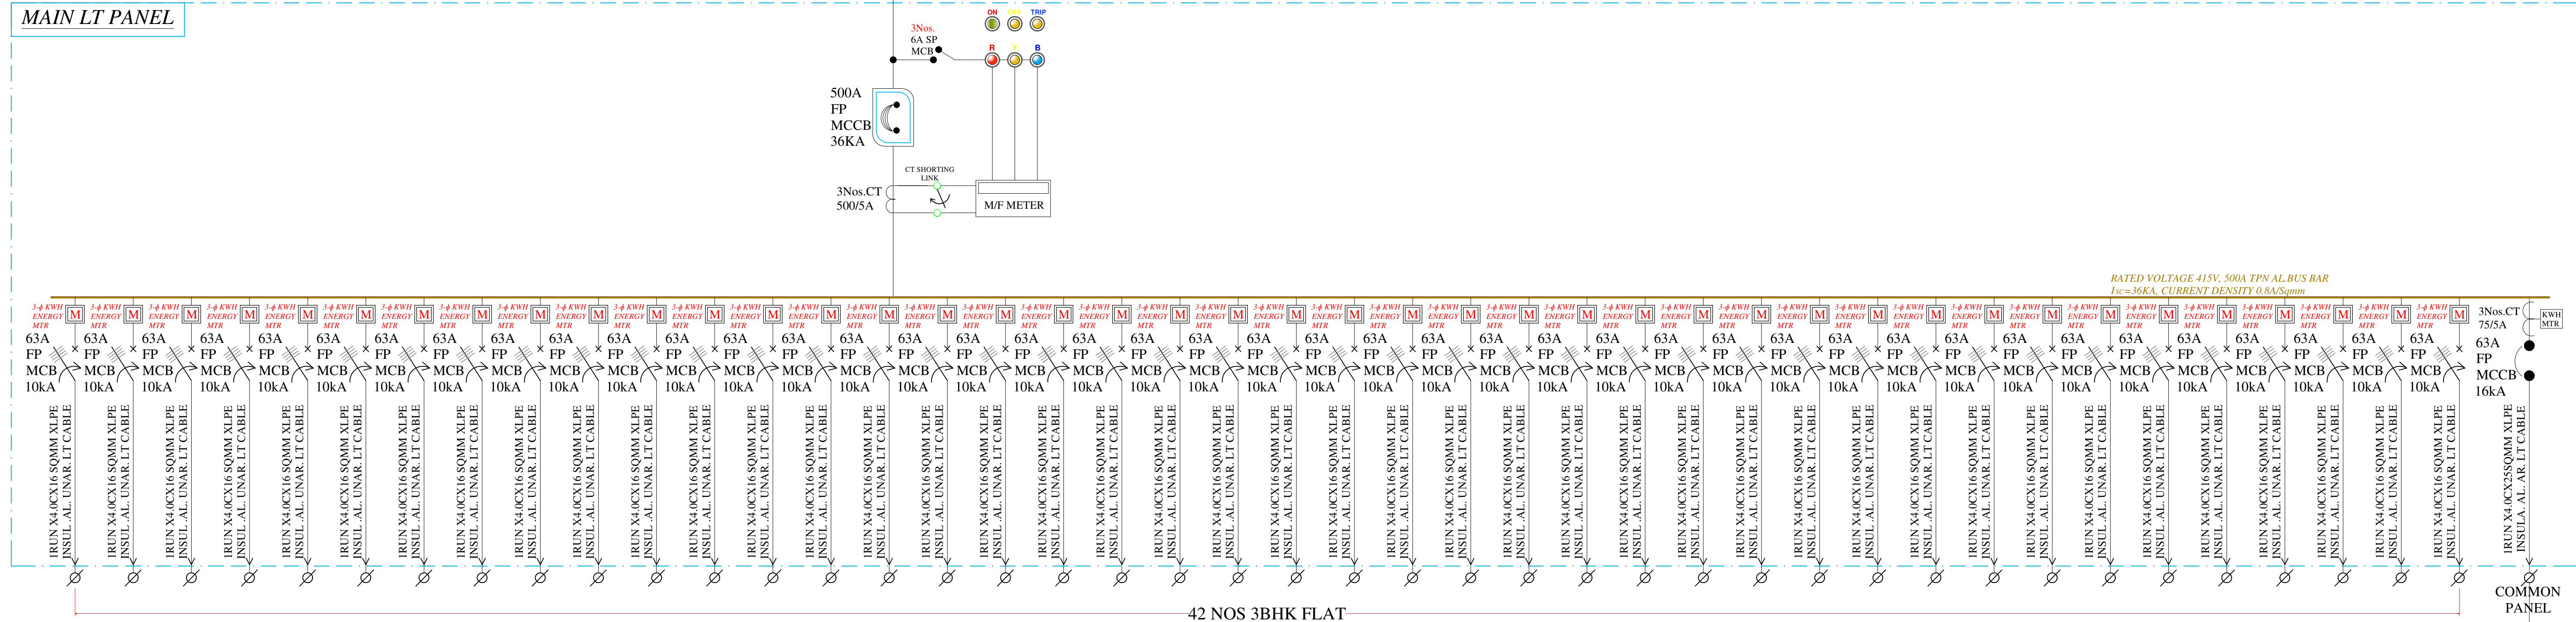

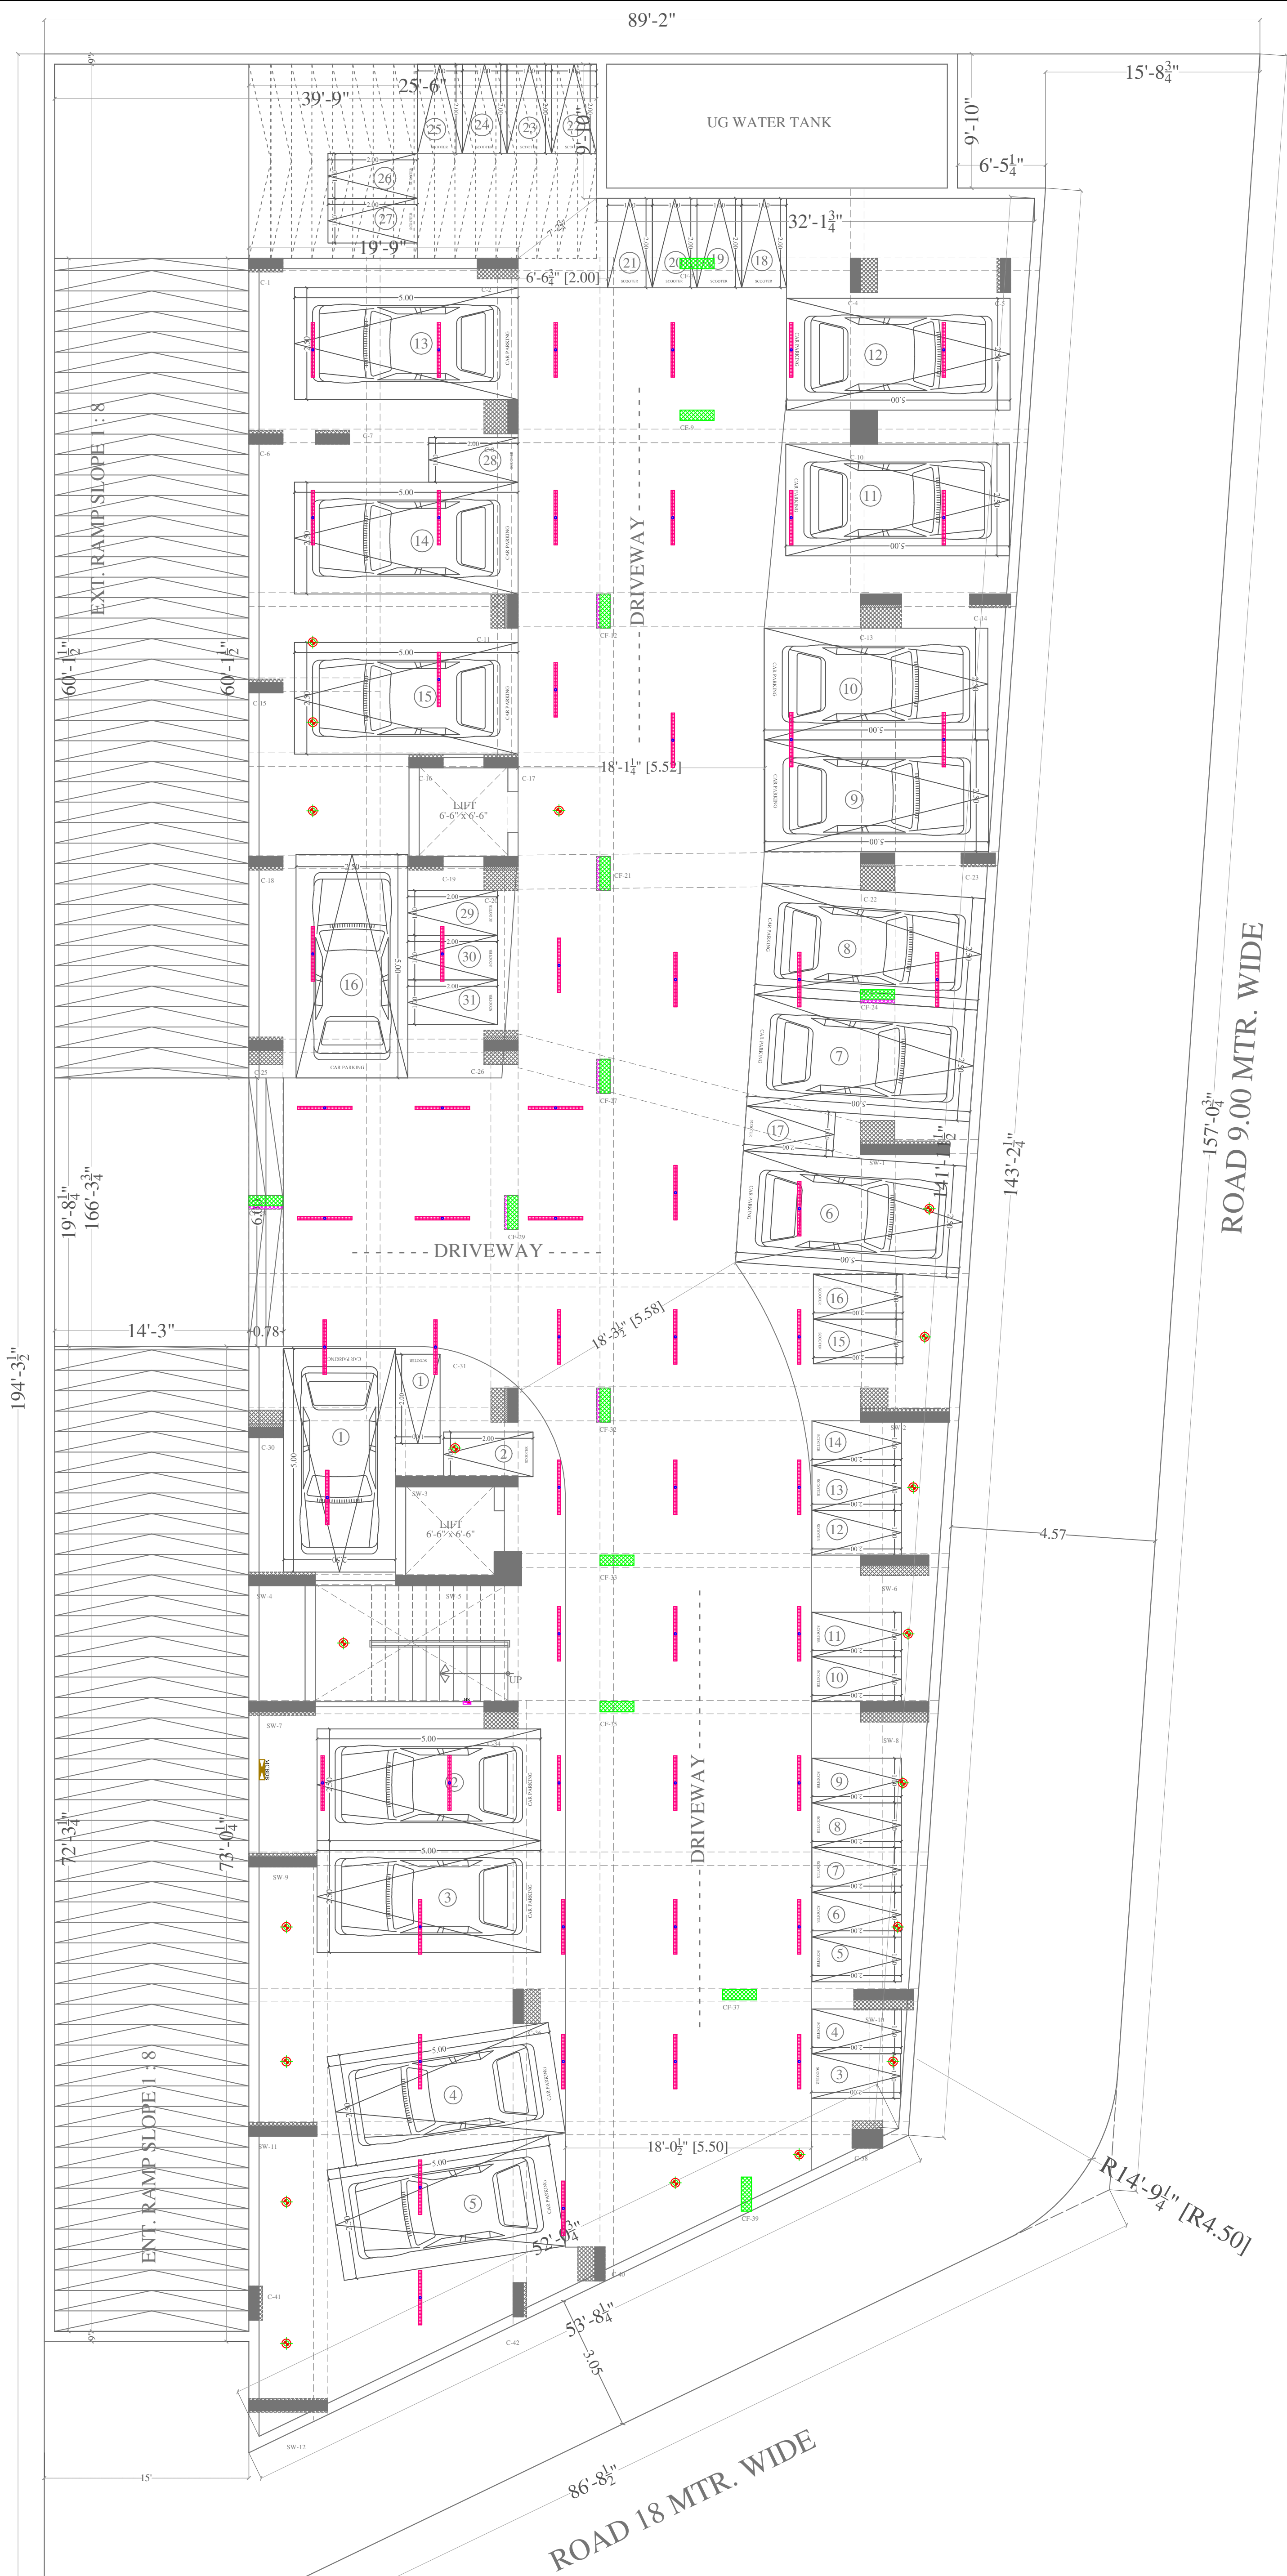

Vipul
VIPUL AGARWAL
M.E.P. CONSULTANT
B.E. ELECTRICAL

LEGENDS:				
Mounting Height	QTY.	ID	SYMBOL	DESCRIPTION
CEILING		FAN/48"		CEILING FAN 48"
CEILING		DL		LED 6" DOWN LIGHTER 20W (SURFACE MOUNTED) MAKE:- SYSKA LED CAT NO:- SDL-15W GLD 6.5K/4K
+90"		BULB		Led Bulb 20W Make:- Syska Led Cat no. SKC-20W 5.7K/3K
VENTILATOR HT.		CR		CEILING ROSE
VENTILATOR HT.		EXP		9" DIA FRESH AIR FAN
CEILING		TL		LED CEILING TUBE LIGHT MAKE:- SYSKA LED CAT NO:- SSK-T5-20W
+90"		TL/W		Led Wall Tube Light Make:- Syska Led Cat no:- SSK-T5-20W
+42"		SB		SWITCH BOARD
+60"		MCB DB		MCB DISTRIBUTION BOARD

SERVICES CONSULTANT:
ASHI ASSOCIATES
F 9 / 440 , Keshav Marg Chitrakut Scheme,Jaipur
PH:91-0-93146-10438 ,0141-2440946 Mail:vipul8599@yahoo.com

ARCHITECTS:-

SPACE GRID
C-49,VIDYA
APARTMENT,PARAS MARG,
BAPU NAGAR,NEAR JANTA
STORE CIRCLE, JAIPUR-302015
PH-09314918766,0141-4005506 (O)
Email:-info.spacegrid@gmail.com

PROJECT NAME:-
FRANKFURT BY R. R. HOMES

FIRM:-
**RAJ RAJESHWARI
REAL ESTATES LLP**

PROJECT ADDRESS:-
**PROPOSED RESIDENTIAL
BUILDING AT PLOT NO. 05, "R R
HOMES KANAKPURA-III", JAIPUR**

DRAWING:-
**BASEMENT FLOOR
ELECTRICAL POINT
MARKED PLAN**

SCALE:-	1:100	
DATE:-	28-08-2024	
REV.:-	00	



Vipul
VIPUL AGARWAL
M.E.P. CONSULTANT
B.E. ELECTRICAL

LEGENDS:				
Mounting Height	QTY.	ID	SYMBOL	DESCRIPTION
CEILING		FAN/48"		CEILING FAN 48"
CEILING		DL		LED 6" DOWN LIGHTER 20W (SURFACE MOUNTED) MAKE:- SYSKA LED CAT NO.:- SDL-15W GLD 6.5K/4K
+90"		BULB		Led Bulb 20W Make:- Syska Led Cat no:- SKC-20W 5.7K/3K
VENTILATOR HT.		CR		CEILING ROSE
VENTILATOR HT.		EXF		9" DIA FRESH AIR FAN
CEILING		TL		LED CEILING TUBE LIGHT MAKE:- SYSKA LED CAT NO.:- SSK-TS-20W
+90"		TL/W		Led Wall Tube Light Make:- Syska Led Cat no:- SSK-TS-20W
+42"		SB		SWITCH BOARD
+60"		MCB DB		MCB DISTRIBUTION BOARD

SERVICES CONSULTANT:
ASHI ASSOCIATES
F 9 / 440 , Keshav Marg Chitrakut Scheme,Jaipur
PH:91-0-93146-10438 ,0141-2440946 Mail:vipul8599@yahoo.com

ARCHITECTS:-
SPACE GRID
C-49,VIDYA APARTMENT,PARAS MARG, BAPU NAGAR,NEAR JANTA STORE CIRCLE, JAIPUR-302015
PH-09314918766,0141-4005506 (O)
Email:-info.spacegrid@gmail.com


PROJECT NAME:-
FRANKFURT BY R. R. HOMES

FIRM:-
RAJ RAJESHWARI REAL ESTATES LLP

PROJECT ADDRESS:-
PROPOSED RESIDENTIAL BUILDING AT PLOT NO. 05, "R R HOMES KANAKPURA-III", JAIPUR

DRAWING:-
STILT FLOOR ELECTRICAL POINT MARKED PLAN

SCALE:-		
DATE:-	1:100	
REV.:-	28-08-2024	
	00	

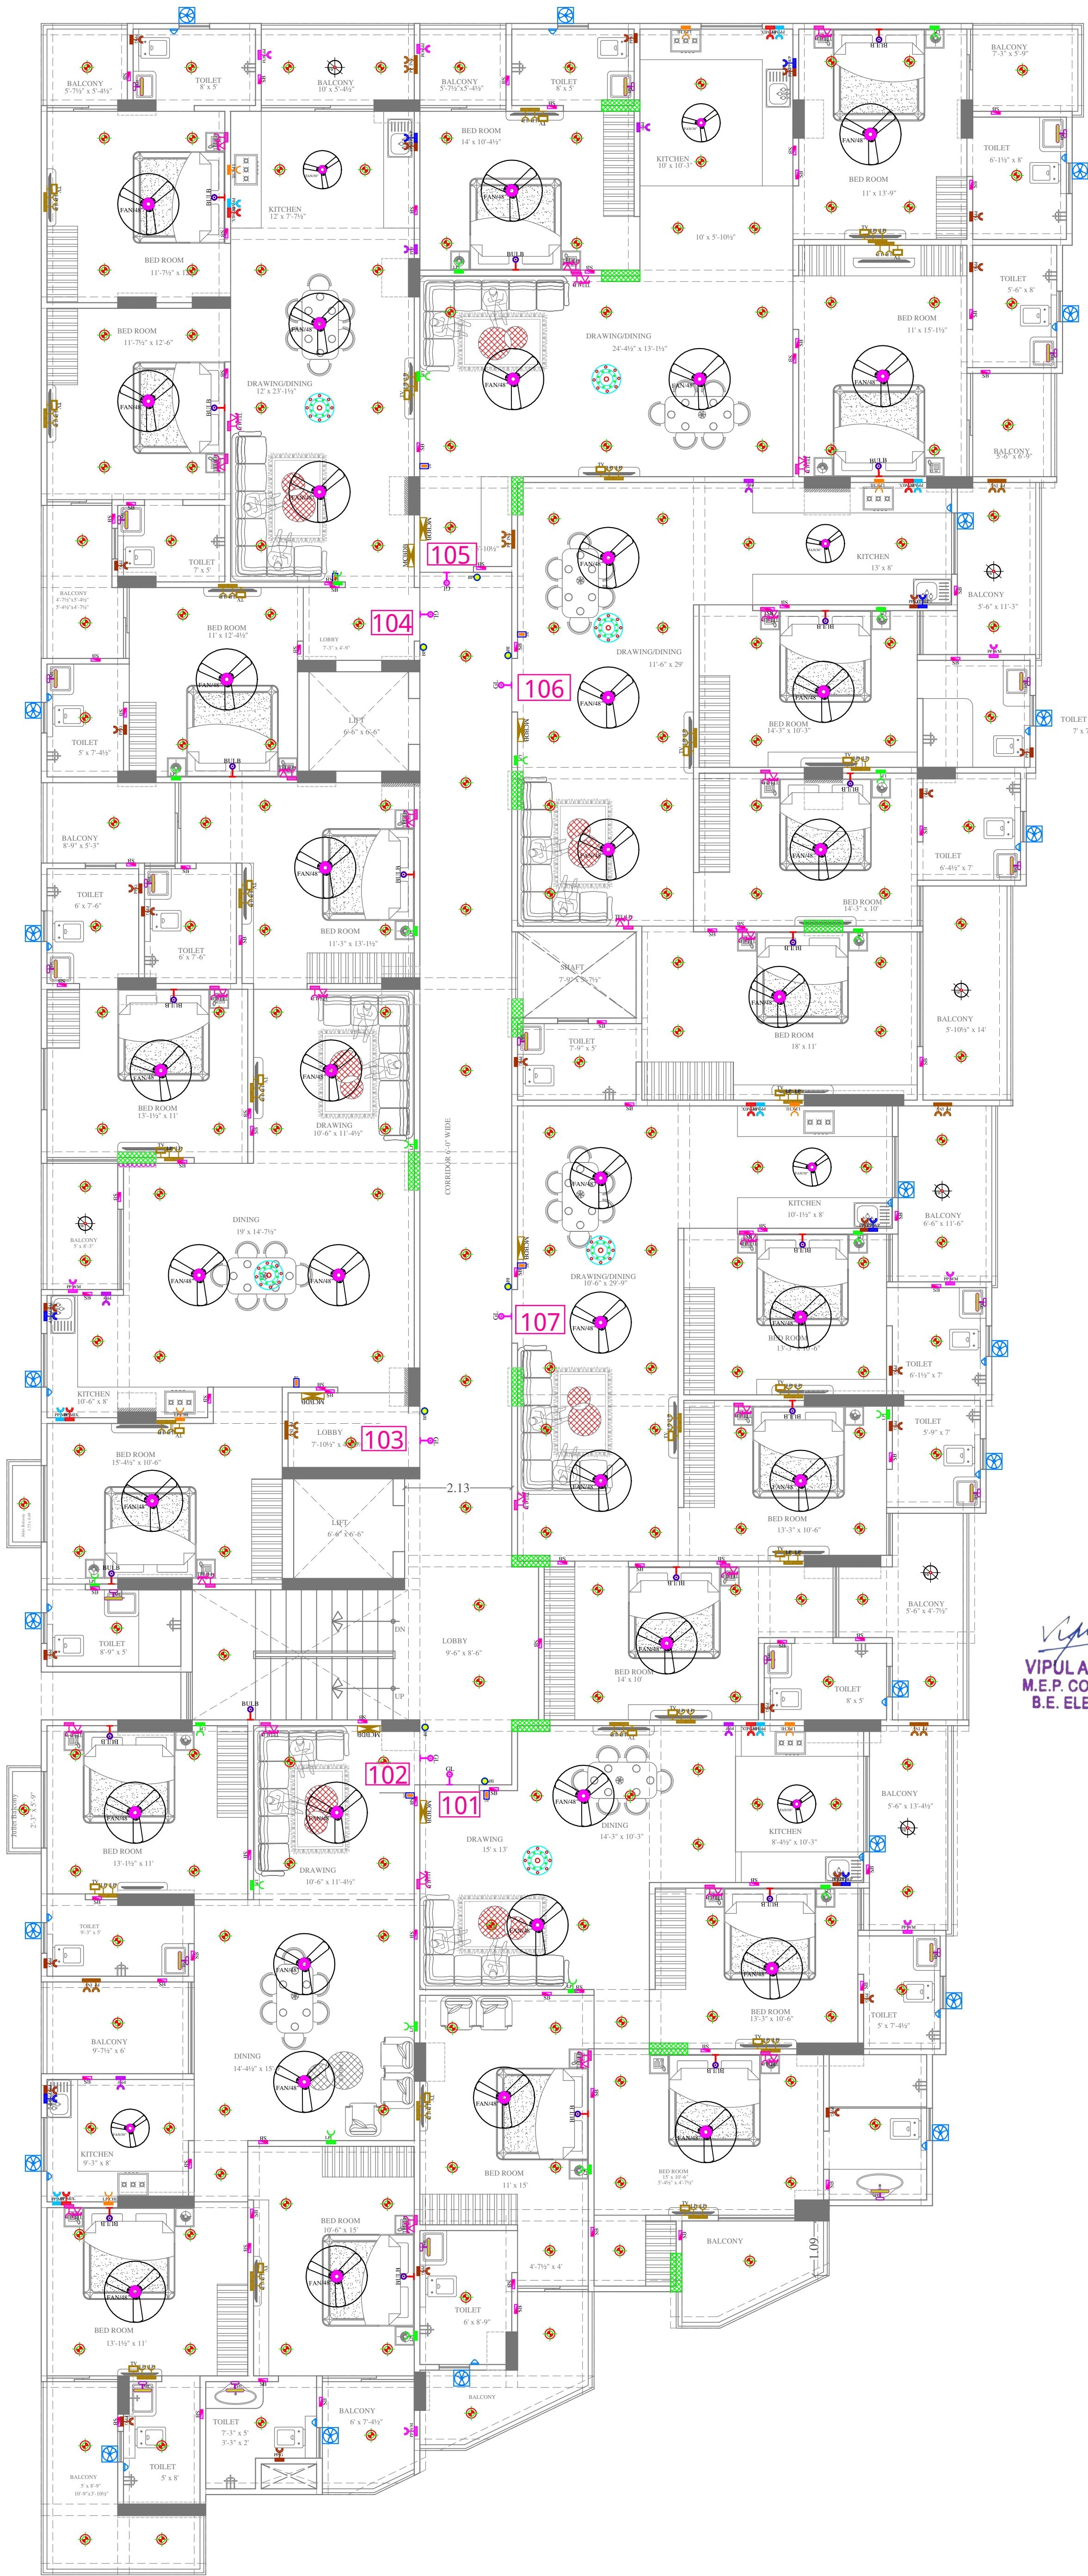

Vipul
VIPUL AGARWAL
M.E.P. CONSULTANT
B.E. ELECTRICAL

LEGENDS:

Mounting Height	No.	1 D	Symbol	Description
CEILING		FAN/48"		CEILING FAN 48"
CEILING		FAN/30"		CEILING FAN 30"
CEILING		FB		FAN BOX
CEILING		CHI		CHANDELIER
+90"		TL/W		LED WALL TUBE LIGHT MAKE:- SYSKA LED CAT NO.- SSK-T5-20W
+90"		BULB		LED BULB 20W MAKE:- SYSKA LED CAT NO.- SKC-20W 5.7K/3K
+90"		GL		WALL BRACKETS AS DESIGN FOR GANESH LIGHT
+78"		ML		12X2 LED MIRROR LIGHT MAKE:- SYSKA LED CAT NO.- FPL-12X2
CEILING		DL		LED 6" DOWN LIGHTER 20W (SURFACE MOUNTED) MAKE:- SYSKA LED CAT NO.- SDL-15W GLD 6.5K/4K
VENTILATOR HT.		CR		CEILING ROSE
VENTILATOR HT.		EXF		9" DIA EXHAUST FAN
+42"		SB		SWITCH BOARD
+24"		TEL		TELEPHONE POINT
+24"		LP TEL		6A PLUG POINT FOR TELEPHONE
+48"		TV		TV COAXIAL POINT
+48"		LP TV		6A PLUG POINT FOR TV
+24"		LP		6A PLUG POINT FOR SIDE TABLE
+36"		LP		6A PLUG POINT FOR STUDY TABLE
+72"		LP-CH		6A PLUG POINT FOR CHIMNEY
+42"		PP-MIX		16 A POWER POINT FOR MIXER
+42"		PP-MIC		16 A POWER POINT FOR MICROWAVE
+78"		PP-G		16 A POWER POINT FOR GEYSER
+54"		PP-F		16 A POWER POINT FOR FRIDGE
+78"		PP-WP		16 A POWER POINT FOR WATER PURIFIER
+48"		PP-WM		16 A POWER POINT FOR WASHING MACHINE
+12"		PP-INV.		16 A POWER POINT FOR INVERTOR
+60"		BP		6 A BELL PUSH
+90"		BZ		BUZZER FOR CALL BELL
+60"		MCB DB		MCB DISTRIBUTION BOARD

SERVICES CONSULTANT:
ASHI ASSOCIATES
F 9 / 440 , Keshav Marg Chitrakut Scheme,Jaipur
PH:91-0-93146-10438 ,0141-2440946 Mail:vipul8599@yahoo.com

ARCHITECTS:-

SPACE GRID
C-49,VIDYA
APARTMENT,PARAS MARG,
BAPU NAGAR,NEAR JANTA
STORE CIRCLE, JAIPUR-302015
PH-09314918766,0141-4005506 (O)
Email:-info.spacegrid@gmail.com

PROJECT NAME:-

FRANKFURT BY R. R. HOMES

FIRM:-

RAJ RAJESHWARI
REAL ESTATES LLP

PROJECT ADDRESS:-

PROPOSED RESIDENTIAL
BUILDING AT PLOT NO. 05, "R R
HOMES KANAKPURA-III", JAIPUR

DRAWING:-

TYPICAL 1ST TO 5TH FLOOR
ELECTRICAL POINT
MARKED PLAN

SCALE:-


1:100


DATE:-

28-08-2024

REV.:-

00

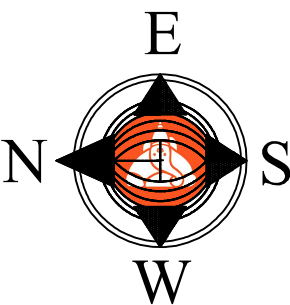

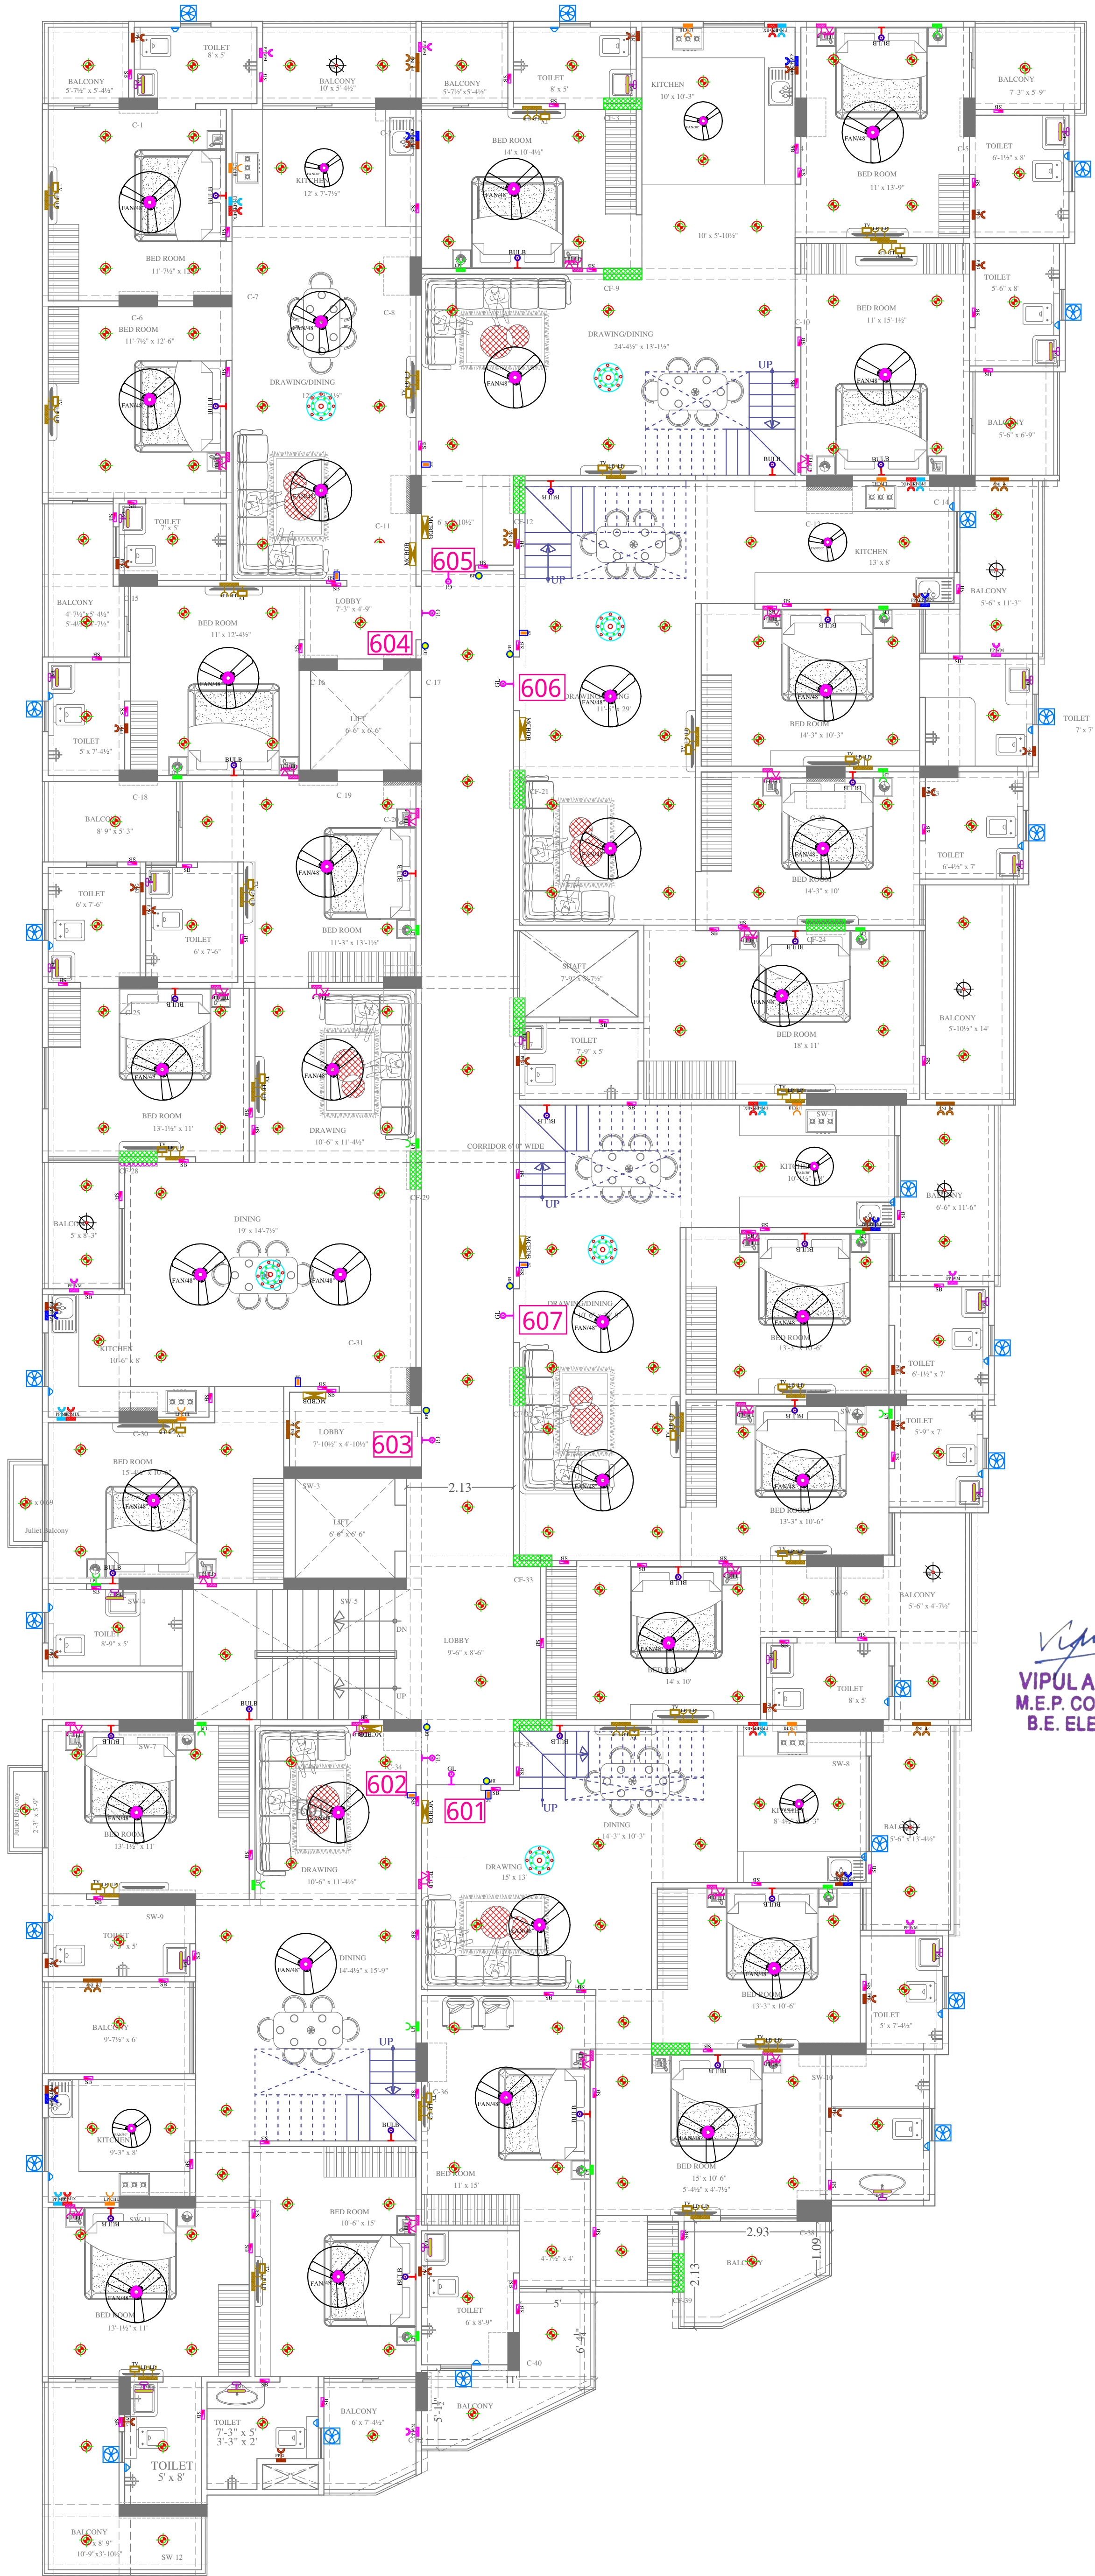

Vipul
VIPUL AGARWAL
M.E.P. CONSULTANT
B.E. ELECTRICAL

LEGENDS:				
Mounting Height	No.	I D	Symbol	Description
CEILING		FAN/48"		CEILING FAN 48"
CEILING		FAN/30"		CEILING FAN 30"
CEILING		FB		FAN BOX
CEILING		CH1		CHANDELIER
+90"		TL/W		LED WALL TUBE LIGHT MAKE:- SYSKA LED CAT NO.- SSK-T5-20W
+90"		BULB		LED BULB 20W MAKE:- SYSKA LED CAT NO.- SSK-20W 5.7K/3K
+90"		GL		WALL BRACKETS AS DESIGN FOR GANESH LIGHT
+78"		ML		12X2 LED MIRROR LIGHT MAKE:- SYSKA LED CAT NO.- FPL-12X2
CEILING		DL		LED 6" DOWN LIGHTER 20W (SURFACE MOUNTED) MAKE:- SYSKA LED CAT NO.- SDL-15W GLD 6.5K/4K
VENTILATOR HT.		CR		CEILING ROSE
VENTILATOR HT.		EXP		9" DIA EXHAUST FAN
+42"		SB		SWITCH BOARD
+24"		TEL		TELEPHONE POINT
+24"		LP TEL		6A PLUG POINT FOR TELEPHONE
+48"		TV		TV COAXIAL POINT
+48"		LP TV		6A PLUG POINT FOR TV
+24"		LP		6A PLUG POINT FOR SIDE TABLE
+36"		LP		6A PLUG POINT FOR STUDY TABLE
+72"		LP-CH		6A PLUG POINT FOR CHIMNEY
+42"		PP-MIX		16 A POWER POINT FOR MIXER
+42"		PP-MIC		16 A POWER POINT FOR MICROWAVE
+78"		PP-G		16 A POWER POINT FOR GEYSER
+54"		PP-F		16 A POWER POINT FOR FRIDGE
+78"		PP-WP		16 A POWER POINT FOR WATER PURIFIER
+48"		PP-WM		16 A POWER POINT FOR WASHING MACHINE
+12"		PP-INV.		16 A POWER POINT FOR INVERTOR
+60"		BP		6 A BELL PUSH
+90"		BZ		BUZZER FOR CALL BELL
+60"		MCB DB		MCB DISTRIBUTION BOARD

SERVICES CONSULTANT:
ASHI ASSOCIATES
F 9 / 440 , Keshav Marg Chitrakut Scheme,Jaipur
PH:91-0-93146-10438 ,0141-2440946 Mail:vipul8599@yahoo.com

ARCHITECTS:-

SPACE GRID
C-49,VIDYA
APARTMENT,PARAS MARG,
BAPU NAGAR,NEAR JANTA
STORE CIRCLE, JAIPUR-302015
PH-09314918766,0141-4005506 (O)
Email:-info.spacegrid@gmail.com


PROJECT NAME:-
FRANKFURT BY R. R. HOMES

FIRM:-
**RAJ RAJESHWARI
REAL ESTATES LLP**

PROJECT ADDRESS:-
**PROPOSED RESIDENTIAL
BUILDING AT PLOT NO. 05, "R R
HOMES KANAKPURA-III", JAIPUR**

DRAWING:-
**6TH FLOOR
ELECTRICAL POINT
MARKED PLAN**

SCALE:-		
1:100		
DATE:-	28-08-2024	
REV.:-	00	

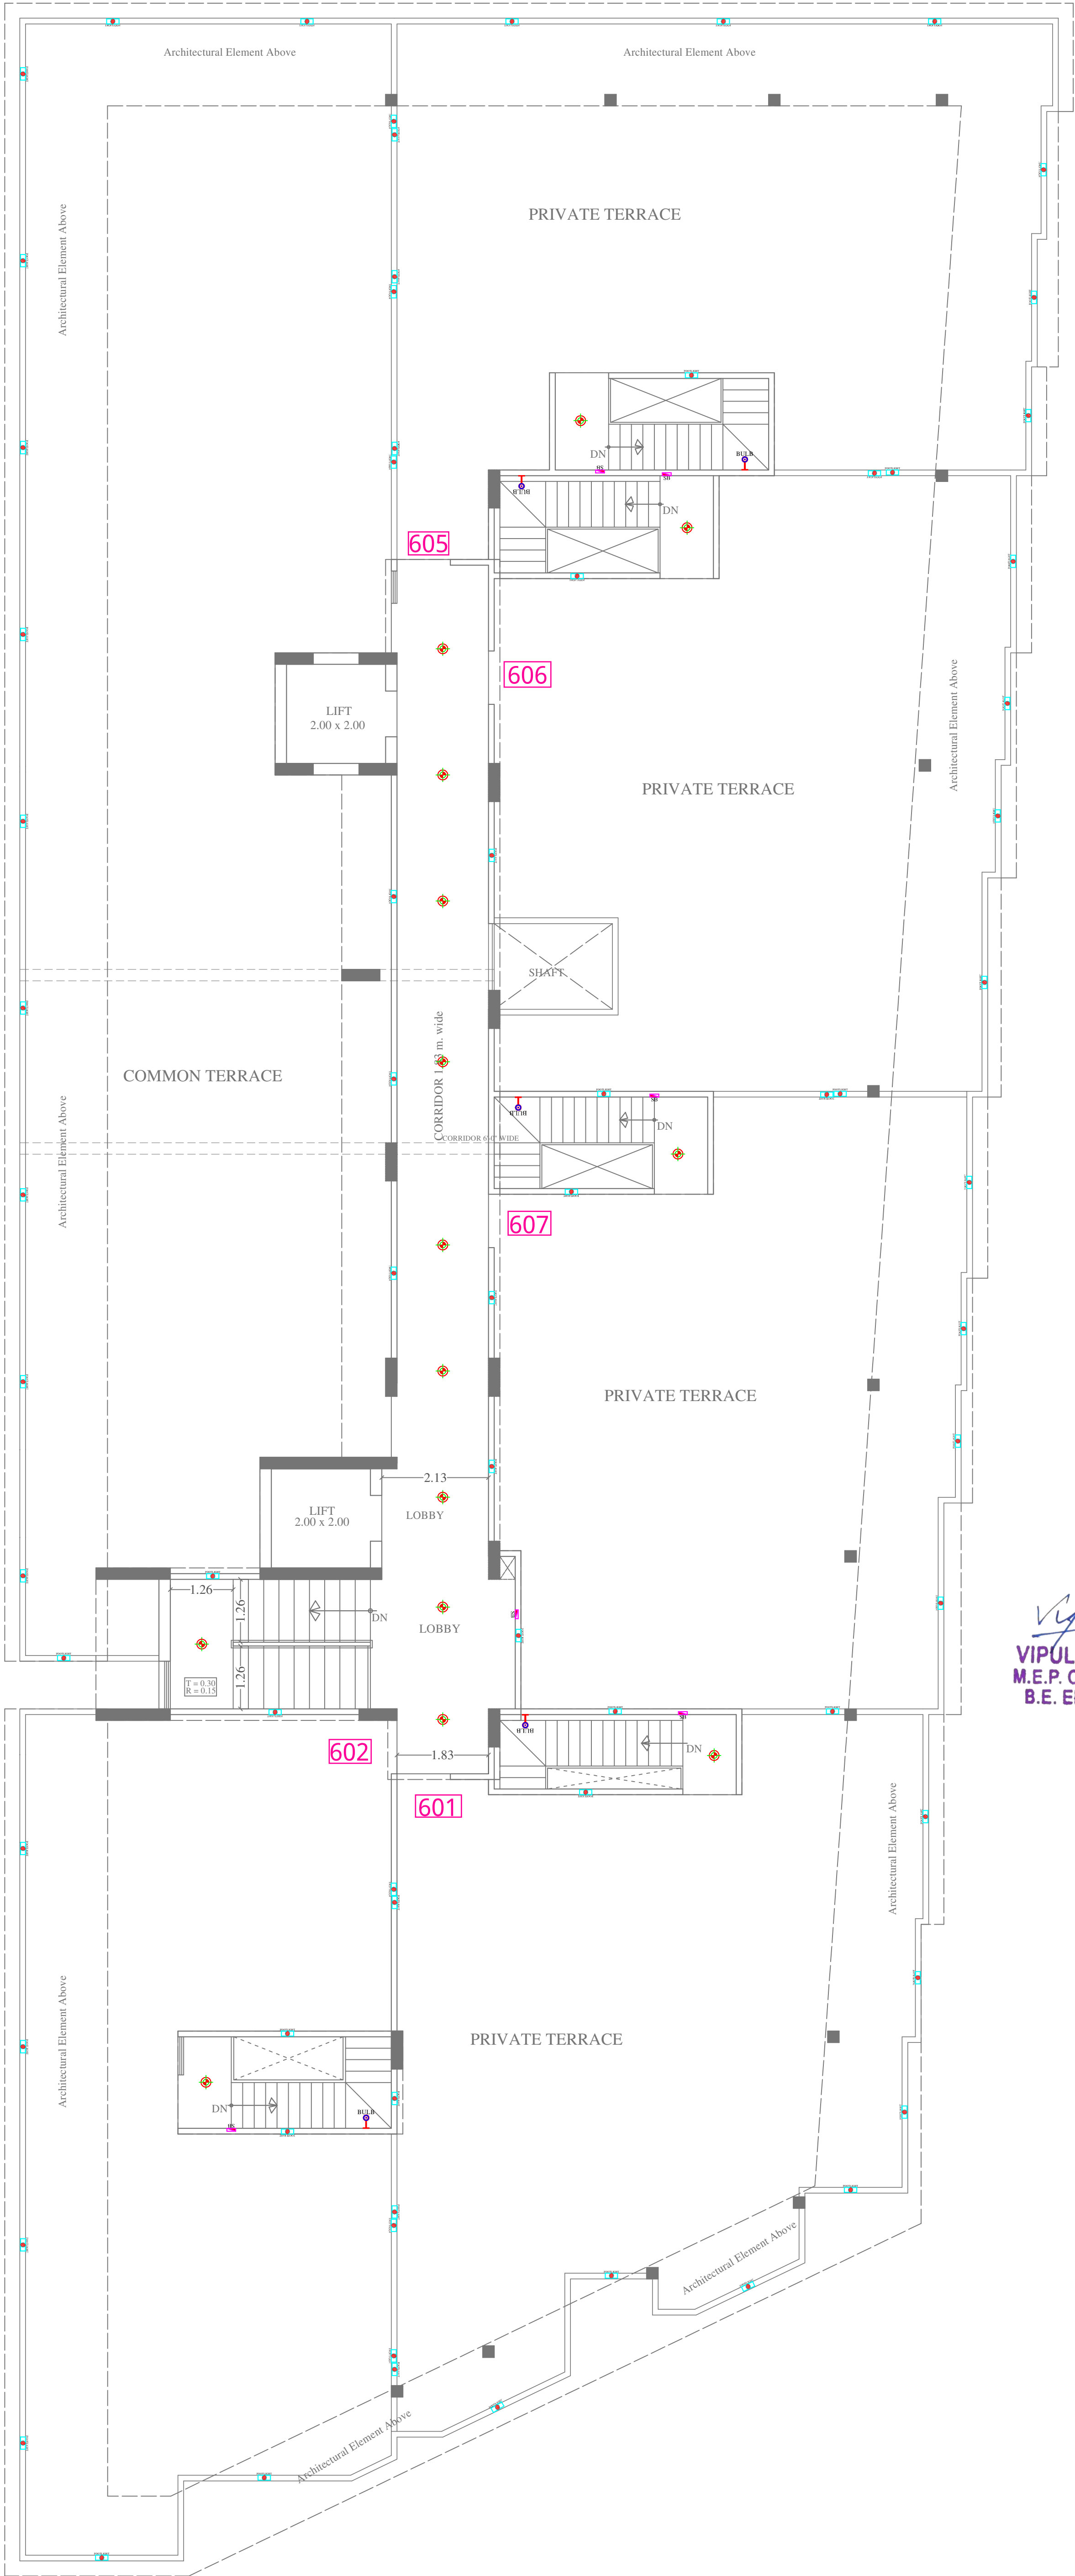

Vipul
VIPUL AGARWAL
M.E.P. CONSULTANT
B.E. ELECTRICAL

LEGENDS:

Mounting Height	No.	ID	Symbol	Description
+90"		BULB		LED BULB 20W MAKE:- SYSKA LED CAT NO. SKC-20W 5.7K/3K
CEILING		DL		LED 6" DOWN LIGHTER 20W (SURFACE MOUNTED) MAKE:- SYSKA LED CAT NO:- SDL-15W GLD 6.5K/4K
+90"		TL/W		Led Wall Tube Light Make:- Syska Led Cat no:- SSK-T5-20W
+18"		FL		FOOT LIGHT
+42"		SB		SWITCH BOARD

SERVICES CONSULTANT:
ASHI ASSOCIATES
F 9 / 440 , Keshav Marg Chitrakut Scheme,Jaipur
PH:91-0-93146-10438 ,0141-2440946 Mail:vipul8399@yahoo.com

ARCHITECTS:-
SPACE GRID
C-49,VIDYA
APARTMENT,PARAS MARG,
BAPU NAGAR,NEAR JANTA
STORE CIRCLE, JAIPUR-302015
PH-09314918766,0141-4005506 (O)
Email:-info.spacegrid@gmail.com

PROJECT NAME:-
FRANKFURT BY R. R. HOMES

FIRM:-
**RAJ RAJESHWARI
REAL ESTATES LLP**

PROJECT ADDRESS:-
**PROPOSED RESIDENTIAL
BUILDING AT PLOT NO. 05, "R R
HOMES KANAKPURA-III", JAIPUR**

DRAWING:-
**TERRACE FLOOR
ELECTRICAL POINT
MARKED PLAN**

SCALE:- 1:100	
DATE:- 28-08-2024	
REV.:- 00	