
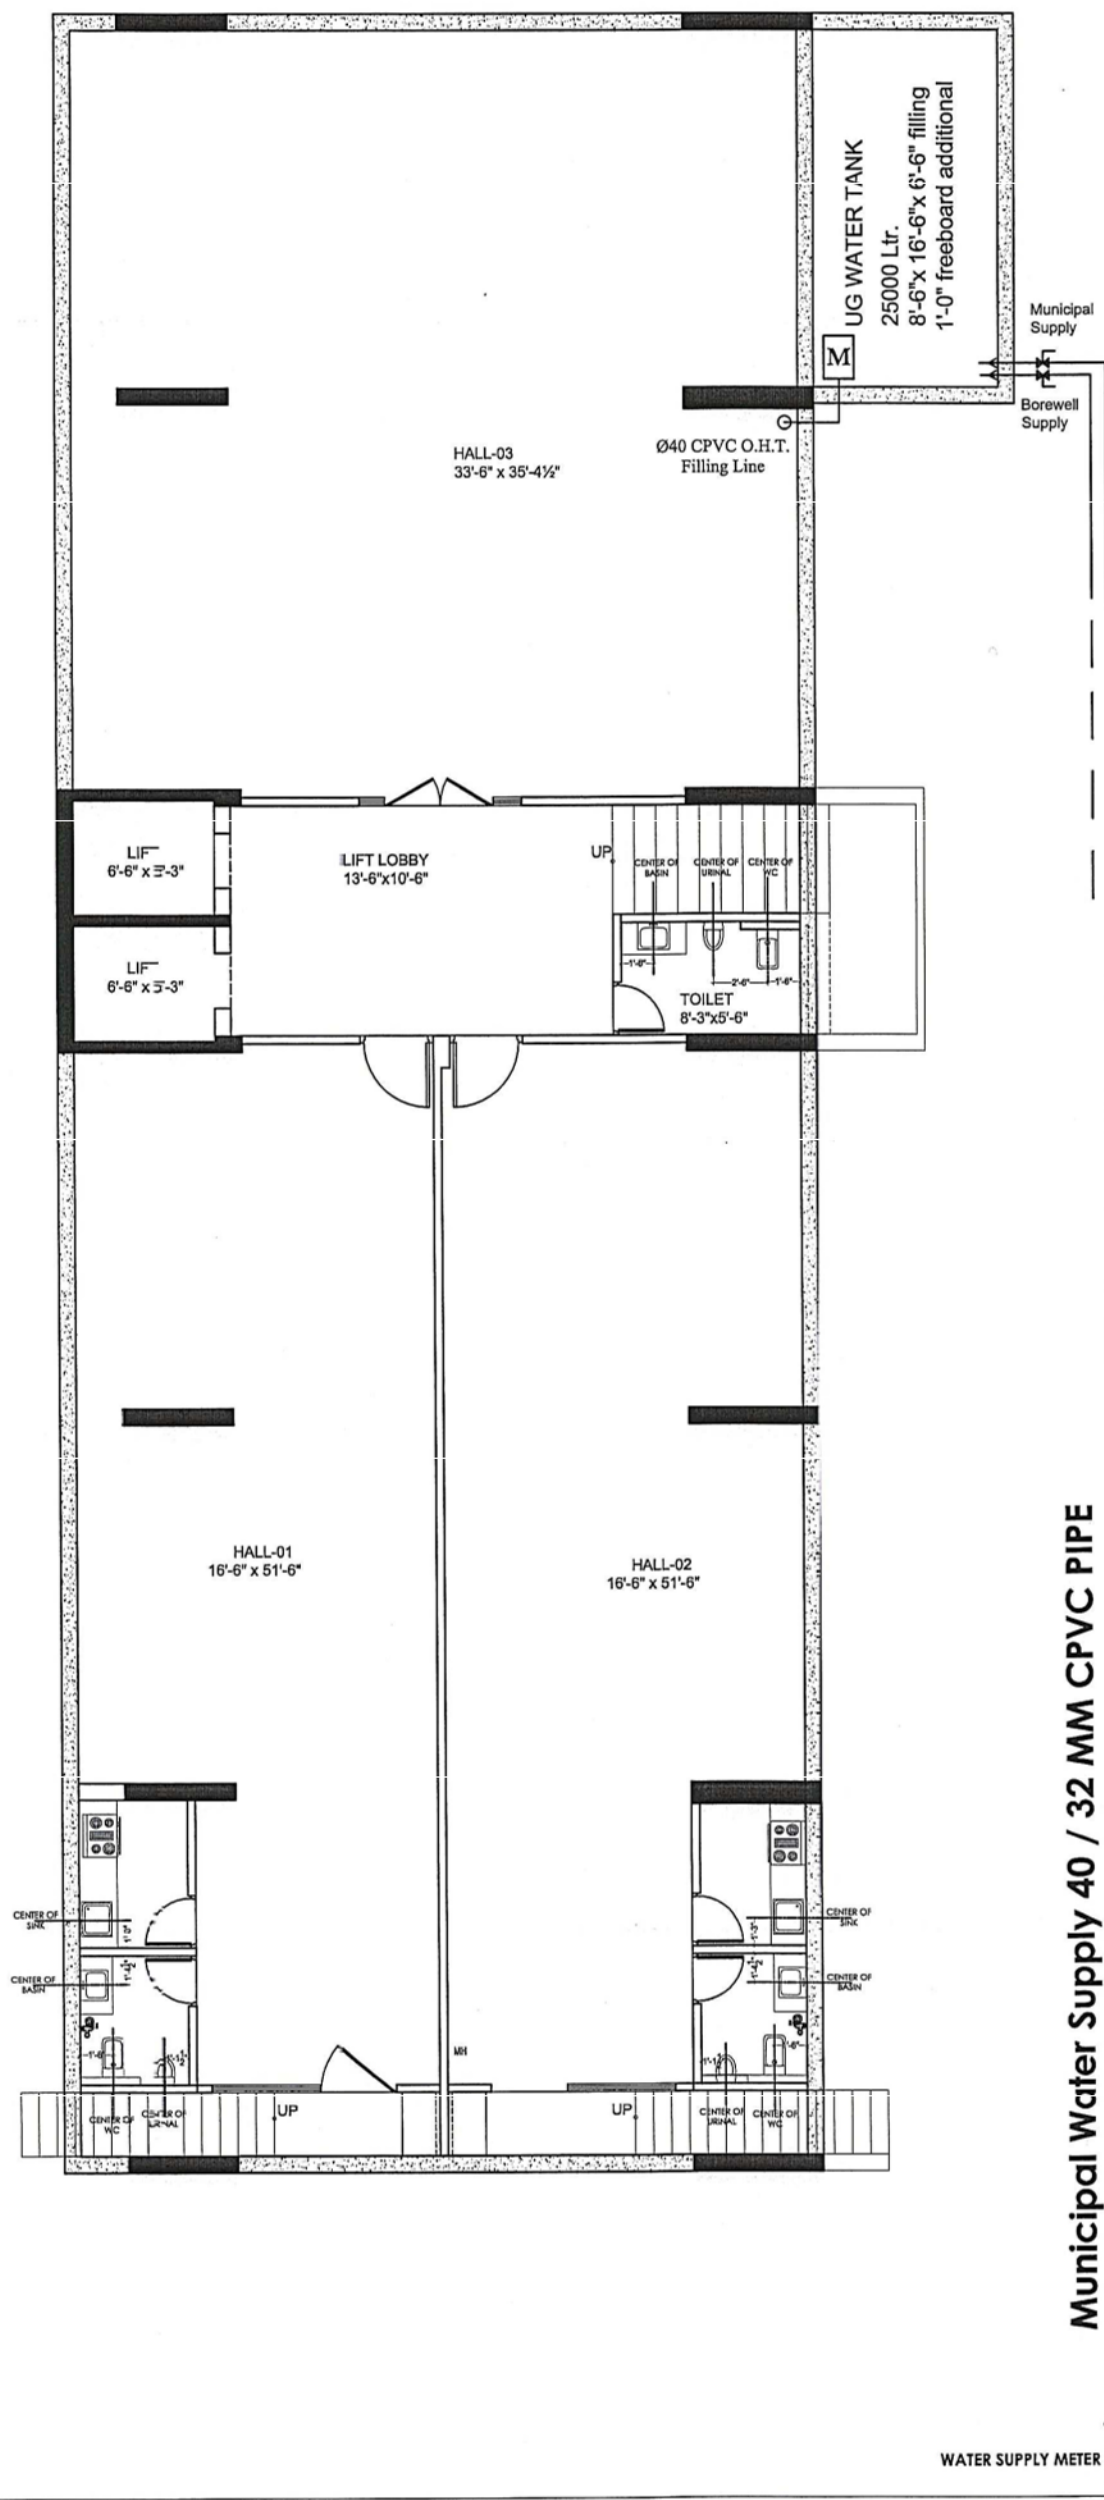


"PEARL ROYAL" ,
PLOT NO. D-231-B, TULSI MARG, BANI PARK, JAIPUR.
PROMOTOR NAME - PEARL INDIA BUILDHOME PVT. LTD.

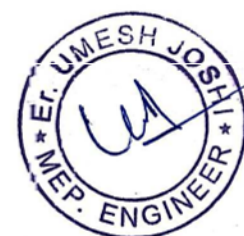

**MAIN WATER SUPPLY
BASEMENT FLOOR
PLUMBING PLAN**

GENERAL NOTES
1. ALL DIMENSIONS ARE IN FEET & INCHES, UNLESS SPECIFIED OTHERWISE.
2. THE DIMENSIONS ARE TO BE READ ONLY AND NOT TO BE MEASURED.
3. ANY DISCREPANCY IN THE DRAWING SHOULD BE BROUGHT IN THE NOTICE OF THE ARCHITECT.


PROJECT
PEARL ROYAL AT BANIPARK

ARCHITECT
DESTYLIO
design style studio

DRAWING
BASEMENT FLOOR WATER SUPPLY PLAN
SH.NO. PLU-1
DATE : 14-10-2022
SCALE: N.T.S.


NOTE
THIS DRAWING IS THE SOLE PROPERTY OF DESTYLIO AND IS NOT TO BE COPIED, USED OR REPRODUCED FOR ANY PURPOSE OTHER THAN FOR WHICH IT HAS BEEN LOANED.

"PEARL ROYAL" ,
PLOT NO. D-231-B, TULSI MARG, BANI PARK, JAIPUR.
PROMOTOR NAME - PEARL INDIA BUILDHOME PVT. LTD.

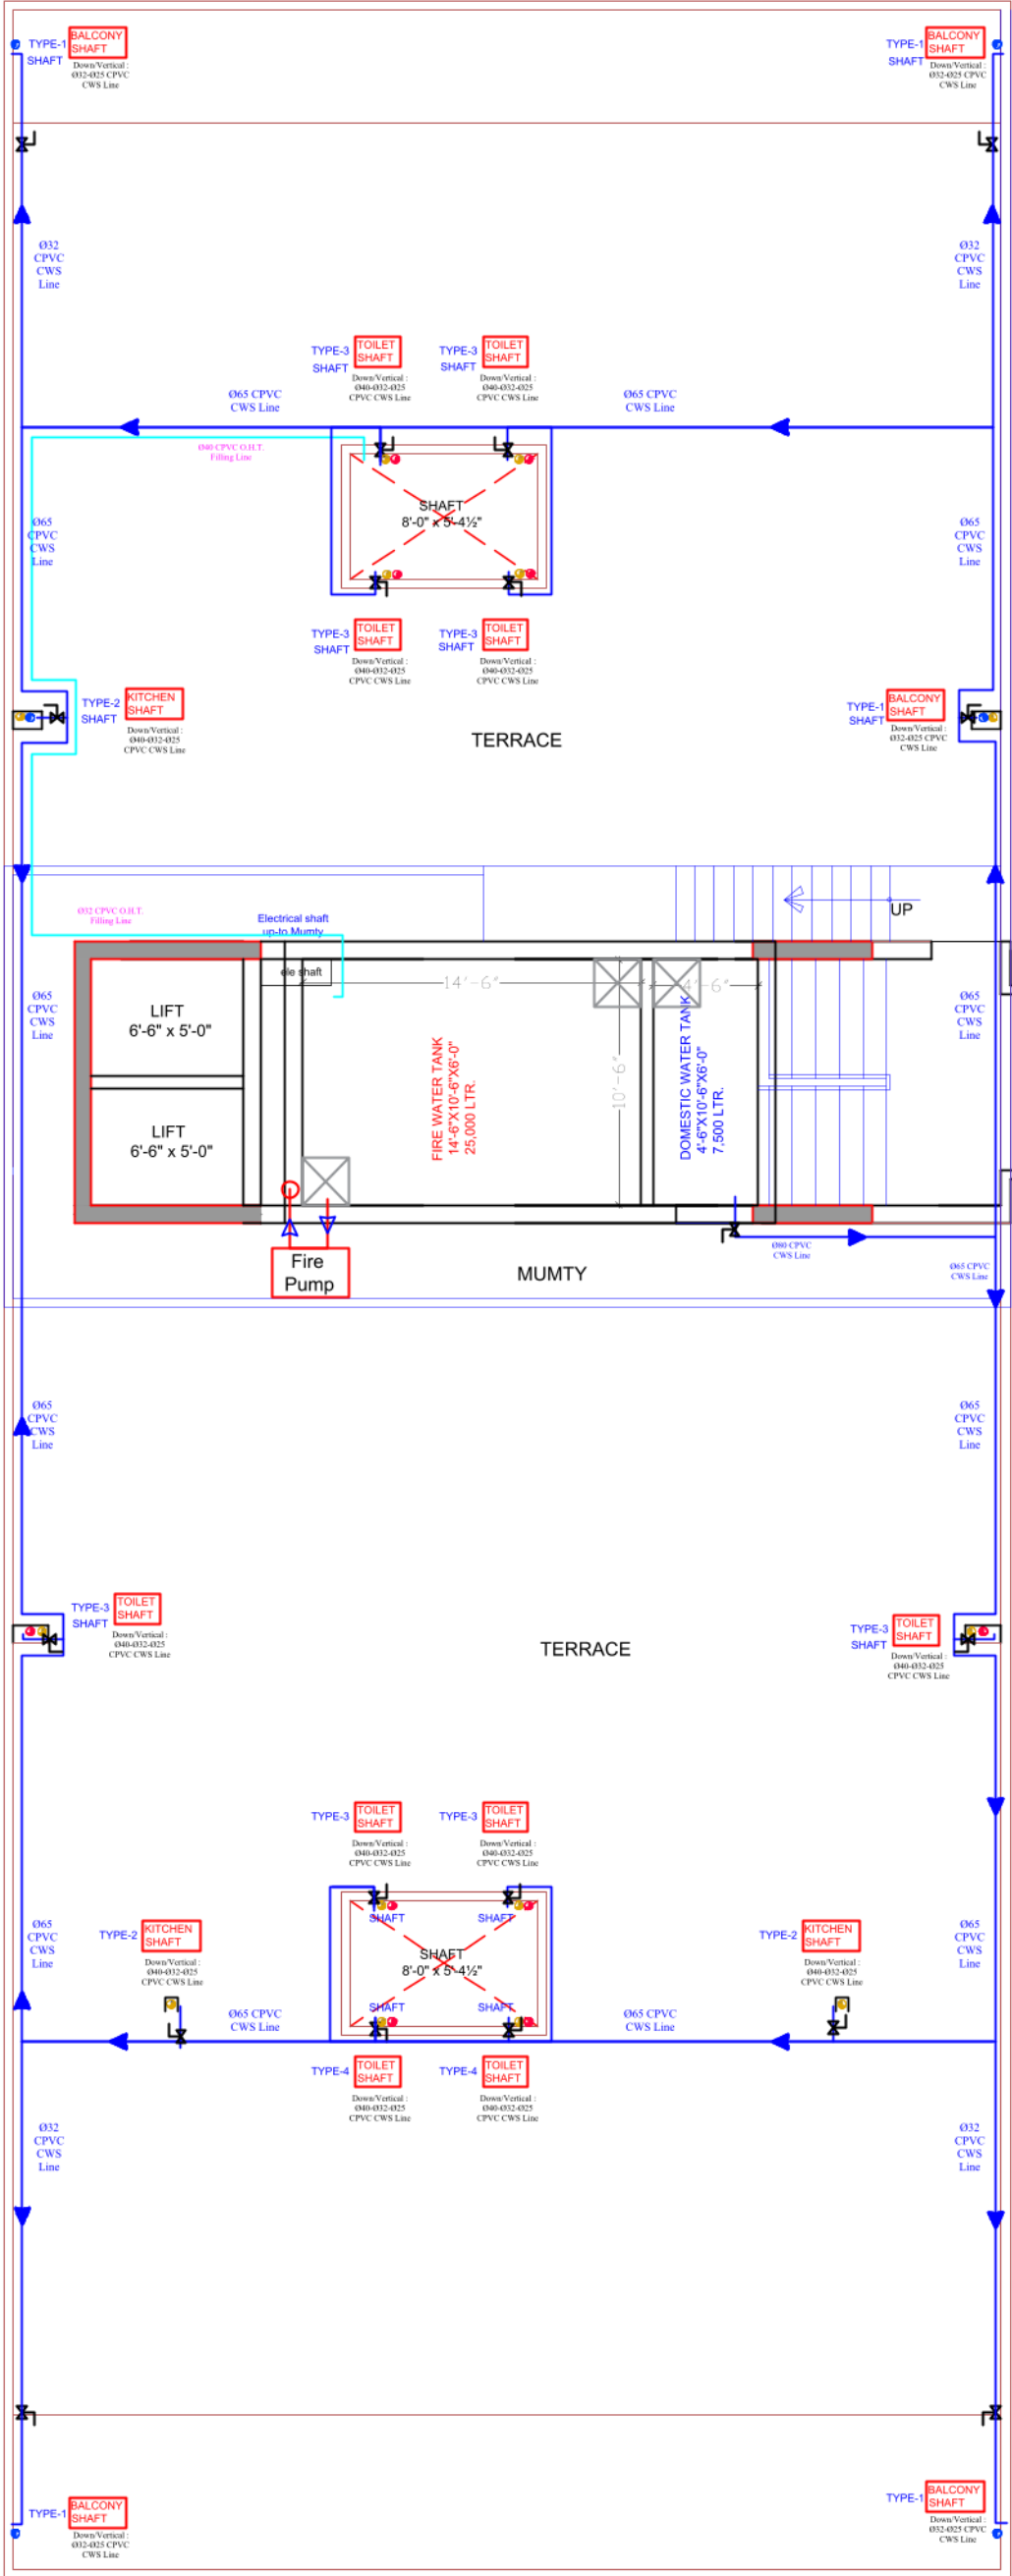

LEGEND:	
SYBLOL	DESCRIPTION
	Water Supply (UG to OHT)
	O.H.T. Water Filling Line - Ø32
	Terrace Water Supply Line (C-PVC) 80 MM & 65 MM LINES (SCH-40 / SCH-80)
	Shaft Water Supply Line (Vertical) Ø40-Ø32-Ø25 CPVC

- NOTE:
- # ALL VERTICAL WATER SUPPLY LINES SHOULD BE REDUCE IN SIZE AS MENTIONED IN DOWN/VERTICAL LINES.
 - # EACH TOILET OR KITCHEN WATER SUPPLY BRANCHES CONSIDER Ø20 WITH BALL / CONCILED VALVE.

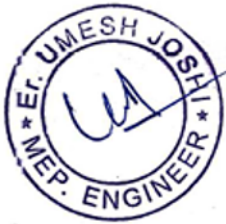

TERRACE WATER SUPPLY
RING LINE PLAN


GENERAL NOTES		ARCHITECT	DRAWING			NOTE
1. ALL DIMENSIONS ARE IN FEET & INCHES, UNLESS SPECIFIED OTHERWISE. 2. THE DIMENSIONS ARE TO BE READ ONLY AND NOT TO BE MEASURED. 3. ANY DISCREPANCY IN THE DRAWING SHOULD BE BROUGHT IN THE NOTICE OF THE ARCHITECT.	PEARL ROYAL AT BANIPARK	DESTYLIO design style studio	TERRACE WATER SUPPLY RING LINE PLAN			THIS DRAWING IS THE SOLE PROPERTY OF DESTYLIO AND IS NOT TO BE COPIED, USED, OR REPRODUCED FOR ANY PURPOSE OTHER THAN FOR WHICH IT HAS BEEN LOANED.
			SH.NO. F-1	DATE : 10-10-2022		
			SCALE: N.T.S.			

"PEARL ROYAL",
PLOT NO. D-231-B, TULSI MARG, BANI PARK, JAIPUR.
PROMOTOR NAME - PEARL INDIA BUILDHOME PVT. LTD.



- NOTE:
- # ALL VERTICAL WATER SUPPLY LINES SHOULD BE REDUCE IN SIZE AS MENTIONED IN DOWN/VERTICAL LINES.
 - # EACH TOILET OR KITCHEN WATER SUPPLY BRANCHES CONSIDER Ø20 WITH BALL / CONCILED VALVE.

WATER SUPPLY SLD

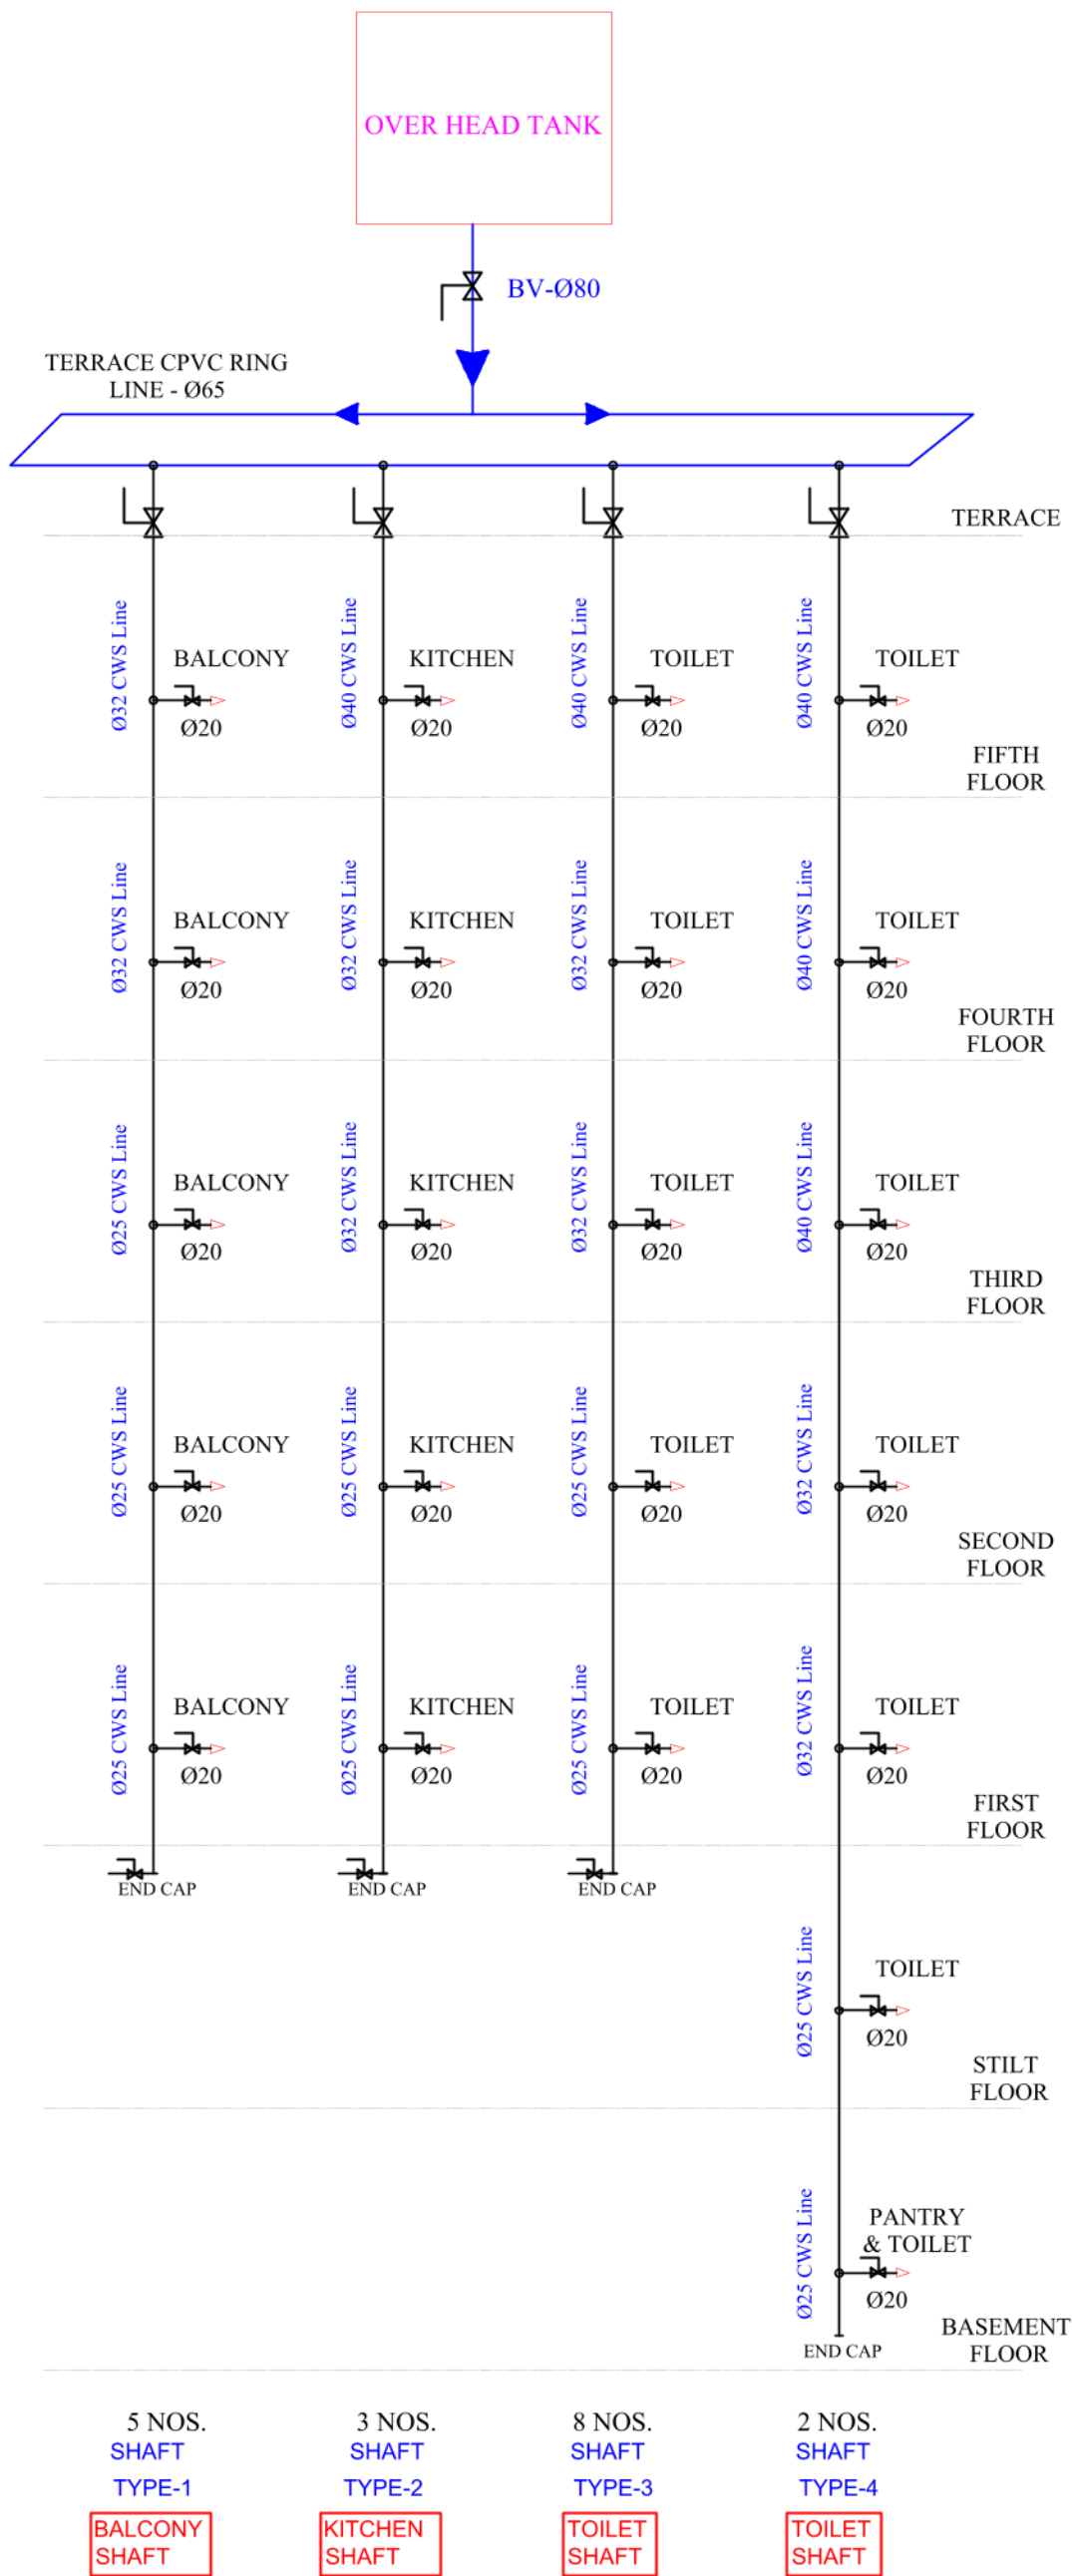

GENERAL NOTES		ARCHITECT	DRAWING			NOTE
1. ALL DIMENSIONS ARE IN FEET & INCHES, UNLESS SPECIFIED OTHERWISE. 2. THE DIMENSIONS ARE TO BE READ ONLY AND NOT TO BE MEASURED. 3. ANY DISCRIPANCY IN THE DRAWING SHOULD BE BROUGHT IN THE NOTICE OF THE ARCHITECT.	PEARL ROYAL AT BANIPARK	<div>DESTYLIO</div> <div>design style studio</div>	WATER SUPPLY SLD			THIS DRAWING IS THE SOLE PROPERTY OF DESTYLIO AND IS NOT TO BE COPIED, USED OR REPRODUCED FOR ANY PURPOSE OTHER THAN FOR WHICH IT HAS BEEN LOANED.
			SH.NO. F-1	DATE : 10-10-2022		
				SCALE: N.T.S.		