



For SOMYA BUILDHOME LLP
HONORARY PARTNER
Designated Partner

Vipul
VIPUL AGARWAL
M.E.P. CONSULTANT
B.E. ELECTRICAL


DRG. TITLE :-
**BASEMENT FLOOR
MAIN DISTRIBUTION PANEL
MARKED & ELECTRIC CABLE
TRAY ROUTE PLAN**


DRN. BY:- VIJESH/PAWAN	SCALE:-
CHKD. BY:- SANJAY	DATE:- 09-10-2024
APPD. BY:- VIPUL AGARWAL	REV.:- 01

SERVICE CONSULTANT
ASHI ASSOCIATES
F 9 / 440 , Keshav Marg Chitrakut Scheme,Jaipur
PH:91-0-93146-10438 ,0141-2440946, Mail:vipul8599@yahoo.com

PROJECT NAME :-
SOMYA SKY ELITE
PROMOTER NAME :-
SOMYA BUILDHOME LLP

PROJECT :-
PROPOSED RESIDENTIAL BUILDING AT
KHA. NO. 116, 515/474 PART OF 474/ 115 AT,
VILL.- MURLIPURA, TEH.-SANGANER,
JAIPUR

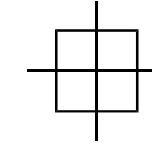ARCHITECT :-
**SPACE GRID**
C-49,VIDYA APARTMENT,PARAS MARG,
BAPU NAGAR,NEAR JANTA STORE
CIRCLE, JAIPUR-302015
PH-09314918766,0141-4005506 (O)
Email:-info.spacegrid@gmail.com

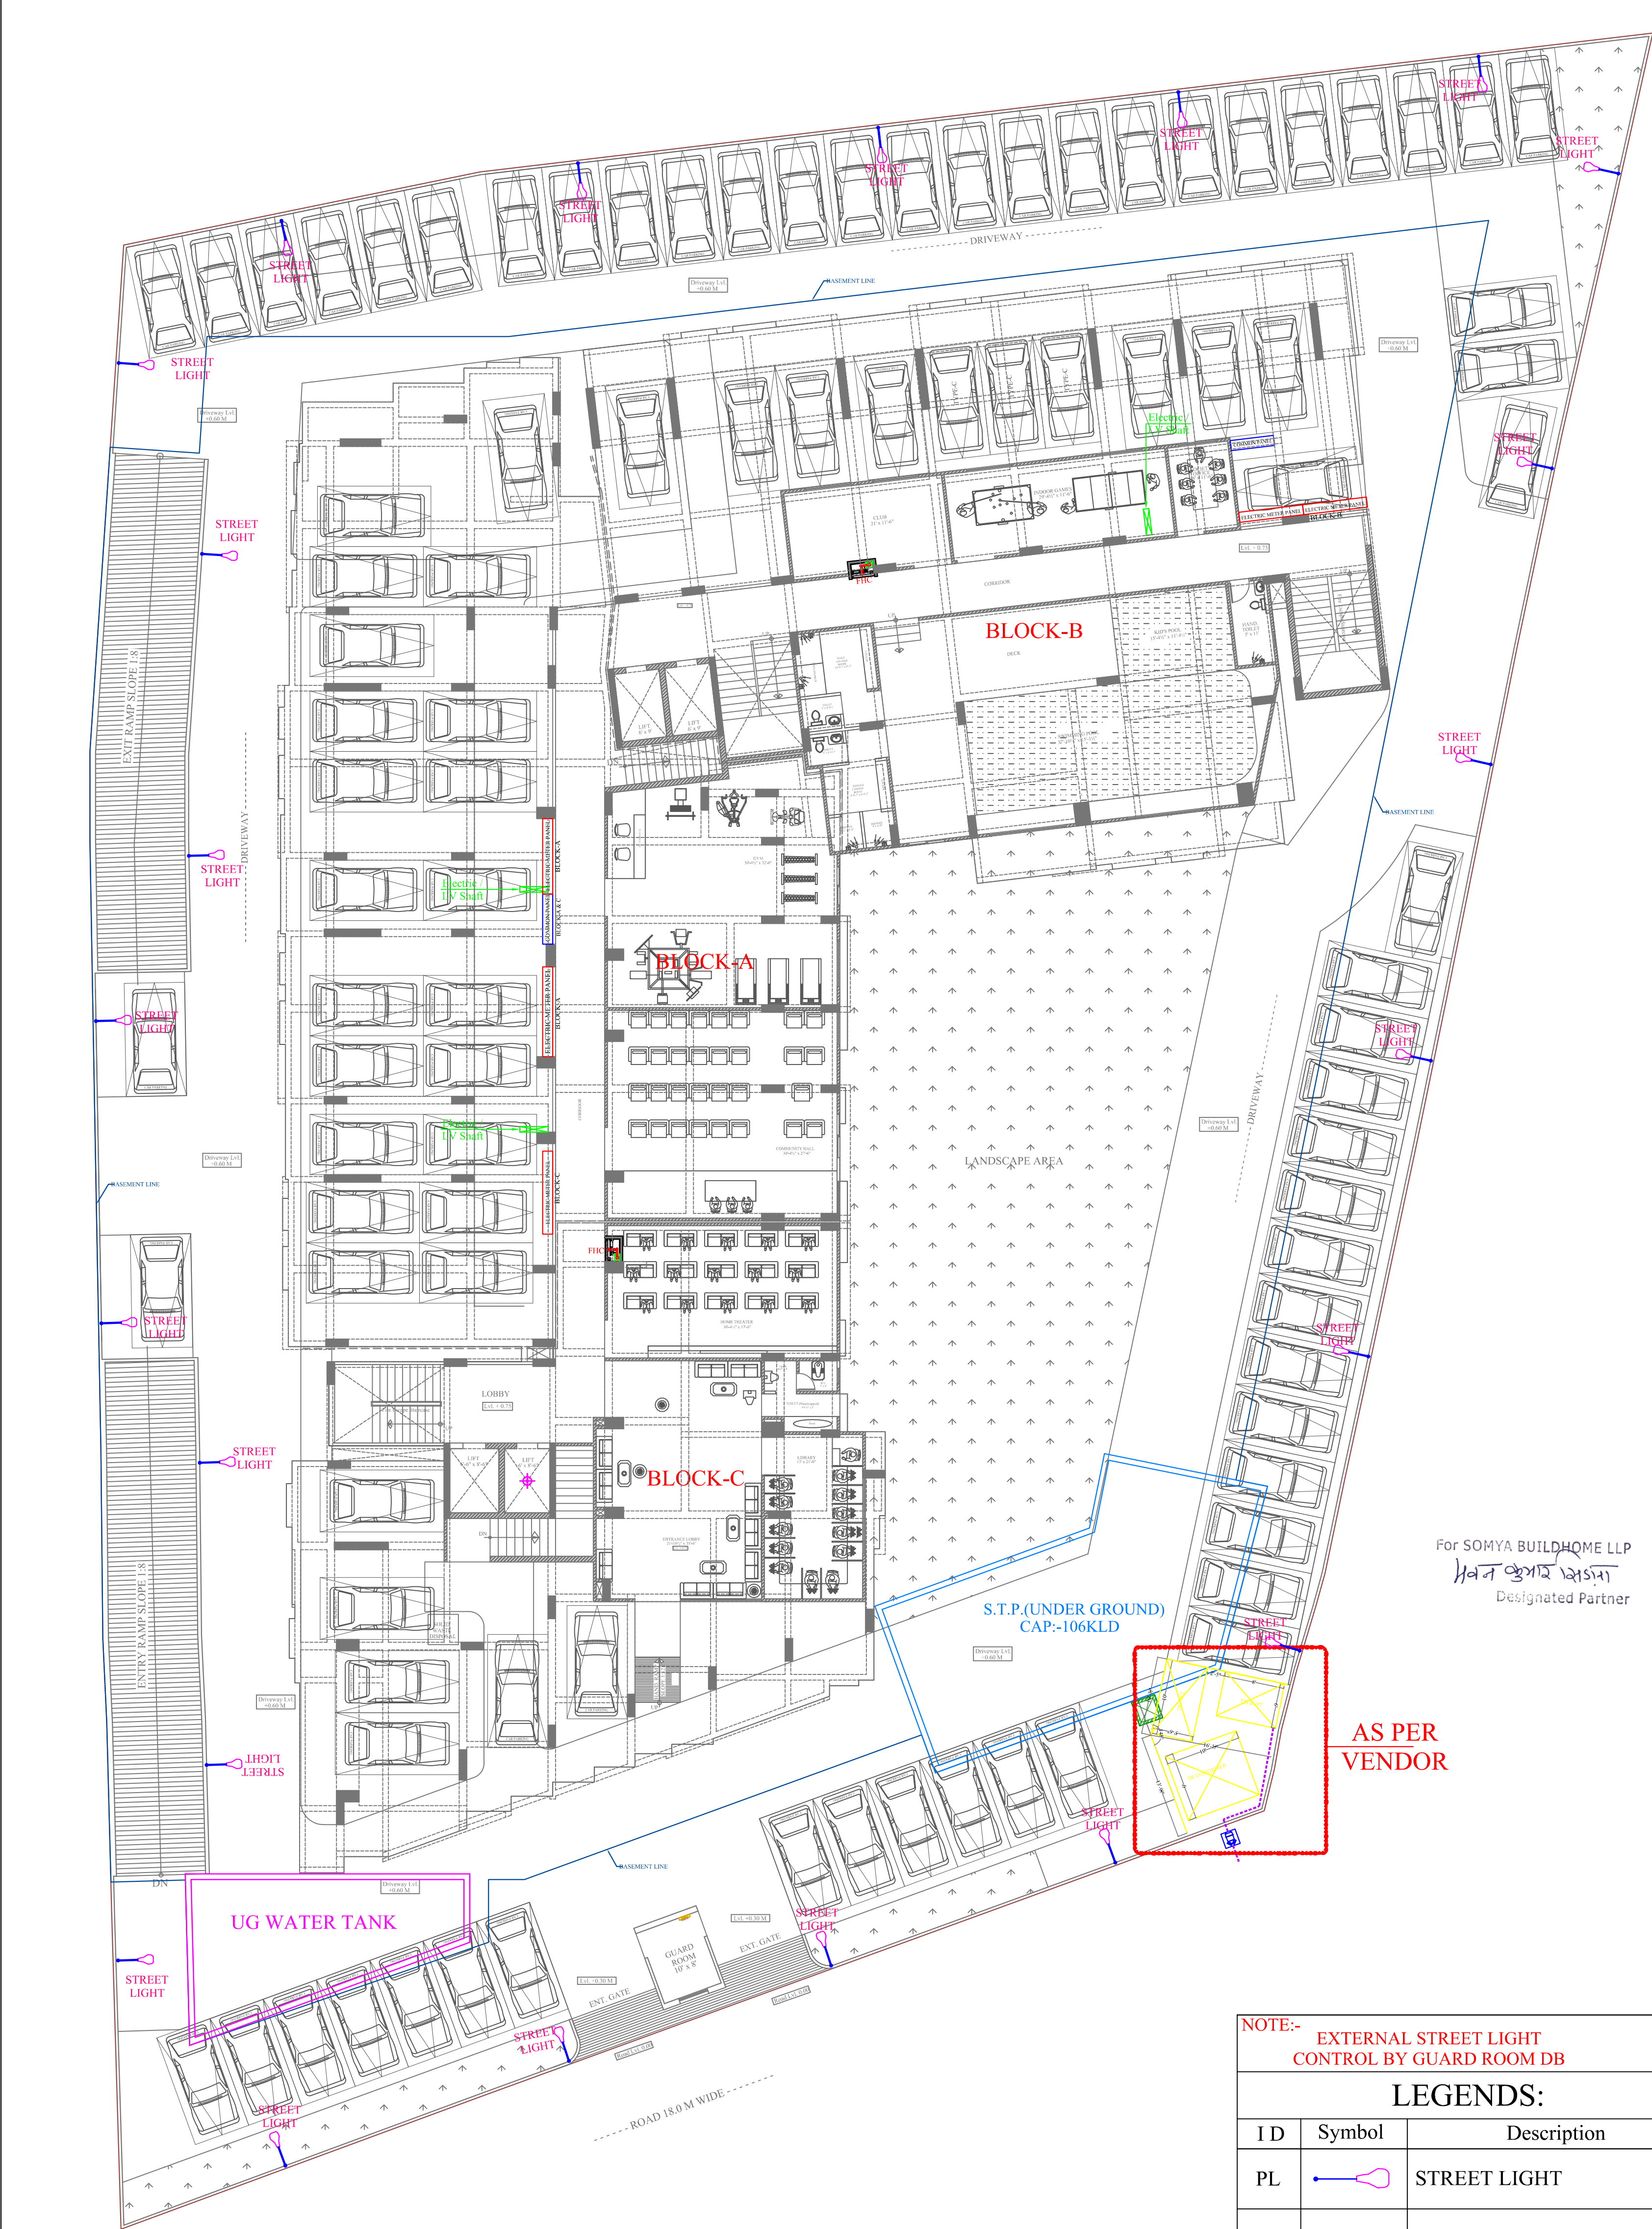

For SOMYA BUILDHOME LLP
Hवन कुमार अस्थाना
Designated Partner

NOTE:-
EXTERNAL STREET LIGHT
CONTROL BY GUARD ROOM DB

LEGENDS:

I D	Symbol	Description
PL		STREET LIGHT
DB		MCB DISTRIBUTION BOARD

Vipul
VIPUL AGARWAL
M.E.P. CONSULTANT
B.E. ELECTRICAL

DRG. TITLE :-

EXTERNAL STREET
LIGHTING PLAN

DRN. BY:-	SCALE:-
CHKD. BY:-	DATE:-
APPD. BY:-	REV.:-
VIPUL AGARWAL	01

SERVICE CONSULTANT

ASHI ASSOCIATES

F 9 / 440 , Keshav Marg Chitrakut Scheme,Jaipur
PH:91-0-93146-10438 ,0141-2440946, Mail:vipul8599@yahoo.com

PROJECT NAME :
SOMYA SKY ELITE

PROMOTER NAME :
SOMYA BUILDHOME LLP




PROJECT :-

PROPOSED RESIDENTIAL BUILDING AT
KHA. NO. 116, 515/474 PART OF 474/ 115 AT,
VILL.- MURLIPURA, TEH.-SANGANER,
JAIPUR

ARCHITECT :-

SPACE GRID

C-49,VIDYA APARTMENT,PARAS MARG,
BAPU NAGAR,NEAR JANTA STORE
CIRCLE, JAIPUR-302015
PH-09314918766,0141-4005506 (O)
Email:-info.spacegrid@gmail.com

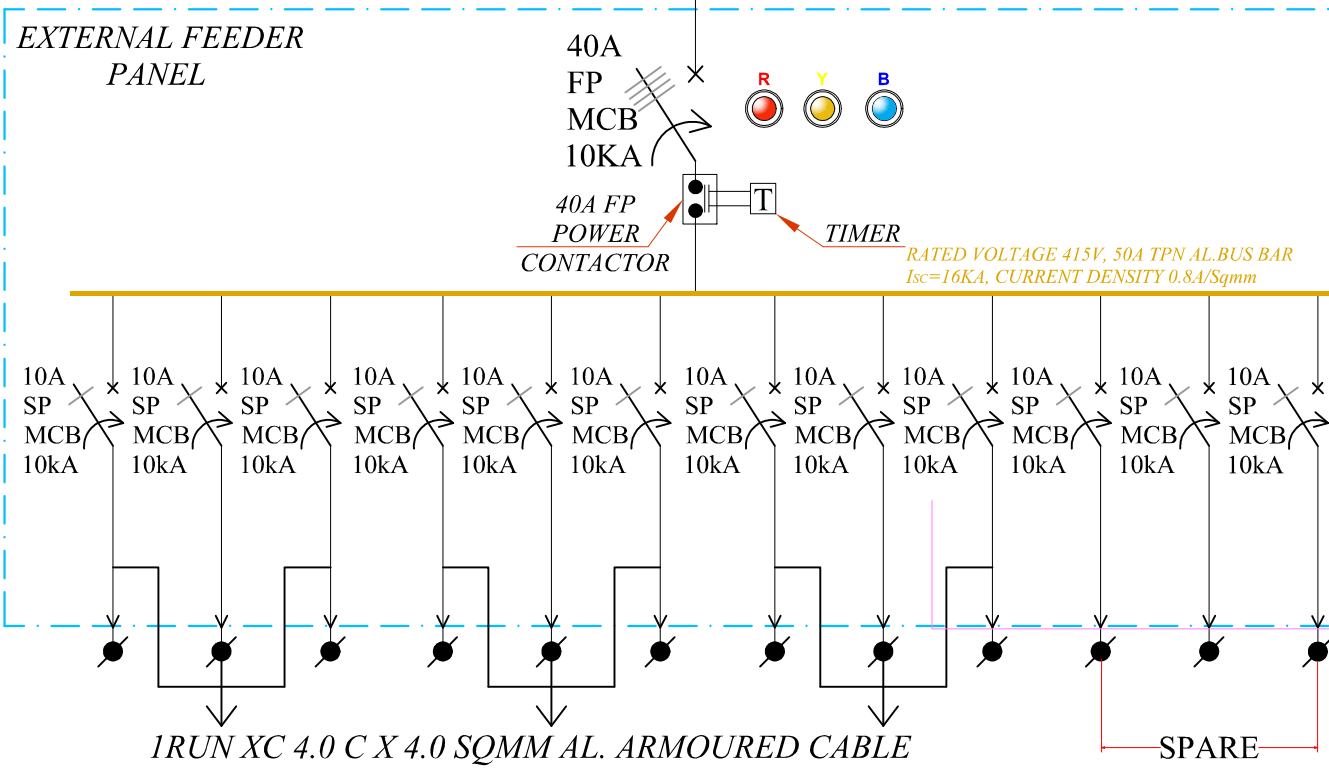
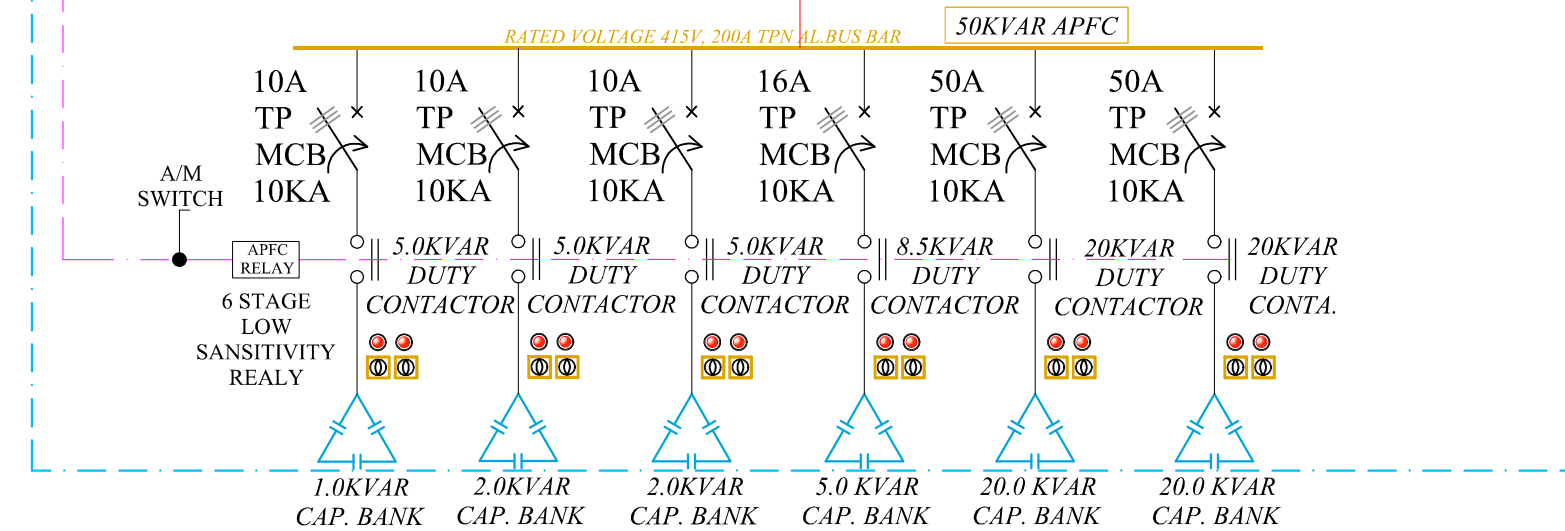
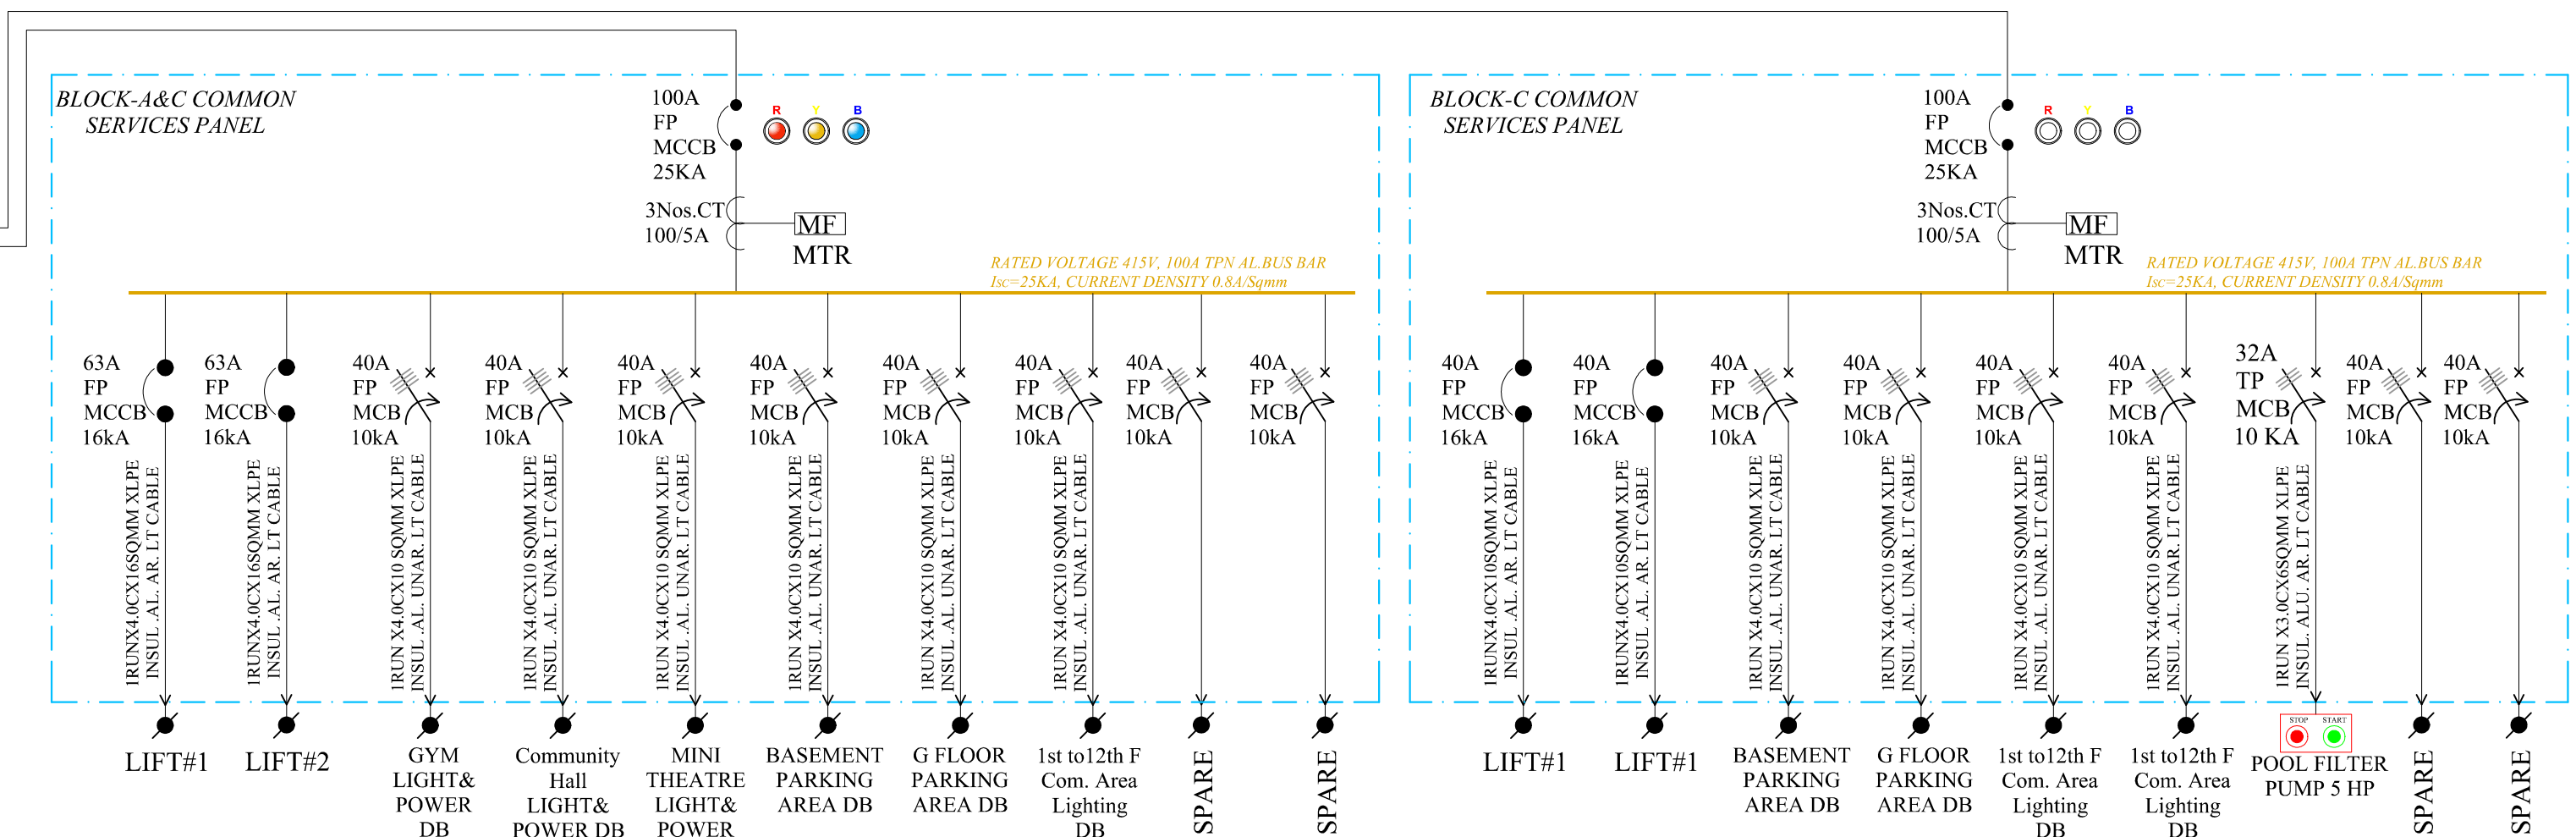


NOTE:-

THIS SLD HAS BEEN PREPARED AS PER CONCEPT
STAGE DATA AVAILABLE WITH US. KINDLY
CONTACT US FOR FINAL SLD & DETAILS BEFORE
PLACING ORDER FOR FABRICATION. WE SHALL NOT
BE RESPONSIBLE, IF THE PANELS ARE UNDER
UTILISED OR OVER LOADED AT ANY STAGE.

VIPUL AGARWAL
M.E.P. CONSULTANT
B.E. ELECTRICAL

MEP CONSULTANT: ASHI ASSOCIATES F 9-440, KESHAV MARG, CHITRAKUT SCHEME, JAIPUR PH-93146-10438, 2440946 E MAIL-vipul8599@yahoo.com	
PROJECT NAME : SOMYA SKY ELITE	
PROMOTER NAME : SOMYA BUILDHOME LLP	
TITLE: MAIN DISTRIBUTION PANELS <i>00</i>	
DRAWING: SINGLE LINE DIAGRAM	
DATE:- 04-11-2023	REV:-
DRAWN BY:- VICKY YADAV	
CHECKED BY:- VIPUL AGARWAL	

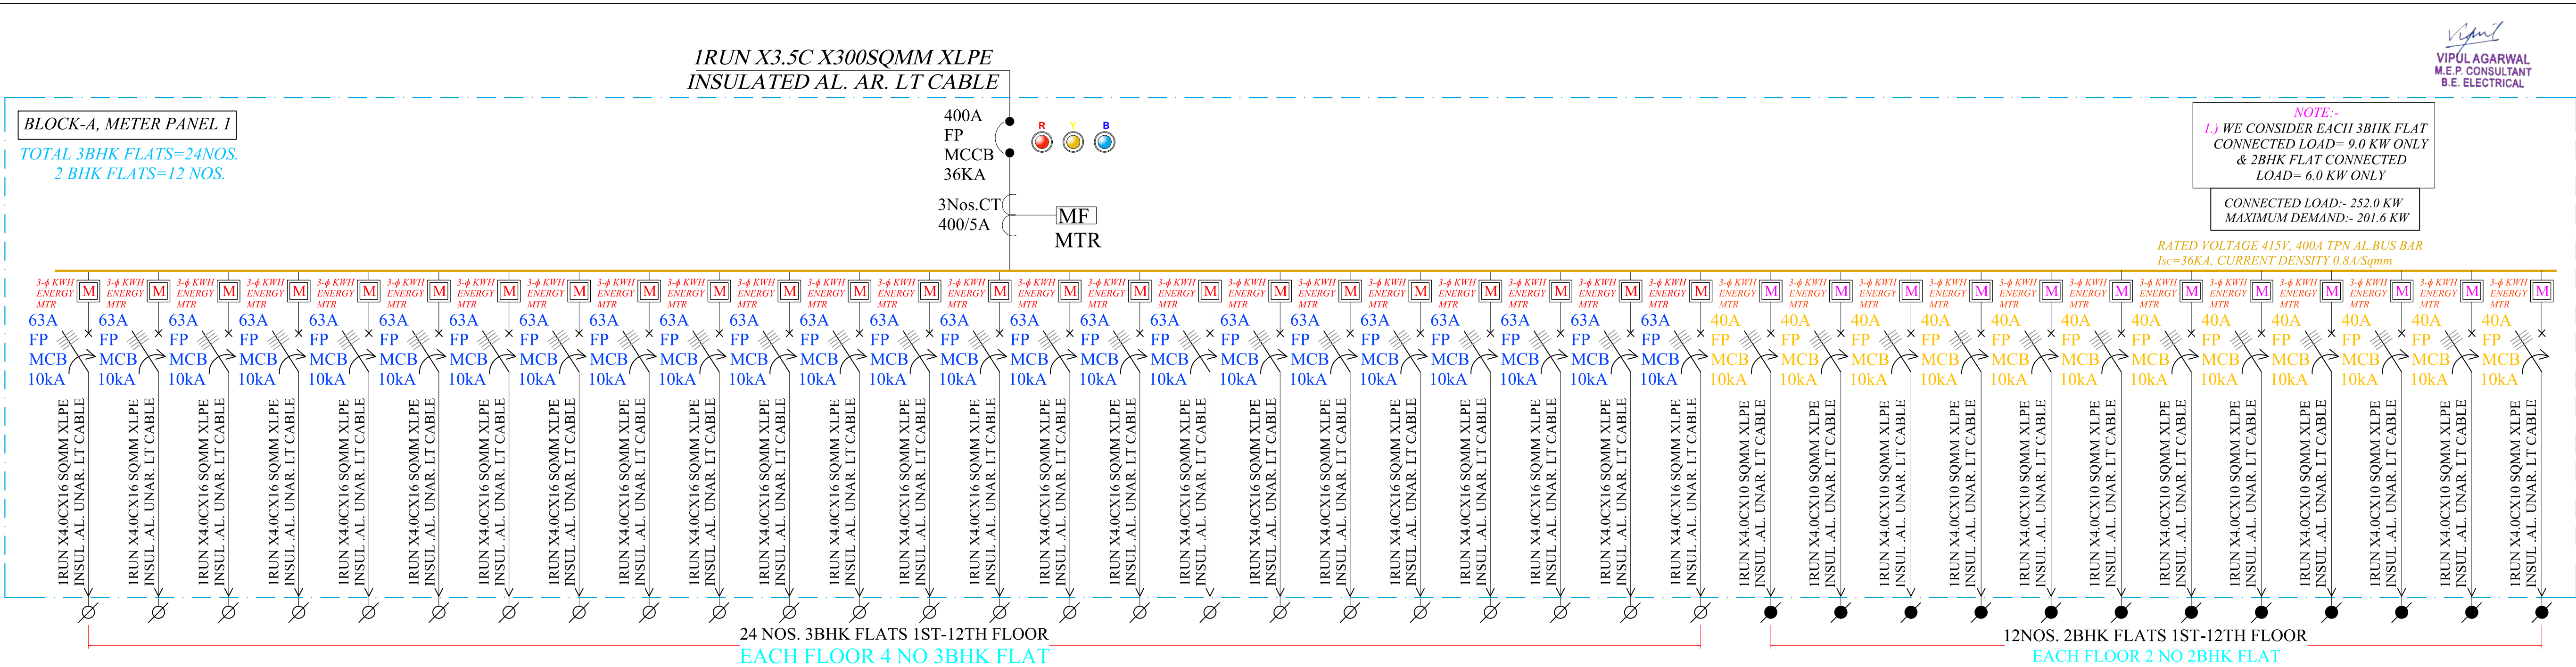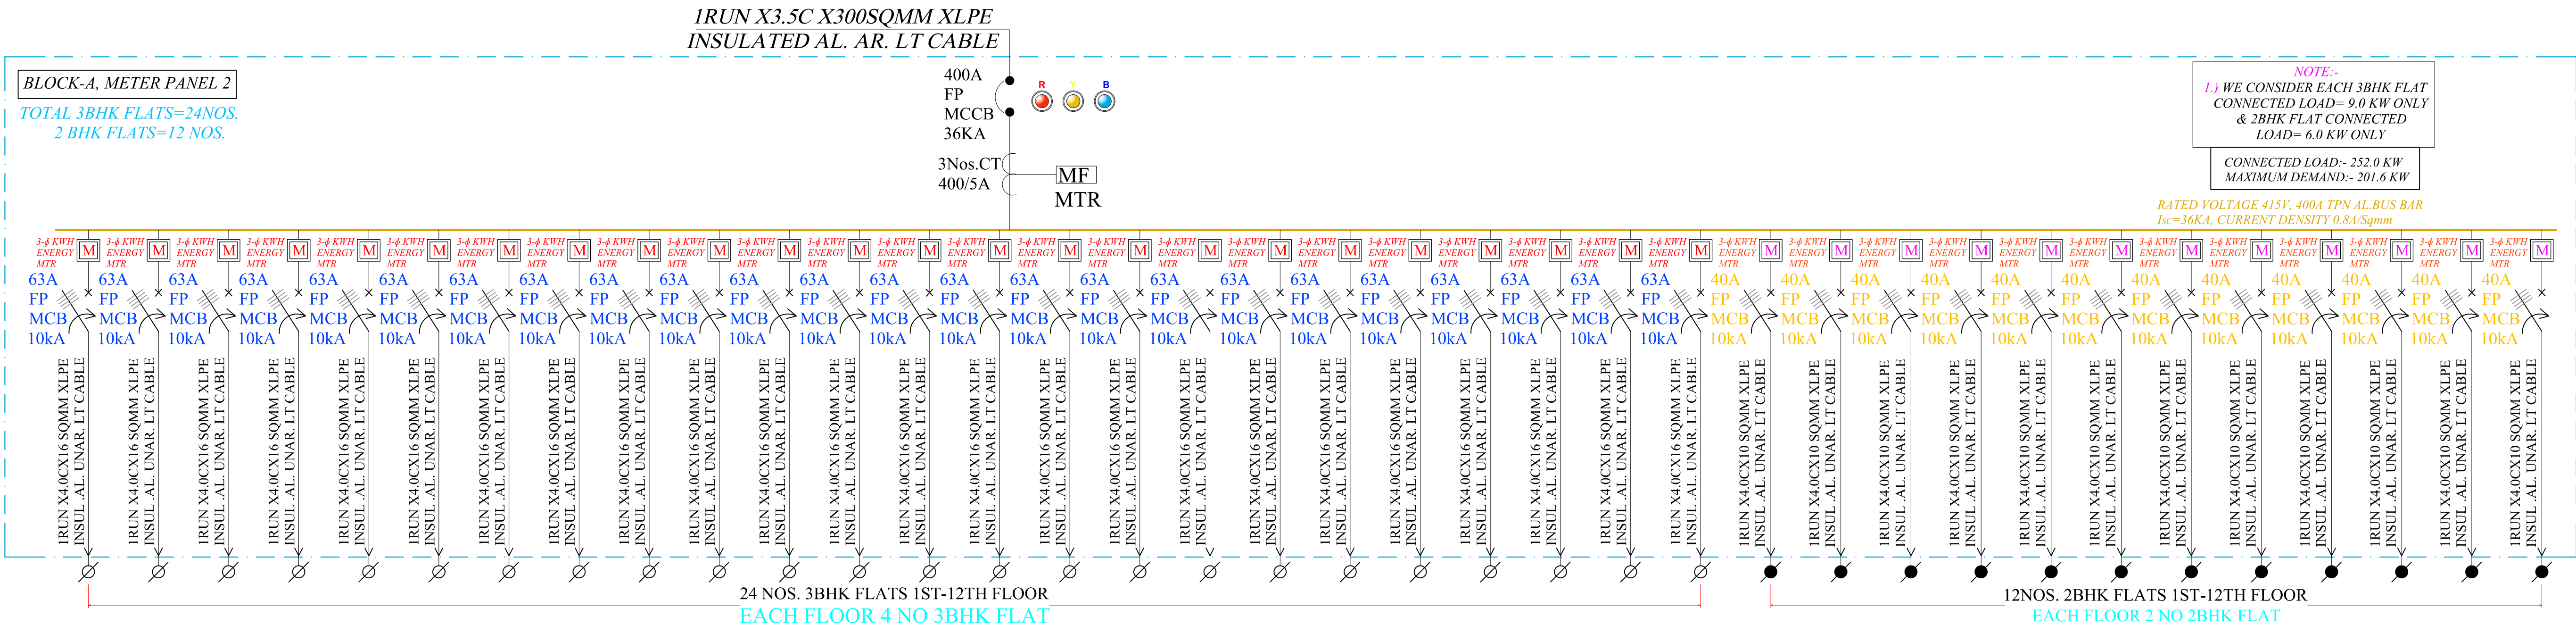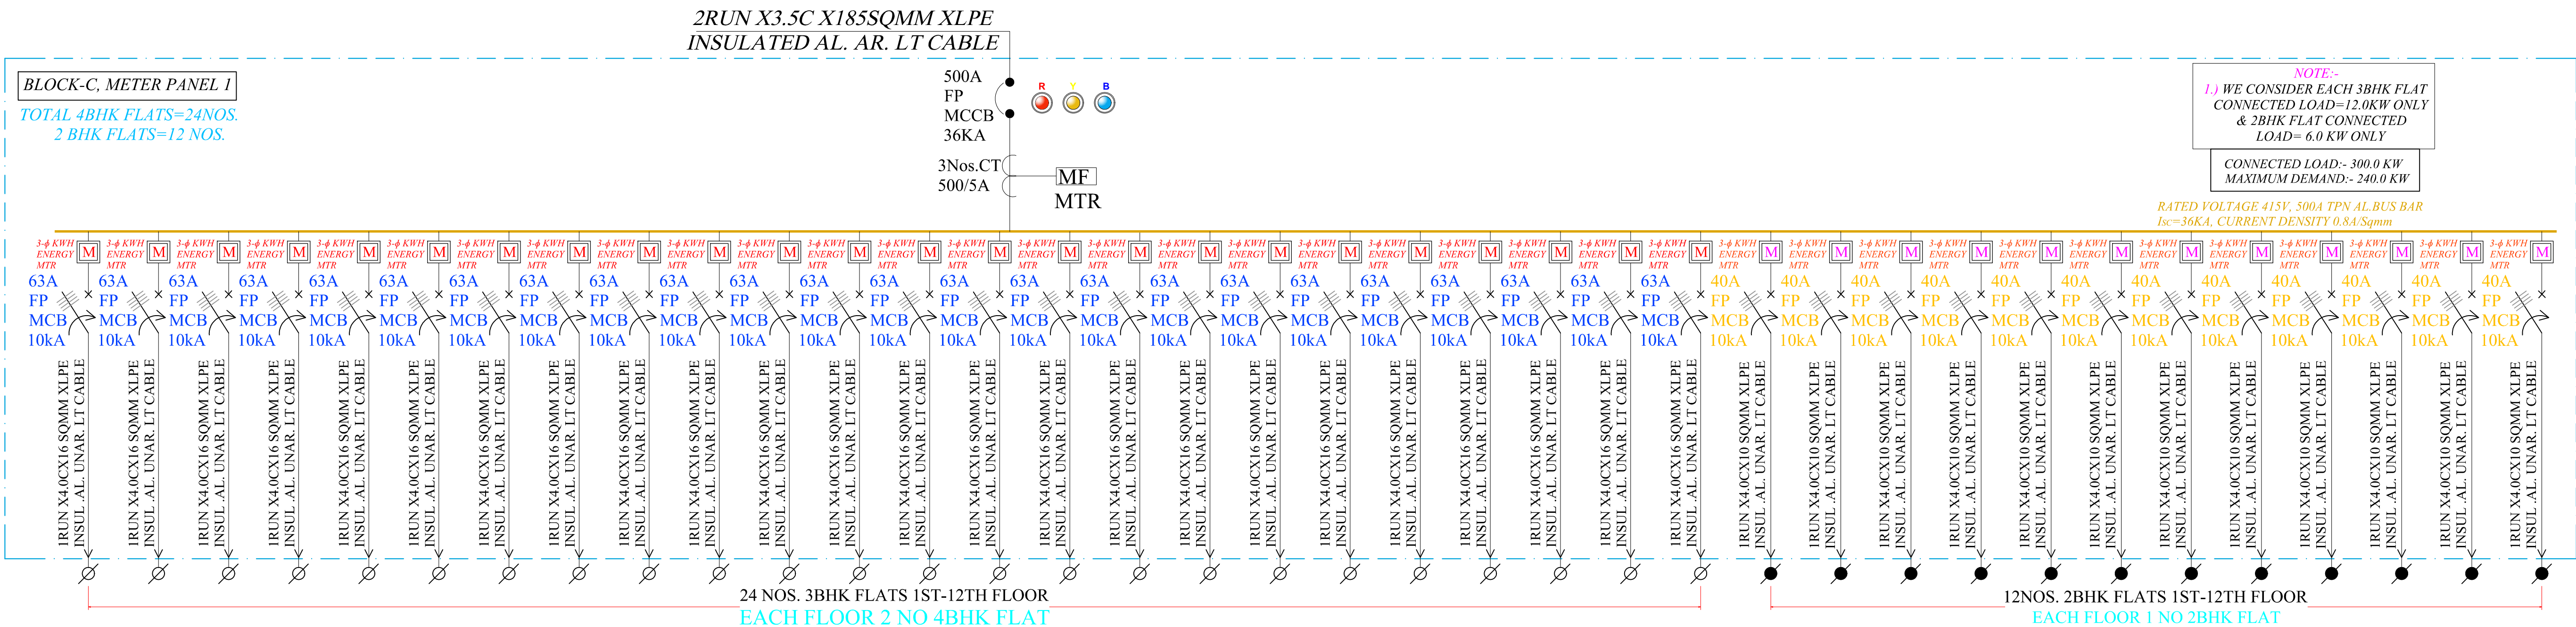

MEP CONSULTANT:
ASHI ASSOCIATES
F 9-440, KESHAV MARG,
CHITRAKUT SCHEME, JAIPUR
PH:93146-10438,2440946
E MAIL:vipul8599@yahoo.com

PROJECT: SOMYA SKY ELITE

PROMOTER NAME:
SOMYA BUILDHOME LLP


TITLE:
BLOCK- A & C METER PANELS



DRAWING:
SINGLE LINE DIAGRAM

DATE:- 04-11-2023 REV:- 00

DRAWN BY:- VICKY YADAV

CHECKED BY :- VIPUL AGARWAL

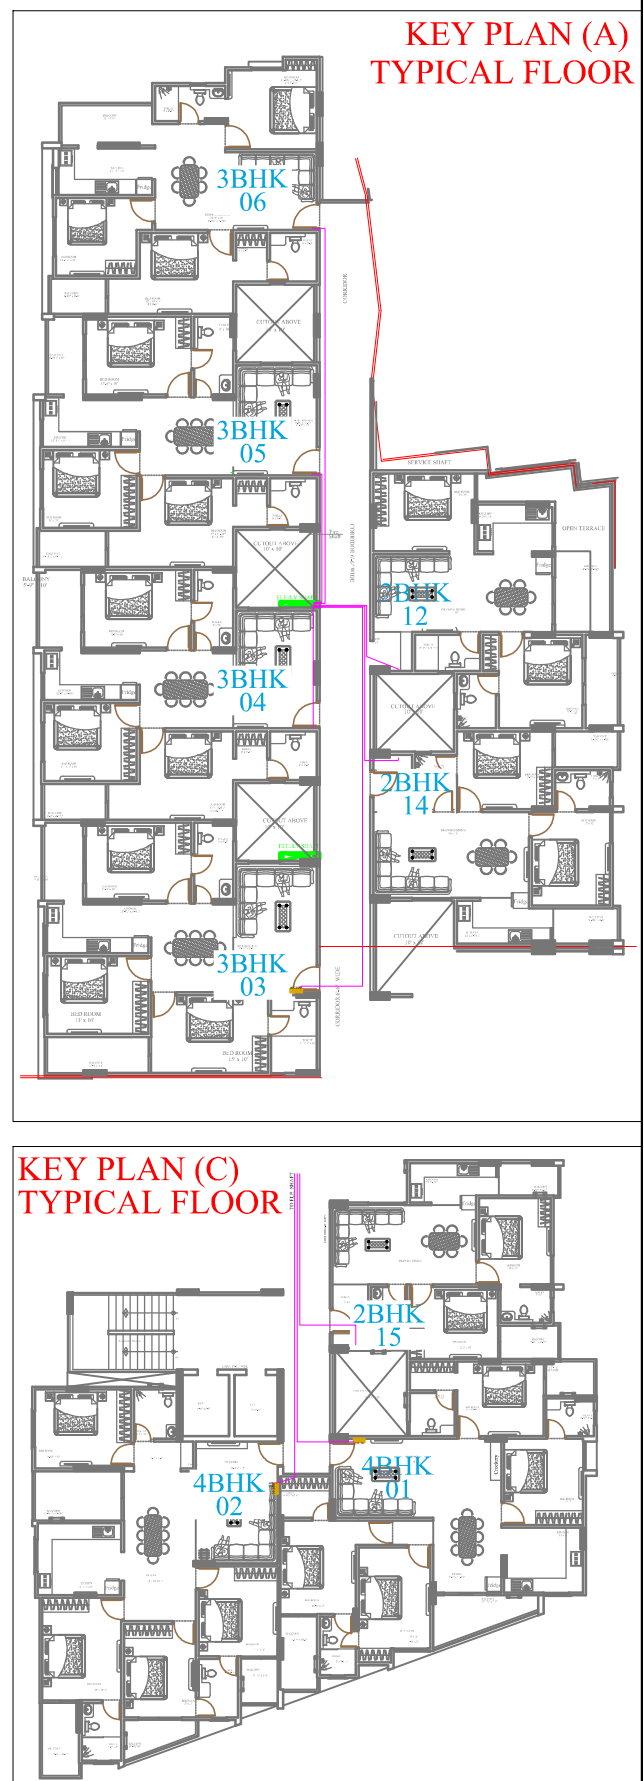

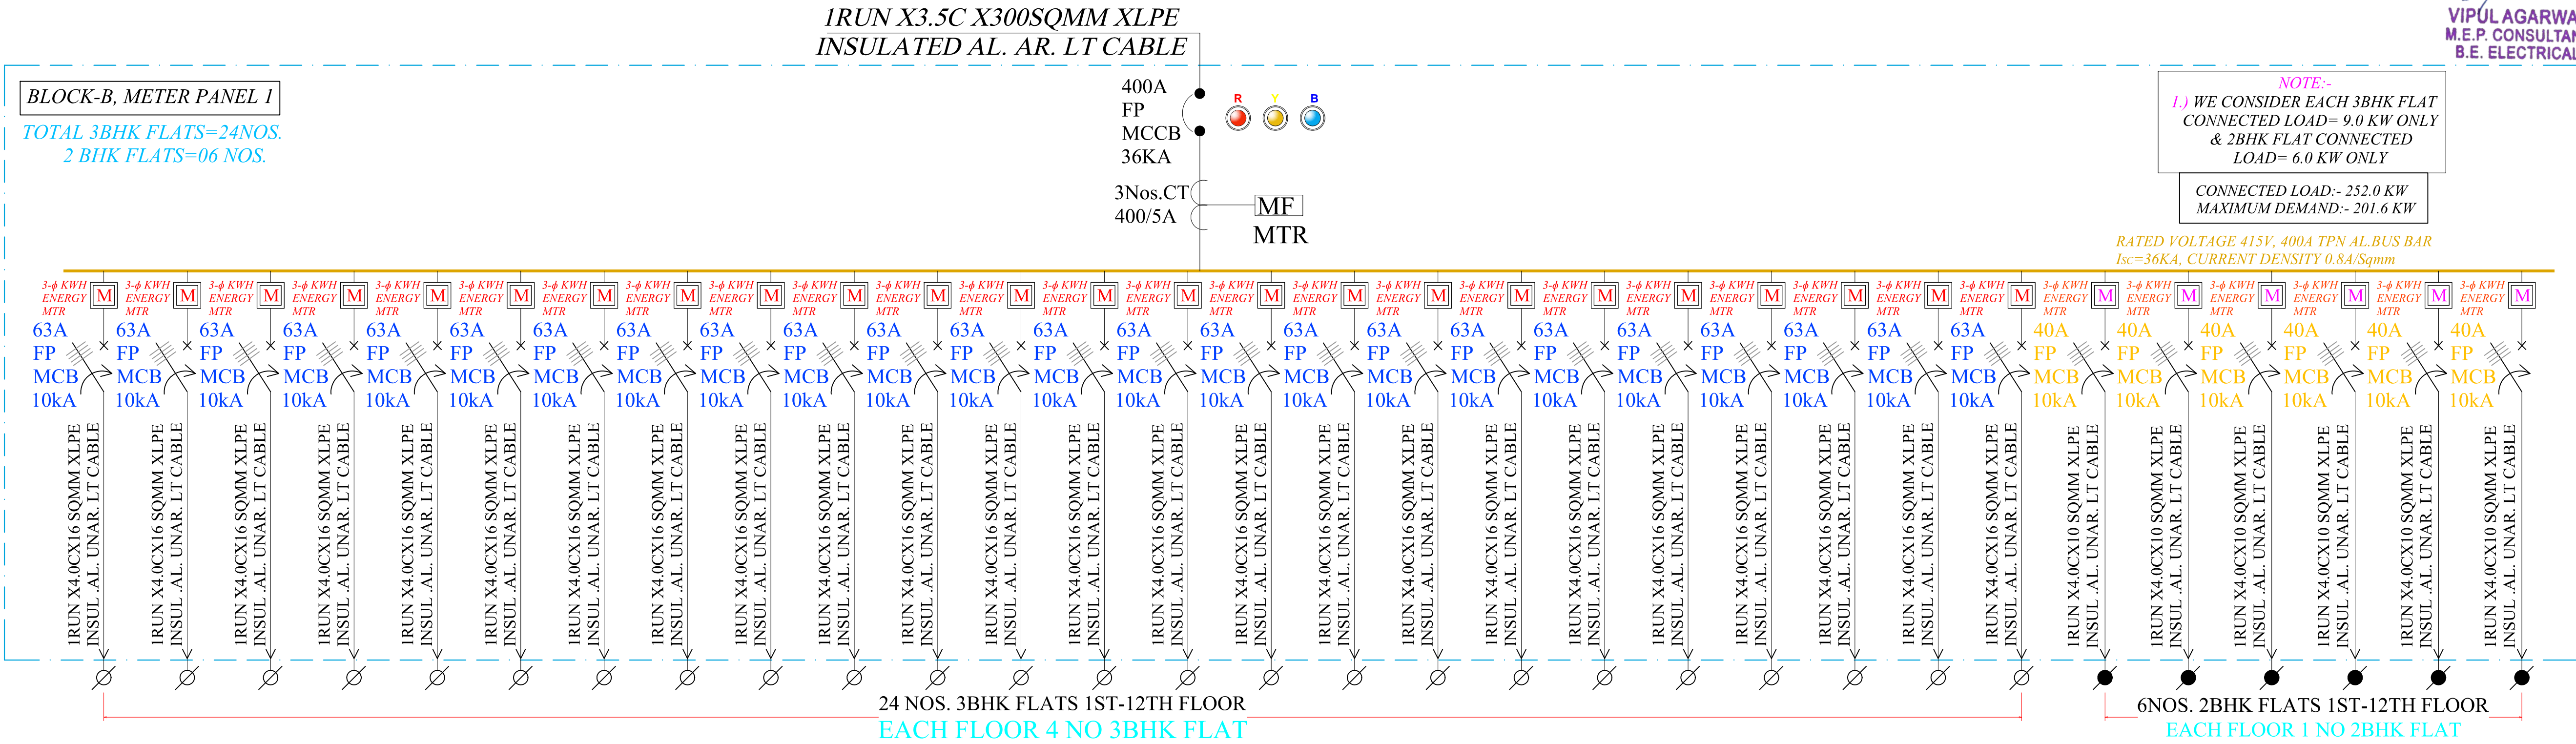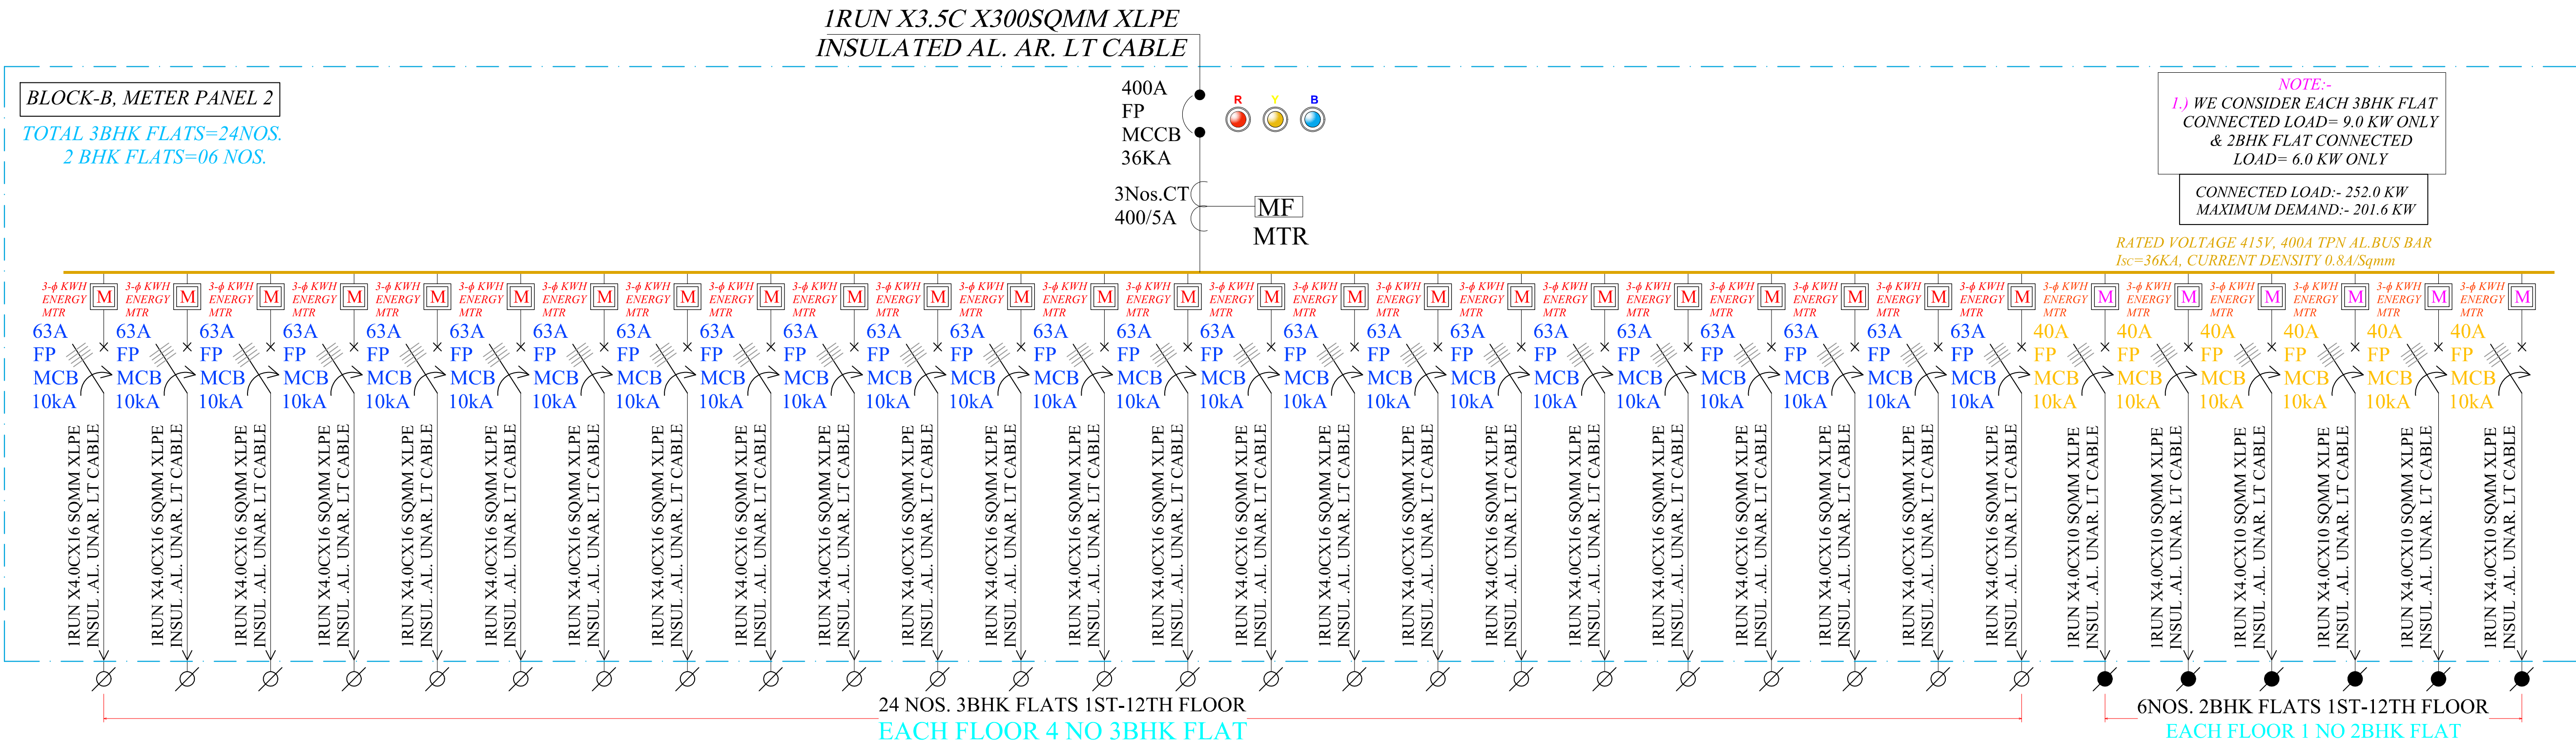

MEP CONSULTANT:
ASHI ASSOCIATES
F 9-440, KESHAV MARG,
CHITRAKUT SCHEME, JAIPUR
PH:93146-10438,2440946
E MAIL:vipul8599@yahoo.com

PROJECT : SOMYA SKY ELITE

PROMOTER NAME :
SOMYA BUILDHOME LLP


TITLE: BLOCK- B METER
PANELS


DRAWING: SINGLE LINE DIAGRAM

DATE:- 04-11-2023 **REV:-**

DRAWN BY:- VICKY YADAV

CHECKED BY :- VIPUL AGARWAL

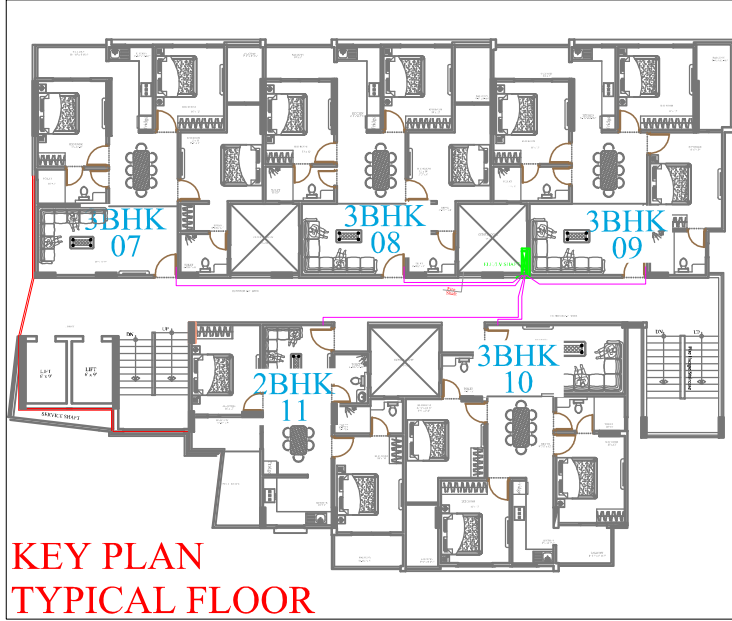

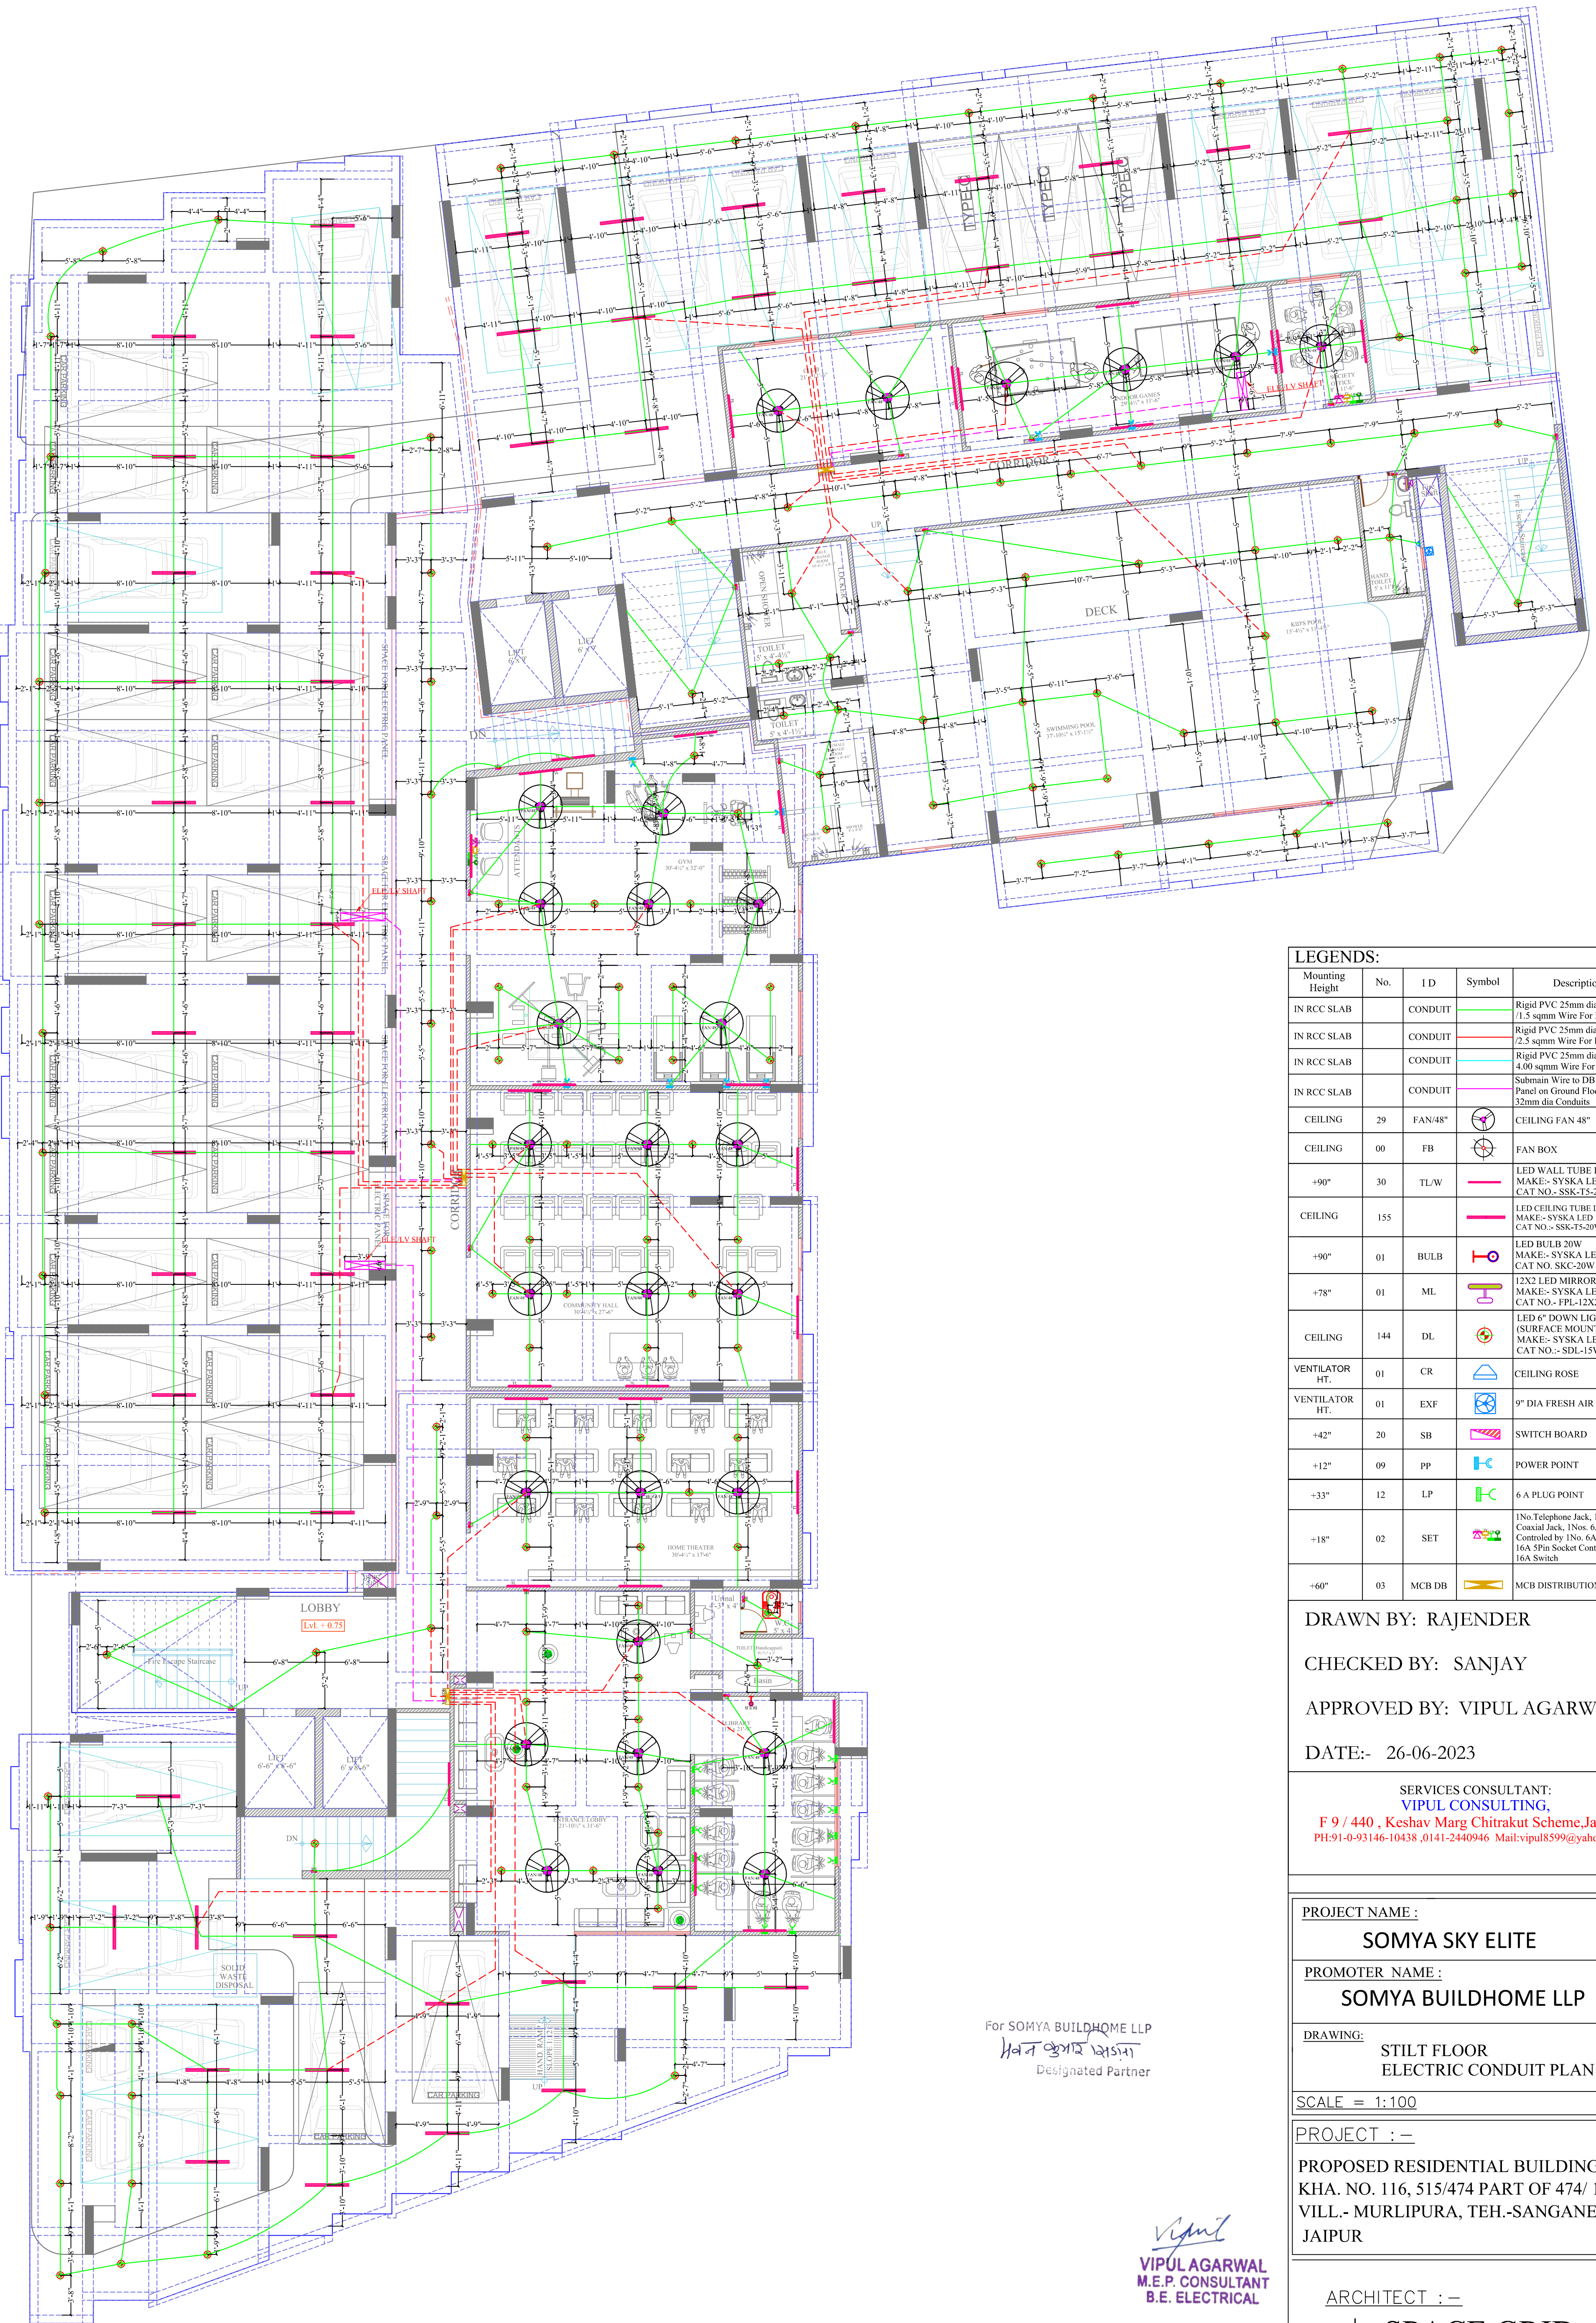

LEGENDS:				
Mounting Height	No.	I D	Symbol	Description
IN RCC SLAB		CONDUIT		Rigid PVC 25mm dia. Conduit / 1.5 sqmm Wire For Light Points
IN RCC SLAB		CONDUIT		Rigid PVC 25mm dia. Conduit / 2.5 sqmm Wire For Light Circuits
IN RCC SLAB		CONDUIT		Rigid PVC 25mm dia. Conduit / 4.00 sqmm Wire For Power Circuits
IN RCC SLAB		CONDUIT		Submain Wire to DB From Main Panel on Ground Floor in Innos. 32mm dia Conduits
CEILING	29	FAN/48"		CEILING FAN 48"
CEILING	00	FB		FAN BOX
+90"	30	TL/W		LED WALL TUBE LIGHT MAKE:- SYSKA LED CAT NO.- SSK-TS-20W
CEILING	155			LED CEILING TUBE LIGHT MAKE:- SYSKA LED CAT NO.- SSK-TS-20W
+90"	01	BULB		LED BULB 20W MAKE:- SYSKA LED CAT NO. SKC-20W 5.7K/3K
+78"	01	ML		12X2 LED MIRROR LIGHT MAKE:- SYSKA LED CAT NO.- FPL-12X2
CEILING	144	DL		LED 6" DOWN LIGHTER 20W (SURFACE MOUNTED) MAKE:- SYSKA LED CAT NO.- SDL-15W GLD 6.5K/4K
VENTILATOR HT.	01	CR		CEILING ROSE
VENTILATOR HT.	01	EXP		9" DIA FRESH AIR FAN
+42"	20	SB		SWITCH BOARD
+12"	09	PP		POWER POINT
+33"	12	LP		6 A PLUG POINT
+18"	02	SET		1No.Telephone Jack, 1No. TV Coaxial Jack, 1Nos. 6A Socket Controlled by 1No. 6A Switch & 1Nos. 16A 5Pin Socket Controlled by 1No. 16A Switch
+60"	03	MCB DB		MCB DISTRIBUTION BOARD

DRAWN BY: RAJENDER

CHECKED BY: SANJAY

APPROVED BY: VIPUL AGARWAL

DATE:- 26-06-2023

SERVICES CONSULTANT:
VIPUL CONSULTING,
F 9 / 440 , Keshav Marg Chitrakut Scheme,Jaipur
PH:91-0-93146-10438 ,0141-2440946 Mail:vipul8599@yahoo.com

PROJECT NAME :

SOMYA SKY ELITE

PROMOTER NAME :

SOMYA BUILDHOME LLP

DRAWING:

STILT FLOOR
ELECTRIC CONDUIT PLAN

SCALE = 1:100

PROJECT :-

PROPOSED RESIDENTIAL BUILDING AT
KHA. NO. 116, 515/474 PART OF 474/ 115 AT,
VILL.- MURLIPURA, TEH.-SANGANER,
JAIPUR

ARCHITECT :-



SPACE GRID

C-49,VIDYA
APARTMENT,PARAS MARG,
BAPU NAGAR,NEAR JANTA
STORE CIRCLE,
JAIPUR-302015
PH-09314918766,0141-4005506
(0)
Email:-info.spacegrid@gmail.com


For SOMYA BUILDHOME LLP
H.A.T. Oshin Designated Partner

VIPUL AGARWAL
M.E.P. CONSULTANT
B.E. ELECTRICAL

1No.Telephone Jack, 1No. TV Coaxial
Jack, 1Nos. 6A Socket Controlled by 1No.
6A Switch & 1Nos. 16A 5Pin Socket
Controlled by 1No. 16A Switch

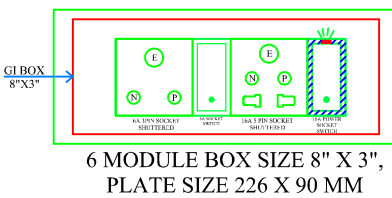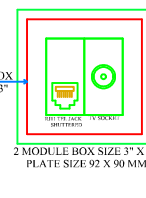

+18"

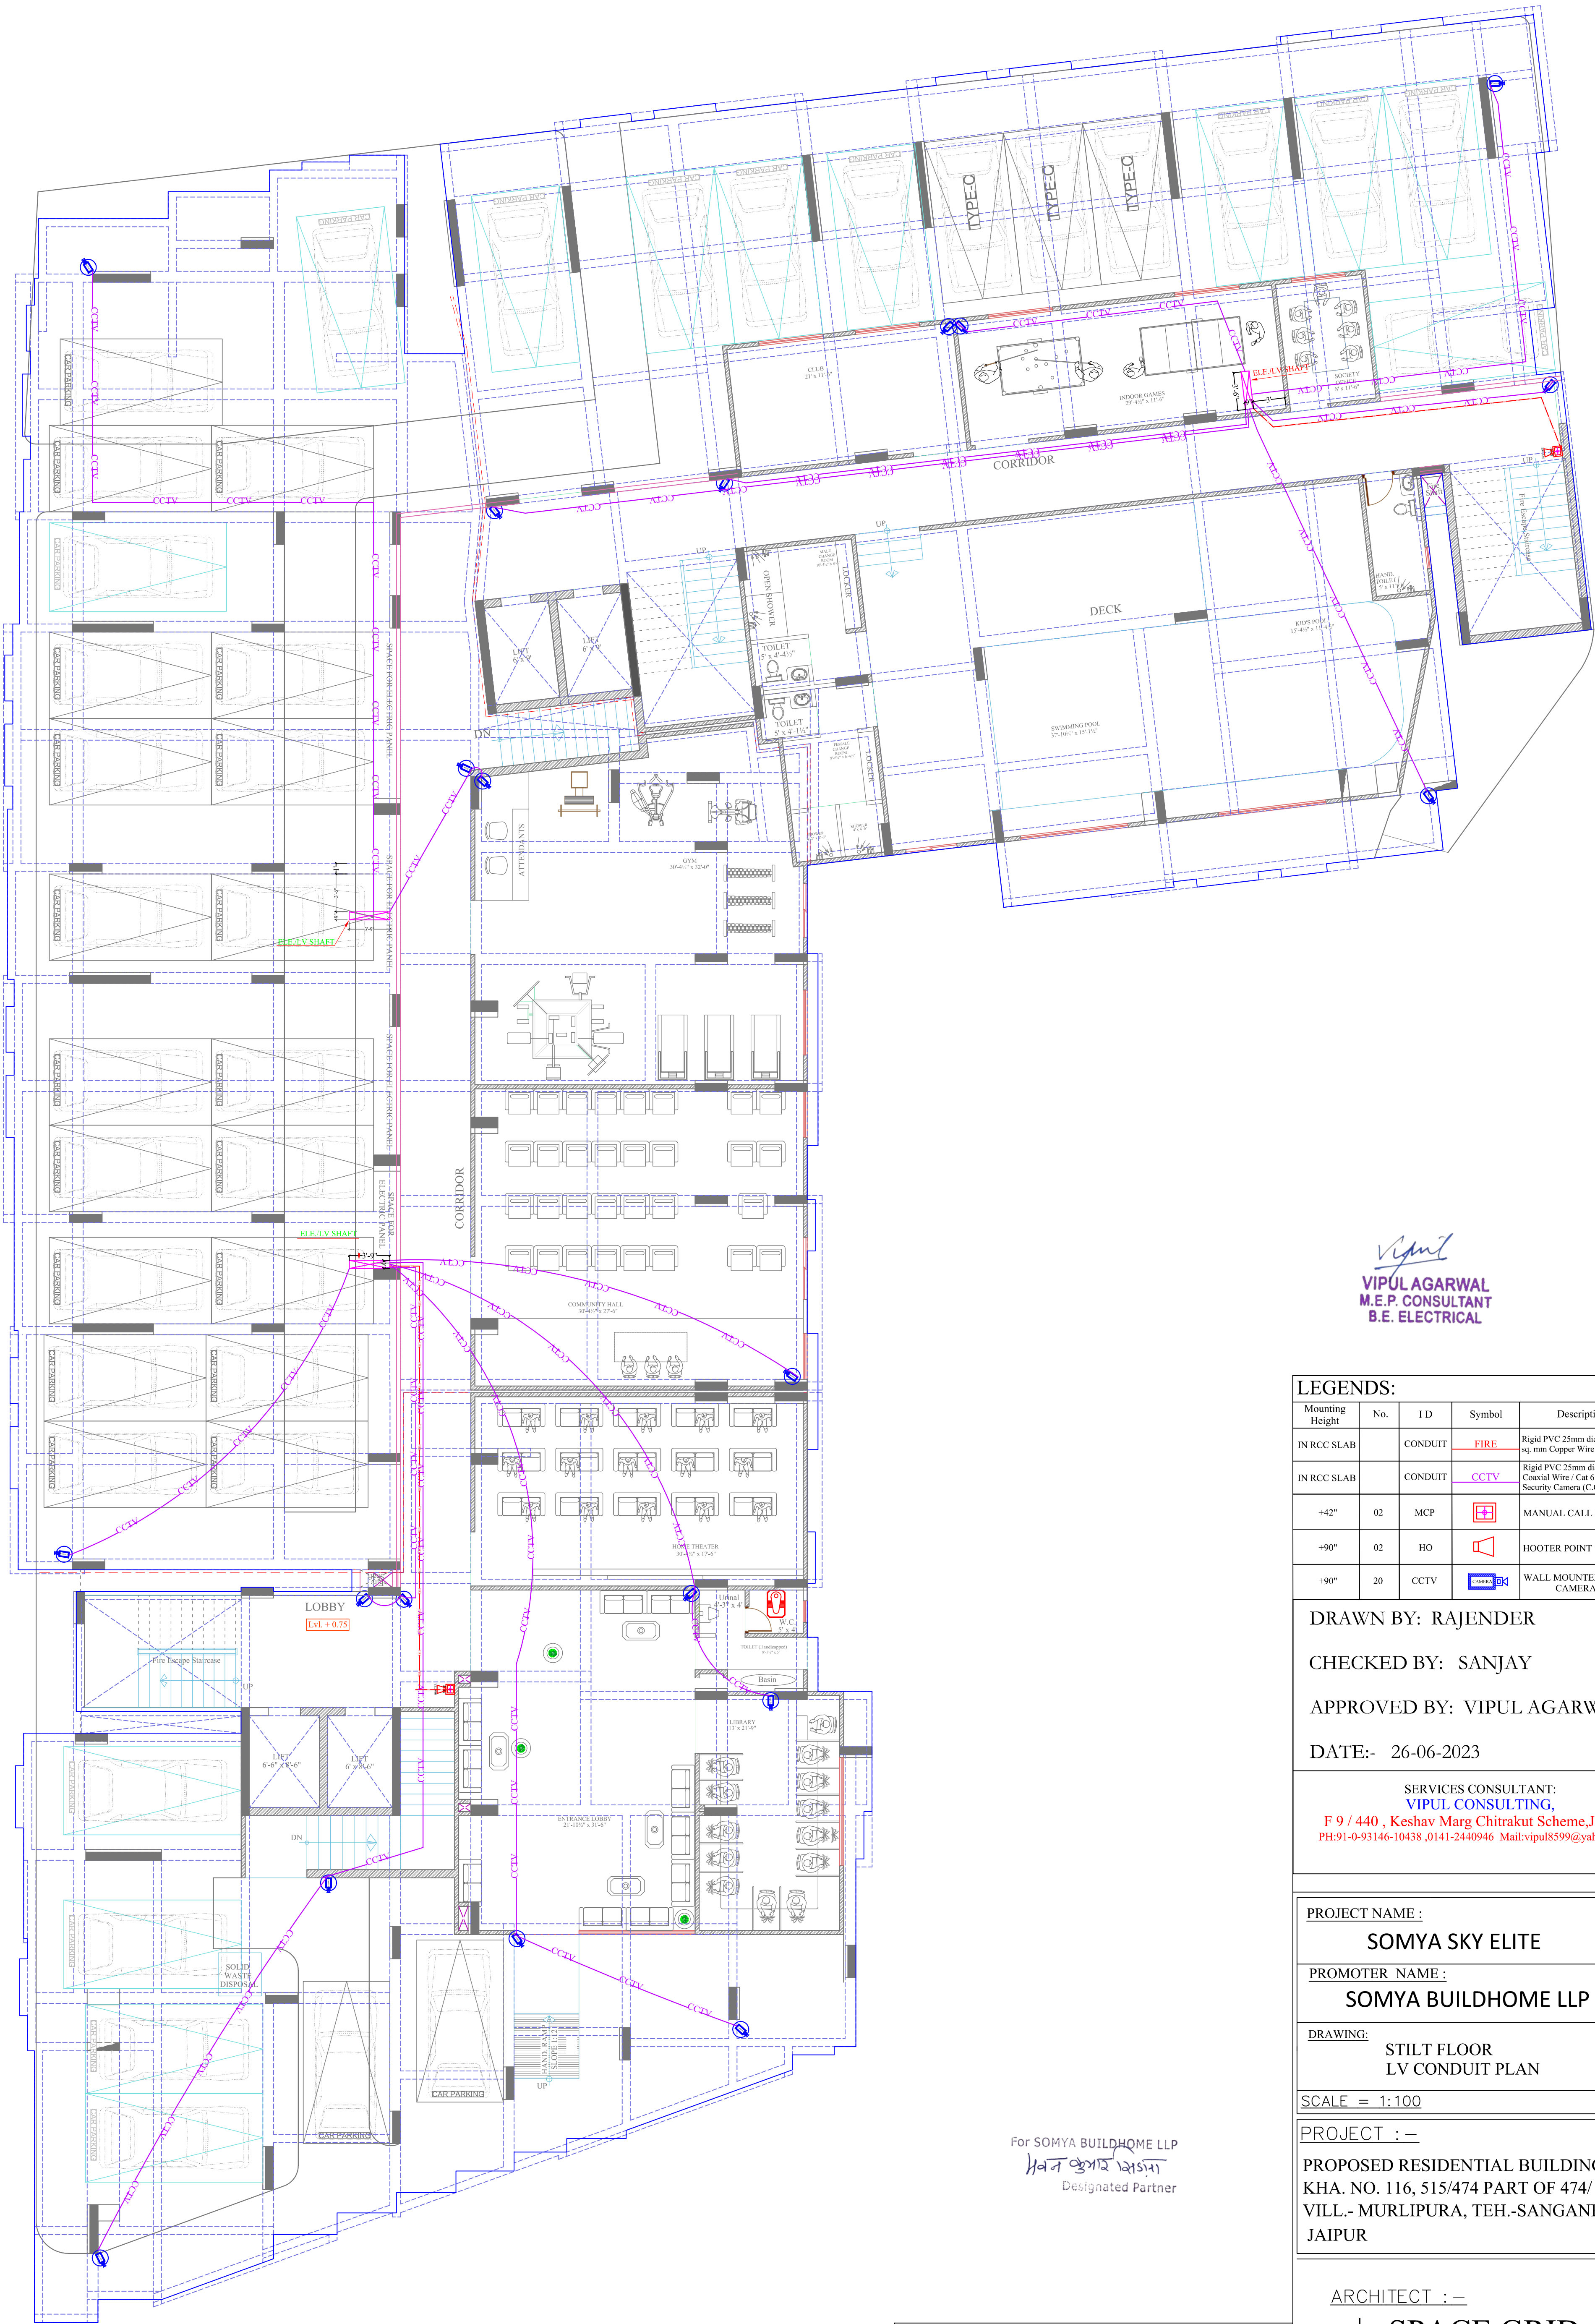

Vipul
VIPUL AGARWAL
M.E.P. CONSULTANT
B.E. ELECTRICAL

LEGENDS:

Mounting Height	No.	I D	Symbol	Description
IN RCC SLAB		CONDUIT	—	Rigid PVC 25mm dia. Conduit / 2X1.5 sq. mm Copper Wire For Fire Alarm
IN RCC SLAB		CONDUIT	—	Rigid PVC 25mm dia. Conduit / 3+1 Coaxial Wire / Cat 6 UTP Cable For Security Camera (C.C.T.V.).
+42"	02	MCP		MANUAL CALL POINT
+90"	02	HO		HOOTER POINT
+90"	20	CCTV		WALL MOUNTED CCTV CAMERA

DRAWN BY: RAJENDER

CHECKED BY: SANJAY

APPROVED BY: VIPUL AGARWAL

DATE:- 26-06-2023

SERVICES CONSULTANT:
VIPUL CONSULTING,
F 9 / 440 , Keshav Marg Chitrakut Scheme,Jaipur
PH:91-0-93146-10438,0141-2440946 Mail:vipul8599@yahoo.com

PROJECT NAME :

SOMYA SKY ELITE

PROMOTER NAME :

SOMYA BUILDHOME LLP

DRAWING:

**STILT FLOOR
LV CONDUIT PLAN**

SCALE = 1:100

PROJECT : —

PROPOSED RESIDENTIAL BUILDING AT
KHA. NO. 116, 515/474 PART OF 474/ 115 AT,
VILL.- MURLIPURA, TEH.-SANGANER,
JAIPUR

ARCHITECT : —

SPACE GRID

C-49,VIDYA
APARTMENT,PARAS MARG,
BAPU NAGAR,NEAR JANTA
STORE CIRCLE,
JAIPUR-302015
PH-09314918766,0141-4005506
(0)
Email: -info.spacegrid@gmail.com

For SOMYA BUILDHOME LLP
हवन कुमार शर्मा
Designated Partner

1No.Telephone Jack, 1No. TV Coaxial Jack, 1Nos. 6A Socket Controlled by 1No. 6A Switch & 1Nos. 16A 5Pin Socket Controlled by 1No. 16A Switch

6 MODULE BOX SIZE 8" X 3",
PLATE SIZE 226 X 90 MM

1 SOCKET BOX SIZE 7" X 7",
PLATE SIZE 92 X 90 MM