


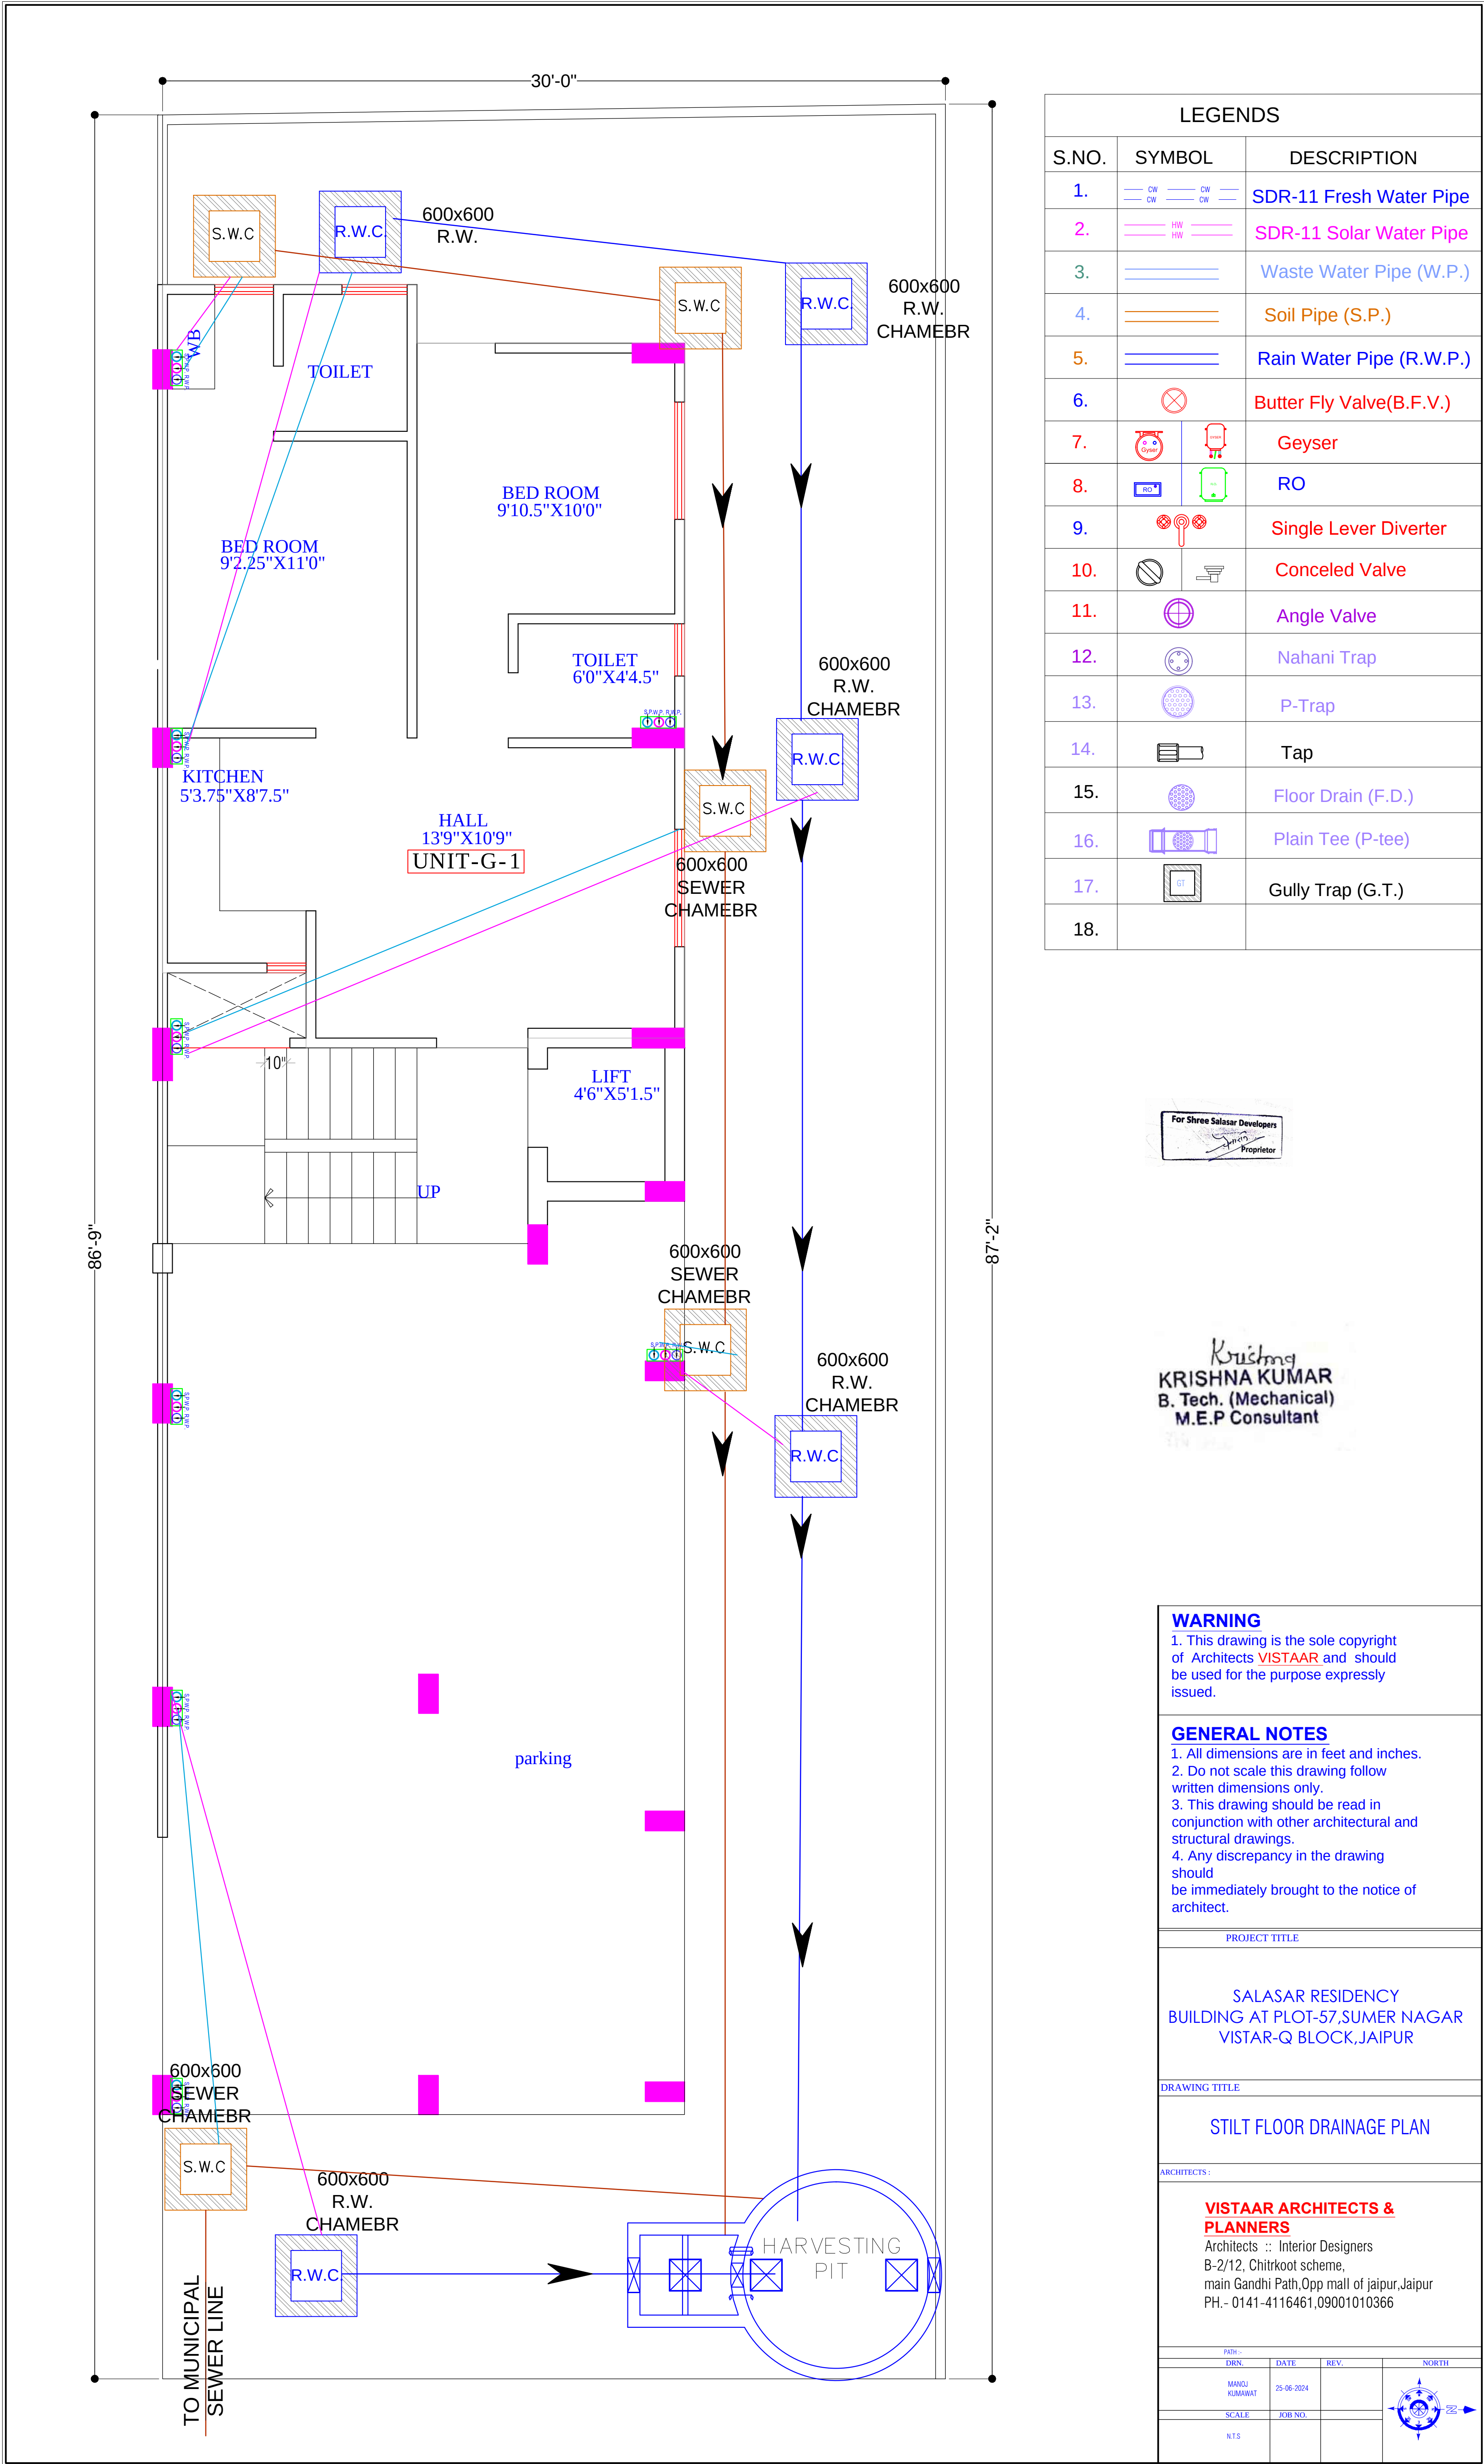

LEGENDS		
S.NO.	SYMBOL	DESCRIPTION
1.		SDR-11 Fresh Water Pipe
2.		SDR-11 Solar Water Pipe
3.		Waste Water Pipe (W.P.)
4.		Soil Pipe (S.P.)
5.		Rain Water Pipe (R.W.P.)
6.		Butter Fly Valve(B.F.V.)
7.		Geyser
8.		RO
9.		Single Lever Diverter
10.		Concealed Valve
11.		Angle Valve
12.		Nahani Trap
13.		P-Trap
14.		Tap
15.		Floor Drain (F.D.)
16.		Plain Tee (P-tee)
17.		Gully Trap (G.T.)
18.		

For Shree Salasar Developers
Proprietor

Krishna
KRISHNA KUMAR
B. Tech. (Mechanical)
M.E.P Consultant

WARNING
1. This drawing is the sole copyright of Architects VISTAAR and should be used for the purpose expressly issued.

GENERAL NOTES
1. All dimensions are in feet and inches.
2. Do not scale this drawing follow written dimensions only.
3. This drawing should be read in conjunction with other architectural and structural drawings.
4. Any discrepancy in the drawing should be immediately brought to the notice of architect.

PROJECT TITLE

SALASAR RESIDENCY
BUILDING AT PLOT-57,SUMER NAGAR
VISTAR-Q BLOCK,JAIPUR

DRAWING TITLE


STILT FLOOR DRAINAGE PLAN


ARCHITECTS :

VISTAAR ARCHITECTS & PLANNERS

Architects :: Interior Designers
B-2/12, Chitrkoot scheme,
main Gandhi Path,Opp mall of jaipur,Jaipur
PH.- 0141-4116461,09001010366

PATH -	DATE	REV.	NORTH
DRN	25-06-2024		
MANU KUMAR			
SCALE	JOB NO.		
1/8"			

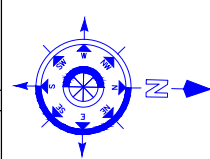

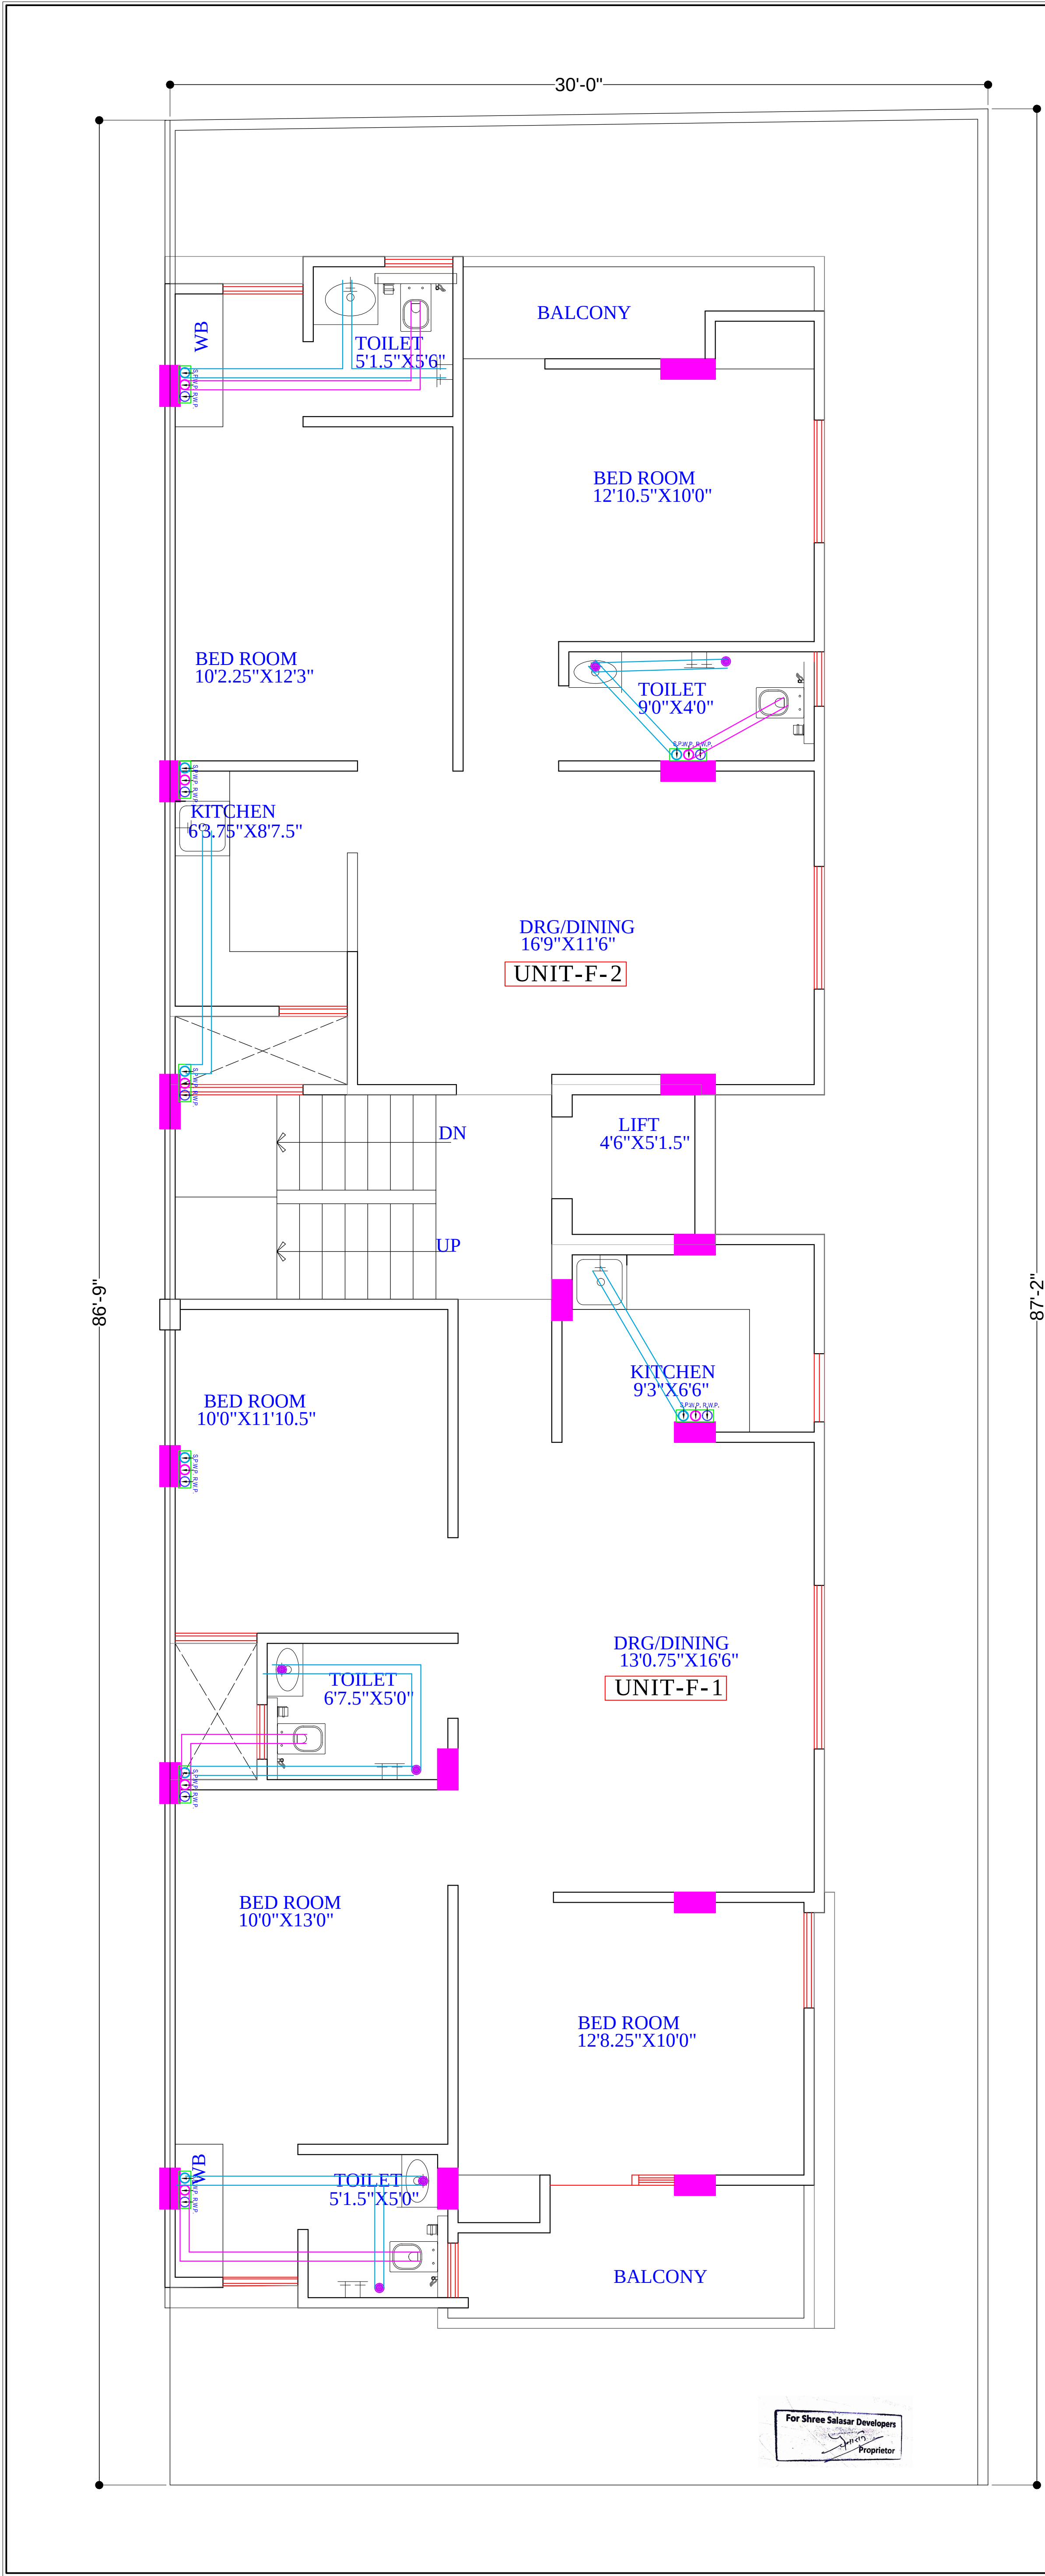

LEGENDS		
S.NO.	SYMBOL	DESCRIPTION
1.		SDR-11 Fresh Water Pipe
2.		SDR-11 Solar Water Pipe
3.		Waste Water Pipe (W.P.)
4.		Soil Pipe (S.P.)
5.		Rain Water Pipe (R.W.P.)
6.		Butter Fly Valve(B.F.V.)
7.		Geyser
8.		RO
9.		Single Lever Diverter
10.		Concealed Valve
11.		Angle Valve
12.		Nahani Trap
13.		P-Trap
14.		Tap
15.		Floor Drain (F.D.)
16.		Plain Tee (P-tee)
17.		Gully Trap (G.T.)
18.		

Krishna
KRISHNA KUMAR
B. Tech. (Mechanical)
M.E.P Consultant

WARNING
1. This drawing is the sole copyright of Architects VISTAAR and should be used for the purpose expressly issued.

GENERAL NOTES
1. All dimensions are in feet and inches.
2. Do not scale this drawing follow written dimensions only.
3. This drawing should be read in conjunction with other architectural and structural drawings.
4. Any discrepancy in the drawing should be immediately brought to the notice of architect.

PROJECT TITLE

SALASAR RESIDENCY
BUILDING AT PLOT-57,SUMER NAGAR
VISTAR-Q BLOCK,JAIPUR

DRAWING TITLE


GROUN TO 3TH. FLOOR DRAINAGE
PLAN

ARCHITECTS :

VISTAAR ARCHITECTS & PLANNERS
Architects :: Interior Designers
B-2/12, Chitrkoot scheme,
main Gandhi Path, Opp mall of jaipur,Jaipur
PH.- 0141-4116461,09001010366

PATH:-	DATE	REV.	NORTH
DRN.	25-06-2024		
MANUJ KUMAR			
SCALE	JOB NO.		
NTS			

LEGENDS		
S.NO.	SYMBOL	DESCRIPTION
1.		SDR-11 Fresh Water Pipe
2.		SDR-11 Solar Water Pipe
3.		Waste Water Pipe (W.P.)
4.		Soil Pipe (S.P.)
5.		Rain Water Pipe (R.W.P.)
6.		Butter Fly Valve (B.F.V.)
7.		Geyser
8.		RO
9.		Single Lever Diverter
10.		Concealed Valve
11.		Angle Valve
12.		Nahani Trap
13.		P-Trap
14.		Tap
15.		Floor Drain (F.D.)
16.		Plain Tee (P-tee)
17.		Gully Trap (G.T.)
18.		

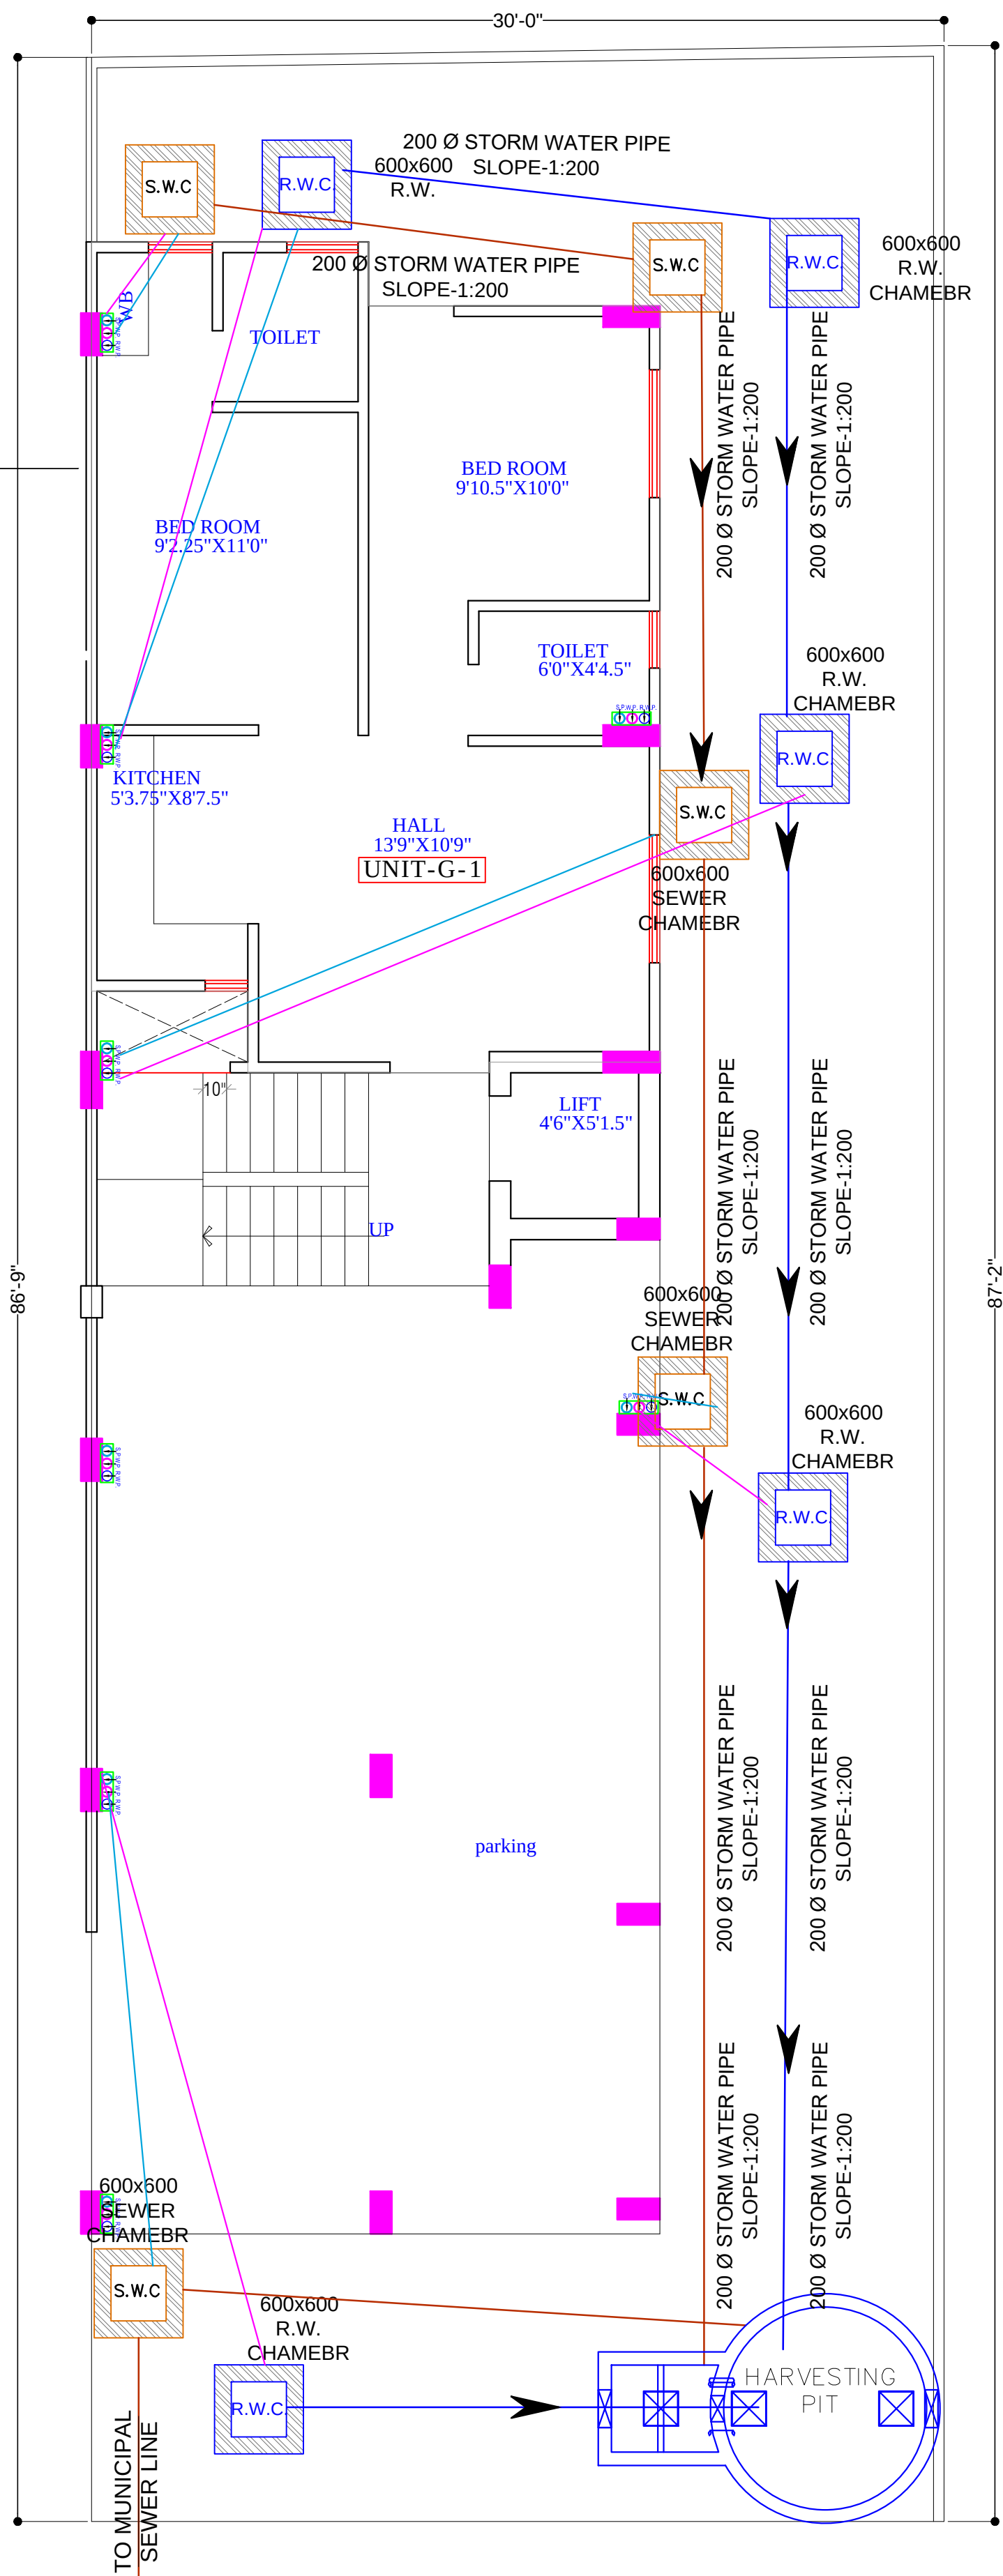

WARNING

1. This drawing is the sole copyright of Architects **VISTAAR** and should be used for the purpose expressly issued.

GENERAL NOTES

1. All dimensions are in feet and inches.
2. Do not scale this drawing follow written dimensions only.
3. This drawing should be read in conjunction with other architectural and structural drawings.
4. Any discrepancy in the drawing should be immediately brought to the notice of architect.


PROJECT TITLE

SALASAR RESIDENCY
BUILDING AT PLOT-57,SUMER NAGAR
VISTAR-Q BLOCK,JAIPUR

DRAWING TITLE	
,SANITATION(STORM WATER DRAINAGE, SEWERAGE,STP,SOLID WATER DISPOSAL) AND RAIN WATER HARVESTING PLAN	

ARCHITECTS :
VISTAAR ARCHITECTS & PLANNERS
Architects :: Interior Designers
B-2/12, Chitrkoot scheme,
main Gandhi Path, Opp mall of jaipur, Jaipur
PH.- 0141-4116461, 09001010366

PLOT:		REV:		
DIN:	DATE:	REV:		
MANGU KUMARAT	25-06-2024			
SCALE:	JOB NO:			
RTS				

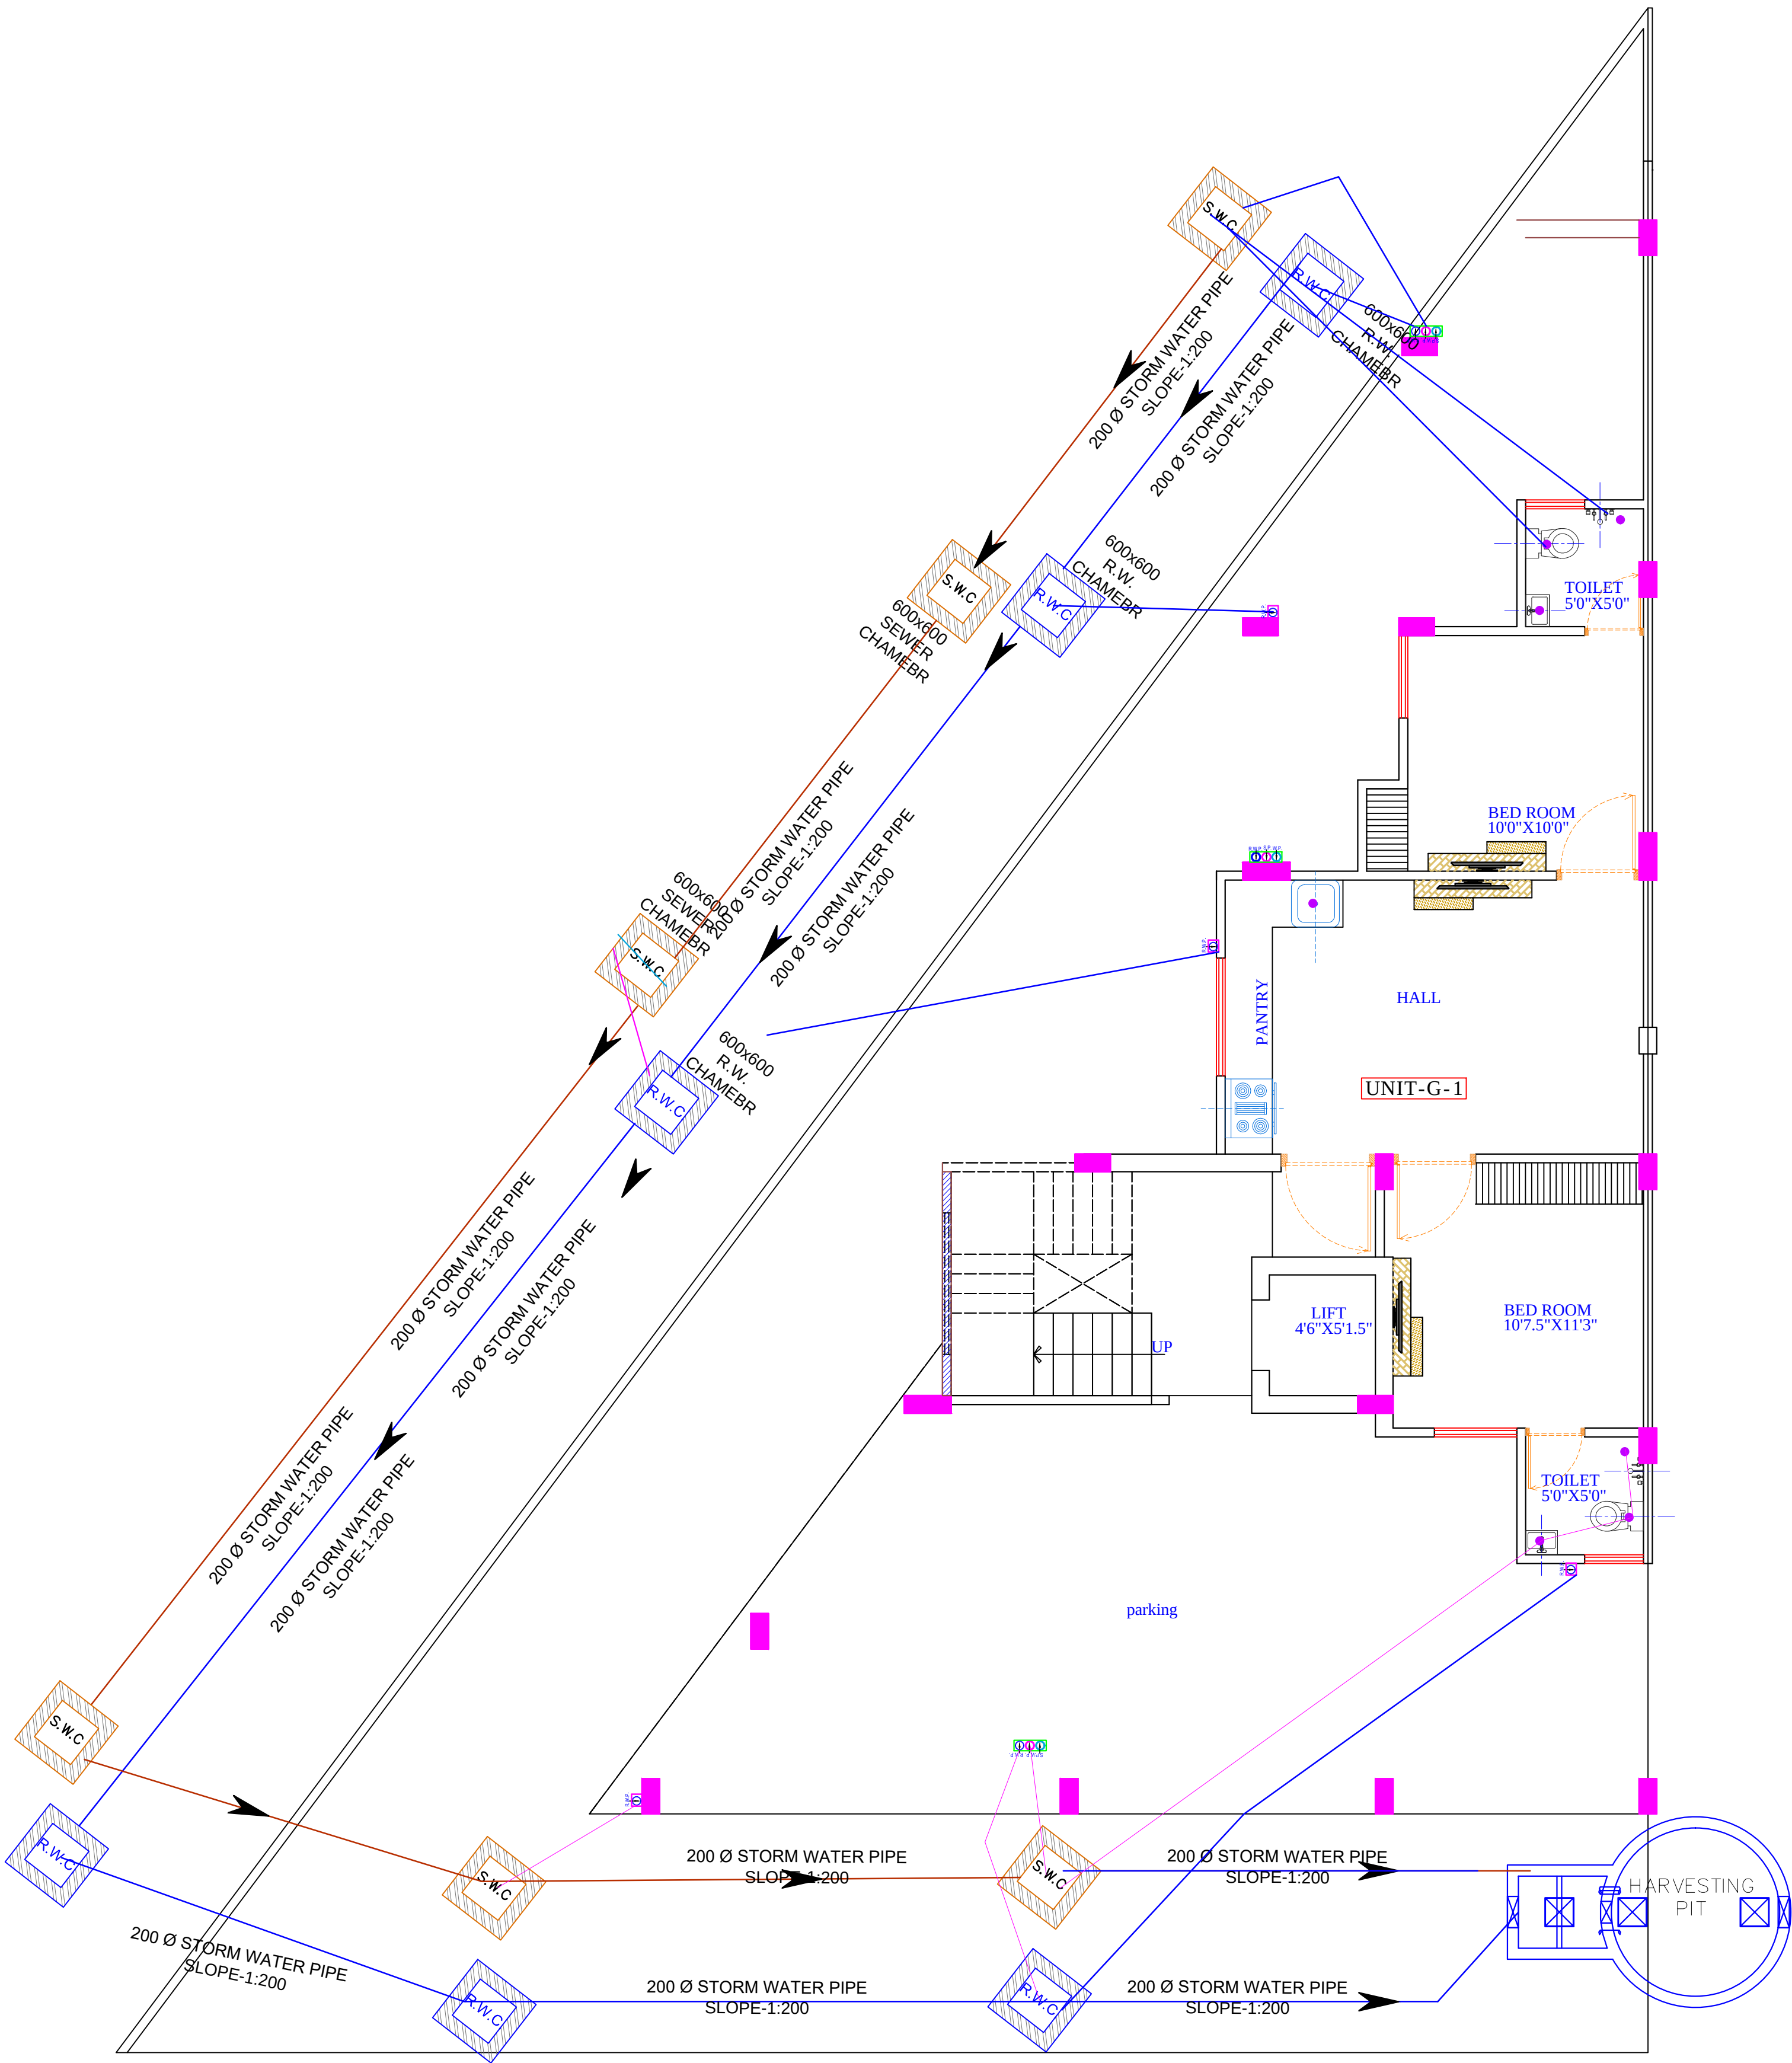

For Shree Salasar Developers
Proprietor

KRISHNA KUMAR
B. Tech. (Mechanical)
M.E.P Consultant

LEGENDS		
S.NO.	SYMBOL	DESCRIPTION
1.		SDR-11 Fresh Water Pipe
2.		SDR-11 Solar Water Pipe
3.		Waste Water Pipe (W.P.)
4.		Soil Pipe (S.P.)
5.		Rain Water Pipe (R.W.P.)
6.		Butter Fly Valve (B.F.V.)
7.		Geyser
8.		RO
9.		Single Lever Diverter
10.		Concealed Valve
11.		Angle Valve
12.		Nahani Trap
13.		P-Trap
14.		Tap
15.		Floor Drain (F.D.)
16.		Plain Tee (P-tee)
17.		Gully Trap (G.T.)
18.		

WARNING

1. This drawing is the sole copyright of Architects
VISTAAR and should be used for the purpose
expressly issued.

GENERAL NOTES

- All dimensions are in feet and inches.
- Do not scale this drawing follow written dimensions only.
- This drawing should be read in conjunction with other architectural and structural drawings.
- Any discrepancy in the drawing should be immediately brought to the notice of architect.

PROJECT TITLE

SALASAR RESIDENCY
BUILDING AT PLOT-58,SUMER NAGAR
VISTAR-Q BLOCK,JAIPUR

DRAWING TITLE


STILT FLOOR DRAINAGE PLAN


ARCHITECTS :

VISTAAR ARCHITECTS & PLANNERS

Architects :: Interior Designers
B-2/12, Chitrakoot scheme,
main Gandhi Path Opp mall of jaipur,Jaipur
PH - 0141-4116461,09001010366

DATE	DATE	REV.	NORTH
23-05-2022			
SCALE	JOB NO.		
NTS			

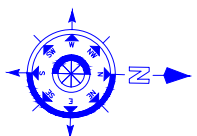

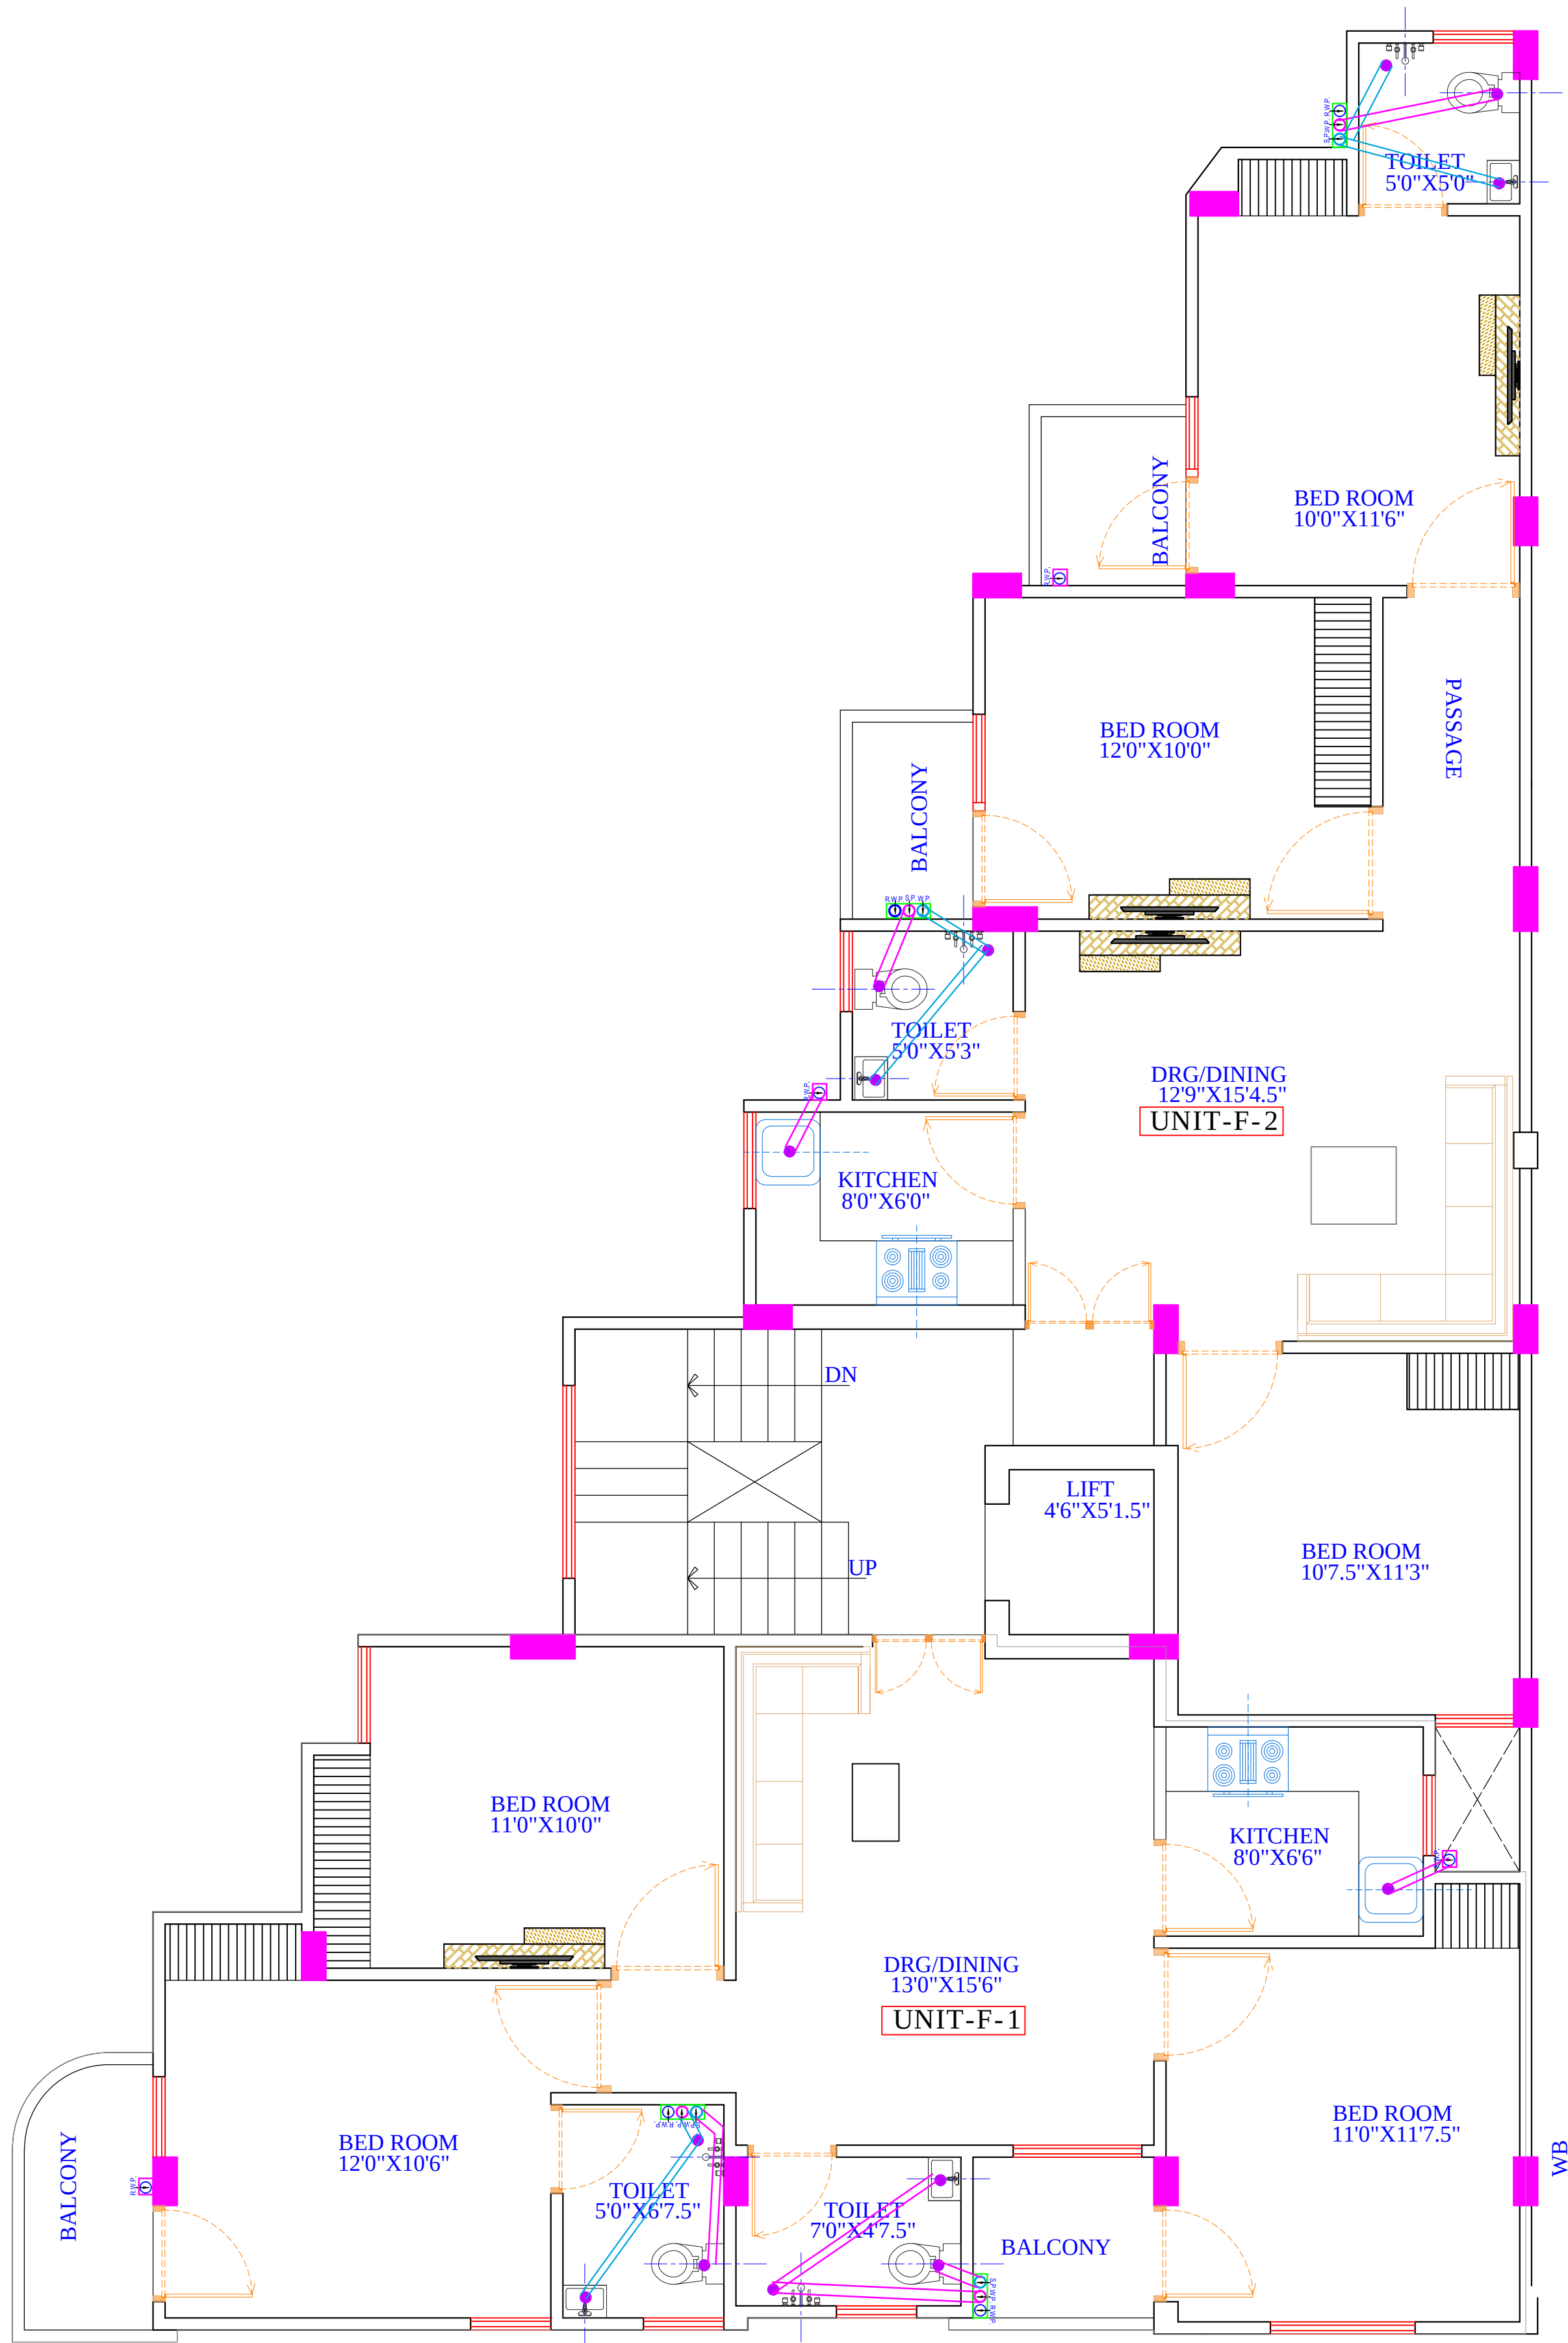

For Shree Salasar Developers
Proprietor

Krishna
KRISHNA KUMAR
B. Tech. (Mechanical)
M.E.P Consultant

LEGENDS

S.NO.	SYMBOL	DESCRIPTION
1.		SDR-11 Fresh Water Pipe
2.		SDR-11 Solar Water Pipe
3.		Waste Water Pipe (W.P.)
4.		Soil Pipe (S.P.)
5.		Rain Water Pipe (R.W.P.)
6.		Butter Fly Valve(B.F.V.)
7.		Geyser
8.		RO
9.		Single Lever Diverter
10.		Concealed Valve
11.		Angle Valve
12.		Nahani Trap
13.		P-Trap
14.		Tap
15.		Floor Drain (F.D.)
16.		Plain Tee (P-tee)
17.		Gully Trap (G.T.)
18.		

WARNING

1. This drawing is the sole copyright of Architects **VISTAAR** and should be used for the purpose expressly issued.

GENERAL NOTES

- All dimensions are in feet and inches.
- Do not scale this drawing follow written dimensions only.
- This drawing should be read in conjunction with other architectural and structural drawings.
- Any discrepancy in the drawing should be immediately brought to the notice of architect.

PROJECT TITLE

SALASAR RESIDENCY
BUILDING AT PLOT-58,SUMER NAGAR
VISTAR-Q BLOCK,JAIPUR

DRAWING TITLE

GROUND TO 3TH FLOOR DRAINAGE PLAN

ARCHITECTS :


VISTAAR ARCHITECTS & PLANNERS

Architects :: Interior Designers
B-2/12, Chitrkoot scheme,
main Gandhi Path,Opp mall of jaipur,Jaipur
PH. - 0141-4116461,09001010366

PATH :-

DRN.	DATE	REV.	NORTH
MANGU KUMARAT	23-05-2022		
SCALE	JOB NO.		
NTS			

LEGENDS		
S.NO.	SYMBOL	DESCRIPTION
1.		SDR-11 Fresh Water Pipe
2.		SDR-11 Solar Water Pipe
3.		Waste Water Pipe (W.P.)
4.		Soil Pipe (S.P.)
5.		Rain Water Pipe (R.W.P.)
6.		Butter Fly Valve(B.F.V.)
7.		Geyser
8.		RO
9.		Single Lever Diverter
10.		Concealed Valve
11.		Angle Valve
12.		Nahani Trap
13.		P-Trap
14.		Tap
15.		Floor Drain (F.D.)
16.		Plain Tee (P-tee)
17.		Gully Trap (G.T.)
18.		

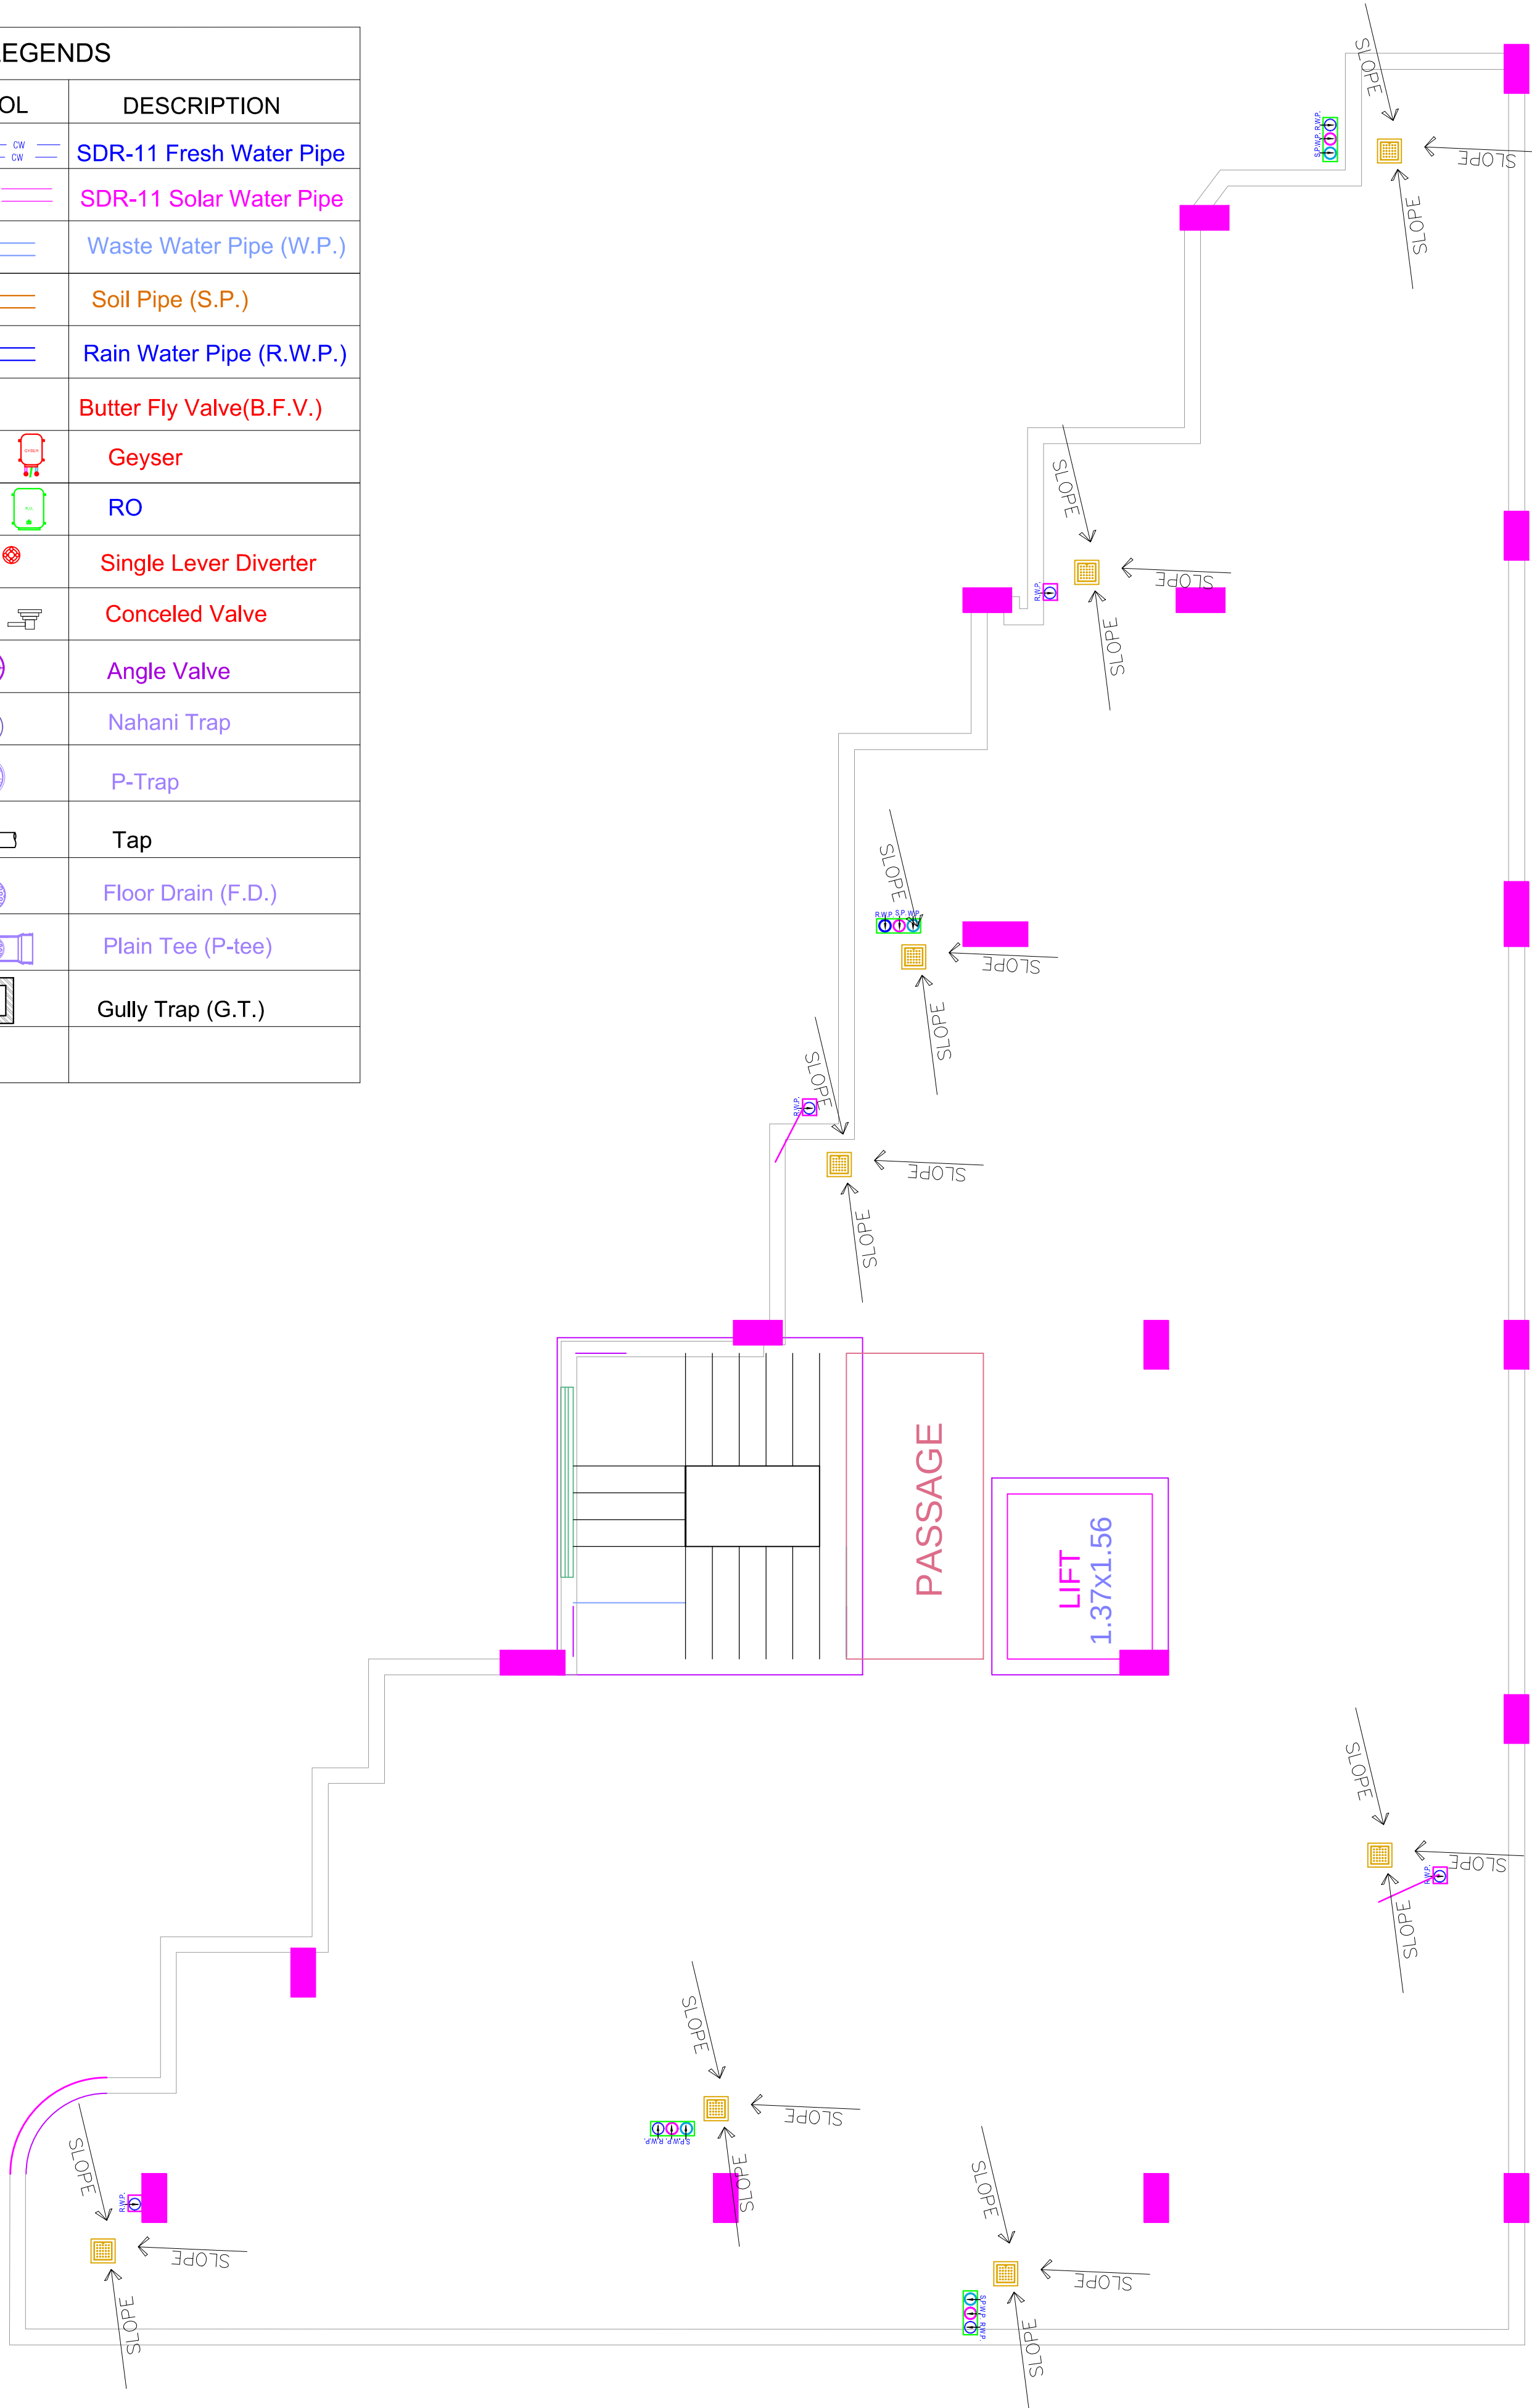

For Shree Salasar Developers
Proprietor

Krishna
KRISHNA KUMAR
B. Tech. (Mechanical)
M.E.P Consultant

WARNING
1. This drawing is the sole copyright of Architects **VISTAAR** and should be used for the purpose expressly issued.

GENERAL NOTES
1. All dimensions are in feet and inches.
2. Do not scale this drawing follow written dimensions only.
3. This drawing should be read in conjunction with other architectural and structural drawings.
4. Any discrepancy in the drawing should be immediately brought to the notice of architect.

PROJECT TITLE

SALASAR RESIDENCY
BUILDING AT PLOT-58,SUMER NAGAR
VISTAR-Q BLOCK,JAIPUR

DRAWING TITLE

TERRACE FLOOR DRAINAGE PLAN

ARCHITECTS :

VISTAAR ARCHITECTS & PLANNERS
Architects :: Interior Designers
B-2/12, Chitrkoot scheme,
main Gandhi Path,Opp mall of jaipur,Jaipur
PH.- 0141-4116461,09001010366

PRJ:-	DATE	REV.	
DRN:	25-06-2024		
MAKED BY:	JUBIN		
SCALE	1:1		
NTS			



PROJECT TITLE			
<p style="text-align: center;">SALASAR RESIDENCY BUILDING AT PLOT-58,SUMER NAGAR VISTAR-Q BLOCK,,JAIPUR</p>			
DRAWING TITLE			
<p style="text-align: center;">,SANITATION(,STORM WATER DRAINAGE, SEWERAGE,STP,SOLID WATER DISPOSAL) AND RAIN WATER HARVESTING PLAN</p>			
ARCHITECTS :			
<p>VISTAAR ARCHITECTS & PLANNERS Architects :: Interior Designers B-2/12, Chirkoot scheme, main Gandhi Path,Opp mall of jaipur,Jaipur PH - 0141-4116461,09001010366</p>			
P&T:-			
DEN.	DATE	REV.	NORTH
MANGI KUMAWAT	23-05-2022		
SCALE	JOB NO.		
NTS			