


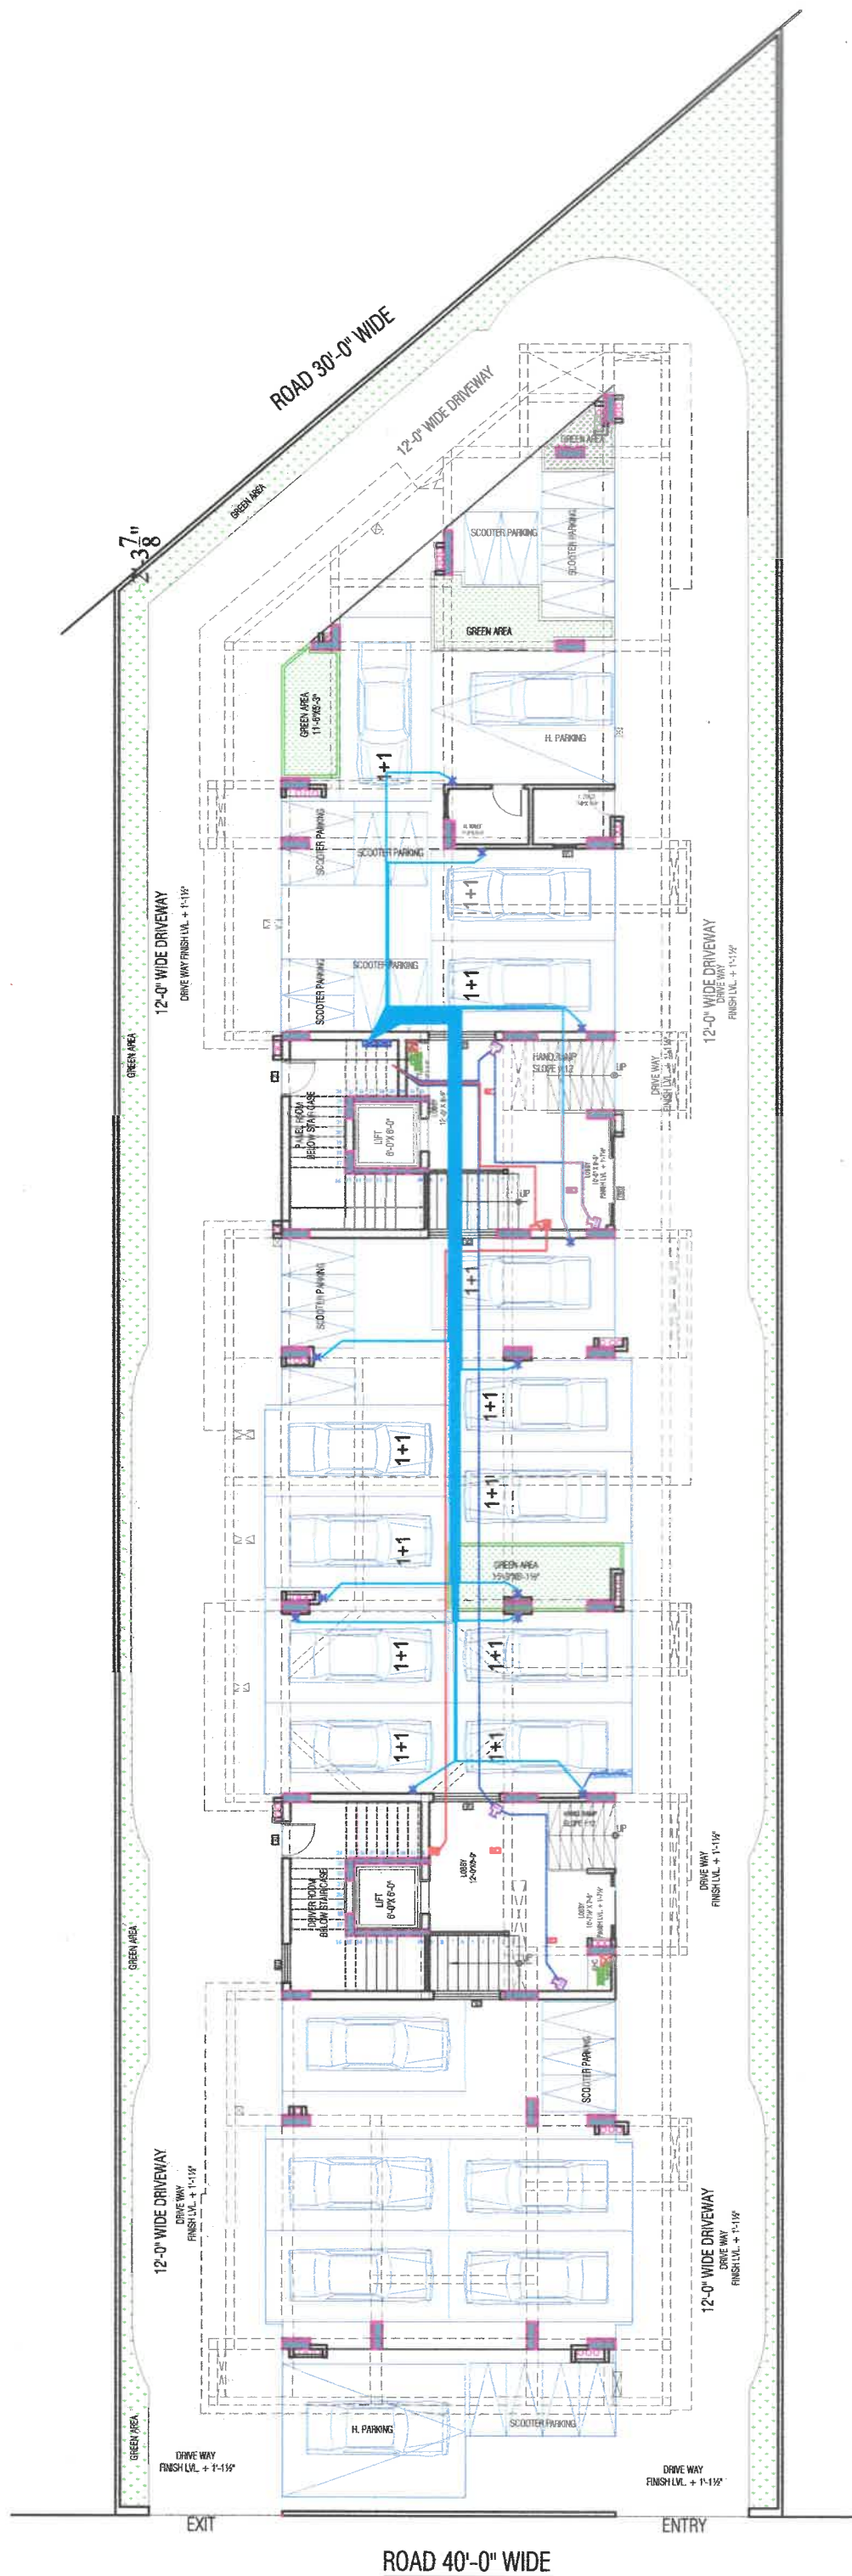

'RASIK RESIDENCY'
AT A-6 & A-11, NANDAN VIHAR,
JAGATPURA, JAIPUR.

LEGEND			
NO.	DESCRIPTION	SYMBOL	REMARKS
1	CORNER SWITCH		CEILING
2	STANDARD SWITCH		40'-0"
3	WALL SWITCH		40'-0"
4	A.C. SWITCH (1/2 HP)		40'-0"
5	A.C. SWITCH (1/4 HP)		40'-0"
6	TRANSFORMER		40'-0"
7	A.C. SWITCH		40'-0"
8	WATERPROOF SWITCH		40'-0"
9	OTHER SWITCH (1/2 HP)		40'-0"
10	WATERPROOF SWITCH		40'-0"
11	WALL SWITCH		40'-0"
12	A.C. SWITCH (1/2 HP)		40'-0"
13	A.C. SWITCH (1/4 HP)		40'-0"
14	A.C. SWITCH		40'-0"
15	TRANSFORMER (1/2 HP)		40'-0"
16	TRANSFORMER (1/4 HP)		40'-0"
17	A.C. SWITCH (1/2 HP)		40'-0"
18	WALL SWITCH		40'-0"
19	KEY TAG		40'-0"
20	WATERPROOF SWITCH		40'-0"
21	SWITCH (1/2 HP)		40'-0"
22	SWITCH (1/4 HP)		40'-0"
23	WALL		40'-0"
24	OTHER SWITCH (1/2 HP)		40'-0"
25	TRANSFORMER		40'-0"
26	TRANSFORMER (1/2 HP)		40'-0"
27	TRANSFORMER (1/4 HP)		40'-0"
28	TV POINT (1/2 HP)		40'-0"
29	LAN POINT		40'-0"
30	CEILING LIGHT		CEILING
31	CEILING LIGHT		CEILING
32	CEILING LIGHT		CEILING
33	NEW TUBE LIGHT ON CEILING		CEILING
34	BULB HOLDER ON SIDE WALL		7'-0"
35	TUBE LIGHT ON WALL		7'-0"
36	RECORDING BOARD		2'-0"
37	DISTRIBUTION BOX		5'-0"
38	BILL		7'-0"
39	CONCRETE CIRCUIT (1/2 HP)		CEILING
40	CONCRETE CIRCUIT (1/4 HP)		CEILING
41	CONCRETE CIRCUIT (1/2 HP)		CEILING
42	NEW TUBE LIGHT		CEILING
43	split ac		7'-0"
44	ac outdoor		7'-0"

MEP CONSULTANTS :
SRAJAN ASSOCIATES
C-SCHEME, JAIPUR
Email :- srajaipur@hotmail.com



REVISIONS			
NO.	ISSUED TO	CKD.	

PROJECT TITLE
'RASIK RESIDENCY'
AT A-6 & A-11, NANDAN VIHAR,
JAGATPURA, JAIPUR.

DRAWING TITLE
STILT FLOOR
ELECTRICAL PLAN

ARCHITECTS :
MISHRA GARG & ASSOCIATES
ARCHITECTS, PLANNERS & INTERIOR DESIGNERS
C-35A/ATK MARG, C-SCHEME, JAIPUR
TEL. : (0141) 237374, 510686
Email :- mishra.garg@gmail.com, mishra.garg@yahoo.com

DEALT	CHECKED	DATE	NORTH
RAHMAN		01-03-2023	
SCALE	JOB NO.	DRG. NO.	
N.T.S.		3.401	

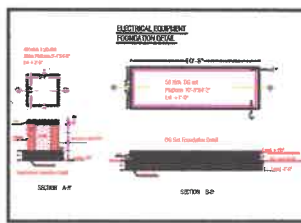 


AJAY DADHICH
(BTECH ELECT)

MEP CONSULTANTS :

SRAJAN ASSOCIATES
C-SCHEME, JAIPUR
Email :- snajipur@hotmail.com

REVISIONS

	PROJECT TITLE

'RASIK RESIDENCY'
AT A-6 & A-11, NANDAN VIHAR,
JAGATPURA, JAIPUR.

DRAWING TITLE	
---------------	--


STILT FLOOR
EXTERNAL SUBSTATION PLAN

ARCHITECTS :

MISHRA GARG & ASSOCIATES
ARCHITECTS, PLANNERS & INTERIOR DESIGNER
C-35, LAJPAT NAGAR C-Scheme, JAIPUR
TEL : (0141) 2373274, 5104988
Email-id :- mishra.garg@gmail.com,
mishra.garg@yahoo.com

DEALT	CHECKED	DATE	NORTH
RAHMAN	SK	24-08-2023	N →
SCALE	JOB NO.	DRG. NO.	
N.T.S		3.401	

ROAD 30'-0" WIDE

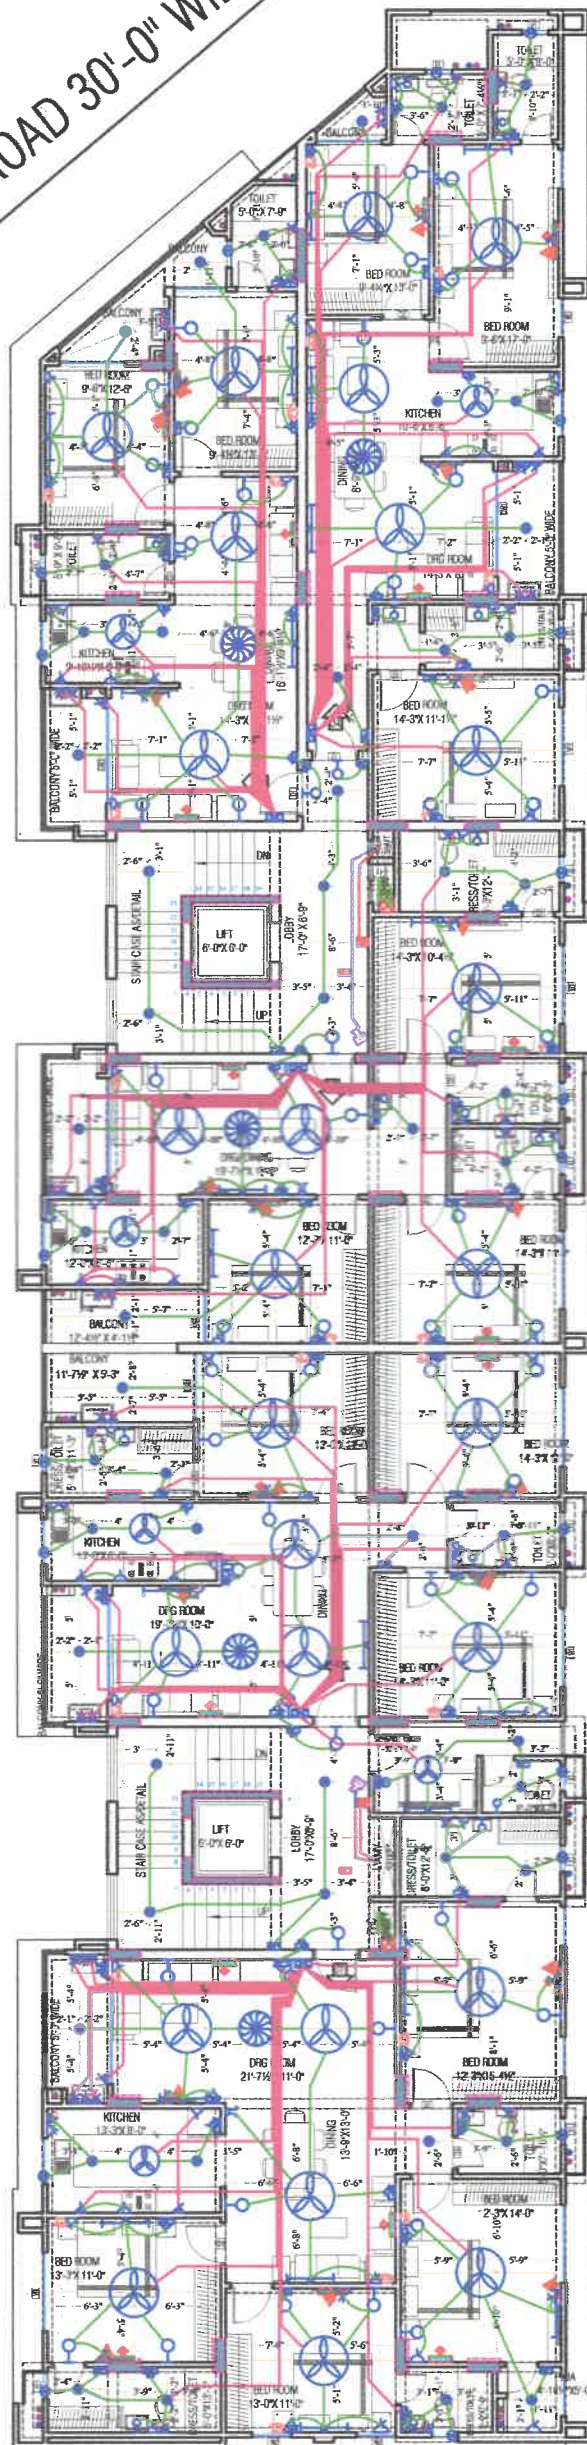

ROAD 40'-0" WIDE

'RASIK RESIDENCY'
AT A-6 & A-11, NANDAN VIHAR,
JAGATPURA, JAIPUR.

LEGEND			
NO	DESCRIPTION	SYMBOL	FROM FFL
1.	CEILING FAN		CEILING
2.	EXHAUST		6'-0"
3.	WALL SWITCH		6'-0"
4.	A/C POINT (WINDOW AC)		1'-0"
5.	A/C POINT (SPLIT AC)		AS PER ITS
6.	3 PHASE POINT		AS PER ITS
7.	A/C SOCKET		AS PER ITS
8.	16 AMP POWER PLUG (GENERAL)		1'-0"
9.	GYSEK SOCKET 16 AMP		6'-0"
10.	16 AMP POWER PLUG (GENERAL)		AS PER ITS
11.	16 AMP SOCKET		AS PER ITS
12.	6 AMP PLUG POINT (BED ROOM)		2'-6"
13.	6 AMP SOCKET (BED ROOM)		7'-0"
14.	6 AMP SOCKET (BED ROOM)		AS PER ITS
15.	2000 AMP POWER PLUG (GENERAL)		1'-0"
16.	2000 AMP POWER PLUG POINT		1'-0"
17.	6 AMP PLUG POINT (GENERAL)		1'-0"
18.	NIGHT LAMP		1'-0"
19.	KEY TAG		4'-0"
20.	INVERTER SOCKET		1'-0"
21.	SWITCH BOARD WITH 6 AMP POINT		4'-0"
22.	SWITCH BOARD WITH 6 AMP POINT		4'-0"
23.	SWITCH BOARD		4'-0"
24.	GYSEK SWITCH 16 AMP		4'-0"
25.	PROJECTOR POINT		3'-6"
26.	TELEPHONE POINT (GENERAL)		2'-6"
27.	TELEPHONE POINT (GENERAL)		1'-0"
28.	TV POINT (GENERAL)		2'-6"
29.	LAN POINT		2'-6"
30.	CEILING LIGHT FZ		CEILING
31.	CEILING LIGHT		CEILING
32.	CHANDLIER		CEILING
33.	40W TUBE LIGHT ON CEILING		CEILING
34.	BULB HOLDER ON SIDE WALL		7'-0"
35.	TUBE LIGHT ON WALL		7'-0"
36.	BULB HOLDER FOR RAMP		2'-6"
37.	DISTRIBUTION BOX		5'-0"
38.	BELL		7'-0"
39.	CONDUIT CIRCUIT (25MM)		CEILING
40.	CONDUIT POINT WINDING (25MM)		CEILING
41.	CONDUIT RED MAIN WINDING (25MM)		CEILING
42.	15W TUBE LIGHT		CEILING
43.	split ac		7'-0"
44.	ac outdoor		7'-0"

AYAJ DADHI
BTECH ELECT

MEP CONSULTANTS :

SRAJAN ASSOCIATES
C-SCHEME, JAIPUR
Email :- snajalpur@hotmail.com

REVISIONS

	NO.	ISSUED TO	CKD.

PROJECT TITLE

'RASIK RESIDENCY'
AT A-6 & A-11, NANDAN VIHAR,
JAGATPURA, JAIPUR.


DRAWING TITLE

1ST TO 6TH FLOOR
ELECTRICAL PLAN

ARCHITECTS :

MISHRA GARG & ASSOCIATES
ARCHITECTS, PLANNERS & INTERIOR DESIGNER
C-33, LAXMI NAGAR, C-SCHEME, JAIPUR
TEL. : 0141 231 3774, 510600
Email id :- misha.garg@gmail.com, misha.garg@yahoo.com

DEALT	CHECKED	DATE	NORTH
RAHMAN	AK	30-09-2022	
SCALE	JOB NO.	DRG. NO.	
NTS.		SA/RG/22/371	

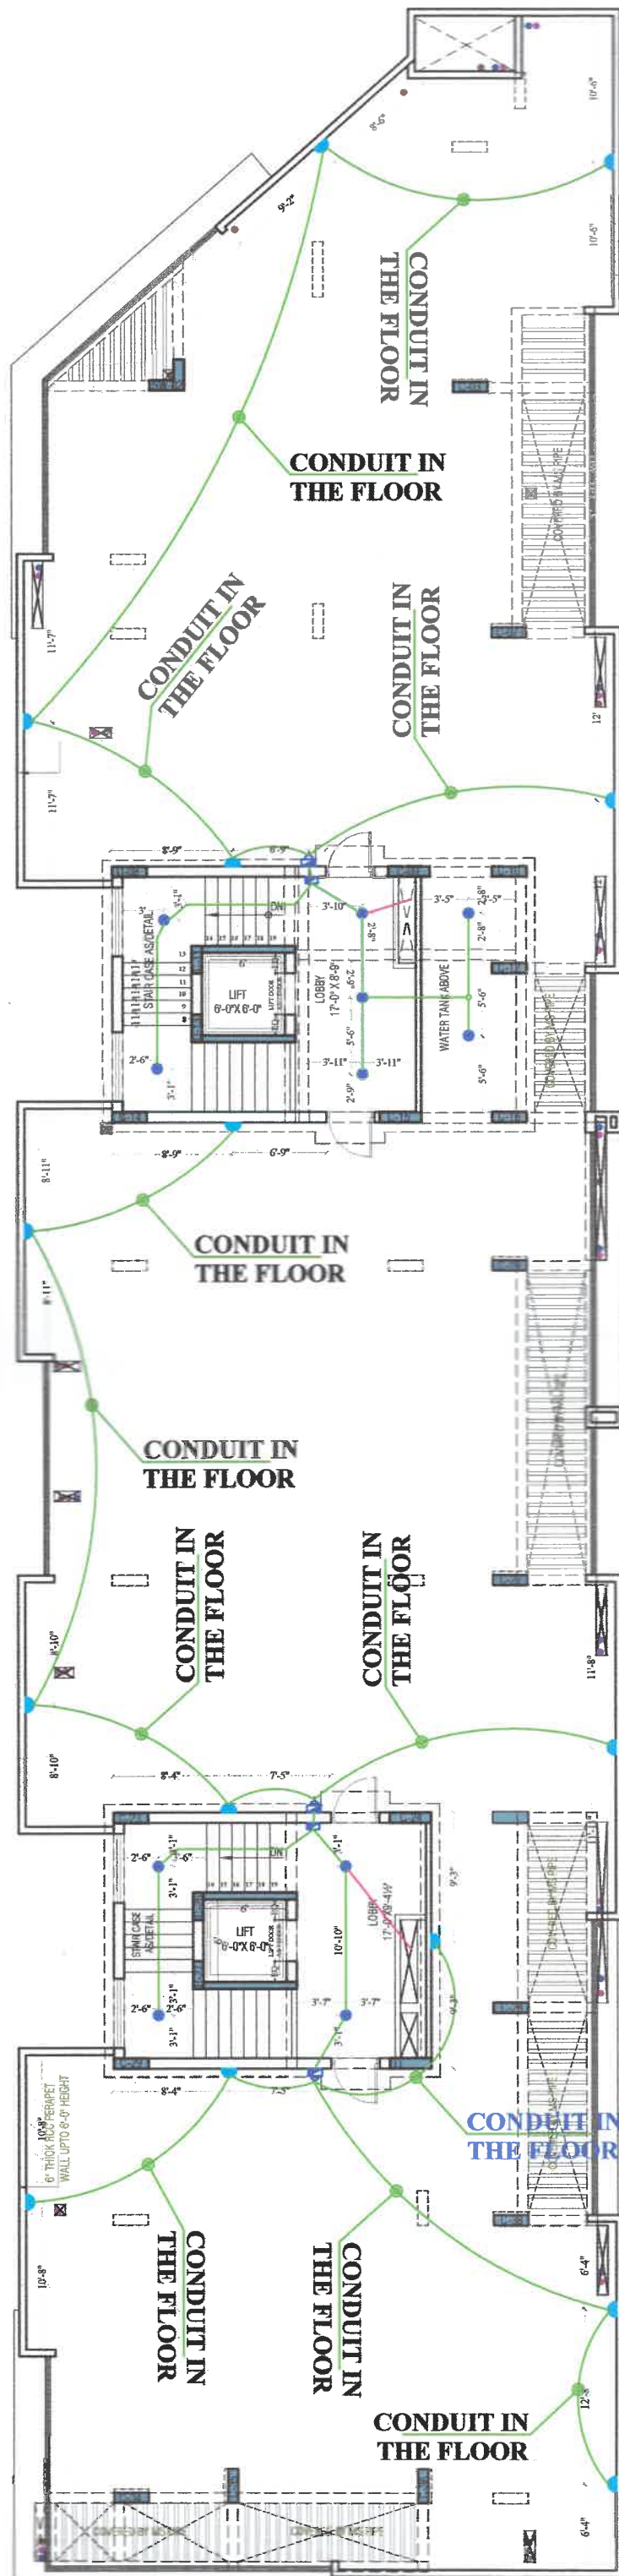

LEGEND			
NO	DESCRIPTION	SYMBOL	FROM FFL
1.	CEILING FAN		CEILING
2.	EXHAUST		6'-0"
3.	WALL FAN POINT		6'-0"
4.	A.C. POINT (WINDOW AC)		1'-0"
5.	A.C. POINT (SPLIT AC)		AS PER SITE
6.	3 PHASE POINT		AS PER SITE
7.	A.C. SOCKET		AS PER SITE
8.	16 AMP POWER PLUG POINT (GENERAL)		1'-0"
9.	GYSER SOCKET 16 AMP		6'-0"
10.	16 AMP POWER PLUG POINT (KITCHEN)		1'-0" ABOVE KITCHEN SLAB
11.	16 AMP SOCKET		AS PER SITE
12.	6 AMP PLUG POINT (BED SIDE)		2'-6"
13.	6 AMP SOCKET (CHIMNEY)		7'-0"
14.	6 AMP SOCKET		AS PER SITE
15.	2 NOS 6 AMP POWER PLUG POINT (FOR TV)		1'-0" / 4'-0"
16.	2 NOS 6 AMP POWER PLUG POINT		1'-0" / 4'-0"
17.	6 AMP PLUG POINT (GENERAL)		1'-0"
18.	NIGHT LAMP		1'-6"
19.	KEY TAG		4'-0"
20.	INVERTOR SOCKET		1'-6"
21.	SWITCH BOARD WITH OUT 6 AMP POINT		4'-0"
22.	SWITCH BOARD WITH 6 AMP POINT		4'-0"
23.	BELL RING		4'-0"
24.	GYSER SWITCH 16 AMP		4'-0"
25.	PROJECTOR POINT		3'-6"
26.	TELEPHONE POINT (BED SIDE)		2'-6"
27.	TELEPHONE POINT (GENERAL)		1'-0"
28.	TV POINT (GENERAL)		2'-6"
29.	LAN POINT		2'-6"
30.	CEILING LIGHT 2X2		CEILING
31.	CEILING LIGHT		CEILING
32.	CHANDELIER		CEILING
33.	40W TUBE LIGHT ON CEILING		CEILING
34.	BULB HOLDER ON SIDE WALL		7'-0"
35.	TUBE LIGHT ON WALL		7'-0"
36.	BULB HOLDER ON WALL		2'-6"
37.	DISTRIBUTION BOX		5'-6"
38.	BELL		7'-0"
39.	CONDUIT (GENERAL) (DRAWING)		CEILING
40.	CONDUIT (GENERAL) (DRAWING)		CEILING
41.	CONDUIT (GENERAL) (DRAWING)		CEILING
42.	40W TUBE LIGHT		CEILING
43.	split ac		7'-0"
44.	ac outdoor		7'-0"

Play
AJAY BATHIC
(BTECH ELECT)

MEP CONSULTANTS :

SRAJAN ASSOCIATES
C-SCHEME, JAIPUR
Email :- srajanpur@hotmail.com

REVISIONS

	NO.	ISSUED TO	CKD.

PROJECT TITLE

'RASIK RESIDENCY'
AT A-6 & A-11, NANDAN VIHAR,
JAGATPURA, JAIPUR.


DRAWING TITLE

TERRACE FLOOR
ELECTRICAL PLAN

ARCHITECTS :

MISHRA GARG & ASSOCIATES
ARCHITECTS PLANNERS & INTERIOR DESIGNERS
C-33, LAPAT, MARVEL SCHEME, JAIPUR
TEL. : (0141) 2372774, 2372775
Email :- mishra.garg@gmail.com, mishra.garg@yahoo.com

DEALT	CHECKED	DATE	NORTH
RAHMAN		04-05-2023	
SCALE	JOB NO.	DRG. NO.	
N.T.S.		3.401	

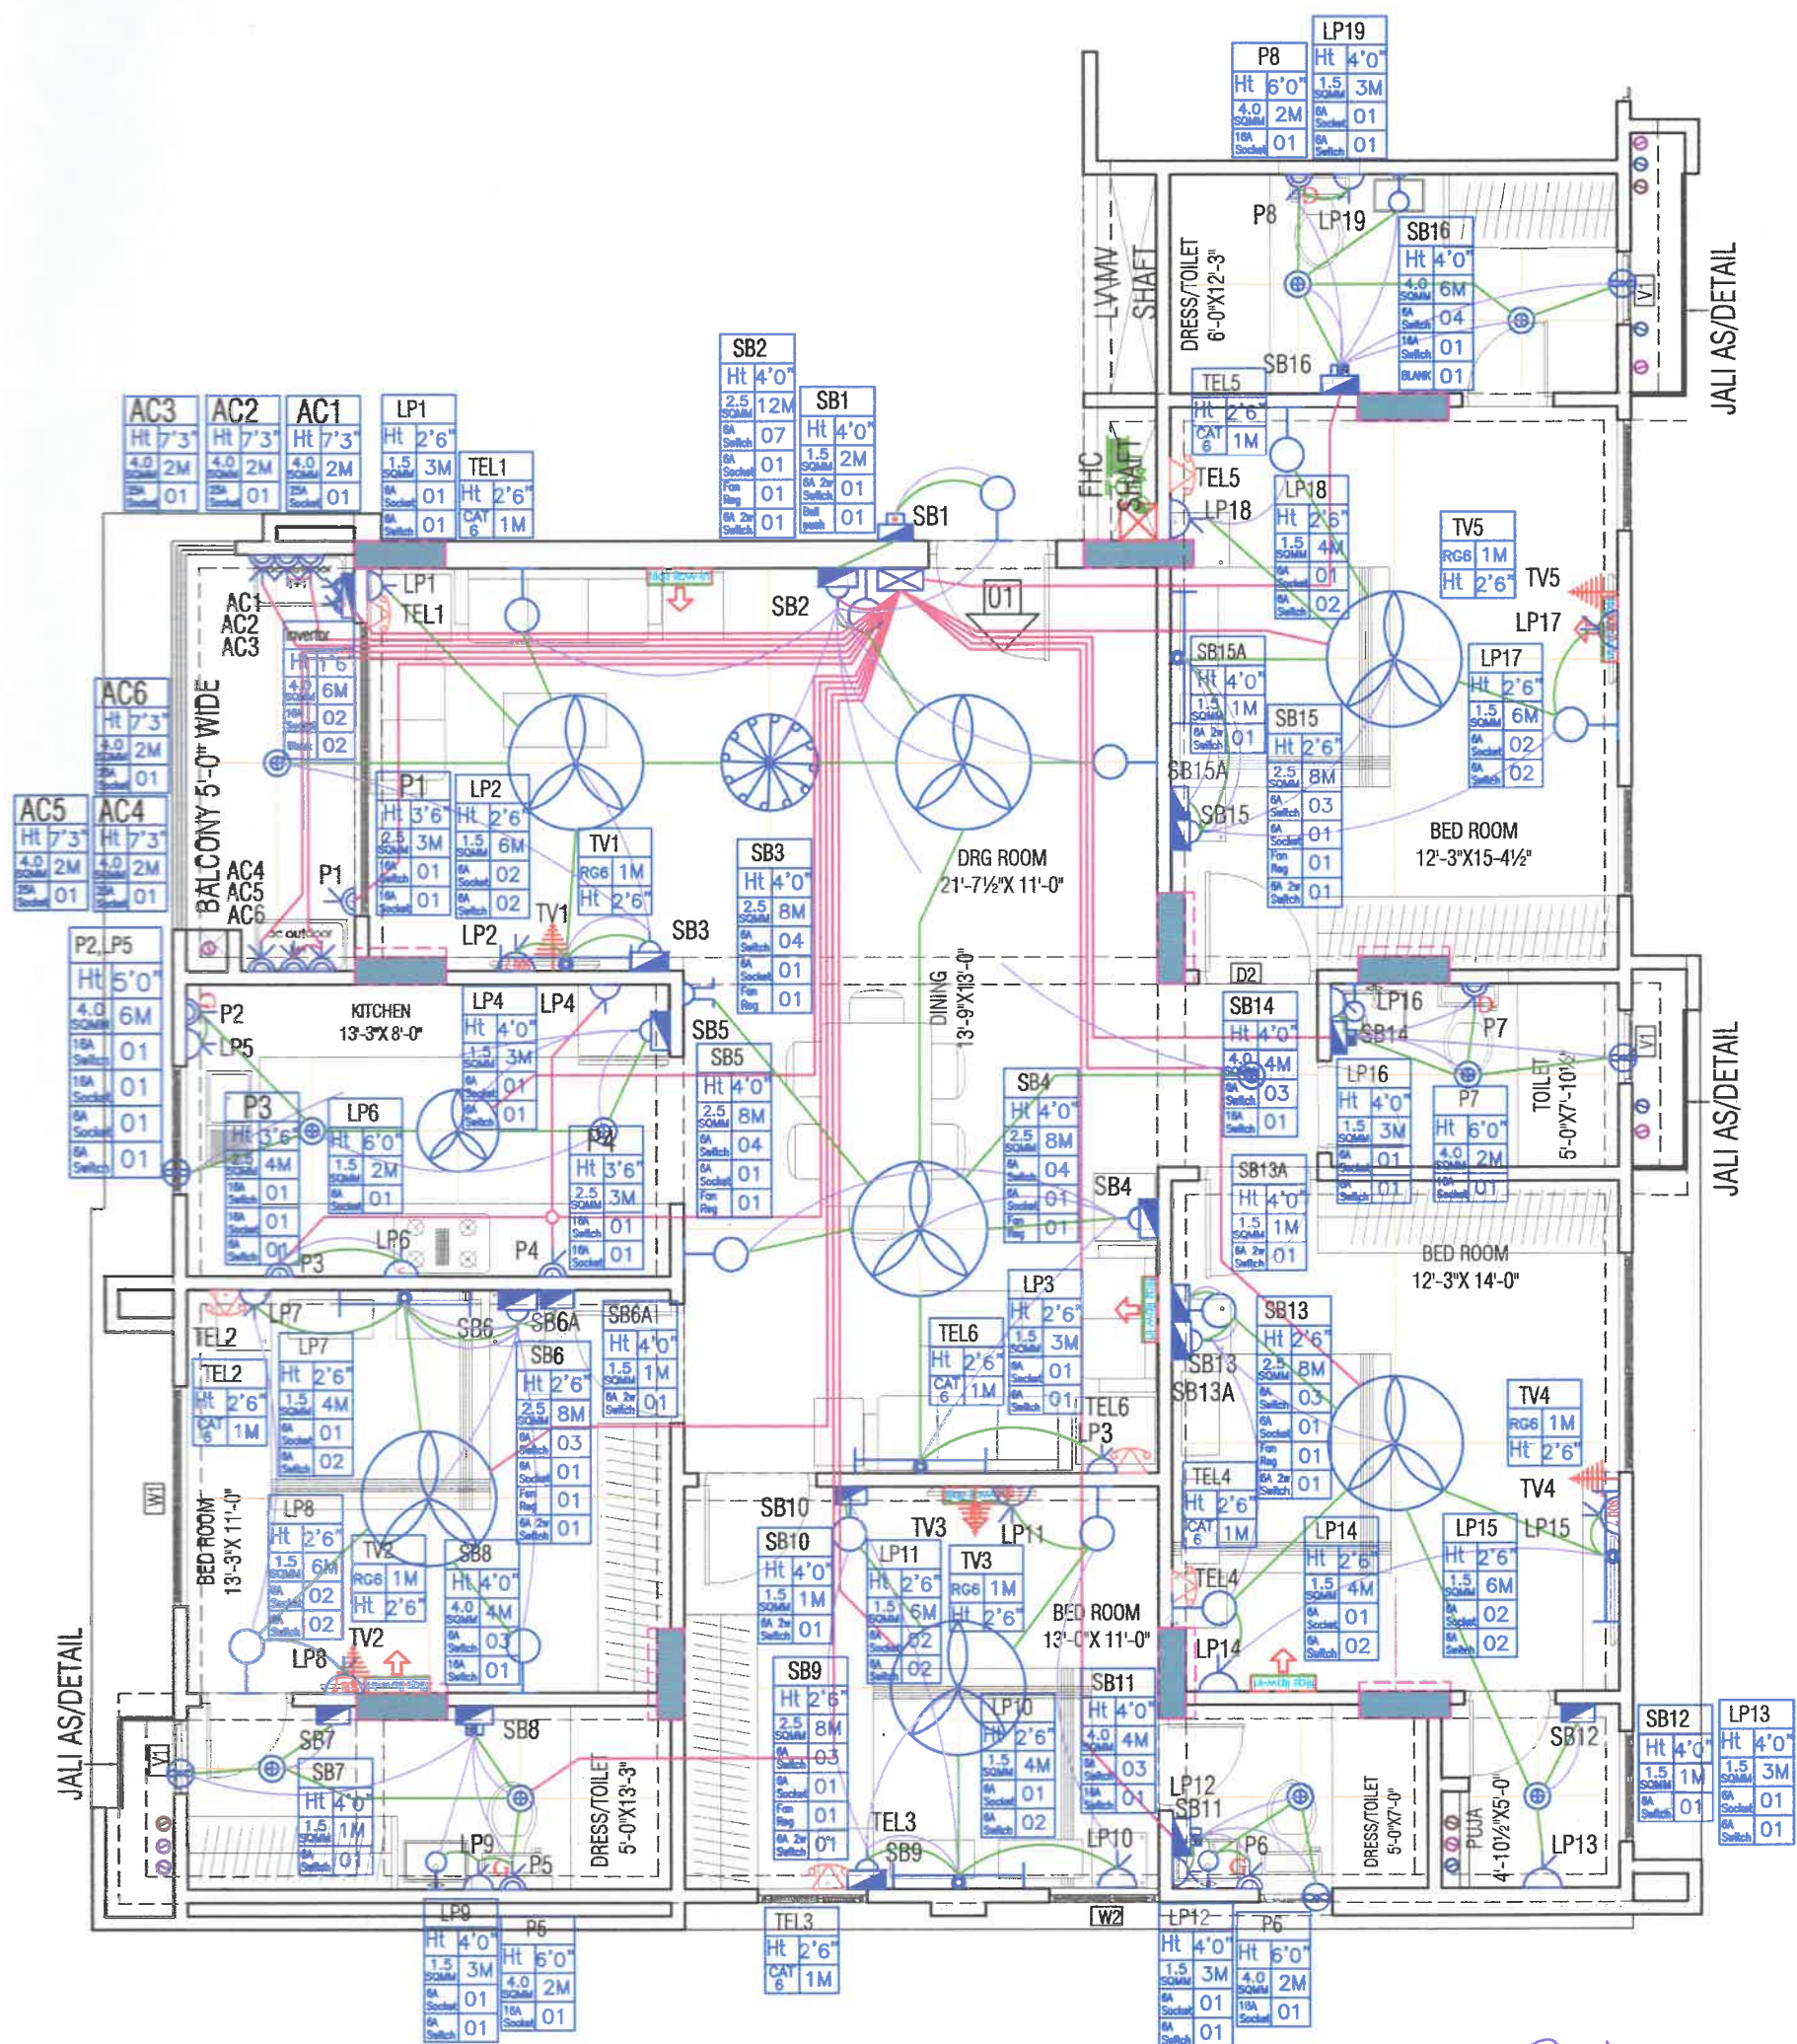

NO.	DESCRIPTION	SYMBOL	FROM H.T.
1.	CORRIDOR		00'-0"
2.	REAR/ENTRY		00'-0"
3.	WALL/ENTRY		00'-0"
4.	A.C. PORT/ENTRY AC		1'-0"
5.	A.C. PORT/ENTRY AC		1'-0"
6.	3 PHASE		1'-0"
7.	A.C. SOCKET		1'-0"
8.	4 AMP SOCKET (GENERAL)		1'-0"
9.	4 AMP SOCKET (GENERAL)		1'-0"
10.	4 AMP SOCKET (GENERAL)		1'-0"
11.	4 AMP SOCKET (GENERAL)		1'-0"
12.	4 AMP SOCKET (GENERAL)		1'-0"
13.	4 AMP SOCKET (GENERAL)		1'-0"
14.	4 AMP SOCKET (GENERAL)		1'-0"
15.	4 AMP SOCKET (GENERAL)		1'-0"
16.	4 AMP SOCKET (GENERAL)		1'-0"
17.	4 AMP SOCKET (GENERAL)		1'-0"
18.	4 AMP SOCKET (GENERAL)		1'-0"
19.	4 AMP SOCKET (GENERAL)		1'-0"
20.	4 AMP SOCKET (GENERAL)		1'-0"
21.	4 AMP SOCKET (GENERAL)		1'-0"
22.	4 AMP SOCKET (GENERAL)		1'-0"
23.	4 AMP SOCKET (GENERAL)		1'-0"
24.	4 AMP SOCKET (GENERAL)		1'-0"
25.	4 AMP SOCKET (GENERAL)		1'-0"
26.	4 AMP SOCKET (GENERAL)		1'-0"
27.	4 AMP SOCKET (GENERAL)		1'-0"
28.	4 AMP SOCKET (GENERAL)		1'-0"
29.	4 AMP SOCKET (GENERAL)		1'-0"
30.	4 AMP SOCKET (GENERAL)		1'-0"
31.	4 AMP SOCKET (GENERAL)		1'-0"
32.	4 AMP SOCKET (GENERAL)		1'-0"
33.	4 AMP SOCKET (GENERAL)		1'-0"
34.	4 AMP SOCKET (GENERAL)		1'-0"
35.	4 AMP SOCKET (GENERAL)		1'-0"
36.	4 AMP SOCKET (GENERAL)		1'-0"
37.	4 AMP SOCKET (GENERAL)		1'-0"
38.	4 AMP SOCKET (GENERAL)		1'-0"
39.	4 AMP SOCKET (GENERAL)		1'-0"
40.	4 AMP SOCKET (GENERAL)		1'-0"
41.	4 AMP SOCKET (GENERAL)		1'-0"
42.	4 AMP SOCKET (GENERAL)		1'-0"
43.	4 AMP SOCKET (GENERAL)		1'-0"
44.	4 AMP SOCKET (GENERAL)		1'-0"
45.	4 AMP SOCKET (GENERAL)		1'-0"
46.	4 AMP SOCKET (GENERAL)		1'-0"
47.	4 AMP SOCKET (GENERAL)		1'-0"
48.	4 AMP SOCKET (GENERAL)		1'-0"
49.	4 AMP SOCKET (GENERAL)		1'-0"
50.	4 AMP SOCKET (GENERAL)		1'-0"

MEP CONSULTANTS :
SRAJAN ASSOCIATES
 C-SCHEME, JAIPUR
 Email :- srajan@rediffmail.com

REVISIONS	NO.	ISSUED TO	CKD.


PROJECT TITLE
'RASIK RESIDENCY'
 AT A-6 & A-11, NANDAN VIHAR,
 JAGATPURA, JAIPUR.

DRAWING TITLE
TYPICAL FLOOR
SWITCH & SOCKET PLAN FLAT -01

ARCHITECTS :
 MISHRA GARG & ASSOCIATES
 ARCHITECTS PLANNERS & INTERIOR DESIGNERS
 G-10, RAJAPALACE, C-SCHEME, JAIPUR
 TEL: 0141-25224, 25246
 Email: 45 - misha.garg@yahoo.com
 misha.garg@yahoo.com

DEALT	CHECKED	DATE	NOTED
RAJMAN		24-02-2023	
SCALE	JOB NO.	DRG. NO.	
N.T.S.		3401	

Day
ADARSH
BTECH (ELECT)

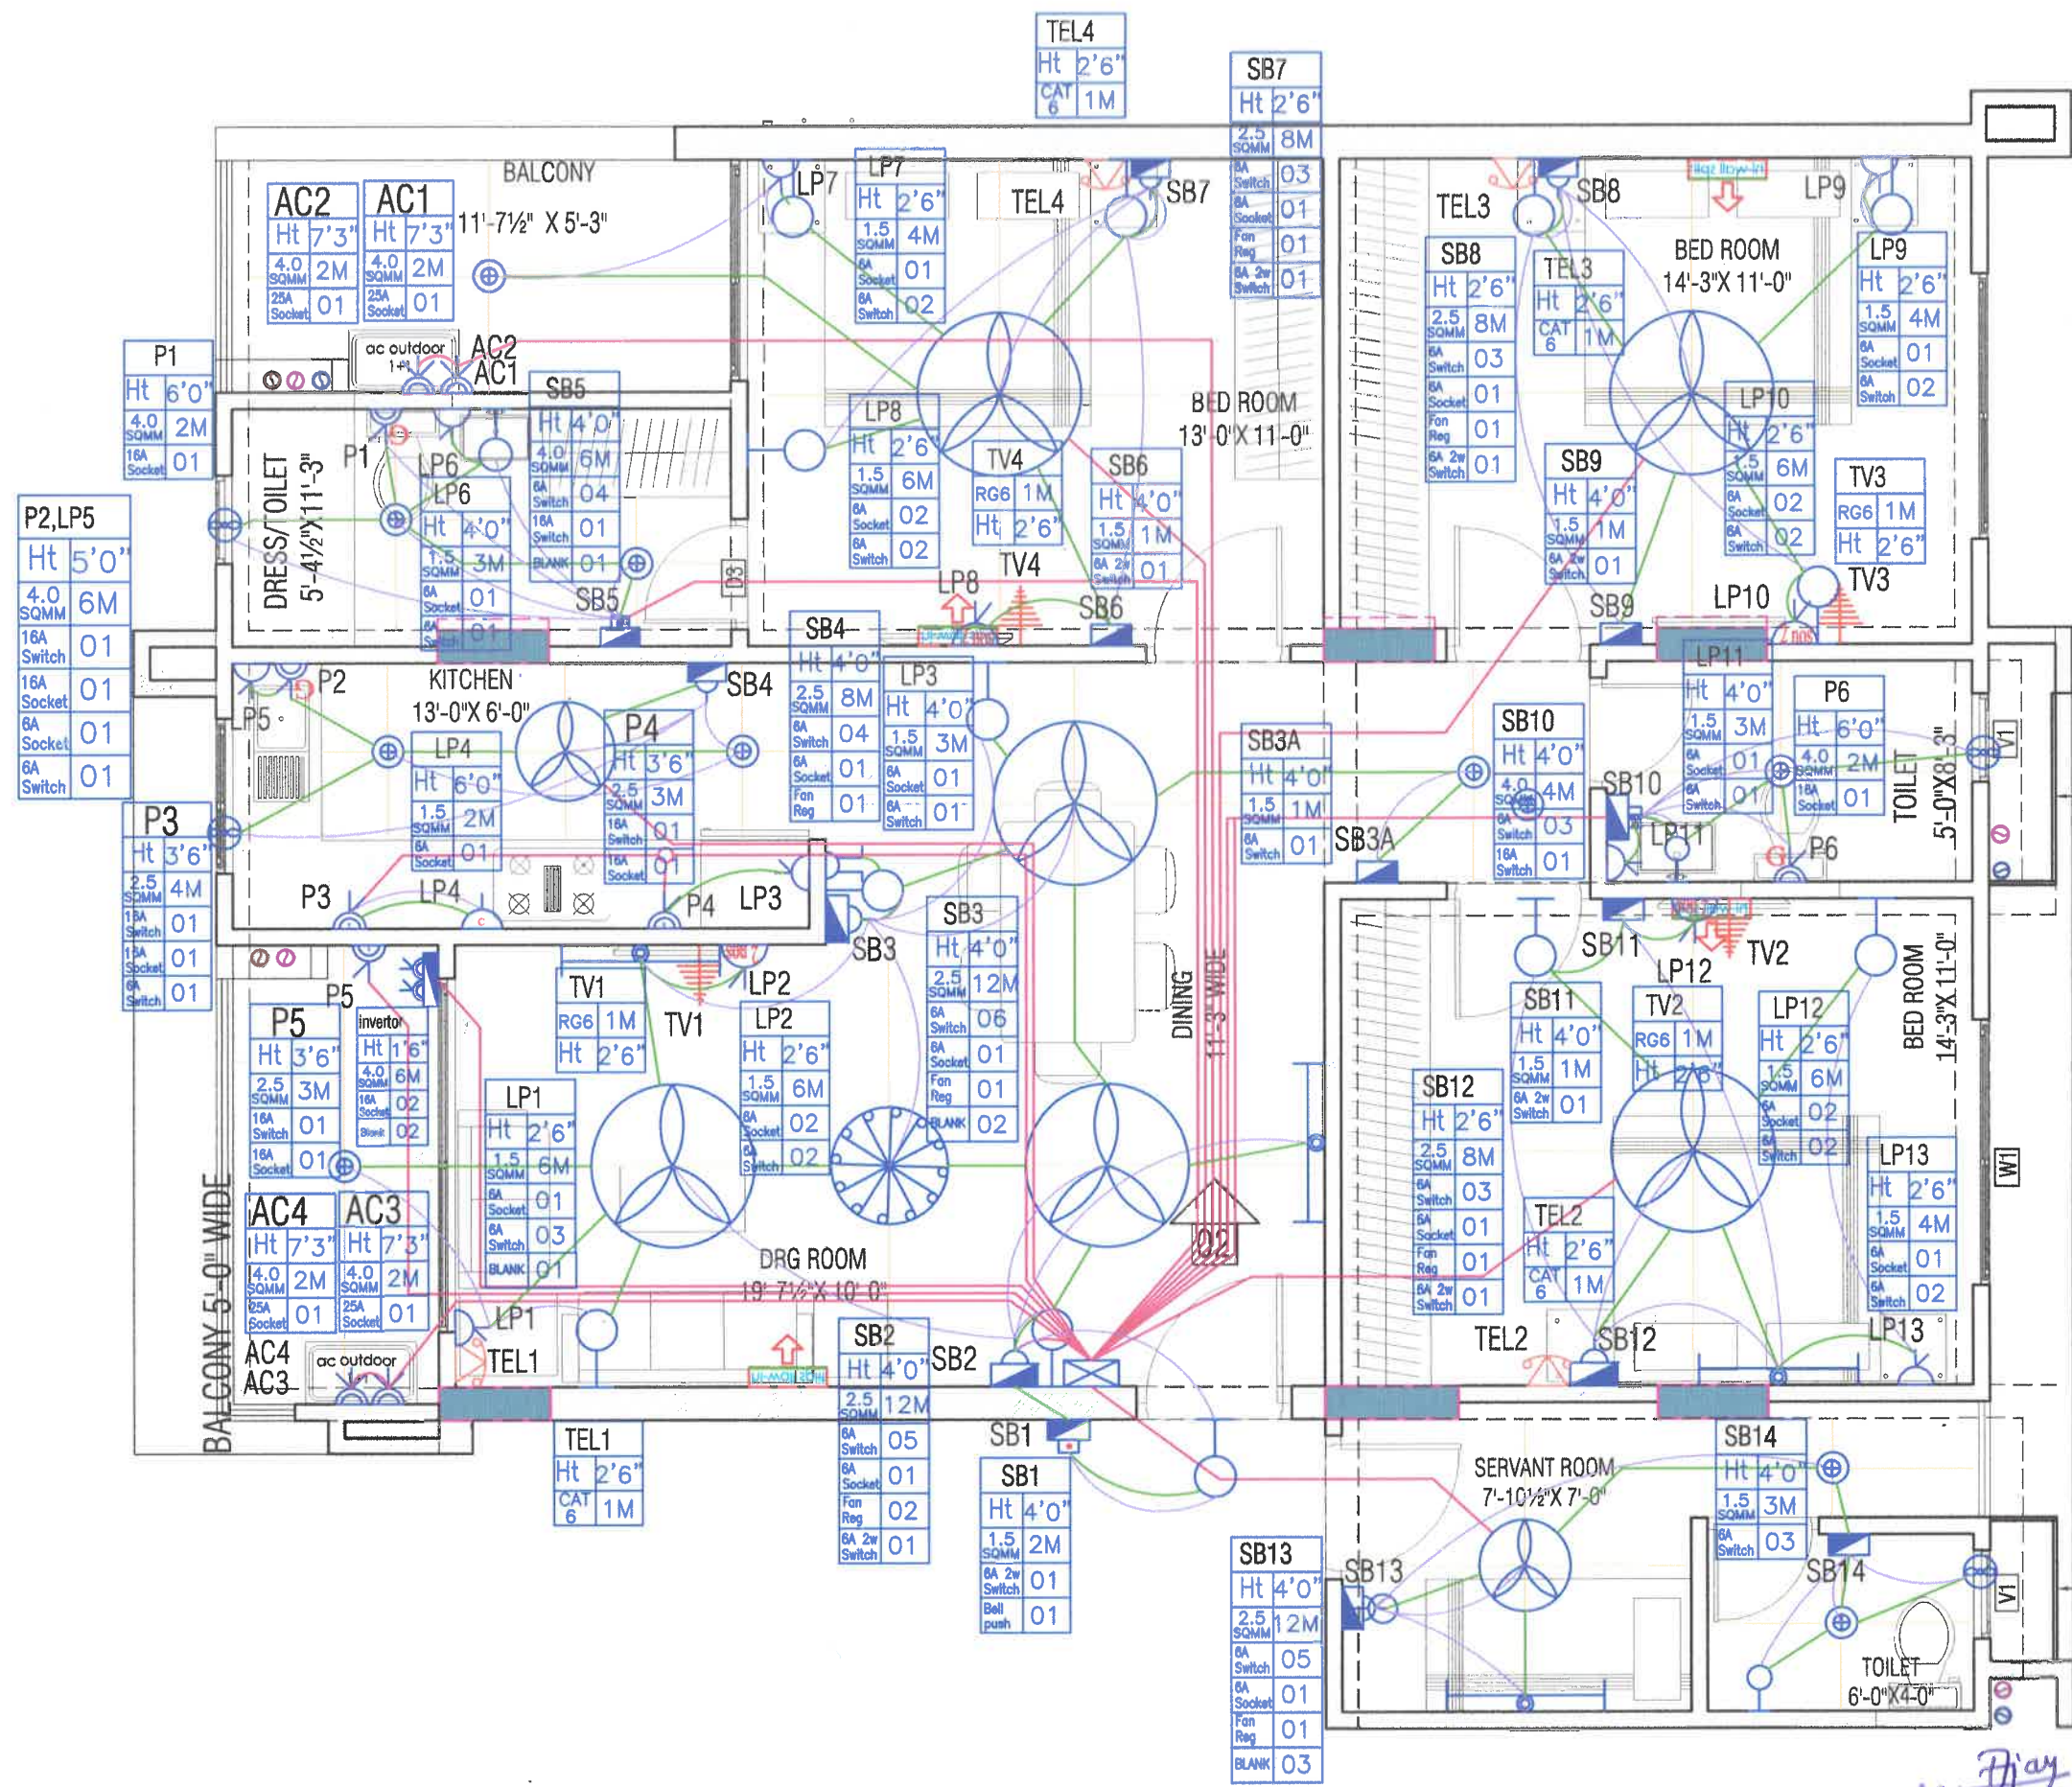

JALI AS/DETAIL

JALI AS/DETAIL

AYADADHICH
BTECH ELEC

NO.	DESCRIPTION	SYMBOL	UNIT
1.	CUTTING FAN		100-150"
2.	EXHAUST FAN		100-150"
3.	WALL FAN UNIT		100-150"
4.	A/C PORTER/DOOR AC		100-150"
5.	A/C PORTER/DOOR AC		100-150"
6.	FRIDGE UNIT		100-150"
7.	A/C SOCKET		100-150"
8.	16 AMP POWER PLUG POINT (GENERAL)		100-150"
9.	GYSEK SOCKET 16 AMP		100-150"
10.	16 AMP POWER PLUG POINT (GENERAL)		100-150"
11.	16 AMP SOCKET		100-150"
12.	6 AMP PLUG POINT (BED ROOM)		100-150"
13.	6 AMP SOCKET (CHAMBER)		100-150"
14.	6 AMP SOCKET		100-150"
15.	20W 6 AMP POWER PLUG POINT		100-150"
16.	20W 6 AMP POWER PLUG POINT		100-150"
17.	6 AMP PLUG POINT (GENERAL)		100-150"
18.	NIGHT LAMP		100-150"
19.	KEY TAG		100-150"
20.	INVERTER SOCKET		100-150"
21.	SWITCH BOARD WITH OUT 6 AMP POINT		100-150"
22.	SWITCH BOARD WITH 6 AMP POINT		100-150"
23.	ILLUMI		100-150"
24.	GYSEK SWITCH 16 AMP		100-150"
25.	PROJECTOR POINT		100-150"
26.	TELEPHONE PORT (GENERAL)		100-150"
27.	TELEPHONE PORT (GENERAL)		100-150"
28.	LAN POINT		100-150"
29.	CILING LIGHT 200		100-150"
30.	CILING LIGHT		100-150"
31.	CILING LIGHT		100-150"
32.	40W TUBE LIGHT ON CEILING		100-150"
33.	BUILD HOLDER ON SIDE WALL		100-150"
34.	TUBE LIGHT ON WALL		100-150"
35.	BEATHEAD FOR AMP		100-150"
36.	DISTRIBUTION BOX		100-150"
37.	BELL		100-150"
38.	CONDUIT CIRCUIT (CHAMBER)		100-150"
39.	CONDUIT PORT WITHIN (CHAMBER)		100-150"
40.	CONDUIT RUN MAIN WITHIN (CHAMBER)		100-150"
41.	LOW TUBE LIGHT		100-150"
42.	split ac		100-150"
43.	ac outdoor		100-150"

MEP CONSULTANTS :

SRAJAN ASSOCIATES
C-SCHEME, JAIPUR
Email :- snajalpur@hotmail.com

REVISIONS

NO.	ISSUED TO	CKD.

PROJECT TITLE

'RANIK RESIDENCY'
AT A-6 & A-11, NANDAN VIHAR,
JAGATPURA, JAIPUR.


DRAWING TITLE

TYPICAL FLOOR
SWITCH & SOCKET PLAN FLAT -02

ARCHITECTS

MISHRA GARG & ASSOCIATES
ARCHITECTS & ENGINEERS
B-10, LAXMI NAGAR, JALAN, JAIPUR.
Ph. 0141-2511111, 2511112
Fax. 0141-2511113
Email :- misha.garg@gmail.com

DATE	CHECKED	DATE	REVISION

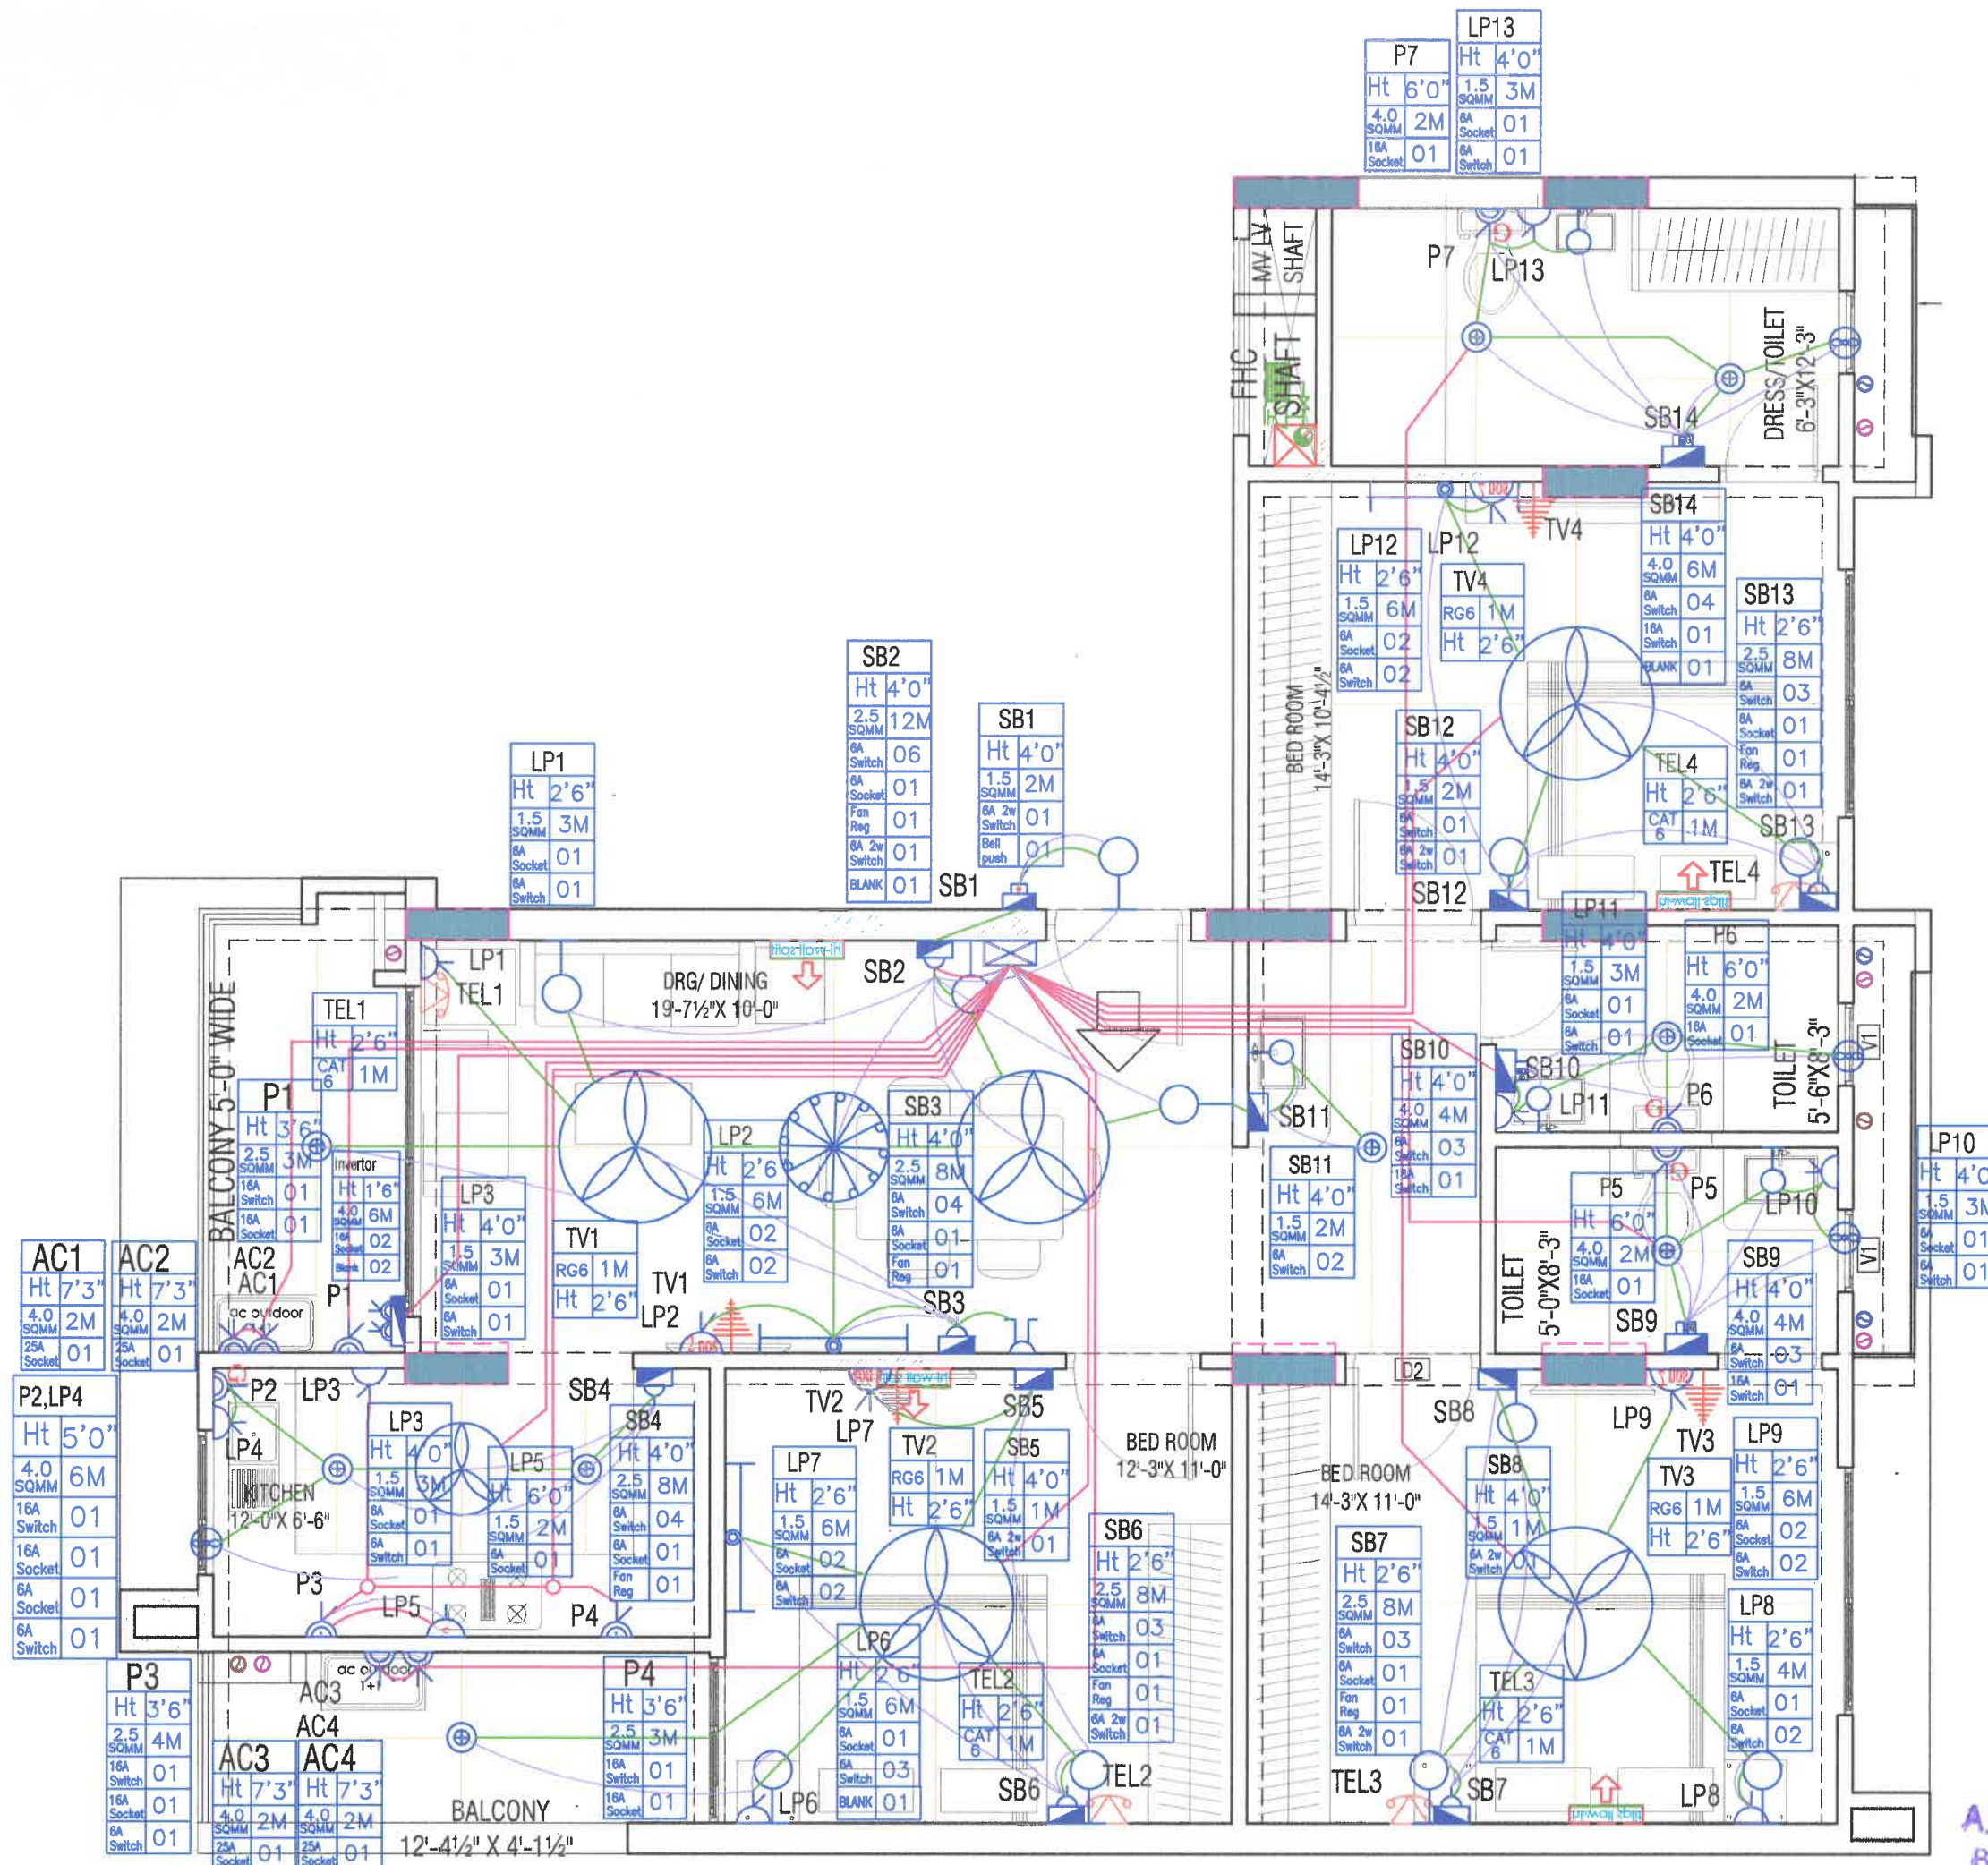

LEGEND			
NO	DESCRIPTION	SYMBOL	FROM PFL
1.	CEILING FAN		CEILING
2.	EXHAUST		6'-0"
3.	WALL FAN POINT		6'-0"
4.	A.C. POINT (WINDOW AC)		1'-0"
5.	A.C. POINT (SPLIT AC)		AS PER SITE
6.	3 PHASE POINT		AS PER SITE
7.	A.C. SOCKET		AS PER SITE
8.	16 AMP POWER PLUG POINT (GENERAL)		1'-0"
9.	CYBER SOCKET 16 AMP		6'-0"
10.	16 AMP POWER PLUG POINT (TOYOTA)		AS PER SITE
11.	16 AMP SOCKET		AS PER SITE
12.	6 AMP PLUG POINT (BED ROOM)		2'-6"
13.	6 AMP SOCKET (CERAMIC)		7'-0"
14.	6 AMP SOCKET		AS PER SITE
15.	16 AMP POWER PLUG POINT (TOYOTA)		1'-0"
16.	2 INCH 6 AMP POWER PLUG POINT		1'-0"
17.	6 AMP PLUG POINT (GENERAL)		1'-0"
18.	NIGHT LAMP		1'-0"
19.	KEY TAG		4'-0"
20.	INVERTER SOCKET		1'-0"
21.	SWITCH BOARD WITHOUT 6 AMP POINT		4'-0"
22.	SWITCH BOARD WITH 6 AMP POINT		4'-0"
23.	BELT		4'-0"
24.	CYBER SWITCH 16 AMP		4'-0"
25.	PROJECTOR POINT		3'-0"
26.	TELEPHONE POINT (BED ROOM)		2'-6"
27.	TELEPHONE POINT (GENERAL)		1'-0"
28.	TV POINT (GENERAL)		2'-6"
29.	LAN POINT		2'-6"
30.	CEILING LIGHT TYP		CEILING
31.	CEILING LIGHT		CEILING
32.	CHANDLIER		CEILING
33.	40W TUBE LIGHT ON CEILING		CEILING
34.	BULB HOLDER ON SIDE WALL		7'-0"
35.	TUBE LIGHT ON WALL		7'-0"
36.	SHARED FORAM		2'-6"
37.	DISTRIBUTION BOX		5'-0"
38.	BELL		7'-0"
39.	CONDUIT CIRCUIT (GND)		CEILING
40.	CONDUIT POINT WIRING (GND)		CEILING
41.	CONDUIT RUN MAIN WIRING (GND)		CEILING
42.	18W TUBE LIGHT		CEILING
43.	split ac		7'-0"
44.	ac outdoor		7'-0"

MEP CONSULTANTS :

SRAJAN ASSOCIATES
C-SCHEME, JAIPUR
Email :- snajalpur@hotmail.com

REVISIONS

NO.	ISSUED TO	CKD.

PROJECT TITLE

'RASIK RESIDENCY'
AT A-6 & A-11, NANDAN VIHAR,
JAGATPURA, JAIPUR.

DRAWING TITLE


TYPICAL FLOOR
SWITCH & SOCKET PLAN FLAT -03

ARCHITECTS :

WISHRA GARG & ASSOCIATES
ARCHITECTS, PLANNERS & INTERIORS
D-88, ALPURA ROAD, JAGATPURA, JAIPUR
TEL : 0141-2475757, 2475758
Email id : wishra.garg@gmail.com
www.wishra.gargassociates.com

DRAWN	CHECKED	DATE	REVISION
RAHMAN		24-03-2023	
SPATE			
N.T.S.			

Asay
ASAY DADHTI
BTECH ELEC

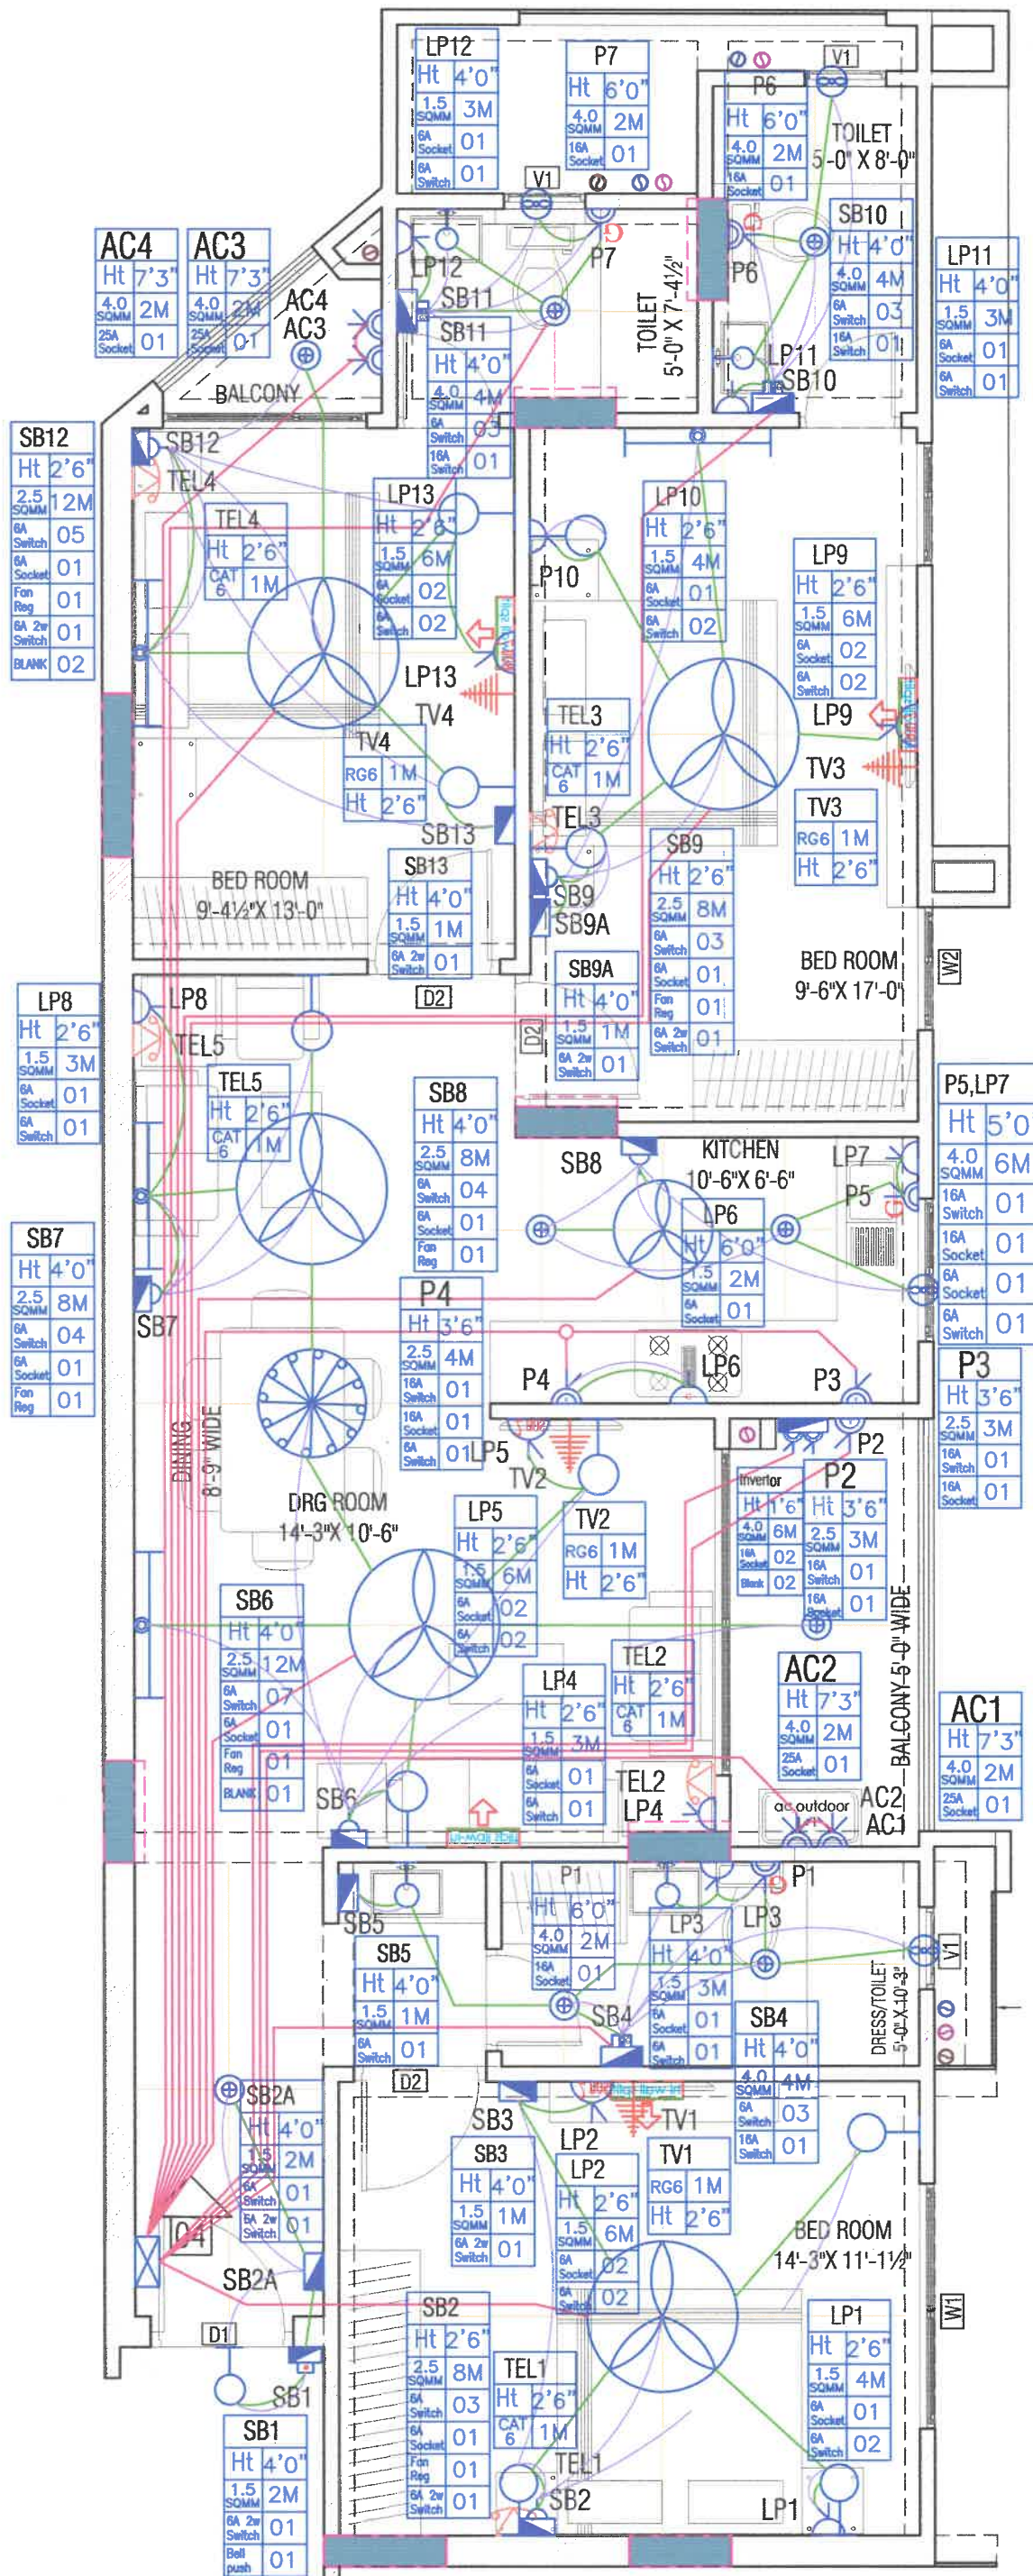

Hay
AJAY DADHIC
BTECH ELECT

NO	DESCRIPTION	SYMBOL	FROM FFL
1.	CEILING FAN		CEILING
2.	EXHAUST		6'-0"
3.	WALL FAN POINT		6'-0"
4.	A.C. POINT (WINDOW AC)		1'-0"
5.	A.C. POINT (SPLIT AC)		AS PER REQ.
6.	3 PHASE POINT		AS PER REQ.
7.	A.C. SOCKET		AS PER REQ.
8.	16 AMP POWER PLUG (GENERAL)		1'-0"
9.	CYBER SOCKET 16 AMP		6'-0"
10.	16 AMP POWER PLUG (GENERAL)		AS PER REQ.
11.	16 AMP SOCKET		AS PER REQ.
12.	6 AMP PLUG POINT (BED ROOM)		2'-6"
13.	6 AMP SOCKET (KITCHEN)		7'-0"
14.	6 AMP SOCKET		AS PER REQ.
15.	1254 AMP POWER PLUG (FOR TV)		1'-0"
16.	2 NOS 6 AMP POWER PLUG POINT		1'-0"
17.	6 AMP PLUG POINT (GENERAL)		1'-0"
18.	NEED LAMP		1'-6"
19.	KEY TAG		4'-0"
20.	INVERTOR SOCKET		1'-6"
21.	SWITCH BOARD WITH 6 AMP POINT		4'-0"
22.	SWITCH BOARD WITH 6 AMP POINT		4'-0"
23.	BELL		4'-0"
24.	CYBER SWITCH 16 AMP		4'-0"
25.	PROTECTOR POINT		3'-6"
26.	TRANSFER PORT (BED ROOM)		2'-6"
27.	TRANSFER PORT (KITCHEN)		1'-0"
28.	TV POINT (GENERAL)		2'-6"
29.	LAN POINT		2'-6"
30.	CEILING LIGHT 222		CEILING
31.	CEILING LIGHT		CEILING
32.	CHANDLER		CEILING
33.	40W TUBE LIGHT ON CEILING		CEILING
34.	BUILD HOLDER ON SIDE WALL		7'-0"
35.	TUBE LIGHT ON WALL		7'-0"
36.	EXHAUST PUMP		2'-6"
37.	DISTRIBUTION BOX		5'-6"
38.	BELL		7'-0"
39.	CONDUIT CHECKOUT (CSM)		CEILING
40.	CONDUIT POINT W/222 (CSM)		CEILING
41.	CONDUIT RUN MAIN W/222 (CSM)		CEILING
42.	10W TUBE LIGHT		CEILING
43.	split ac		7'-0"
44.	ac outdoor		7'-0"

MEP CONSULTANTS :

SRAJAN ASSOCIATES
C-SCHEME, JAIPUR
Email :- snajapur@hotmail.com

REVISIONS

NO.	ISSUED TO	CKD.

PROJECT TITLE

'RASIK RESIDENCY'
AT A-6 & A-11, NANDAN VIHAR,
JAGATPURA, JAIPUR.


DRAWING TITLE

TYPICAL FLOOR
SWITCH & SOCKET PLAN FLAT -04

ARCHITECTS :

MISHRA GARG & ASSOCIATES
ARCHITECTS, PLANNERS & INTERIOR DESIGNER
C-33, LAPAT MANG, C-SCHEME, JAIPUR.
TEL. : (0141) 237574, 510488
Email :- mishra.garg@gmail.com, mishra.garg@yahoo.com

DEALT	CHECKED	DATE	NORTH
RAHMAN		24-02-2023	
SCALE	JOB NO.	DRG. NO.	
N.T.S.		3.401	

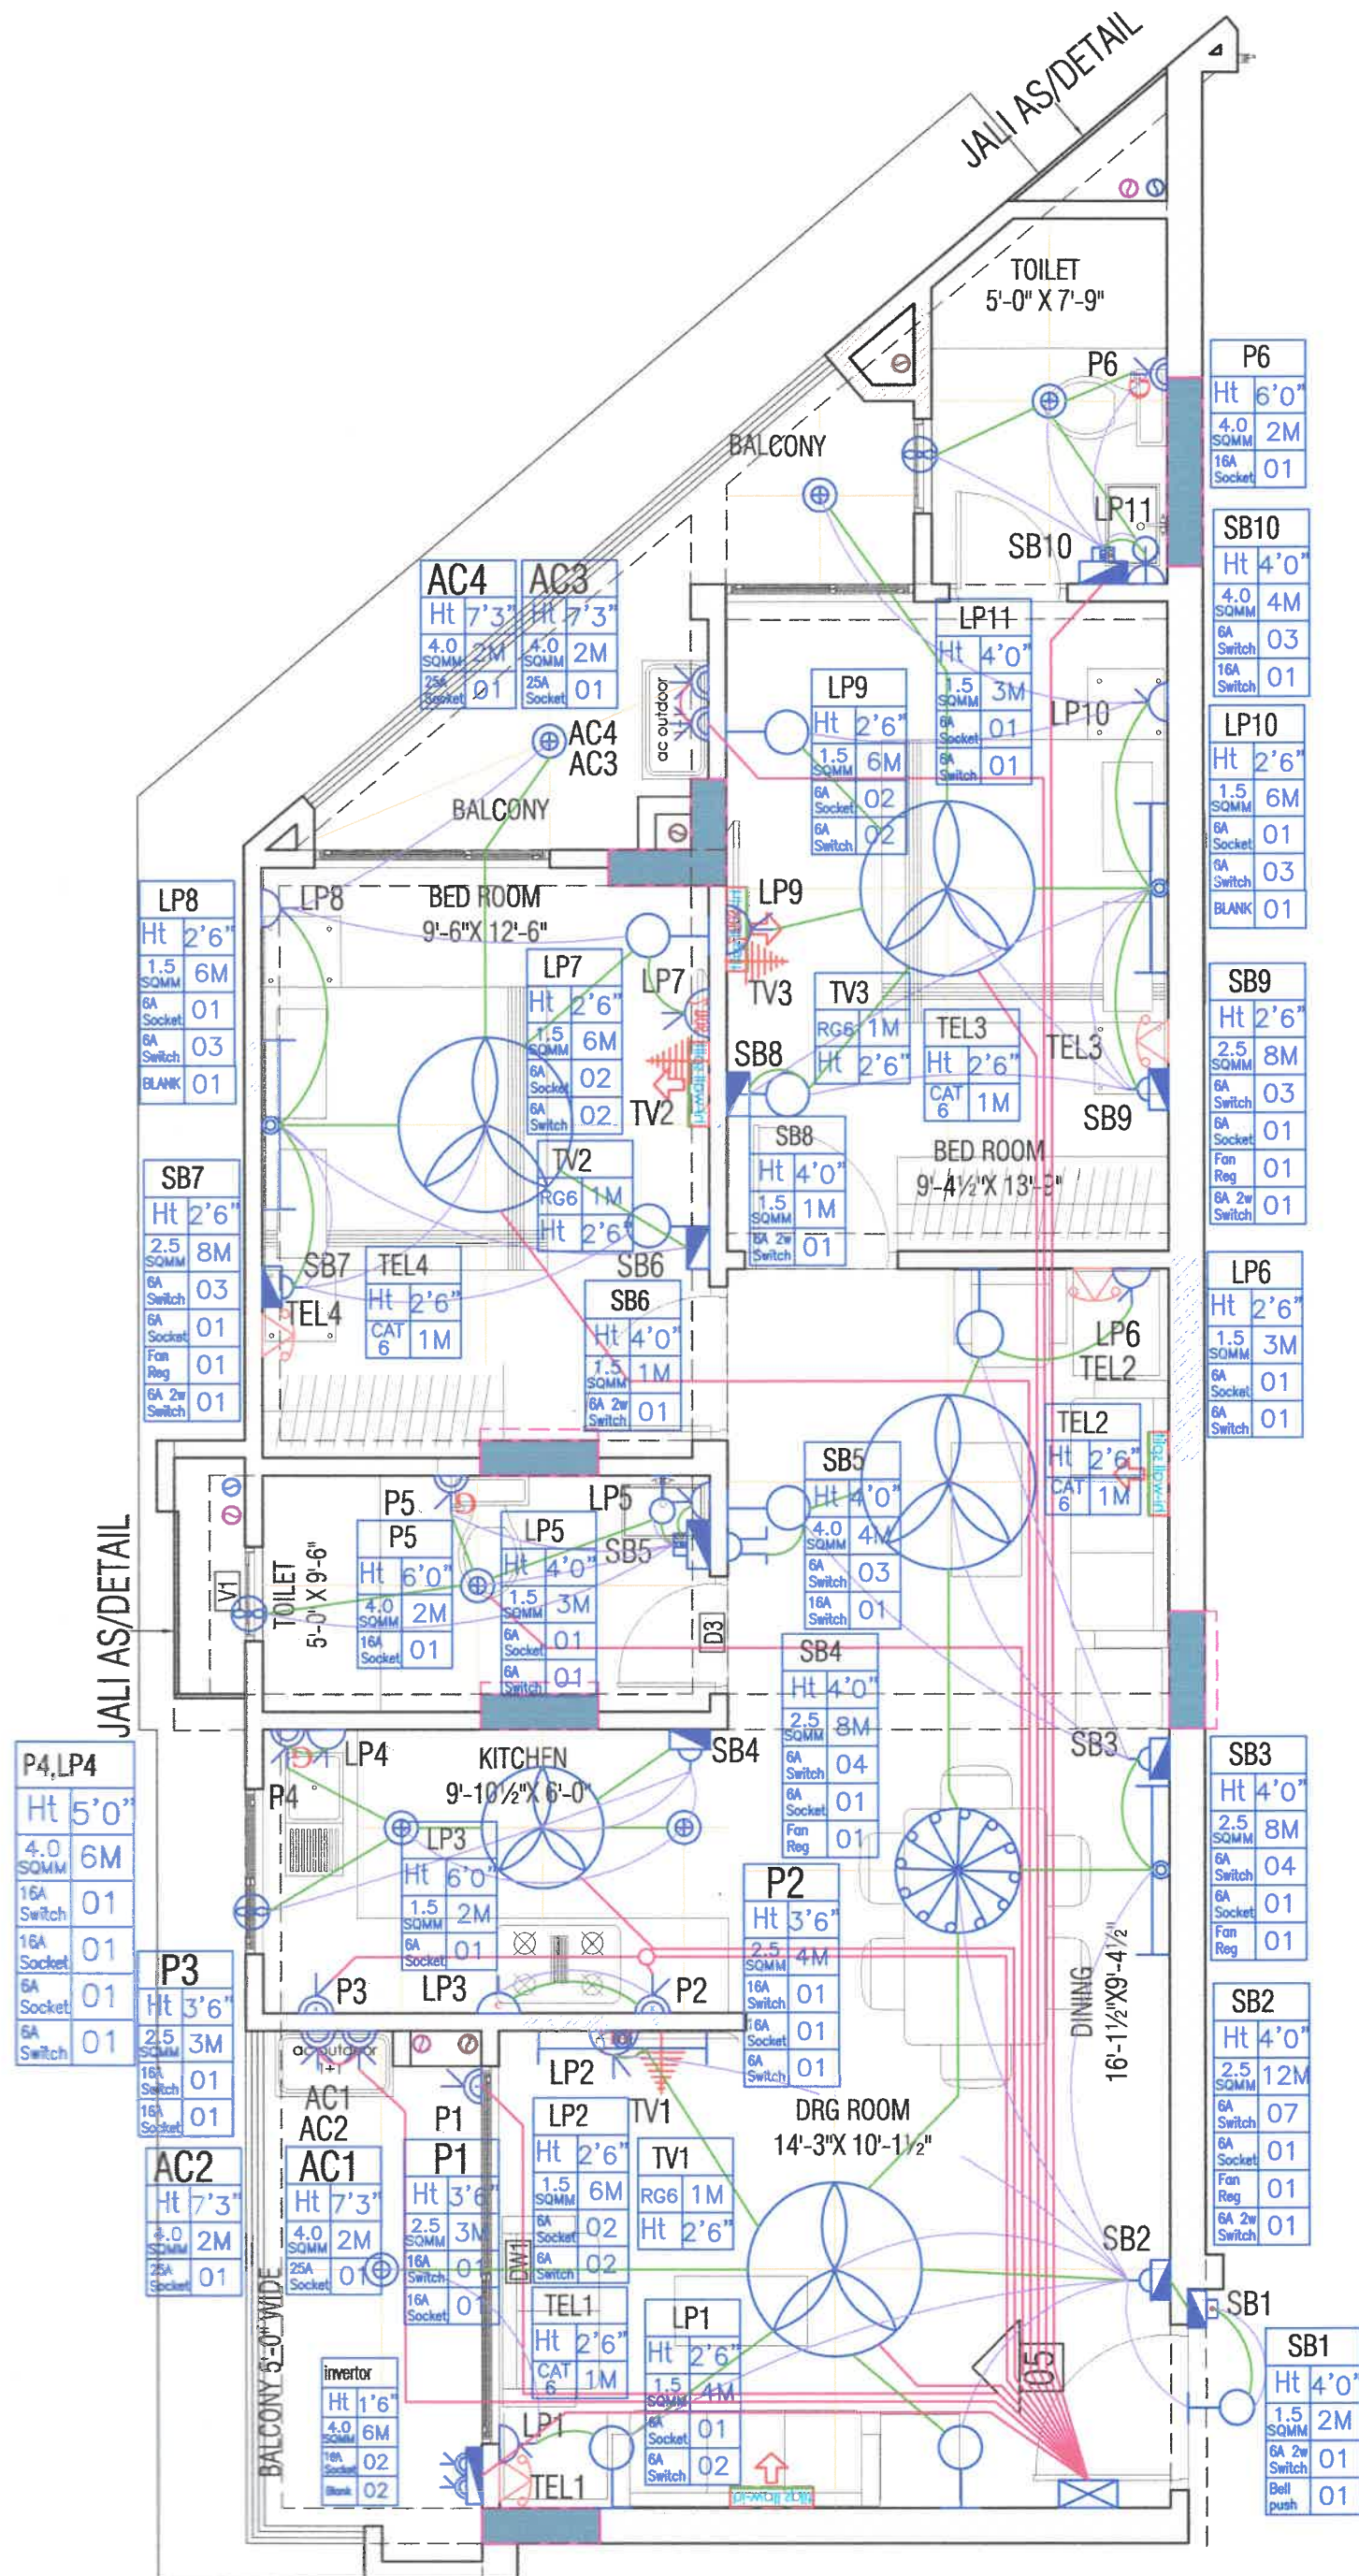

Ajay
AJAY DADHICI
BTECH ELECT)

LEGEND			
NO	DESCRIPTION	SYMBOL	FROM FFL
1.	CEILING FAN		CEILING
2.	EXHAUST		6'-0"
3.	WALL FAN POINT		6'-0"
4.	A.C. POINT (WINDOW A.C.)		1'-0"
5.	A.C. POINT (SPLIT A.C.)		AS PER SITE
6.	3 PHASE POINT		AS PER SITE
7.	A.C. SOCKET		AS PER SITE
8.	16 AMP POWER PLUG (GENERAL)		1'-0"
9.	GYSER SOCKET 16 AMP		6'-0"
10.	16 AMP POWER PLUG (KITCHEN)		1'-0"
11.	16 AMP SOCKET		AS PER SITE
12.	6 AMP PLUG POINT (BED ROOM)		2'-6"
13.	6 AMP SOCKET (KITCHEN)		7'-0"
14.	6 AMP SOCKET		AS PER SITE
15.	2 NO. 16 AMP POWER PLUG (B.T.)		1'-0"
16.	2 NO. 6 AMP POWER PLUG POINT		1'-0"
17.	6 AMP PLUG POINT (GENERAL)		1'-0"
18.	NIGHT LAMP		1'-6"
19.	KEY TAG		4'-0"
20.	INVERTER SOCKET		1'-6"
21.	SWITCH BOARD WITH OUT 6 AMP POINT		4'-0"
22.	SWITCH BOARD WITH 6 AMP POINT		4'-0"
23.	BELL PUSH		4'-0"
24.	GYSER SWITCH 16 AMP		4'-0"
25.	PROTECTOR POINT		3'-6"
26.	TELEPHONE POINT (BED)		2'-6"
27.	TELEPHONE POINT (GENERAL)		1'-0"
28.	TV POINT (GENERAL)		2'-6"
29.	LAN POINT		2'-6"
30.	CEILING LIGHT 220		CEILING
31.	CEILING LIGHT		CEILING
32.	CHANDLIER		CEILING
33.	40W TUBE LIGHT ON CEILING		CEILING
34.	BULB HOLDER ON SIDE WALL		7'-0"
35.	TUBE LIGHT ON WALL		7'-0"
36.	BULB HOLDER ON WALL		2'-6"
37.	DISTRIBUTION BOX		5'-6"
38.	BELL		7'-0"
39.	CONDUIT CIRCUIT (25MM)		CEILING
40.	CONDUIT POINT WIRING (25MM)		CEILING
41.	CONDUIT MAIN WIRING (25MM)		CEILING
42.	18W TUBE LIGHT		CEILING
43.	split ac		7'-0"
44.	ac outdoor		7'-0"

MEP CONSULTANTS :

SRAJAN ASSOCIATES
 C-SCHEME, JAIPUR
 Email :- snajipur@hotmail.com

REVISIONS

	NO.	ISSUED TO	CKD.

PROJECT TITLE

'RASIK RESIDENCY'
 AT A-6 & A-11, NANDAN VIHAR,
 JAGATPURA, JAIPUR.

DRAWING TITLE



TYPICAL FLOOR
SWITCH & SOCKET PLAN FLAT -05

ARCHITECTS :

MISHRA GARG & ASSOCIATES
 ARCHITECTS, PLANNERS & INTERIOR DESIGNER
 C-35, LAPOUR MARKET, SCHEME JAIPUR
 TEL : (0141) 227324, 510498
 Email-id :- mishra.garg@gmail.com, mishra.garg@yahoo.com

DEALT	CHECKED	DATE	NORTH
RAHMAN		24-02-2023	
SCALE	JOB NO.	DRG. NO.	
N.T.S.		3.401	

12WAY TPN DOUBLE DOOR

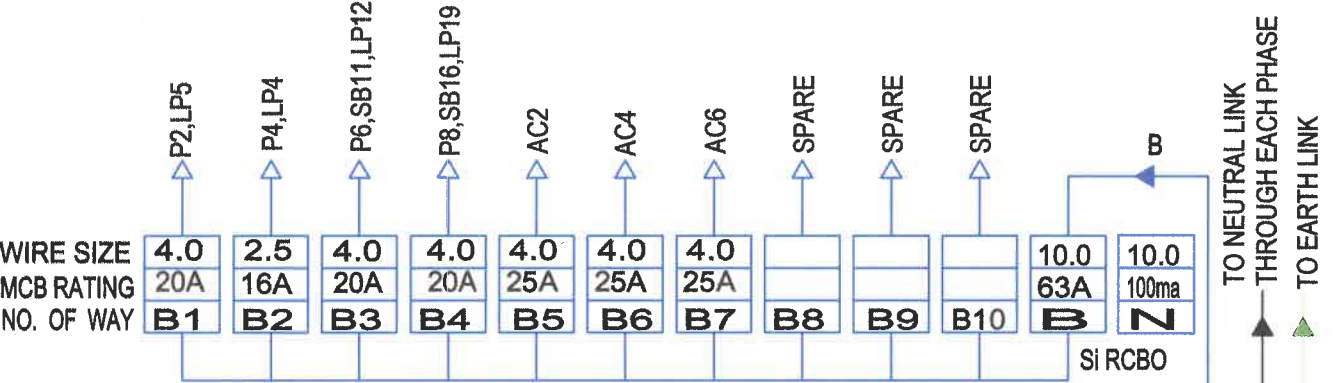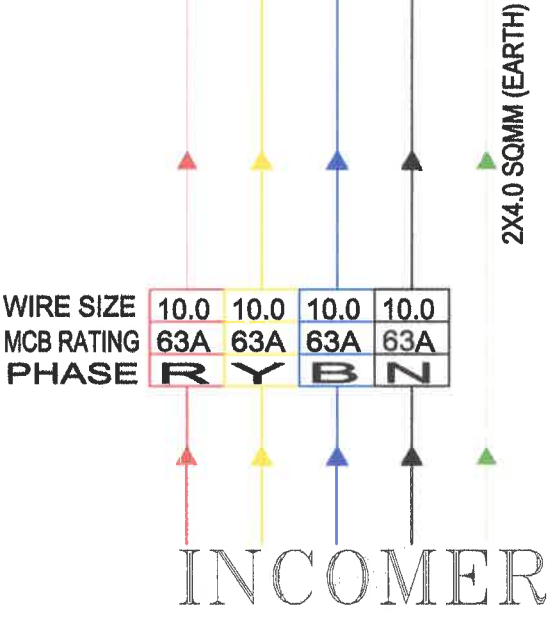

WIRE SIZES IN SQ MM

DETAILS WIRE SIZE(COPPER)	P & N	EARTH
LIGHTS/FANS	1.5 Sq. MM	1.5 Sq. MM
SOCKET 6 AMP	1.5 Sq. MM	1.5 Sq. MM
SOCKET 16 AMP.(INDIVIDUAL)	2.5 Sq. MM	1.5 Sq. MM
SOCKET 16 AMP.(GRP OF 2) 1st	4.0 Sq. MM	2.5 Sq. MM
SOCKET 16 AMP.(GRP OF 2) 2nd	2.5 Sq. MM	1.5 Sq. MM
GEYSER POINT	4.0 Sq. MM	2.5 Sq. MM
A.C. SOCKET POINT	4.0 Sq. MM	2.5 Sq. MM
LIGHT POINT CIRCUIT	2.5 Sq. MM	1.5 Sq. MM
EMERGENCY LIGHT POINT CIRCUIT	2.5 Sq. MM	1.5 Sq. MM

AJAY DADHIC
BTECH ELECT.

PROJECT :-
'RASIK RESIDENCY'
AT A-6 &A-11, NANDAN VIHAR,
JAGATPURA, JAIPUR.

ARCHITECTS

MISHRA GARG & ASSOCIATES
ARCHITECTS,PLANERS & INTERIOR DESIGNER
C-35,LAJPAT MARG,C-SCHEME,JAIPUR.
TEL : (0141) 2373274 , 5104986
Email-id :- mishra.garg@gmail.com,
mishra.garg@yahoo.com

MEP CONSULTANT :-

SRAJAN ASSOCIATES
C-35A, NAKSHTRA PRIDE, LAJPAT MARG,
C-SCHEME, JAIPUR
EMAIL:- snajaipur@hotmail.com

DB DETAIL

(TYPICAL FLAT- 01 DB DETAIL)

SCALE:- N.T.S.

DATE:- 24-02-2023


Dwan BY:- RAHMAN

DRG. NO.

SA/MAS/0000

Checked By:- AK

8WAY TPN DOUBLE DOOR

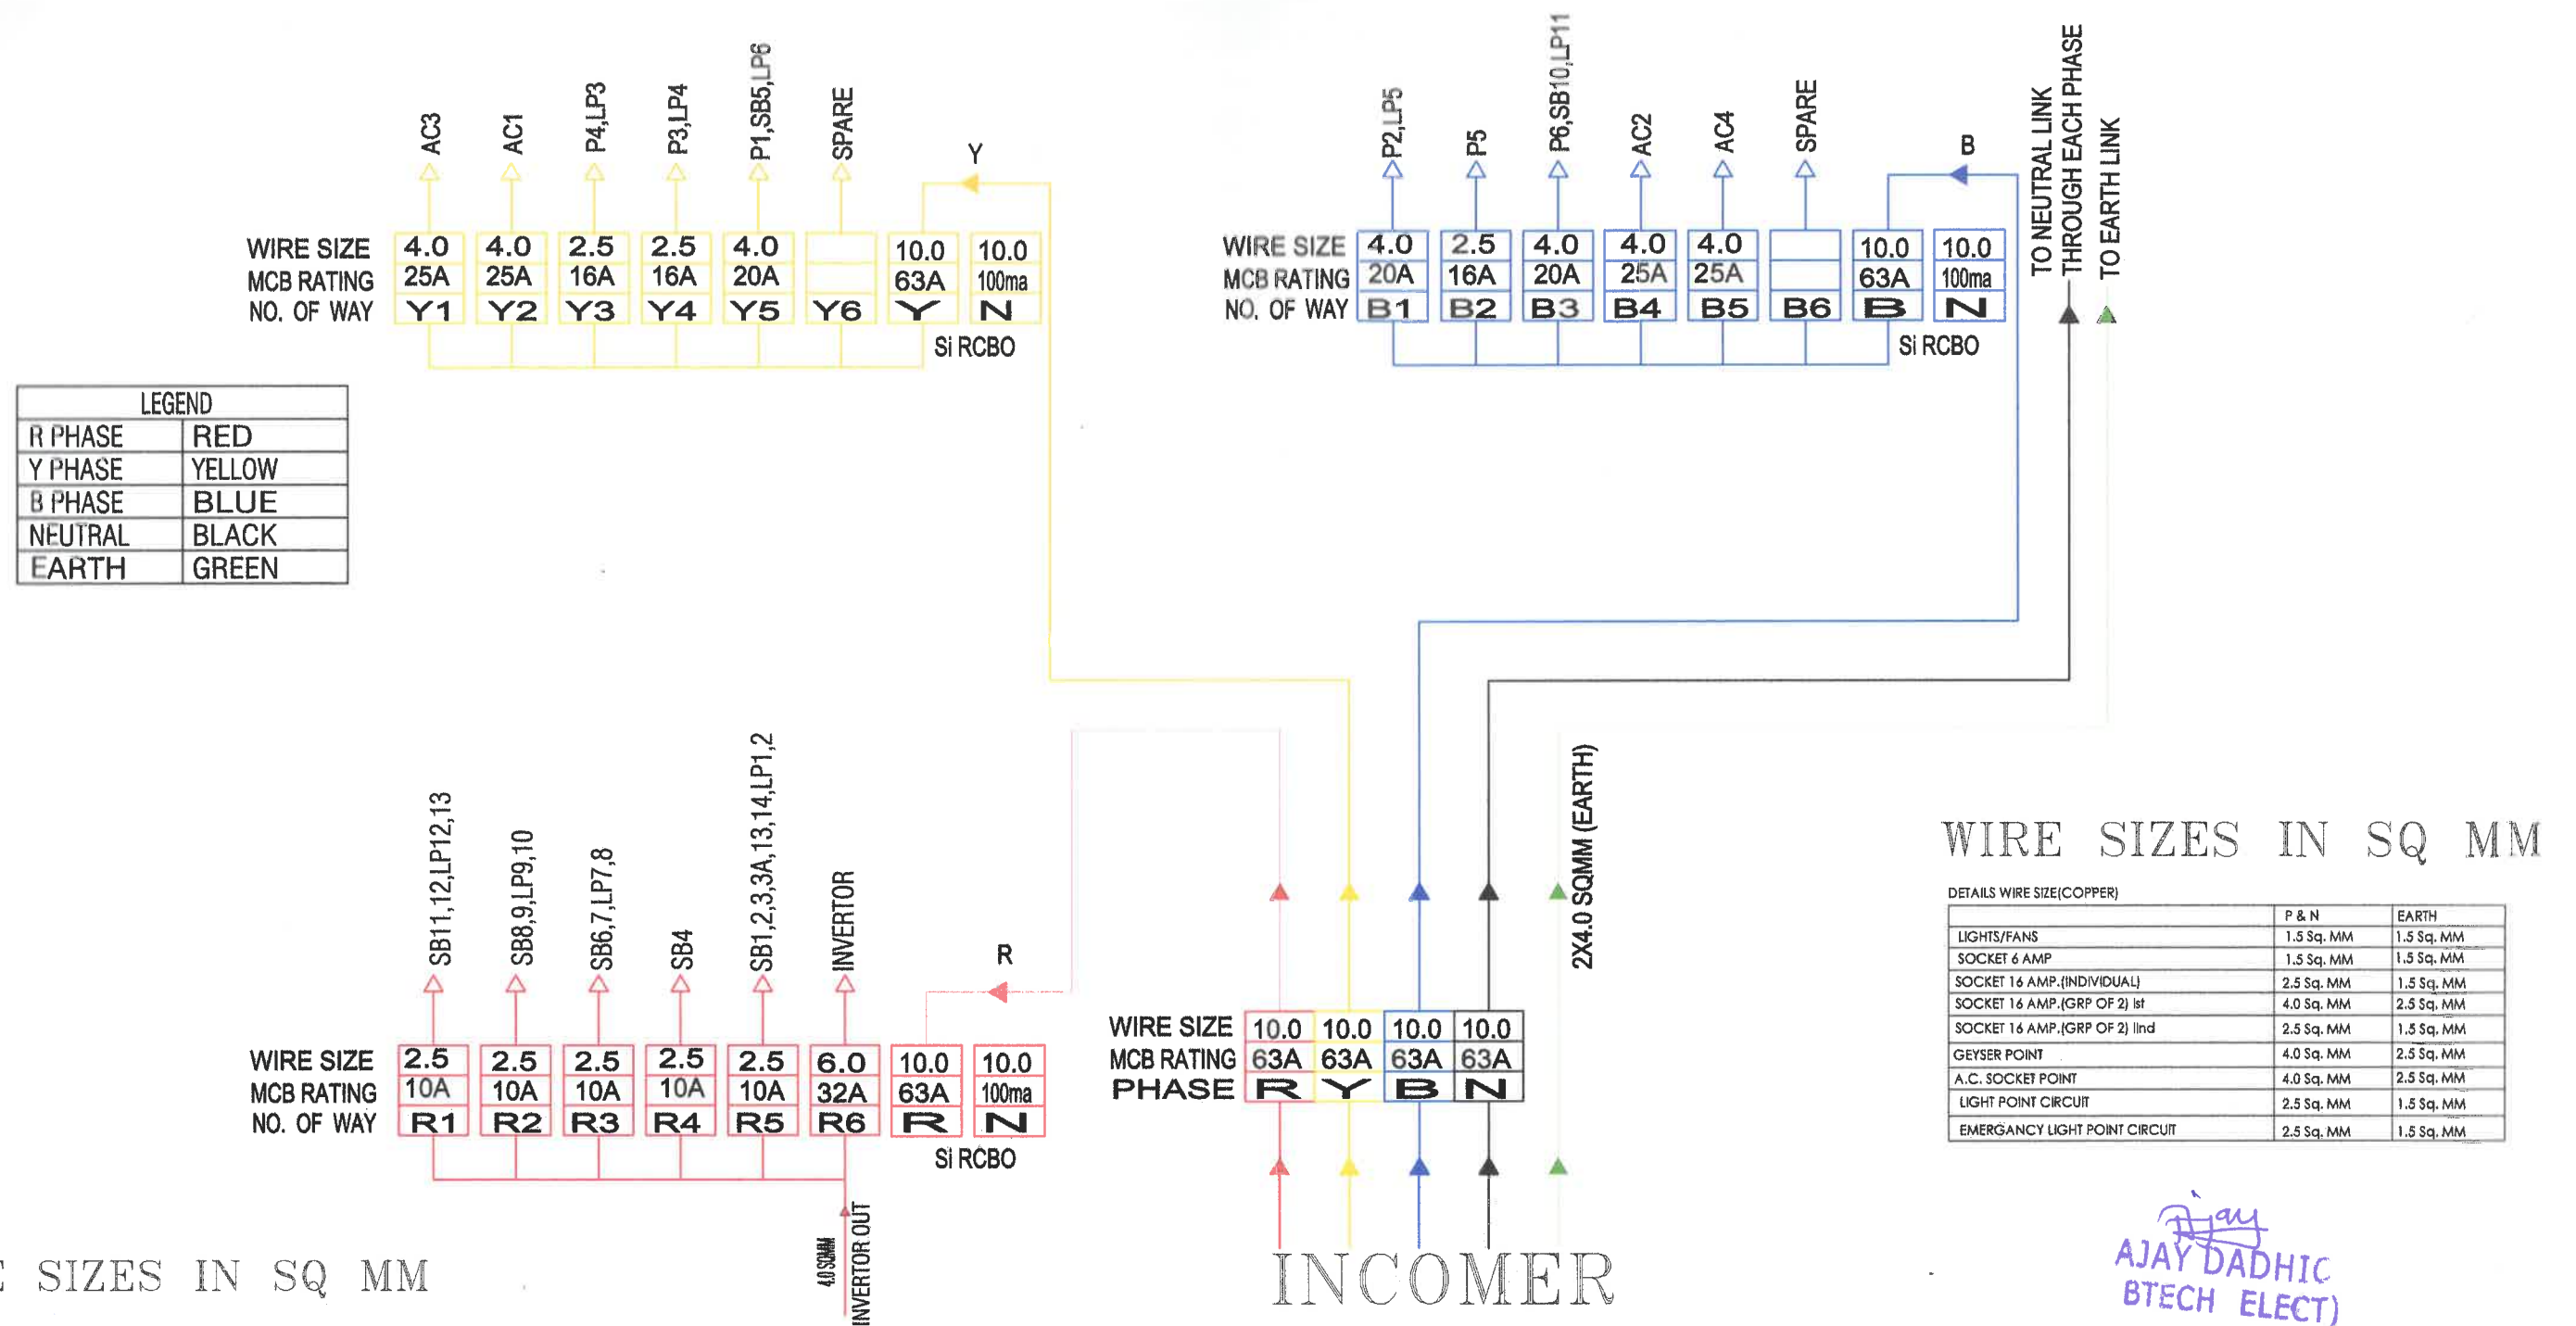

AY DADHIC
BTECH ELECT)

PROJECT :-

'RASIK RESIDENCY'
AT A-6 &A-11, NANDAN VIHAR,
JAGATPURA, JAIPUR.

ARCHITECTS

MISHRA GARG & ASSOCIATES
ARCHITECTS,PLANERS & INTERIOR DESIGNER
C-35,LAJPAT MARG,C-SCHEME,JAIPUR.
TEL : (0141) 2373274 , 5104986
Email-id :- mishra.garg@gmail.com,
mishra.garg@yahoo.com

MEP CONSULTANT :-

SRAJAN ASSOCIATES
C-35A, NAKSHTRA PRIDE, LAJPAT MARG,
C-SCHEME, JAIPUR
EMAIL:- snajaipur@hotmail.com

DB DETAIL
(TYPICAL FLAT- 02 DB DETAIL)

SCALE:- N.T.S.

DATE:- 24-02-2023


Dwan BY:- RAHMAN

DRG. NO.

SA/MAS/0000

Checked By:- AK

8WAY TPN DOUBLE DOOR

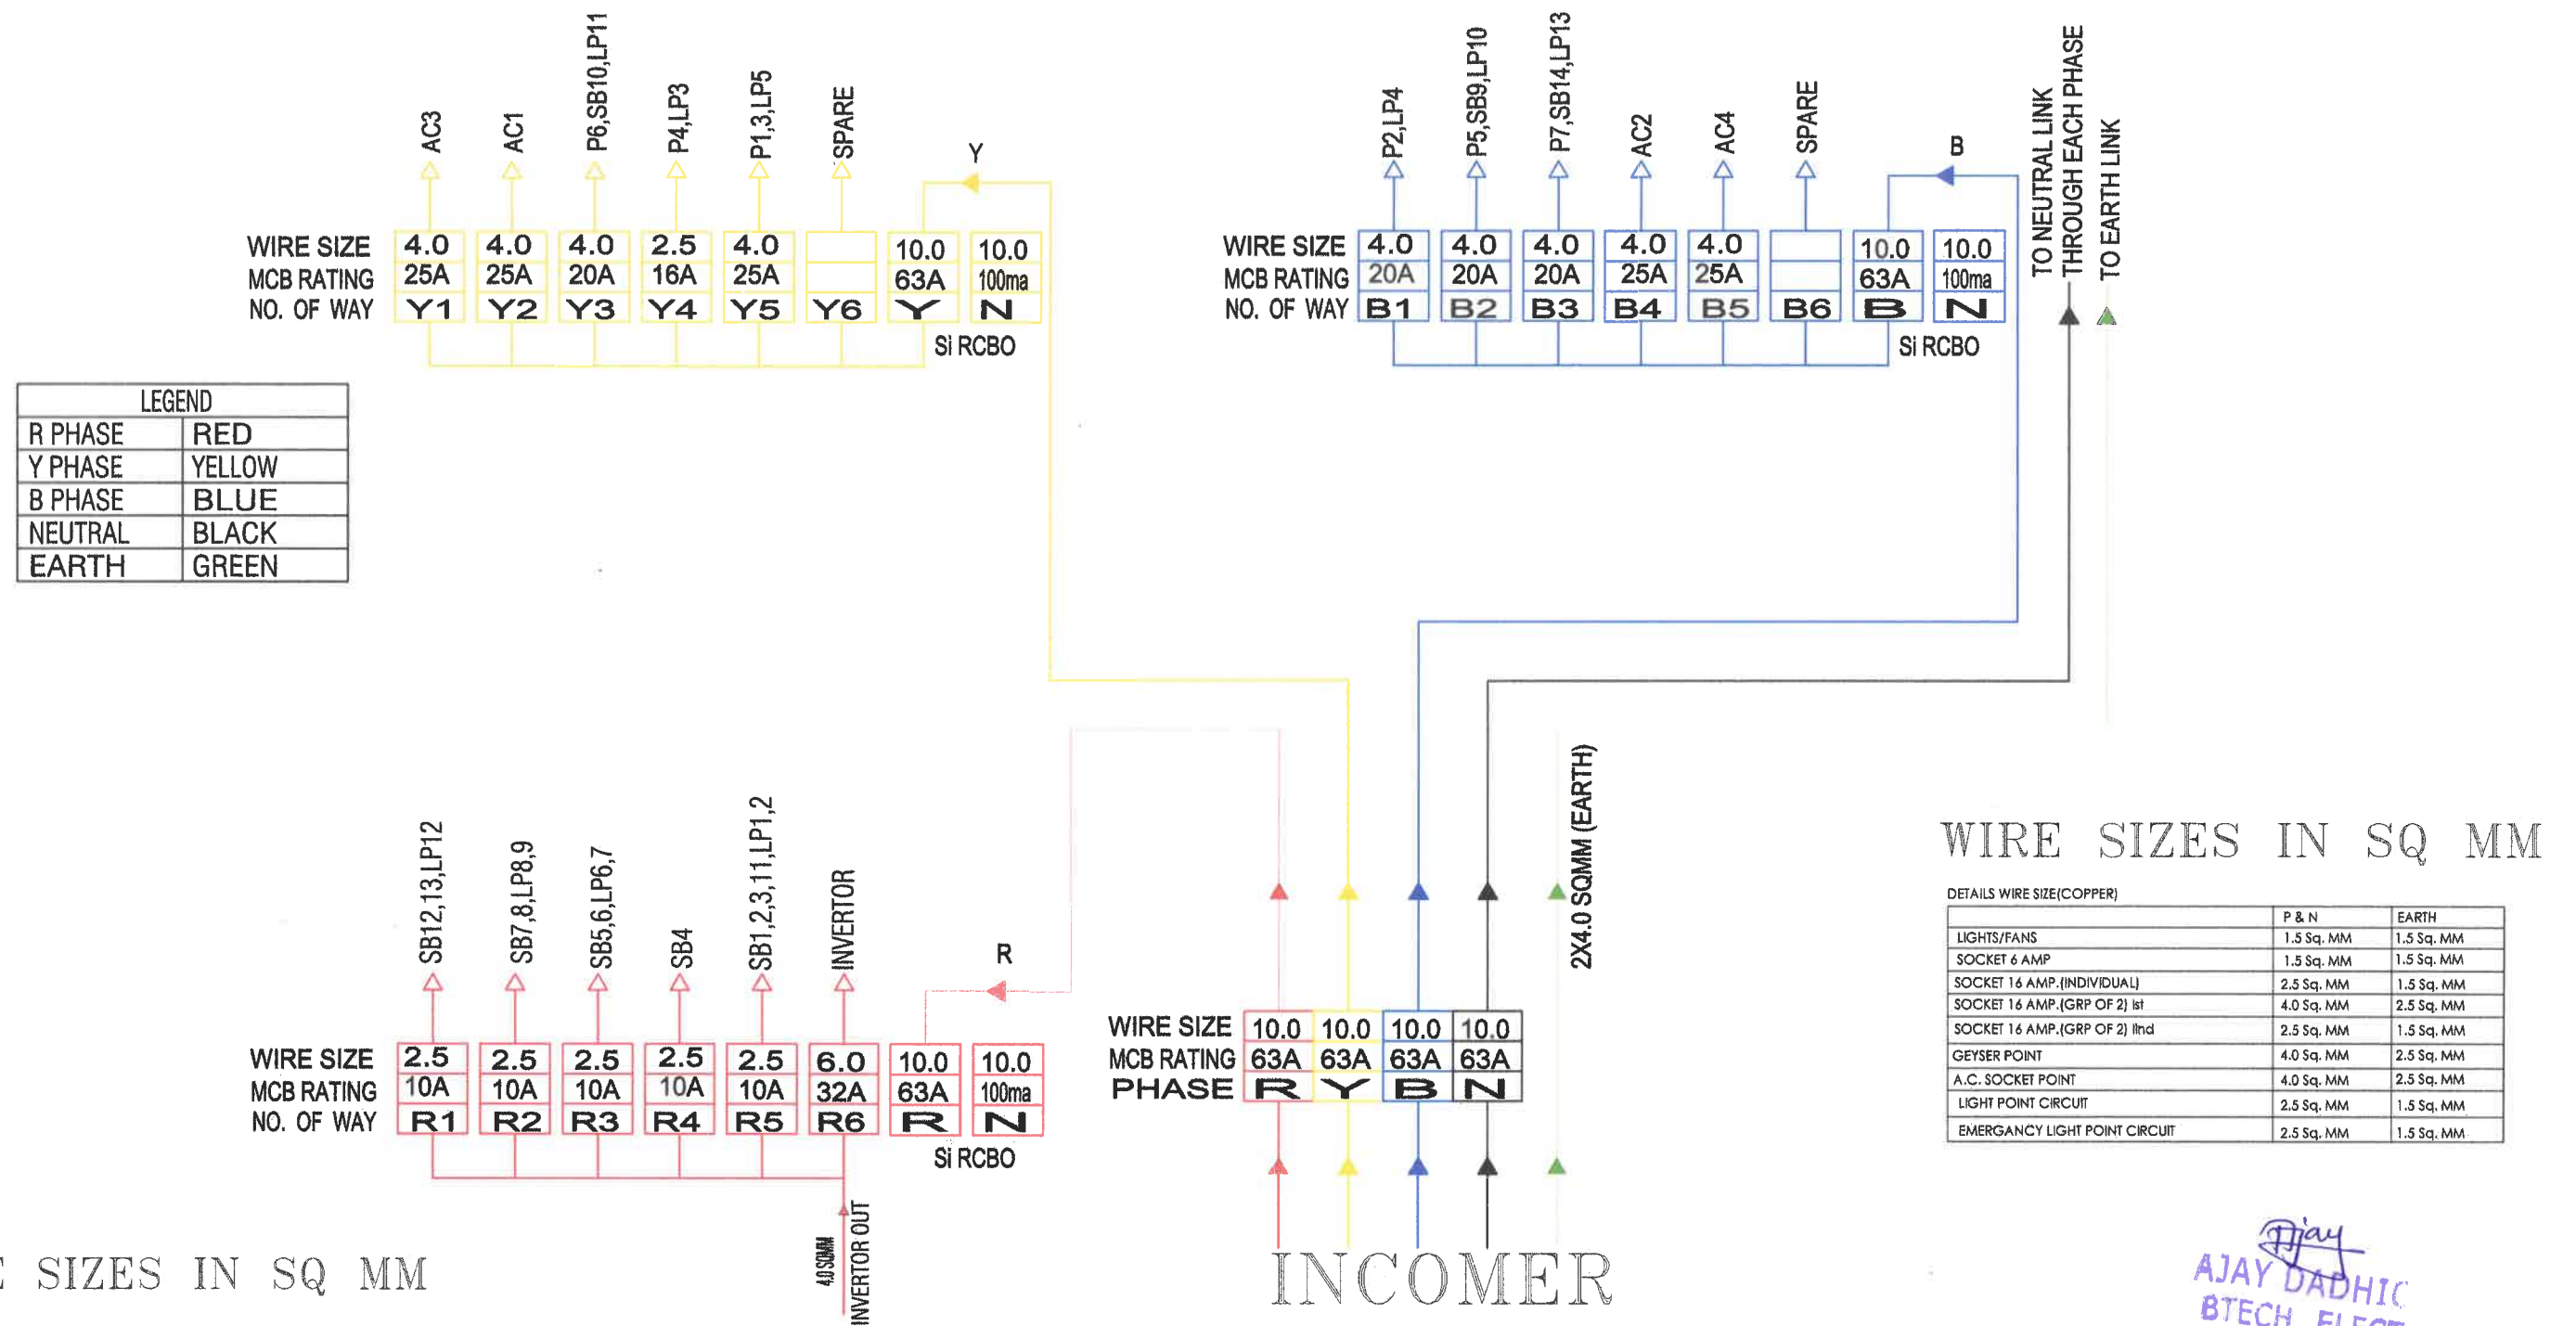

DETAILS WIRE SIZE(COPPER)		
	P & N	EARTH
LIGHTS/FANS	1.5 Sq. MM	1.5 Sq. MM
SOCKET 6 AMP	1.5 Sq. MM	1.5 Sq. MM
SOCKET 16 AMP.(INDIVIDUAL)	2.5 Sq. MM	1.5 Sq. MM
SOCKET 16 AMP.(GRP OF 2) 1st	4.0 Sq. MM	2.5 Sq. MM
SOCKET 16 AMP.(GRP OF 2) 1IInd	2.5 Sq. MM	1.5 Sq. MM
GEYSER POINT	4.0 Sq. MM	2.5 Sq. MM
A.C. SOCKET POINT	4.0 Sq. MM	2.5 Sq. MM
LIGHT POINT CIRCUIT	2.5 Sq. MM	1.5 Sq. MM
EMERGENCY LIGHT POINT CIRCUIT	2.5 Sq. MM	1.5 Sq. MM

Ajay
AJAY DADHIC
BTECH ELECT)

PROJECT :-

ARCHITECTS

MEP CONSULTANT :-

DB DETAIL
(TYPICAL FLAT- 03 DB DETAIL)

'RASIK RESIDENCY'
AT A-6 & A-11, NANDAN VIHAR,
JAGATPURA, JAIPUR.



MISHRA GARG & ASSOCIATES
ARCHITECTS, PLANERS & INTERIOR DESIGNER
C-35, LAJPAT MARG, C-SCHEME, JAIPUR.
TEL. : (0141) 2373274 , 5104986
Email-id :- mishra.garg@gmail.com,
mishra.garg@yahoo.com

SRAJAN ASSOCIATES
C-35A, NAKSHTRA PRIDE, LAJPAT MARG,
C-SCHEME, JAIPUR
EMAIL:- snajaipur@hotmail.com

SCALE:— N.T.S.

DATE:- 24-02-2023

Dwan BY:-

RAHMAN





DRG. NO.

SA/MAS/0000

Checked By:— AK

8WAY TPN DOUBLE DOOR

LEGEND	
R PHASE	RED
Y PHASE	YELLOW
B PHASE	BLUE
NEUTRAL	BLACK
EARTH	GREEN

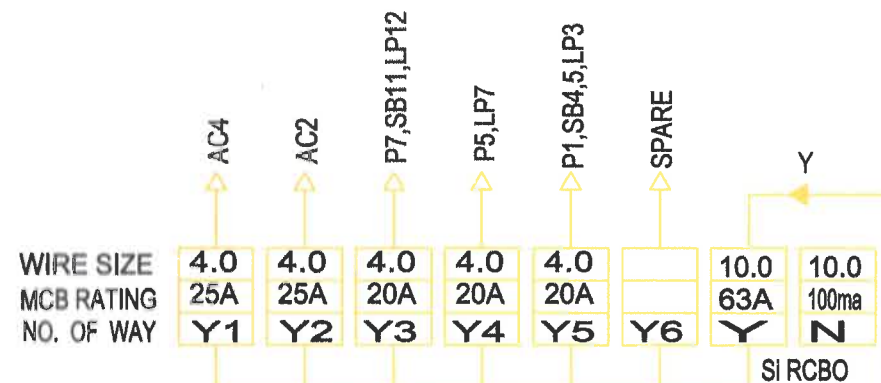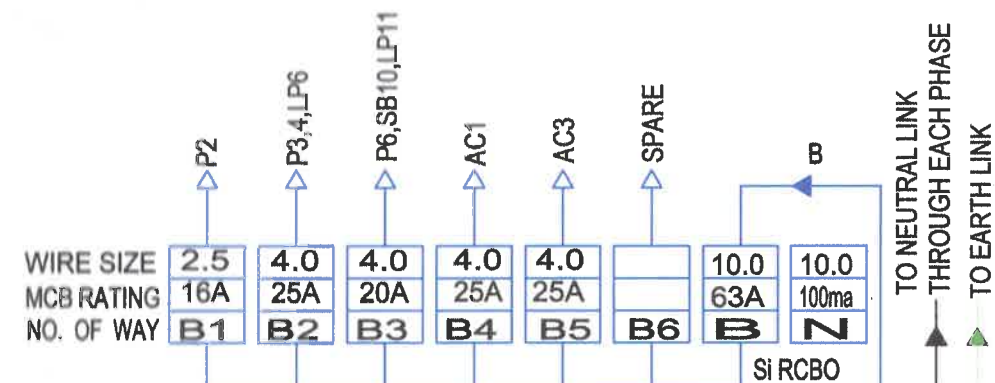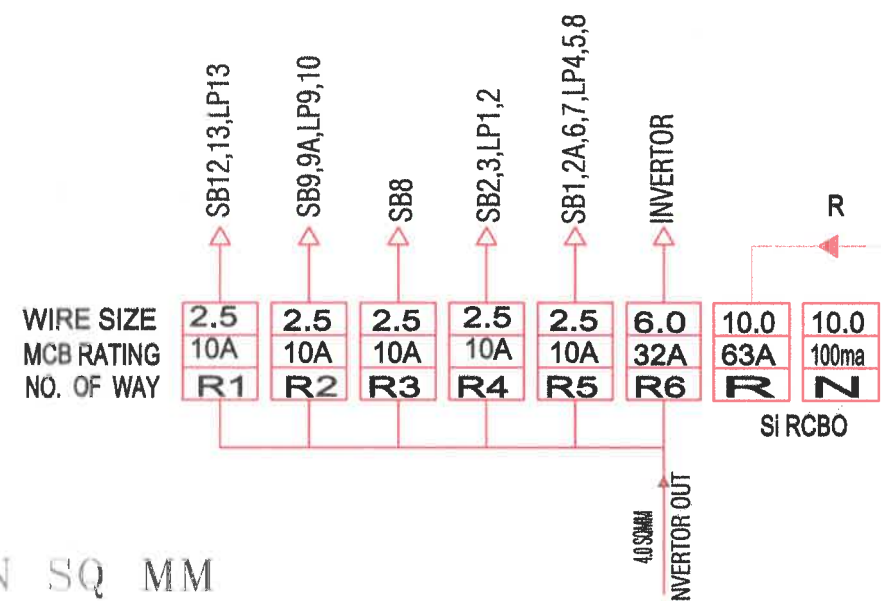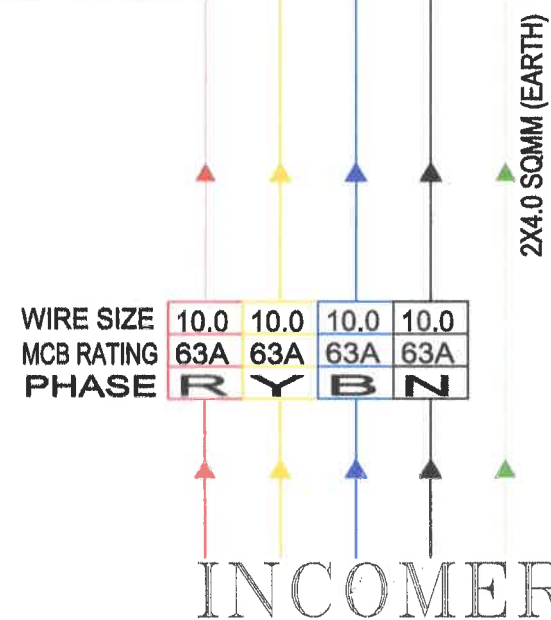

WIRE SIZES IN SQ MM

DETAILS WIRE SIZE (COPPER)	P & N	EARTH
LIGHTS/FANS	1.5 Sq. MM	1.5 Sq. MM
SOCKET 6 AMP	1.5 Sq. MM	1.5 Sq. MM
SOCKET 16 AMP, (INDIVIDUAL)	2.5 Sq. MM	1.5 Sq. MM
SOCKET 16 AMP, (GRP OF 2) 1st	4.0 Sq. MM	2.5 Sq. MM
SOCKET 16 AMP, (GRP OF 2) 11nd	2.5 Sq. MM	1.5 Sq. MM
GEYSER POINT	4.0 Sq. MM	2.5 Sq. MM
A.C. SOCKET POINT	4.0 Sq. MM	2.5 Sq. MM
LIGHT POINT CIRCUIT	2.5 Sq. MM	1.5 Sq. MM
EMERGENCY LIGHT POINT CIRCUIT	2.5 Sq. MM	1.5 Sq. MM

Ajay
AJAY DADHI
BTECH ELECT

WIRE SIZES IN SQ MM

INCOMER

PROJECT :-

ARCHITECTS

MEP CONSULTANT :-

DB DETAIL
(TYPICAL FLAT- 04 DB DETAIL)

'RASIK RESIDENCY'
AT A-6 & A-11, NANDAN VIHAR,
JAGATPURA, JAIPUR.


MISHRA GARG & ASSOCIATES
ARCHITECTS, PLANNERS & INTERIOR DESIGNER
C-35, LAJPAT MARG, C-SCHEME, JAIPUR.
TEL : (0141) 2373274, 5104986
Email-id :- mishra.garg@gmail.com,
mishra.garg@yahoo.com

SRAJAN ASSOCIATES
C-35A, NAKSHTRA PRIDE, LAJPAT MARG,
C-SCHEME, JAIPUR
EMAIL:- snajaipur@hotmail.com

SCALE:- N.T.S.

DATE:- 24-02-2023


Drawn BY:- RAHMAN

DRG. NO.

SA/MAS/0000

Checked By:- AK

8WAY TPN DOUBLE DOOR

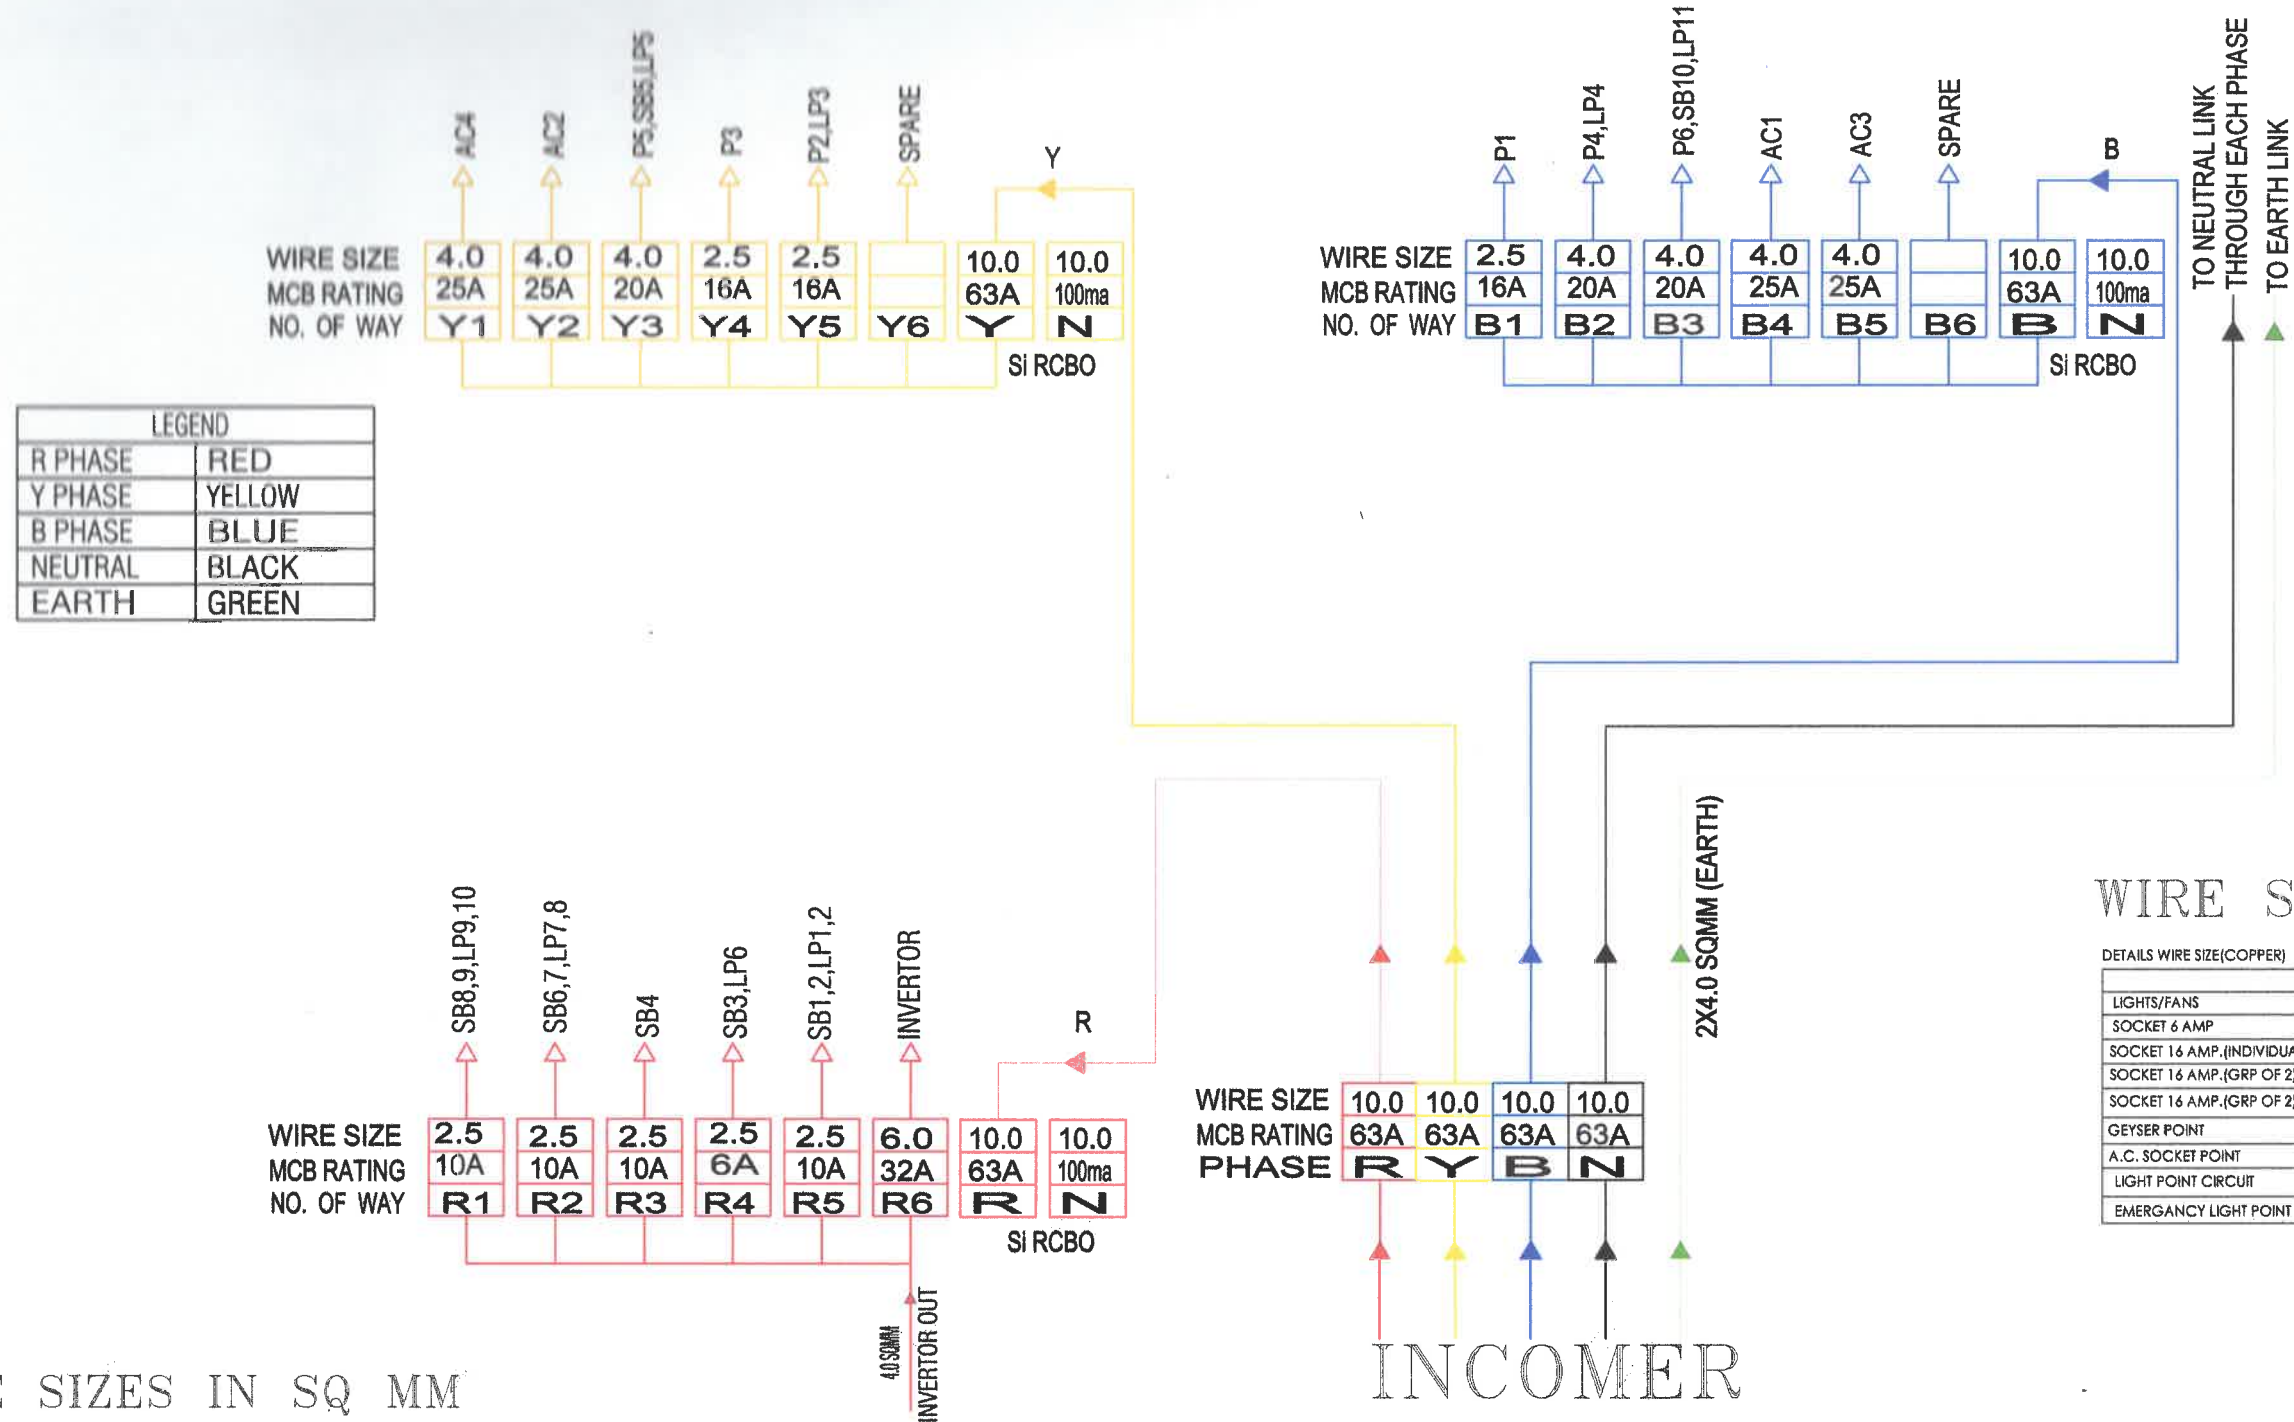

WIRE SIZES IN SQ MM

DETAILS WIRE SIZE(COPPER)		
	P & N	EARTH
LIGHTS/FANS	1.5 Sq. MM	1.5 Sq. MM
SOCKET 6 AMP	1.5 Sq. MM	1.5 Sq. MM
SOCKET 16 AMP.(INDIVIDUAL)	2.5 Sq. MM	1.5 Sq. MM
SOCKET 16 AMP.{GRP OF 2} 1st	4.0 Sq. MM	2.5 Sq. MM
SOCKET 16 AMP.{GRP OF 2} 11nd	2.5 Sq. MM	1.5 Sq. MM
GEYSER POINT	4.0 Sq. MM	2.5 Sq. MM
A.C. SOCKET POINT	4.0 Sq. MM	2.5 Sq. MM
LIGHT POINT CIRCUIT	2.5 Sq. MM	1.5 Sq. MM
EMERGENCY LIGHT POINT CIRCUIT	2.5 Sq. MM	1.5 Sq. MM


 AJAY DADHIL
 (BTECH ELECT)

PROJECT :-

ARCHITECTS

'RASIK RESIDENCY'
AT A-6 & A-11, NANDAN VIHAR,
JAGATPURA, JAIPUR.

MISHRA GARG & ASSOCIATES
ARCHITECTS, PLANNERS & INTERIOR DESIGNER
C-35, LAJPAT MARG, C-SCHEME, JAIPUR.
TEL. : (0141) 2373274 , 5104986
Email-id :- mishra.garg@gmail.com,
mishra.garg@yahoo.com

MEP CONSULTANT :-

SRAJAN ASSOCIATES
C-35A, NAKSHTRA PRIDE, LAJPAT MARG,
C-SCHEME, JAIPUR
EMAIL:- snajaipur@hotmail.com

DB DETAIL
(TYPICAL FLAT- 05 DB DETAIL)

SCALE:- N.T.S.

DATE:-
24-02-2023


Dwan BY:-
RAHMAN

DRG. NO.

SA/MAS/0000

Checked By:-- AK

30 NO 3 PHASE
METER + 01 NO
3P CT METER
PANEL

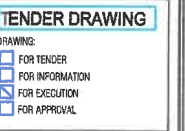

Ajay
AJAY BADHICHI
(BTECH ELECT)

DRAWING:

- ☐ FOR TENDER
- ☐ FOR INFORMATION
- ☒ FOR EXECUTION
- ☐ FOR APPROVAL

