



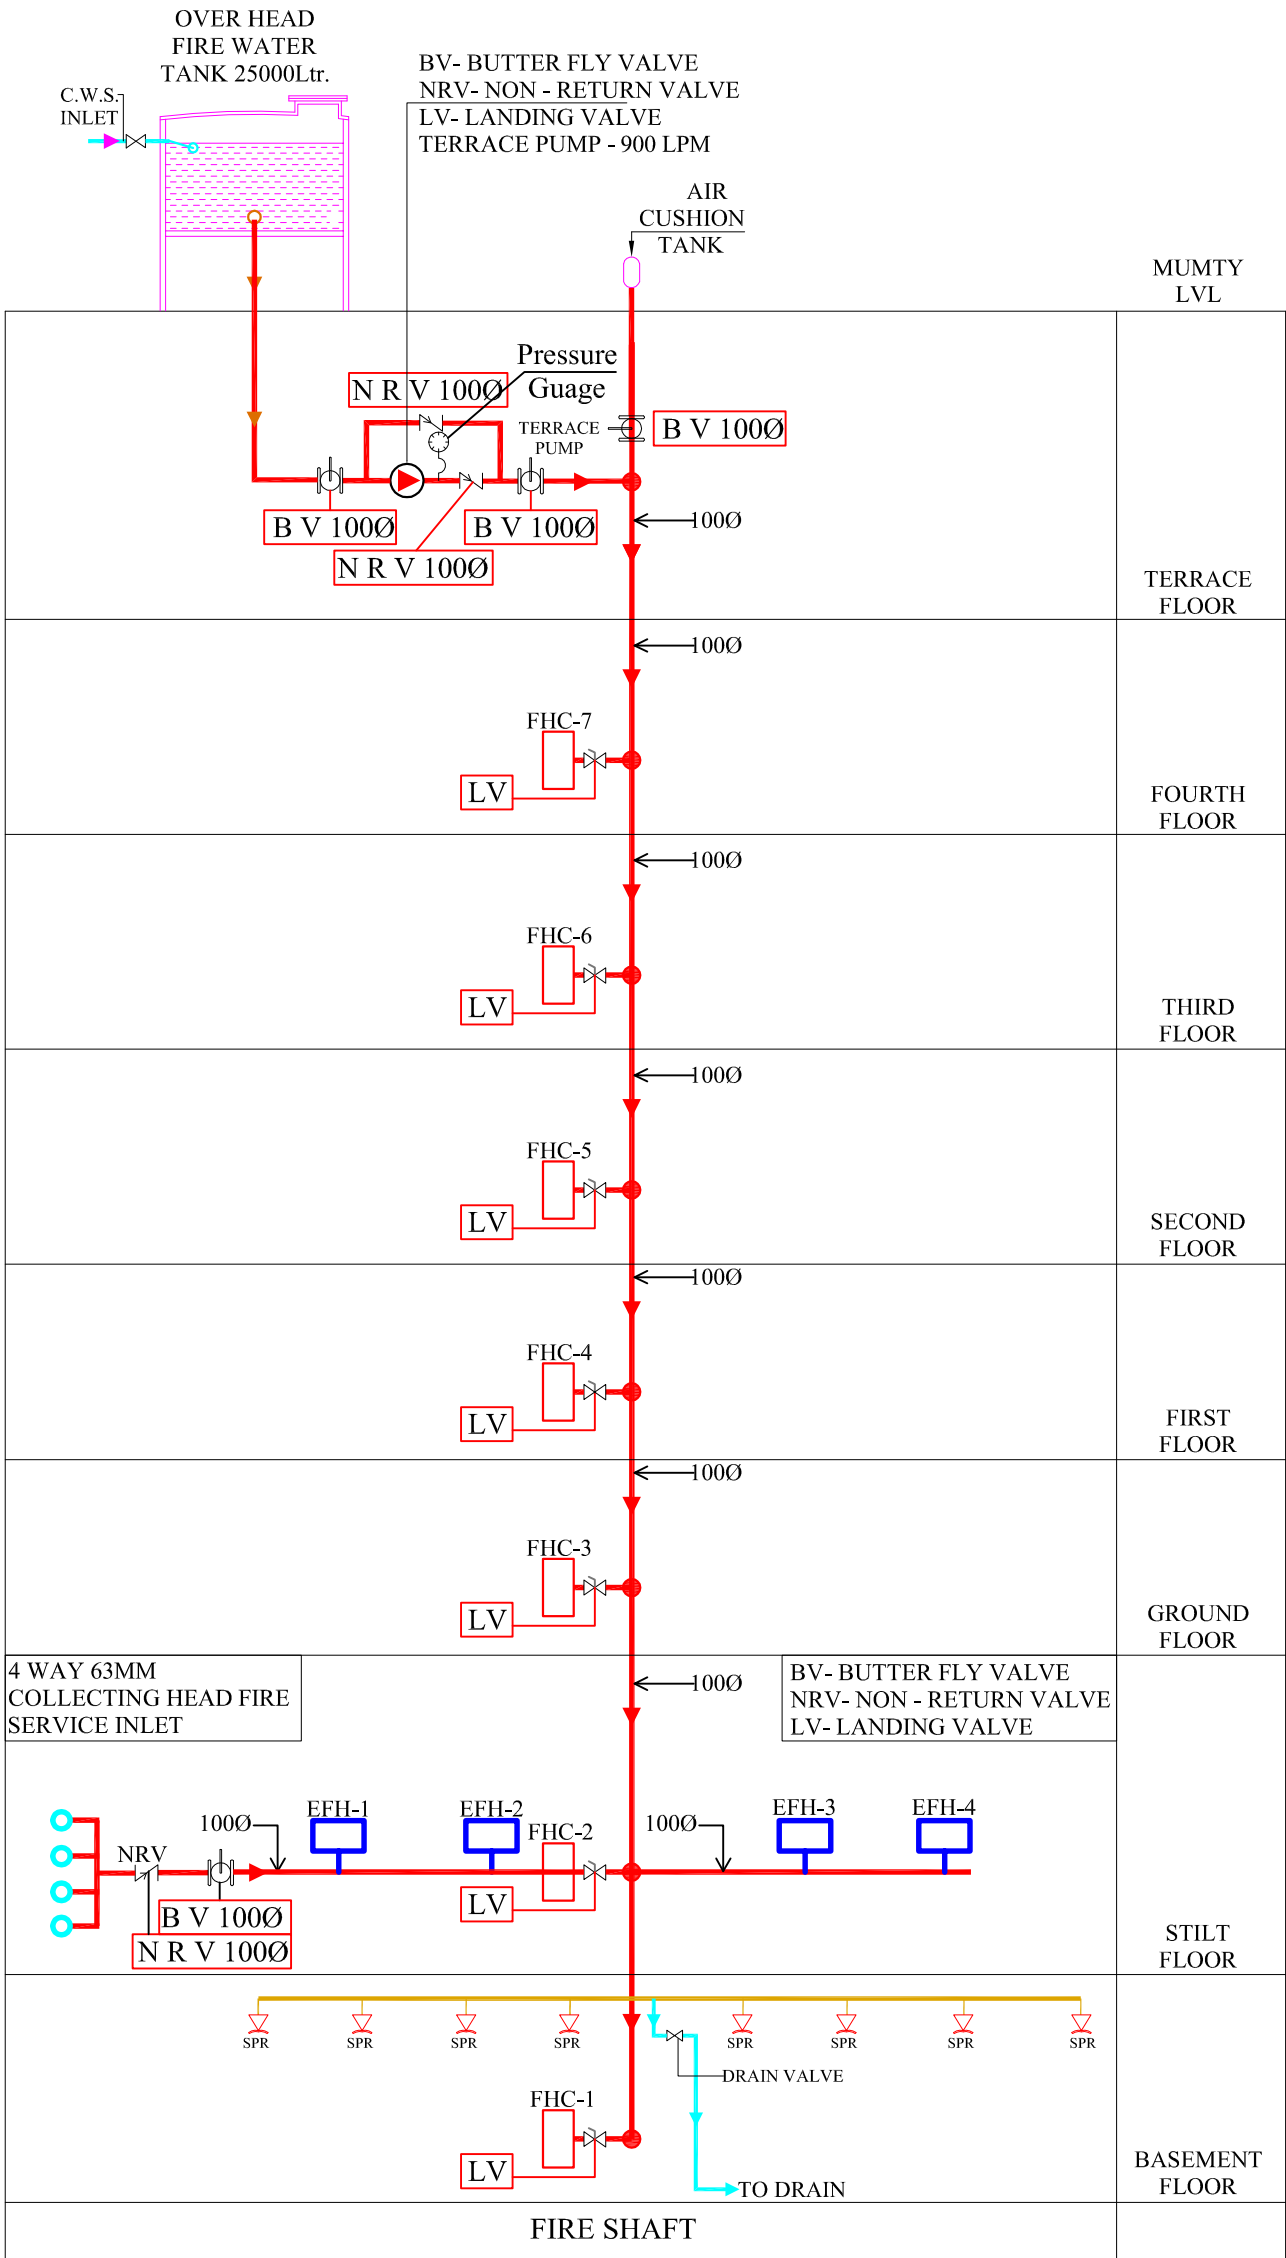

Vipul
VIPUL AGARWAL
M.E.P. CONSULTANT
B.E. ELECTRICAL

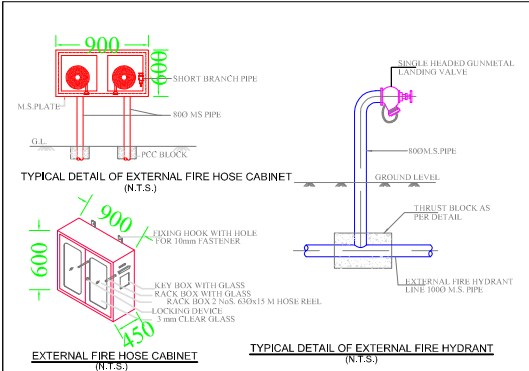

LEGEND			
S.no.	Symbol	Description	Size in mm
1.		Butter fly Valve	100Ø
2.		Non Return Valve	100Ø
3.		Landing Valve Single headed	63Ø
4.		Pressure Guage	
5.		FHC	
6.		External Fire Hose Cabinet	

SERVICE CONSULTANT

ASHI ASSOCIATES
F 9 / 440 , Keshav Marg Chitrakut Scheme,Jaipur
PH:91-0-93146-10438 ,0141-2440946, Mail:vipul8599@yahoo.com

ARCHITECT :-

SPACE EDGE ARCHITECTS
B-6, Moti Marg, Bapu Nagar, Jaipur.
Ph.: 0141-4062903 , +91-9314510603
E-Mail: spaceedgejpr@gmail.com


CLIENT/BUILDER:

PROJECT :-

PROPOSED BUILDING AT PLOT NO -A-18, A-19, A-20, A-21, & 86 - A, AT MONIKA VIHAR, VILLAGE- MANYAWAS, TEHSIL- SANGANER, JAIPUR

DRG. TITLE :-




FIRE SCHEMATIC LAYOUT

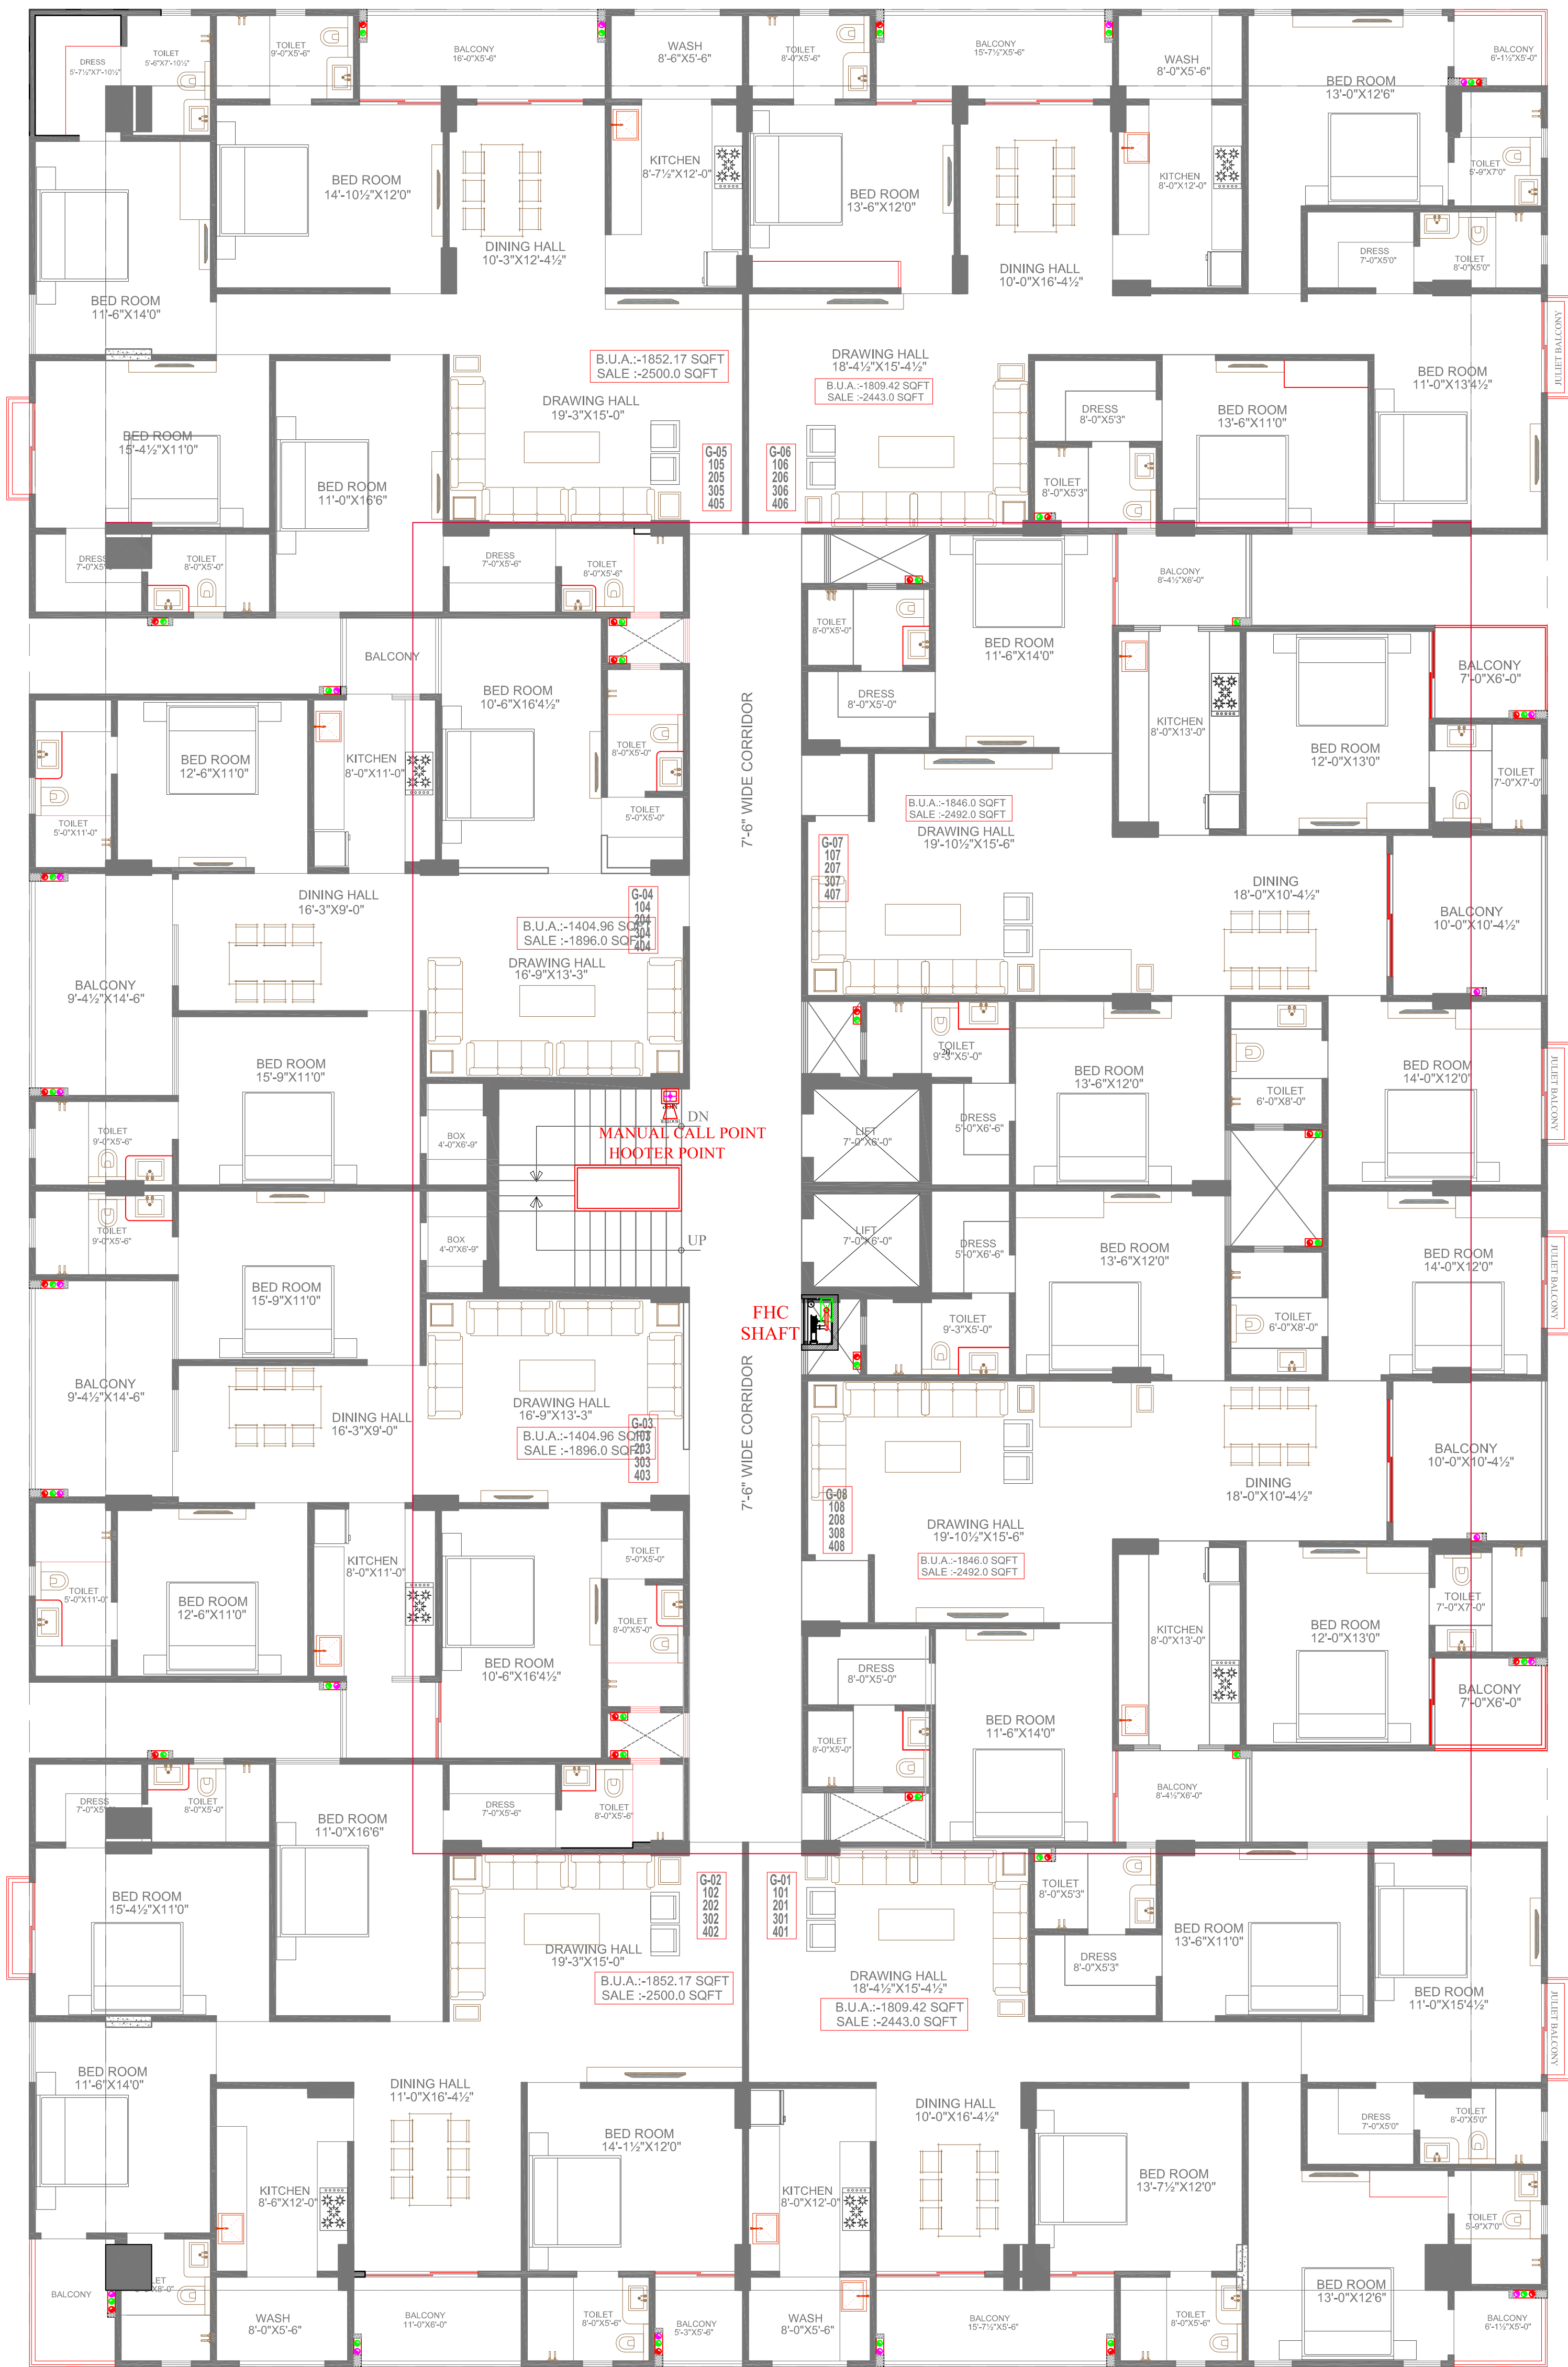

GROUND,1ST,2ND,3RD,& 4TH
FLOOR PLAN


Vipul
VIPUL AGARWAL
M.E.P. CONSULTANT
B.E. ELECTRICAL

ROAD

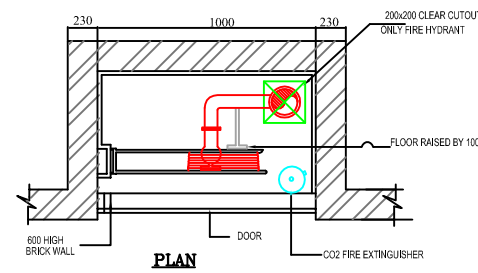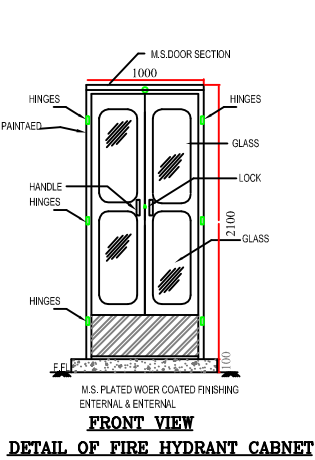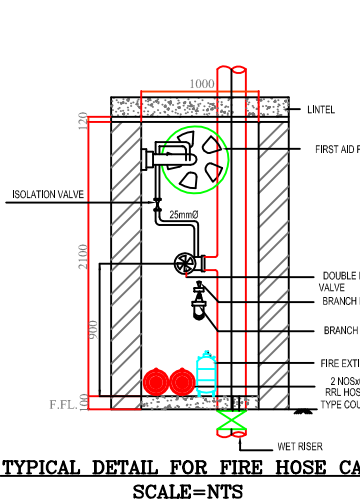

LEGENDS:				
Mounting Height	No.	ID	Symbol	Description
IN CEILING				FIRE 2X1.5 sq. mm Copper Wire For Fire Alarm
+42"	01	MCP		MANUAL CALL POINT
+90"	01	HO		HOOTER POINT

PROJECT:- PROPOSED BUILDING AT PLOT NO -A-18, A-19, A-20, A-21, & 86 - A, AT MONIKA VIHAR, VILLAGE- MANYAWAS, TEHSIL- SANGANER, JAIPUR	DRAWING:- TYPICAL FLOOR MCP,HOOTER & FHC PLAN	CLIENT/ BUILDER:	SERVICES CONSULTANT: ASHI ASSOCIATES F 9 / 440 , Keshav Marg Chitrakut Scheme,Jaipur PH:91-0-93146-10438 0141-2440946 Mail:vipul8599@yahoo.com	ARCHITECT:- SPACE EDGE ARCHITECTS B-6, Moti Marg, Bapu Nagar, Jaipur. Ph.: 0141-4062903 , +91-9314510603 E-Mail: spaceedgepr@gmail.com
--	---	------------------	---	---

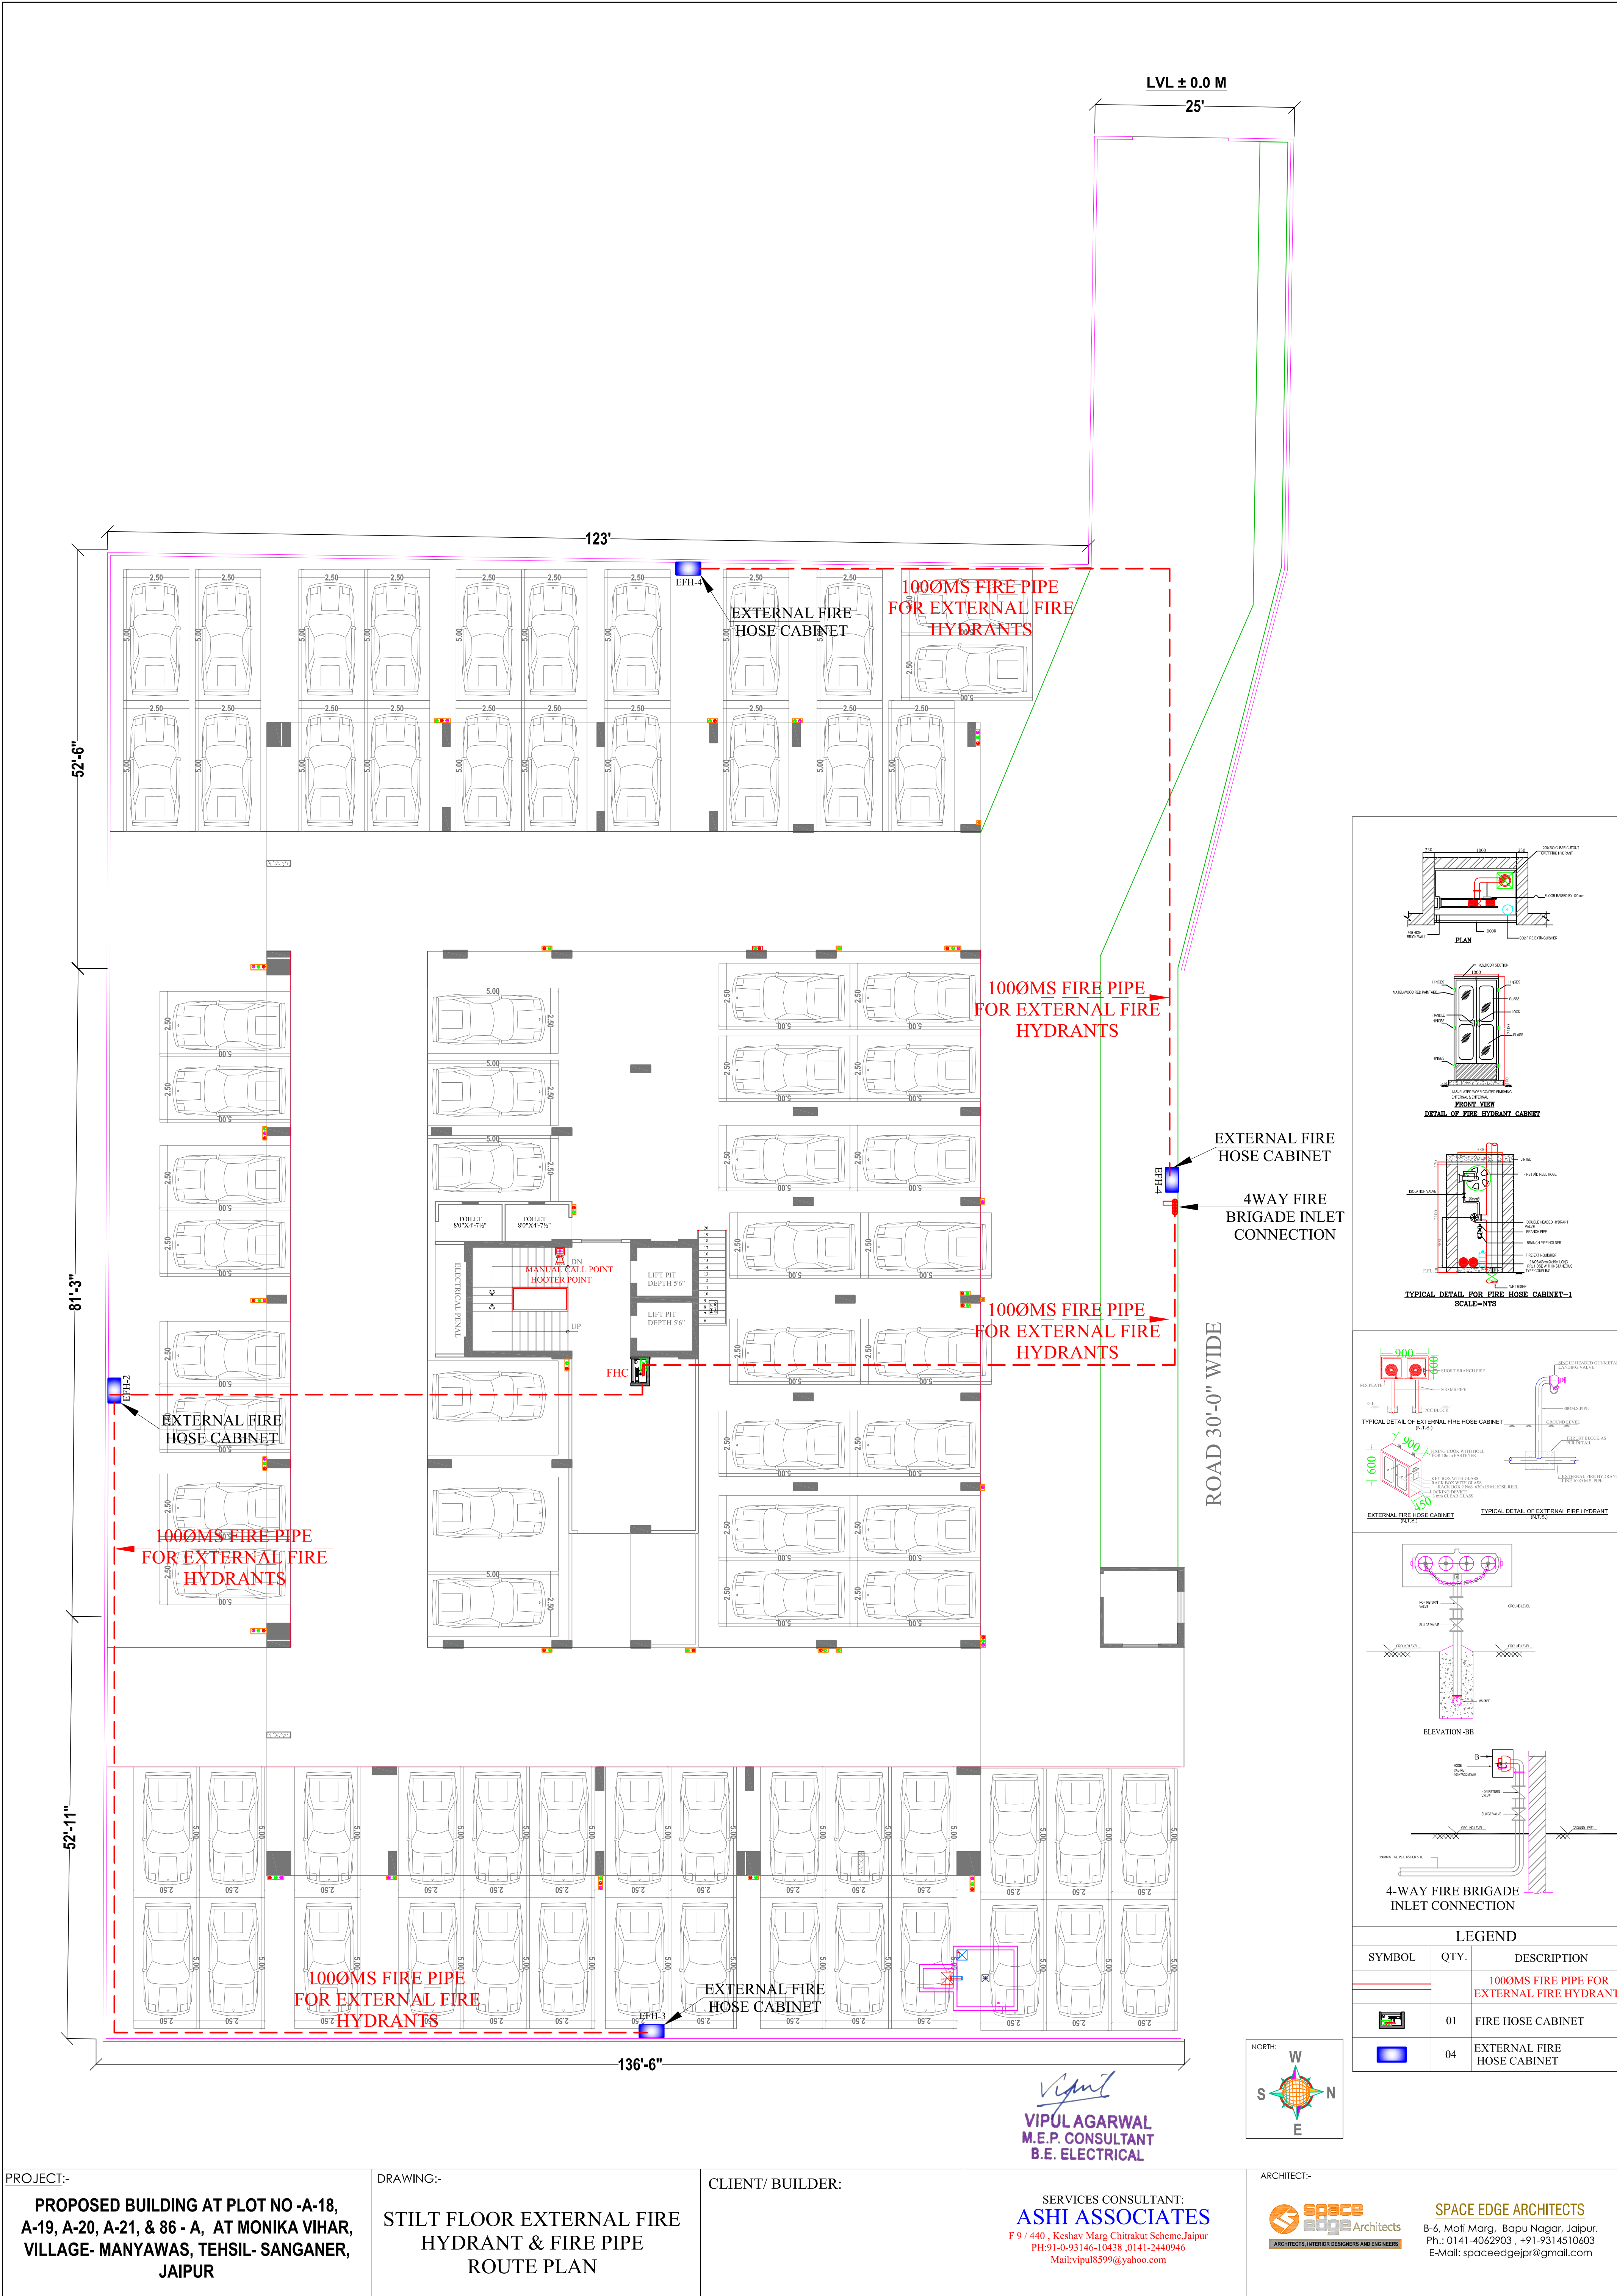

<p>PROJECT:-</p> <p>PROPOSED BUILDING AT PLOT NO -A-18, A-19, A-20, A-21, & 86 - A, AT MONIKA VIHAR, VILLAGE- MANYAWAS, TEHSIL- SANGANER, JAIPUR</p>	<p>DRAWING:-</p> <p>STILT FLOOR EXTERNAL FIRE HYDRANT & FIRE PIPE ROUTE PLAN</p>	<p>CLIENT/ BUILDER:-</p>	<p>SERVICES CONSULTANT:</p> <p>ASHI ASSOCIATES</p> <p>F 9 / 440 , Keshav Marg Chitrakut Scheme,Jaipur PH:91-0-93146-10438 , 0141-2440946 Mail:vipul8599@yahoo.com</p>	<p>ARCHITECT:-</p> <p>SPACE EDGE ARCHITECTS</p> <p>B-6, Moti Marg, Bapu Nagar, Jaipur. Ph.: 0141-4062903 , +91-9314510603 E-Mail: spaceedgejpr@gmail.com</p>
---	---	--------------------------	--	---