

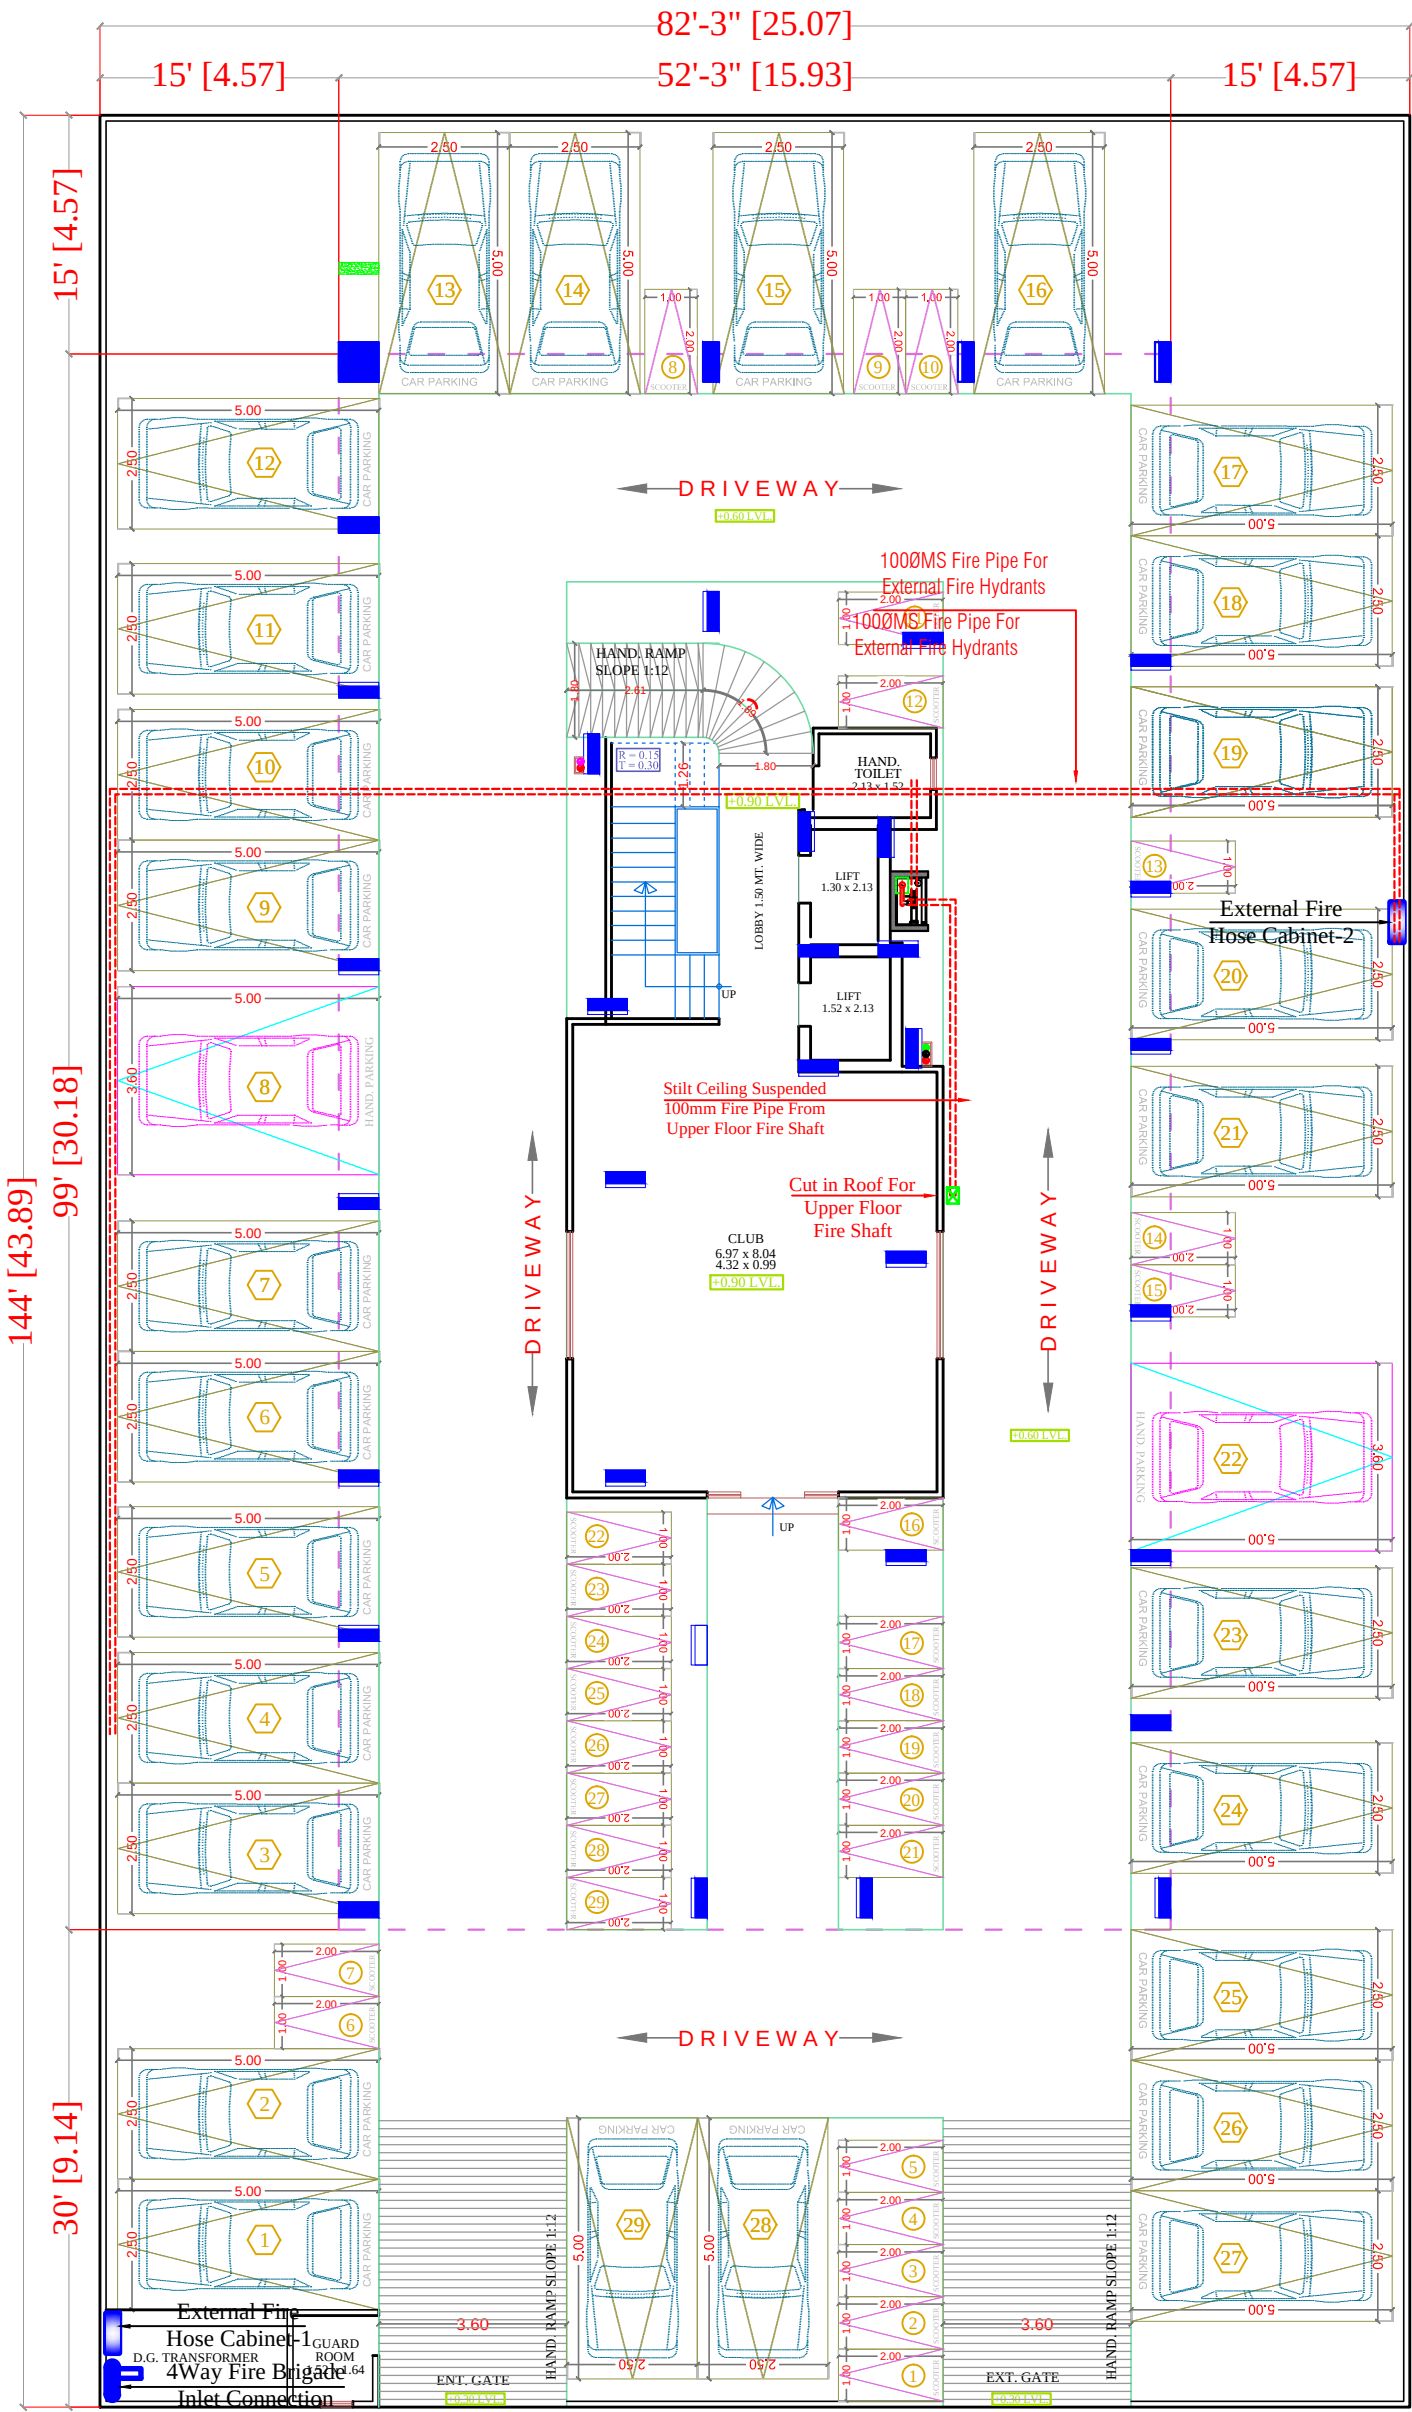


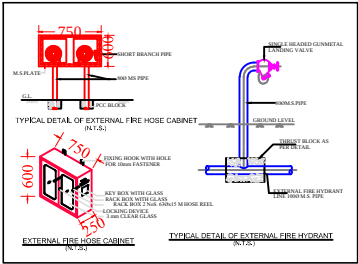

STILT FLOOR PLAN

----- R O A D 40'-0" WIDE -----

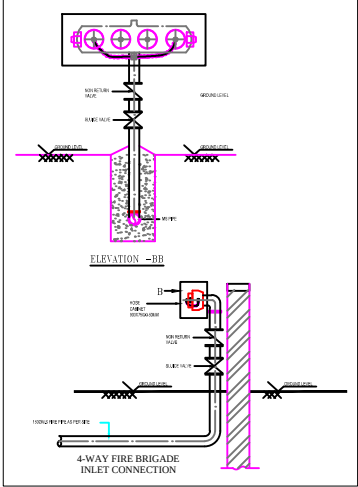

LEGEND		
SYMBOL	QTY.	DESCRIPTION
	02	EXTERNAL FIRE HOSE CABINET
	01	FIRE HOSE CABINET
		1000MS FIRE PIPE FOR EXTERNAL FIRE HYDRANTS

SEAL:-

RAMESH KUMAWAT
M.E.P. CONSULTANT
B.E. CIVIL

SPACE CONSULTANT

PLOT-A-173, JAGDAMBA NAGAR, HEERAPURA
POWER HOWER, JAIPUR (RAJ) 302024

ARCHITECT :-

FRANK SQUARE
ARCHITECTURE | PLANNER | DESIGNER
C-49 VIDYA APARTMENT PARAS MARG,
BAPU NAGAR JAIPUR, (RAJ.)
Email-afanksquare@gmail.com
Mobile-9461302542


PROJECT :-

PROPOSED BUILDING AT K. NO. 231/5 VILL-MOHANPURA ,
SANGANER JAIPUR

DRAWING:

STILT FLOOR
EXTERNAL FIRE HYDRANT
FOR RERA SUBMISSION PLAN

DATE	
SCALE:-	N.T.S.

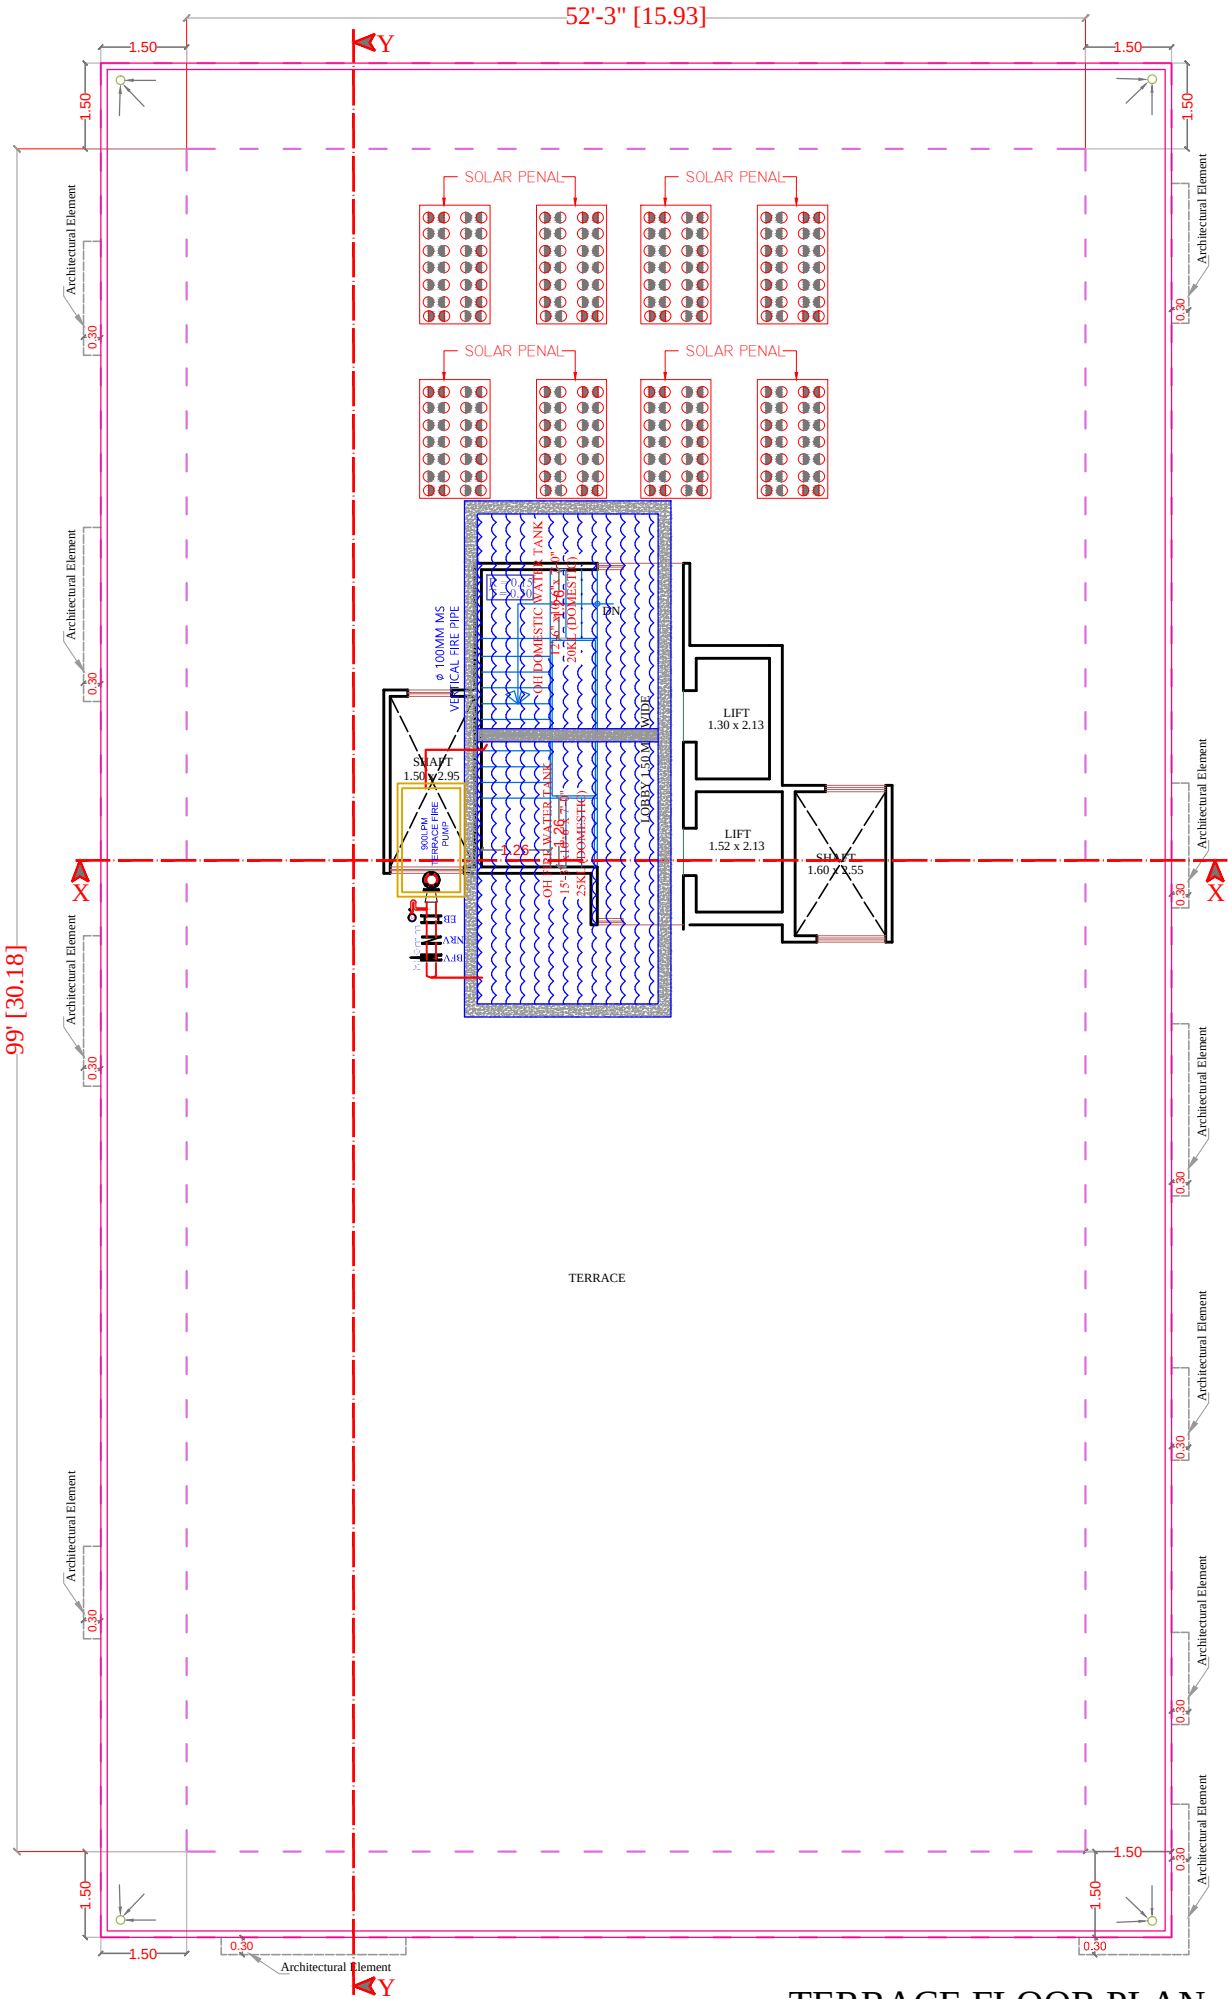

TERRACE FLOOR PLAN

LEGENDS:			
SR NO.	Symbol	Description	Qty.
1.		HYDRANT	00
2.		HOSE REEL	00
3.		HOSE BOX	01
4.		FOUR WAY	00
5.		FIRE PUMP	01
6.		WATER TANK	01

RAMESH KUMAWAT
M.E.P. CONSULTANT
B.E. CIVIL

PROJECT TITLE :- PROPOSED BUILDING AT K. NO. 231/5 VILL-MOHANPURA , SANGANER JAIPUR	DRAWING TITLE :- TARRACE FLOOR FIRE FIGHTING	SPACE CONSULTANT PLOT-A-173, JAGDAMBA NAGAR, HEERAPURA POWER HOWER, JAIPUR (RAJ) 302024	DRN. BY		DATE	NORTH
			APPD. BY		REVISION	
			SCALE			

