


ELECTRICAL LAYOUT PLAN OF HANUMAN NAGAR BLOCK H VILLAGE -SAWAI JAISINGHPURA (BASS BILWA), TEH. -SANGANER, JAIPUR


J.D.A.

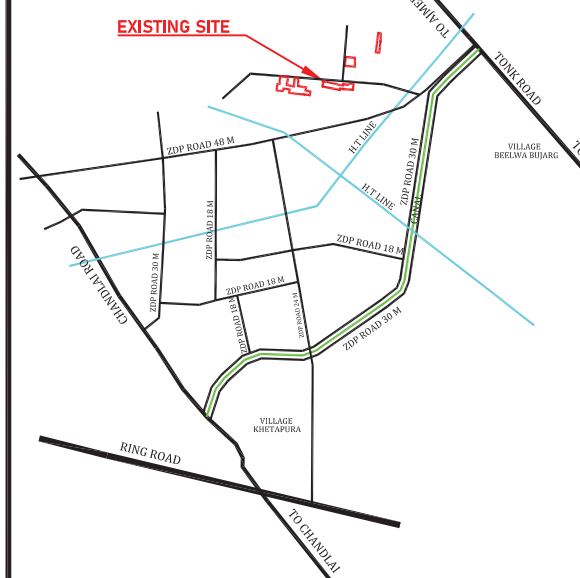

KEY PLAN



	TRANSFORMER
	EXTRA TRANSFORMER
	LT PANELS
	LT LINE
	HT LINE

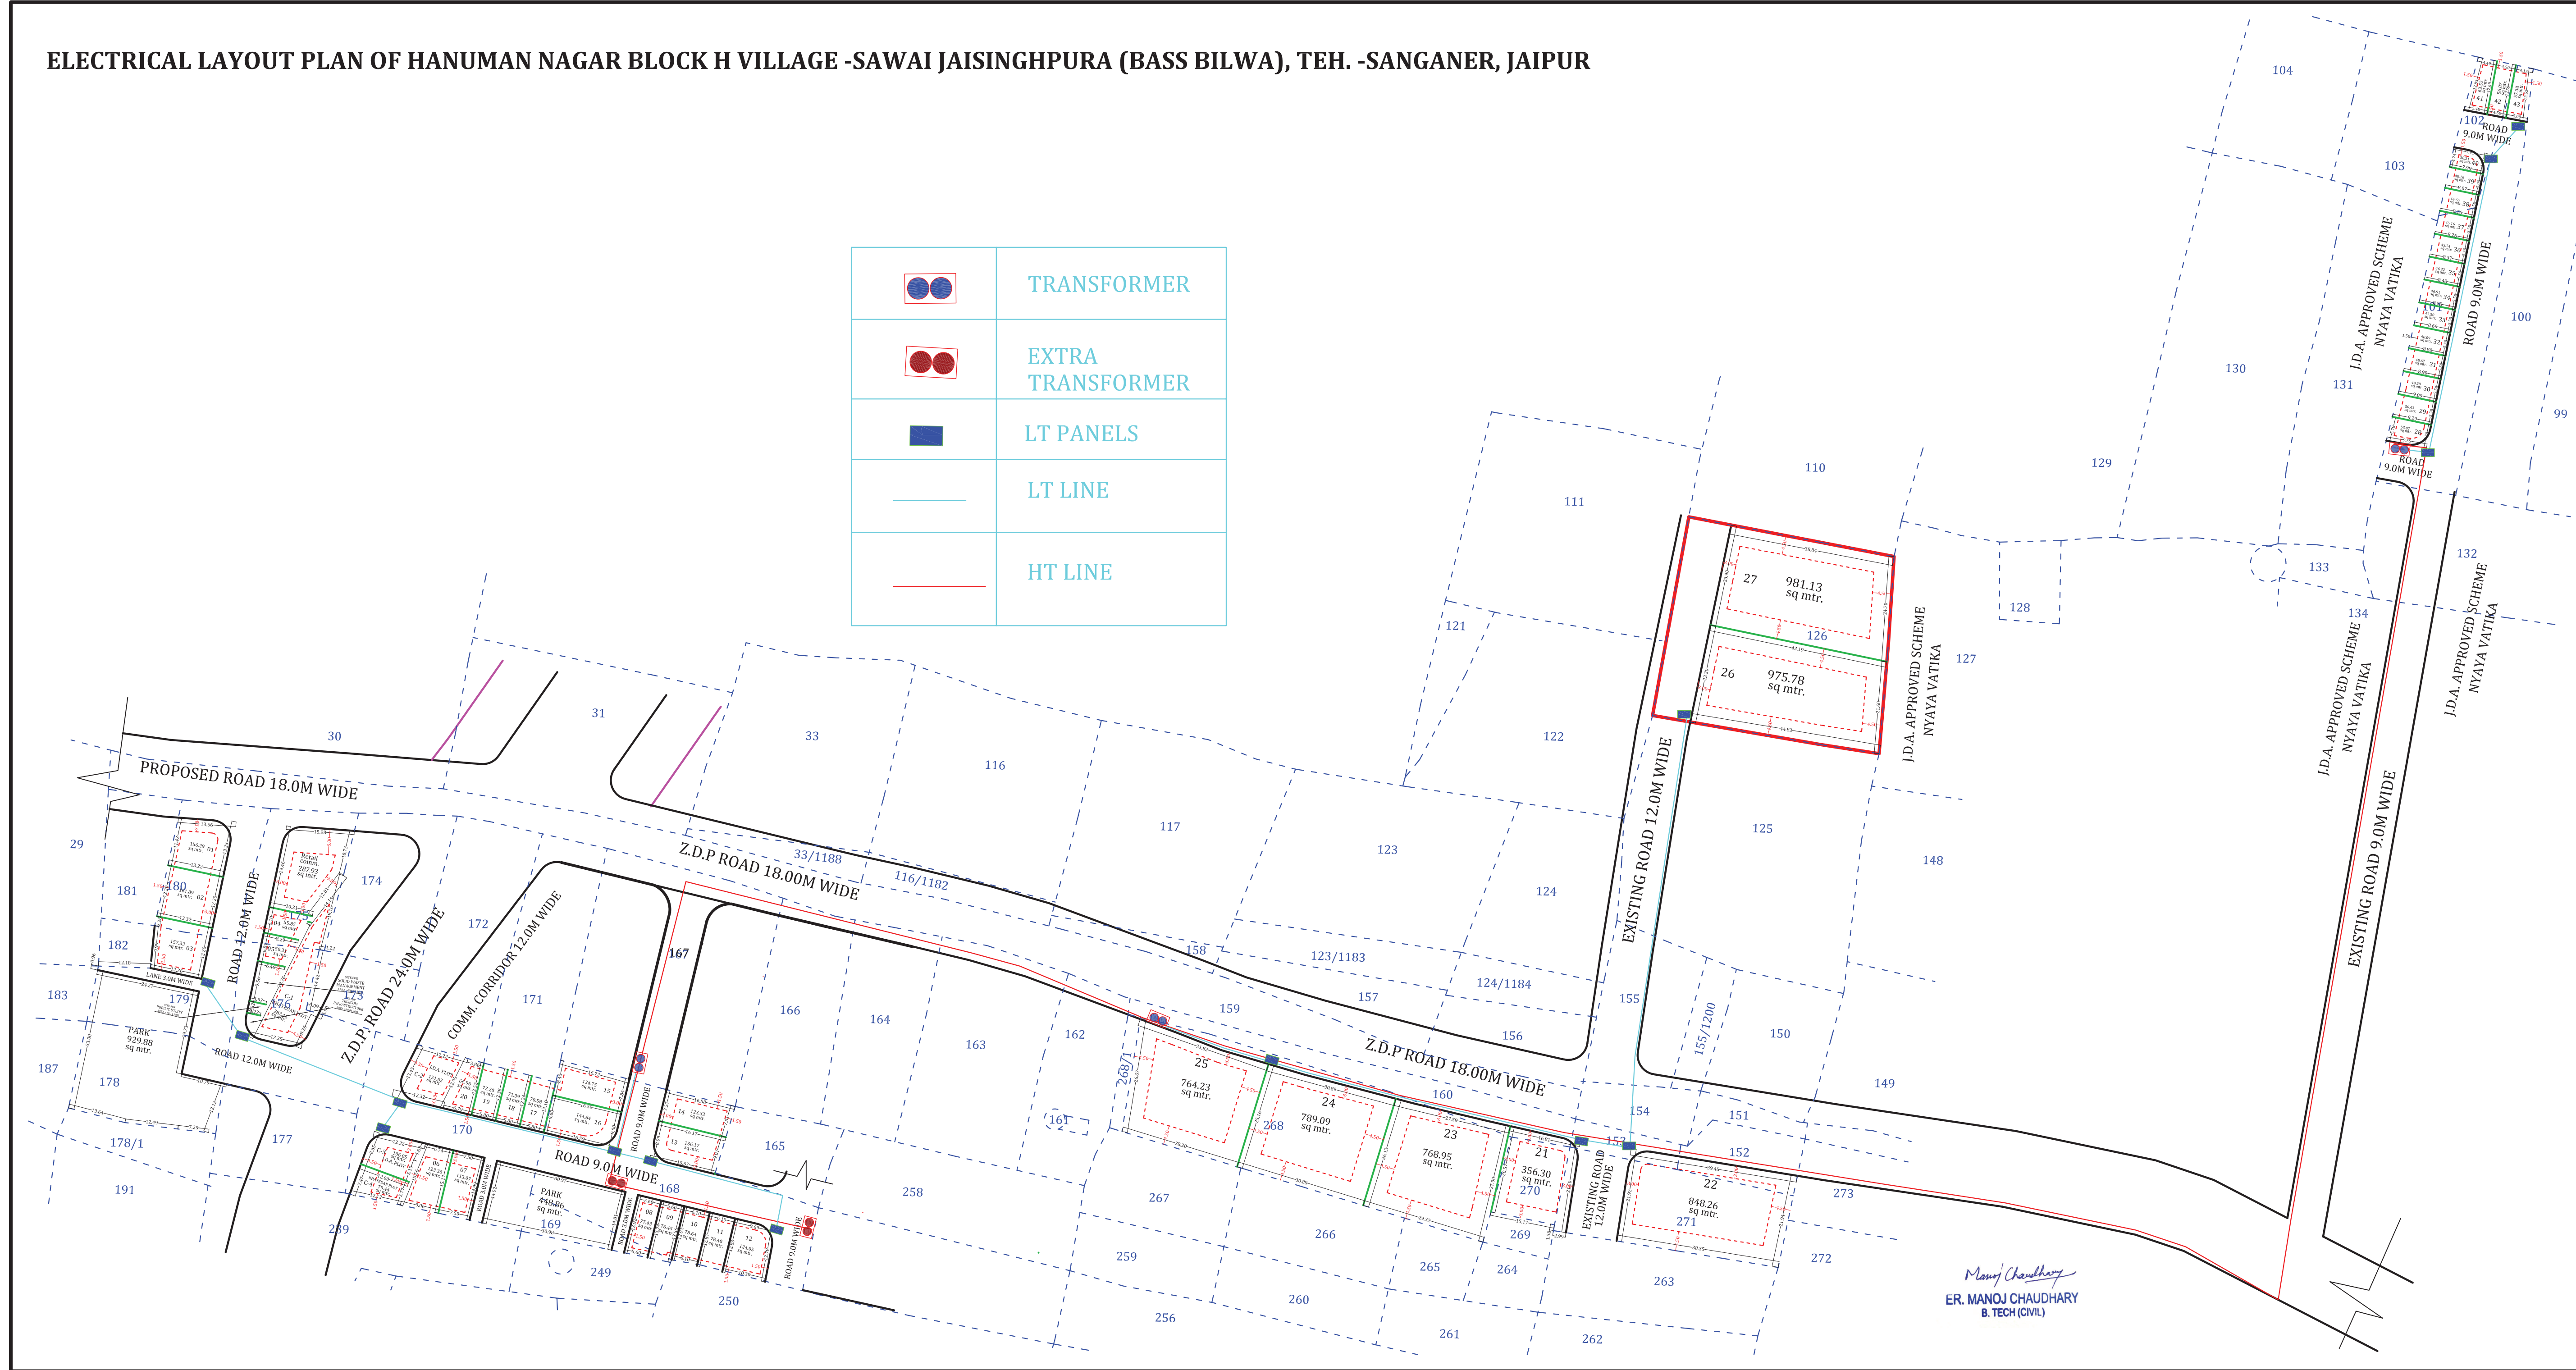

NAME OF SOCIETY :-

NIJJI KHATEDARI

NAME OF SCHEME :-

ZONE NO.-14

SECTOR NO.-

SCALE:- 1"=50'

DRG. NO.

J.E.N (ZONE-14)

AMIN (ZONE-14)

T.D.R. (ZONE-14)

A.T.P. (ZONE-14)

D.C (ZONE-14)

JAIPUR DEVELOPMENT AUTHORITY, JAIPUR