


LEGENDS:-		
S.No.	SYMBOL	DESCRIPTION
1		150MM DRAIN CHANNEL
2		RAIN WATER PIPE
3		Ø100MM RAIN PIPE

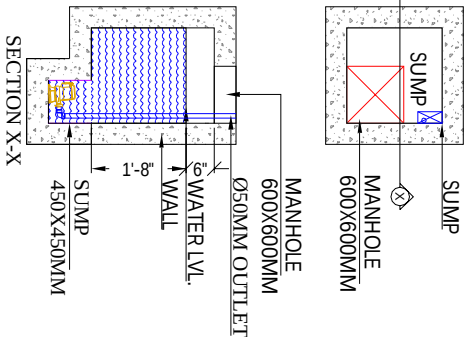

MEP CONSULTANTS:

PILLARPUS PVT.LTD.-The New Age MEP Consultancy Firm
Plot No. 45/46 gun lamheswar nagar A,
Vijay Dwar, Gandhinagar, Jaipur-302021
JAI PUR I GURGAON I BANGLORE
Email: contact@pillarpus.com Contact No. +91-9798858301 / Web site: www.pillarpus.com

STATUS OF RELEASE:


☒ FOR APPROVAL	☐ FOR TENDER
☐ FOR DISCUSSION	☐ FOR CONSTRUCTION

REV.	DATE	PREP BY	CHK BY	APPVD BY	REMARK
R0	02-06-2022	RAHUL	VINOTH	VINOTH	
REV.	DATE	PREP BY	CHK BY	APPVD BY	REMARK


PROJECT NAME:
proposed residential flats
@inderprast,jaipur

CLIENT NAME:
SOMYA-KRITI
Architects, Interior Designers
B-2 / 518, Chitrakoot Scheme,
Ajmer Road, Jaipur
PH: +91-9829073383
email:
architects.somyakriti@gmail.com

DRAWING TITLE				
STILT FLOOR- DRAINAGE LAYOUT				
NORTH	DRAWING NO	REV.		
SCALE	DATE	PREP	CHD	APPVD
N.T.S	10-06-2022	ANIL JANGIR	VINOTH	

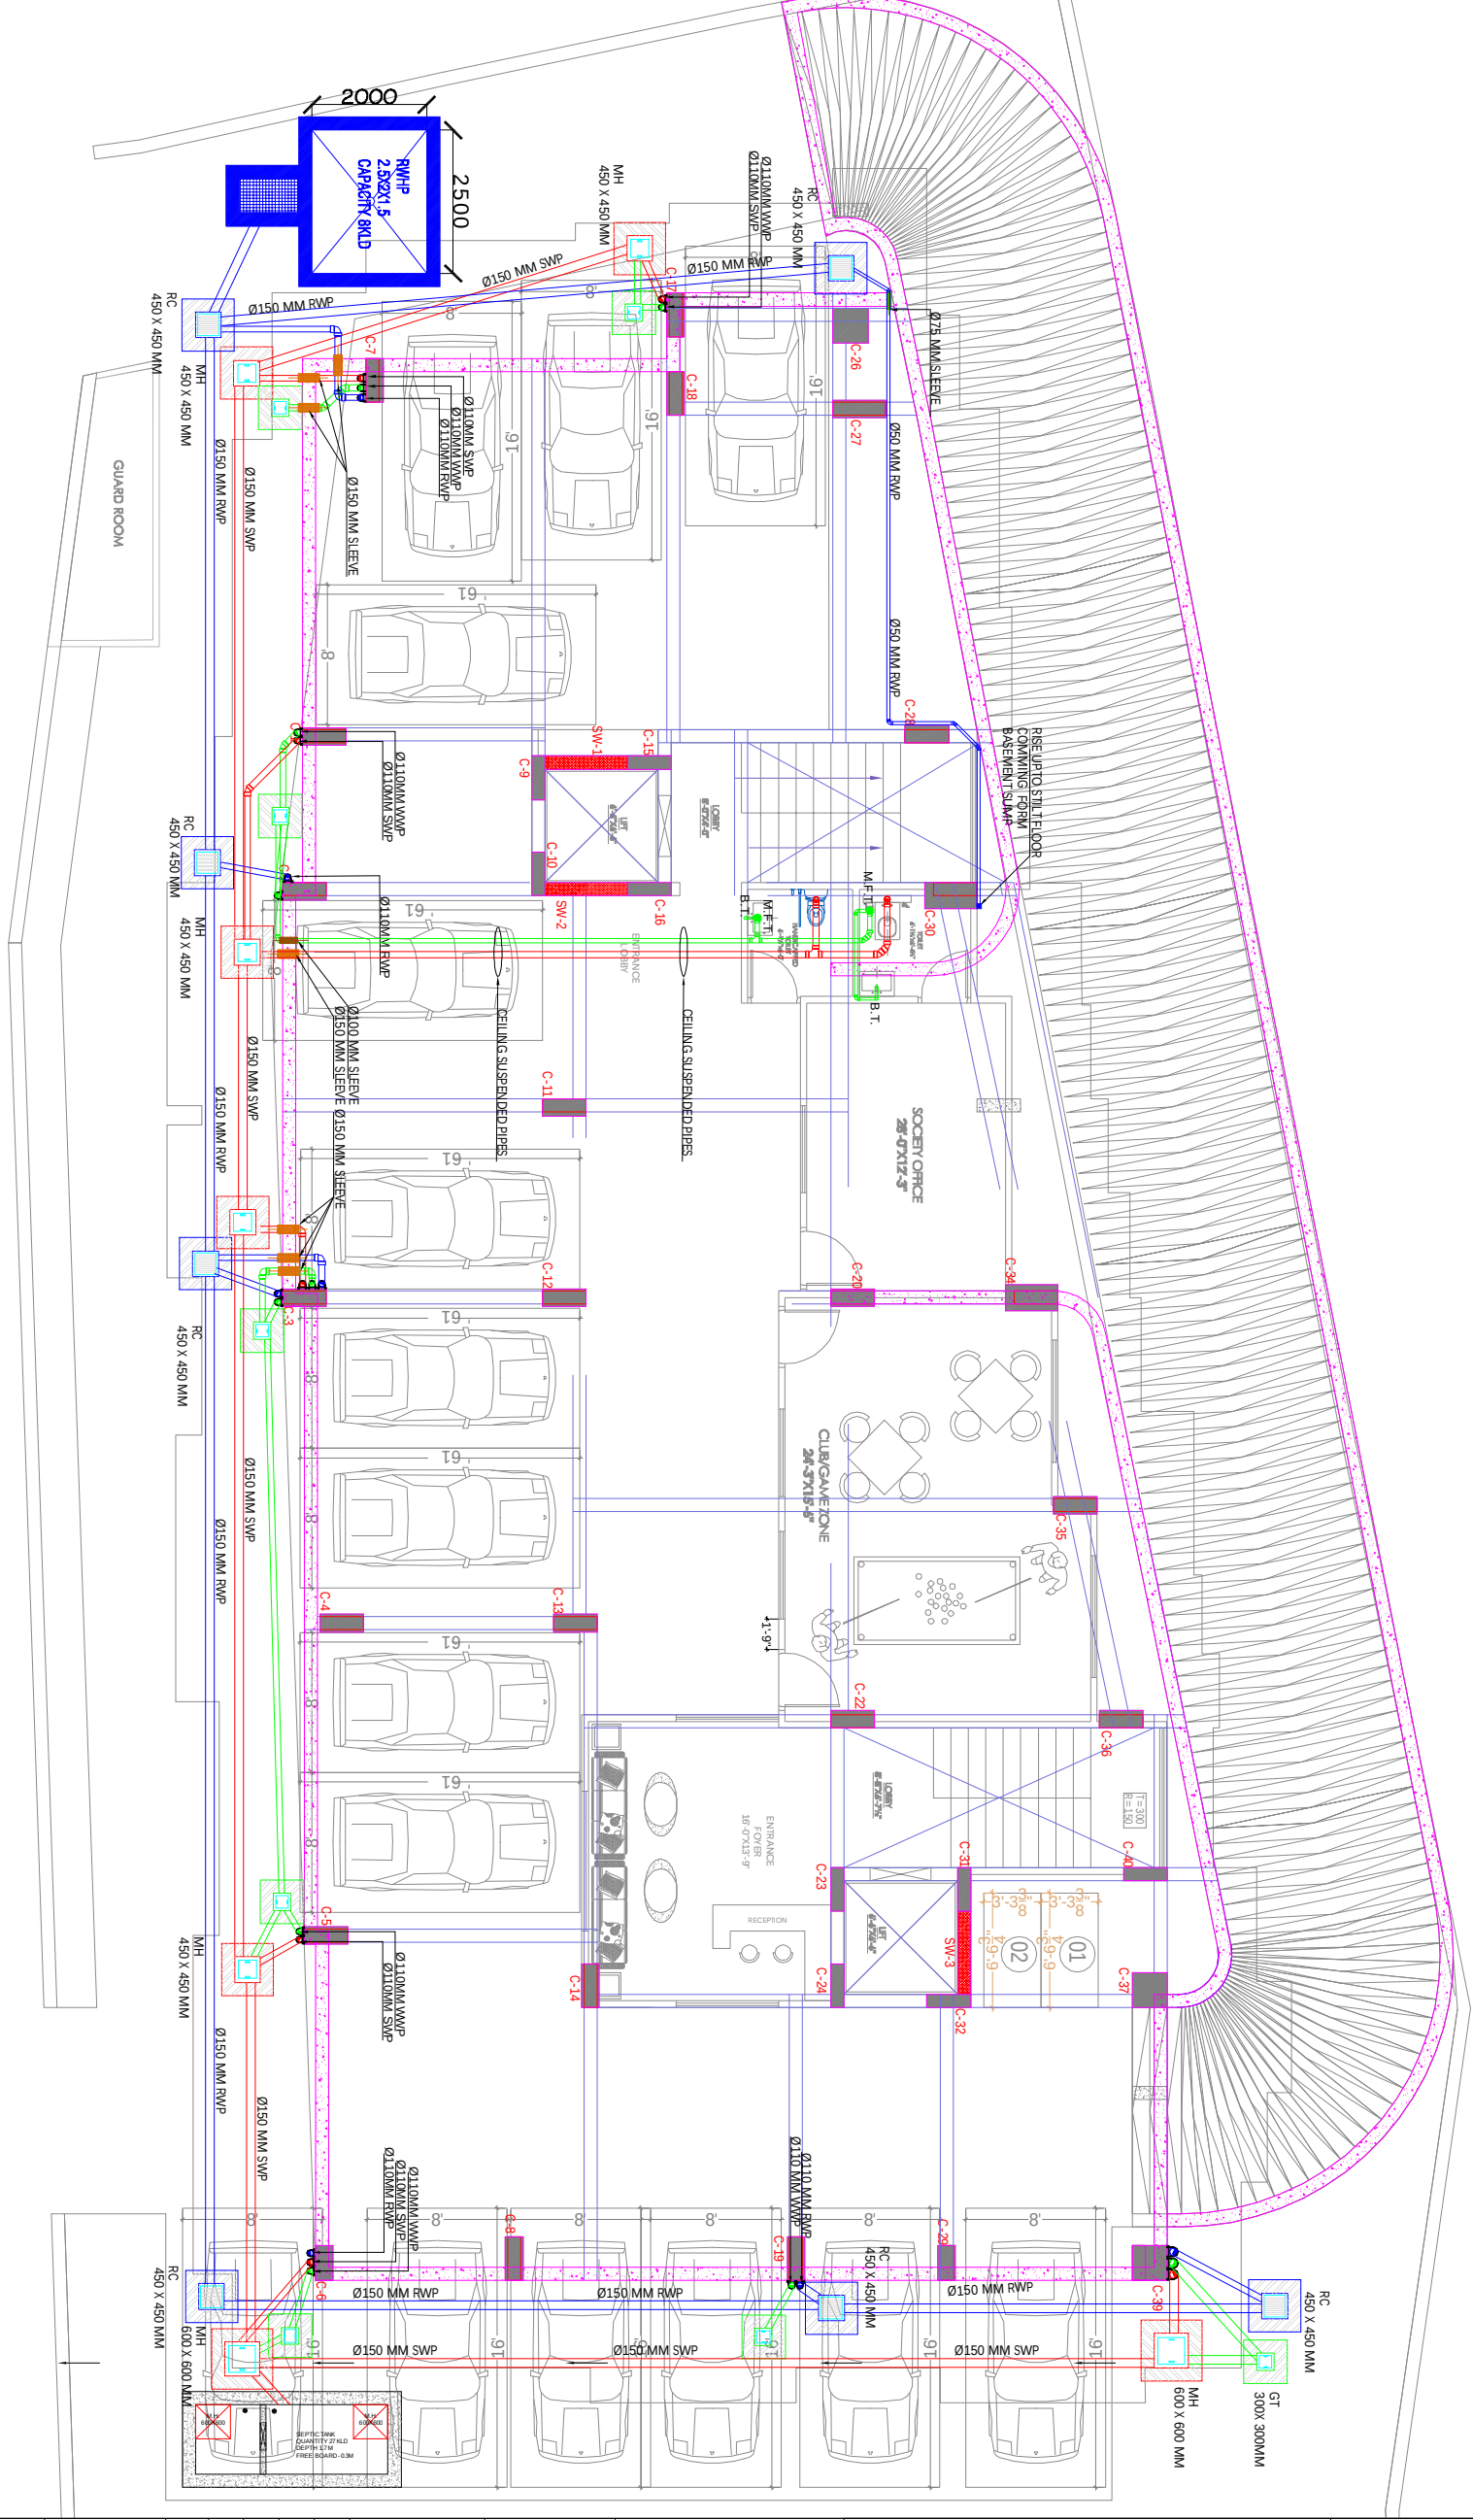

STILT FLOOR
LAYOUT PLAN

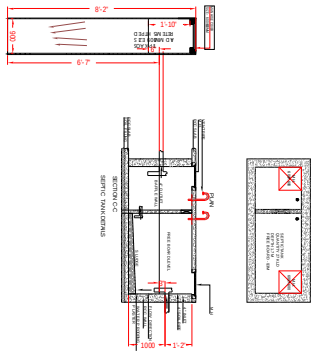

Amit Kothiwala
AMIT KOTHIWAL
ARCHITECT
CA/2005/37255