
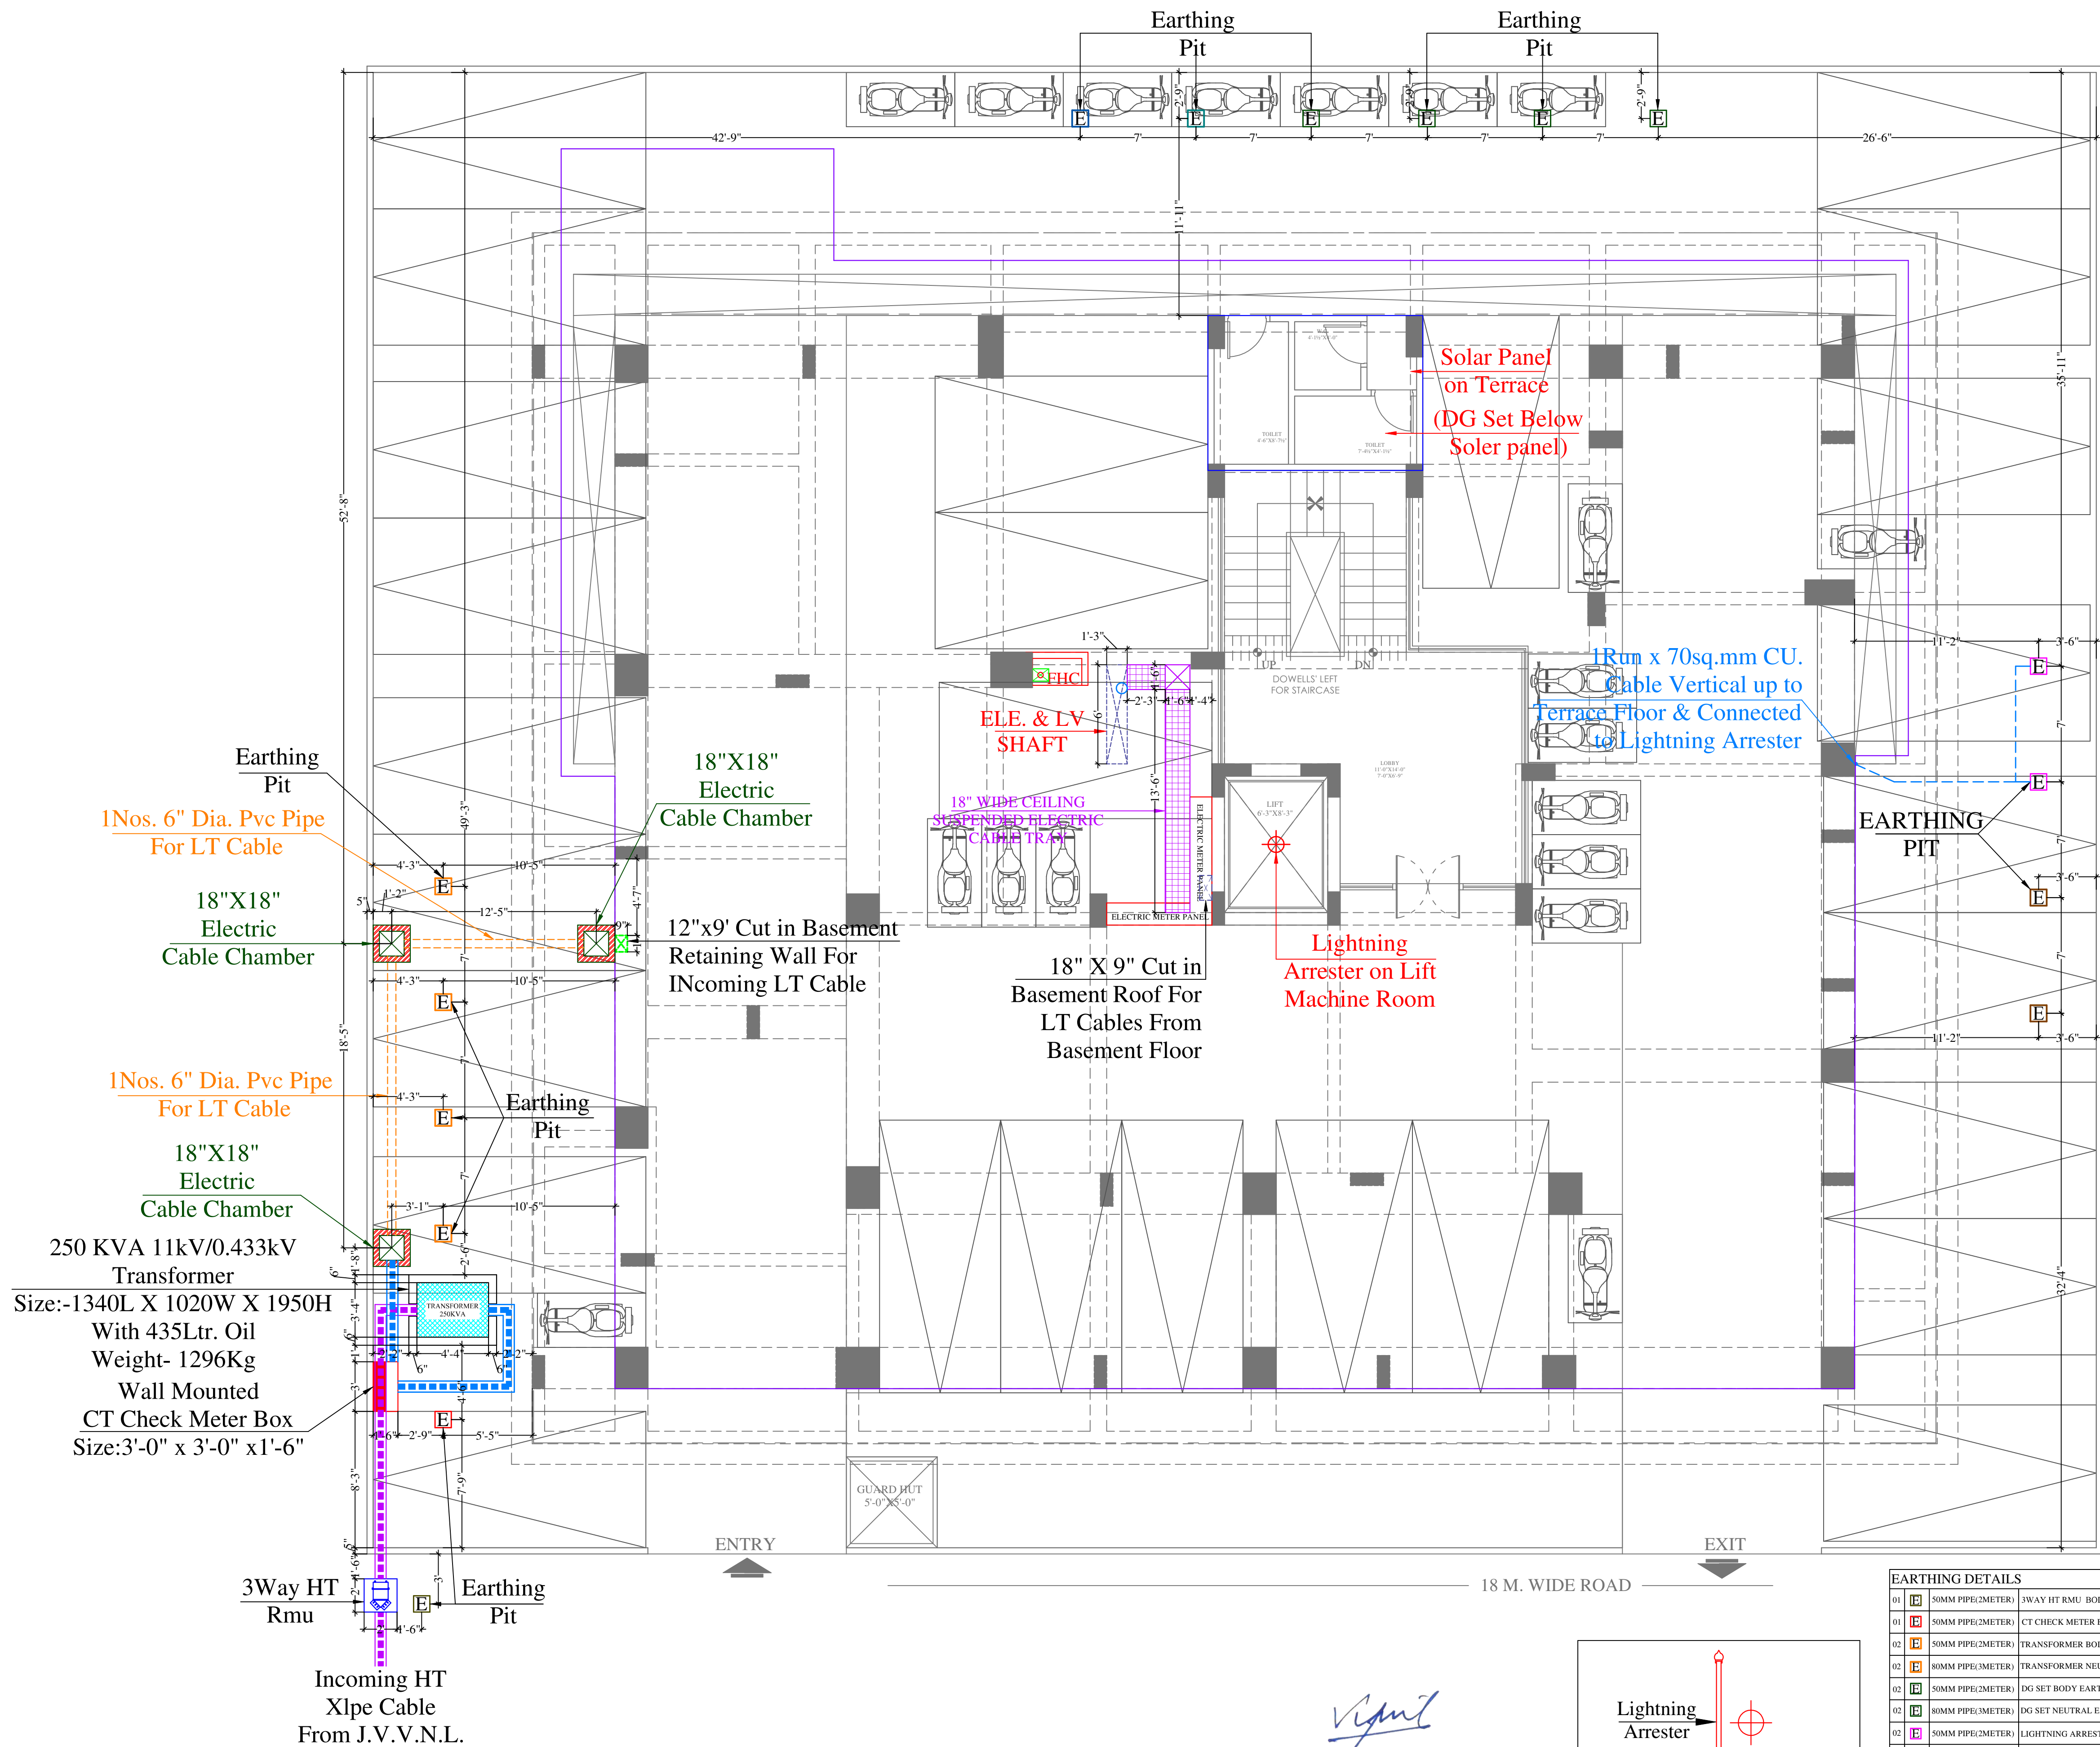
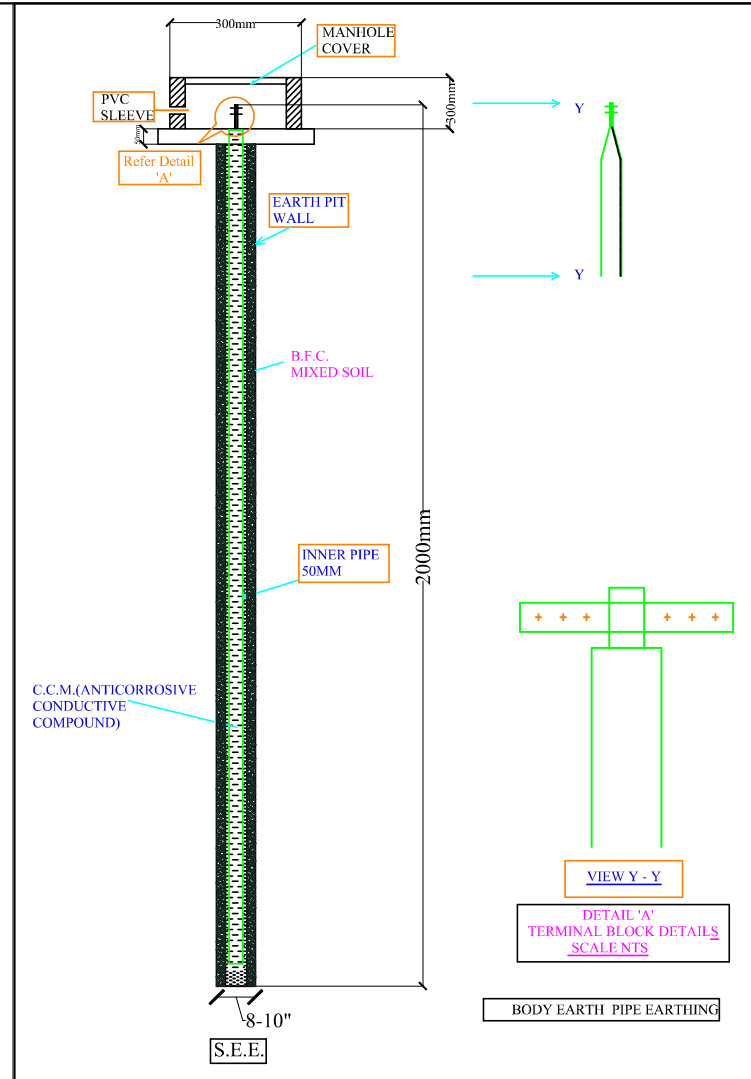


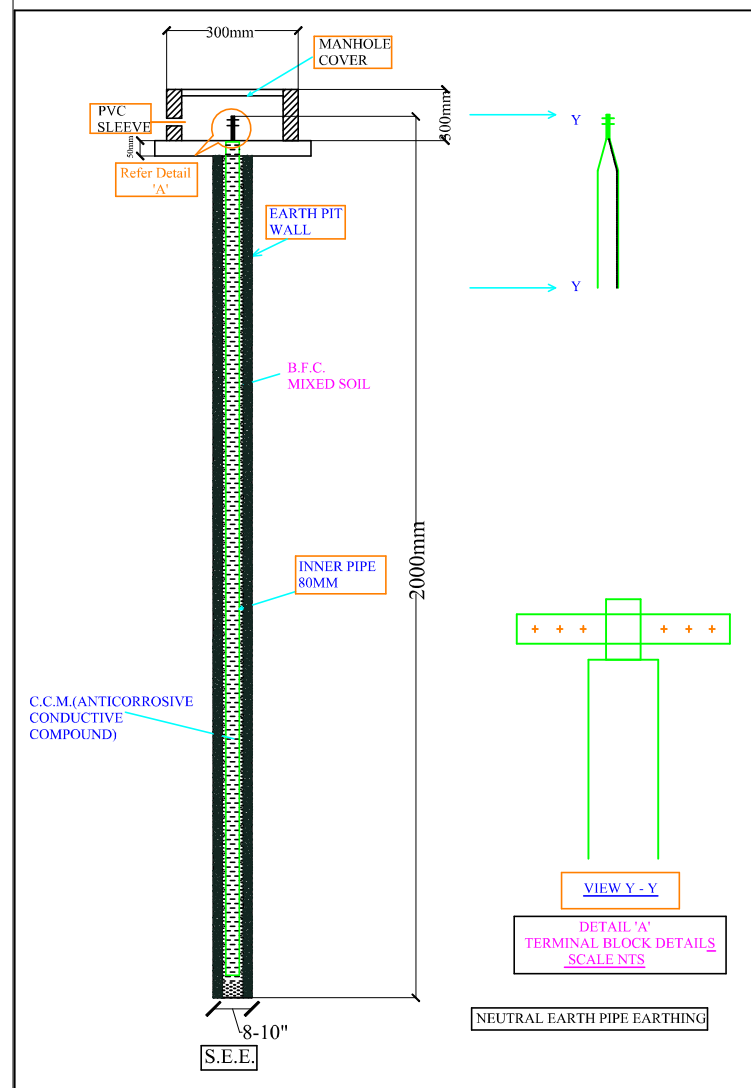

PROJECT:-
"ELITE 24"

PROJECT ADDRESS:-
PROPOSED RESIDENTIAL BUILDING
AT PLOT NO. A-46 & A-47, SCHEME-6D,
ENGINEERS COLONY,
VILL.-MANYAWAS, MASAROVAR,
JAIPUR

DEVELOPER:-
ELITE
BUILDERS & DEVELOPERS

ARCHITECT:-
MEP
INVISION
ARCHITECTS
ARCHITECTURE | INTERIORS | LANDSCAPING | PRC
invisionarchitect@gmail.com | Mob. +91 7665234536

STRUCTURE CONSULTANT:-
BACKBONE
STRUCTURAL CONSULTANTS
PH:07726939881,09414781885
Mail:shekhawat.mahendra@gmail.com

SERVICES CONSULTANT:-
ASHI ASSOCIATES
P 9 / 440 , Keshav Marg Chitrakut Scheme,Jaipur
PH:91-093146-10438 ,0141-2440946,
Mail:vipul8599@yahoo.com

DRAWING TITLE:-
STILT FLOOR
ELE. SUB-STATION, CABLE
ROUTE & LIGHTNING
ARRESTER PLAN

NORTH:-
E
N
S
W

DWG. NO.:-

DATE:-
28-11-2023

REV.:-
01

DRAWN BY:-
VIJESH/PAWAN

CHECKED BY:-
SANJAY

APPD. BY:-
VIPUL AGARWAL

EARTHING DETAILS		
01	50MM PIPE(2METER)	3WAY HT Rmu BODY EARTH
01	50MM PIPE(2METER)	CT CHECK METER BOX BODY EARTH
02	50MM PIPE(2METER)	TRANSFORMER BODY EARTH
02	80MM PIPE(3METER)	TRANSFORMER NEUTRAL EARTH
02	50MM PIPE(2METER)	DG SET BODY EARTH
02	80MM PIPE(3METER)	DG SET NEUTRAL EARTH
02	50MM PIPE(2METER)	LIGHTNING ARRESTER BODY EARTH
01	50MM PIPE(2METER)	ELECTRIC PANEL BODY EARTH
01	50MM PIPE(2METER)	TELEPHONE EXCH. BODY EARTH
02	50MM PIPE(2METER)	LIFT PANEL BODY EARTH
NOTES: 1. ALL NEUTRAL EARTHS TO BE CONNECTED 50 X 3 GI EARTH STRIP FROM EARTH PIT TO EQUIPMENT. 2. ALL BODY EARTHS TO BE CONNECTED 25 X 3 GI EARTH STRIP FROM EARTH PIT TO EQUIPMENT.		

VIPUL AGARWAL
M.E.P. CONSULTANT
B.E. ELECTRICAL

Lightning
Arrester

Model: Stormaster – ESE - 30
(Level 2/Medium Protection)
(Protection radius - 25M
Mast Height - 2 Mtr)

SERVICES CONSULTANT:
ASHI ASSOCIATES
F 9-440, KESHAV MARG,
CHITRAKUT SCHEME, JAIPUR
PH:93146-10438,2440946
E MAIL:vipul8599@yahoo.com

PROJECT:
"ELITE 24"

PROJECT ADDRESS:-
PROPOSED RESIDENTIAL BUILDING
AT PLOT NO. A-46 & A-47,SCHEME-6D,
ENGINEERS COLONY,
VILL.-MANYAWAS, MASAROVAR,
JAIPUR

TITLE:
MAIN LT PANELS

DRAWING:
SINGLE LINE DIAGRAM

DATE:-
06-07-2023


REV:-
00

DRAWN BY:-
VICKY YADAV

CHECKED BY :-
VIPUL AGARWAL

VIPUL AGARWAL
M.E.P. CONSULTANT
B.E. ELECTRICAL

NOTE:-
THIS SLD HAS BEEN PREPARED AS PER CONCEPT STAGE DATA
AVAILABLE WITH US. KINDLY CONTACT US FOR FINAL SLD &
DETAILS BEFORE PLACING ORDER FOR FABRICATION.WE
SHALL NOT BE RESPONSIBLE , IF THE PANELS ARE UNDER
UTILISED OR OVER LOADED AT ANY STAGE.

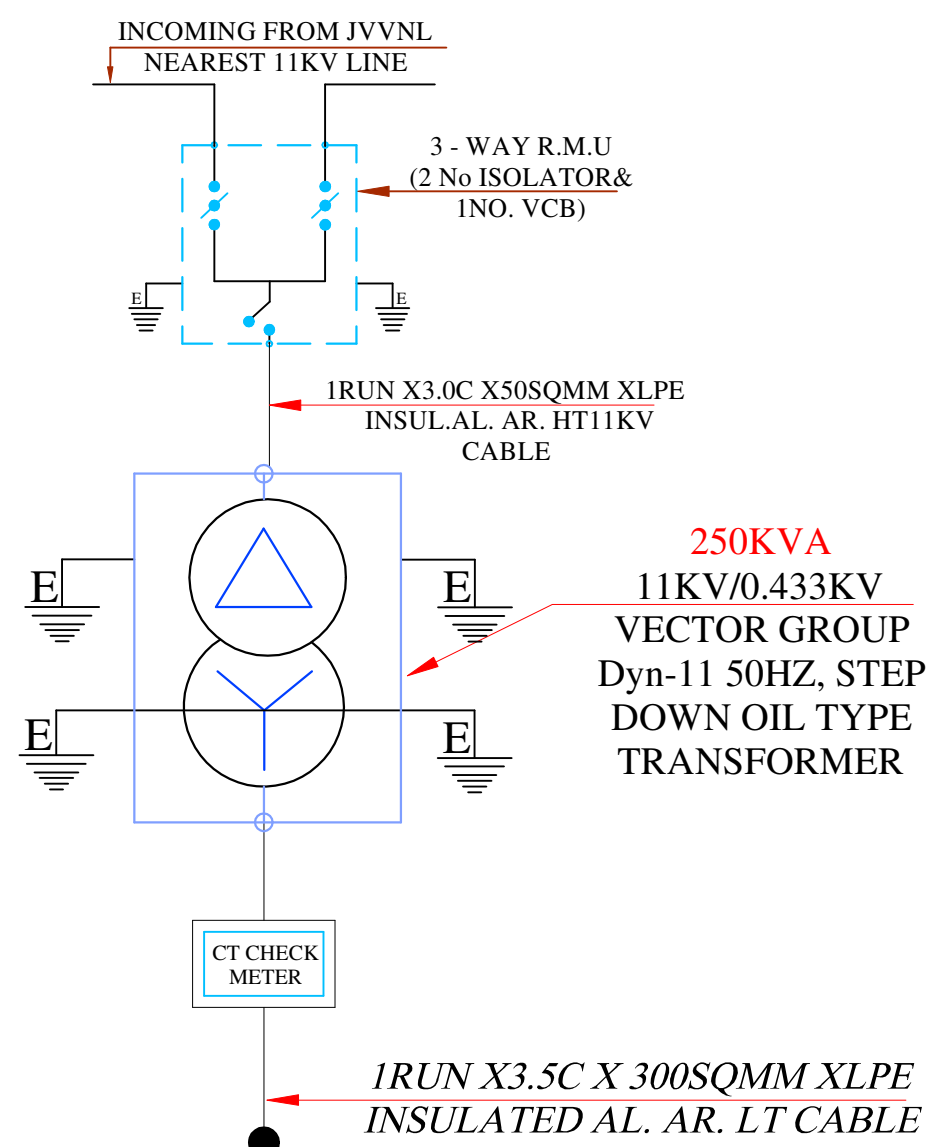

MAIN LT PANEL

