


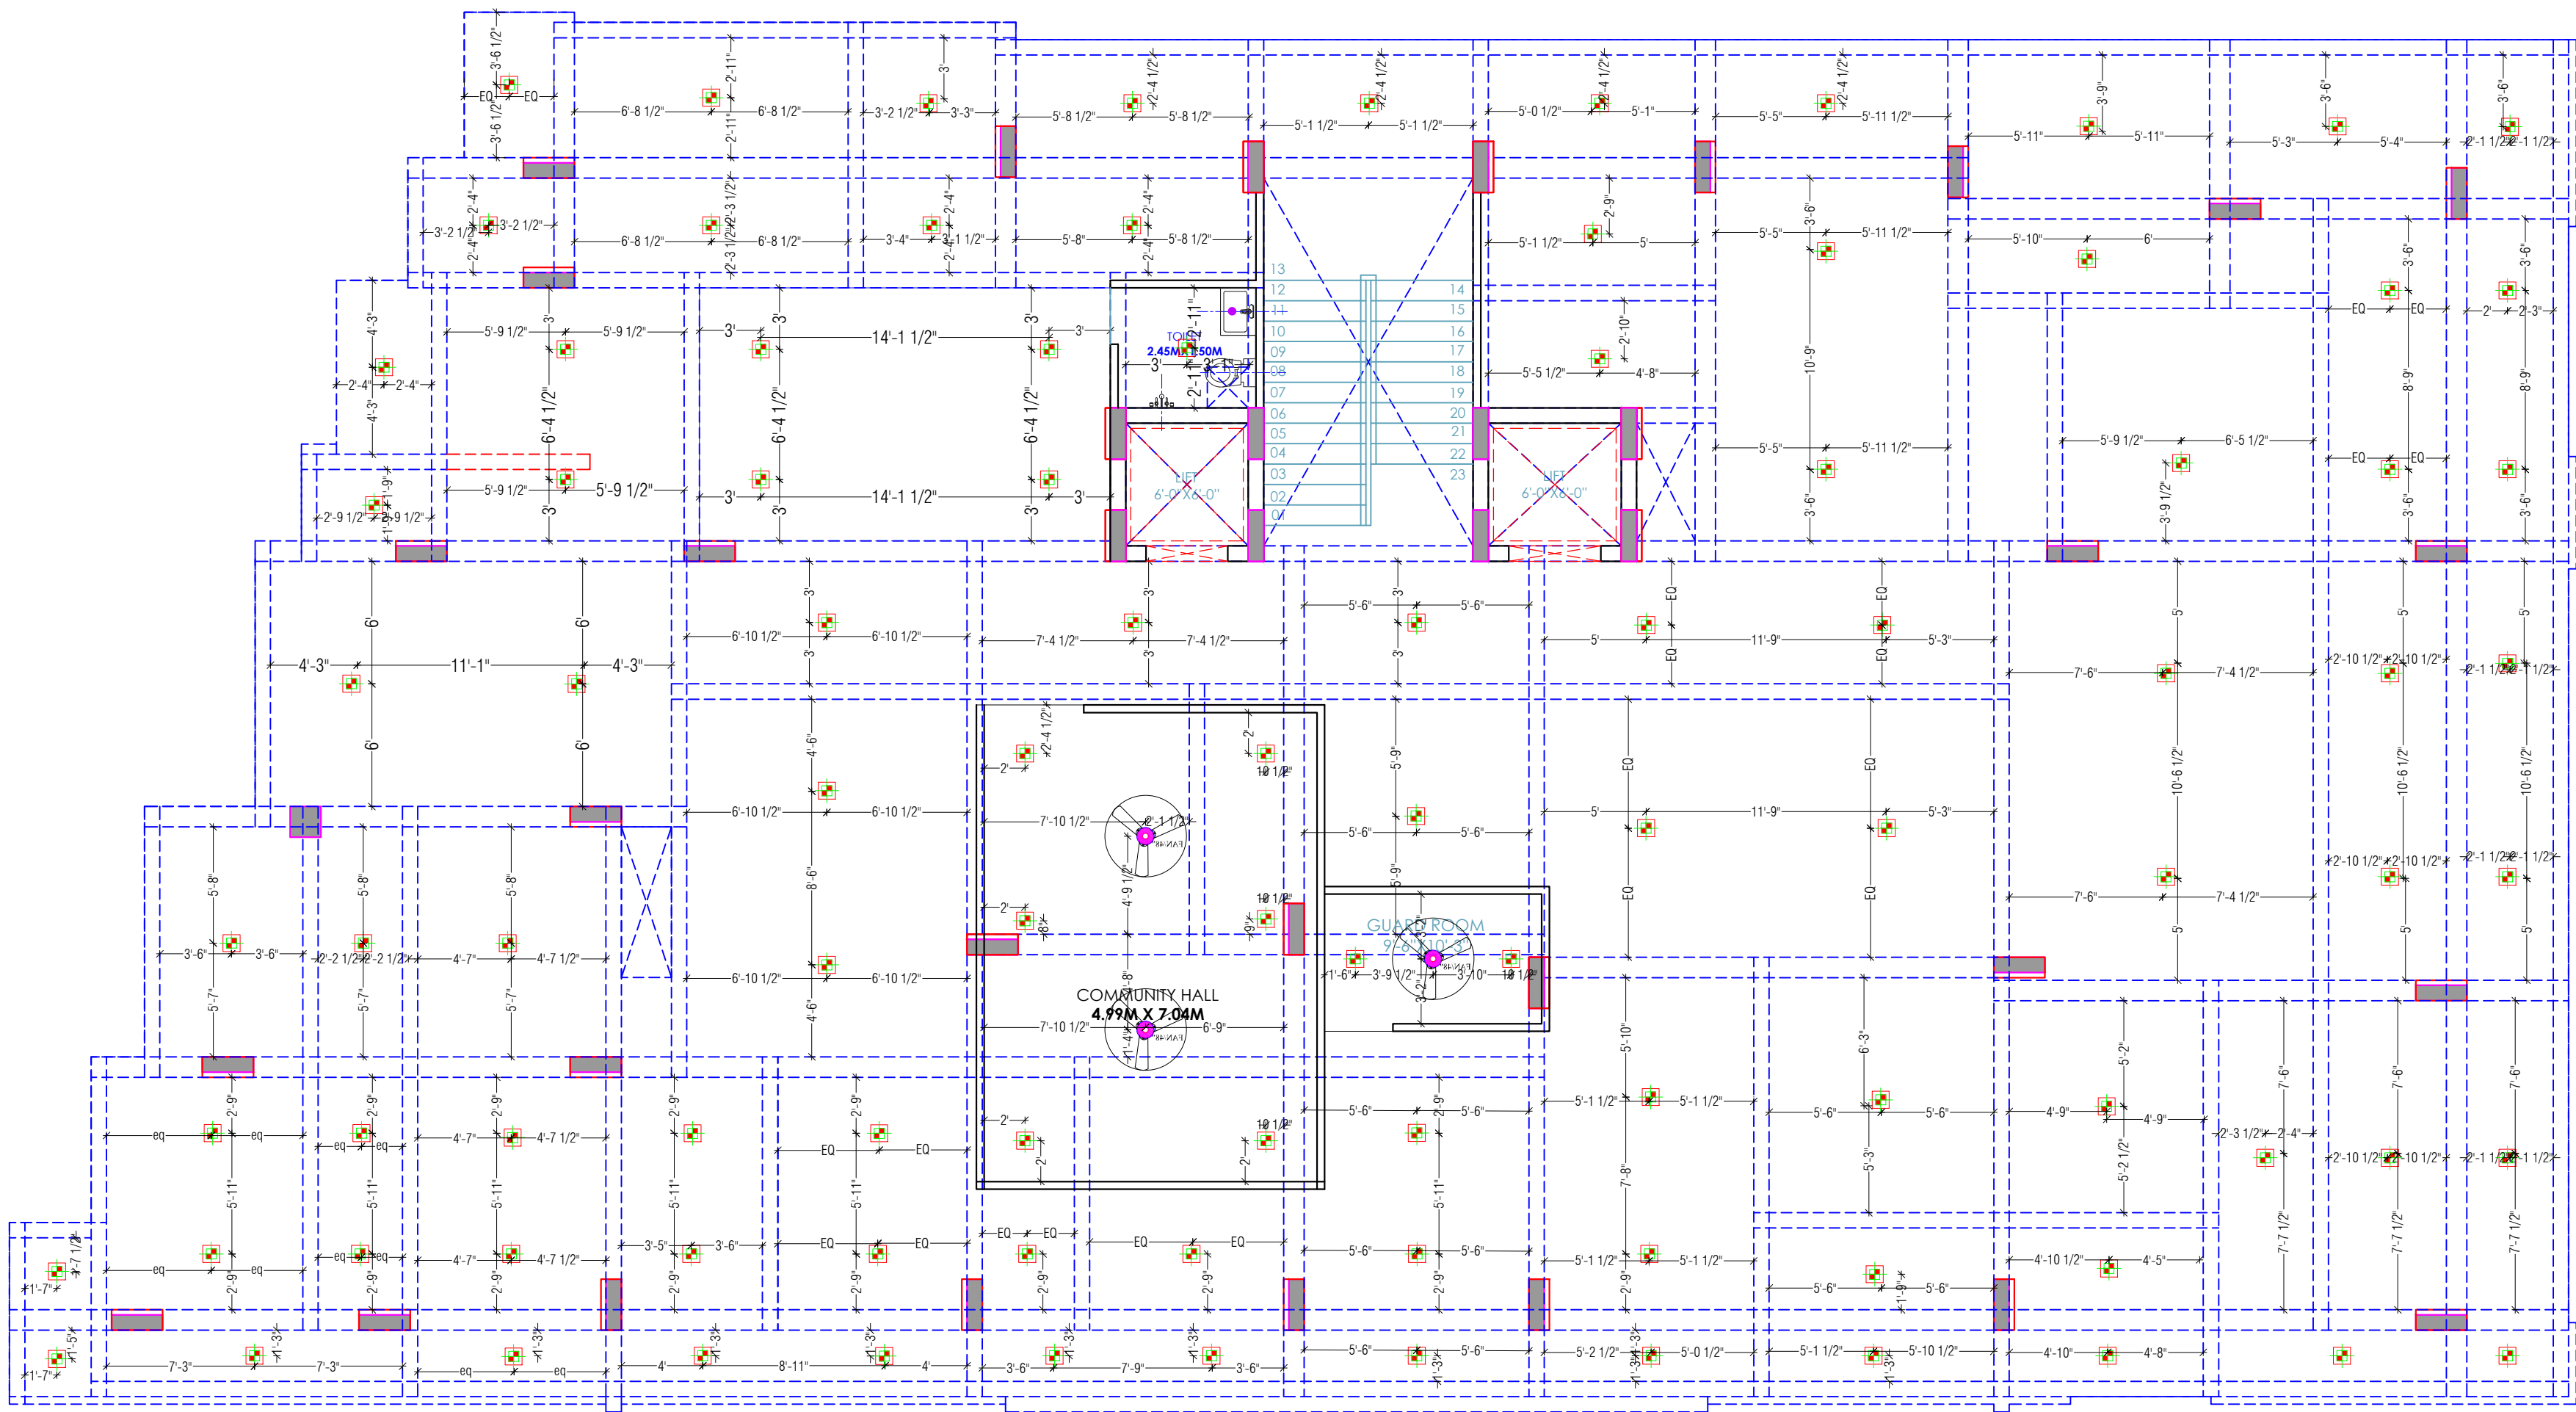

For My Dream House

Partner

For My Dream House
FRAME CONSULTANTS
E: LOKESH WADHWA
B.Tech.(Civil), M.Tech.(Structure)
IASPrudE-AM-232

LEGENDS:				
Mounting Height	No.	I D	Symbol	Description
IN FLOOR			---	CONTROL WIRING
IN CONDUIT			---	CONTROL WIRING
IN CONDUIT			---	AC CONTROL WIRING
IN CONDUIT			---	GEYSER CONTROL WIRING
IN CONDUIT			---	BUZZER CONTROL WIRING
CEILING	06	FAN48"		CEILING FAN 48"
CEILING	02	FAN30"		CEILING FAN 30"
+90°	04	TL		X40W WALL TUBELIGHT
+90°	04	GL		WALL BRACKETS AS DESIGN LIGHT
+90°	02	GL		WALL BRACKETS AS DESIGN FOR GANESH LIGHT
	02	GL		WALL BRACKETS AS DESIGN FOR GATE LIGHT
CEILING	21	CFL		CFL CEILING LIGHT
+21"	02	FL		FOOT LIGHT
+48"	14	SB		SWITCH BOARD
+75"	03	ML		1 X 11 W CFL MIRROR LIGHT
VENTILATOR HT.	03	CR		CEILING ROSE
VENTILATOR HT.	03	EXF		8" DIA FRESH AIR FAN
+24"	02	TEL		TELEPHONE POINT
+27"	03	TV		TV COAXIAL POINT
+24"	02	LP TEL		6 A PLUG POINT FOR TELEPHONE
+27"	03	LP TV		6 A PLUG POINT FOR TV
+24"	02	LP		6 A PLUG POINT
+72"	01	LP-CH		6 A PLUG POINT FOR CHIMNEY
+102"	03	SAC		SPLIT AC
+102"	03	PP-SAC		25 A POWER POINT FOR SPLIT AC
+42"	01	PP-MIX		15 A POWER POINT FOR MIXER
+78"	02	PP-G		15 A POWER POINT FOR GEYSER
+54"	01	PP-F		15 A POWER POINT FOR FRIDGE
+78"	01	PP-WP		15 A POWER POINT FOR WATER PUMPER
+48"	01	PP-SM		15 A POWER POINT FOR WASHING MACHINE
+42"	02	BP		BELL PUSH SWITCH
+90°	01	BZ		BUZZER POINT
+24"	03	AC		AC STARTER
+60"	01	MCB DB		MCB DISTRIBUTION BOARD
	05	SBL/L		SWITCH BOARD NO/LIGHT CIRCUIT NO.
	03	AC		AC CIRCUIT NO.
	05	PI		POWER CIRCUIT NO.

WARNING

1. This drawing is the sole copyright of Architects **VISTAAR** and should be used for the purpose expressly issued.

GENERAL NOTES


- All dimensions are in feet and inches.
- Do not scale this drawing follow written dimensions only.
- This drawing should be read in conjunction with other architectural and structural drawings.
- Any discrepancy in the drawing should be immediately brought to the notice of architect.

PROJECT:-
SUNRISE HEIGHTS
BUILDING AT PLOT NO.-E-15,E-16 & E-17(RECONSTITUTION),JAGDAMBA NAGAR-E,JAIPUR

DRAWING TITLE
STILT FLOOR CEILING ELECTRICAL PLAN

ARCHITECTS :
VISTAAR ARCHITECTS & PLANNERS
Architects :: Interior Designers
B-2/12, Chitrkoot scheme,
main Gandhi Path,Opp mall of jaipur,Jaipur
PH.- 0141-4370233,09001010366

PATH :-			
DRN.	DATE	REV.	NORTH
MANOJ KUMARWAT	06-09-2023		
SCALE	JOB NO.		
N.T.S			

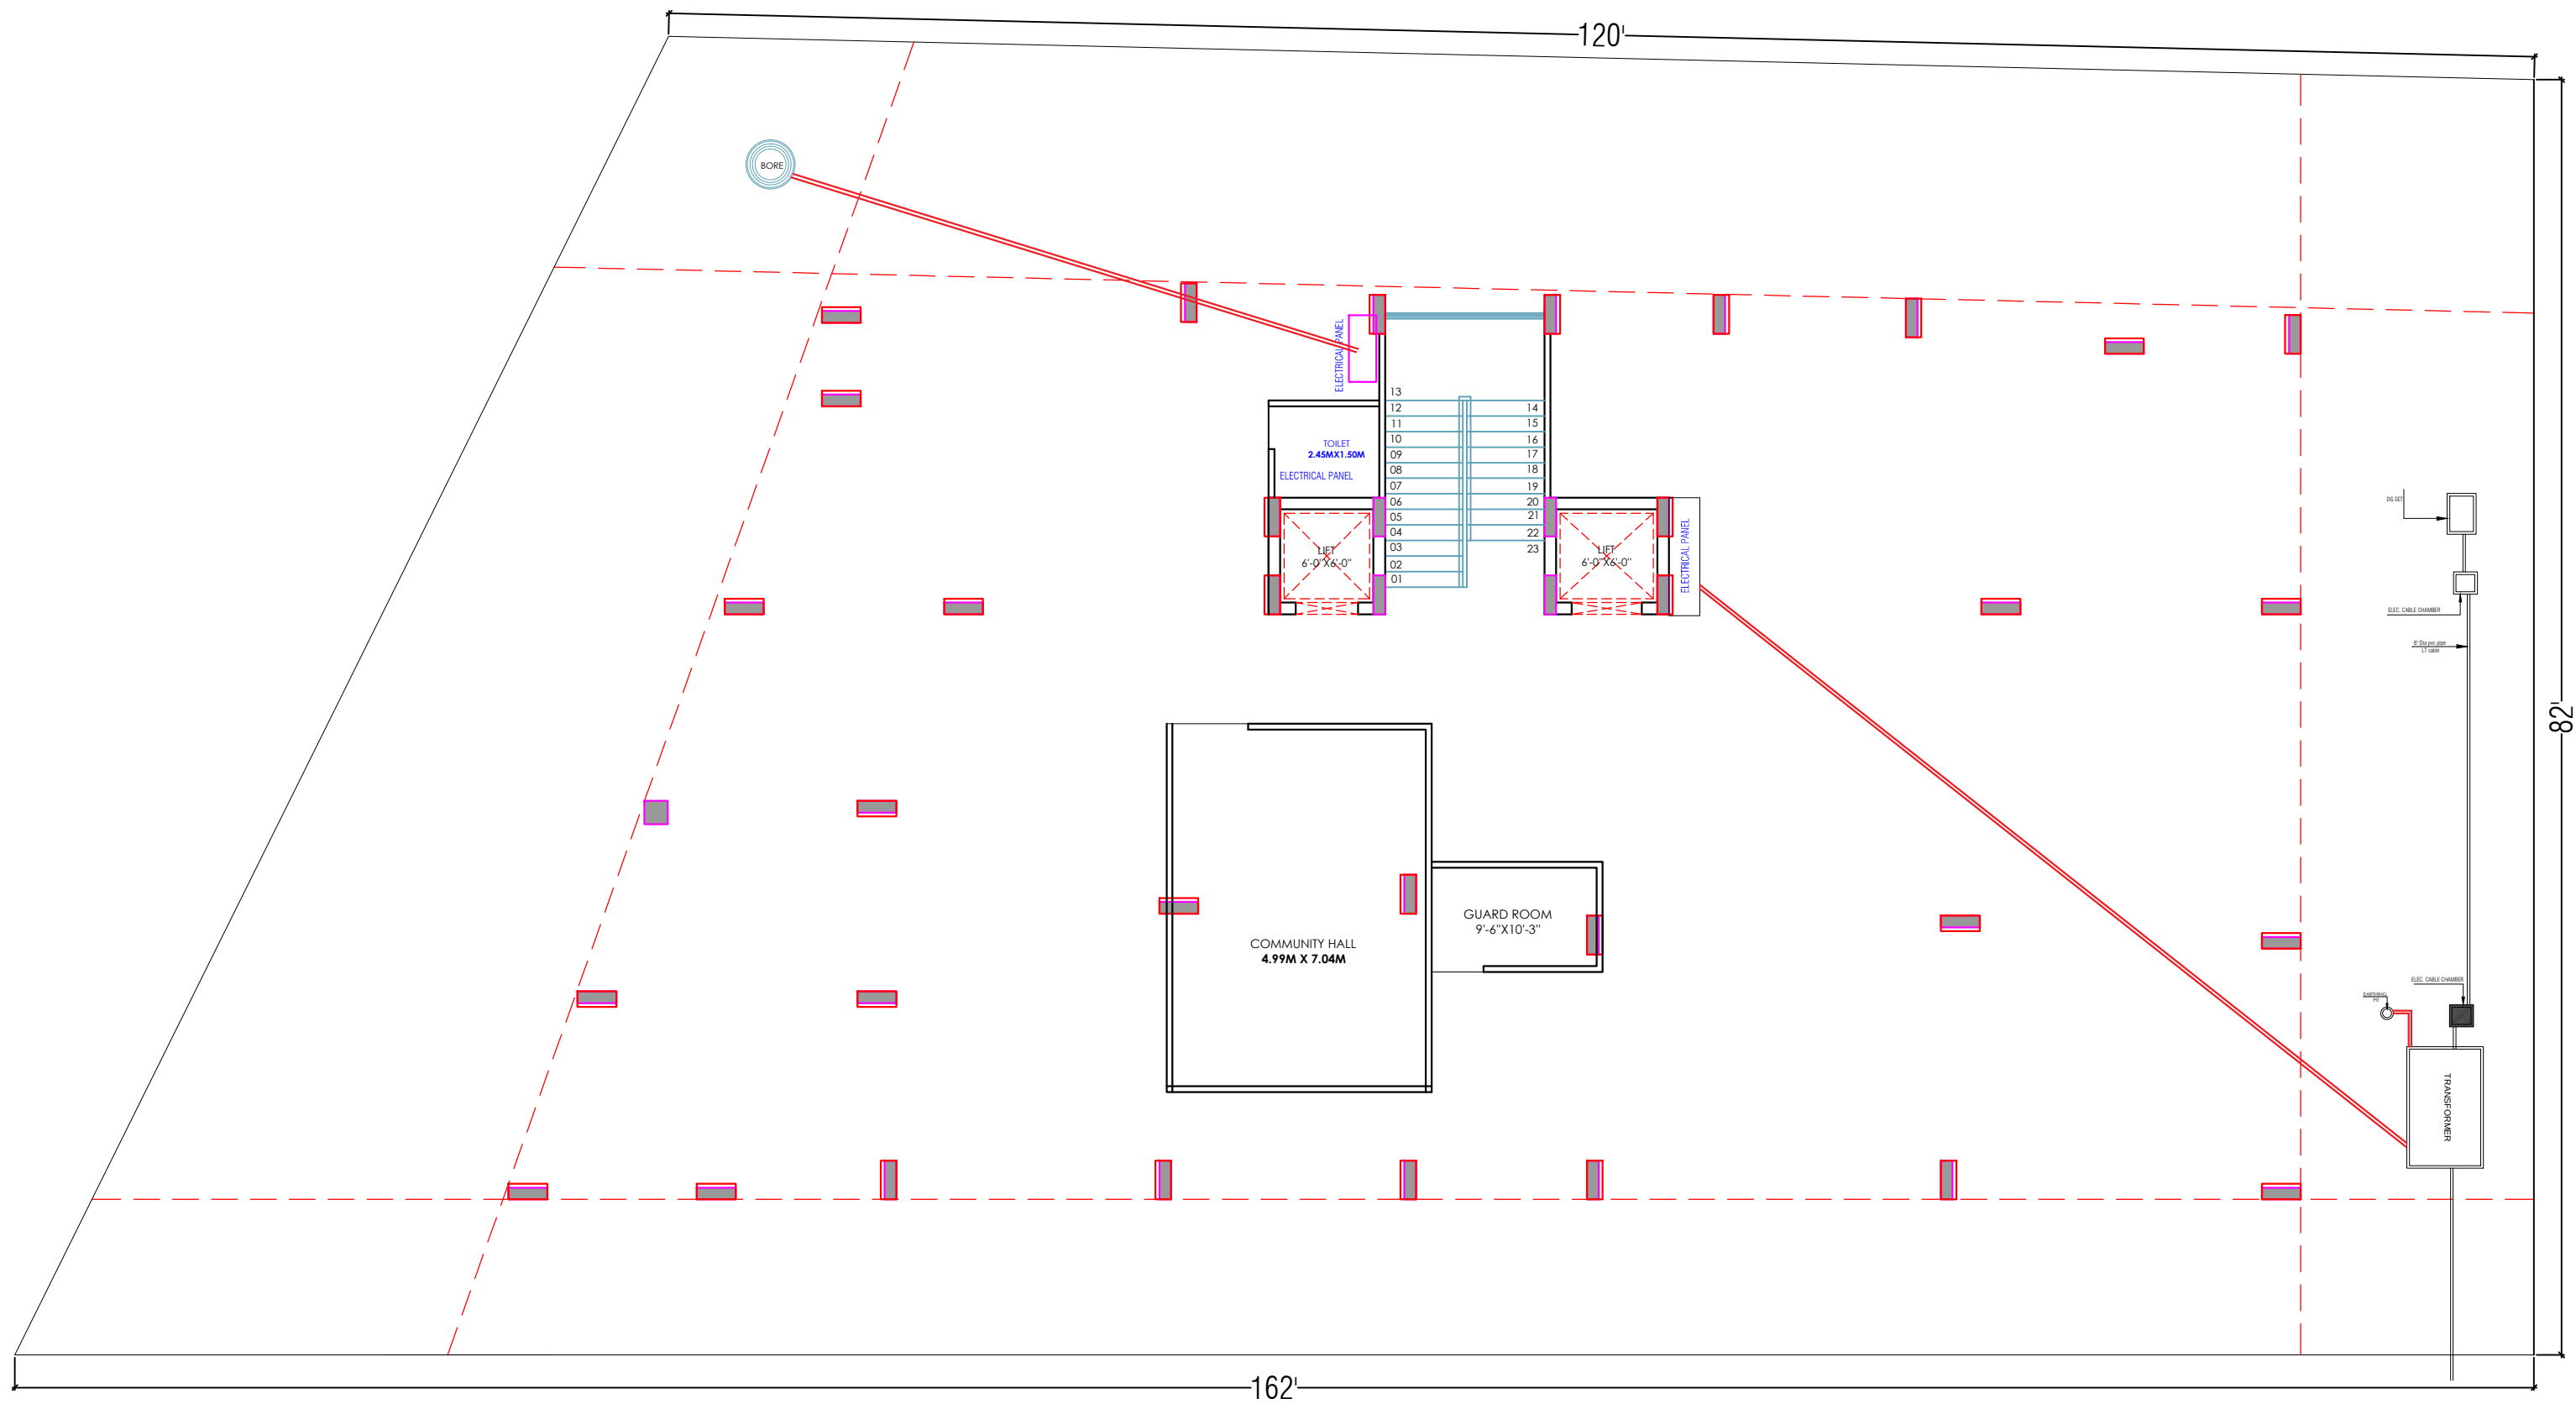

LEGENDS:-				
Mounting Height	No.	I D	Symbol	Description
IN FLOOR				CONTROL WIRING
CONDUIT				CONTROL WIRING
IN CONDUIT				AC CONTROL WIRING
IN CONDUIT				OTHER CONTROL WIRING
IN CONDUIT				BULB CONTROL WIRING
CEILING	06	FAN40"		CEILING FAN 40"
CEILING	02	FAN30"		CEILING FAN 30"
+00"	04	TL		3X4W WALL TUBELIGHT
+00"	04	BULB		WALL BRACKETS AS DESIGN LIGHT
+00"	01	GL		WALL BRACKETS AS DESIGN FOR GANESH LIGHT
02	02	GL		WALL BRACKETS AS DESIGN FOR GATE LIGHT
CEILING	21	CTL		CTL CEILING LIGHT
+21"	02	FL		FLUORESCENT LIGHT
+48"	14	SB		SWITCH BOARD
+70"	03	ML		1 X 1 L W CH. MIRROR LIGHT
VENTILATOR HT	03	CR		CEILING ROSE
VENTILATOR HT	03	ESP		9" DIA. FRESH AIR FAN
+24"	02	TTL		TELEPHONE POINT
+27"	03	TV		TV COWALL POINT
+24"	02	LP TEL		6 A PLUG POINT FOR TELEPHONE
+27"	03	LP TV		6 A PLUG POINT FOR TV
+24"	02	LP		6 A PLUG POINT
+22"	01	LP-CH		6 A PLUG POINT FOR CHIMNEY
+180"	03	SAC		SPST AC
+180"	03	PP-SAC		25 A POWER POINT FOR SPST AC
+42"	01	PP-MMS		15 A POWER POINT FOR MMS
+78"	02	PP-G		15 A POWER POINT FOR GEYSER
+54"	01	PP-F		15 A POWER POINT FOR Fridge
+78"	01	PP-WP		15 A POWER POINT FOR WASHING MACHINE
+48"	01	PP-WM		15 A POWER POINT FOR WASHING MACHINE
+42"	02	BP		BELL PUSH SWITCH
+90"	01	BZ		BUGGER POINT
+24"	03	AC		AC STARTER
+00"	01	MED DB		MED DISTRIBUTION BOARD
05		SB1,1,1		SWITCH BOARD 1/1/1 LIGHT CIRCUIT NO.
03		AC		AC CIRCUIT NO.
05		PT		POWER CIRCUIT NO.

WARNING
1. This drawing is the sole copyright of Architects **VISTAAR** and should be used for the purpose expressly issued.

GENERAL NOTES
1. All dimensions are in feet and inches.
2. Do not scale this drawing follow written dimensions only.
3. This drawing should be read in conjunction with other architectural and structural drawings.
4. Any discrepancy in the drawing should be immediately brought to the notice of architect.

PROJECT TITLE
PROJECT:-
SUNRISE HEIGHTS
BUILDING AT PLOT NO.-E-15,E-16 & E-17(RECONSTITUTION),JAGDAMBA NAGAR-E,JAIPUR


DRAWING TITLE
STILT FLOOR DISTRIBUTION AND LT PANEL COMMON AREA TRANSFORMER PLAN


ARCHITECTS :-
VISTAAR ARCHITECTS & PLANNERS
Architects :: Interior Designers
B-2/12, Chitkoot scheme,
main Gandhi Path,Opp mall of jaipur,Jaipur
PH.- 0141-4370233,09001010366

DATE	REV	NORTH
26-08-2023		
SCALE	JOB NO.	
N.T.S		

For My Dream House
Partner

FRAME CORRELATES
BY LOKESH WADHWA
8, Nehru Chowk, 1st Floor (Shivdham)
Jaipur-302002

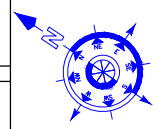

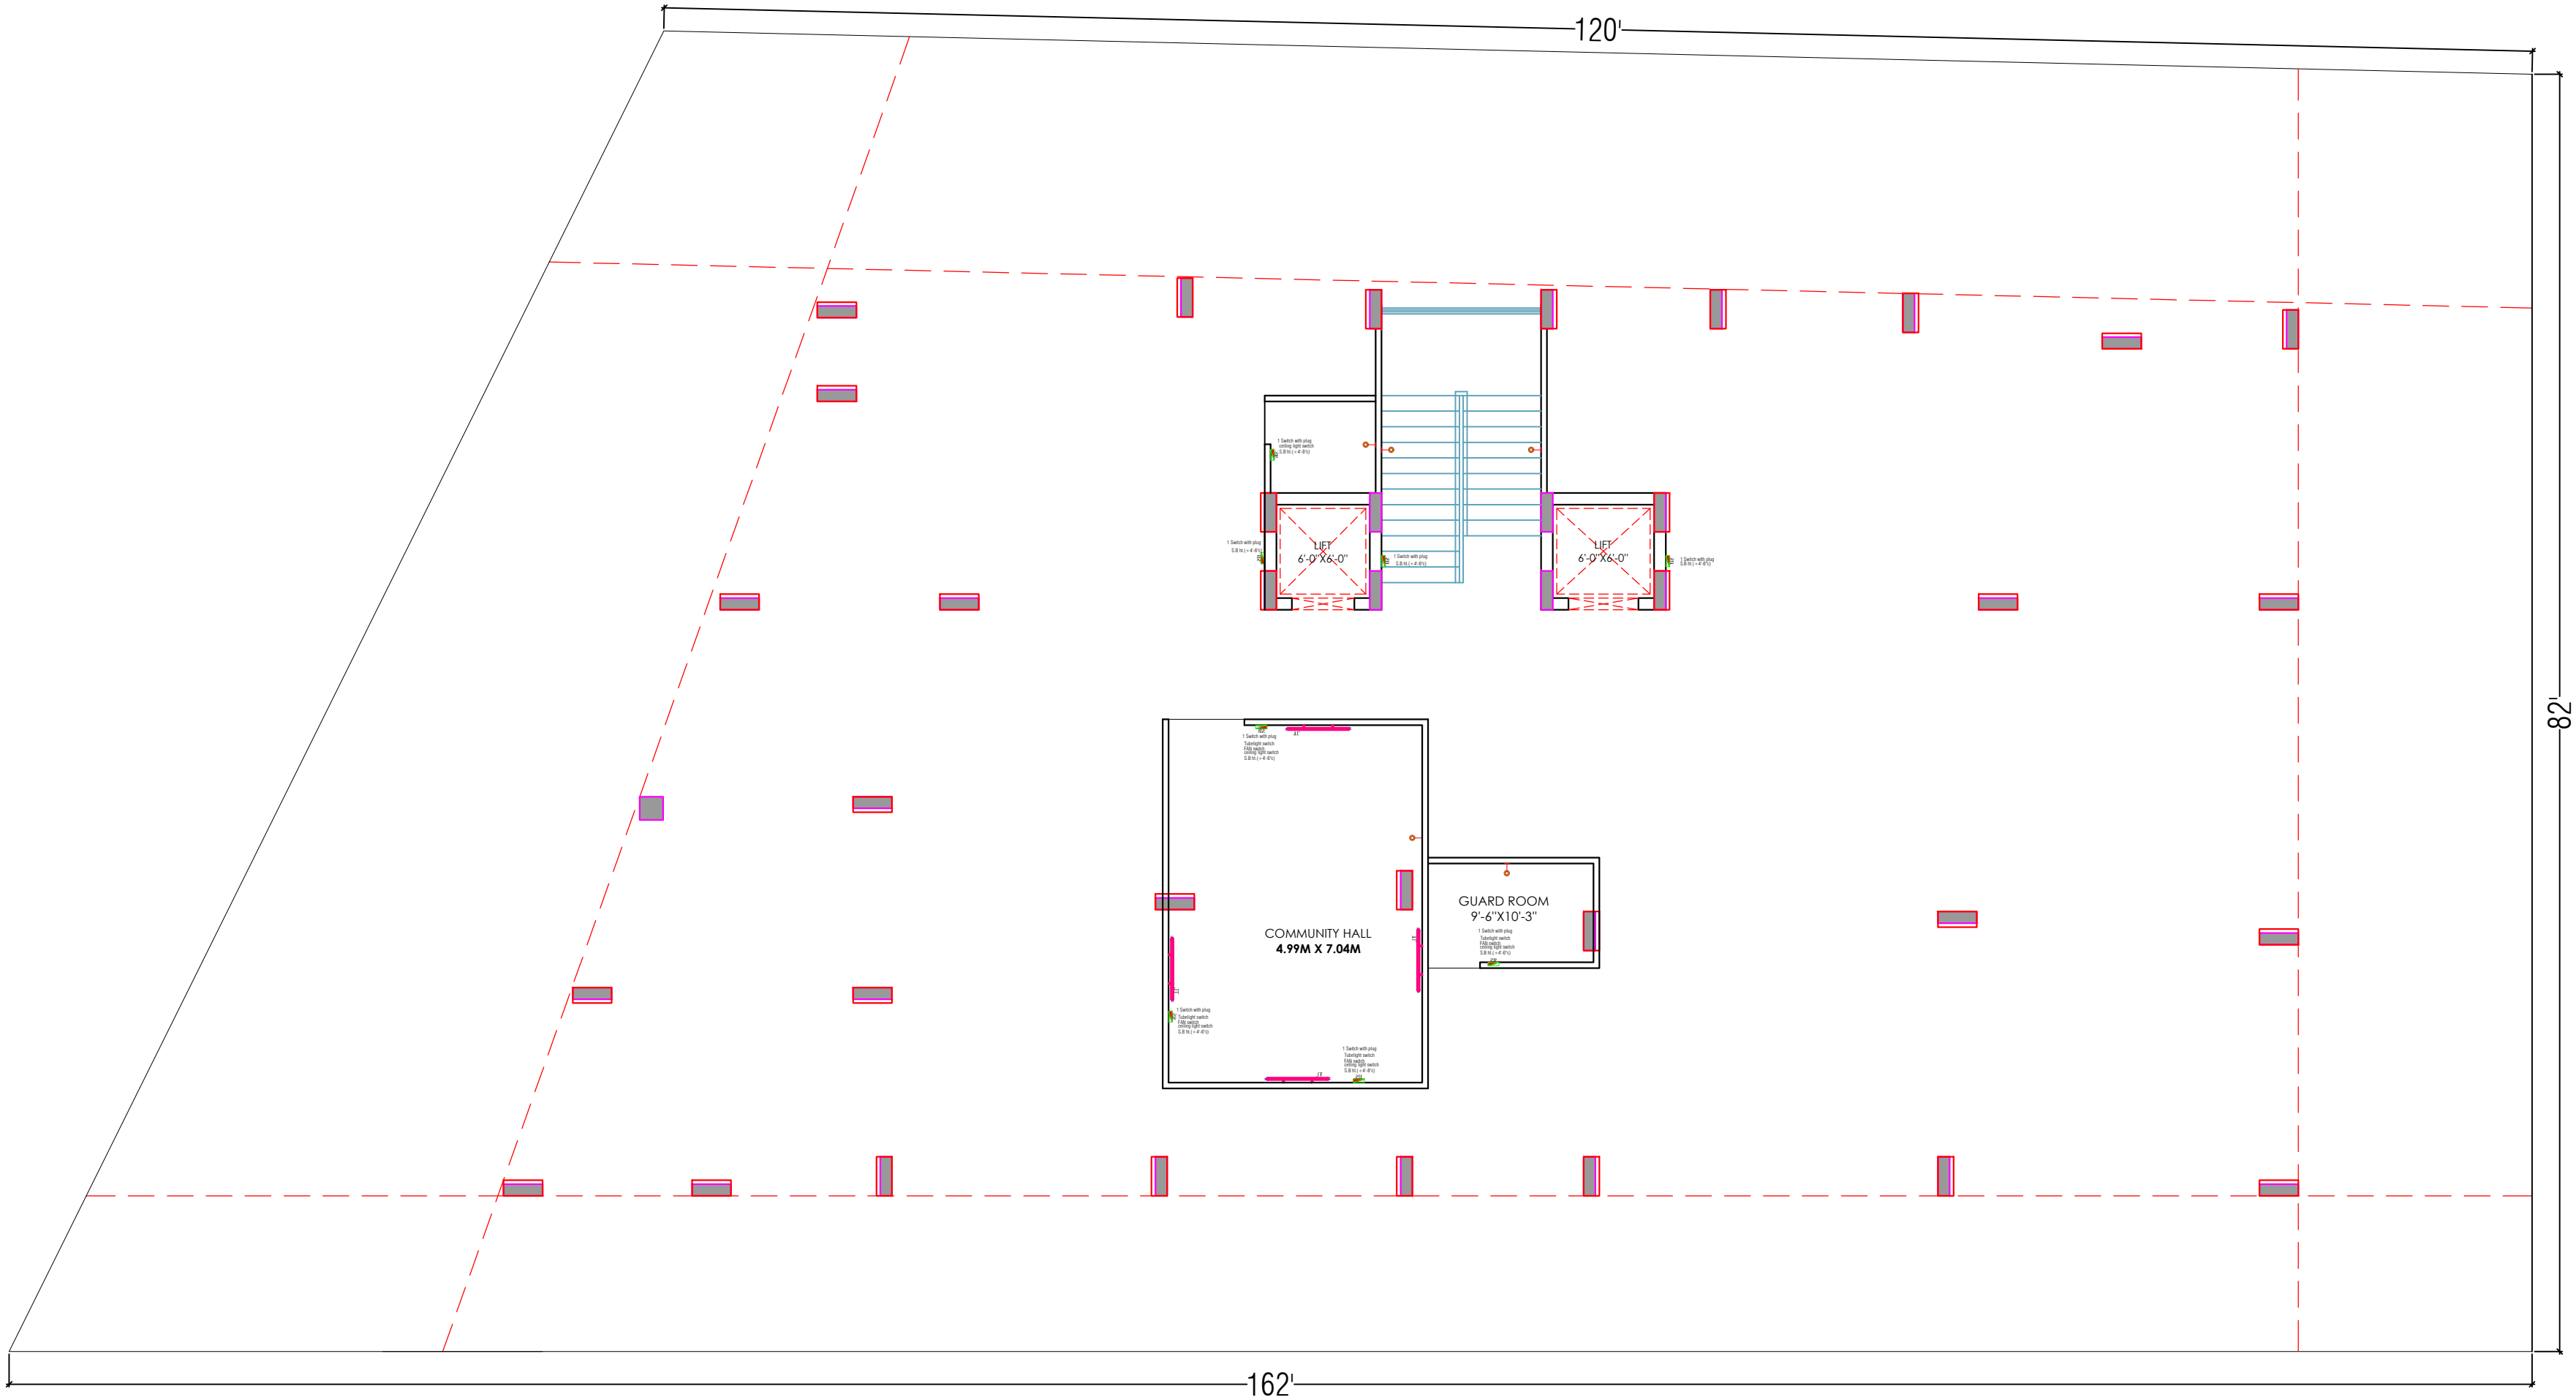

LEGENDS:				
Mounting Height	No.	I.D.	Symbol	Description
IN FLOOR				CONTROL WIRING
IN CONDUIT				CONTROL WIRING
IN CONDUIT				AC CONTROL WIRING
IN CONDUIT				GYSEK CONTROL WIRING
IN CONDUIT				BUZZER CONTROL WIRING
CEILING	06	FAN48"		CEILING FAN 48"
CEILING	02	FAN30"		CEILING FAN 30"
+90"	04	TL		3X4W WALL TUBELIGHT
+90"	04	BULB		WALL BRACKETS AS DESIGN LIGHT
+90"	01	GL		WALL BRACKETS AS DESIGN FOR GANESH LIGHT
02	GL			WALL BRACKETS AS DESIGN FOR GATE LIGHT
CEILING	21	CTL		CFL CEILING LIGHT
+21"	02	FL		FOOT LIGHT
+48"	14	SB		SWITCH BOARD
+70"	03	ML		1 X 11 W CFL MIRROR LIGHT
VENTILATOR HT.	03	CR		CEILING ROSE
VENTILATOR HT.	03	EXF		9" DIA FRESH AIR FAN
+24"	02	TEL		TELEPHONE POINT
+27"	03	TV		TV COAXIAL POINT
+24"	02	LP TEL		6 A PLUG POINT FOR TELEPHONE
+27"	03	LP TV		6 A PLUG POINT FOR TV
+24"	02	LP		6 A PLUG POINT
+72"	01	LP-CH		6 A PLUG POINT FOR CHIMNEY
+102"	03	SAC		SPLIT AC
+102"	03	PP-SAC		25 A POWER POINT FOR SPLIT AC
+42"	01	PP-MIX		15 A POWER POINT FOR MIXER
+78"	02	PP-G		15 A POWER POINT FOR GYSEK
+54"	01	PP-F		15 A POWER POINT FOR FRIDGE
+78"	01	PP-WP		15 A POWER POINT FOR WATER PURIFIER
+48"	01	PP-WM		15 A POWER POINT FOR WASHING MACHINE
+42"	02	BP		BELL PUSH SWITCH
+90"	01	BZ		BUZZER POINT
+24"	03	AC		AC STARTER
+60"	01	MCB DB		MCB DISTRIBUTION BOARD
05			SB/L	SWITCH BOARD NO / LIGHT CIRCUIT NO.
03			AC	AC CIRCUIT NO.
05			PT	POWER CIRCUIT NO.

WARNING
1. This drawing is the sole copyright of Architects **VISTAAR** and should be used for the purpose expressly issued.

GENERAL NOTES
1. All dimensions are in feet and inches.
2. Do not scale this drawing follow written dimensions only.
3. This drawing should be read in conjunction with other architectural and structural drawings.
4. Any discrepancy in the drawing should be immediately brought to the notice of architect.

PROJECT TITLE
PROJECT:-
SUNRISE HEIGHTS
BUILDING AT PLOT NO.-E-15,E-16 &
E-17(RECONSTITUTION),JAGDAMBA
NAGAR-E,JAIPUR

DRAWING TITLE
STILT FLOOR WALL ELECTRICAL
PLAN
ARCHITECTS :
VISTAAR ARCHITECTS & PLANNERS
Architects :: Interior Designers
B-2/12, Chitrkoot scheme,
main Gandhi Path,Opp mall of jaipur,Jaipur
PH.- 0141-4370233,09001010366

PATH >		DATE		REV.		NORTH	
DRN.		DATE		REV.			
MANOJ KUMAWAT		26-08-2023					
SCALE		JOB NO.					
N.T.S							

For My Dream House
Partner