


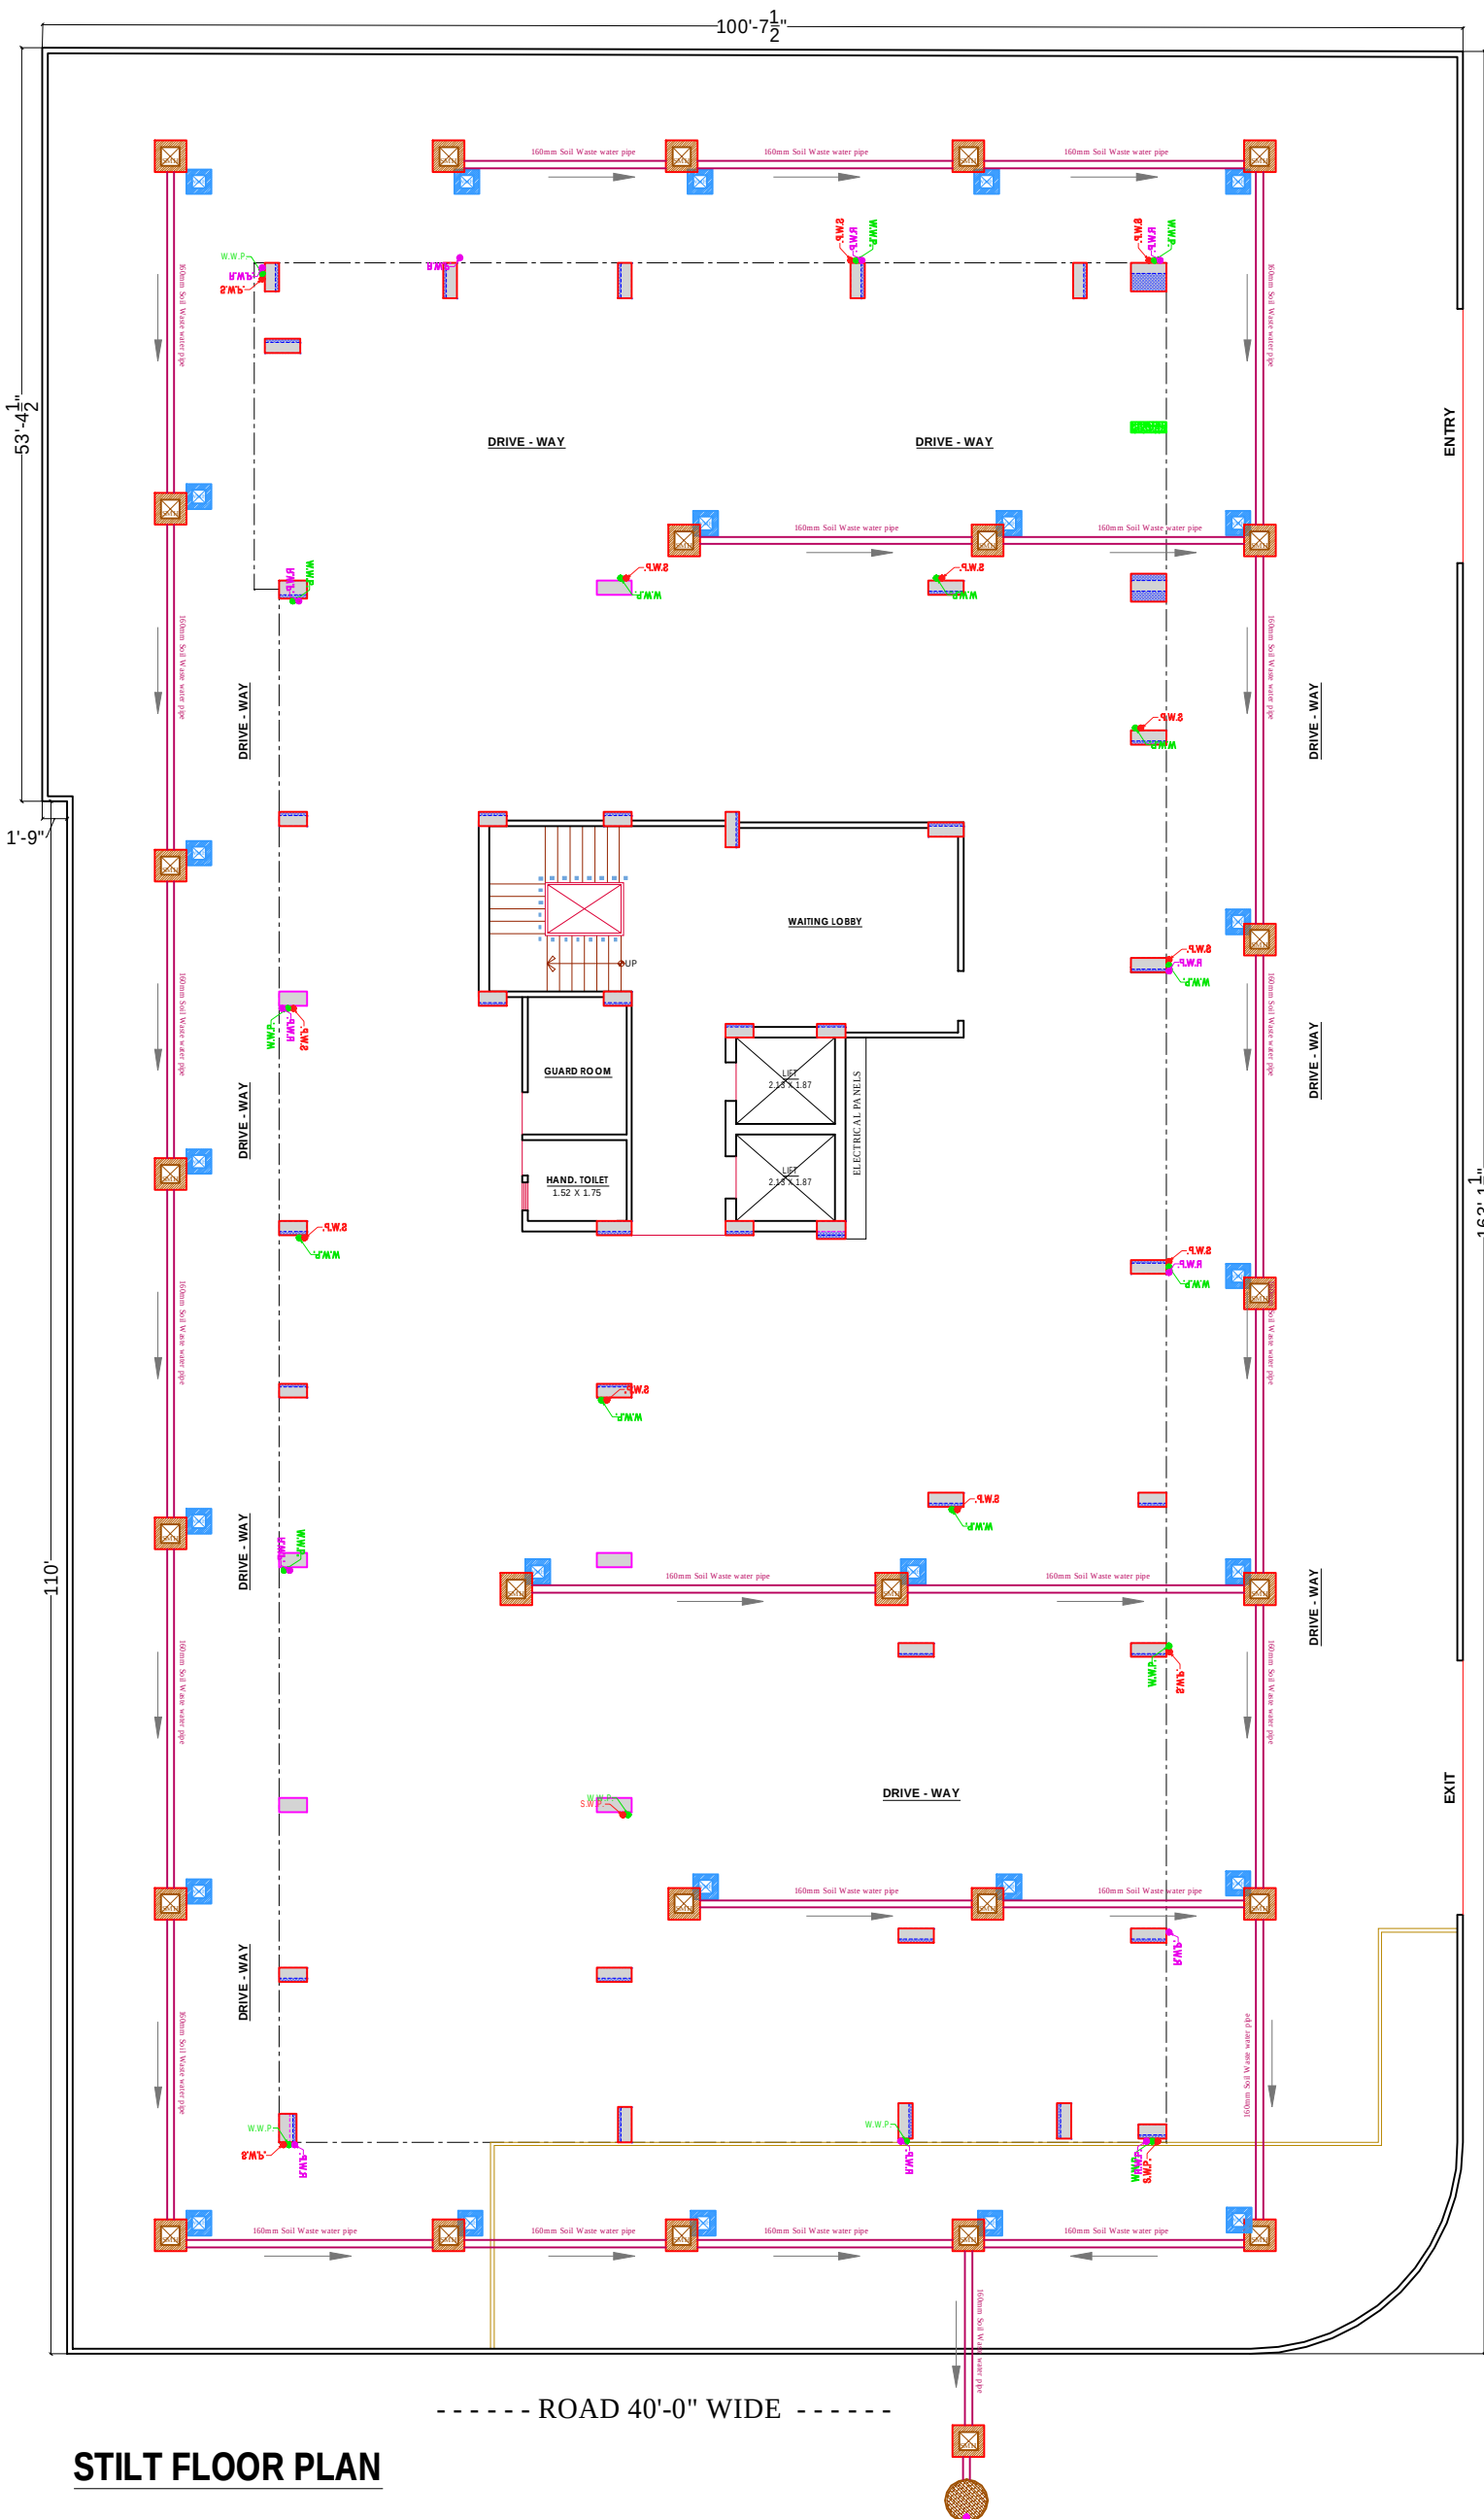

STILT FLOOR PLAN

LEGENDS:-	
	WASTE WATER MANHOLE 450X450MM DEPTH- 300MM
	SEWERAGE MANHOLE 900 mm Dia
	MANHOLE 900X800MM
	SEWERAGE MANHOLE 600X600MM
SYMBOL	DESCRIPTION
	110 mm Soil Waste Water Pipe
	110 mm Waste Water Pipe
	110 mm Rain Water Pipe
	FOLLOW DIRECTION

PROJECT:

THE SHYAM HAVELI
PROPOSED RESIDENTIAL BUILDING AT PLOT
MO. 29, 30, 31, 32, 33 NORTH PART, SCHEME -
NAVJEEVAN GRIHA NIRMAN SHAKARI
SAMEETI, NIRMAN NAGAR A, B, JAIPUR (RAJ)

DRAWING:

**STILT FLOOR
EXTERNAL SEWER CHAMBER
& PIPES ROUTE PLAN**

ARCHITECT:

ARCHITECTS, INTERIOR DESIGNERS AND ENGINEERS

SERVICES CONSULTANT:

Naman Yadav
B.Tech (Service Consultant)

344,Mansarovar plaza,Jaipur

WORKING LAYOUT PLAN

PROPOSAL PLAN

SH.NO.
01

SCALE: NTS

NOTE

THIS DRAWING IS THE SOLE PROPERTY
OF SPACE EDGE ARCHITECTS AND IS NOT
TO BE COPIED, USED OR REPRODUCED
FOR ANY PURPOSE OTHER THAN FOR
WHICH IT HAS BEEN LOANED.

