
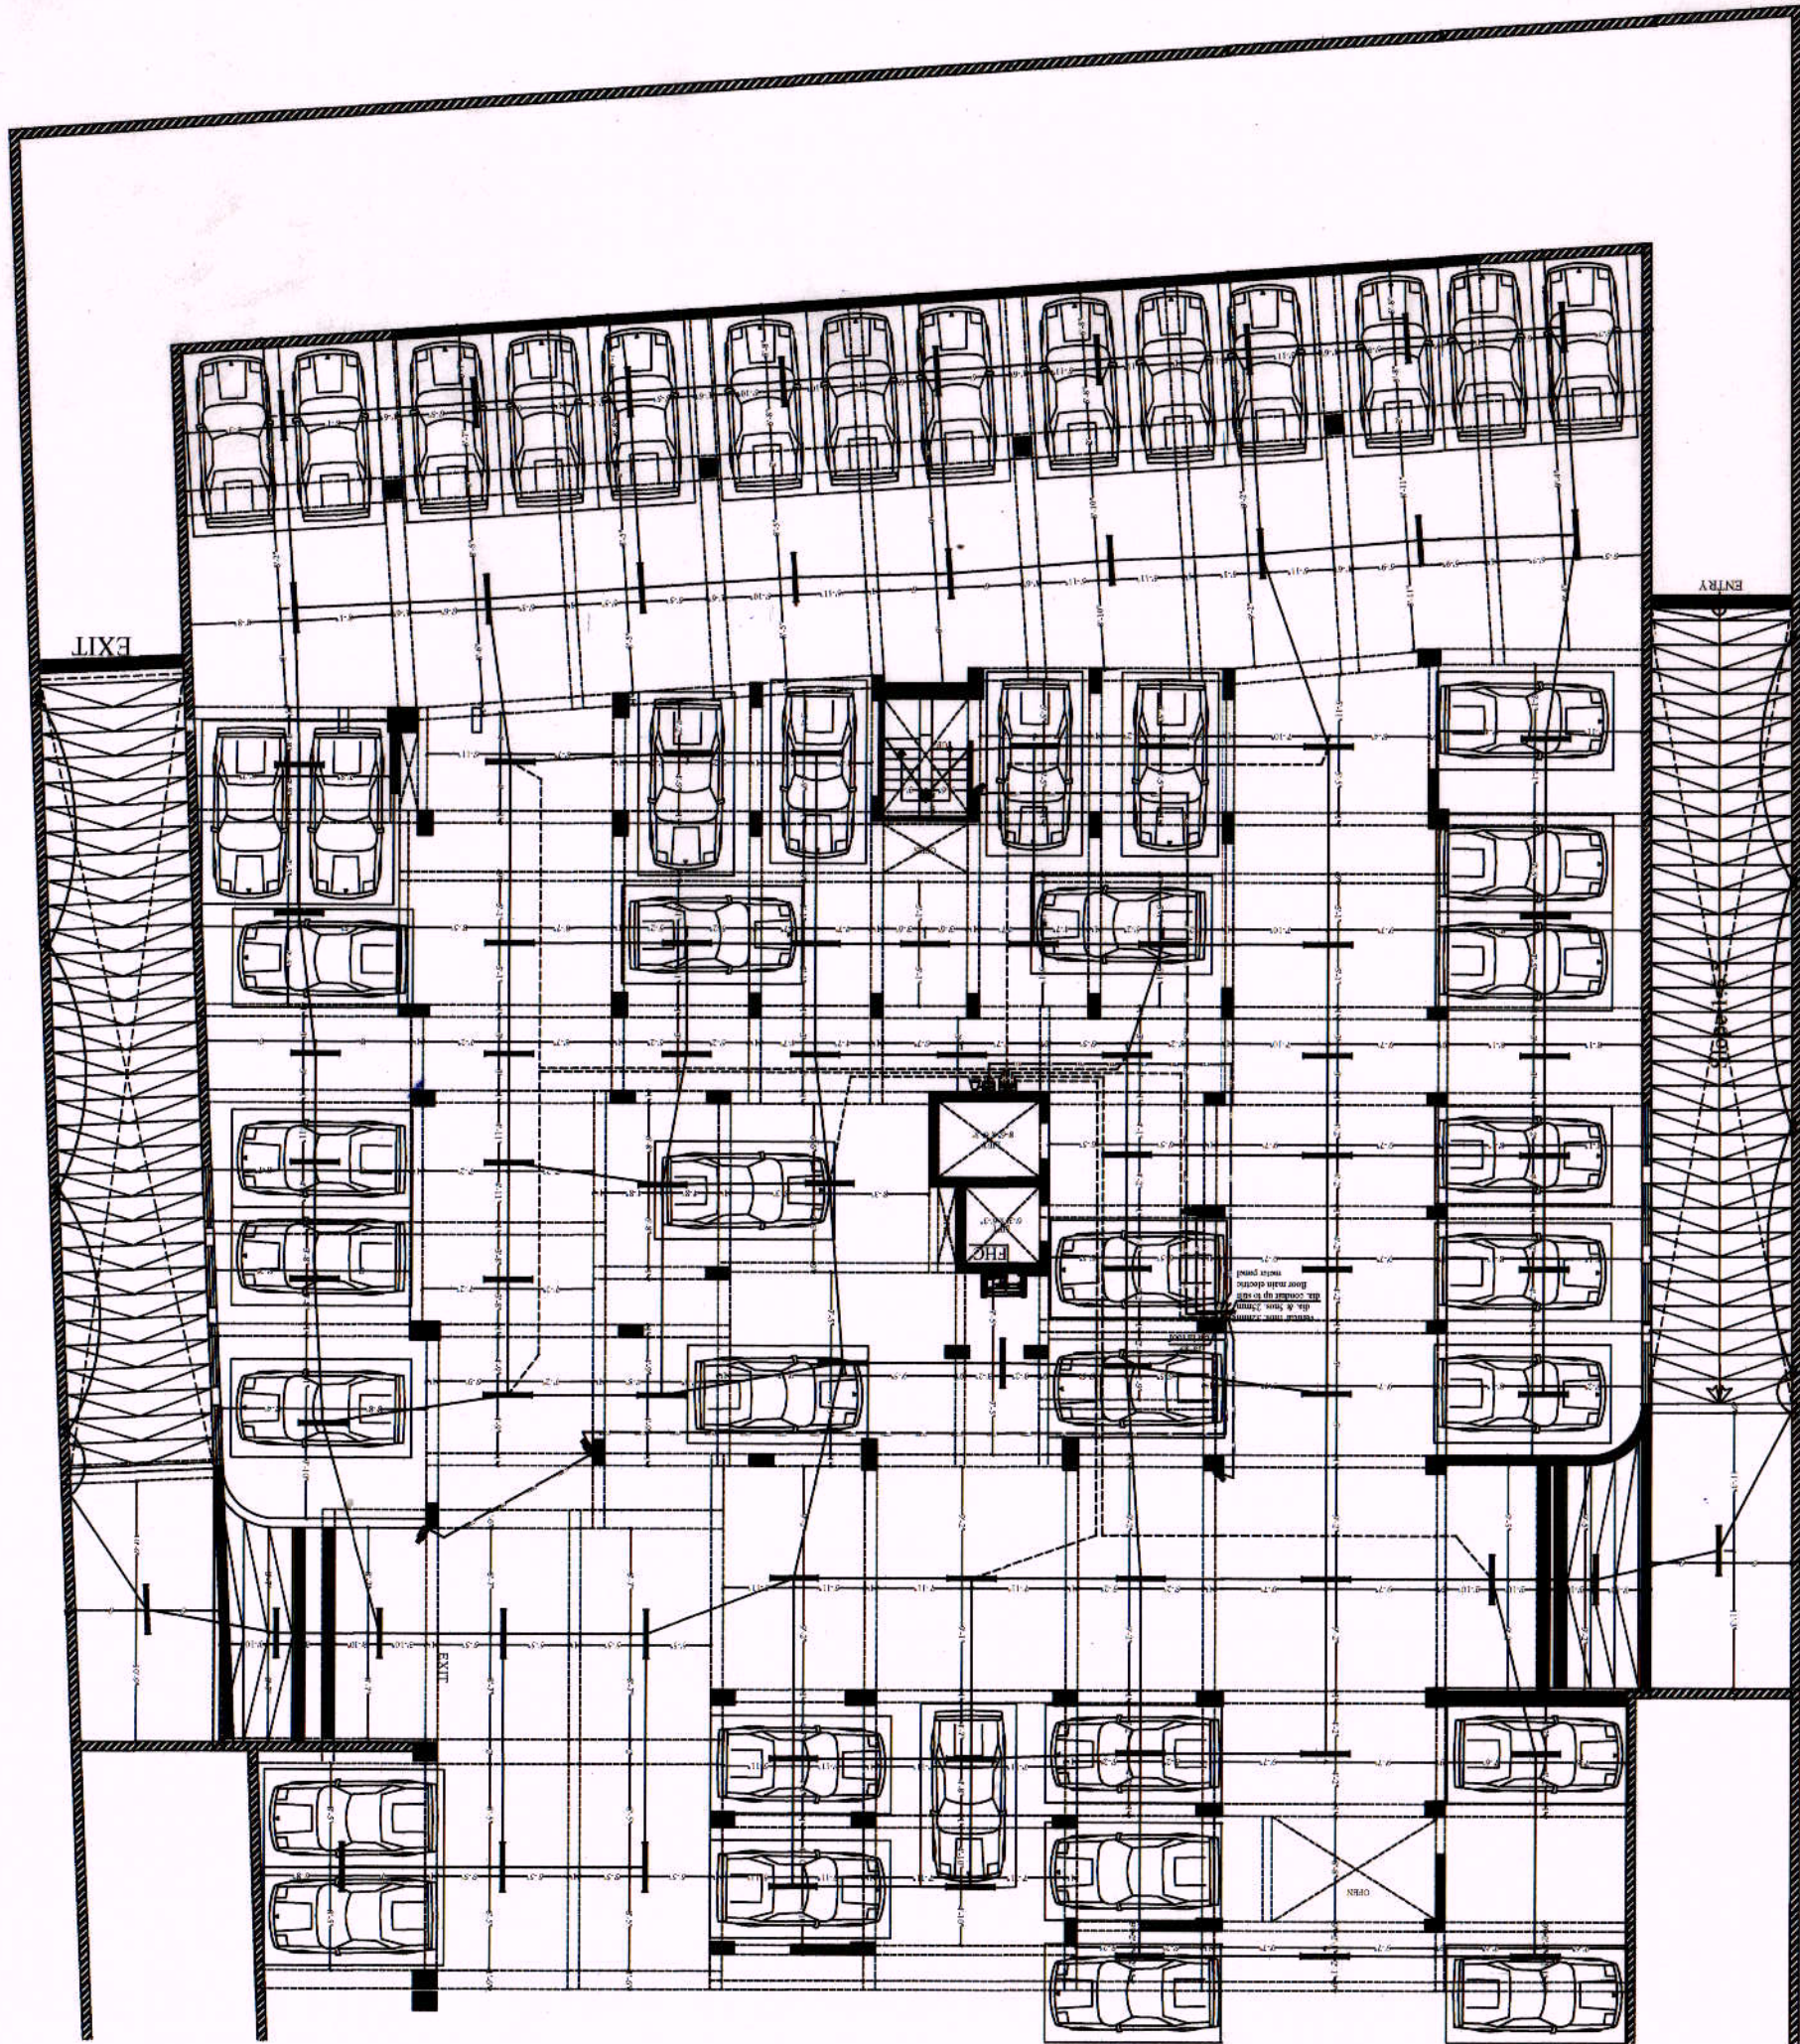
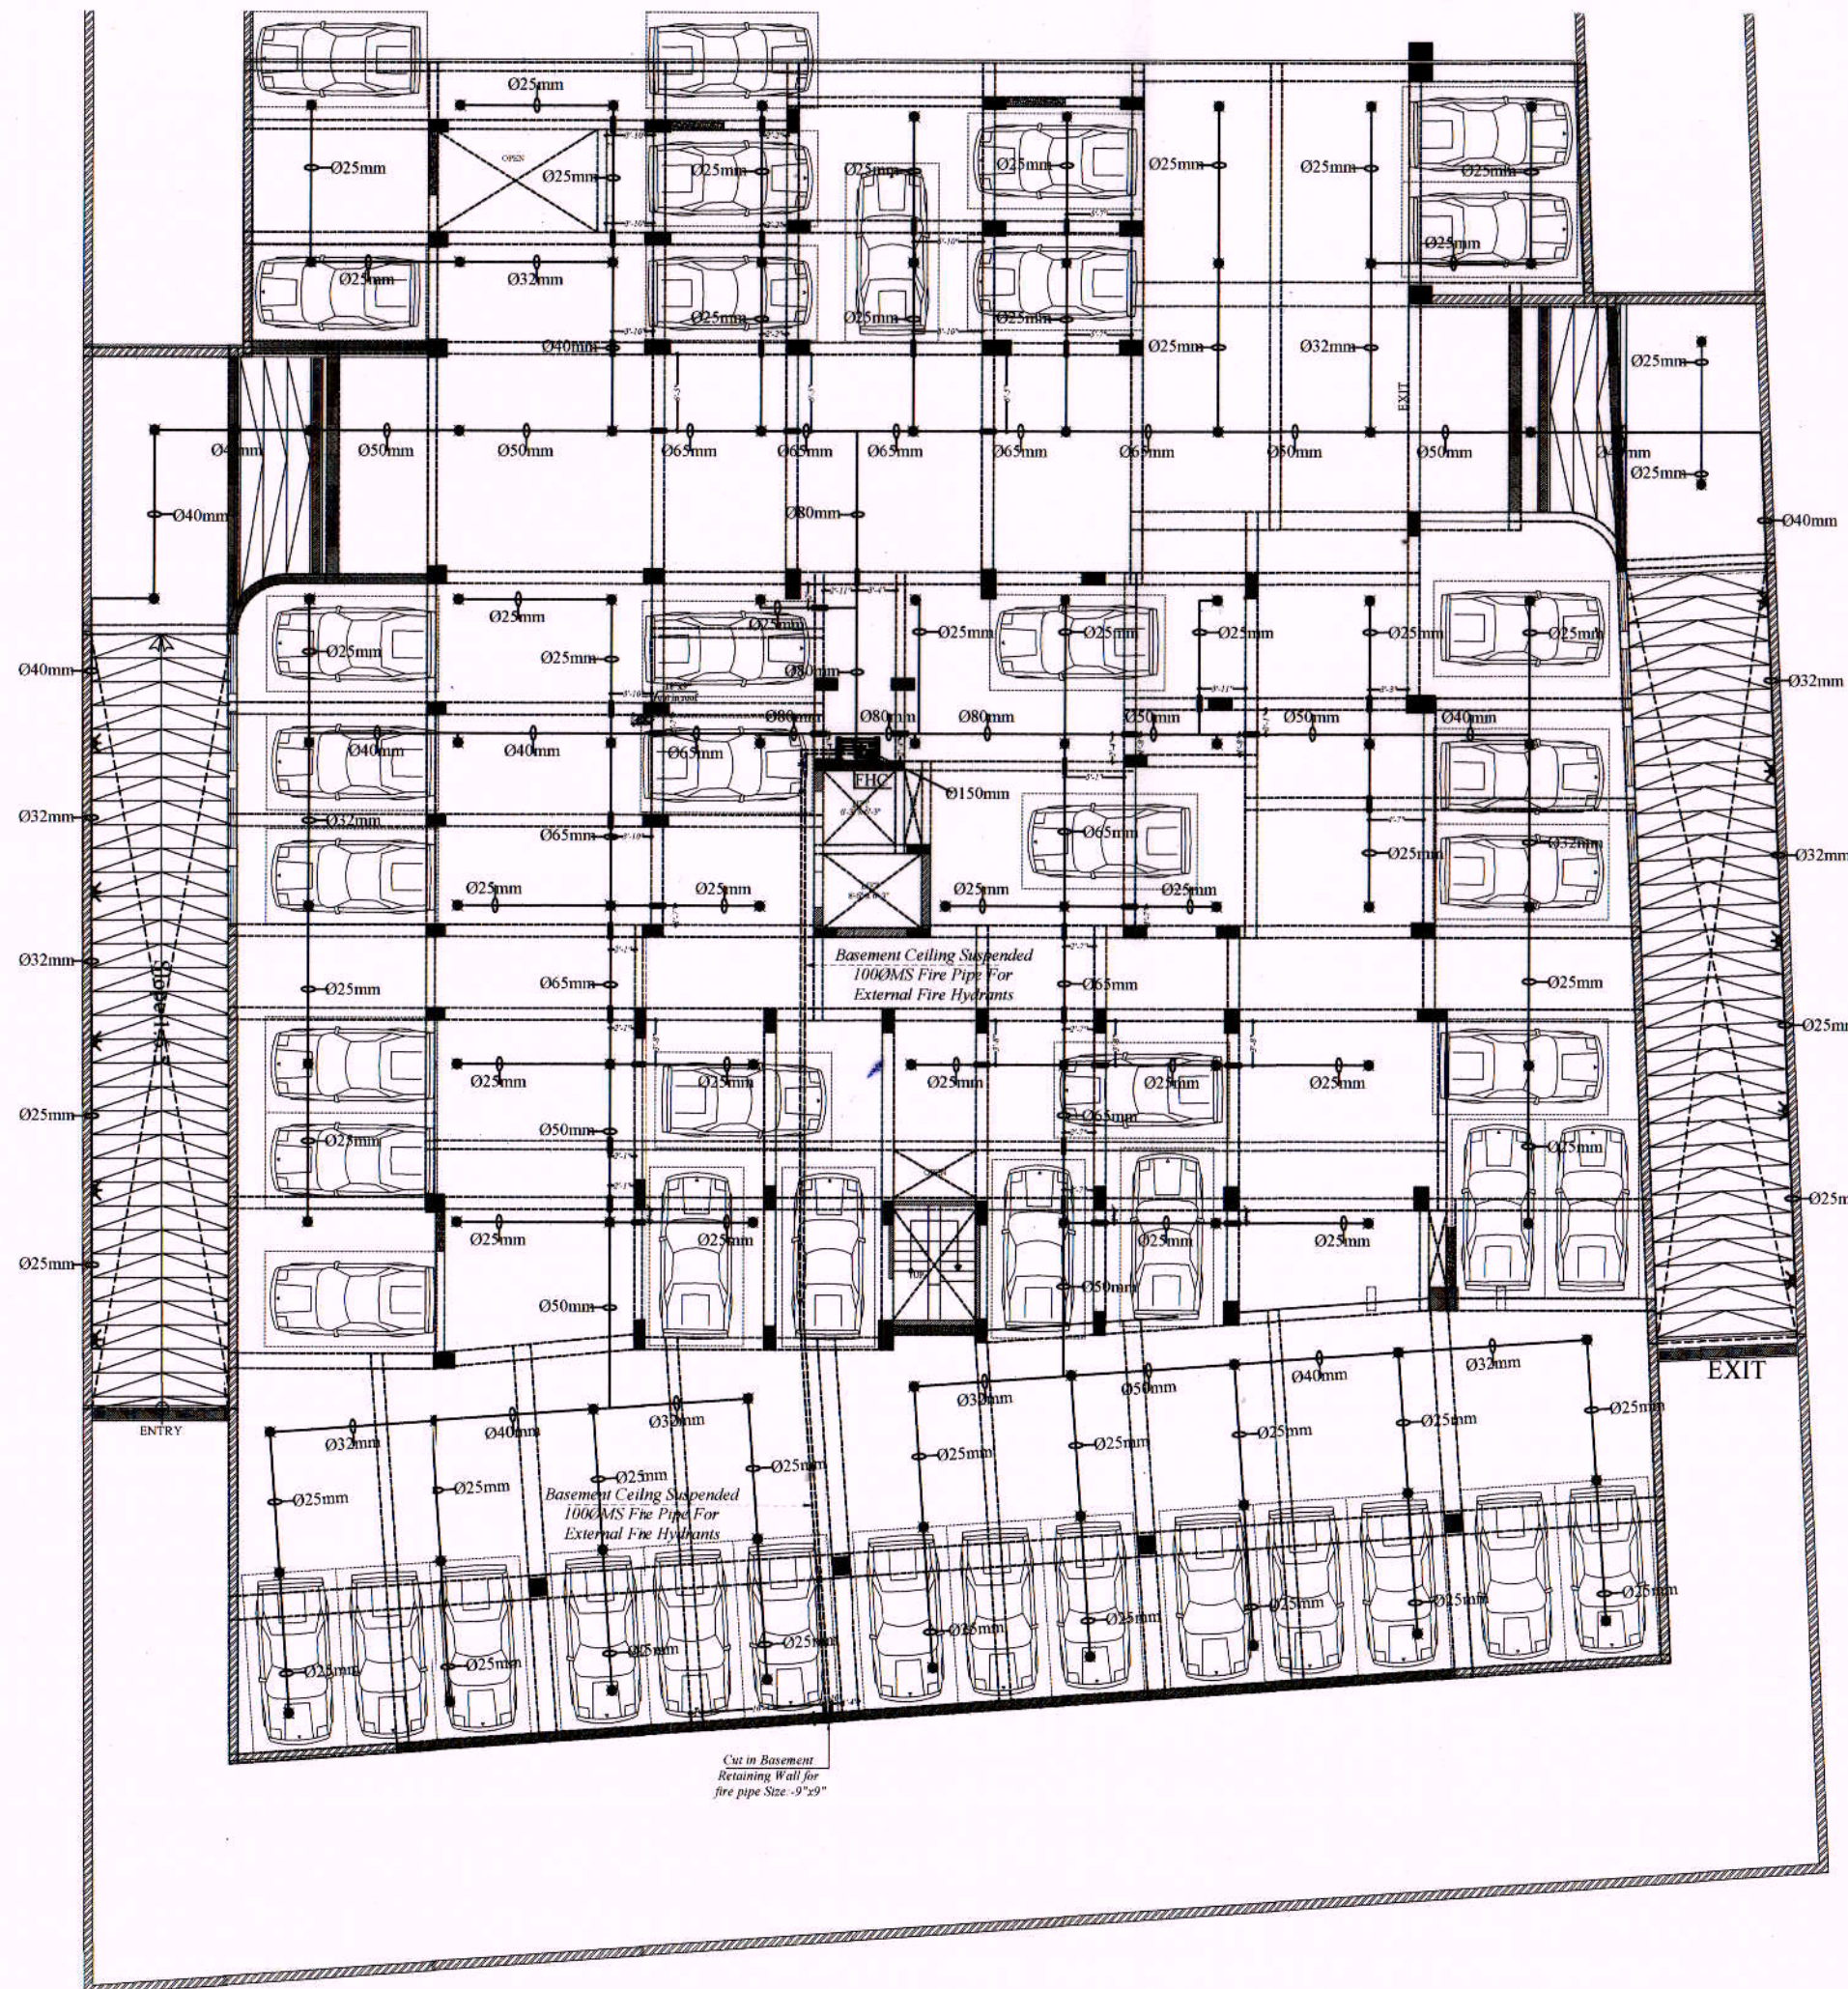
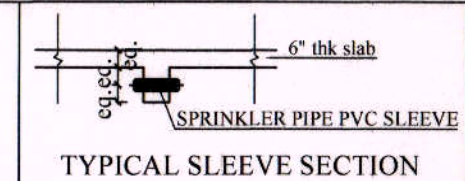


[illegible]

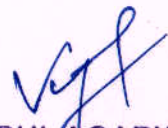


VIPUL AGARWAL
M.E.P. CONSULTANT
B.E. ELECTRICAL

LEGENDS:

Mounting Ht.	Qty.	Symbol	Description
CEILING	102		SPRINKLER POINT
WALL	10		SPRINKLER POINT
CEILING	270mtr		25 MM DIA. MS PIPE
CEILING	50mtr		32 MM DIA. MS PIPE
CEILING	50mtr		40 MM DIA. MS PIPE
CEILING	42mtr		50 MM DIA. MS PIPE
CEILING	40mtr		65 MM DIA. MS PIPE
CEILING	16mtr		80 MM DIA. MS PIPE
CEILING	01mtr		100 MM DIA. MS PIPE
CEILING			100 MM DIA. SLEEVE
CEILING			150 MM DIA. SLEEVE
	01		CONTROL VALVE

SERVICES CONSULTANT:
 VIPUL CONSULTING,
 F 9 / 440 , Keshav Marg Chitrakut Scheme,Jaipur
 PH-91-0-93146-10438 ,0141-2440946 Mail:vipul8599@yahoo.com
 REV. NO. 000, DATE:-01-12-2015

PROJECT NAME
VARDHMAN SAMPADA


PROMOTER:
RICHWELL ENTERPRISES PRIVATE LIMITED

ARCHITECT:-
SPACE GRID
 C-49,VIDYA APARTMEN,PARAS MARG,
 BAPU NAGAR,JAIPUR - 302015.
 PHONE: 9314918766,9314510603

PROJECT:-
 PROPOSED FLAT'S AT KHASRA
 NO. :-1973,1987/1 IN REVENUE-
 VILLAGE- SIRSI,TEH.-JAIPUR,


NAME OF DRAWING:
**BLOCK-B
 BASEMENT FLOOR
 SPRINKLER PLAN**

APPD BY:- VIPUL AGARWAL	DATE:- 01-12-2015
DEALT BY:- SANJAY	REF.
DRAWN BY:- PAWAN	

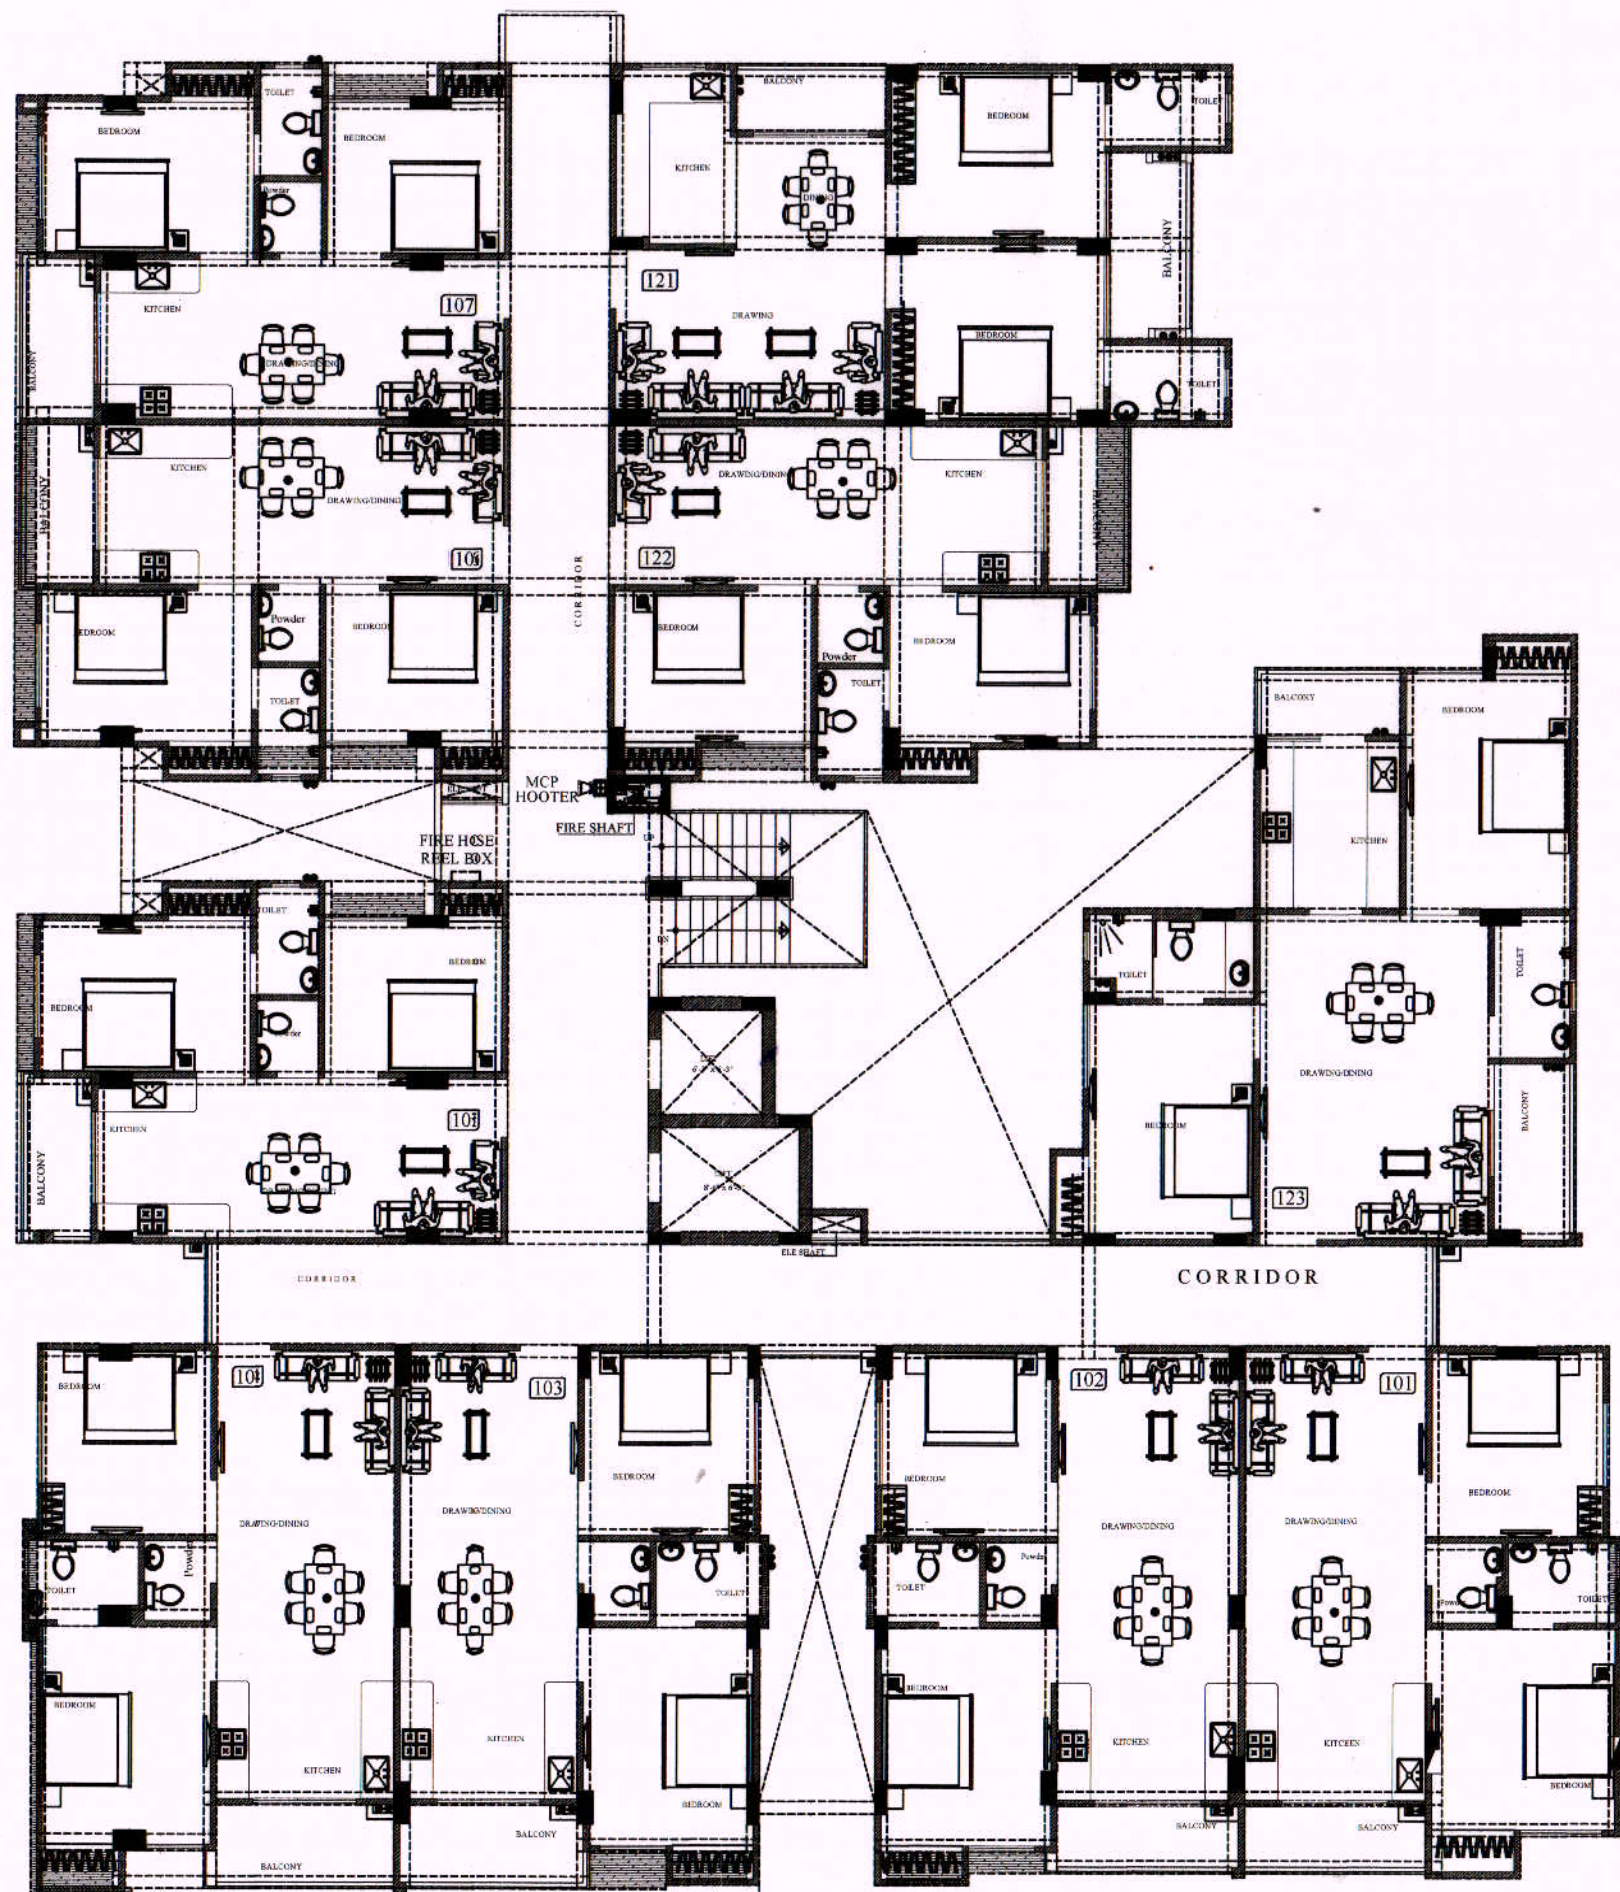


VIPUL AGARWAL
M.E.P. CONSULTANT
B.E. ELECTRICAL

5mm OUTLET NOZZLE

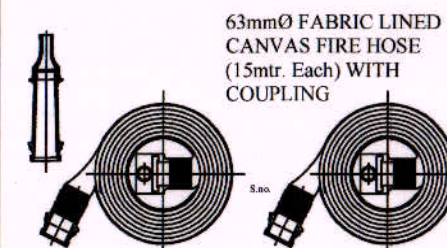

LEGENDS:

Mounting Height	No.	ID	Symbol	Description
IN CEILING				2X1.5 sq. mm Copper Wire For Fire Alarm
+42"	01	MCP		MANUAL CALL POINT
+90"	01	IHO		HOOTER POINT

PROJECT NAME

VARDHMAN SAMPADA

PROMOTER:

RICHWELL ENTERPRISES PRIVATE LIMITED

SERVICES CONSULTANT:

VIPUL CONSULTING,
 F 9 / 440 , Keshav Marg Chitrakut Scheme, Jaipur
 PH: 91-0-93146-10438 , 0141-2440946 Mail: vipul8599@yahoo.com
 REV. NO. 00, DATE: 04-03-2017

ARCHITECT:-

SPACE GRID

C-49, VIDYA APARTMENT, PARAS MARG,
BAPU NAGAR, JAIPUR - 302015.
PHONE: 9314918766, 9314510603

PROJECT:-

PROPOSED FLAT'S AT KHASRA
NO. :- 1973, 1987/1 IN REVENUE-
VILLAGE- SIRSI, TEH.-JAIPUR,

NAME OF DRAWING:

BLOCK-B
TYPICAL FLOOR PLAN

APPD BY:-

VIPUL AGARWAL

DATE:-

04-03-2017

DEALT BY:-


SANJAY

REF.

DRAWN BY:-

VIJESH



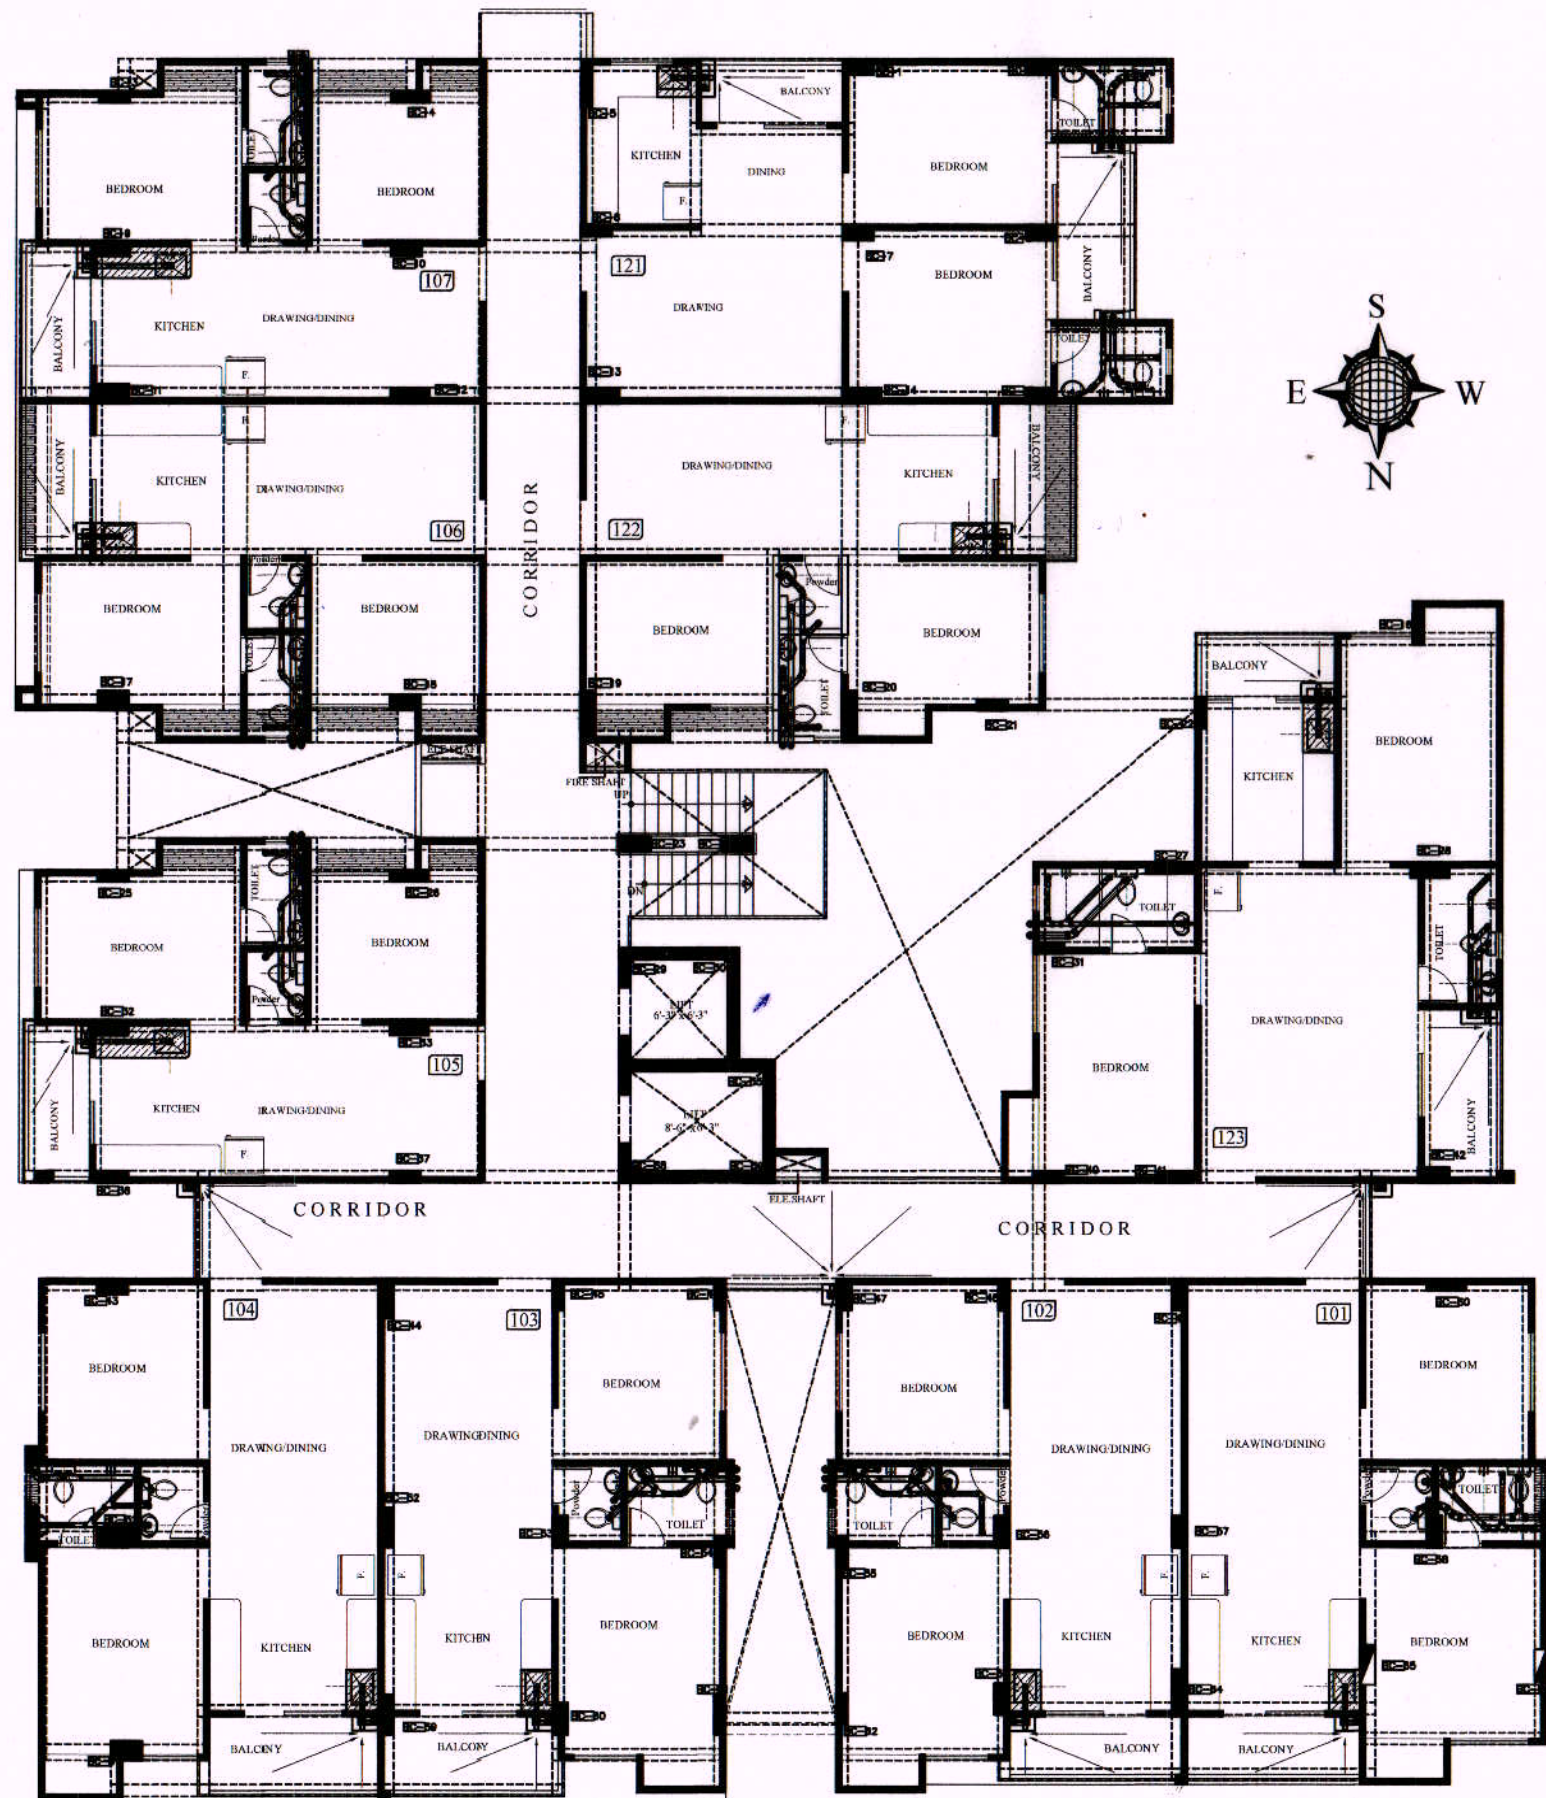

VIPUL AGARWAL
M.E.P. CONSULTANT
B.E. ELECTRICAL

SYMBOL	DESCRIPTION
	110 mm Soil Waste Water Pipe
	110 mm Waste Water Pipe
	110 mm Rain Water Pipe
	110 mm Soil Waste Water Pipe
	110 mm Waste Water Pipe
	110 mm Rain Water Pipe
	75 mm Waste Water Pipe Internal Toilet
	75 mm Rain Water Pipe
	50mm Waste Water Pipe Bottle Trap
	50mm Waste Water Pipe
	Nahani Trap
	Multi Trap
	Vertical MS Grating Cover
	Flow Direction
	6" Platform Raise

SERVICES CONSULTANT:
VIPUL CONSULTING,
F 9 / 440 , Keshav Marg Chitrakut Scheme, Jaipur
PH: 91-0-93146-10438 , 0141-2440946 Mail: vipul8599@yahoo.com
REV. NO. 000, DATE: 03-06-2016

ARCHITECT:-

SPACE GRID

C-49, VIDYA APARTMENT, PARAS MARG,
BAPU NAGAR, JAIPUR - 302015.
PHONE: 9314918766, 9314510603

PROJECT NAME

VARDHMAN SAMPADA

PROMOTER:-

**RICHWELL ENTERPRISES
PRIVATE LIMITED**

PROJECT:-

PROPOSED FLAT'S AT KHASRA
NO. : 1973, 1987/1 IN REVENUE-
VILLAGE- SIRSI, TEH.-JAIPUR,

NAME OF DRAWING:

**BLOCK-B
TYPICAL FLOOR INTERNAL
DRAINAGE PLAN**

APPD BY:-

VIPUL AGARWAL

DATE:-

03-06-2016


DEALT BY:-


SANJAY

REF.

DRAWN BY:-

RAAJ

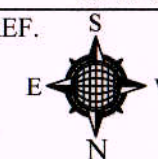

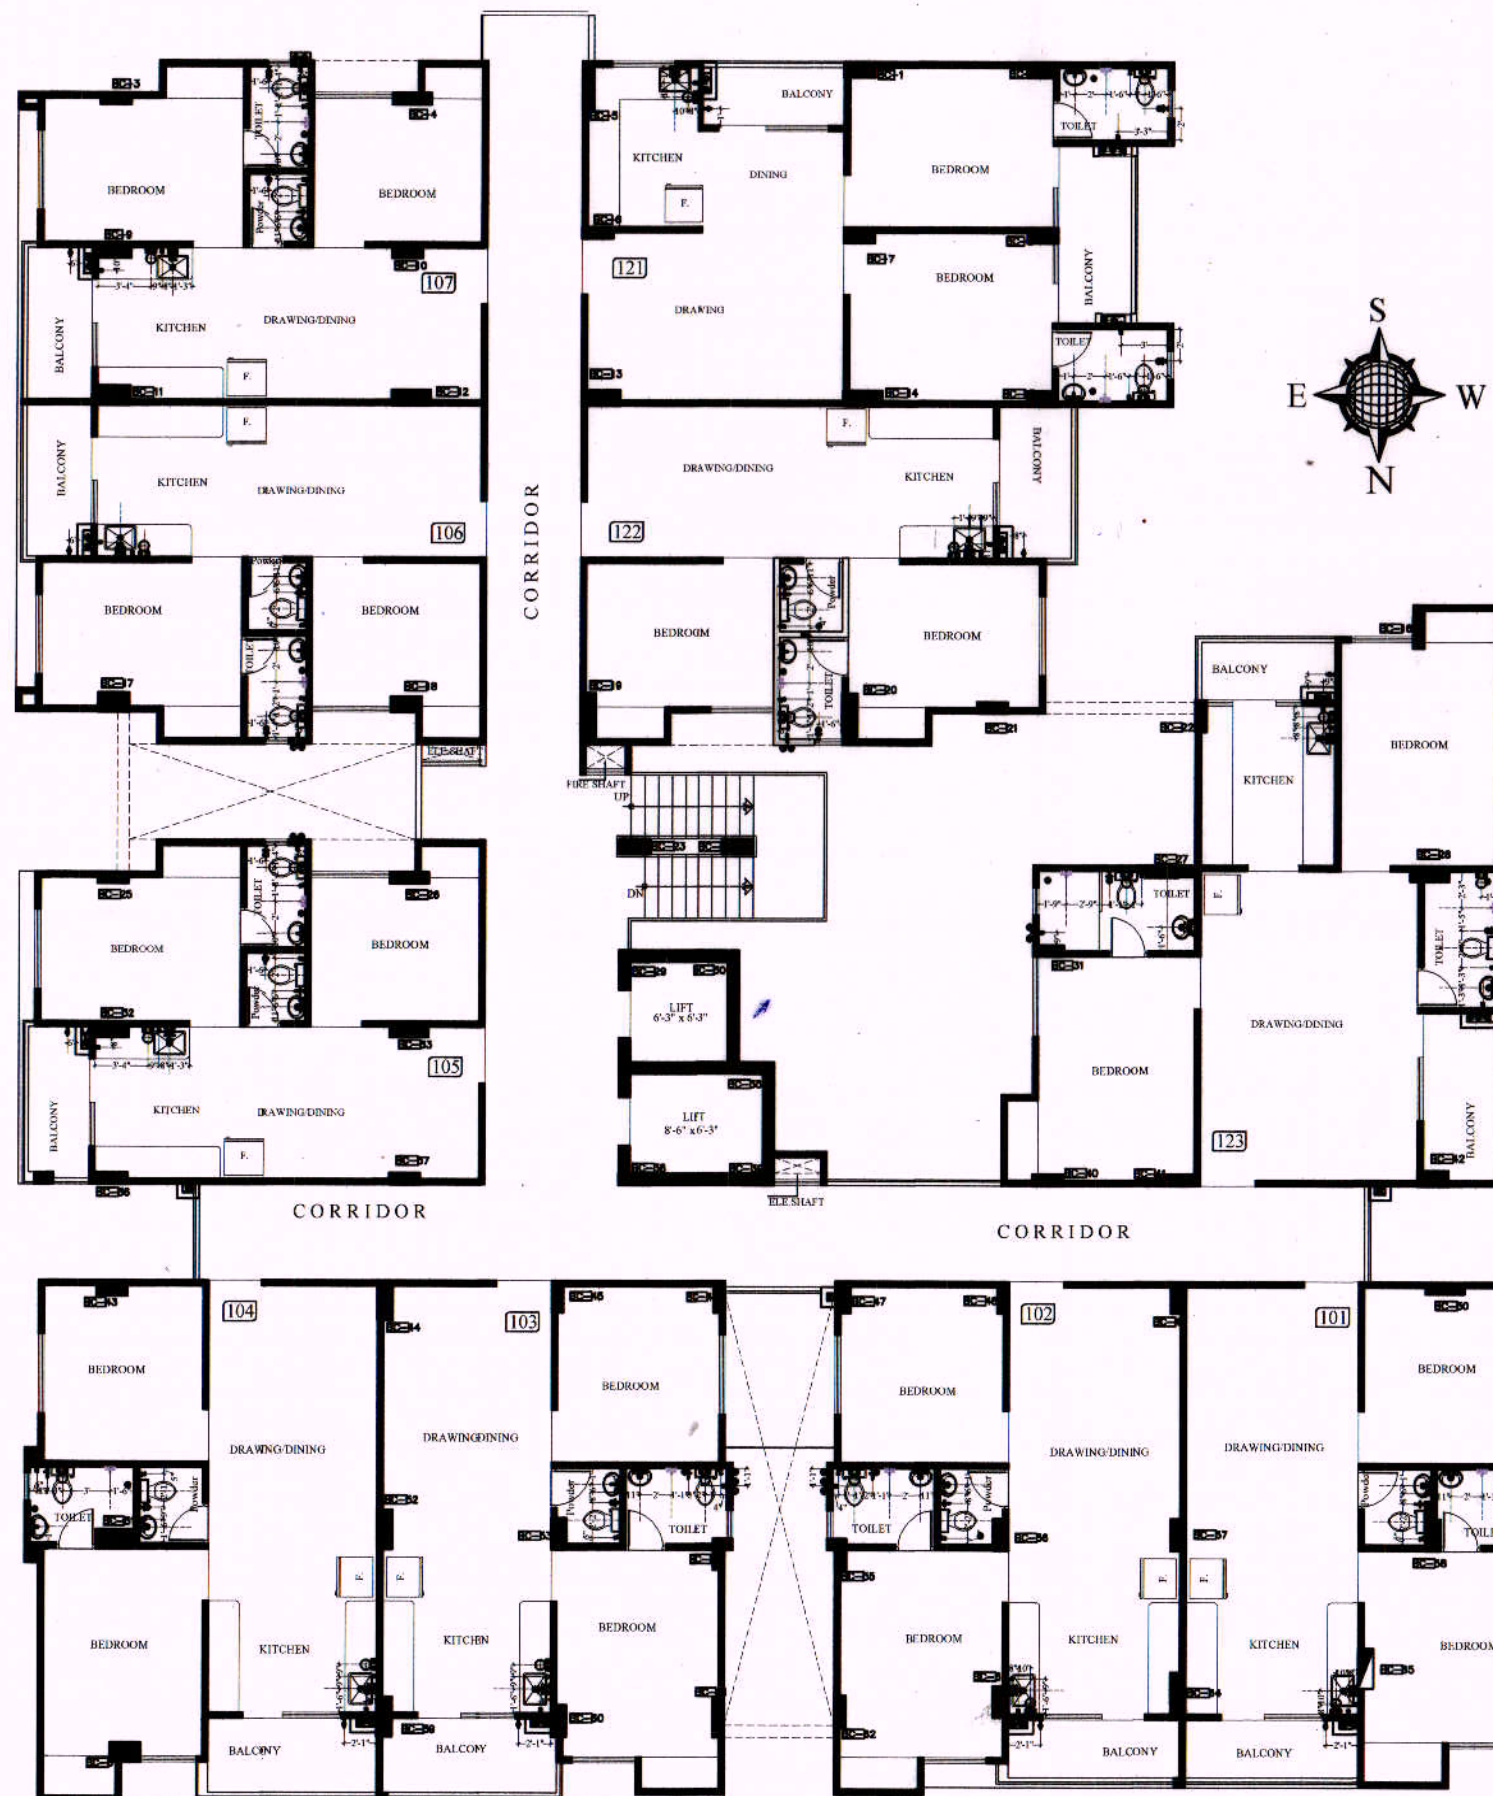

VIPUL AGARWAL
M.E.P. CONSULTANT
B.E. ELECTRICAL

STANDARDS SANITARY APPLIANCES HEIGHTS/AS PER AR DETAILS

TOILET/KITCHEN		All Heights For Finish Floor Lvl
1	WASH BASIN MIXER	+800MM
2	WASH BASIN ANGLE VALVE	+450MM
3	BOTTLE TRAP	+450MM
4	TOWEL RING	+950MM
5	MIRROR 450X450mm(BOTTOM)	+950MM
6	OVER HEAD SHOWER	+2025MM
7	WALL MIXER DIVERTOR	+1000MM
8	TAP FOR BATH AREA	+770MM
9	TAP FOR BALCONY/ WASHING	+450MM
10	SOAP DISH	+1000MM
11	TOWEL RAIL	+1500MM
12	WC WALL MOUNTED(BOTTOM)	+400MM
13	FLUSH VALVE	+900MM
14	TAP FOR WC	+300MM
15	PAPER HOLDER	+450MM
16	ANGLE VALVE FOR GYSER	+1950MM
17	KITCHEN SINK MIXER	+1000MM
18	ANGLE VALVE FOR GYSER	+1950MM
19	ANGLE VALVE FOR WATER PURIFIER	+1500MM
20	CONCEALED STOP COCK	+2100MM

LEGEND:

SYBLOL	DESCRIPTION
	Central Hole Basin Mixture Standard with 2 nos. Angle valve
	2 Way Bib Cock
	Angle Valve For Cistern
	Wall Mixer with Band with Over Head Shower with Arm
	2 Nos. Angle valve For Gysr
	Concealed Stop Cock
	Aqua Guard Valve
	Tap For Washing Machine
	Sink Mixture
	Basin Angle Valve
	Urinal Angle Valve
	Floor Trap
	Cold Water Supply
	Hot Water Line - Internal
	Cold Water Line - Internal

SERVICES CONSULTANT:
VIPUL CONSULTING,

F 9 / 440 , Keshav Marg Chitrakut Scheme,Jaipur
PH:91-0-93146-10438 ,0141-2440946 Mail:vipul8599@yahoo.com
REV. NO. 000, DATE:-09-06-2016

ARCHITECT:-

SPACE GRID

C-49,VIDYA APARTMEN,PARAS MARG,
BAPU NAGAR,JAIPUR - 302015.
PHONE: 9314918766,9314510603

PROJECT NAME

VARDHMAN SAMPADA

PROMOTER:-

RICHWELL ENTERPRISES
PRIVATE LIMITED

PROJECT:-

PROPOSED FLAT'S AT KHASRA
NO. :-1973,1987/1 IN REVENUE-
VILLAGE- SIRS,TEH.-JAIPUR,

NAME OF DRAWING:

BLOCK-B
TYPICAL FLOOR INTERNAL
PLUMBING PLAN

APPD BY:-

VIPUL AGARWAL

DATE:-

09-06-2016

DEALT BY:-

SANJAY

REF.

S

DRAWN BY:-

RAAJ

E W


N

138'-2 1/2"

324'-8 3/4"

298'-8 1/2"

150'-3 1/2"

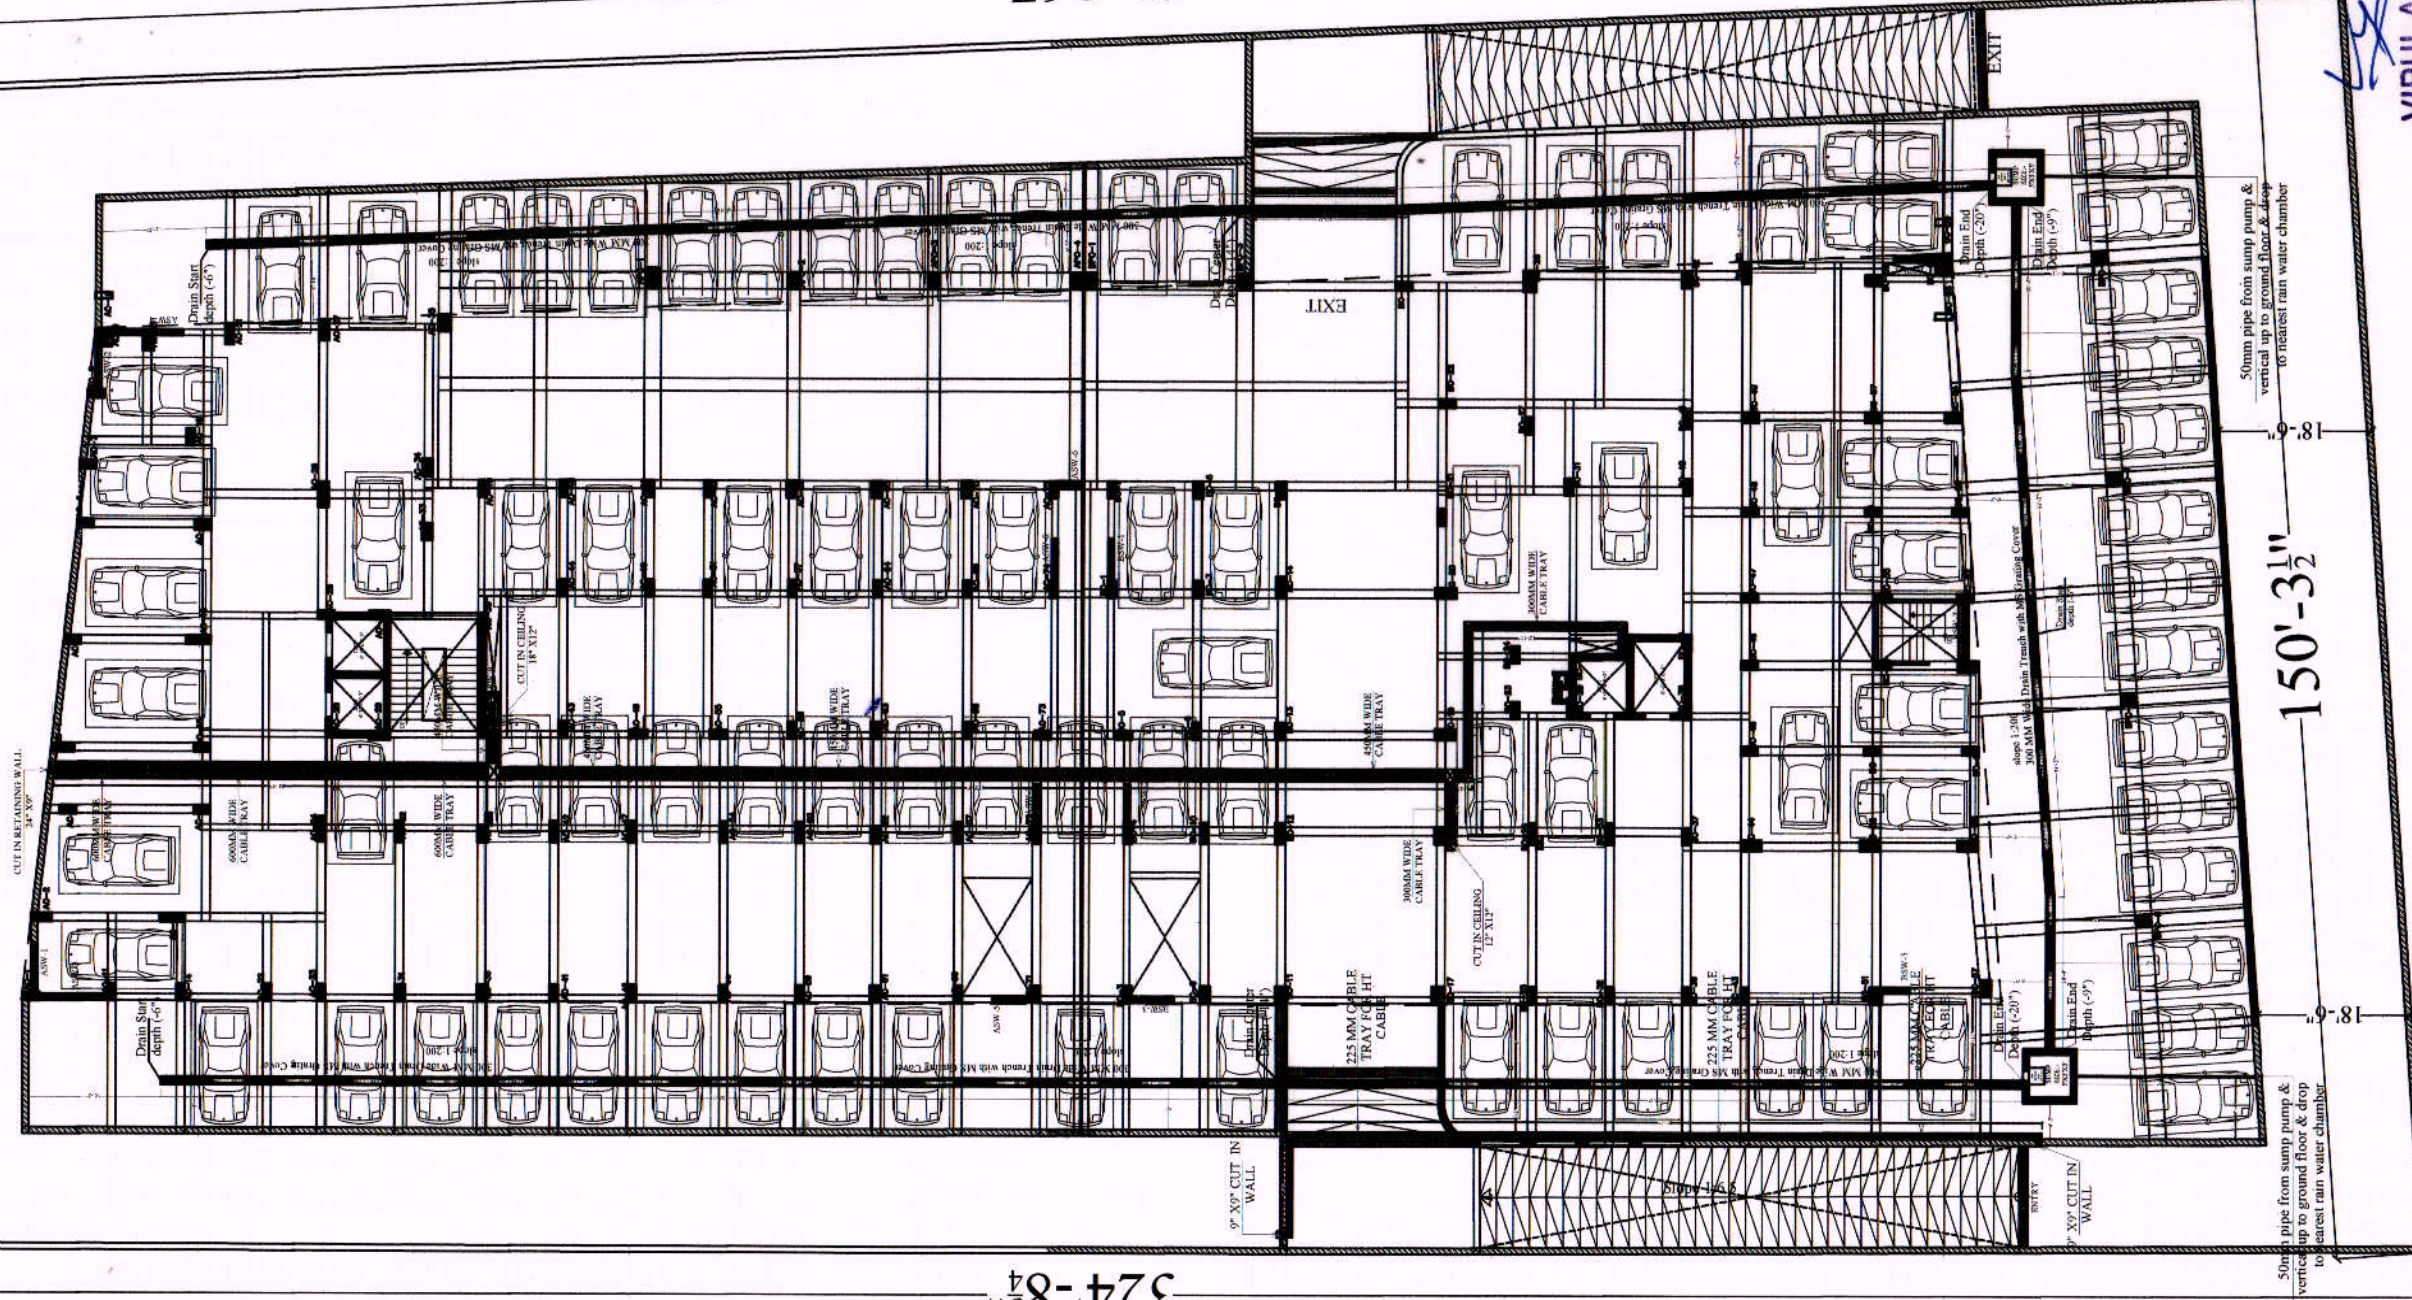

VIPUL AGARWAL
M.E.P. CONSULTANT
B.E. ELECTRICAL

PROJECT:- PROPOSED FLATS AT KHASRA NO. :-1973,1987/1 IN REVENUE-
VILLAGE- SIRSI,TEH-JAIPUR,

PROJECT NAME VARDHMAN SAMPADA

PROMOTER: RICHWELL ENTERPRISES PRIVATE LIMITED

DRAWING: BASEMENT FLOOR CABLE TRAY PLAN

SCALE :-

N.T.S.



ARCHITECTS:-

SPACE GRID

C-49, VIDYA APARTMENT, PARAS MARG,
BAPU NAGAR, JAIPUR - 302015.
PHONE: 9314918766, 9314510603

SERVICES CONSULTANT:


VIPUL CONSULTING,

F 9 / 440, Keshav Marg, Chitrakut Scheme, Jaipur

PH 91-0-93146-10438, 0141-240946

Mail: vipul8599@yahoo.com

REV. NO.01, DATE:-1-03-2017

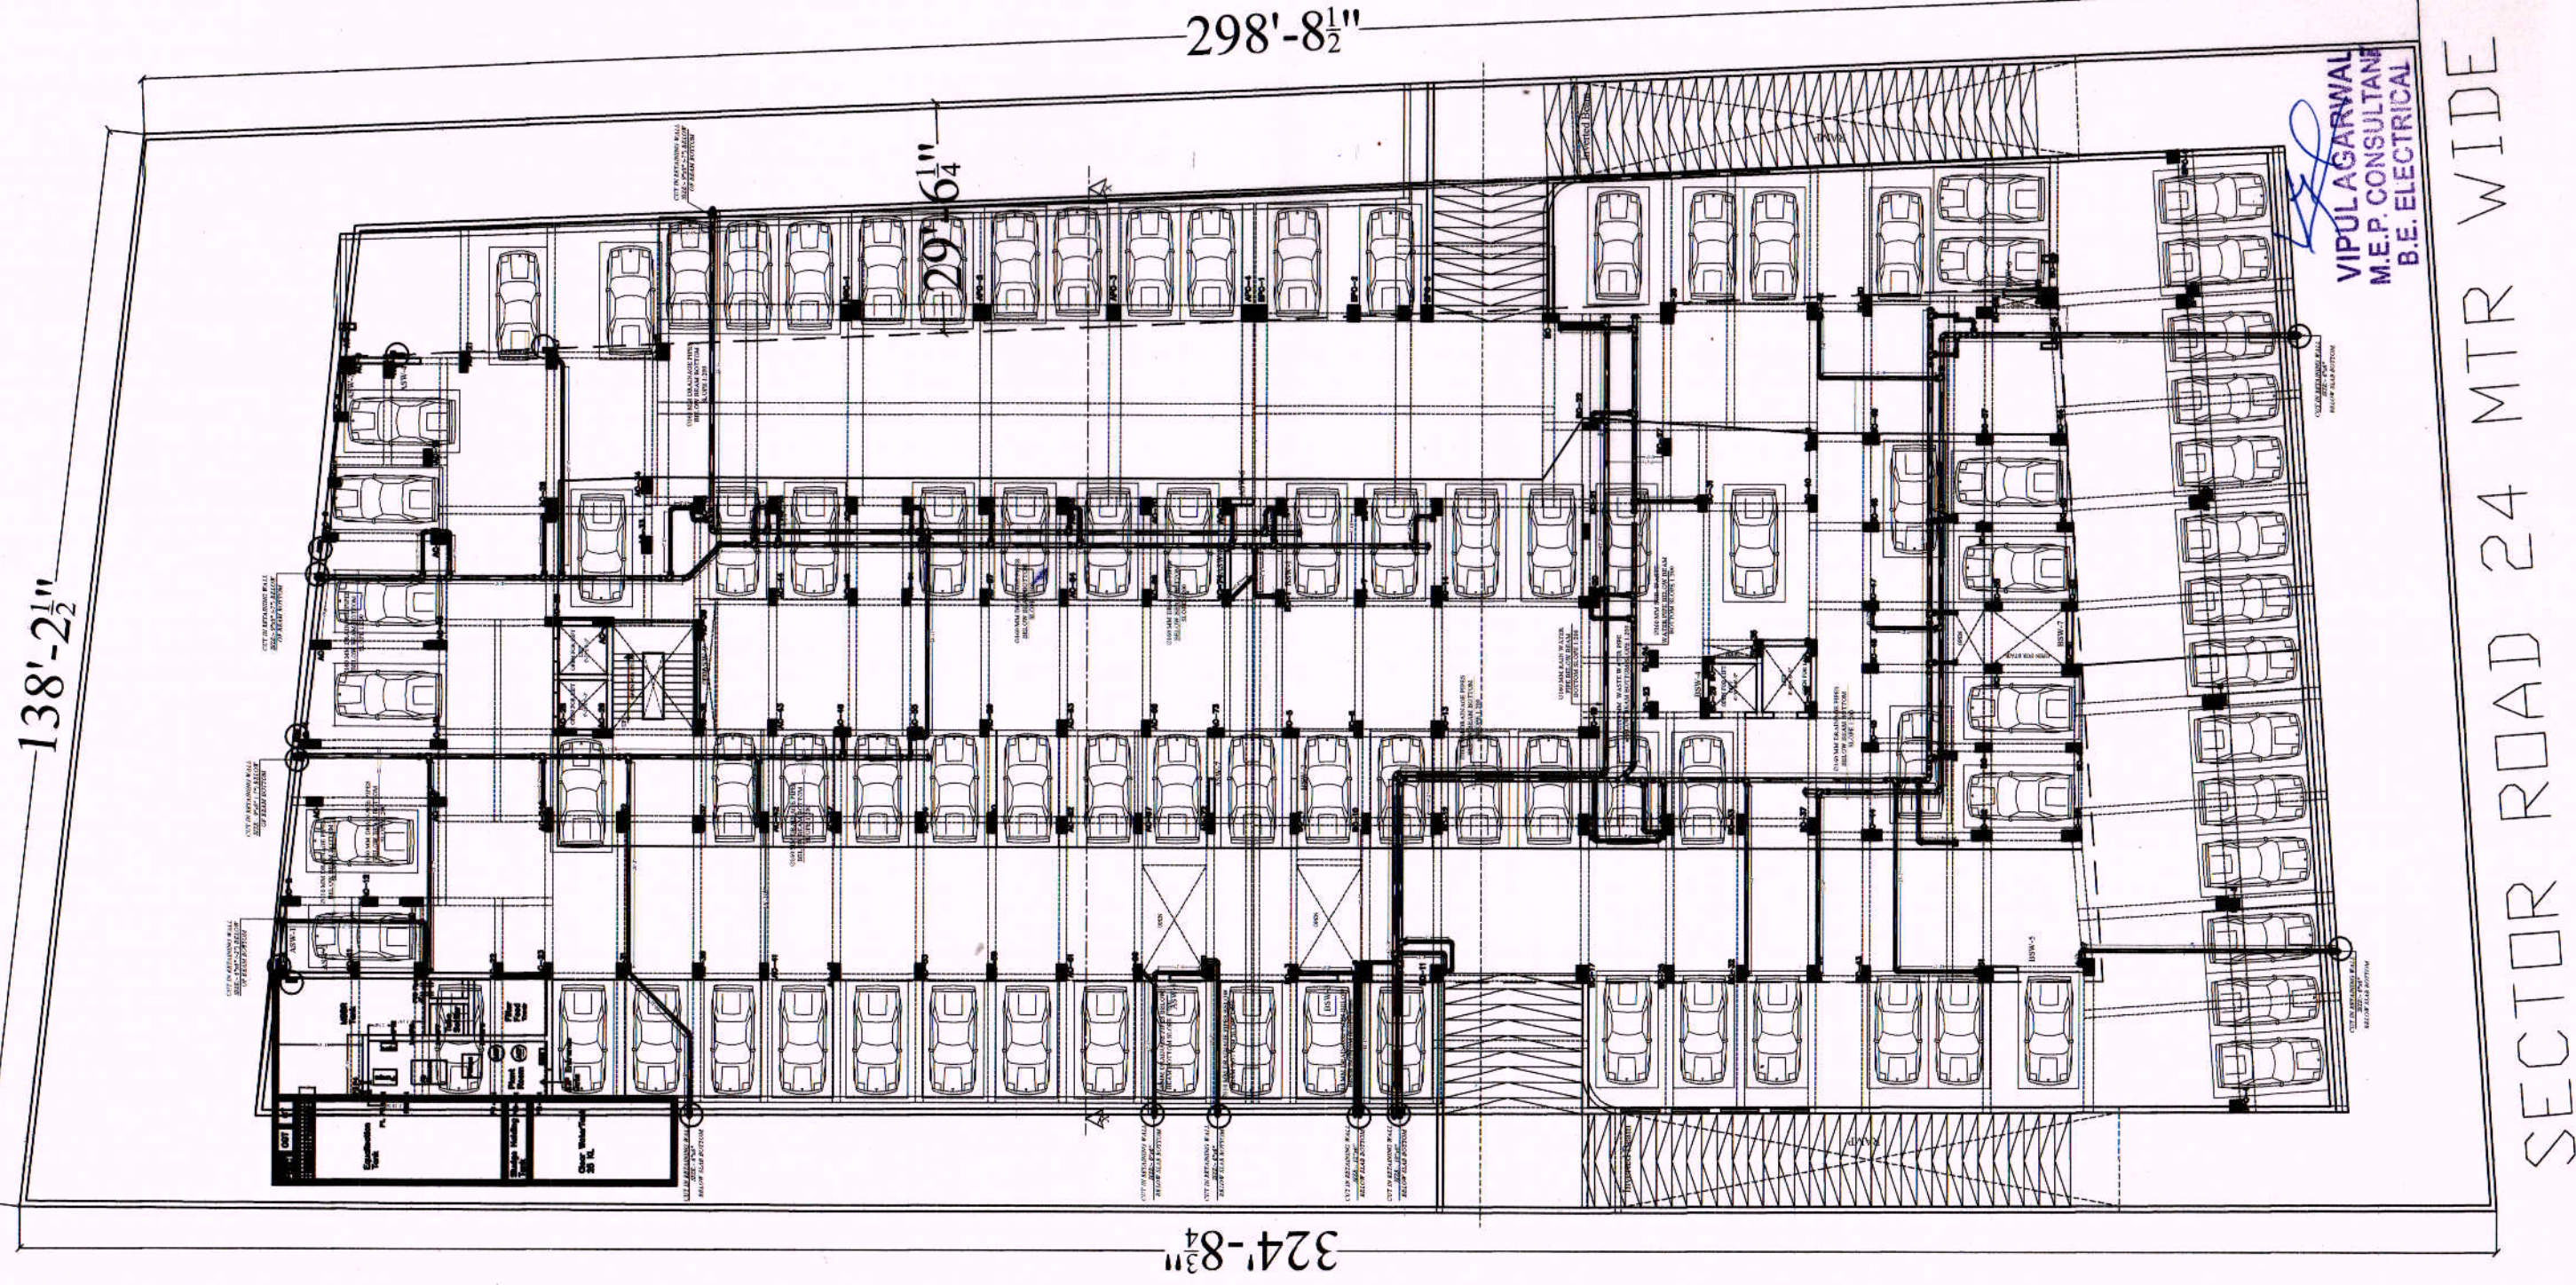

324'-8 $\frac{3}{4}$ '

-298'-8 $\frac{1}{2}$ "

 $29 \frac{1}{4}$

SYMBOL	DESCRIPTION
	110 mm Soil Waste Water Pipe
	110 mm Waste Water Pipe
	110 mm Rain Water Pipe
	110 mm Soil Waste Water Pipe
	110 mm Waste Water Pipe
	110 mm Rain Water Pipe
	160 mm Soil Waste Water Pipe
	160 mm Waste Water Pipe
	160 mm Rain Water Pipe
SERVICE CONSULTANT	

PROJECT NAME

PROMOTER:

PROJECT:-
PROPOSED FLATS AT
KHASRA NO. :-1973,1987/1 IN REVENUE-
VILLAGE-SIRSI,TEH.-JAIPUR,


SCALE: -	REF:
----------	------

DATE: -

DRN.

A. 100% of the available funds.

SPACE GRID

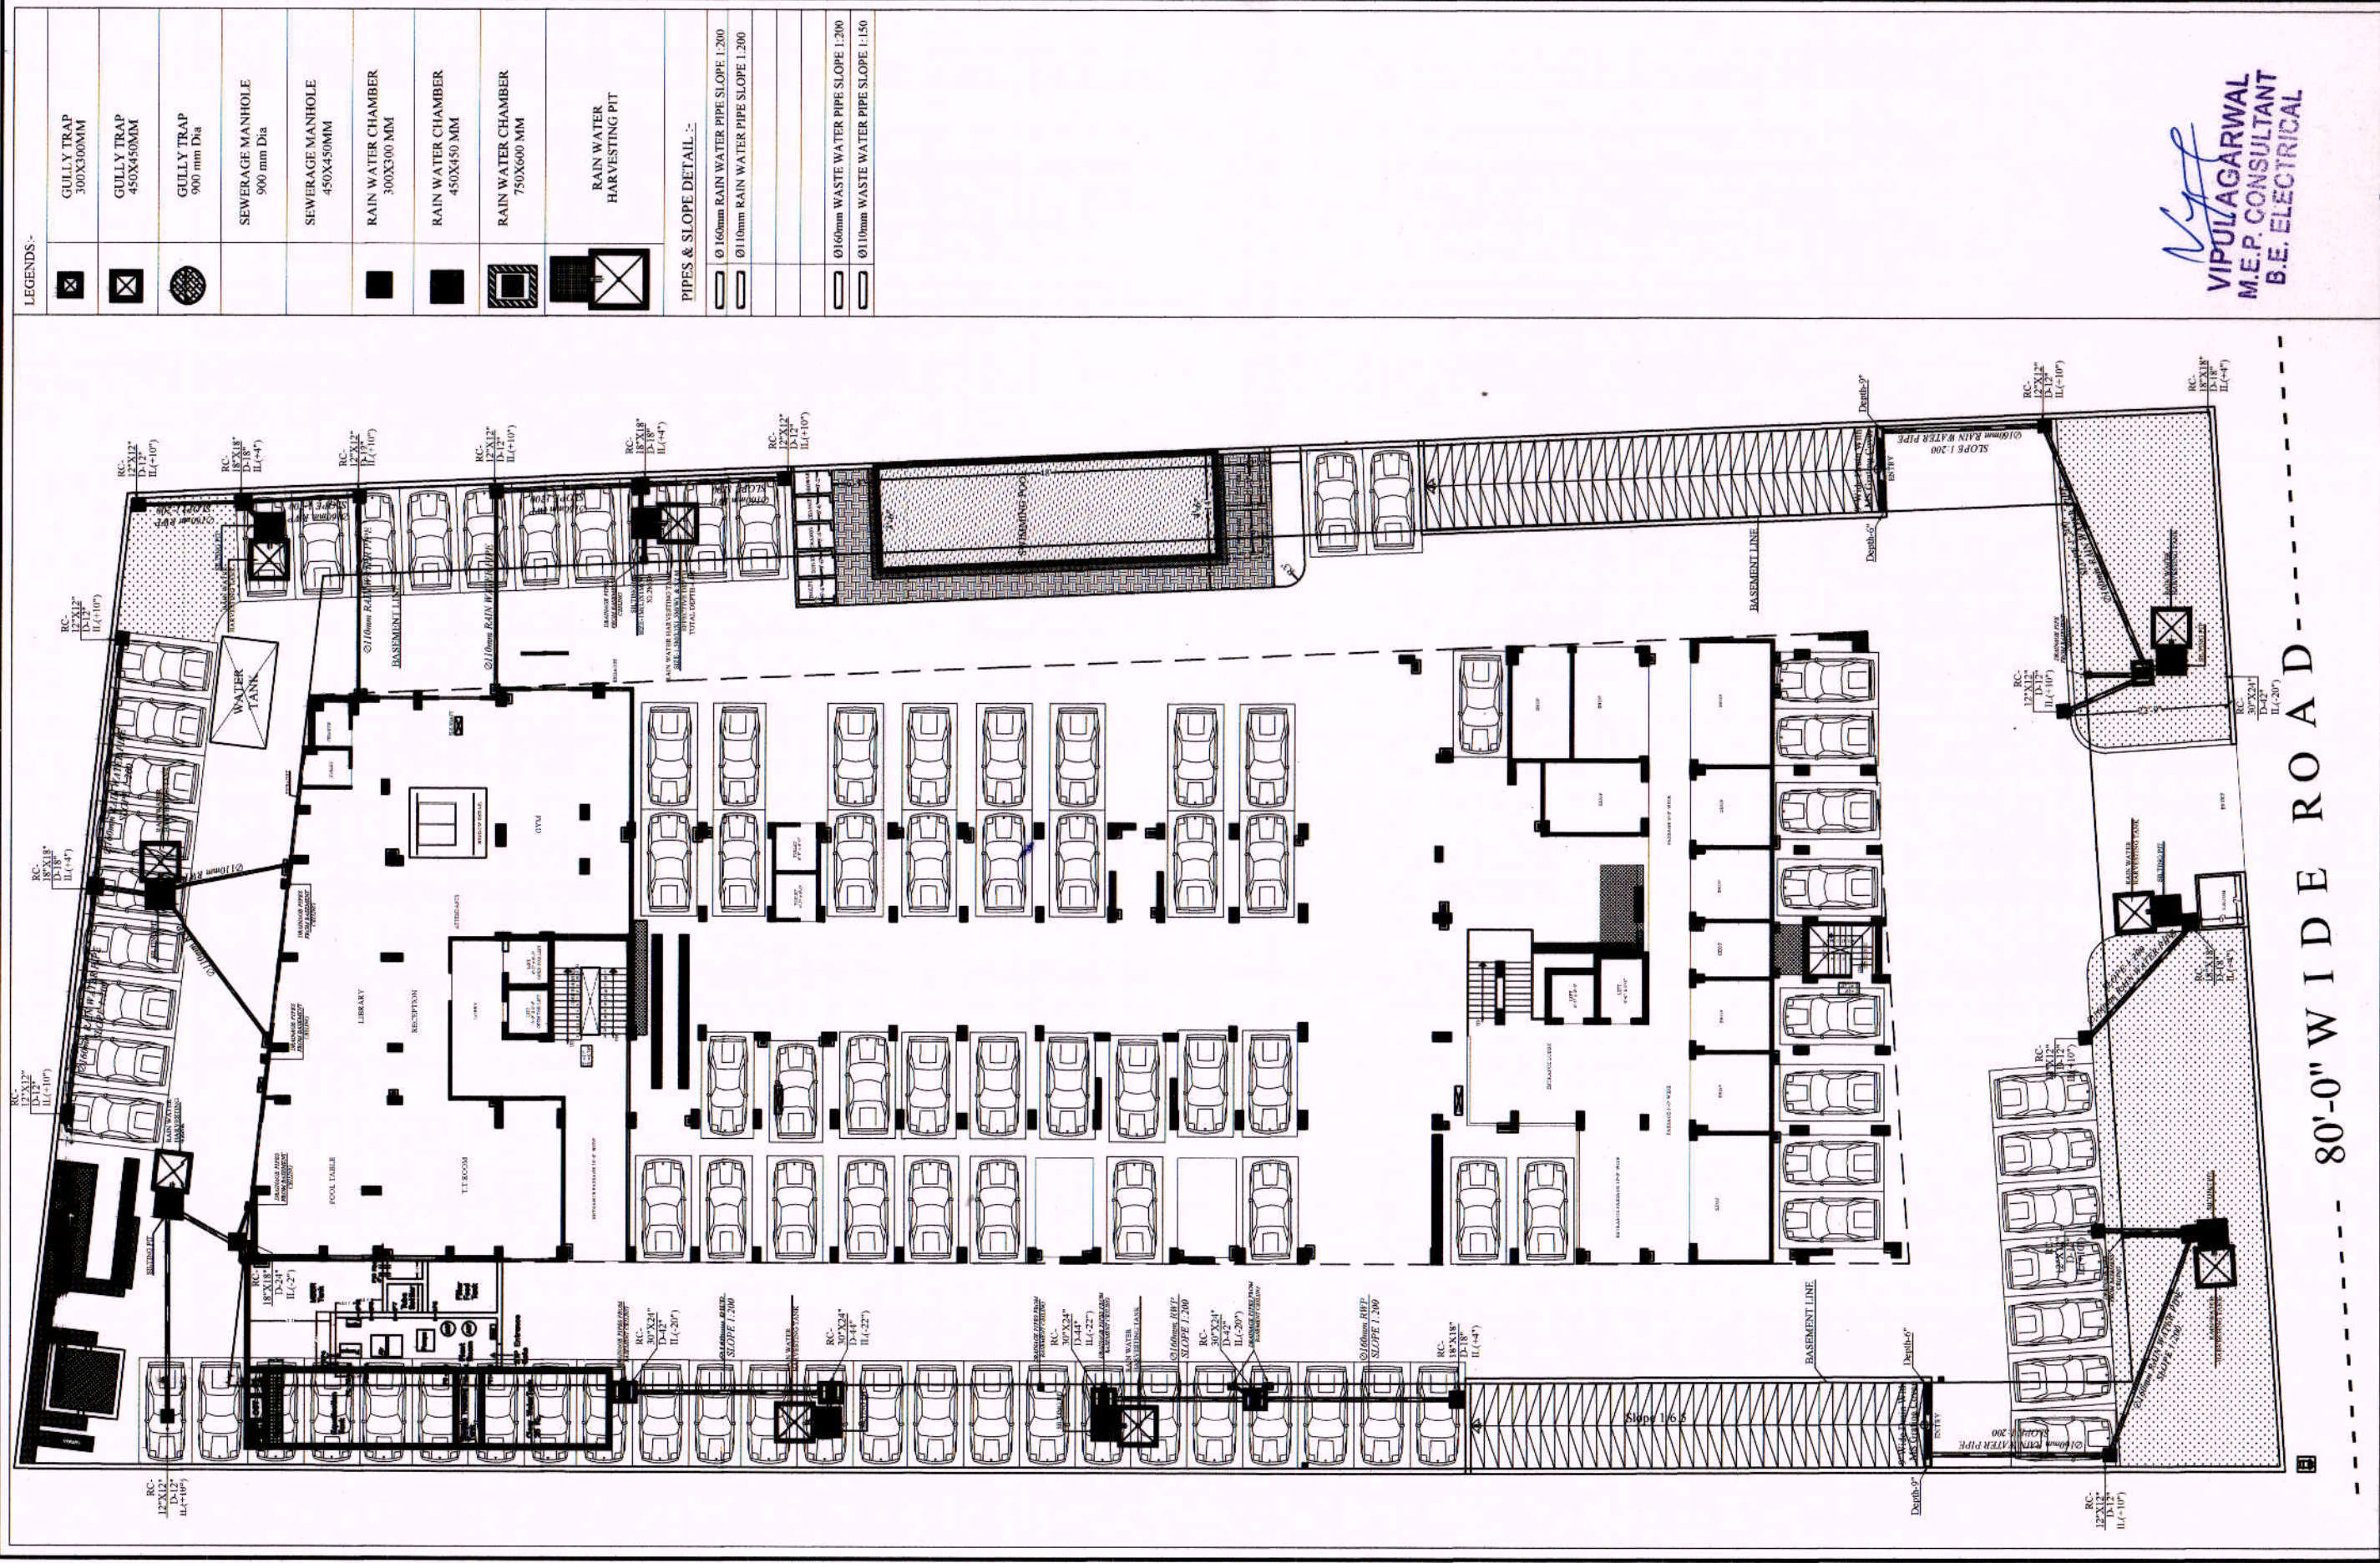

LEGENDS:-

	GULLY TRAP 300X300MM
	GULLY TRAP 450X450MM
	GULLY TRAP 900 mm Dia
	SEWERAGE MANHOLE 900 mm Dia
	SEWERAGE MANHOLE 450X450MM
	RAIN WATER CHAMBER 300X300 MM
	RAIN WATER CHAMBER 450X450 MM
	RAIN WATER CHAMBER 750X600 MM
	RAIN WATER HARVESTING PIT
PIPES & SLOPE DETAIL :-	
	Ø 160mm RAIN WATER PIPE SLOPE 1:200
	Ø 100mm RAIN WATER PIPE SLOPE 1:200
	Ø 160mm WASTE WATER PIPE SLOPE 1:200
	Ø 110mm WASTE WATER PIPE SLOPE 1:150


Vipul
VIPUL AGARWAL
M.E.P. CONSULTANT
B.E. ELECTRICAL

PROJECT:- PROPOSED FLATS AT KHASRA NO. :-1973,1987/1 IN REVENUE-
VILLAGE- SIRSI TEH.-JAIPUR,
PROJECT NAME VARDHMAN SAMPADA
PROMOTER: RICHWELL ENTERPRISES PRIVATE LIMITED
DRAWING: STILT FLOOR EXTERNAL RAIN WATER PIPE ROUTE PLAN

DATE
04-05-2017
N
E
S
W

SERVICE CONSULTANT
VIPUL CONSULTING
F 9/140, Keshav Marg Chitrakut
Scheme Jaipur-11-2440946,
PH-91-0-93146-10438, 0141-2440946,
Mail-vipul8599@yahoo.com


ARCHITECTS:-
SPACE GRID
C-49, VIDYA APARTMEN, PARAS MARG,
BAPU NAGAR, JAIPUR - 302015.
PHONE: 9314918766, 9314510603

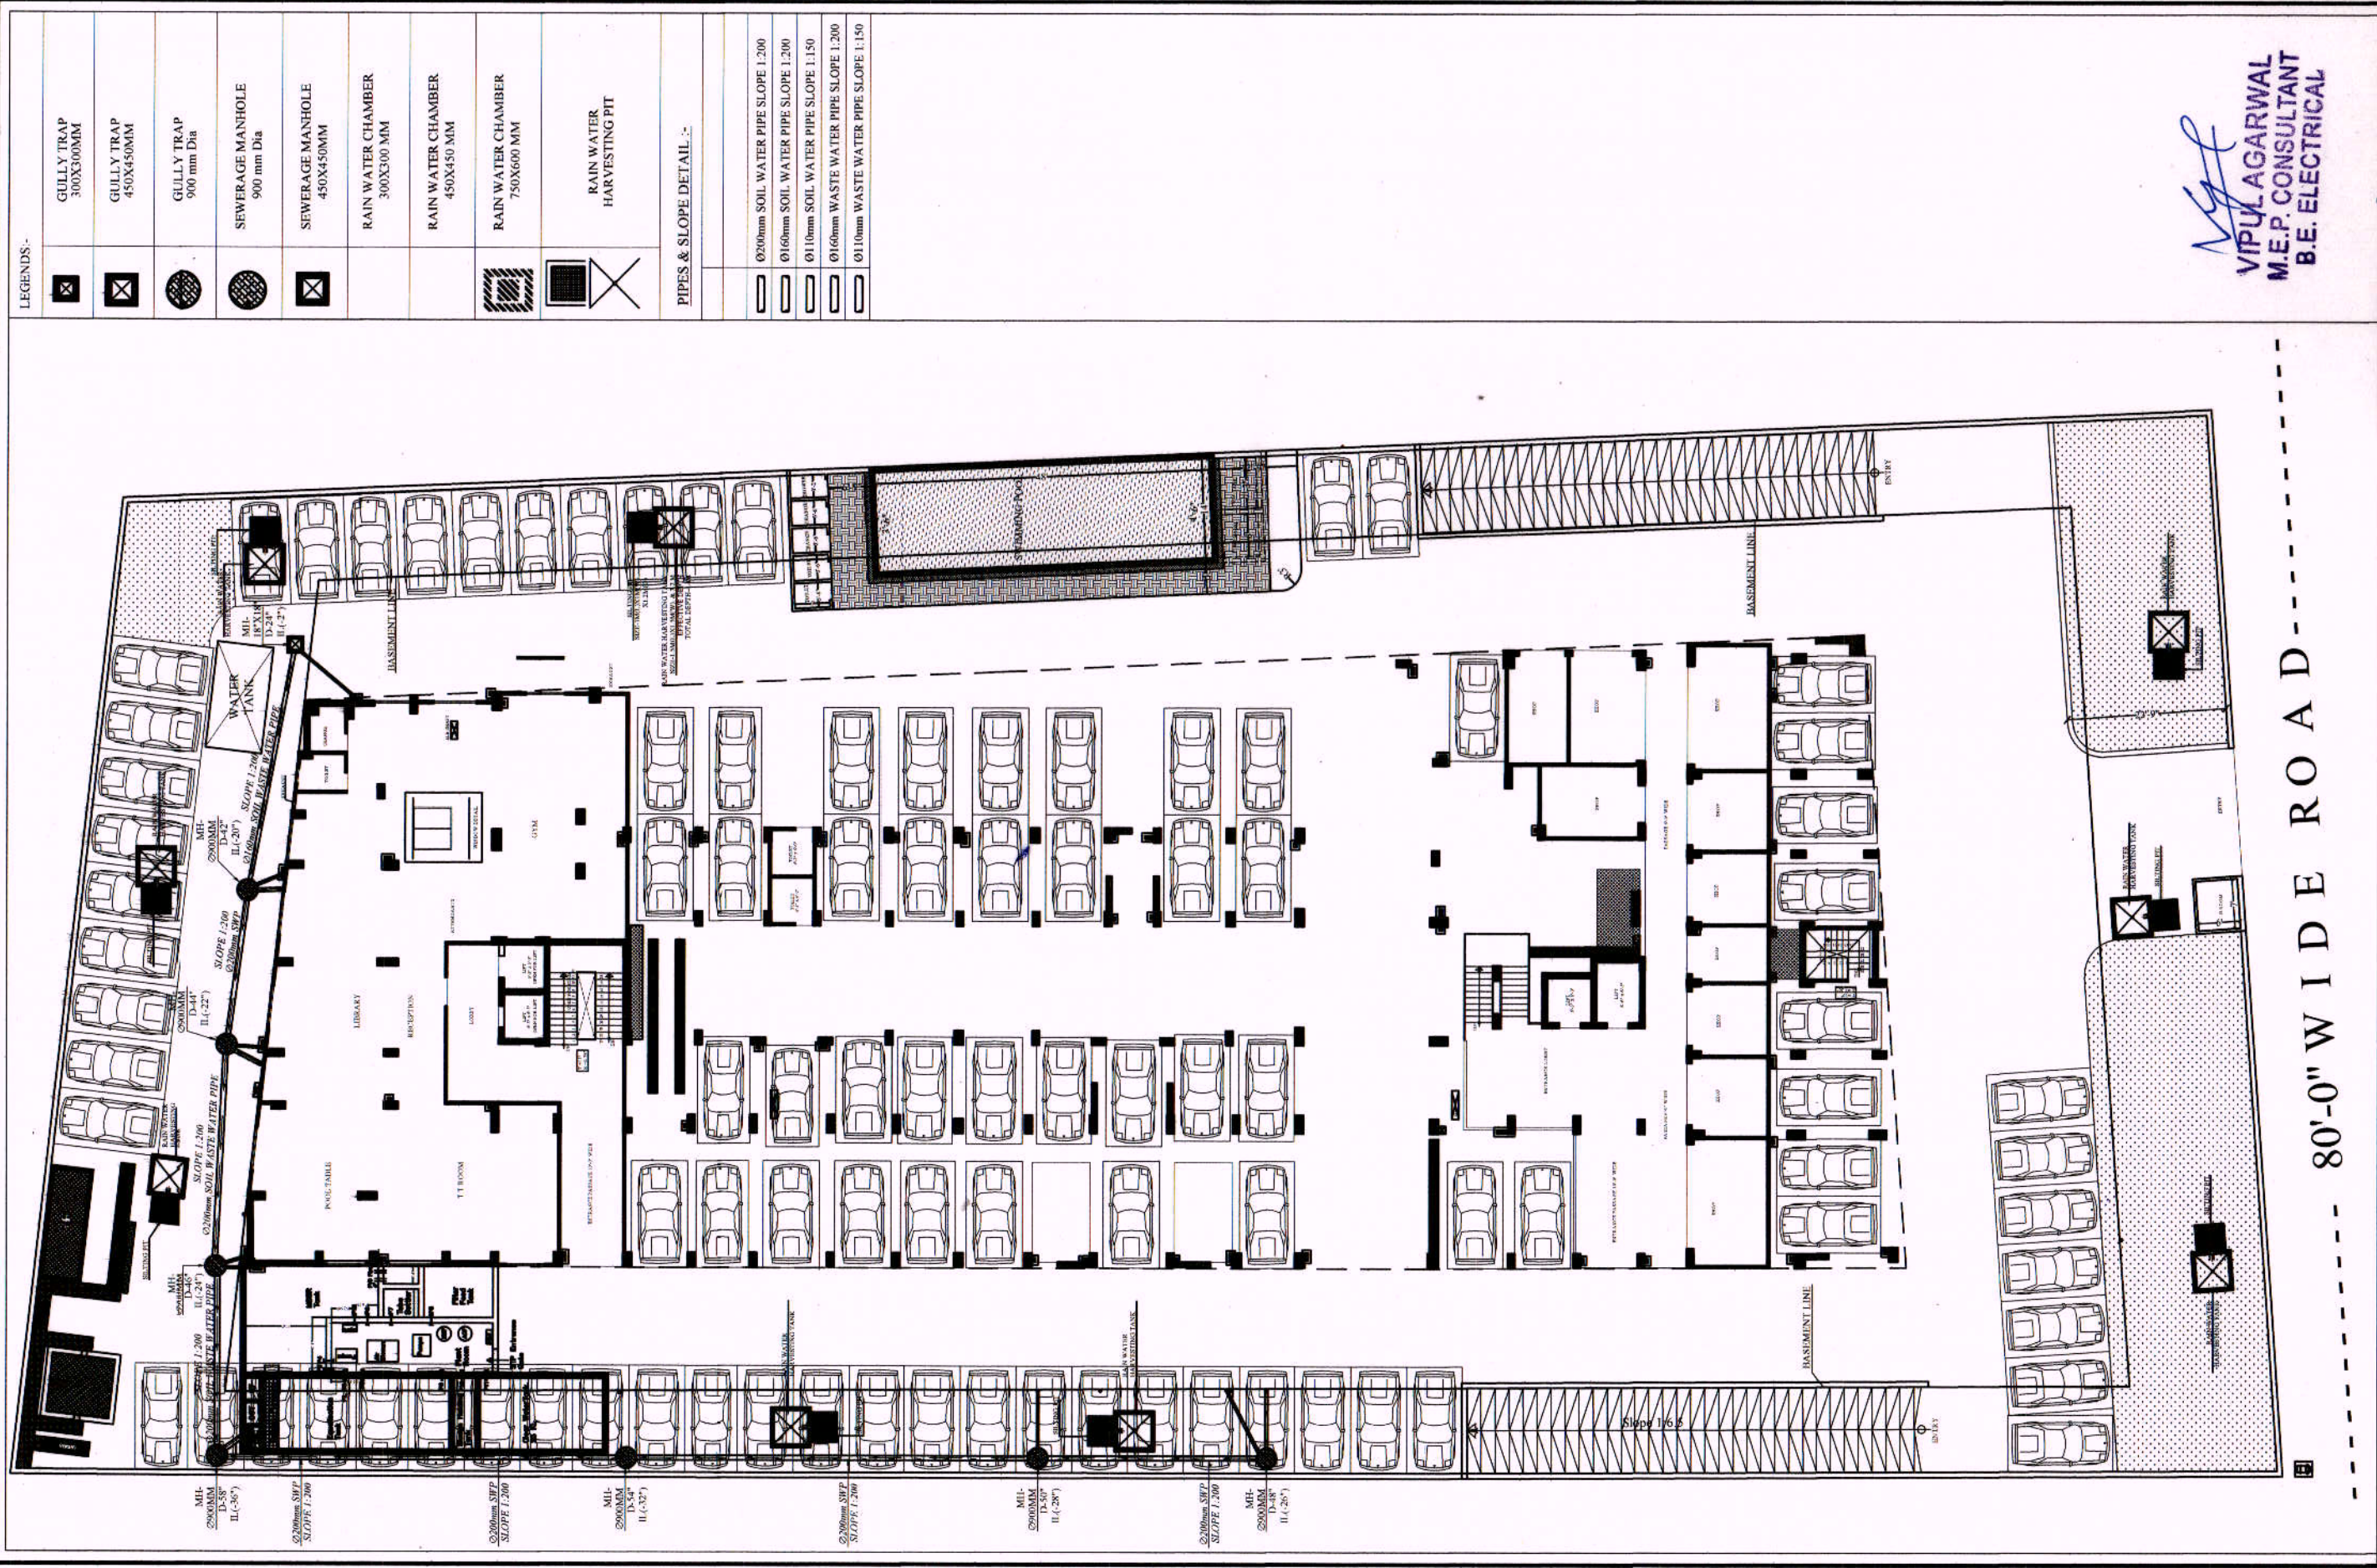


Vipul
VIPUL AGARWAL
M.E.P. CONSULTANT
B.E. ELECTRICAL

PROJECT:- PROPOSED FLATS AT KHASRA NO. :-1973,1987/1 IN REVENUE-VILLAGE- SIRSI,TEH.-JAIPUR,		DATE	ARCHITECTS:- SPACE GRID
PROJECT NAME VARDHMAN SAMPADA		04-05-2017	
PROMOTER: RICHWELL ENTERPRISES PRIVATE LIMITED			SERVICE CONSULTANT VIPUL CONSULTING F 9/140, Keshav Marg Chitrakut Scheme Jaipur PH-91-0-93146-10438, 0141-2440946, Mail: vipul8599@yahoo.com
DRAWING: STILL FLOOR EXTERNAL SEWERAGE PLAN			
			C-49, VIDYA APARTMEN, PARAS MARG, BAPU NAGAR, JAIPUR - 302015. PHONE: 9314918766, 9314510603

VARDHMAN's SAMPADA
STILT FLOOR PLAN

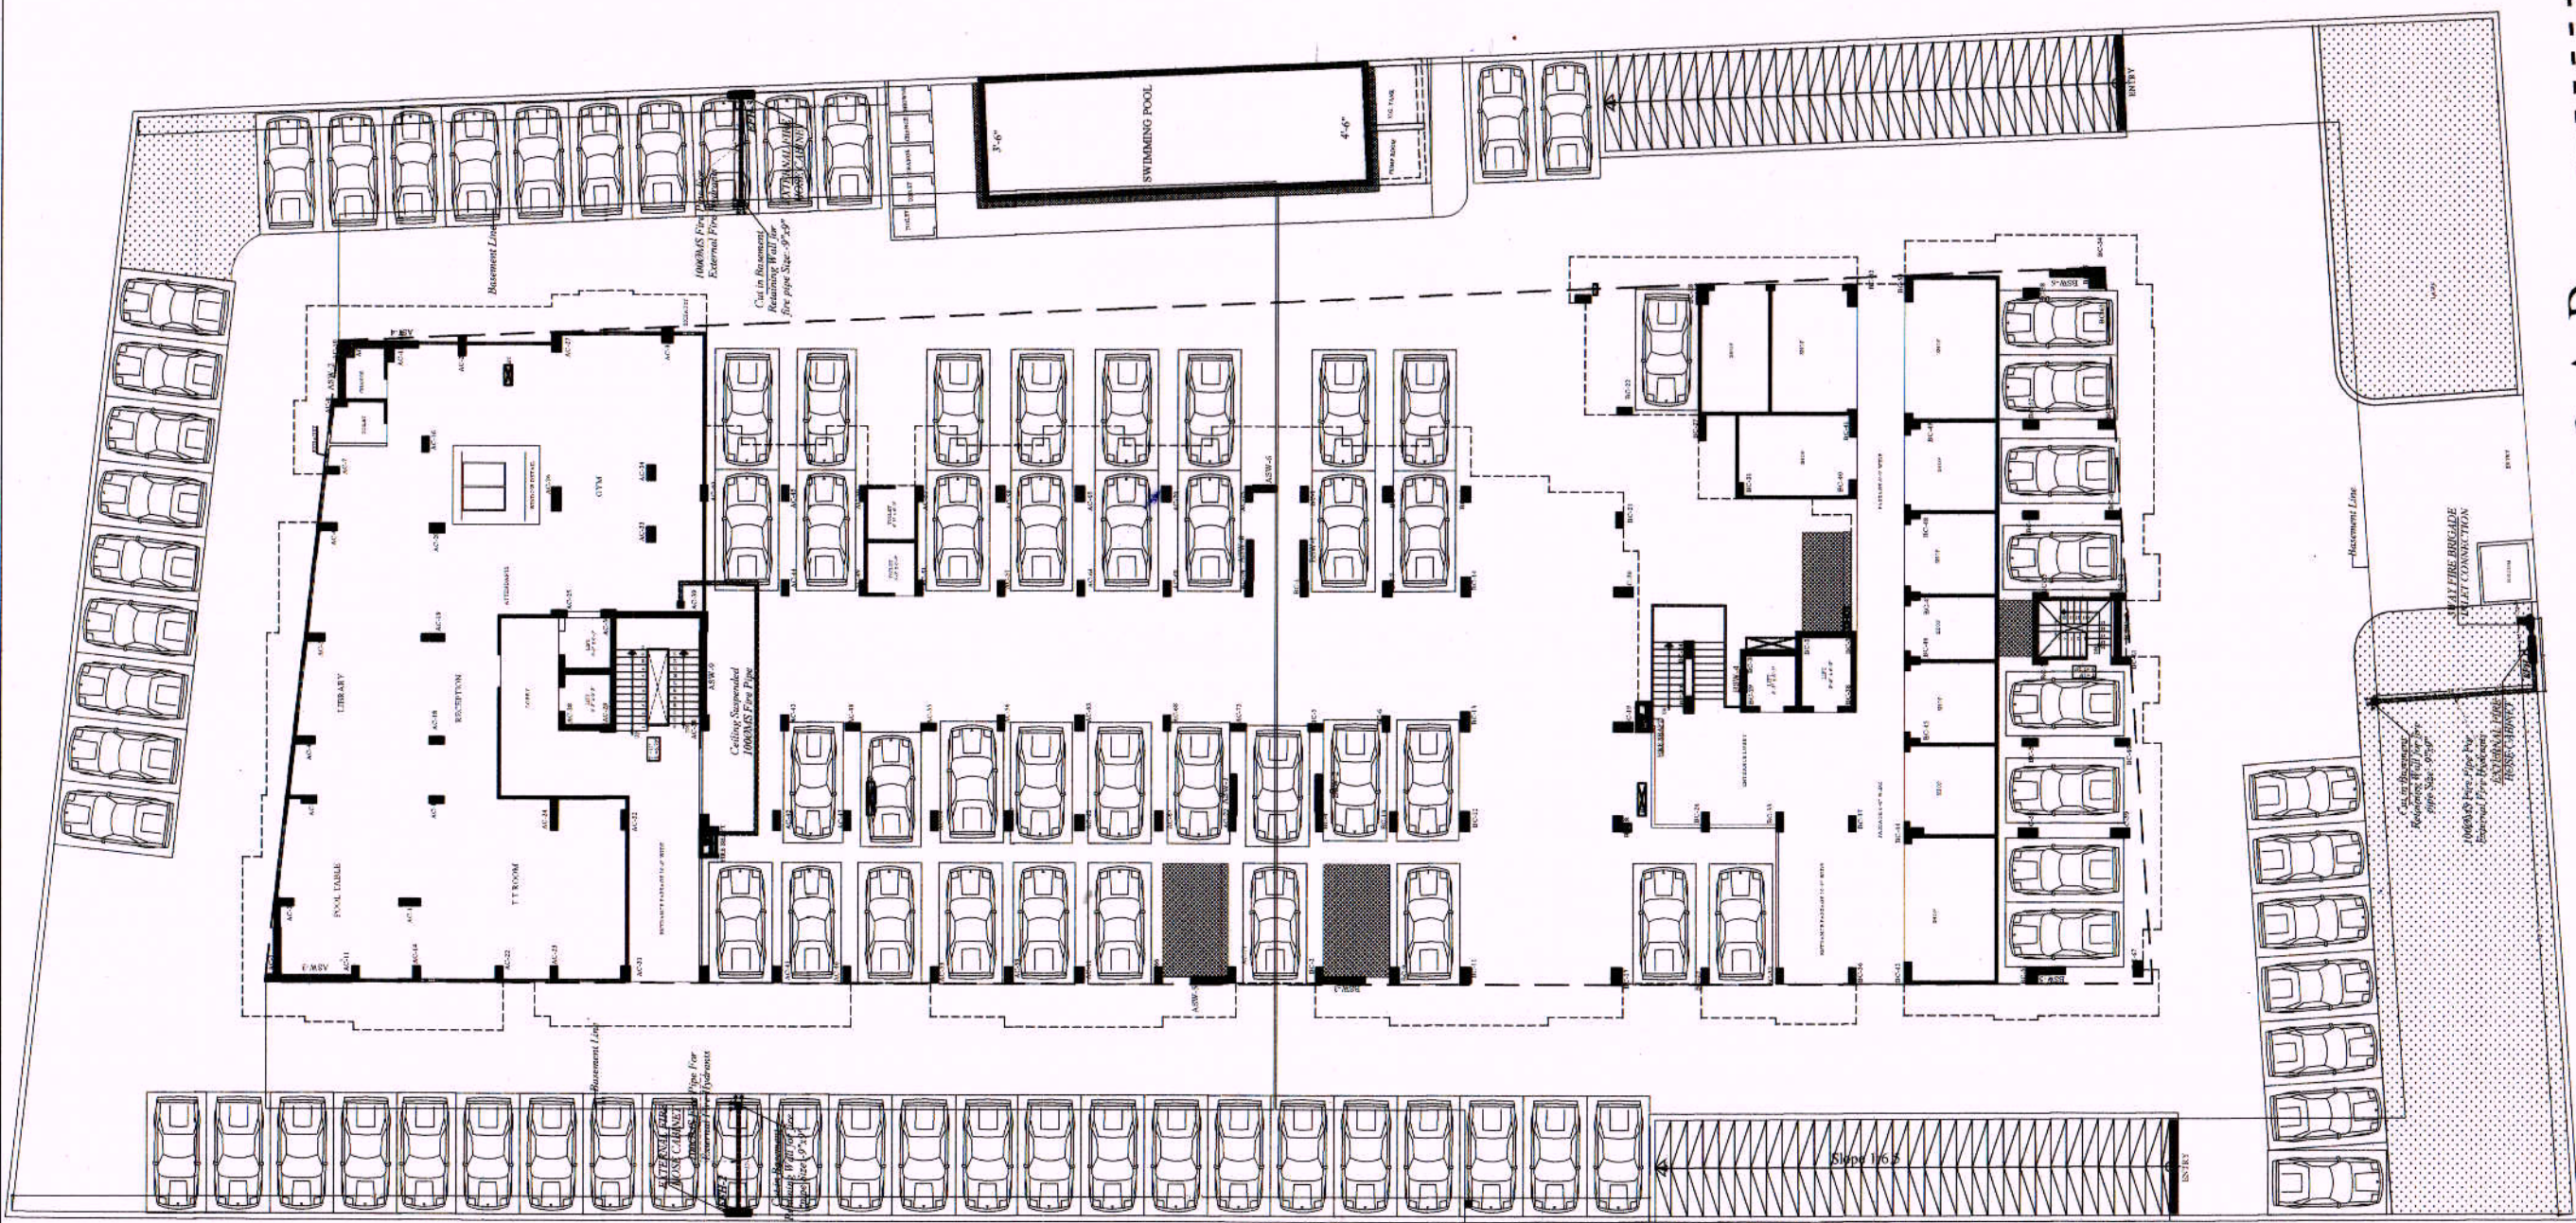

Vy
VIPUL AGARWAL
M.E.P. CONSULTANT
B.E. ELECTRICAL

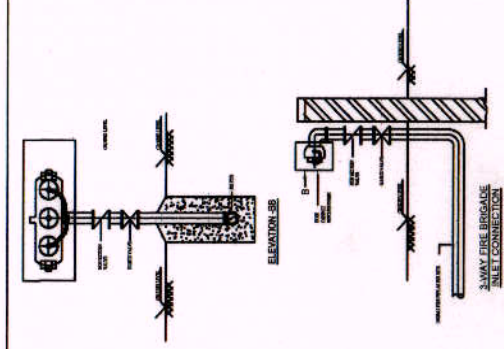

SYMBOL	QTY.	DESCRIPTION
	02	100MM FIRE PIPE FOR EXTERNAL FIRE HYDRANTS
	02	FIRE HOSE CABINET
	03	EXTERNAL FIRE HOSE CABINET

SERVICES CONSULTANT:
VIPUL CONSULTING,
F-9/440, Keshav Marg, Chitrakut
Scheme, Jaipur
PH: 91-0-93146-10438, 0141-2440946
Mail: vipul8599@yahoo.com
REV. NO.01, DATE: 04-03-2017

ARCHITECTS:-
SPACE GRID
C-49, VIDYA APARTMENT, PARAS MARG,
BAPU NAGAR, JAIPUR - 302015.
PHONE: 9314918766, 9314510603



SCALE :-
N.T.S.



PROJECT:- PROPOSED FLATS AT KHASRA NO. -1973, 1987/1 IN REVENUE-
VILLAGE- SIRSI, TEH.-JAIPUR.
PROJECT NAME VARDHMAN SAMPADA
PROMOTER: RICHWELL ENTERPRISES PRIVATE LIMITED
DRAWING: STILT FLOOR EXTERNAL
FIRE HYDRANT PLAN

80'-0" W I D E R O A D

VARDHMAN's SAMPADA
STILT FLOOR PLAN

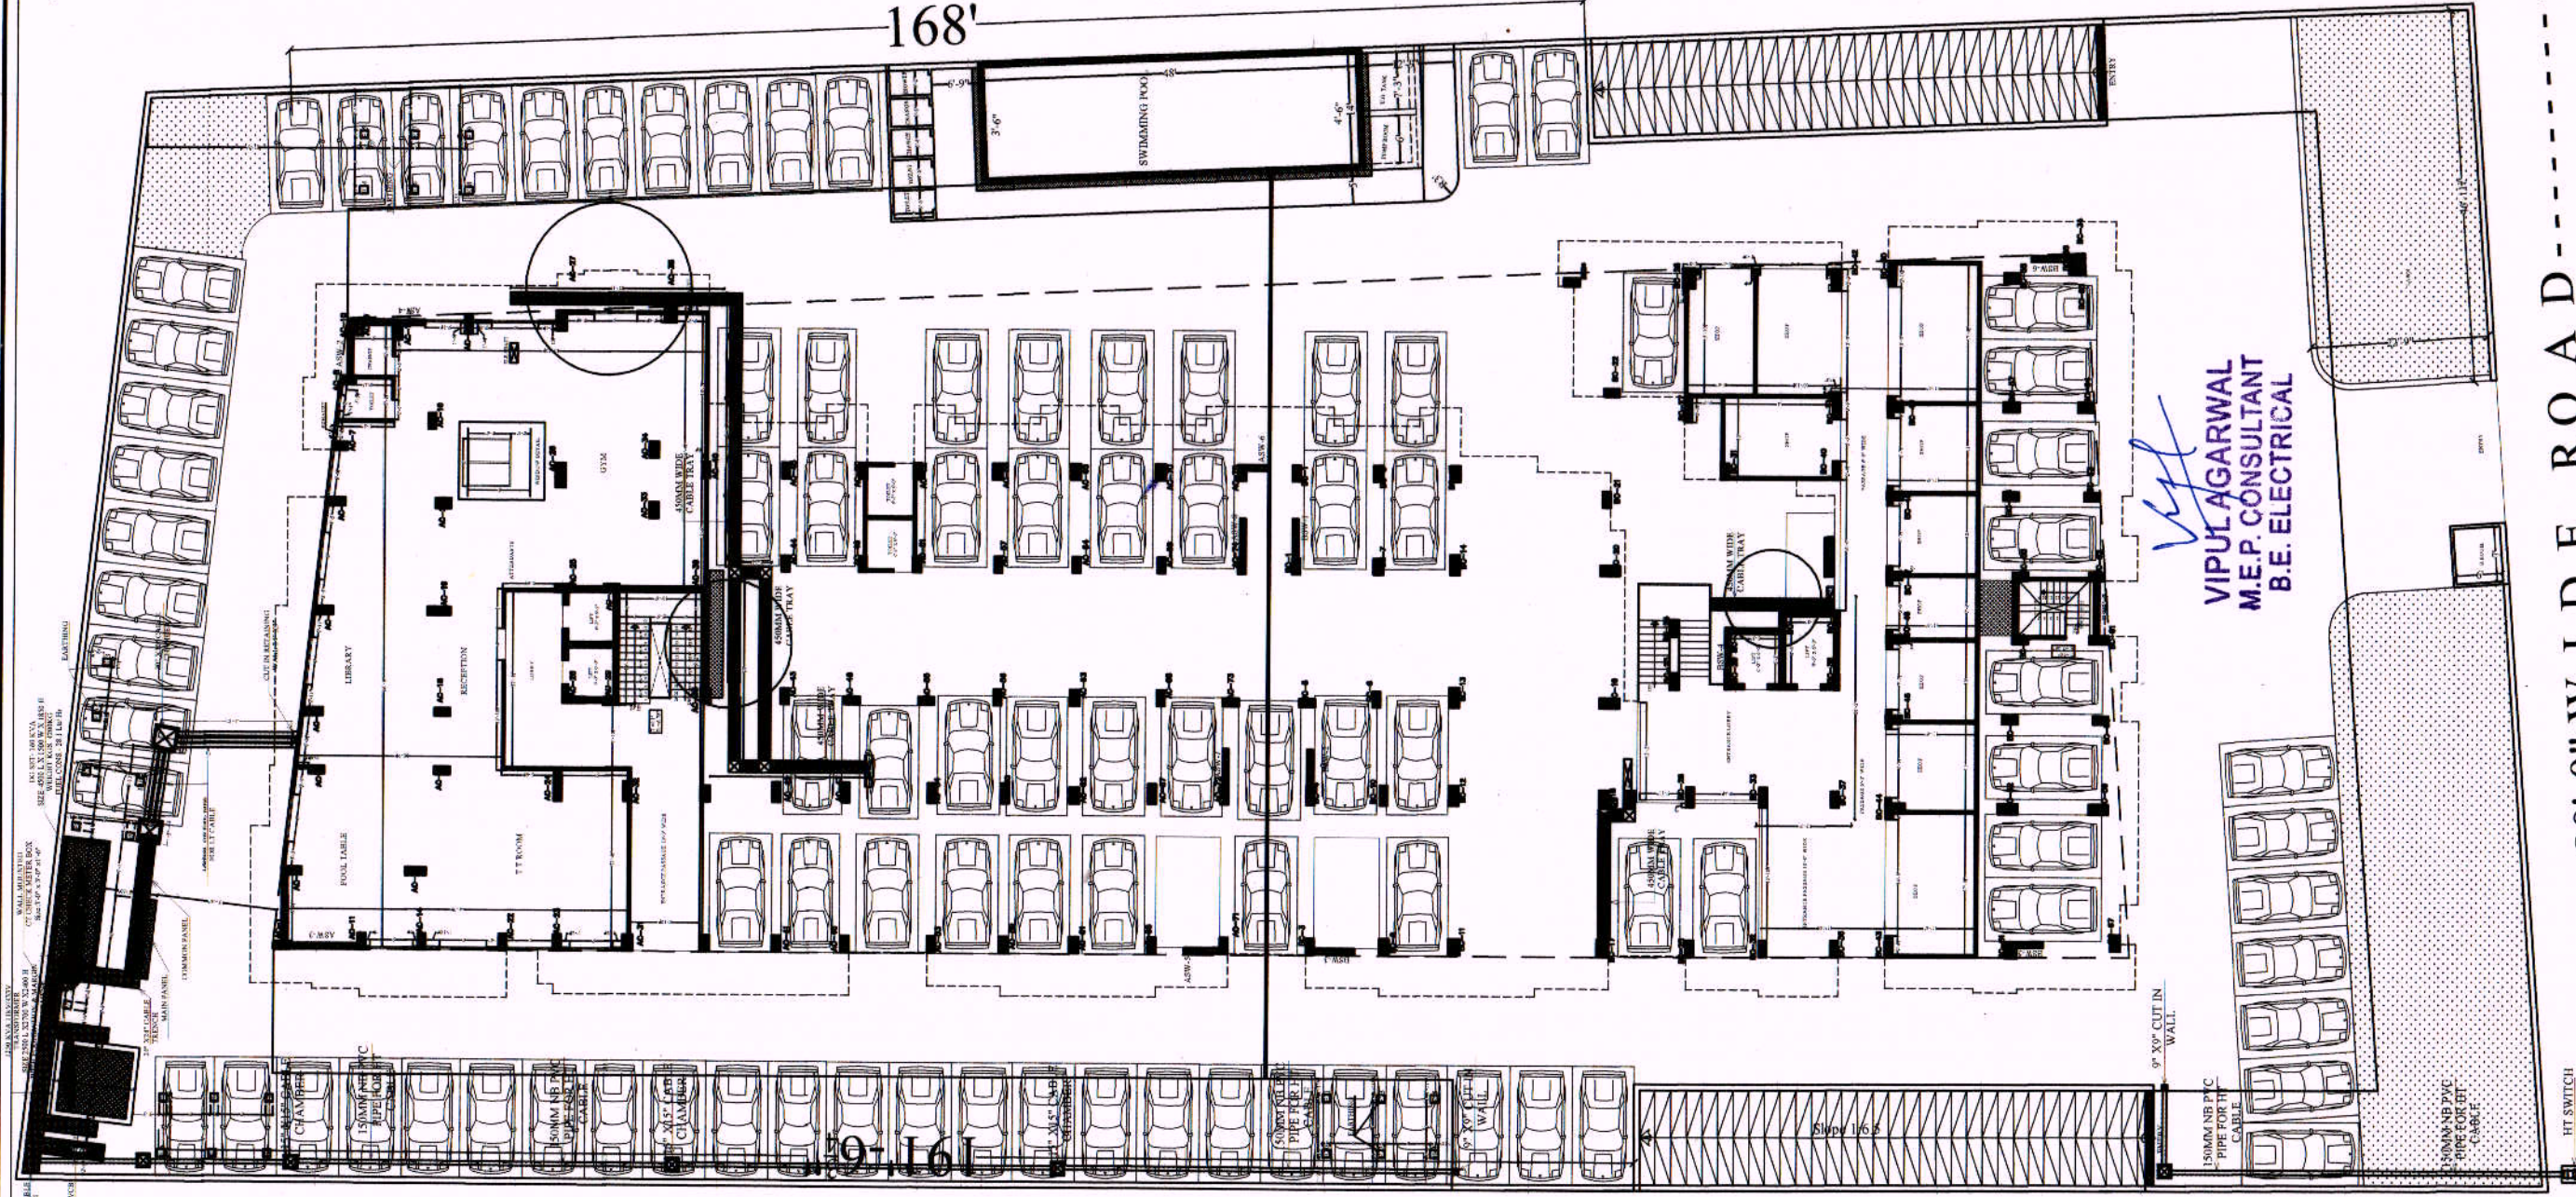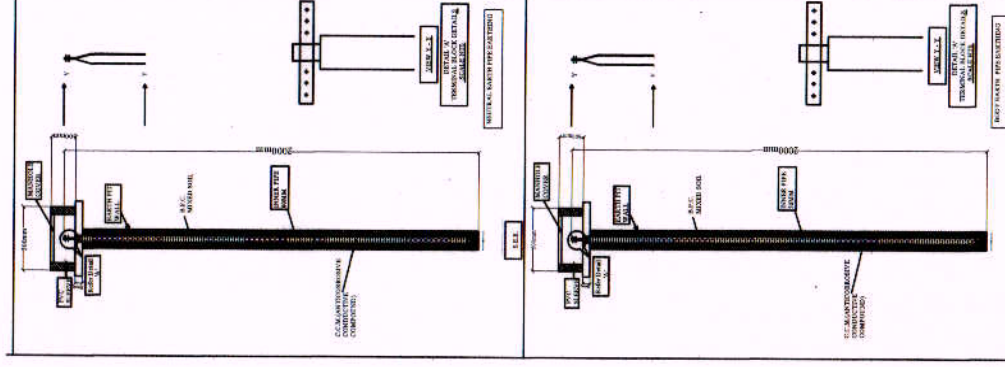

- NOTES:
1. ALL NEUTRAL EARTHS TO BE CONNECTED 50 X 3 GI EARTH STRIP FROM EARTH PIT TO EQUIPMENT.
 2. ALL BODY EARTHS TO BE CONNECTED 25 X 3 GI EARTH STRIP FROM EARTH PIT TO EQUIPMENT.

EARTHING DETAILS	
1. E1	50MM PPG2(METER) HT SWITCH EARTH
2. E2	50MM PPG2(METER) HT SWITCH EARTH
3. E3	50MM PPG2(METER) TRANSFORMER BODY EARTH
4. E4	50MM PPG2(METER) TRANSFORMER BODY EARTH
5. E5	50MM PPG2(METER) TRANSFORMER NEUTRAL EARTH
6. E6	50MM PPG2(METER) TRANSFORMER NEUTRAL EARTH
7. E7	50MM PPG2(METER) CT CHUCK METER BODY EARTH
8. E8	50MM PPG2(METER) DG SET BODY EARTH
9. E9	50MM PPG2(METER) DG SET BODY EARTH
10. E10	50MM PPG2(METER) DG SET NEUTRAL EARTH
11. E11	50MM PPG2(METER) DG SET NEUTRAL EARTH
12. E12	50MM PPG2(METER) MAIN LT PANEL BODY EARTH
13. E13	50MM PPG2(METER) MAIN LT PANEL BODY EARTH
14. E14	50MM PPG2(METER) BLK-A LIFT PANEL 2 BODY EARTH
15. E15	50MM PPG2(METER) BLK-A LIFT PANEL 2 BODY EARTH
16. E16	50MM PPG2(METER) BLK-A TEL EXCH BODY EARTH
17. E17	50MM PPG2(METER) BLK-A METER PANEL BODY EARTH
18. E18	50MM PPG2(METER) BLK-A LIGHTNING ARRESTOR
19. E19	50MM PPG2(METER) BLK-A LIGHTNING ARRESTOR
20. E20	50MM PPG2(METER) BLK-B LIFT PANEL 1 BODY EARTH
21. E21	50MM PPG2(METER) BLK-B LIFT PANEL 1 BODY EARTH
22. E22	50MM PPG2(METER) BLK-B TEL EXCH BODY EARTH
23. E23	50MM PPG2(METER) BLK-B METER PANEL BODY EARTH
24. E24	50MM PPG2(METER) BLK-B LIGHTNING ARRESTOR
25. E25	50MM PPG2(METER) BLK-B LIGHTNING ARRESTOR

PROJECT:- PROPOSED FLATS AT KHASRA NO.:-1973,1987/1 IN REVENUE-

VILLAGE- SIRSI,TEH.-JAIPUR,

PROJECT NAME VARDHMAN SAMPADA

PROMOTER: RICHWELL ENTERPRISES PRIVATE LIMITED

DRAWING: STILT FLOOR ELECTRIC SUB STATION PLAN

SCALE :-

N.T.S.



ARCHITECTS:-

SPACE GRID

C-49,VIDYA APARTMEN,PARAS MARG,

BAPU NAGAR,JAIPUR - 302015.

PHONE: 9314918766,9314510603

SERVICES CONSULTANT:

VIPUL CONSULTING,

F 9 / 440, Keshav Marg, Chitrakut Scheme, Jaipur

PH:91-0-93146-10438,0141-2440946

Mail:vipul8599@yahoo.com

REV. NO.01, DATE:-1-03-2017

200mm DIA BORE WITH 1500 PLAIN /
SLOTTED PIPE
1'-6" CUT REQUIRED FOR MH-2'-0"x2'-0"

2'-0" CUT REQUIRED FOR
Rectangular M.H. 2'-6"x2'-6"

2'-0" CUT REQUIRED FOR
Rectangular M.H. 2'-6"x2'-6"

DRAIN INLET FROM
RAIN WATER CATCH
BASIN CHAMBER AS
PER PLAN

SITE CONDITIONS TO BE
TERMINATED AS PER
50mm DIA VENT PIPE

RAIN WATER PIPE
DROP TO
HARVESTING PIT

RAIN WATER HARVESTING PIT OF
SIZE -6'-8" L X 6'-8" W
X 10'-6" EFFECTIVE DEPTH.
TOTAL DEPTH-12'-3"

SITE CONDITIONS TO BE
TERMINATED AS PER
50mm DIA VENT PIPE

SITE CONDITIONS TO BE
TERMINATED AS PER 50mm DIA
VENT PIPE

2'-6" Rectangular
M.H.

2'-0" Rectangular
M.H.

SITE CONDITIONS TO BE
TERMINATED AS PER 50mm
DIA VENT PIPE

DRAIN INLET FROM
RAIN WATER CATCH
BASIN CHAMBER AS
PER PLAN

GRATING OF MIN. SIZE WITH
16 mm SQ. BARS & FRAME @
20 mm CLEAR SPACING FIXED
AT THE MOUTH OF PIPE AS
PER SITE CONDITION

160mm RAIN WATER OVER
FLOW PIPE DROP TO
EXTERNAL DRAIN FOR AS
PER SITE CONDITION

100mm DIA WEEP HOLES
@ 500mm C/C TO BE
PROVIDED 1200mm
ABOVE THE BOTTOM OF
THE WELL

THIRD LAYER 300mm THICK
SAND FILLING
SECOND LAYER 300mm THICK
OF SMALL STONES
FIRST LAYER 300mm THICK
OF BOULDERS

CEMENT CONC. 1:2:4

200mm DIA BORE
FILLING OF ROUNDED PEA
GRAVEL DULY WASHED
3mm TO 6mm SIZE

1500 SLOTTED PIPE WITH A MINIMUM
DEPTH 35 M. (TO BE TAKEN TO WATER
LEVEL)

VIPUL AGARWAL
M.E.P. CONSULTANT
B.E. ELECTRICAL

SERVICE CONSULTANT

VIPUL CONSULTING
F 9 / 440 , Keshav Marg Chitrakut Scheme,Jaipur
PH:91-0-93146-10438 ,0141-2440946, Mail:vipul8599@yahoo.com

PROJECT NAME

VARDHMAN SAMPADA

DRAWING NAME

RAIN WATER HARVESTING PIT
SECTION DETAILS PLAN

PROMOTER:

RICHWELL ENTERPRISES PRIVATE LIMITED

PROJECT ADDRESS

KHASRA NO. :- 1973,1987/1 IN REVENUE-
VILLAGE- SIRSI,TEH.-JAIPUR,

ARCHITECTS:

SPACE GRID




C-49, VIDYA APARTMENT, PARAS
MARG, BAPU NAGAR, NEAR JANTA
STORE CIRCLE, JAIPUR-302015
PH-09314918766,0141-4005506 (O)
Email:-info.spacegrid@gmail.com

CKD. BY:

SANJAY

DATE:

04-05-2017

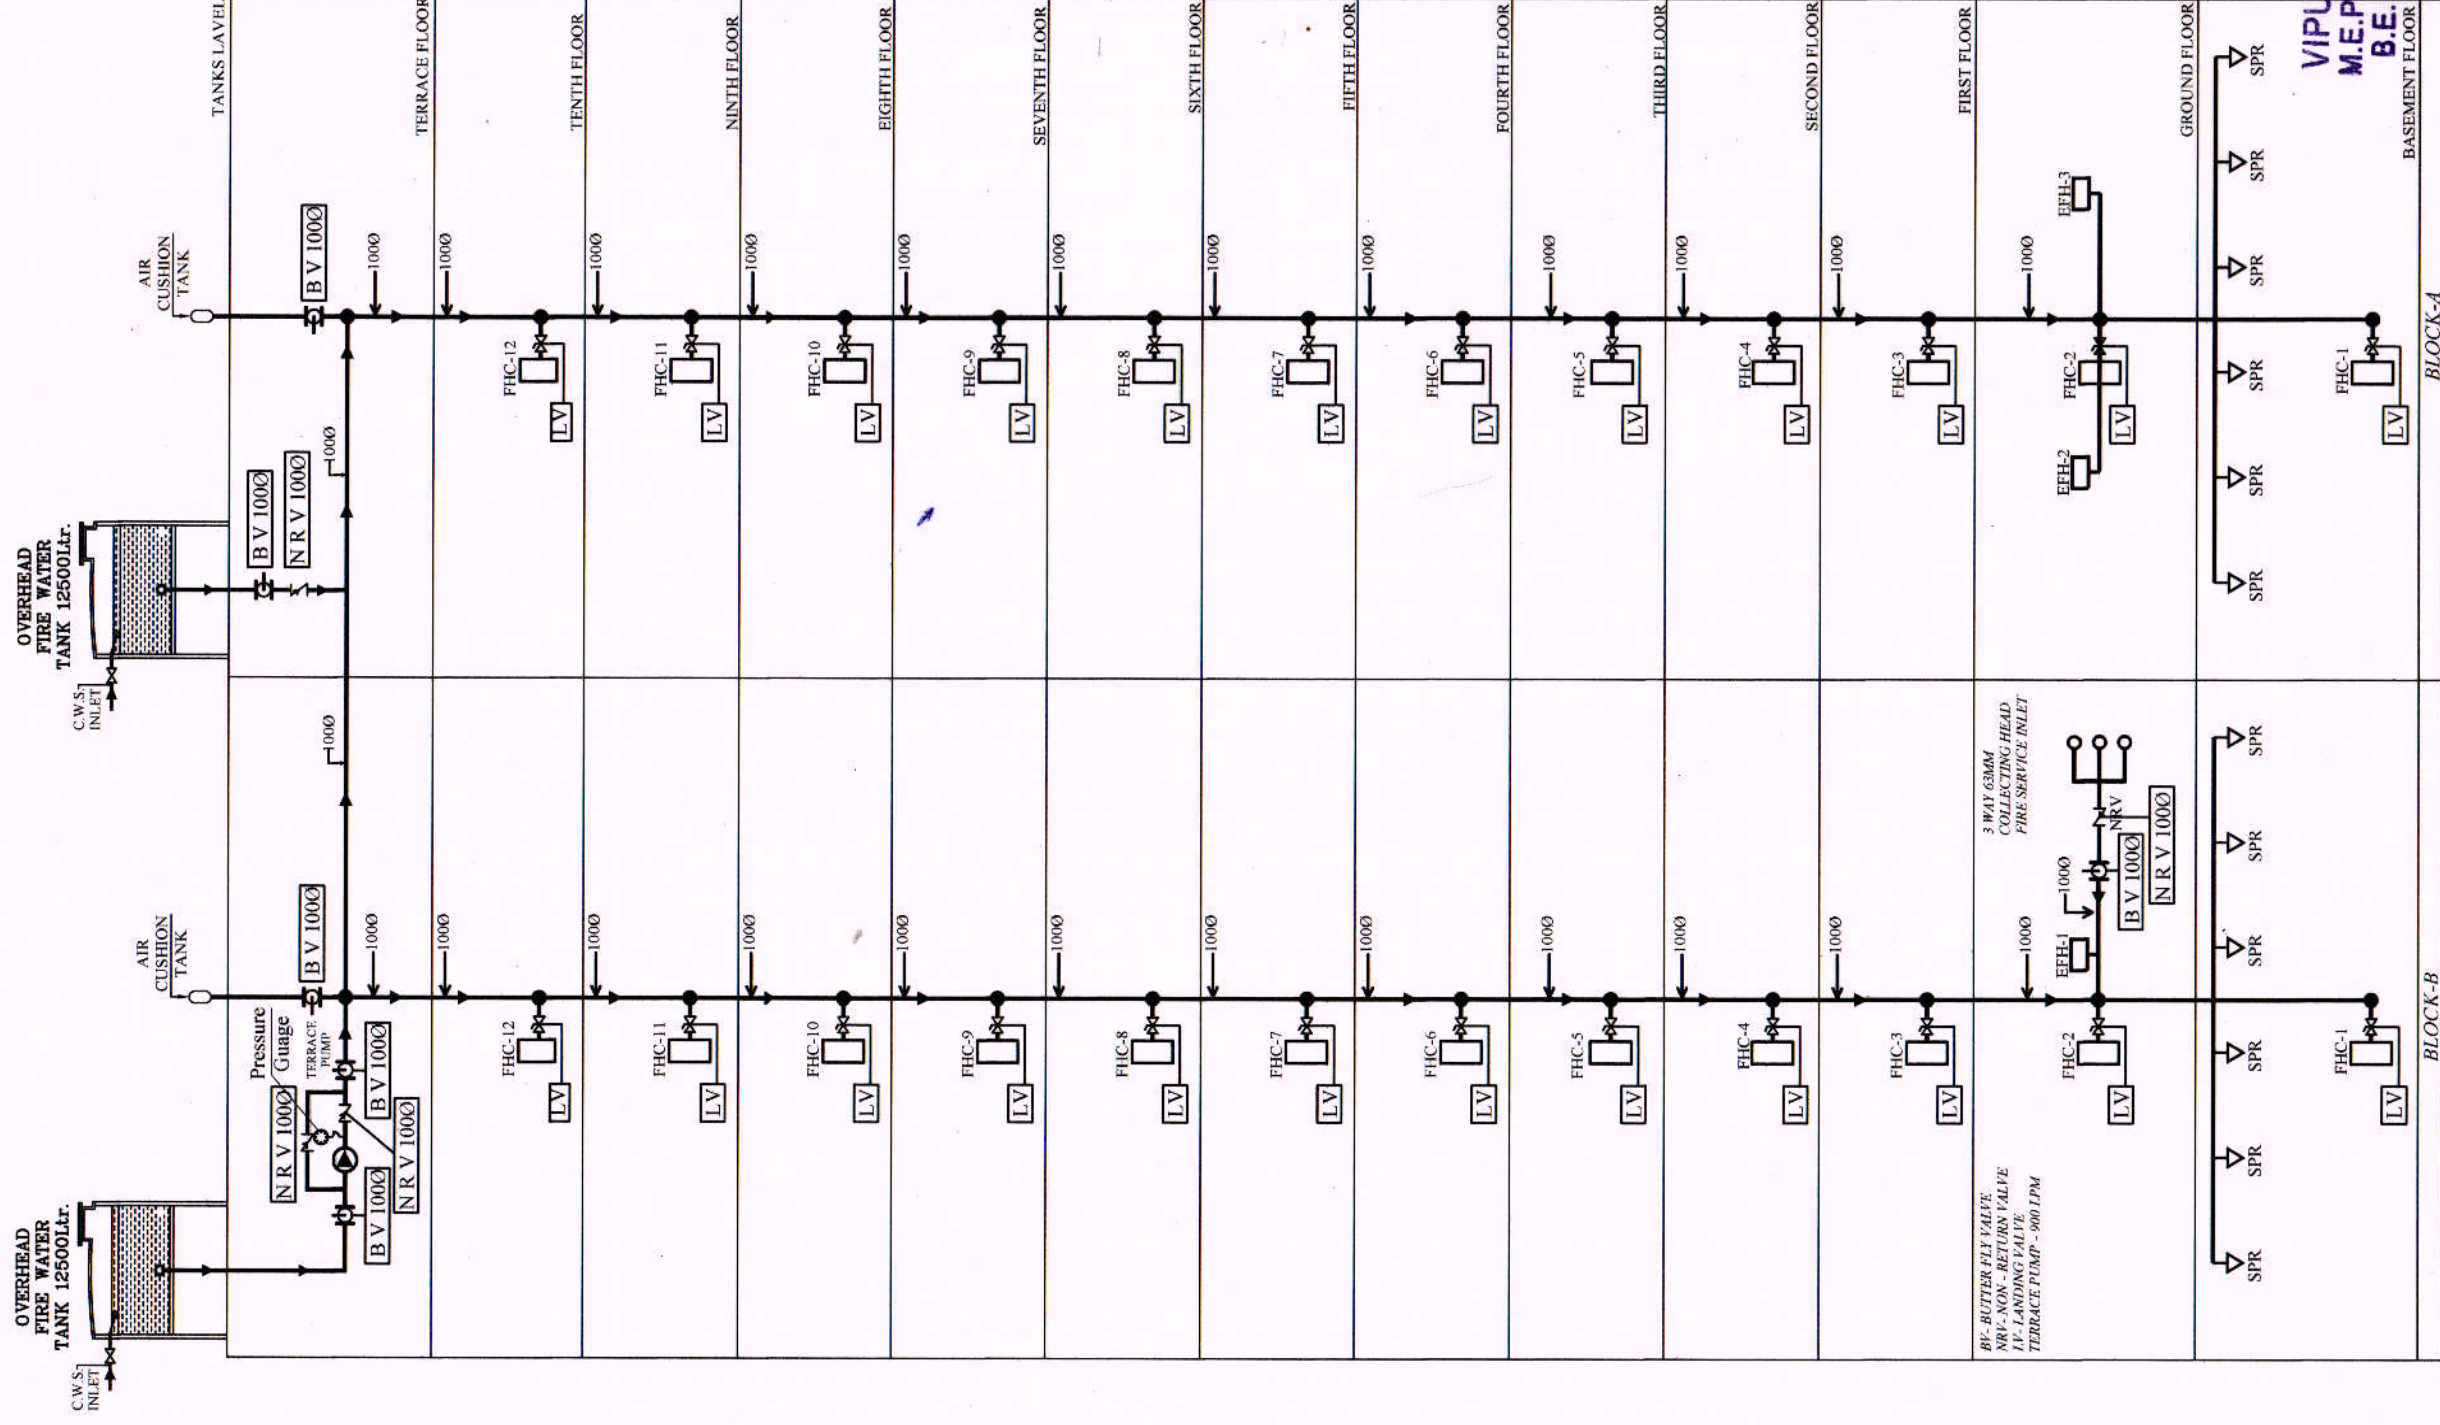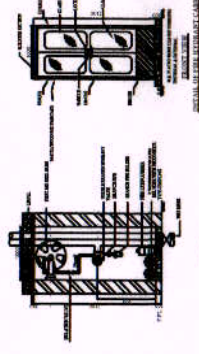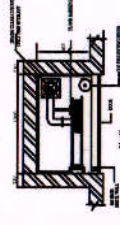

DRAWING

TYPICAL LEGAL FIRE HOSE CABINET

S.no.	Symbol	Description	Qty.	Size in mm
1.		Butter fly Valve	06	1000
2.		Non Return Valve	04	1000
3.		Landing Valve Single headed	24	630
4.		Pressure Gauge	01	
5.		FHC	24	
6.		External Fire Hose Cabinet	03	

PROJECT NAME

VARDHMAN SAMPADA

PROMOTER:

RICHWELL ENTERPRISES PRIVATE LIMITED

SERVICES CONSULTANT.:

VIPUL CONSULTING,
F-9 / 440, Keshav Marg Chitrakot Scheme, Jaipur
PH: 91-99146-10438 0141-344946 Mail: vipul8599@yahoo.com
REV. NO. 00, DATE: 04-03-2017

PROJECT:-

PROPOSED FLATS AT KHASRA
NO. : 1973, 1987/1 IN REVENUE-
VILLAGE- SIRSI, TEH-JAIPUR,

DRAWING TITLE:-


FIRE SCHEMATIC LAYOUT

ARCHITECT :

SPACE GRID

C-49, VIDYA APARTMENT, PARAS MARG,
BAPU NAGAR, JAIPUR - 302015.
PHONE: 9314918766, 9314510603

Vipul
VIPUL AGARWAL
M.E.P. CONSULTANT
B.E. ELECTRICAL

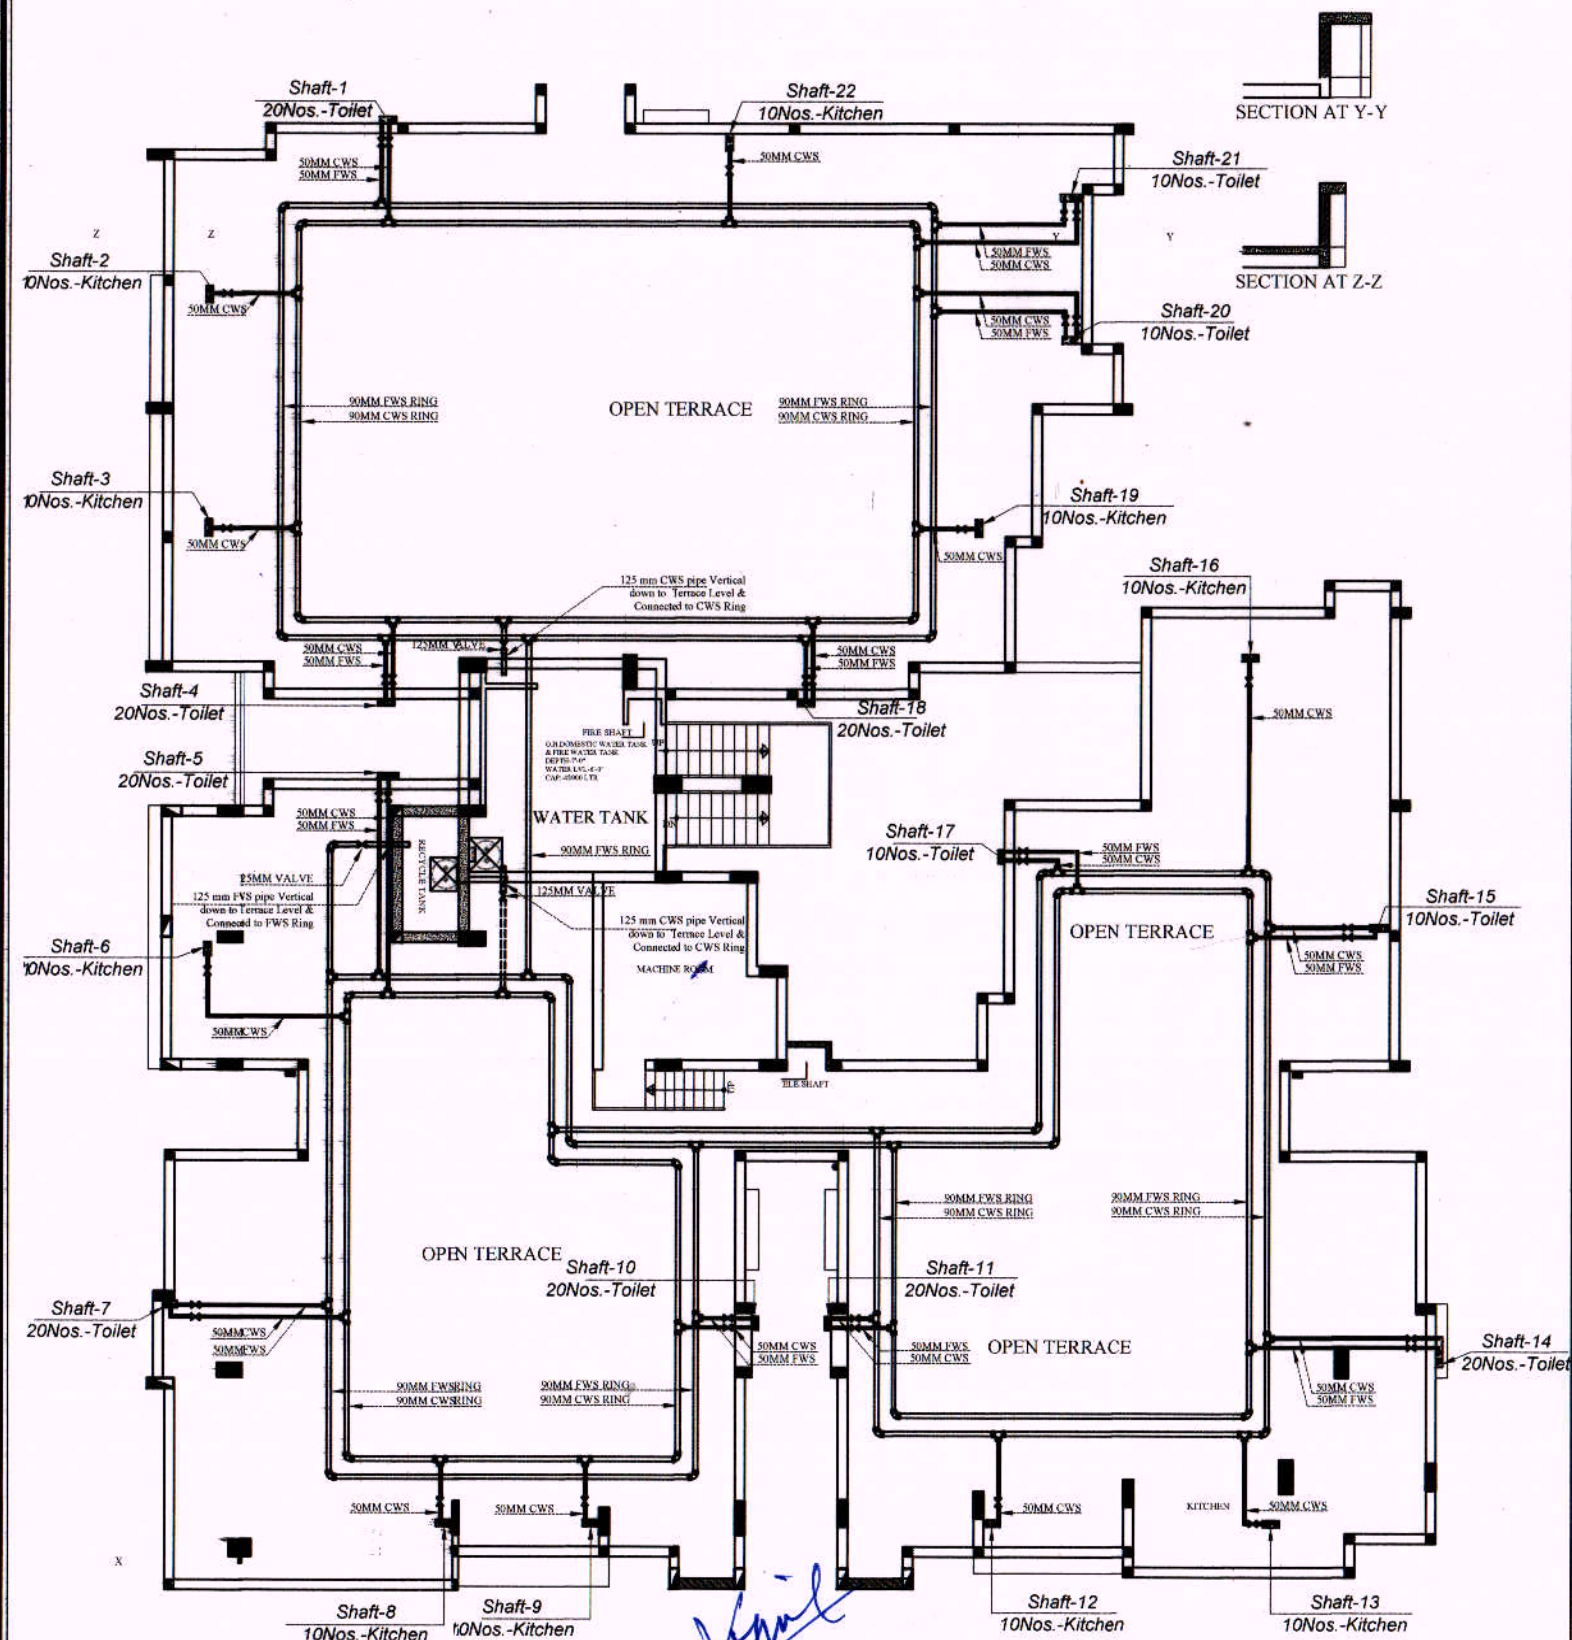

VIPUL AGARWAL
M.E.P. CONSULTANT
B.E. ELECTRICAL

Note:-
All Down take Water Supply Lines from Water Supply Ring Main are refer to Water Supply Schematic Diagram

Cold Water Pipes Detail :-

	SHAFT NO.
	Ø125 mm CWS
	Ø90 mm CWS
	Ø50 mm CWS
	Ø125 mm FWS
	Ø90 mm FWS
	Ø50 mm FWS
	VALVE
	KITCHEN
	TOILET
CWS	Cold Water Supply Pipe
FWS	Flushing Water Supply Pipe

DOWN TAKE PIPES DETAIL FRESH WATER SUPPLY 20NOS. TOILETS

NOTE:- DROP CWS PIPE IN SHAFT
50MM-10th,9th,8th,7th,6th FLOOR ONLY
40MM-5th,4th,3th FLOOR ONLY
32MM-2nd,1st FLOOR ONLY

10NOS. TOILETS

NOTE:- DROP CWS PIPE IN SHAFT
50MM-10th,9th,8th FLOOR ONLY
40MM-7th,6th,5th,4th FLOOR ONLY
32MM-3th,2nd FLOOR ONLY
25MM- 1st FLOOR

10NOS. KITCHEN

NOTE:- DROP CWS PIPE IN SHAFT
50MM-10th,9th FLOOR ONLY
40MM-8th,7th,6th,5th FLOOR ONLY
32MM-4th,3rd,2nd FLOOR ONLY
25MM- 1st FLOOR ONLY

DOWN TAKE PIPES DETAIL FLUSHING WATER SUPPLY 20NOS. TOILETS

NOTE:- DROP CWS PIPE IN SHAFT
50MM-10th,9th,8th,7th,6th FLOOR ONLY
40MM-5th,4th,3th FLOOR ONLY
32MM-2nd,1st FLOOR ONLY

10NOS. TOILETS

NOTE:- DROP CWS PIPE IN SHAFT
50MM-10th,9th,8th FLOOR ONLY
40MM-7th,6th,5th,4th FLOOR ONLY
32MM-3th,2nd FLOOR ONLY
25MM- 1st FLOOR

PROJECT NAME

VARDHMAN SAMPADA

PROMOTER:

RICHWELL ENTERPRISES
PRIVATE LIMITED

ARCHITECT :-

SPACE GRID
C-49, VIDYA
APARTMENT, PARAS MARG,
BAPU NAGAR, NEAR JANTA
STORE CIRCLE, JAIPUR-302015
PH-09314918766, 0141-4005506 (O)
Email -info.spacegrid@gmail.com

PROJECT:-

VARDHMAN's SAMPADA
PROPOSED FLAT'S AT
KHASRA NO. :-1973,1987/1 IN REVENUE-
VILLAGE- SIRSI, TEH.-JAIPUR,

DRAWING:

B- BLOCK- TERRACE
WATER SUPPLY RING PLAN

DRN.

SUNIL

APPD.

SANJAY

DATE :-

27/06/17

REF.



SERVICES CONSULTANT:

VIPUL CONSULTING,
F 9 / 440 , Keshav Marg Chitrakut Scheme, Jaipur
PH:91-0-93146-10438 , 0141-2440946
Mail: vipul8599@yahoo.com
REV. NO. 000, DATE:-27-06-2017

VIPUL AGARWAL
M.E.P. CONSULTANT
B.E. ELECTRICAL

LEGENDS:

Mounting Height	No.	ID	Symbol	Description
IN RCC SLAB		CONDUIT		Rigid PVC Conduit 25mm/1.0 sqmm wire for Light points
IN RCC SLAB		CONDUIT		Rigid PVC Conduit 25mm/2.5 sqmm wire for Light Circuits
IN RCC SLAB		CONDUIT		Rigid PVC Conduit 25mm/4.00 sqmm wire for POWER Circuits
IN RCC SLAB		CONDUIT		Submain wire to DB from Main Panel on Ground Floor in 1 nos. 32 mm dia conduits
IN RCC SLAB		CONDUIT	FIRE	Rigid PVC Conduit 25mm2 core 1.0 sq mm armoured cable for Fire Alarm
IN RCC SLAB		CONDUIT	CCTV	Rigid PVC Conduit 25mm/3+1 coaxial wire for Security Camera (C.C.T.V.).
CEILING	79	TL/C		1X40W CEILING TUBELIGHT
CEILING	01			DEEP JUNCTION 4 WAY
+42"	01	SB		SWITCH BOARD
+60"	01	MCB DB		MCB DISTRIBUTION BOARD
+42"	01	MCP		MANUAL CALL POINT
+90"	01	H0		HOOTER POINT
	04	CCTV		CCTV CAMERA

SERVICES CONSULTANT:
VIPUL CONSULTING,
F 9 / 440 , Keshav Marg Chitrakut Scheme,Jaipur
PH:91-0-93146-10438 ,0141-2440946 Mail:vipul8599@yahoo.com
REV. NO. 000, DATE:-24-09-2015

ARCHITECT:-

SPACE GRID

C-49, VIDYA APARTMEN, PARAS MARG,
BAPU NAGAR, JAIPUR - 302015.
PHONE: 9314918766, 9314510603

PROJECT NAME

VARDHMAN SAMPADA

PROMOTER:

RICHWELL ENTERPRISES
PRIVATE LIMITED

PROJECT:-

VARDHMAN's SAMPADA
PROPOSED FLAT'S AT KHASRA
NO. :-1973,1987/1 IN REVENUE-
VILLAGE- SIRSI,TEH.-JAIPUR,

NAME OF DRAWING:

BLOCK-A
BASEMENT FLOOR
ELECTRIC & LV CONDUIT PLAN

APPD BY:-

VIPUL AGARWAL

DATE:-

24-09-2015


DEALT BY:-

SANJAY


DRAWN BY:-

PAWAN

REF.

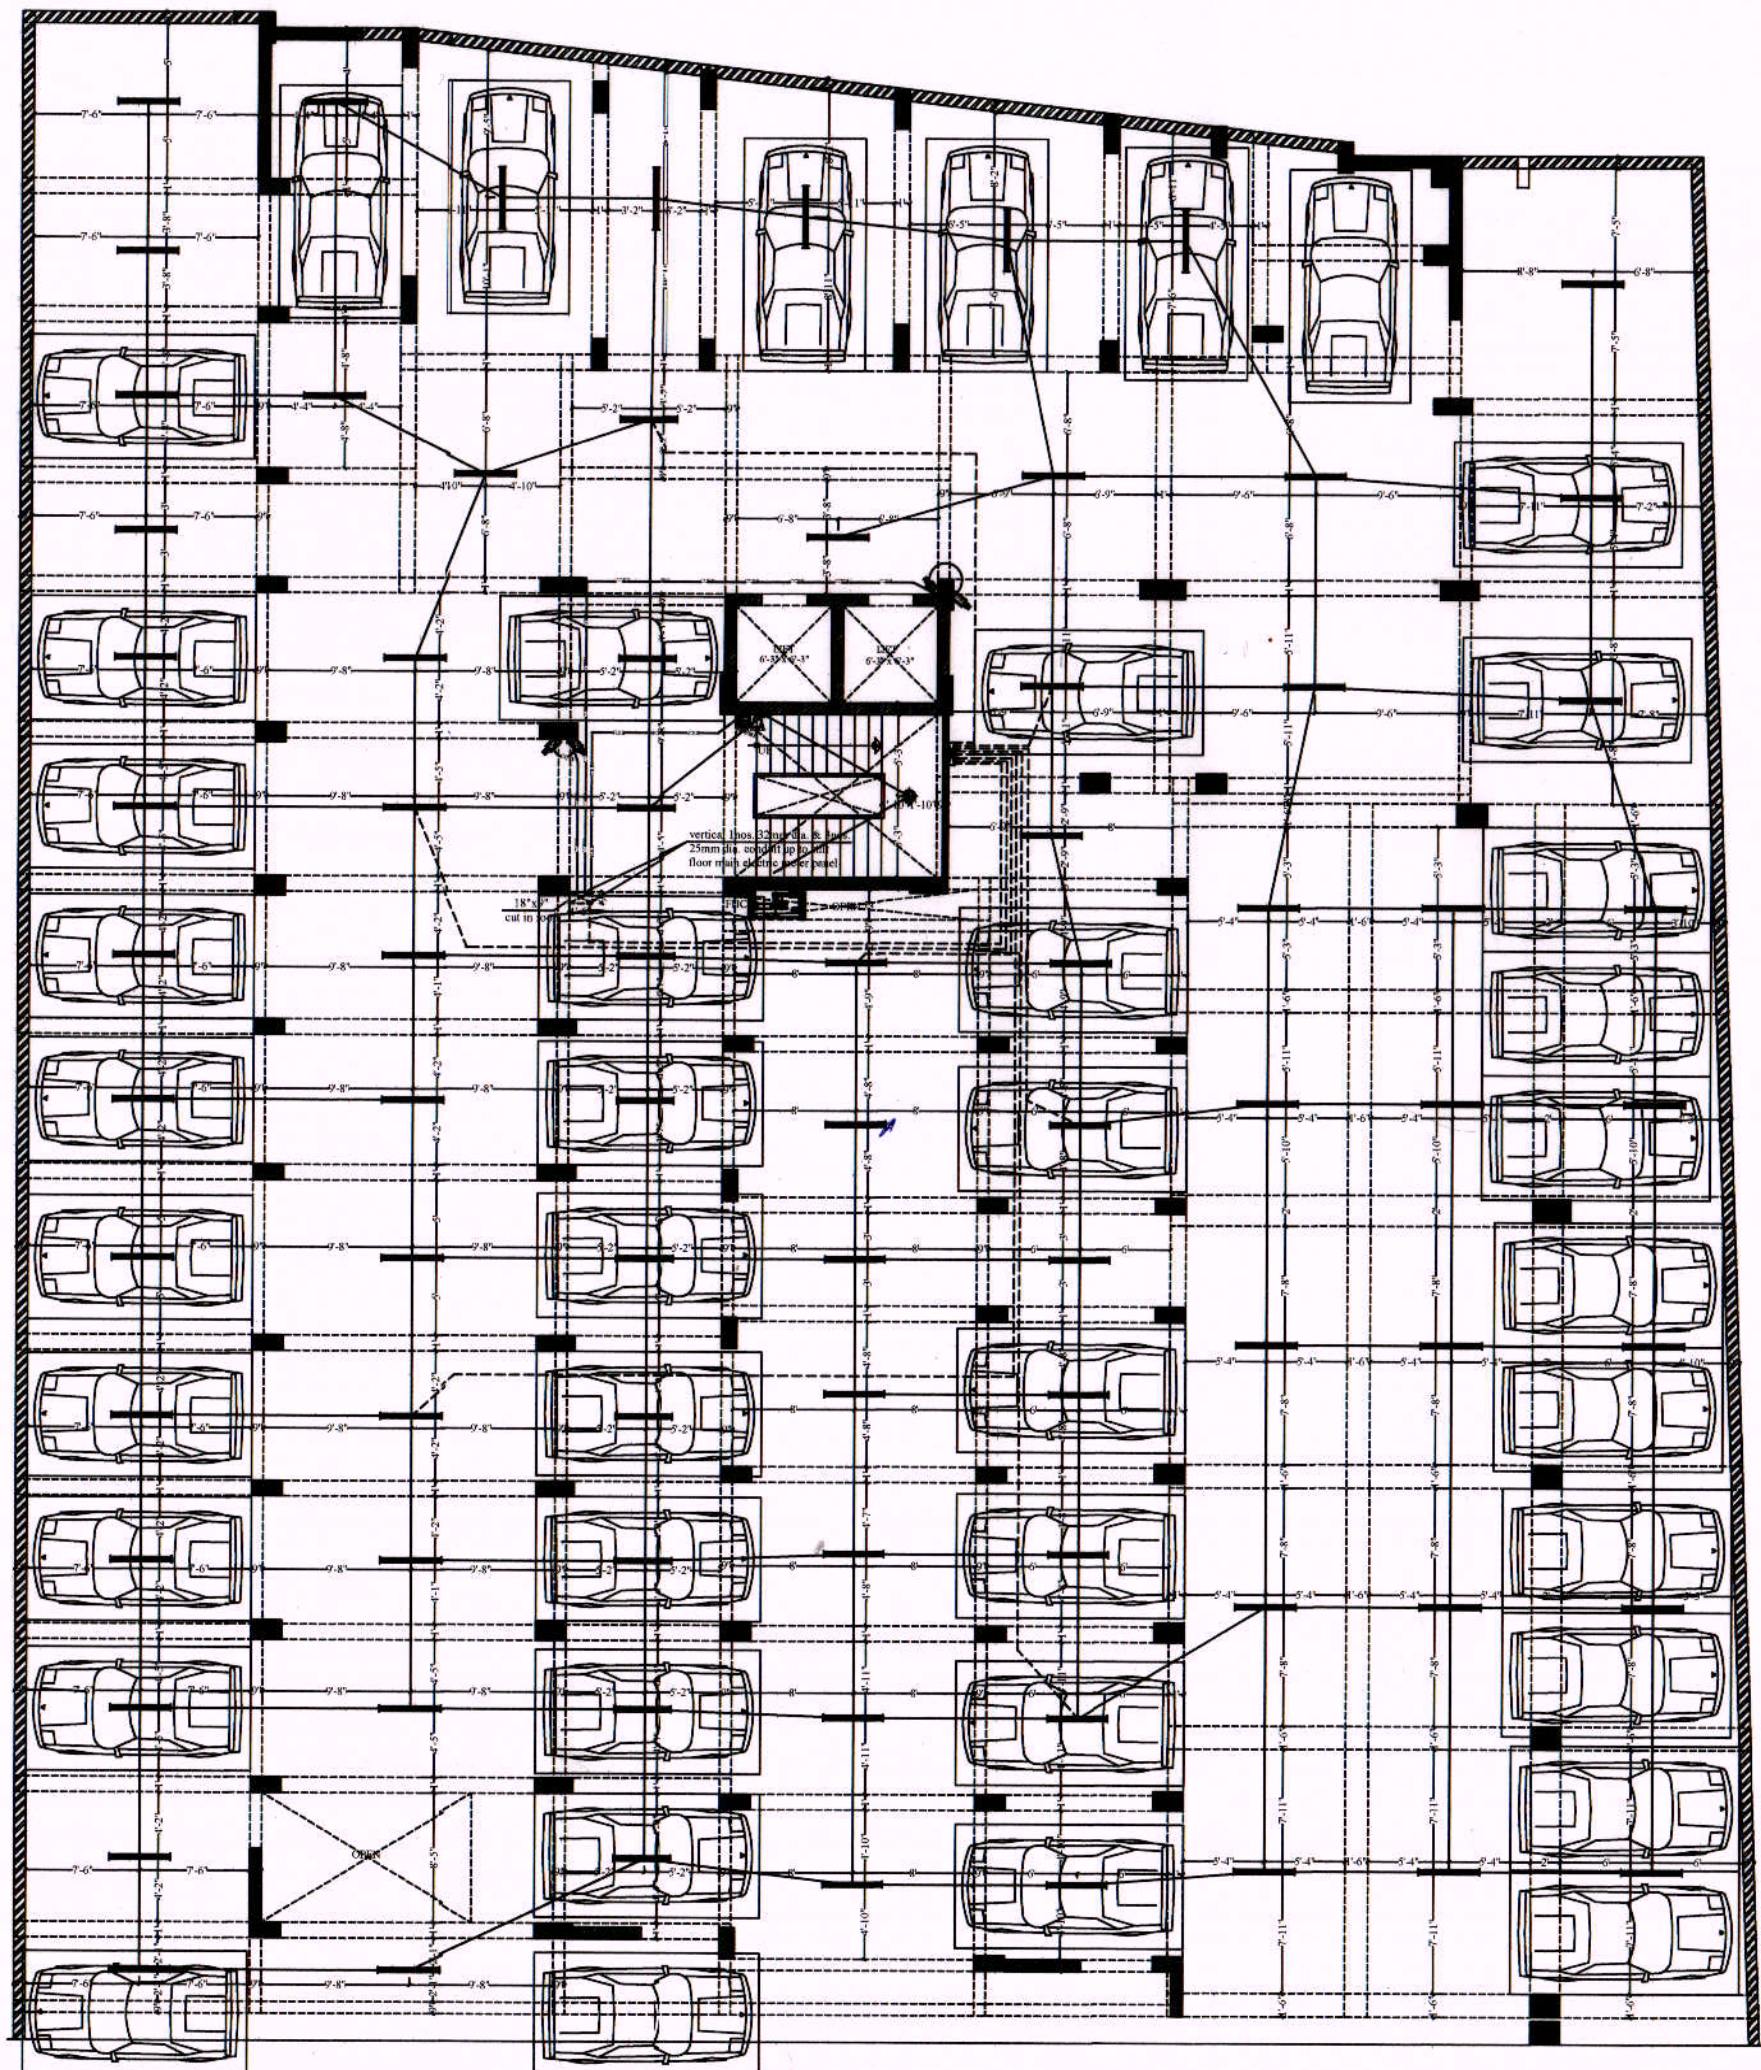

VIPUL AGARWAL
M.E.P. CONSULTANT
B.E. ELECTRICAL

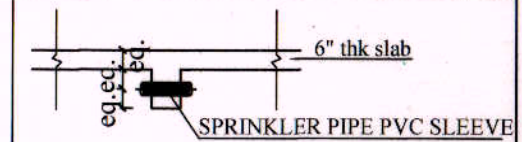

TYPICAL SLEEVE SECTION

LEGENDS:

Mounting Ht.	Qty.	Symbol	Description
CEILING	86		SPRINKLER POINT
CEILING	185mtr		25 MM DIA. MS PIPE
CEILING	40mtr		32 MM DIA. MS PIPE
CEILING	35mtr		40 MM DIA. MS PIPE
CEILING	30mtr		50 MM DIA. MS PIPE
CEILING	22mtr		65 MM DIA. MS PIPE
CEILING	07mtr		80 MM DIA. MS PIPE
CEILING	01mtr		100 MM DIA. MS PIPE
CEILING			100 MM DIA. SLEEVE
CEILING			150 MM DIA. SLEEVE
	01		CONTROL VALVE

SERVICES CONSULTANT:
VIPUL CONSULTING,
F 9 / 440 , Keshav Marg Chitrakut Scheme, Jaipur
PH: 91-0-93146-10438, 0141-2440946 Mail: vipul8599@yahoo.com
REV. NO. 000, DATE: 24-09-2015

PROJECT NAME

VARDHMAN SAMPADA

PROMOTER:

RICHWELL ENTERPRISES PRIVATE LIMITED

ARCHITECT:-

SPACE GRID

C-49, VIDYA APARTMENT, PARAS MARG,
BAPU NAGAR, JAIPUR - 302015.
PHONE: 9314918766, 9314510603

PROJECT:-

PROPOSED FLAT'S AT KHASRA
NO. :- 1973, 1987/1 IN REVENUE-
VILLAGE- SIRSI, TEH.- JAIPUR,

NAME OF DRAWING:

BLOCK-A
BASEMENT FLOOR
SPRINKLER PLAN

APPD BY:-

VIPUL AGARWAL

DATE:-

24-09-2015


DEALT BY:-


SANJAY

DRAWN BY:-

PAWAN


REF.

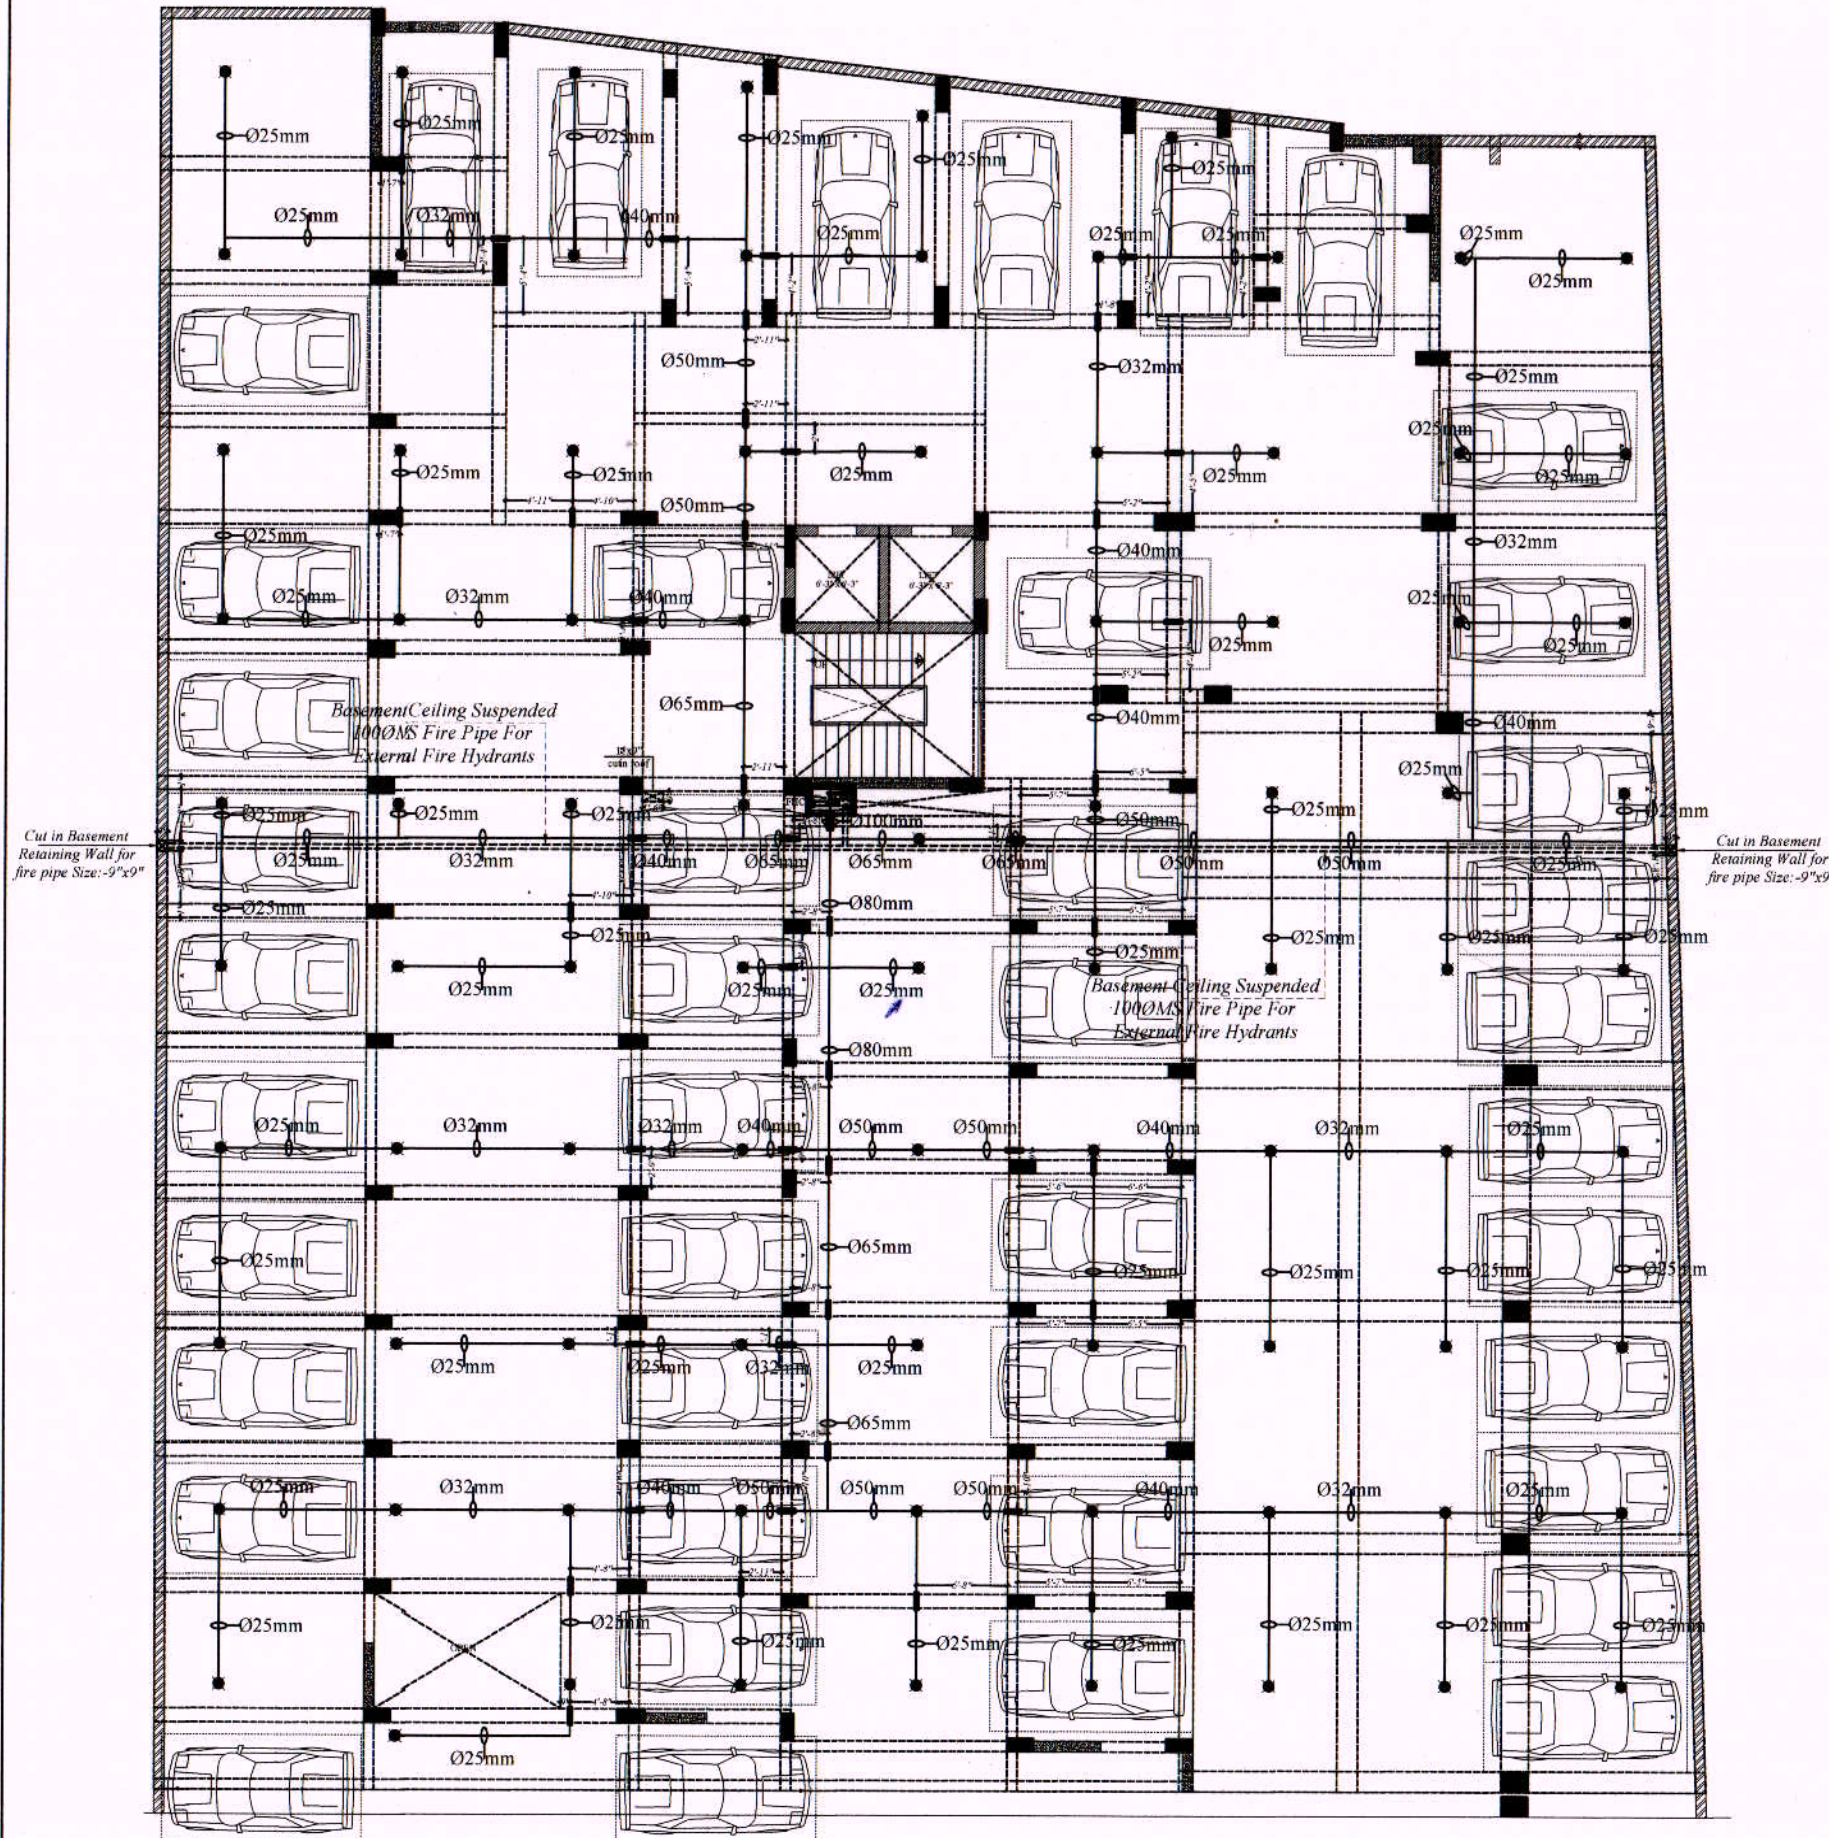

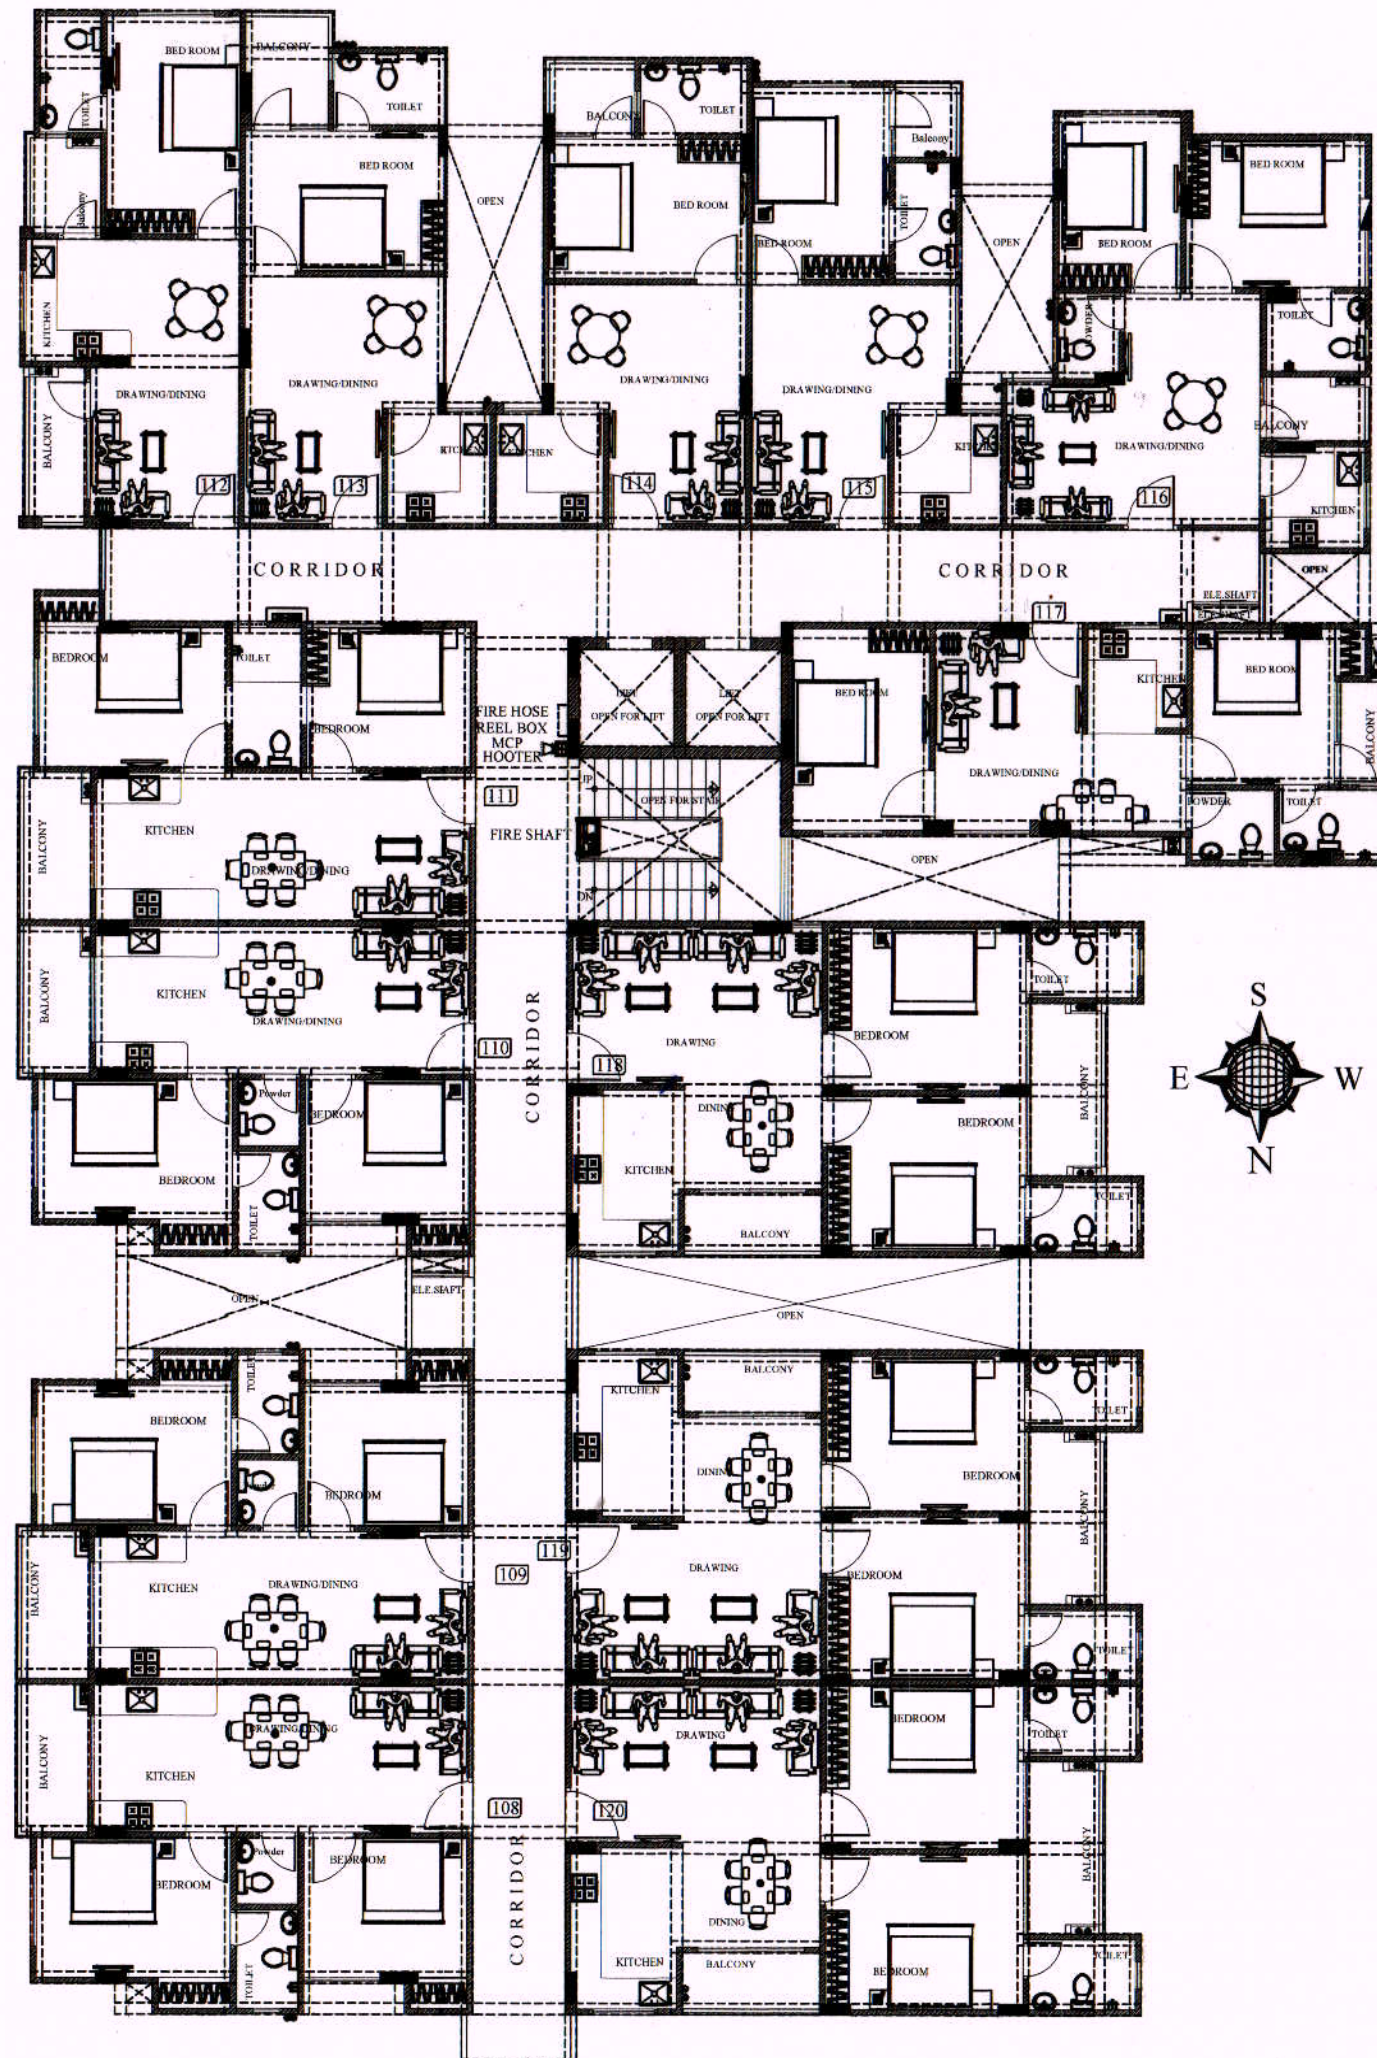

Vipul
VIPUL AGARWAL
M.E.P. CONSULTANT
B.E. ELECTRICAL

5mm OUTLET NOZZLE

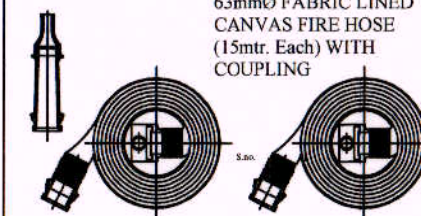

LEGENDS:

Mounting Height	No.	I.D.	Symbol	Description
IN CEILING				2X1.5 sq. mm Copper Wire For Fire Alarm
+42"	01	MCP		MANUAL CALL POINT
+90"	01	HO		HOOTER POINT

SERVICES CONSULTANT:
 VIPUL CONSULTING,
 F 9 / 440, Keshav Marg Chitrakul Scheme, Jaipur
 PH: 91-0-93146-10438, 0141-2440946 Mail: vipul8599@yahoo.com
 REV. NO. 00, DATE: -04-03-2017

ARCHITECT:-

SPACE GRID

C-49, VIDYA APARTMENT, PARAS MARG,
 BAPU NAGAR, JAIPUR - 302015.
 PHONE: 9314918766, 9314510603

PROJECT:-

VARDHMAN'S SAMPADA
 PROPOSED FLAT'S AT KHASRA
 NO. :-1973, 1987/1 IN REVENUE-
 VILLAGE- SIRSI, TEH.-JAIPUR,

NAME OF DRAWING:

BLOCK-A
 TYPICAL FLOOR PLAN

APPD BY:-

VIPUL AGARWAL

DATE:-

04-03-2017

DEALT BY:-


SANJAY

REF.



DRAWN BY:-

VIJESH

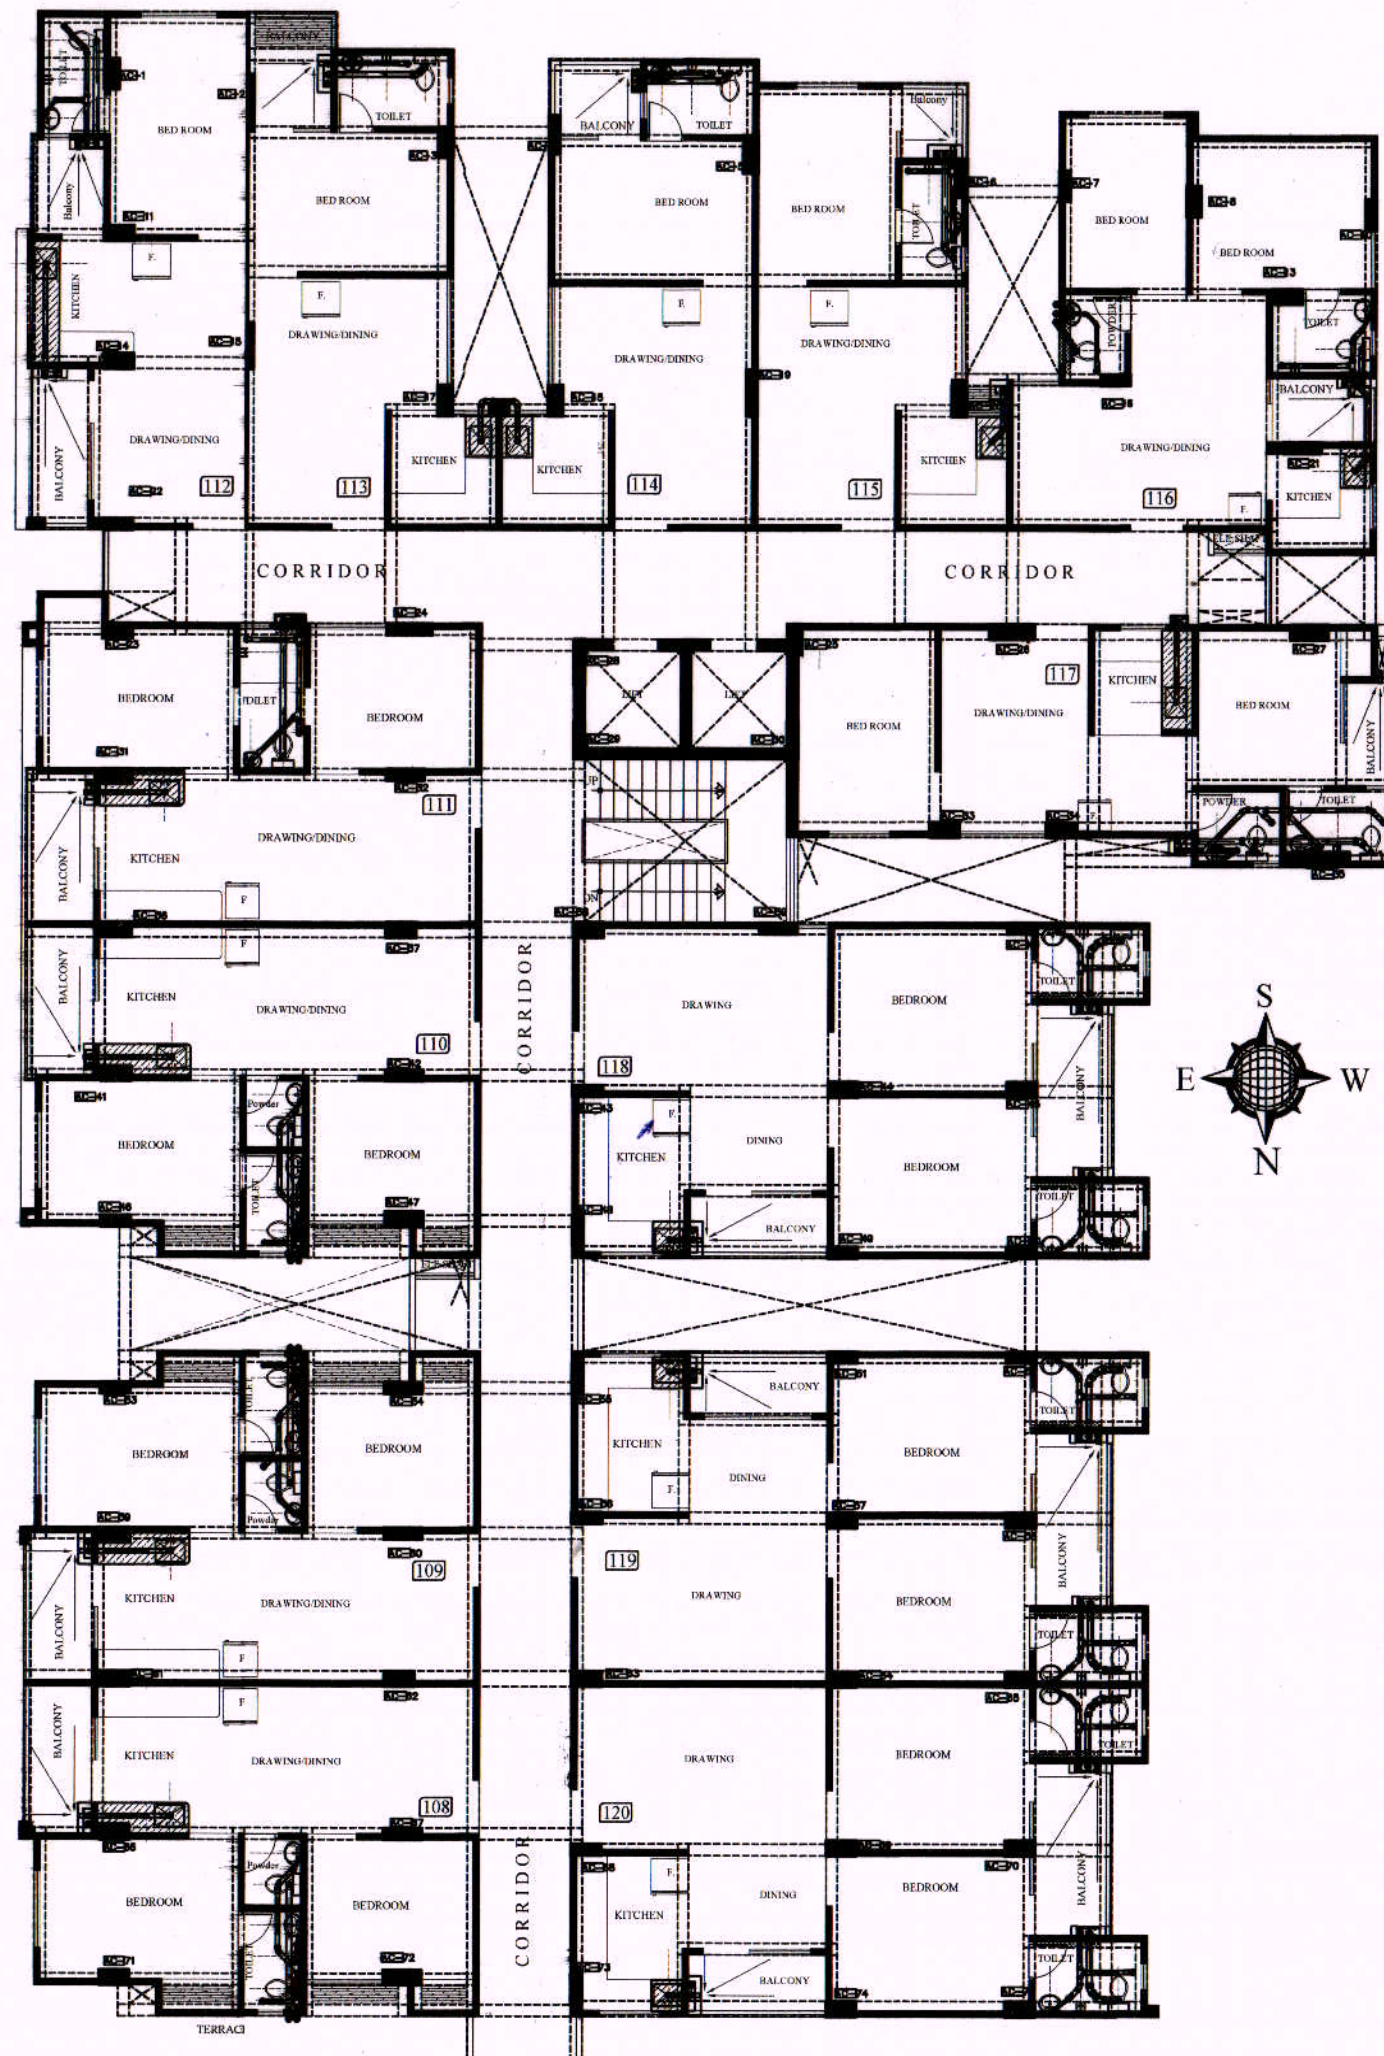

Vipul
VIPUL AGARWAL
M.E.P. CONSULTANT
B.E. ELECTRICAL

SYMBOL	DESCRIPTION
	110 mm Soil Waste Water Pipe
	110 mm Waste Water Pipe
	110 mm Rain Water Pipe
	110 mm Soil Waste Water Pipe
	110 mm Waste Water Pipe
	110 mm Rain Water Pipe
	75 mm Waste Water Pipe Internal Toilet
	75 mm Rain Water Pipe
	50mm Waste Water Pipe Bottle Trap
	50mm Waste Water Pipe
	Nahani Trap
	Multi Trap
	Vertical MS Grating Cover
	Flow Direction
	6" Platform Raise

SERVICES CONSULTANT:
 VIPUL CONSULTING,
 F 9 / 440 , Keshav Marg Chitrakut Scheme, Jaipur
 PH: 91-0-93146-10438 , 0141-2440946 Mail: vipul8599@yahoo.com
 REV. NO. 000, DATE: -07-06-2016

ARCHITECT:-
SPACE GRID
 C-49, VIDYA APARTMEN, PARAS MARG,
 BAPU NAGAR, JAIPUR - 302015.
 PHONE: 9314918766, 9314510603


PROJECT NAME
VARDHMAN SAMPADA

PROMOTER:
**RICHWELL ENTERPRISES
 PRIVATE LIMITED**

PROJECT:-
 PROPOSED FLAT'S AT KHASRA
 NO. :-1973, 1987/1 IN REVENUE-
 VILLAGE- SIRSI, TEH.-JAIPUR,

NAME OF DRAWING:
**BLOCK-A
 TYPICAL FLOOR INTERNAL
 DRAINAGE PLAN**

APPD BY:- VIPUL AGARWAL	DATE:- 07-06-2016
DEALT BY:- SANJAY	REF. S E W N
DRAWN BY:- RAAJ	

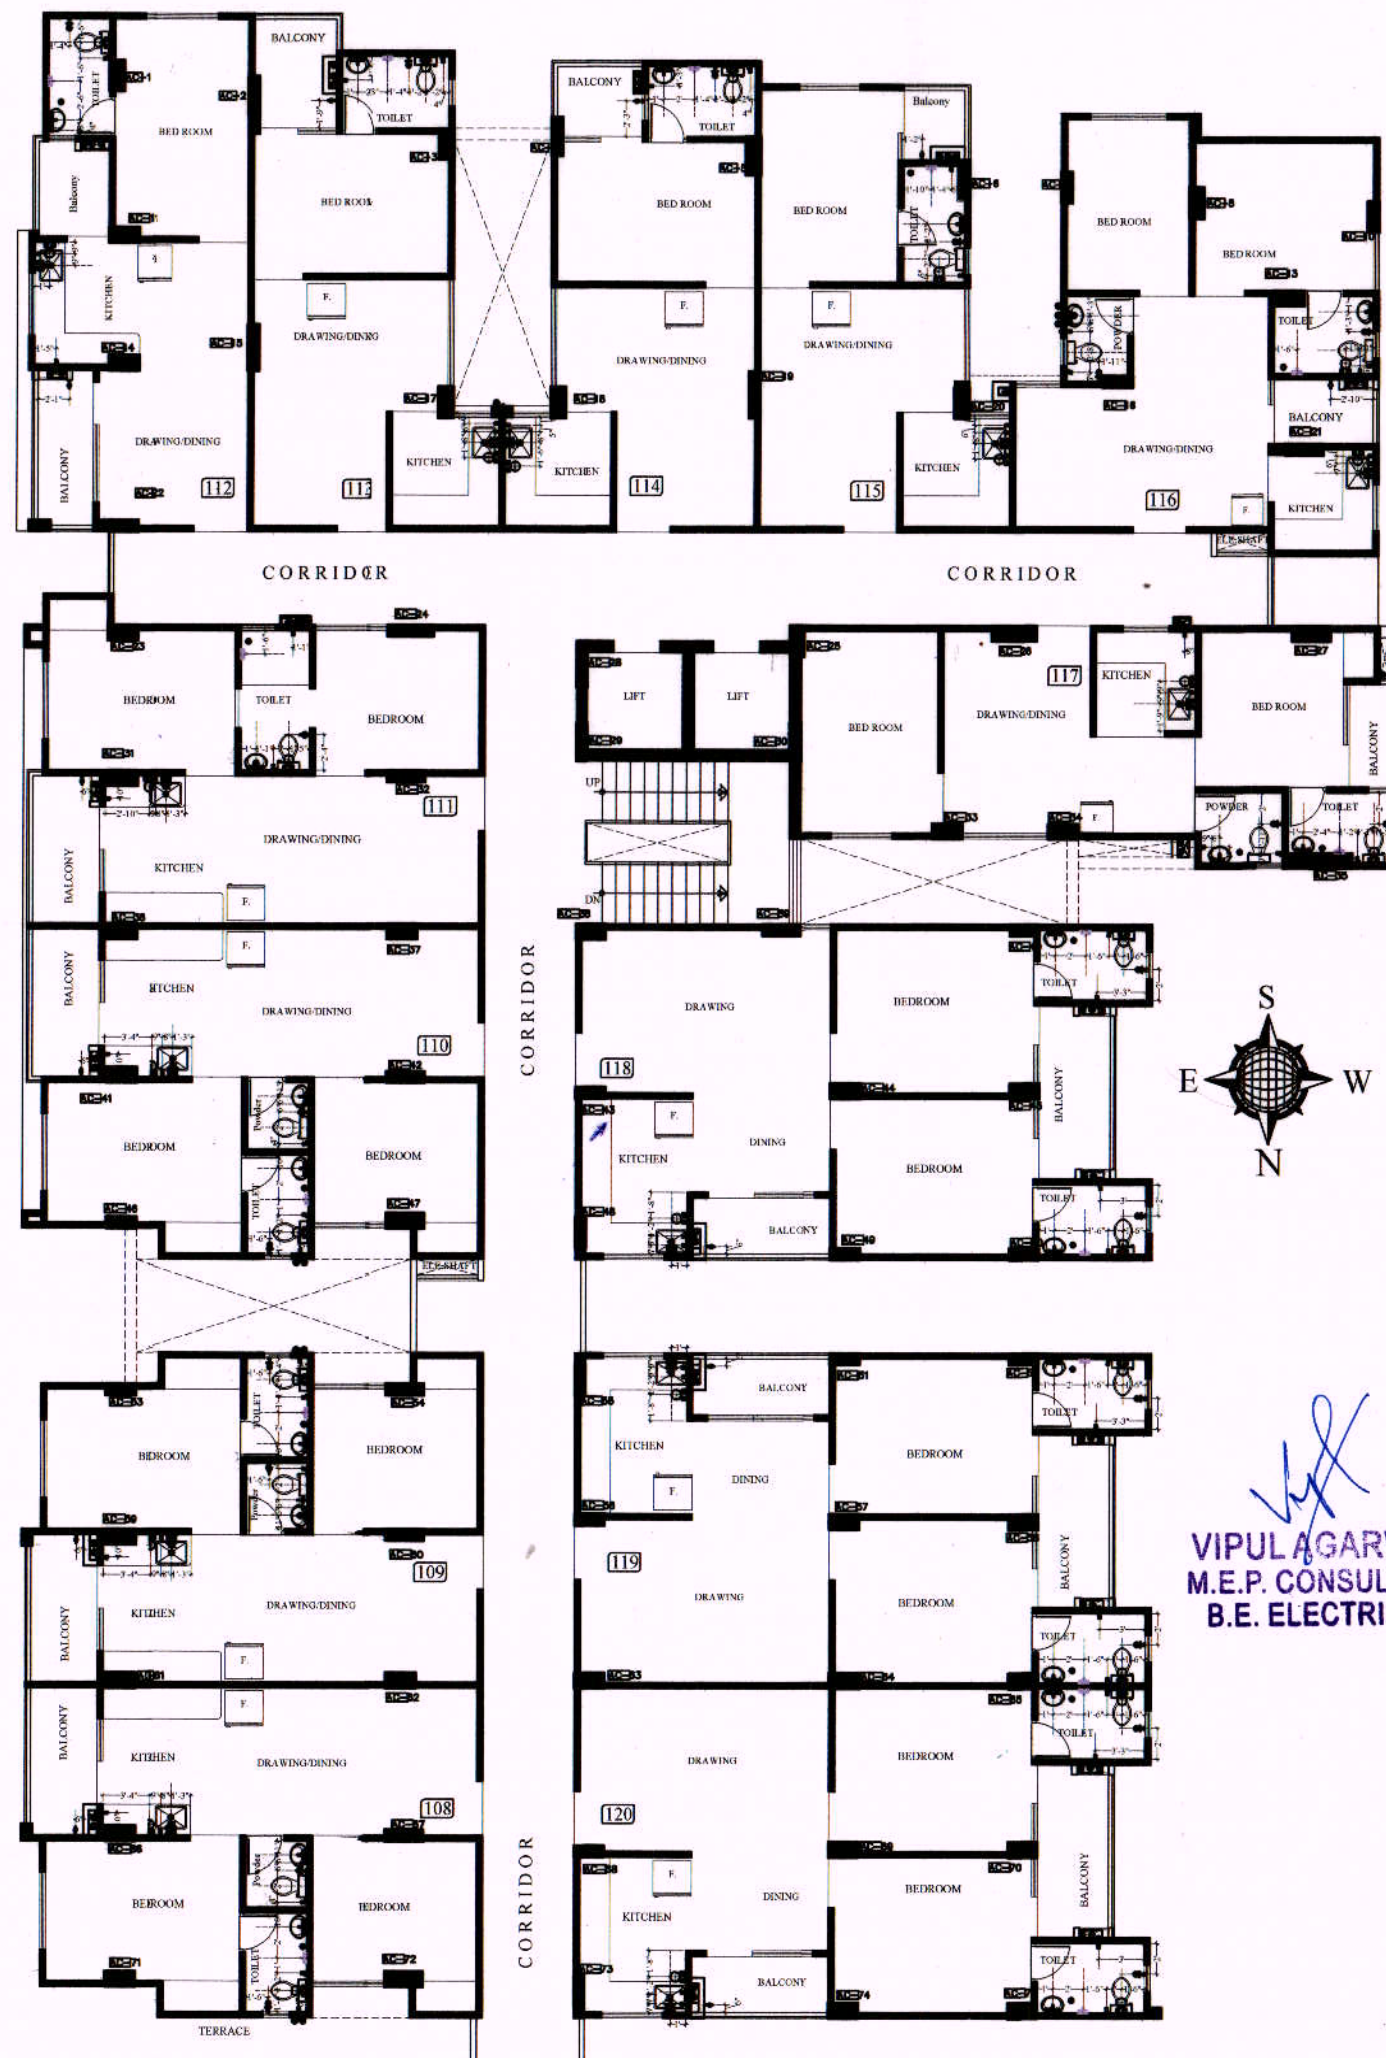

STANDARDS SANITARY APPLIANCES HEIGHTS/AS PER AR DETAILS	
TOILET/KITCHEN	All Heights For Finish Floor Lvl
1 WASH BASIN MIXER	+800MM
2 WASH BASIN ANGLE VALVE	+450MM
3 BOTTLE TRAP	+450MM
4 TOWEL RING	+950MM
5 MIRROR 450X450mm(BOTTOM)	+950MM
6 OVER HEAD SHOWER	+2025MM
7 WALL MIXER DIVERTOR	+1000MM
8 TAP FOR BATH AREA	+770MM
9 TAP FOR BALCONY/ WASHING	+450MM
10 SOAP DISH	+1000MM
11 TOWEL RAIL	+1500MM
12 WC WALL MOUNTED(BOTTOM)	+400MM
13 FLUSH VALVE	+900MM
14 TAP FOR WC	+300MM
15 PAPER HOLDER	+450MM
16 ANGLE VALVE FOR GYSER	+1950MM
17 KITCHEN SINK MIXER	+1000MM
18 ANGLE VALVE FOR GYSER	+1950MM
19 ANGLE VALVE FOR WATER PURIFIER	+1500MM
20 CONCEALED STOP COCK	+2100MM

LEGEND:

SYMBOL	DESCRIPTION
	Central Hole Basin Mixture Standard with 2 nos. Angle valve
	2 Way Bib Cock
	Angle Valve For Cistern
	Wall Mixer with Hand with Over Head Shower with Arm
	2 Nos. Angle valve For Gyser
	Concealed Stop Cock
	Aqua Guard Valve
	Tap For Washing Machine
	Sink Mixture
	Basin Angle Valve
	Urinal Angle Valve
	Floor Trap
	Cold Water Supply
	Hot Water Line - Internal
	Cold Water Line - Internal

SERVICES CONSULTANT:
VIPUL CONSULTING,
F 9/440, Keshav Marg Chitrakut Scheme, Jaipur
PH: 91-0-93146-10438, 0141-2440946, Mail: vipul8599@yahoo.com
REV. NO. 000, DATE: 09-06-2016

ARCHITECT:-

SPACE GRID

C-49, VIDYA APARTMENT, PARAS MARG,
BAPU NAGAR, JAIPUR - 302015.
PHONE: 9314918766, 9314510603

PROJECT NAME

VARDHMAN SAMPADA

PROMOTER:

RICHWELL ENTERPRISES
PRIVATE LIMITED

PROJECT:-

PROPOSED FLAT'S AT KHASRA
NO. :-1973, 1987/1 IN REVENUE-
VILLAGE- SIRSI, TEH.-JAIPUR,

NAME OF DRAWING:

BLOCK-A
TYPICAL FLOOR INTERNAL
PLUMBING PLAN

APPD BY:-

VIPUL AGARWAL

DATE:-

09-06-2016

DEALT BY:-

SANJAY


REF.



DRAWN BY:-

RAAJ

VIPUL AGARWAL
M.E.P. CONSULTANT
B.E. ELECTRICAL

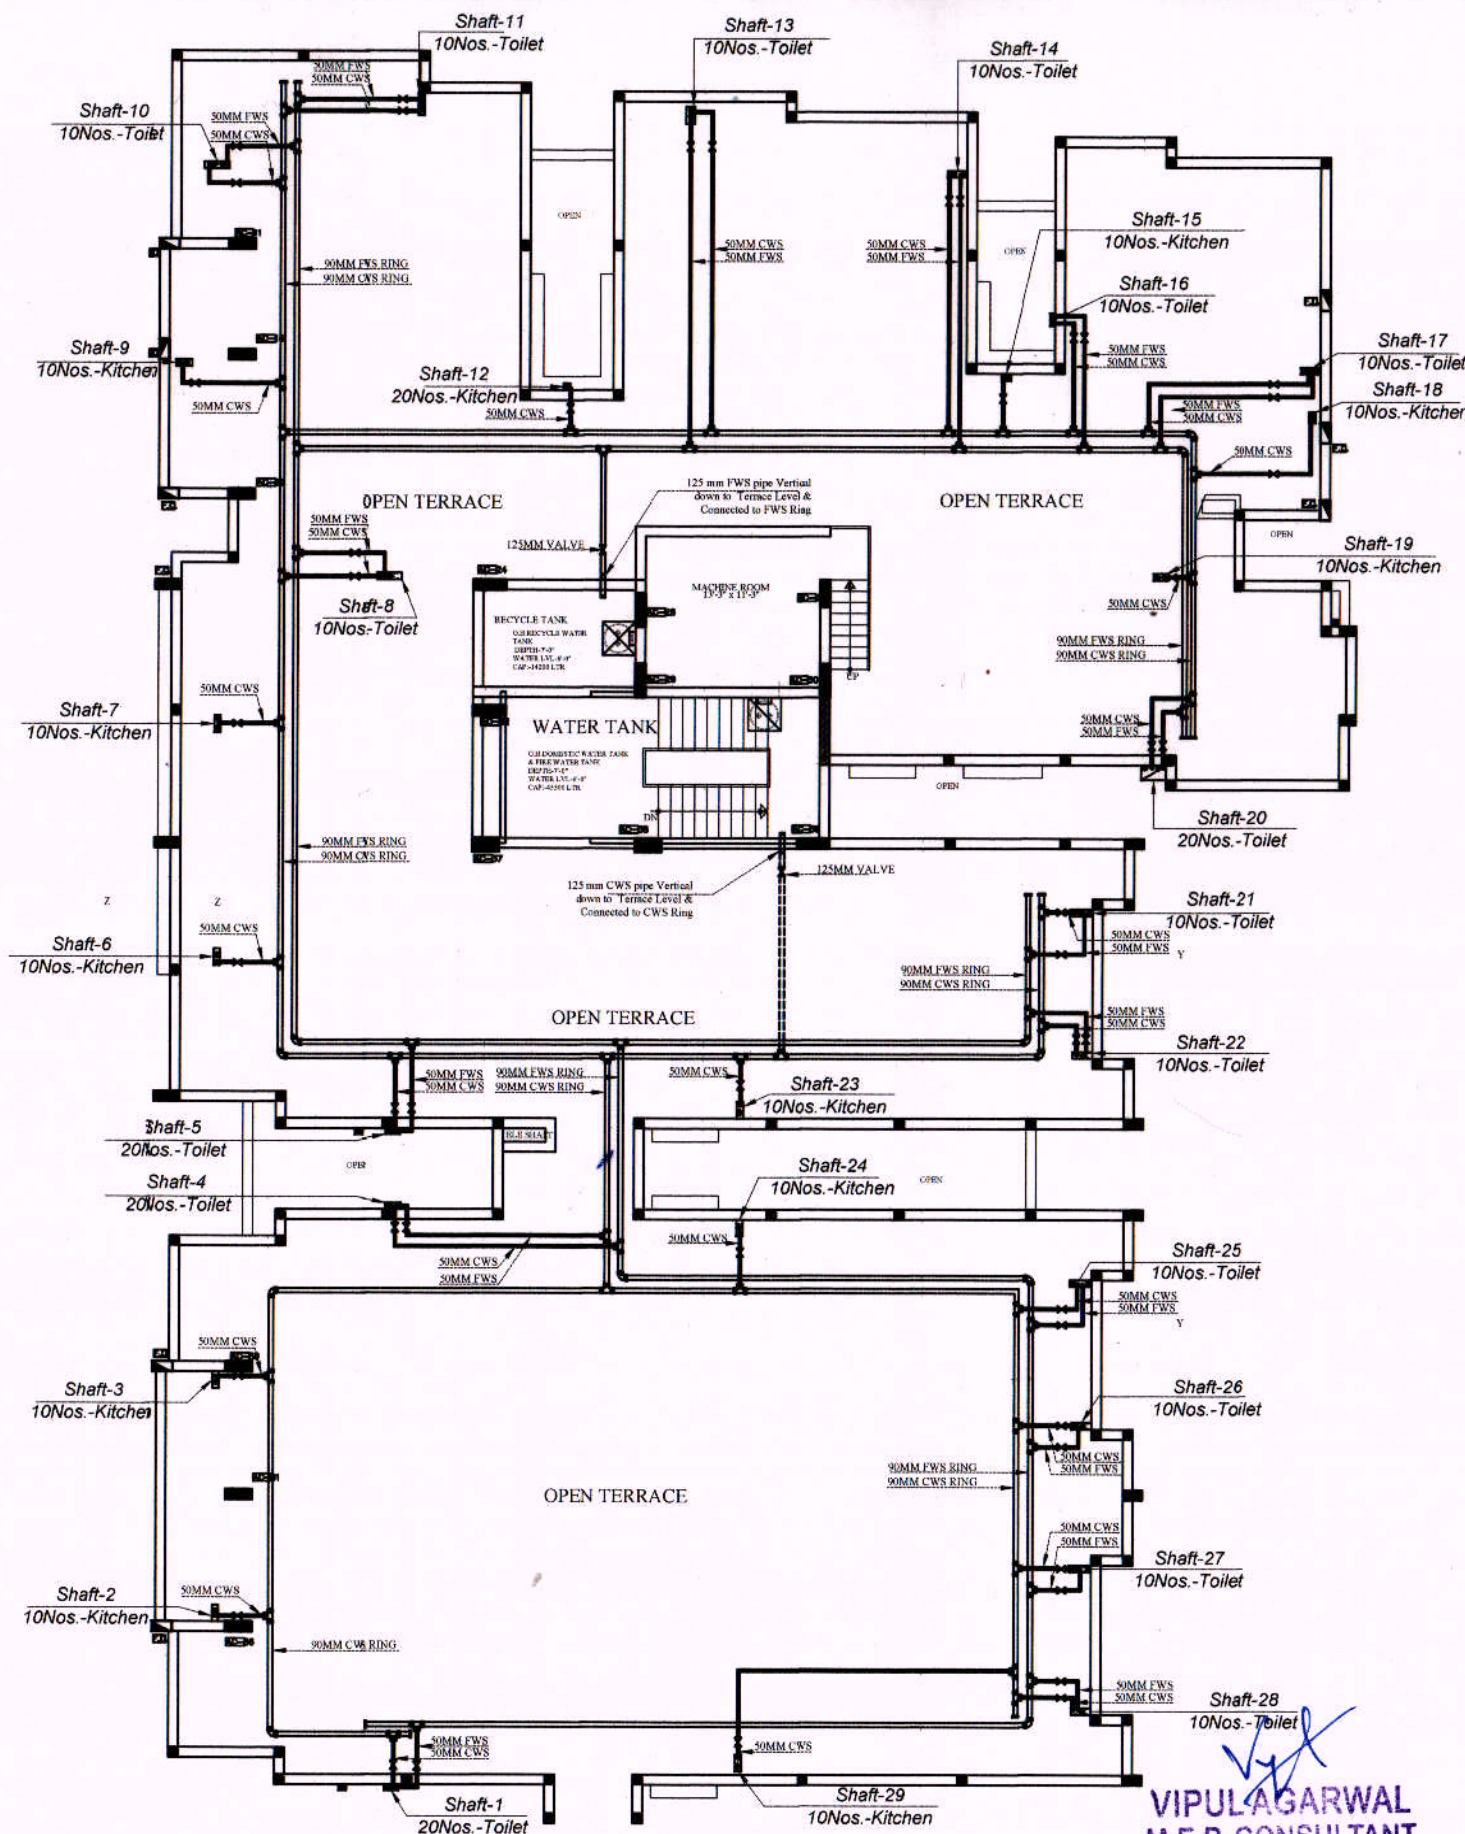

Note:-
All Down take Water Supply Lines from Water Supply Ring Main are refer to Water Supply Schematic Diagram

Cold Water Pipes Detail :-

SHAFT NO.	
Ø125 mm CWS	
Ø90 mm CWS	
Ø50 mm CWS	
Ø125 mm FWS	
Ø90 mm FWS	
Ø50 mm FWS	
VALVE	
KITCHEN	
TOILET	
CWS	Cold Water Supply Pipe
FWS	Flushing Water Supply Pipe

DOWN TAKE PIPES DETAIL FRESH WATER SUPPLY

20NOS. TOILETS

NOTE:- DROP CWS PIPE IN SHAFT
50MM-10th,9th,8th,7th,6th FLOOR ONLY
40MM-5th,4th,3th FLOOR ONLY
32MM-2nd,1st FLOOR ONLY

10NOS. TOILETS

NOTE:- DROP CWS PIPE IN SHAFT
50MM-10th,9th,8th FLOOR ONLY
40MM-7th,6th,5th,4th FLOOR ONLY
32MM-3th,2nd FLOOR ONLY
25MM- 1st FLOOR

10NOS. KITCHEN

NOTE:- DROP CWS PIPE IN SHAFT
50MM-10th,9th FLOOR ONLY
40MM-8th,7th,6th,5th FLOOR ONLY
32MM-4th,3rd,2nd FLOOR ONLY
25MM- 1st FLOOR ONLY

DOWN TAKE PIPES DETAIL FLUSHING WATER SUPPLY

20NOS. TOILETS

NOTE:- DROP CWS PIPE IN SHAFT
50MM-10th,9th,8th,7th,6th FLOOR ONLY
40MM-5th,4th,3th FLOOR ONLY
32MM-2nd,1st FLOOR ONLY

10NOS. TOILETS

NOTE:- DROP CWS PIPE IN SHAFT
50MM-10th,9th,8th FLOOR ONLY
40MM-7th,6th,5th,4th FLOOR ONLY
32MM-3th,2nd FLOOR ONLY
25MM- 1st FLOOR

PROJECT NAME

VARDHMAN SAMPADA

PROMOTER:

RICHWELL ENTERPRISES
PRIVATE LIMITED

ARCHITECT :-

SPACE GRID
C-49, VIDYA
APARTMENT, PARAS MARG,
BAPU NAGAR, NEAR JANTA
STORE CIRCLE, JAIPUR-302015
PH-09314918766, 0141-4005506 (O)
Email -info.spacegrid@gmail.com

PROJECT:-

PROPOSED FLAT'S AT
KHASRA NO. :-1973,1987/1 IN REVENUE-
VILLAGE- SIRSI, TEH.-JAIPUR,

DRAWING:

A -BLOCK- TERRACE
WATER SUPPLY RING PLAN

DRN.

SUNIL

APPD.

SANJAY

DATE :-

27/06/17

REF. S



SERVICES CONSULTANT:

VIPUL CONSULTING,
F 9 / 440 , Keshav Marg Chitrakut Scheme, Jaipur
PH:91-0-93146-10438 , 0141-2440946
Mail:vipul8599@yahoo.com
REV. NO. 000, DATE:-27-06-2017

VIPUL AGARWAL
M.E.P. CONSULTANT
B.E. ELECTRICAL