



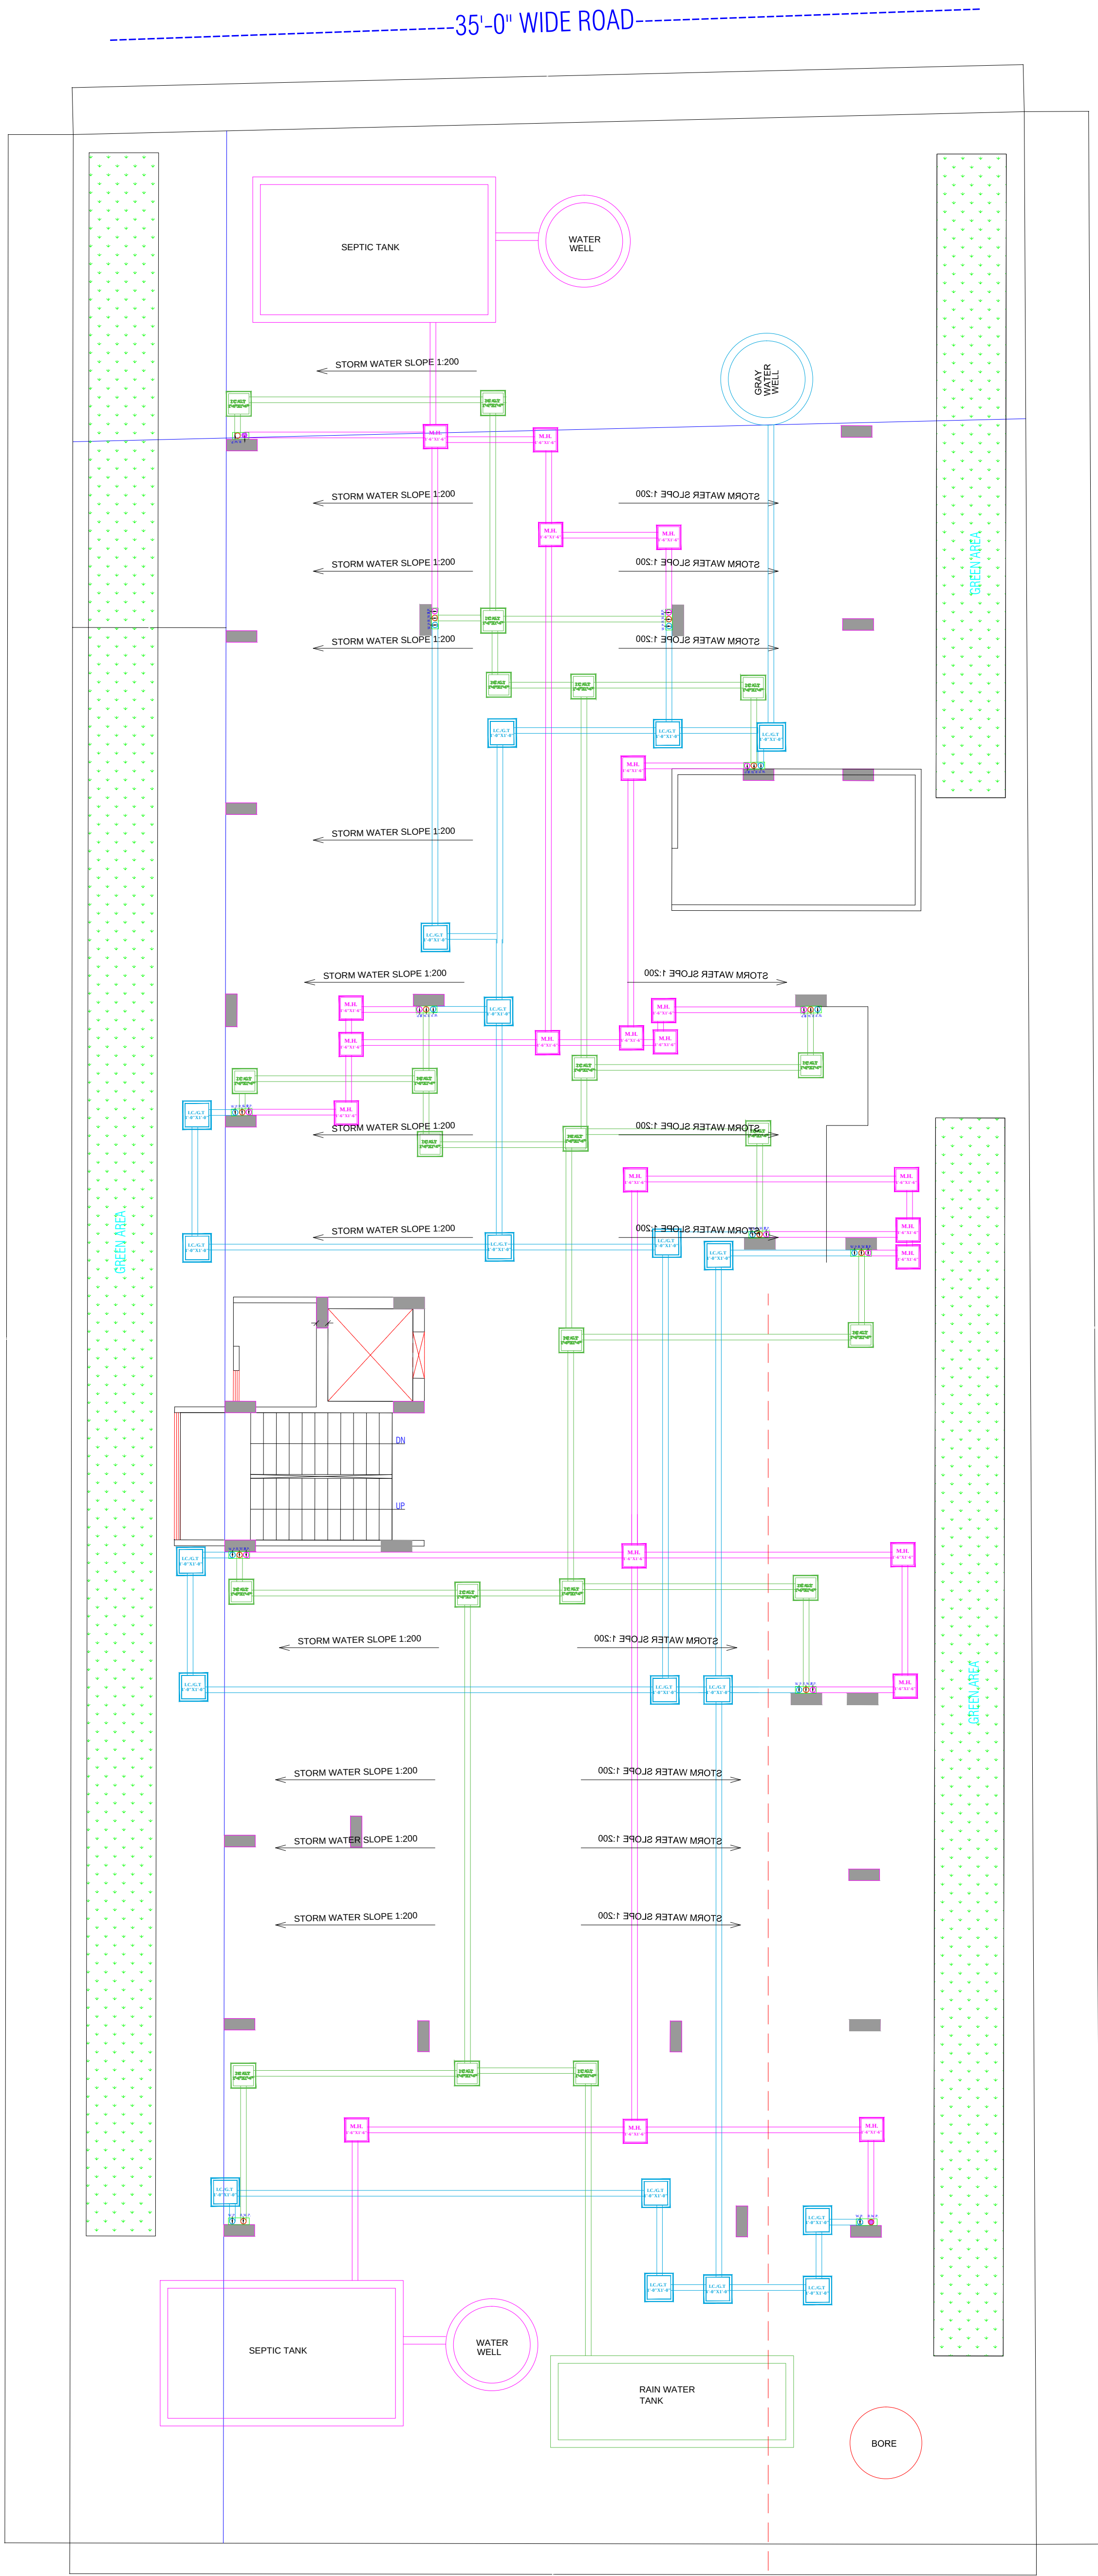

①	RAIN WATER PIPE		
②	WEST WATER PIPE		
③	SOILWATER PIPE		
④	INSPECTION CHAMBER / GULLY TRAP		2'6" DEPTH
⑤	MAN HOLE		2'6" DEPTH
⑥	ELECTRICAL PIPELINE		

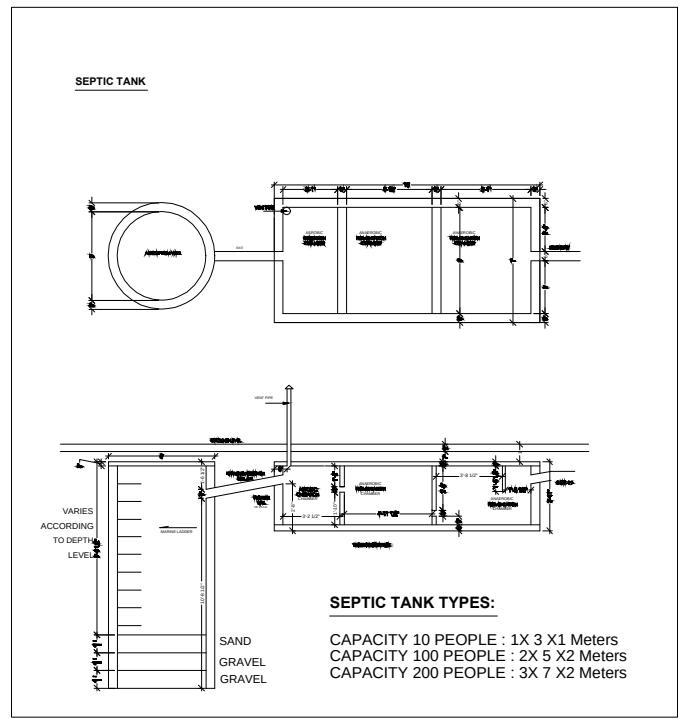

Ar. Lokesh Wadhwa
VISTAAR ARCHITECTS & PLANNERS
Er. LOKESH WADHWHA
P. Tech.(Civl), M.Tech.(Structure)
VISTAAR AM-232

STILT(PARKING)FLOOR PLAN

PROJECT TITLE :-
SALASAR RESIDENCY AT
PLOT-93(E.PJ)B&94.98&99(E.PJ)B,
VRINDAVAN VIHAR,JAIPUR

DRAWING TITLE :-
SANITATION(STORM WATER DRAINAGE,
SEWERAGE,STP,SOLID WATER DISPOSAL) AND
RAIN WATER HARVESTING PLAN,COMMON
AREA WATER SUPPLY

GENERAL NOTES

1. All dimensions are in feet and inches.
2. Do not scale this drawing follow written dimensions only.
3. This drawing should be read in conjunction with other architectural and structural drawings.
4. Any discrepancy in the drawing should be immediately brought to the notice of architect.

CHKD BY :-

AR. VIJAY SHARMA

DRAWN BY :-

MANOJ KUMAWAT

DATE :-


07-07-2022

REV:-

SCALE :-

NTS

NORTH :-

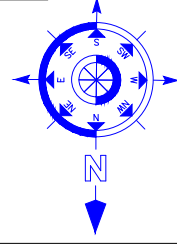


FILE PATH :-

VISTAAR ARCHITECTS & PLANNERS

Architects :: Interior Designers
B-2/12, Chitrkoot scheme,
main Gandhi Path,Opp mall of jaipur,Jaipur-21
Email-Vistaararchitects.web@gmail.com
PH.- 0141-4116461,09001010366

NOTE :- This drawing is the sole copyright of Architects VISTAAR and should be used for the purpose expressly issued.

35'-0" WIDE ROAD

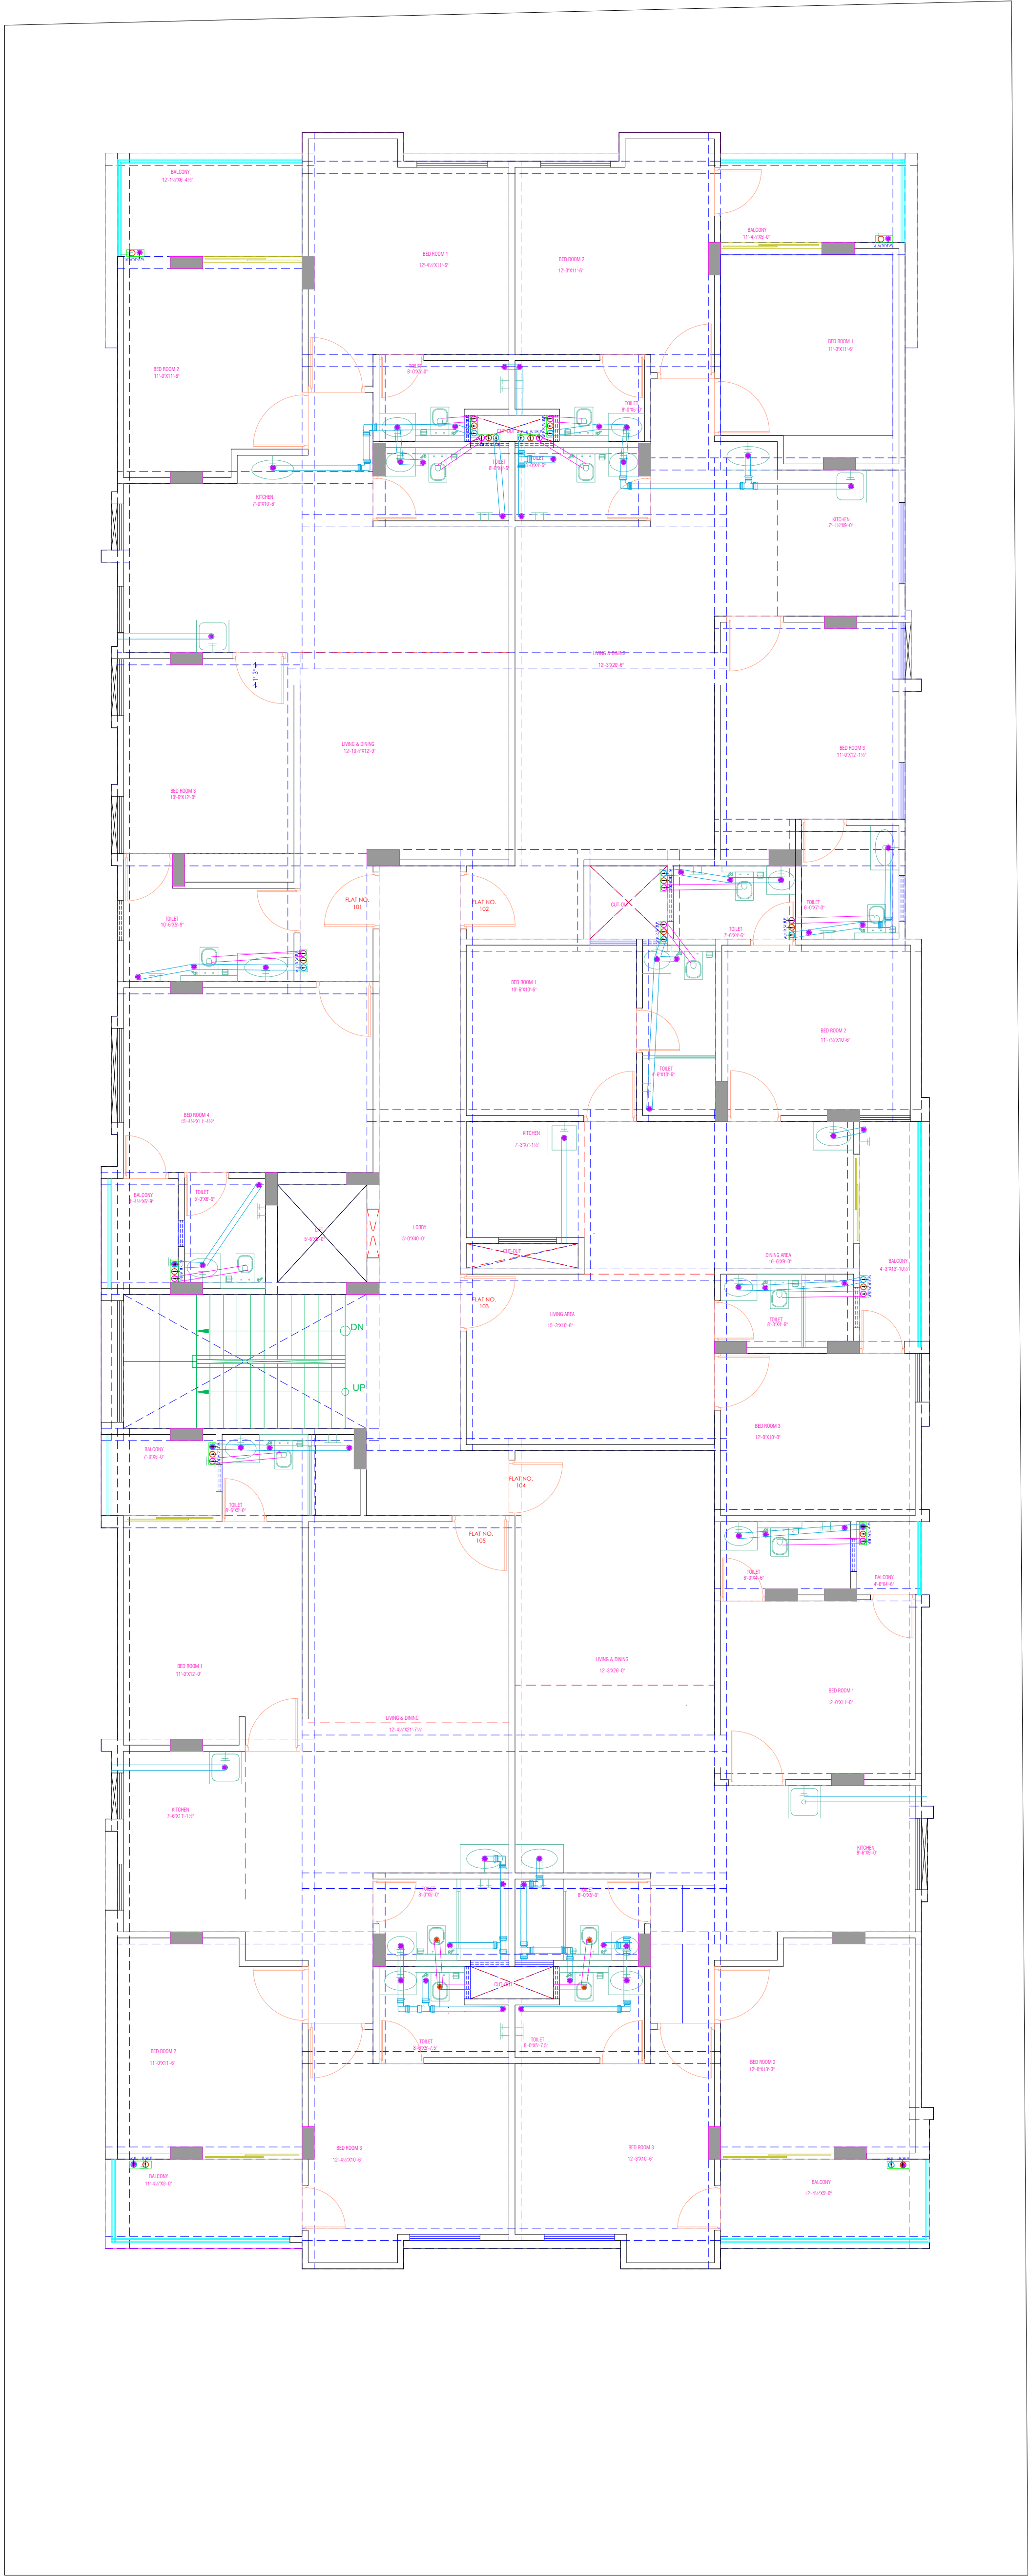

○	RAIN WATER PIPE	○	
②	WEST WATER PIPE	○	
③	SOILWATER PIPE	○	
④			
⑤			

40'-0" WIDE ROAD

VISTAAR ARCHITECTS & PLANNERS
Architects & Interior Designers
B-2/12, Chitrakoot scheme,
main Gandhi Path, Opp mall of jaipur, Jaipur-21
Email- Vistaararchitects.web@gmail.com
PH- 0141-4116461, 09001010366

PROJECT TITLE :- SALASAR RESIDENCY AT PLOT-93(E.P)B&94,98&99(E.P)B, VRINDAVAN VIHAR, JAIPUR	GENERAL NOTES 1. All dimensions are in feet and inches. 2. Do not scale this drawing follow written dimensions only. 3. This drawing should be read in conjunction with other architectural and structural drawings. 4. Any discrepancy in the drawing should be immediately brought to the notice of architect.	CHKD BY :- AR, VIJAY SHARMA DRAWN BY :- MANOJ KUMAWAT DATE :- 23-06-2022 SCALE :- NTS	NORTH :- FILE PATH :-	VISTAAR ARCHITECTS & PLANNERS Architects & Interior Designers B-2/12, Chitrakoot scheme, main Gandhi Path, Opp mall of jaipur, Jaipur-21 Email- Vistaararchitects.web@gmail.com PH- 0141-4116461, 09001010366 NOTE :- This drawing is the sole copyright of Architects VISTAAR and should be used for the purpose expressly issued.
DRAWING TITLE :- TYPICAL FLOOR DRAINAGE WORKING PLAN				