


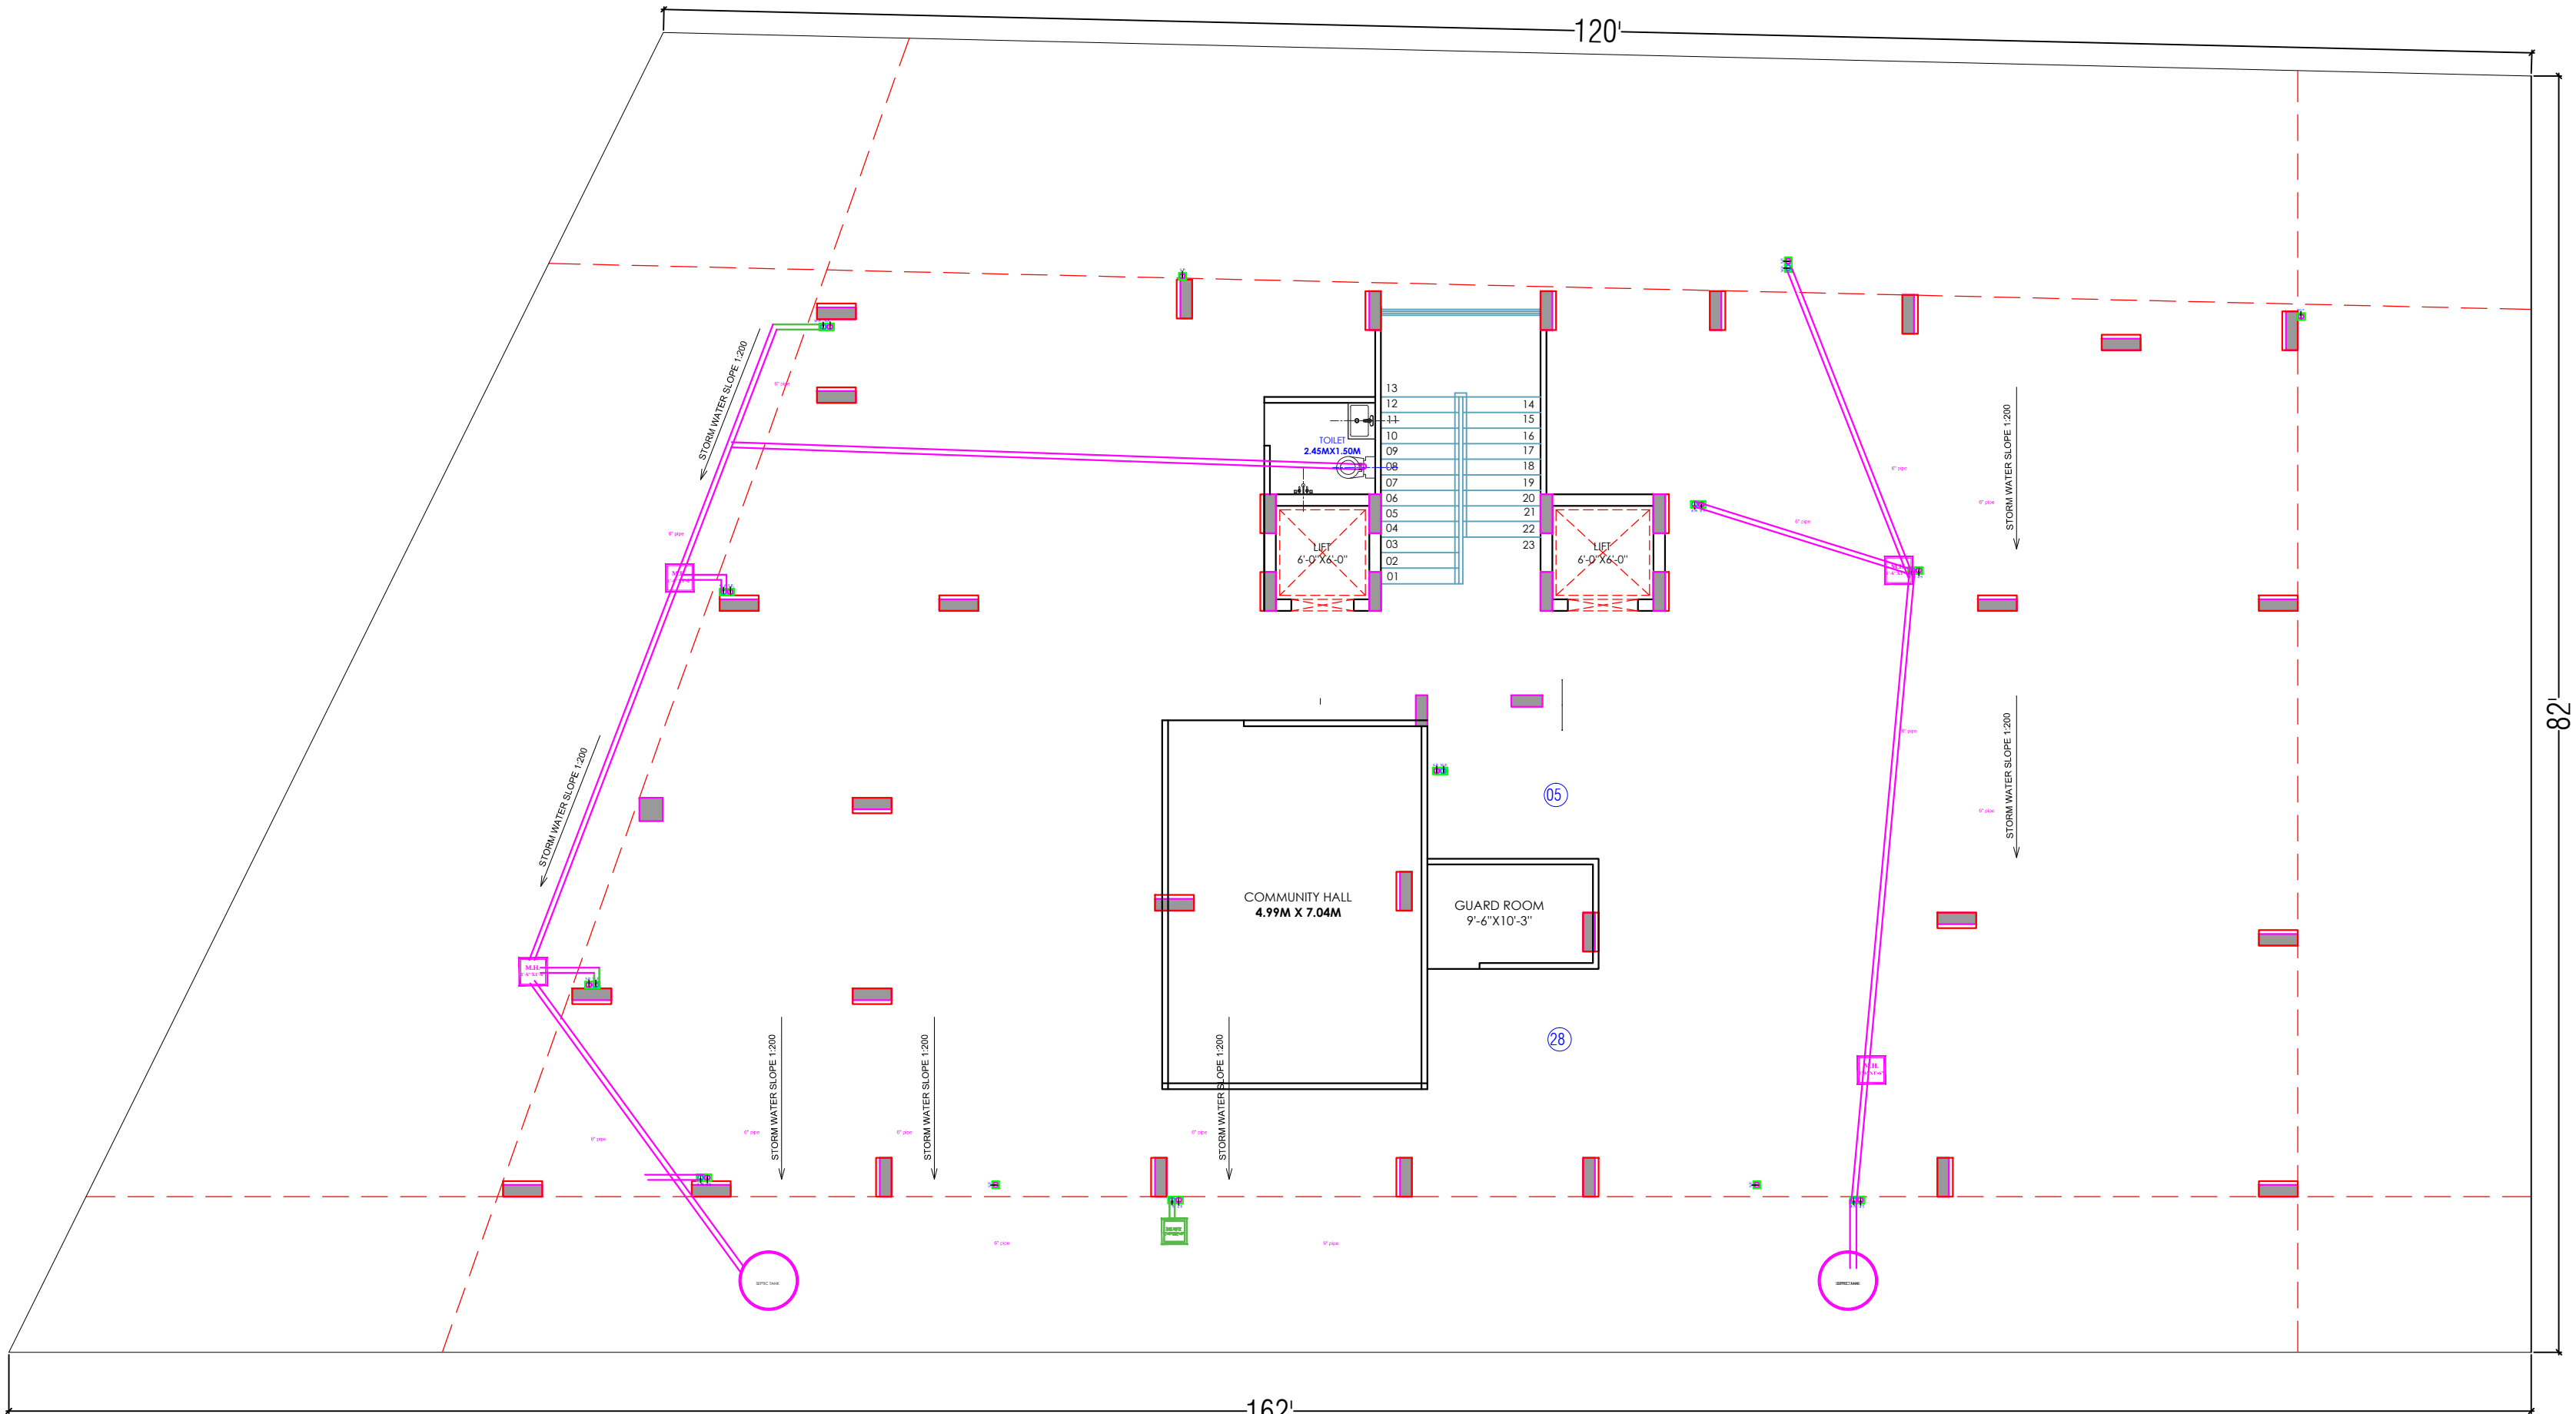

LEGENDS		
S.NO.	SYMBOL	DESCRIPTION
1.		SDR-11 Fresh Water Pipe
2.		SDR-11 Solar Water Pipe
3.		Waste Water Pipe (W.P.)
4.		Soil Pipe (S.P.)
5.		Rain Water Pipe (R.W.P.)
6.		Butter Fly Valve (B.F.V.)
7.		Geyser
8.		RO
9.		Single Lever Diverter
10.		Concealed Valve
11.		Angle Valve
12.		Nahani Trap
13.		P-Trap
14.		Tap
15.		Floor Drain (F.D.)
16.		Plain Tee (P-tee)
17.		Gully Trap (G.T.)
18.		

WARNING

1. This drawing is the sole copyright of Architects VISTAAR and should be used for the purpose expressly issued.

GENERAL NOTES

1. All dimensions are in feet and inches.
2. Do not scale this drawing follow written dimensions only.
3. This drawing should be read in conjunction with other architectural and structural drawings.
4. Any discrepancy in the drawing should be immediately brought to the notice of architect.

PROJECT TITLE

PROJECT:-
SUNRISE HEIGHTS
BUILDING AT PLOT NO.-E-15,E-16 &
E-17(RECONSTITUTION),JAGDAMBA NAGAR-E,JAIPUR


DRAWING TITLE

STILT FLOOR SANITATION PLAN

ARCHITECTS :

VISTAAR ARCHITECTS & PLANNERS
Architects :: Interior Designers
B-2/12, Chitrkoot scheme,
main Gandhi Path,Opp mall of jaipur,Jaipur
PH.- 0141-4370233,09001010366


PATH :-	DATE	REV.	NORTH
DRN.	26-08-2023		
MANOJ KUMAWAT			
SCALE	JOB NO.		
N.T.S			

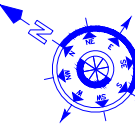

①	RAIN WATER PIPE		
②	WEST WATER PIPE		
③	SOILWATER PIPE		
④		INSPECTION CHAMBER / GULLY TRAP	2'6" DEPTH
⑤		MAN HOLE	2'6" DEPTH
⑥		ELECTRICAL PIPELINE	

For My Dream House
Partner

FRAME CONSULTANTS
E.P. LOKESH WADHWA
B.TECH(CIVIL),M.Tech.(Structure)
H/S.NO.42-AH-232

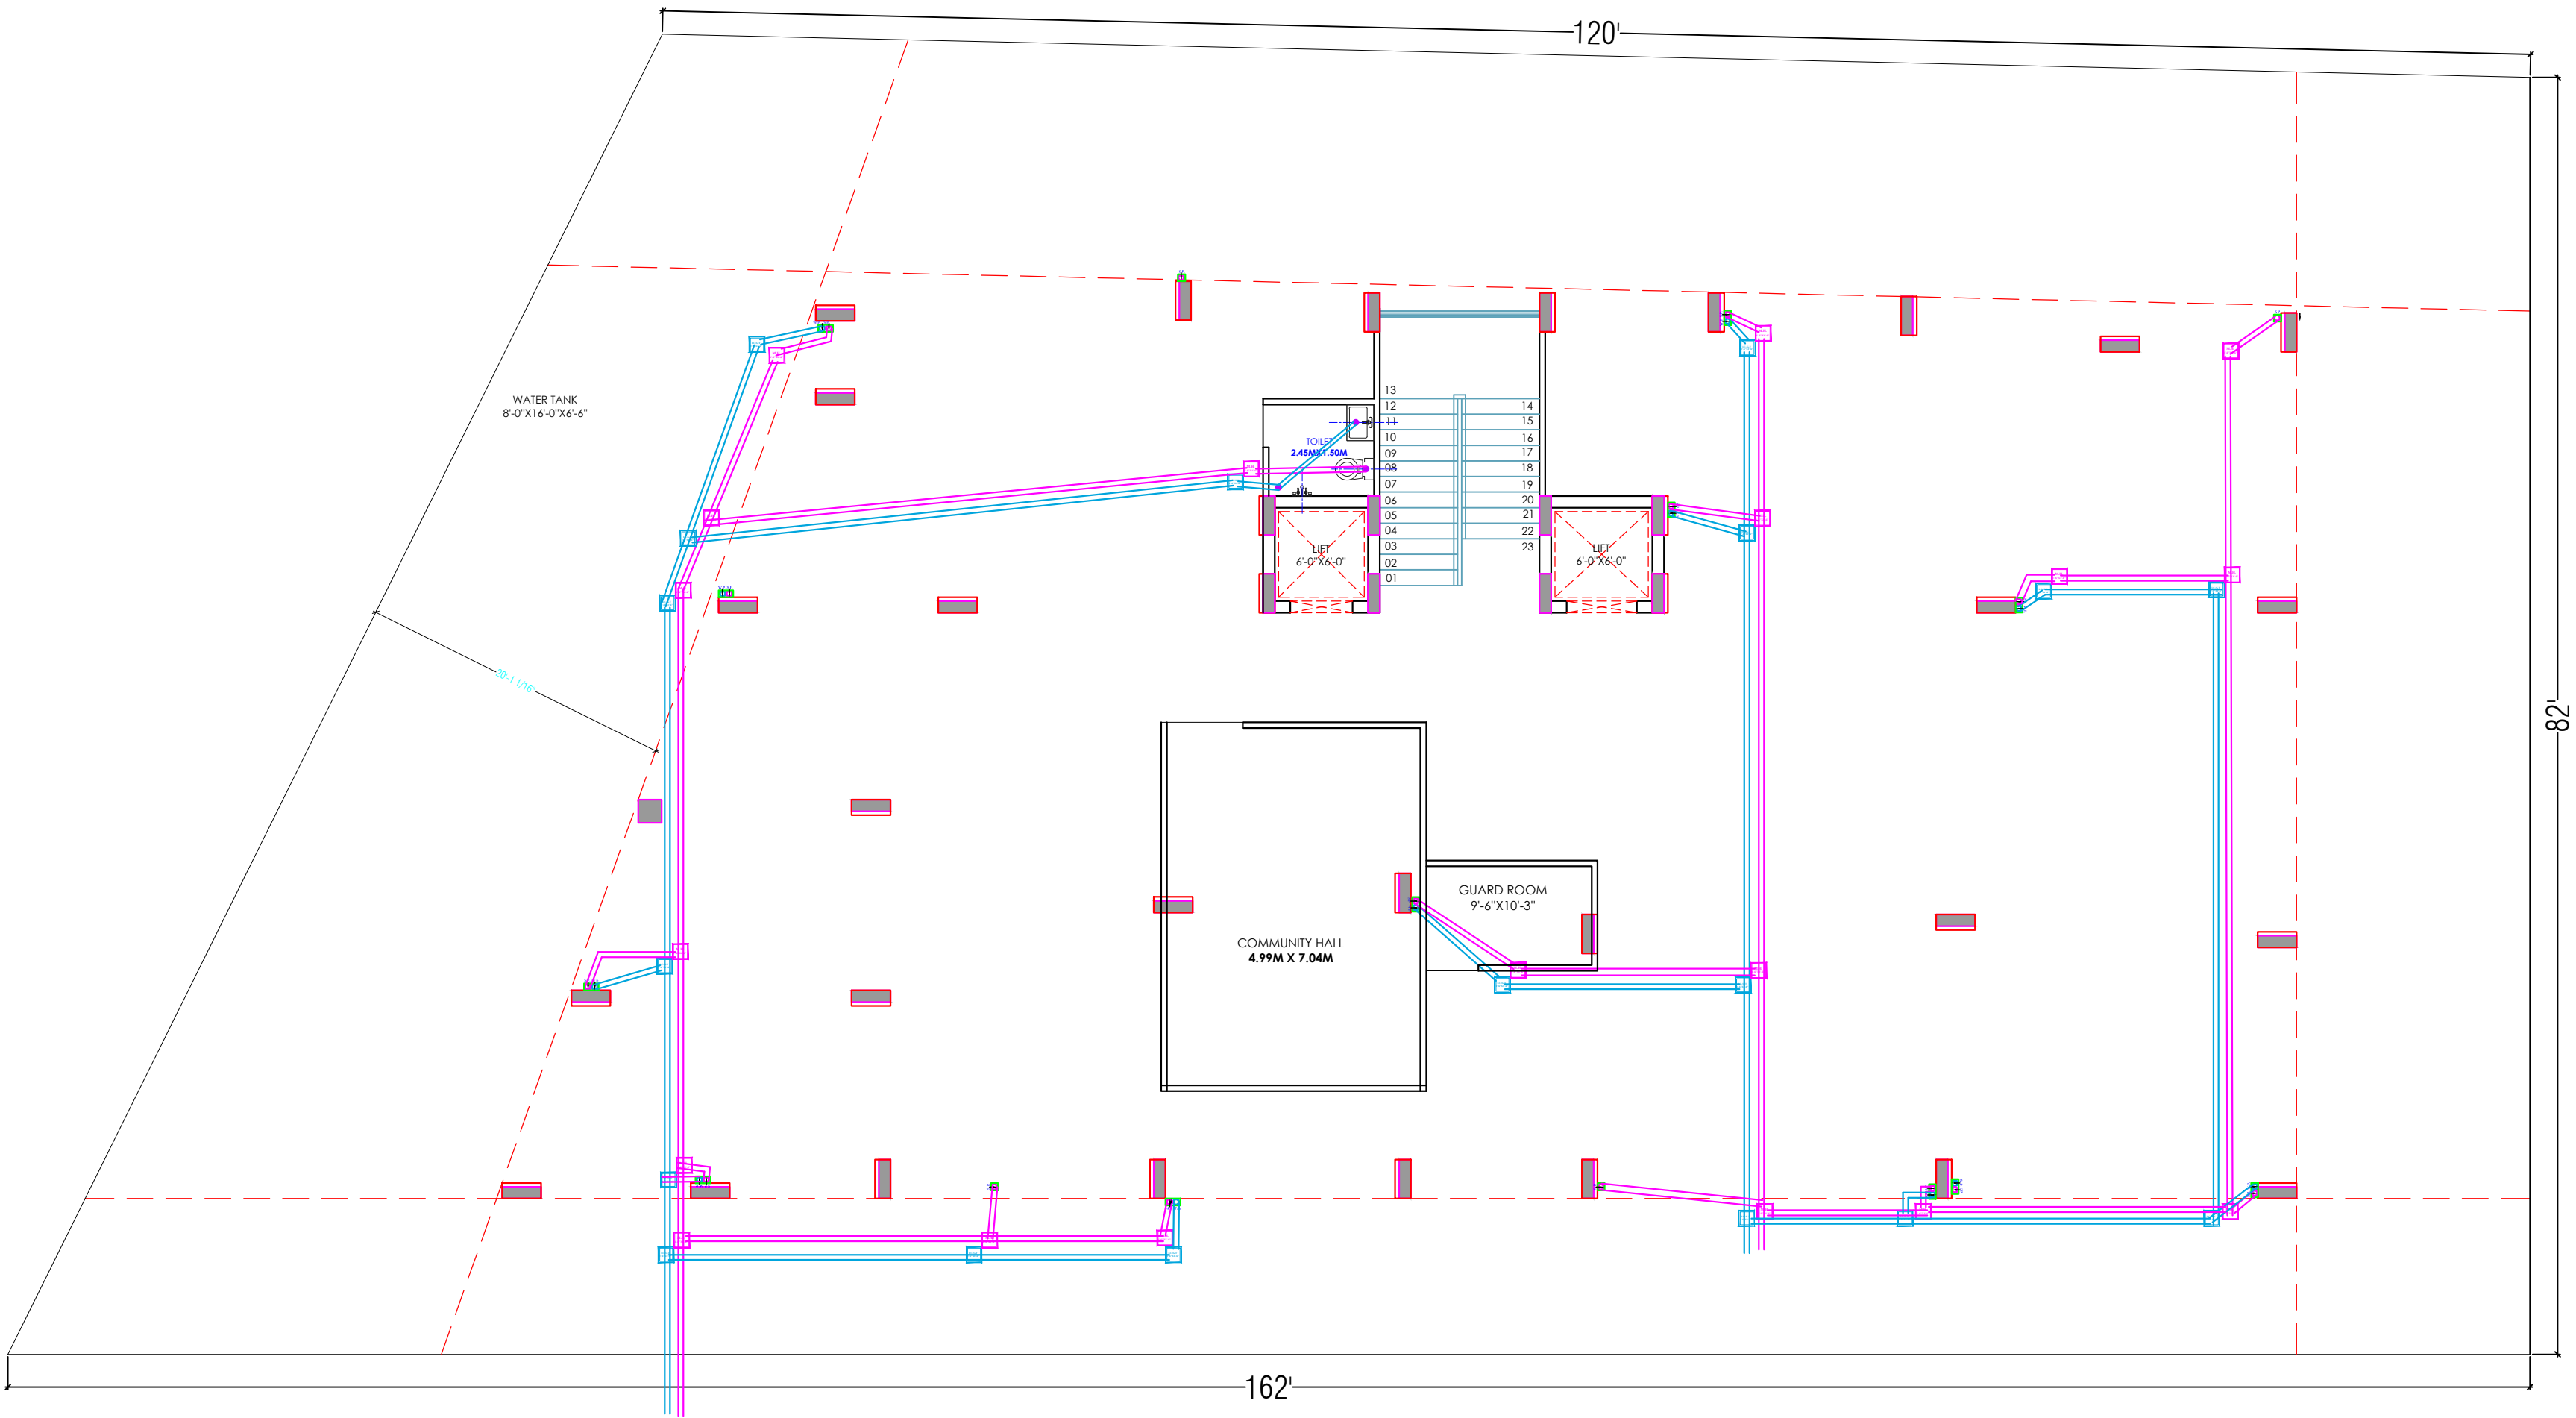

①	RAIN WATER PIPE	
②	WEST WATER PIPE	
③	SOIL WATER PIPE	

LEGENDS		
S.NO.	SYMBOL	DESCRIPTION
1.		SDR-11 Fresh Water Pipe
2.		SDR-11 Solar Water Pipe
3.		Waste Water Pipe (W.P.)
4.		Soil Pipe (S.P.)
5.		Rain Water Pipe (R.W.P.)
6.		Butter Fly Valve (B.F.V.)
7.		Geyser
8.		RO
9.		Single Lever Diverter
10.		Concealed Valve
11.		Angle Valve
12.		Nahani Trap
13.		P-Trap
14.		Tap
15.		Floor Drain (F.D.)
16.		Plain Tee (P-tee)
17.		Gully Trap (G.T.)
18.		

WARNING

1. This drawing is the sole copyright of Architects **VISTAAR** and should be used for the purpose expressly issued.

GENERAL NOTES

1. All dimensions are in feet and inches.
2. Do not scale this drawing follow written dimensions only.
3. This drawing should be read in conjunction with other architectural and structural drawings.
4. Any discrepancy in the drawing should be immediately brought to the notice of architect.

PROJECT TITLE

PROJECT:-
SUNRISE HEIGHTS
BUILDING AT PLOT NO.-E-15,E-16 &
E-17(RECONSTITUTION),JAGDAMBA
NAGAR-E,JAIPUR

DRAWING TITLE

STILT FLOOR PLAN
DRAINAGE PLAN

ARCHITECTS :

VISTAAR ARCHITECTS & PLANNERS
Architects :: Interior Designers
B-2/12, Chitkoot scheme,
main Gandhi Path,Opp mall of jaipur,Jaipur
PH.- 0141-4370233,09001010366

PATH:-

DRN.	DATE	REV.	NORTH
MANOJ KUMAWAT	26-08-2023		
SCALE	JOB NO.		
N.T.S			

For My Dream House

FRAME CONSULTANTS
EX. LOKESH WARDHANA
B. Tech (Civil), M.Tech (Structural)
A/Structure-AIA-232