


PLUMBING DRAWING

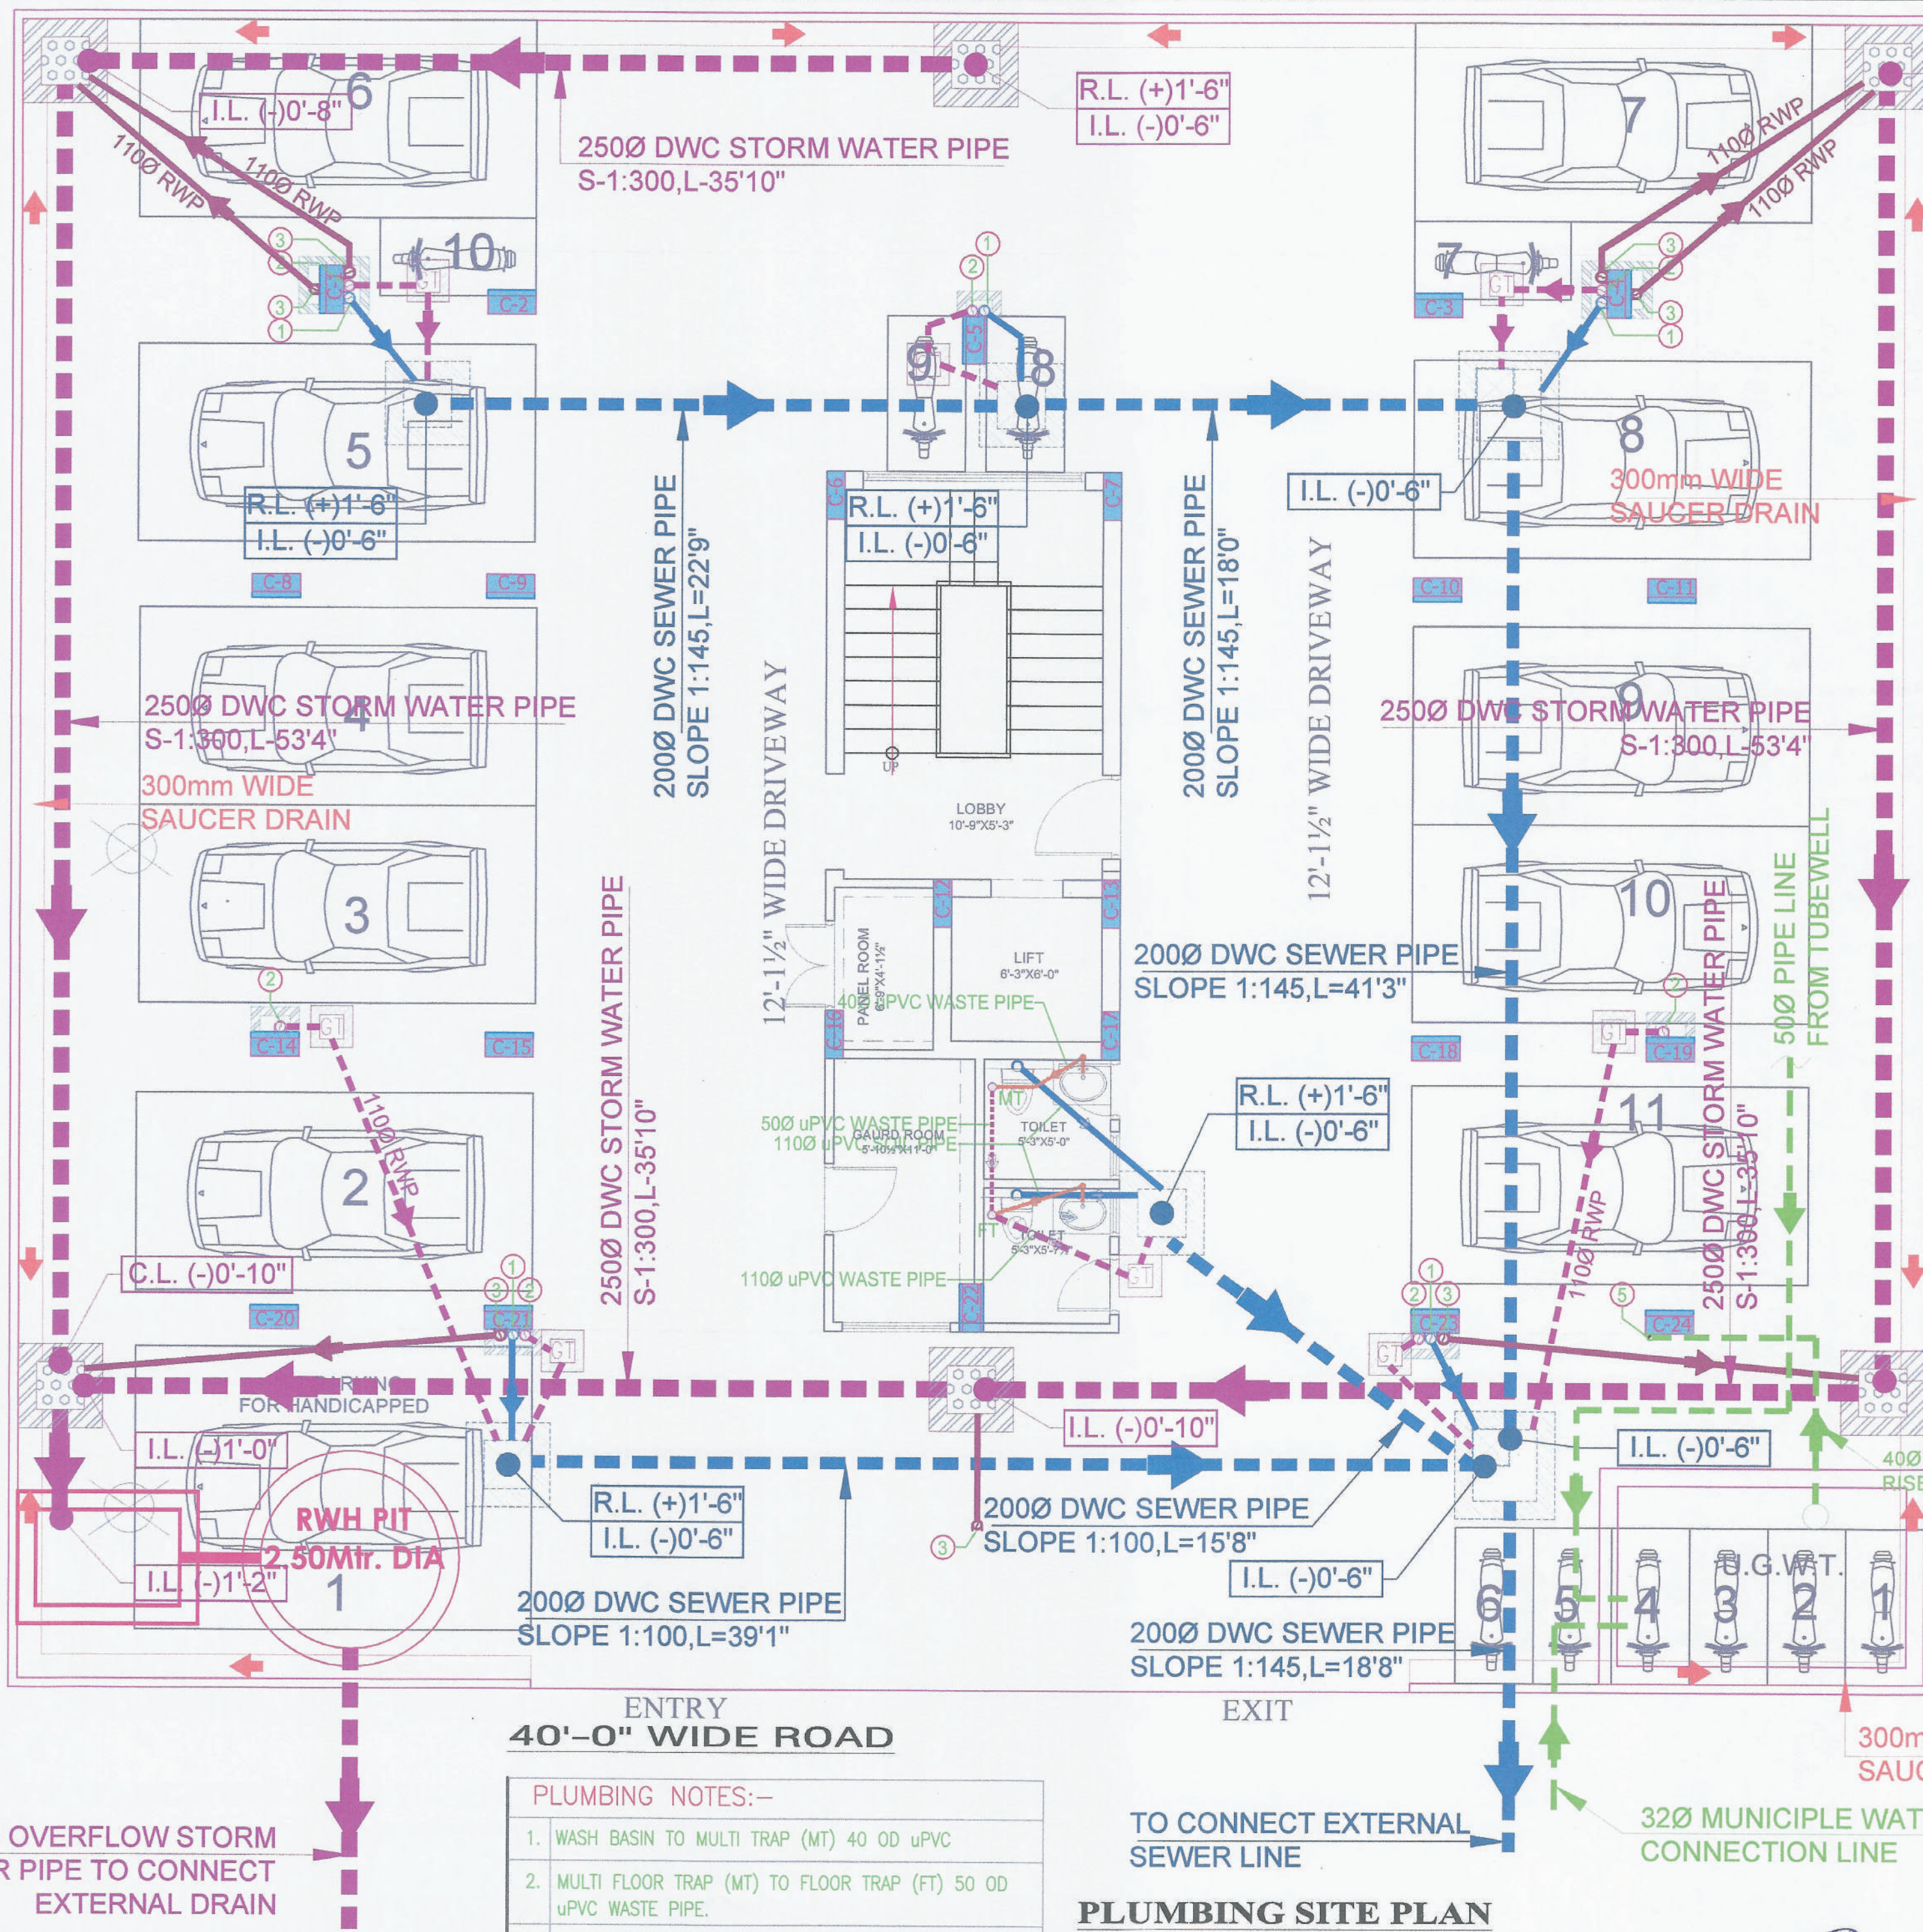

PIPE NO.	DESCRIPTION
1	110 OD uPVC SMR TYPE B SOIL PIPE
2	110 OD uPVC SMR TYPE B WASTE PIPE
3	110 OD uPVC RAIN WATER PIPE FOR TERRACE
4	DOMESTIC WATER SUPPLY D/N TAKE
5	WATER SUPPLY RISER PIPE * (DOMESTIC)
6	90 OD uPVC RAIN WATER PIPE FOR BALCONY
F.G.L.	FINISH GROUND LEVEL
I.L.	INVERT LEVEL
C.L.	CONNECTION LEVEL
---	EXTERNAL STORM WATER LINE
---	EXTERNAL SEWER LINE
---	DOMESTICS WATER SUPPLY LINE

MANHOLE & CATCH BASIN SCHEDULE	
1	RAIN WATER CATCH BASIN (1'-6"x1'-6") UP TO 2'-0" DEPTH
2	RAIN WATER CATCH BASIN (2'-0"x2'-0") UP TO 2'-6" DEPTH
3	RAIN WATER CHAMBER (2'-6"x2'-6") UP TO 3'-0" DEPTH
4	SEWER CHAMBER (2'-0"x2'-0") UP TO 2'-6" DEPTH
5	SEWER CHAMBER (2'-10"x3'-0") UP TO 3'-0" DEPTH
6	910# CIRCULAR SEWER MANHOLE UP TO DEPT 1670mm
7	910# CIRCULAR STROM WATER MANHOLE UP TO DEPT 1670mm
8	GULLY TRAP (1'-0"x1'-0")

DT.	NO.	ISSUED TO	CKD.
REVISIONS			
DT.	NO.	ISSUED TO	CKD.



PRINTS DATA	
PROJECT TITLE	PROPOSED RESIDENTIAL APARTMENT (BUNGLOW 10) AT J 4 & 5 NANDAN VIHAR MAHAL JAGATPURA JAIPUR
DRAWING TITLE	PLUMBING SITE PLAN
ARCHITECTS	MISHRA GARG & ASSOCIATES C-35, 36, 37, 38, 999, 1000

ARCHITECTS:-			
MISHRA GARG & ASSOCIATES C-35,shukhrawati enclave,jalpat nagar,acharya jalpur, ph:-91-141-237-3374,8104986,e-mail: mishra.garg@gmail.com			
PRIME CONSULTANT			
SRAJAN ASSOCIATES NAKSHATRA APPARTMENT JAIPUR			
PLUMBING CONSULTANTS(ASSOCIATE):			
 BEHERA & ASSOCIATES PVT. LTD. F-6238, BEHIND, CNG FILLING STATION, LADO SARAI, NEW DELHI 110030 PH-011-4553886, 09811911853 E mail- behera.associates@gmail.com			
DESIGNED BY	CHECKED BY	DATE	REVISION
S.SINGH	S.BHARA	28-05-2022	
DRAWN	JOB NO.	DRAWN NO.	
N.T.S		PL-03	


PLUMBING NOTES:-	
1.	WASH BASIN TO MULTI TRAP (MT) 40 OD uPVC
2.	MULTI FLOOR TRAP (MT) TO FLOOR TRAP (FT) 50 OD uPVC WASTE PIPE.
3.	FLOOR TRAP (FT) TO VERTICAL PIPE 110 OD uPVC
4.	110 OD uPVC PIPE USED FOR SOIL & WASTE.
5.	110 OD uPVC PIPE USED FOR TERRACE RAIN WATER

PLUMBING SITE PLAN


SOMAN BEHARA
BTECH (CIVIL)

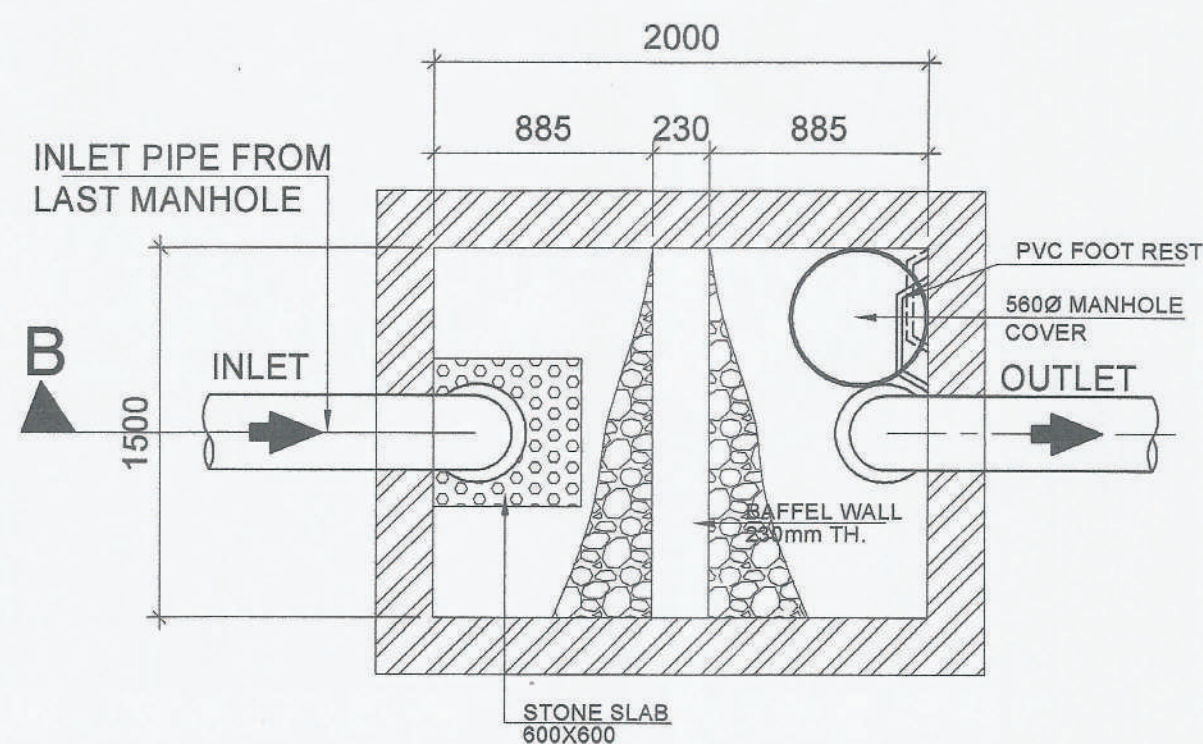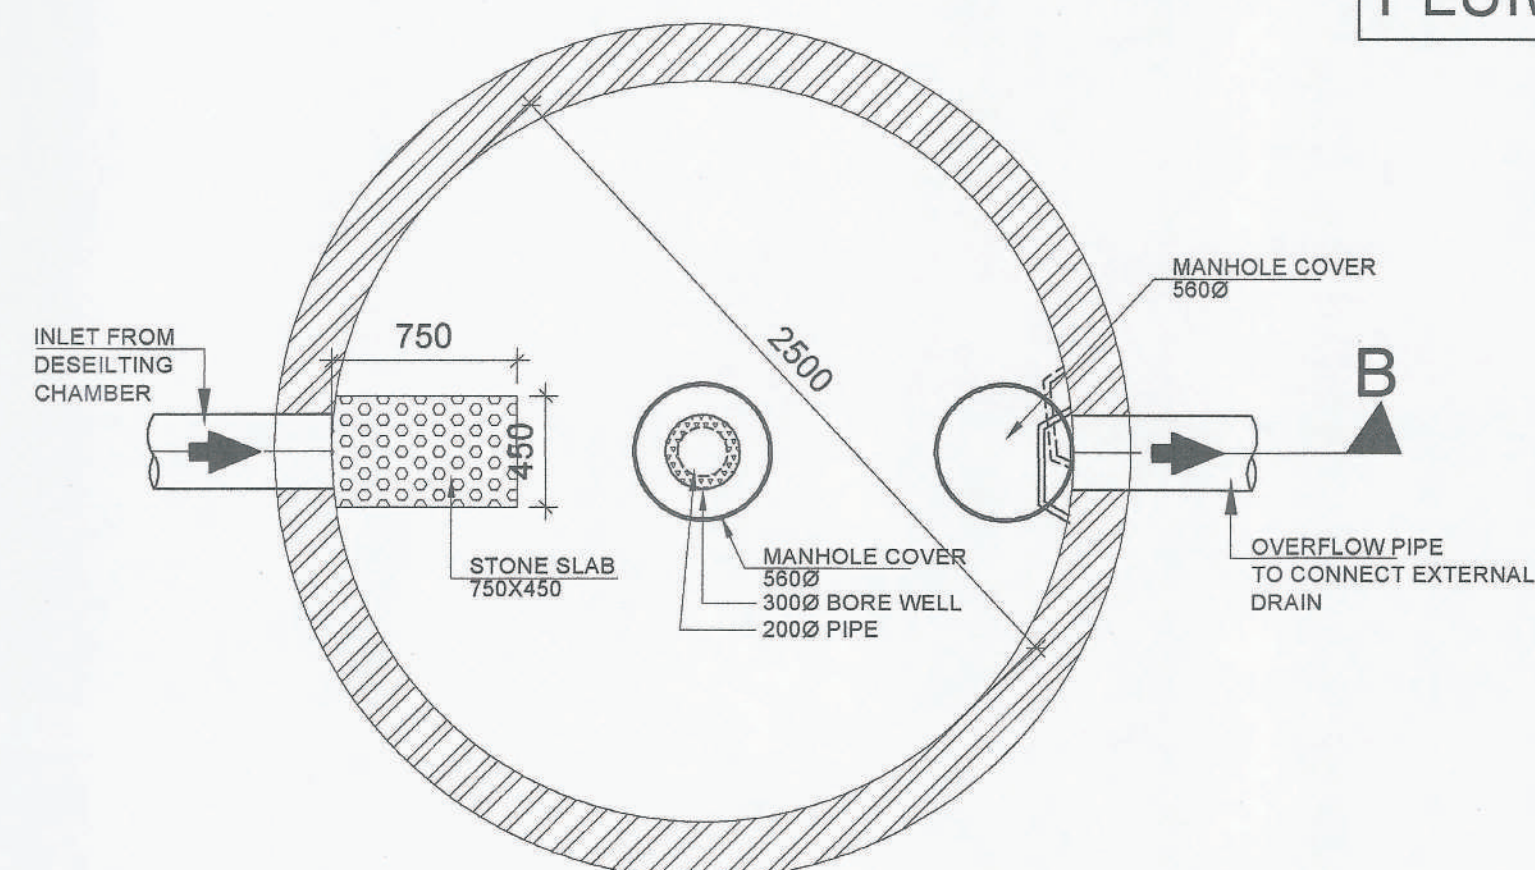

PLAN OF DESILTING CHAMBER & RWH PIT

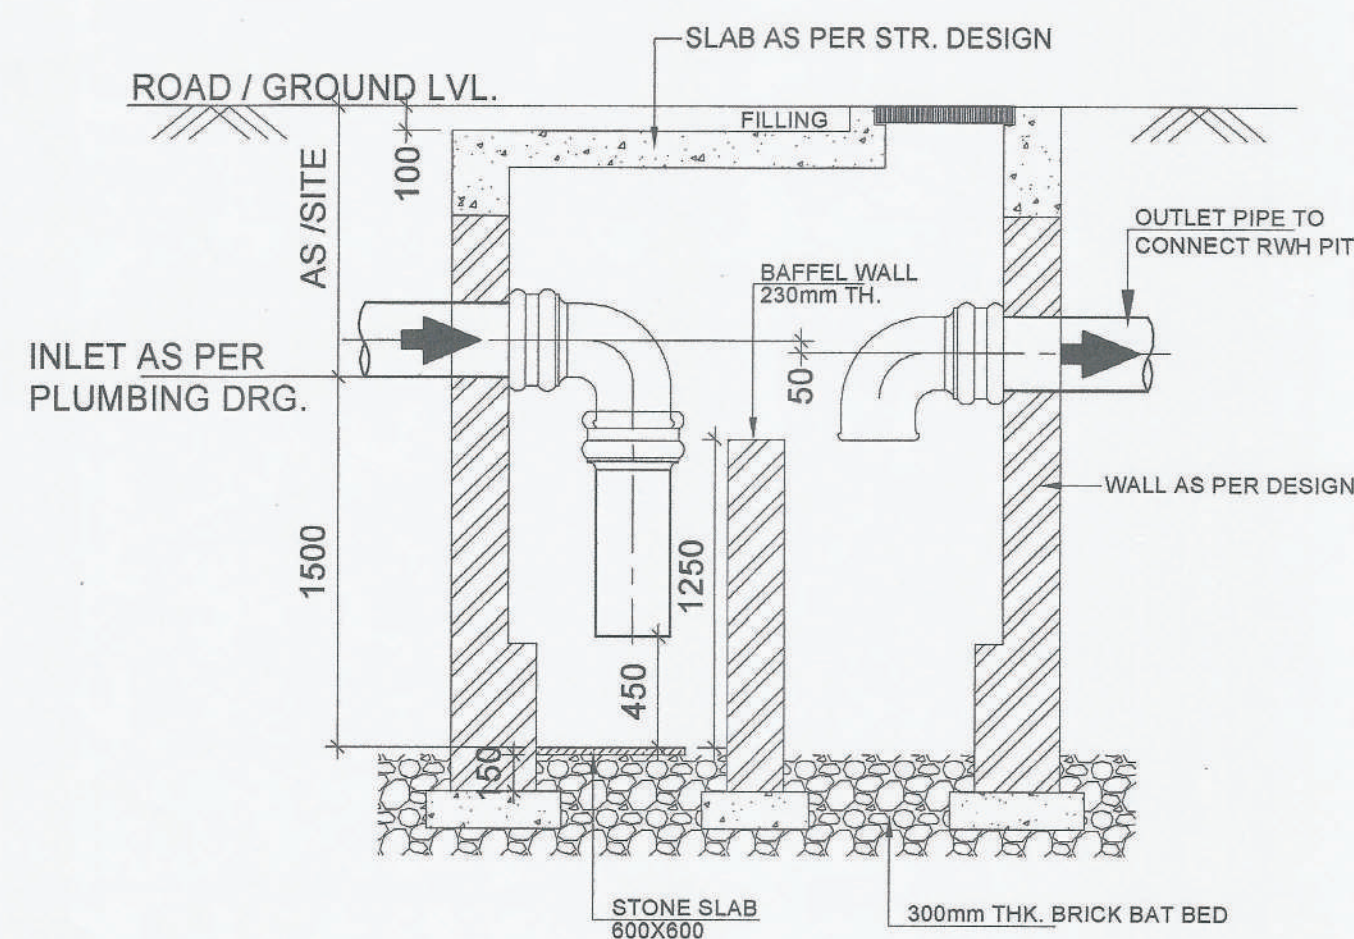

SECTION-B B

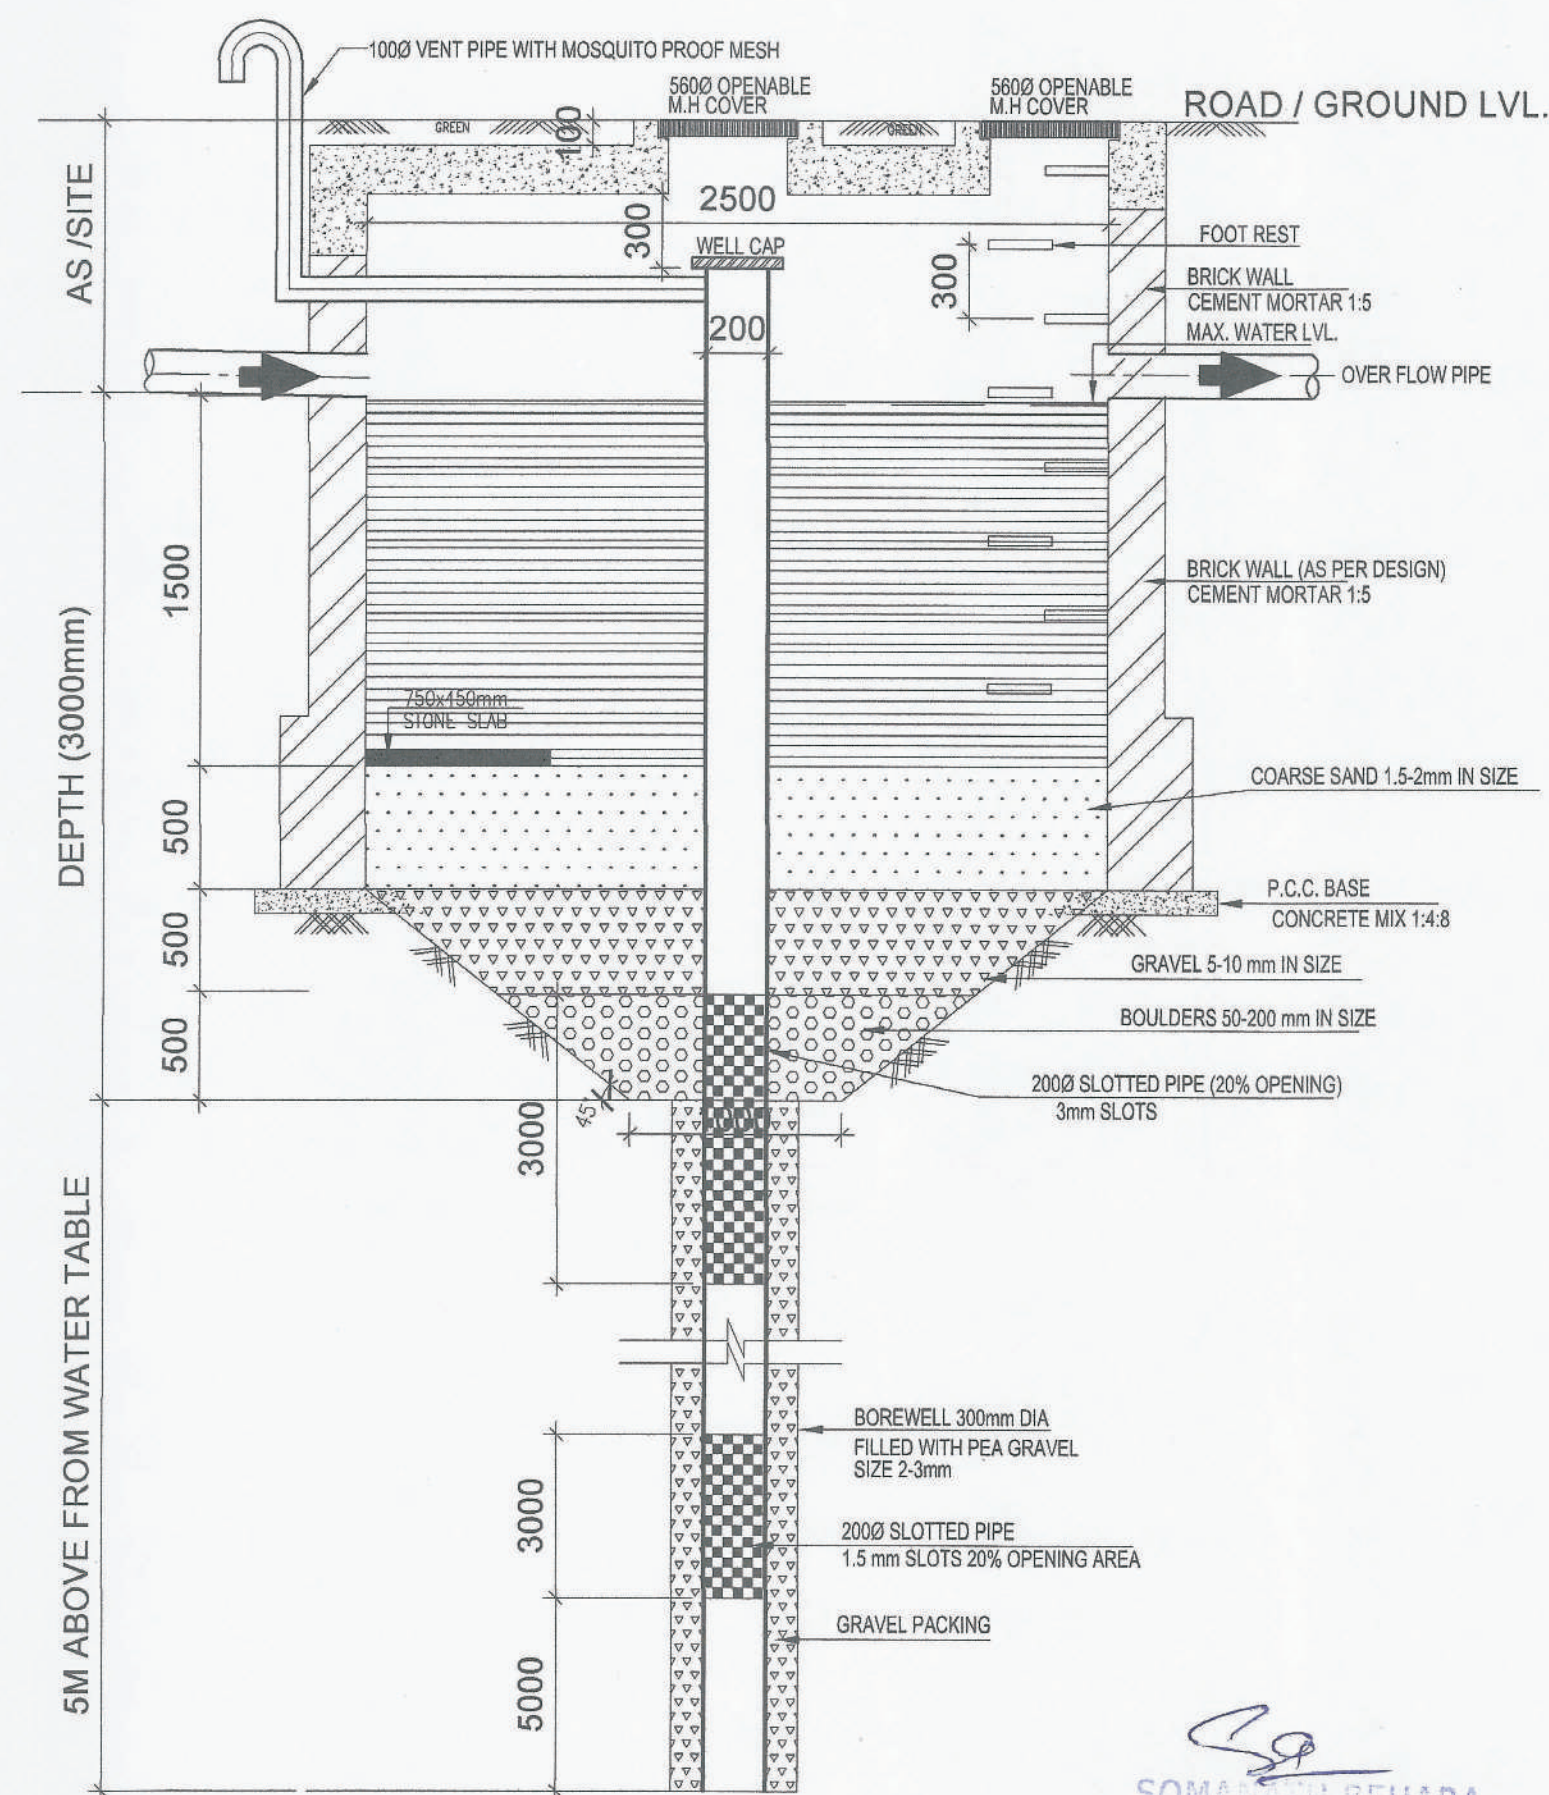

DT.	NO.	ISSUED TO	CKD.
REVISIONS			
DT.	NO.	ISSUED TO	CKD.
PRINTS DATA			
PROJECT TITLE			
PROPOSED RESIDENTIAL APARTMENT (BUNGLOW 10) AT J 4 & 5 NANDAN VIHAR MAHAL JAGATPURA JAIPUR			
DRAWING TITLE			
TYPICAL RAIN WATER HARVESTING PIT DRG.			
ARCHITECTS:			
MISHRA GARG & ASSOCIATES C-35, Shikharwati, Indraprastha, Jaipur. E-mail: mishra.garg@gmail.com ph: +91-141-337-3274, 5104986			
PRIME CONSULTANT			
SRAJAN ASSOCIATES NAKSHATRA APARTMENT JAIPUR			
PLUMBING CONSULTANTS (ASSOCIATE):			
BEHERA & ASSOCIATES PVT. LTD. F-623a, BEHIND, CNG FILLING STATION, LADO SARAI, NEW DELHI 110030 PH:- 011-40583898, 08611911853 E mail:- behera.associates@gmail.com			
DRAWN BY	CHECKED BY	DATE	SHEET
S. BEHERA	S. BEHERA	25.06.2022	1
SCALE	JOB NO.	DRG. NO.	
N.T.S		PL-08	

SOMANATH BEHARA
BTECH (CIVIL)