




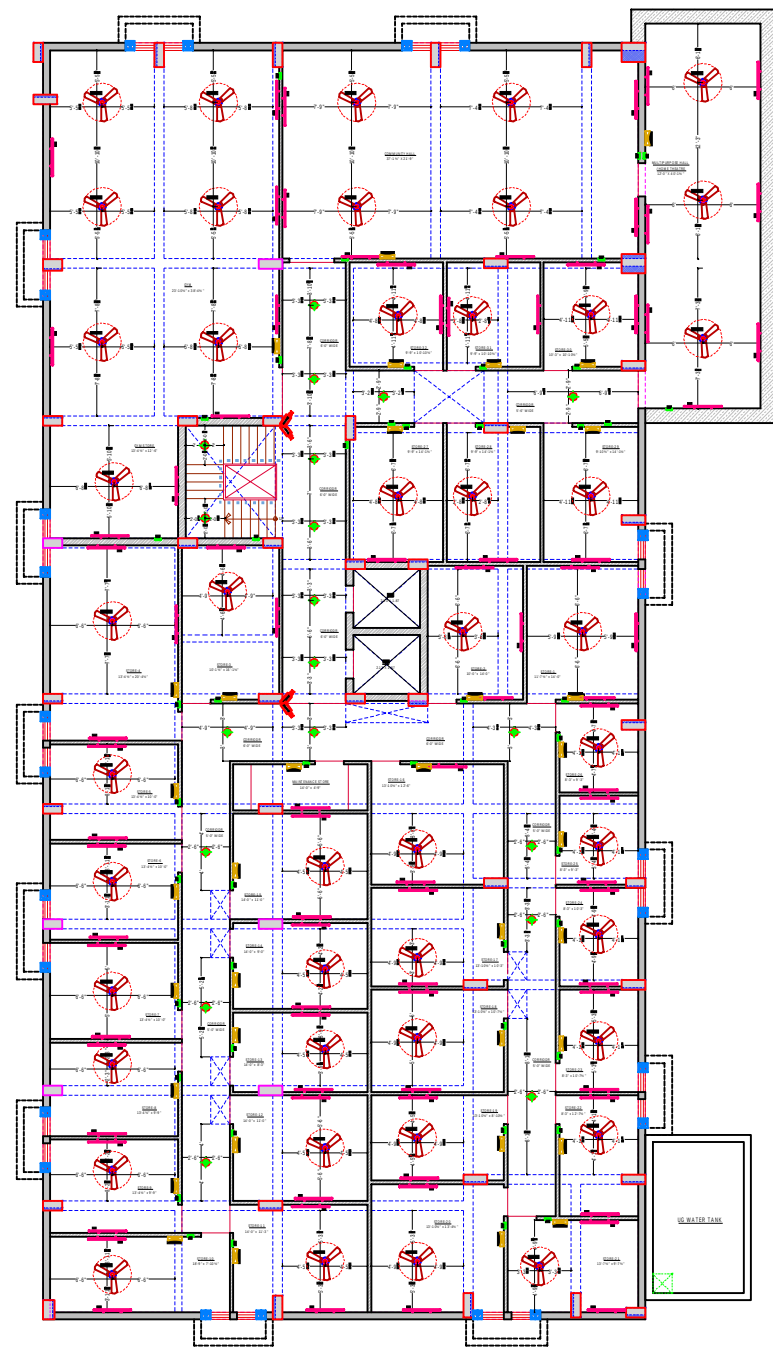

BASEMENT FLOOR ELECTRICAL PLAN

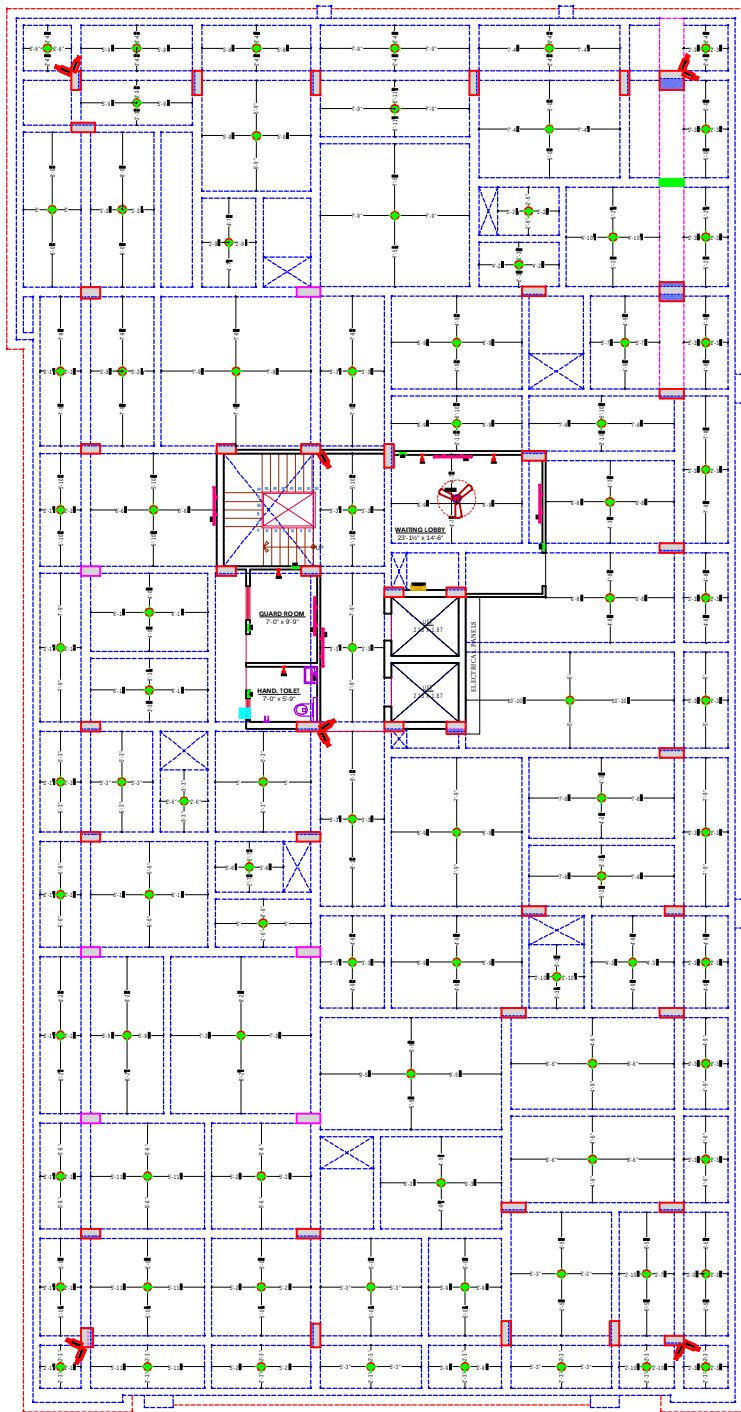

STILT FLOOR ELECTRICAL PLAN

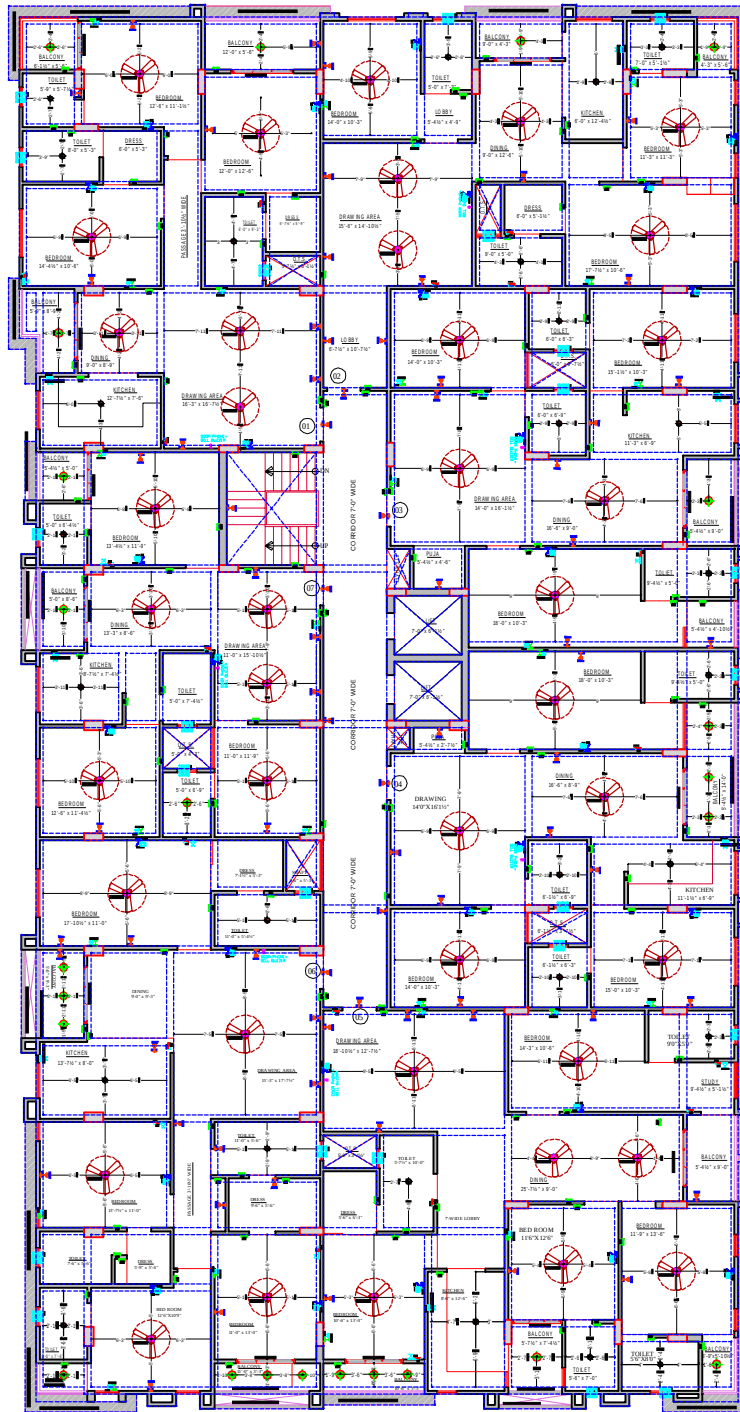


FIRST FLOOR WORKING PLAN

LEGENDS:			
Mounting Height	ID	Symbol	Description
CEILING	FAN/48"		CEILING FAN 48"
CEILING	FAN/BOX		CEILING FAN BOX
+90"	TLW		1X40W WALL TUBELIGHT
+90"	BULB		WALL BRACKETS AS DESIGN LIGHT
+90"	GL		WALL BRACKETS AS DESIGN FOR GANESH LIGHT
CEILING	CFL		CEILING LIGHT CFL
+42"	SB		SWITCH BOARD
+78"	ML		1 X 11 W CFL MIRROR LIGHT
VENTILATOR HT.	EXF		9" DIA FRESH AIR FAN
+24"	TEL		TELEPHONE POINT
as per elevation	TV		TV COAXIAL POINT.
+24"	LP		6 A PLUG POINT
as per elevation	LP TV		6 A PLUG POINT FOR TV
+24"	LP		6 A PLUG POINT
+72"	LP-CH		6 A PLUG POINT FOR CHIMNEY
+90"	SAC		SPLIT AC INDOOR UNIT
+42"	PP-MIX		15 A POWER POINT FOR MIXER
+78"	PP-G		15 A POWER POINT FOR GEYSER
+78"	PP-WP		15 A POWER POINT FOR WATER PURIFIER
+60"	BP		6 A BELL PUSH
+90"	BZ		BUZZER FOR CALL BELL
+60"	MCB DB		MCB DISTRIBUTION BOARD

FLOOR ELECTRICAL PLAN

PROJECT:-
THE SHYAM HAVELI
PROPOSED RESIDENTIAL BUILDING AT PLOT MO. 29, 30, 31, 32, 33
NORTH PART, SCHEME - NAVJEEVAN GRIHA NIRMAN SHAKARI
SAMEETI, NIRMAN NAGAR A, B, JAIPUR (RAJ)

SCALE:-
1:100

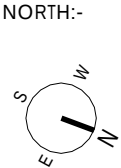


ARCHITECT:-

B-6, GANESH KRIPA, MOTI MARG,
BAPU NAGAR JAIPUR - 302015.
TEL. 9314510603, 0141-4062903

SERVICES CONSULTANT:

344,Mansarovar plaza,Jaipur

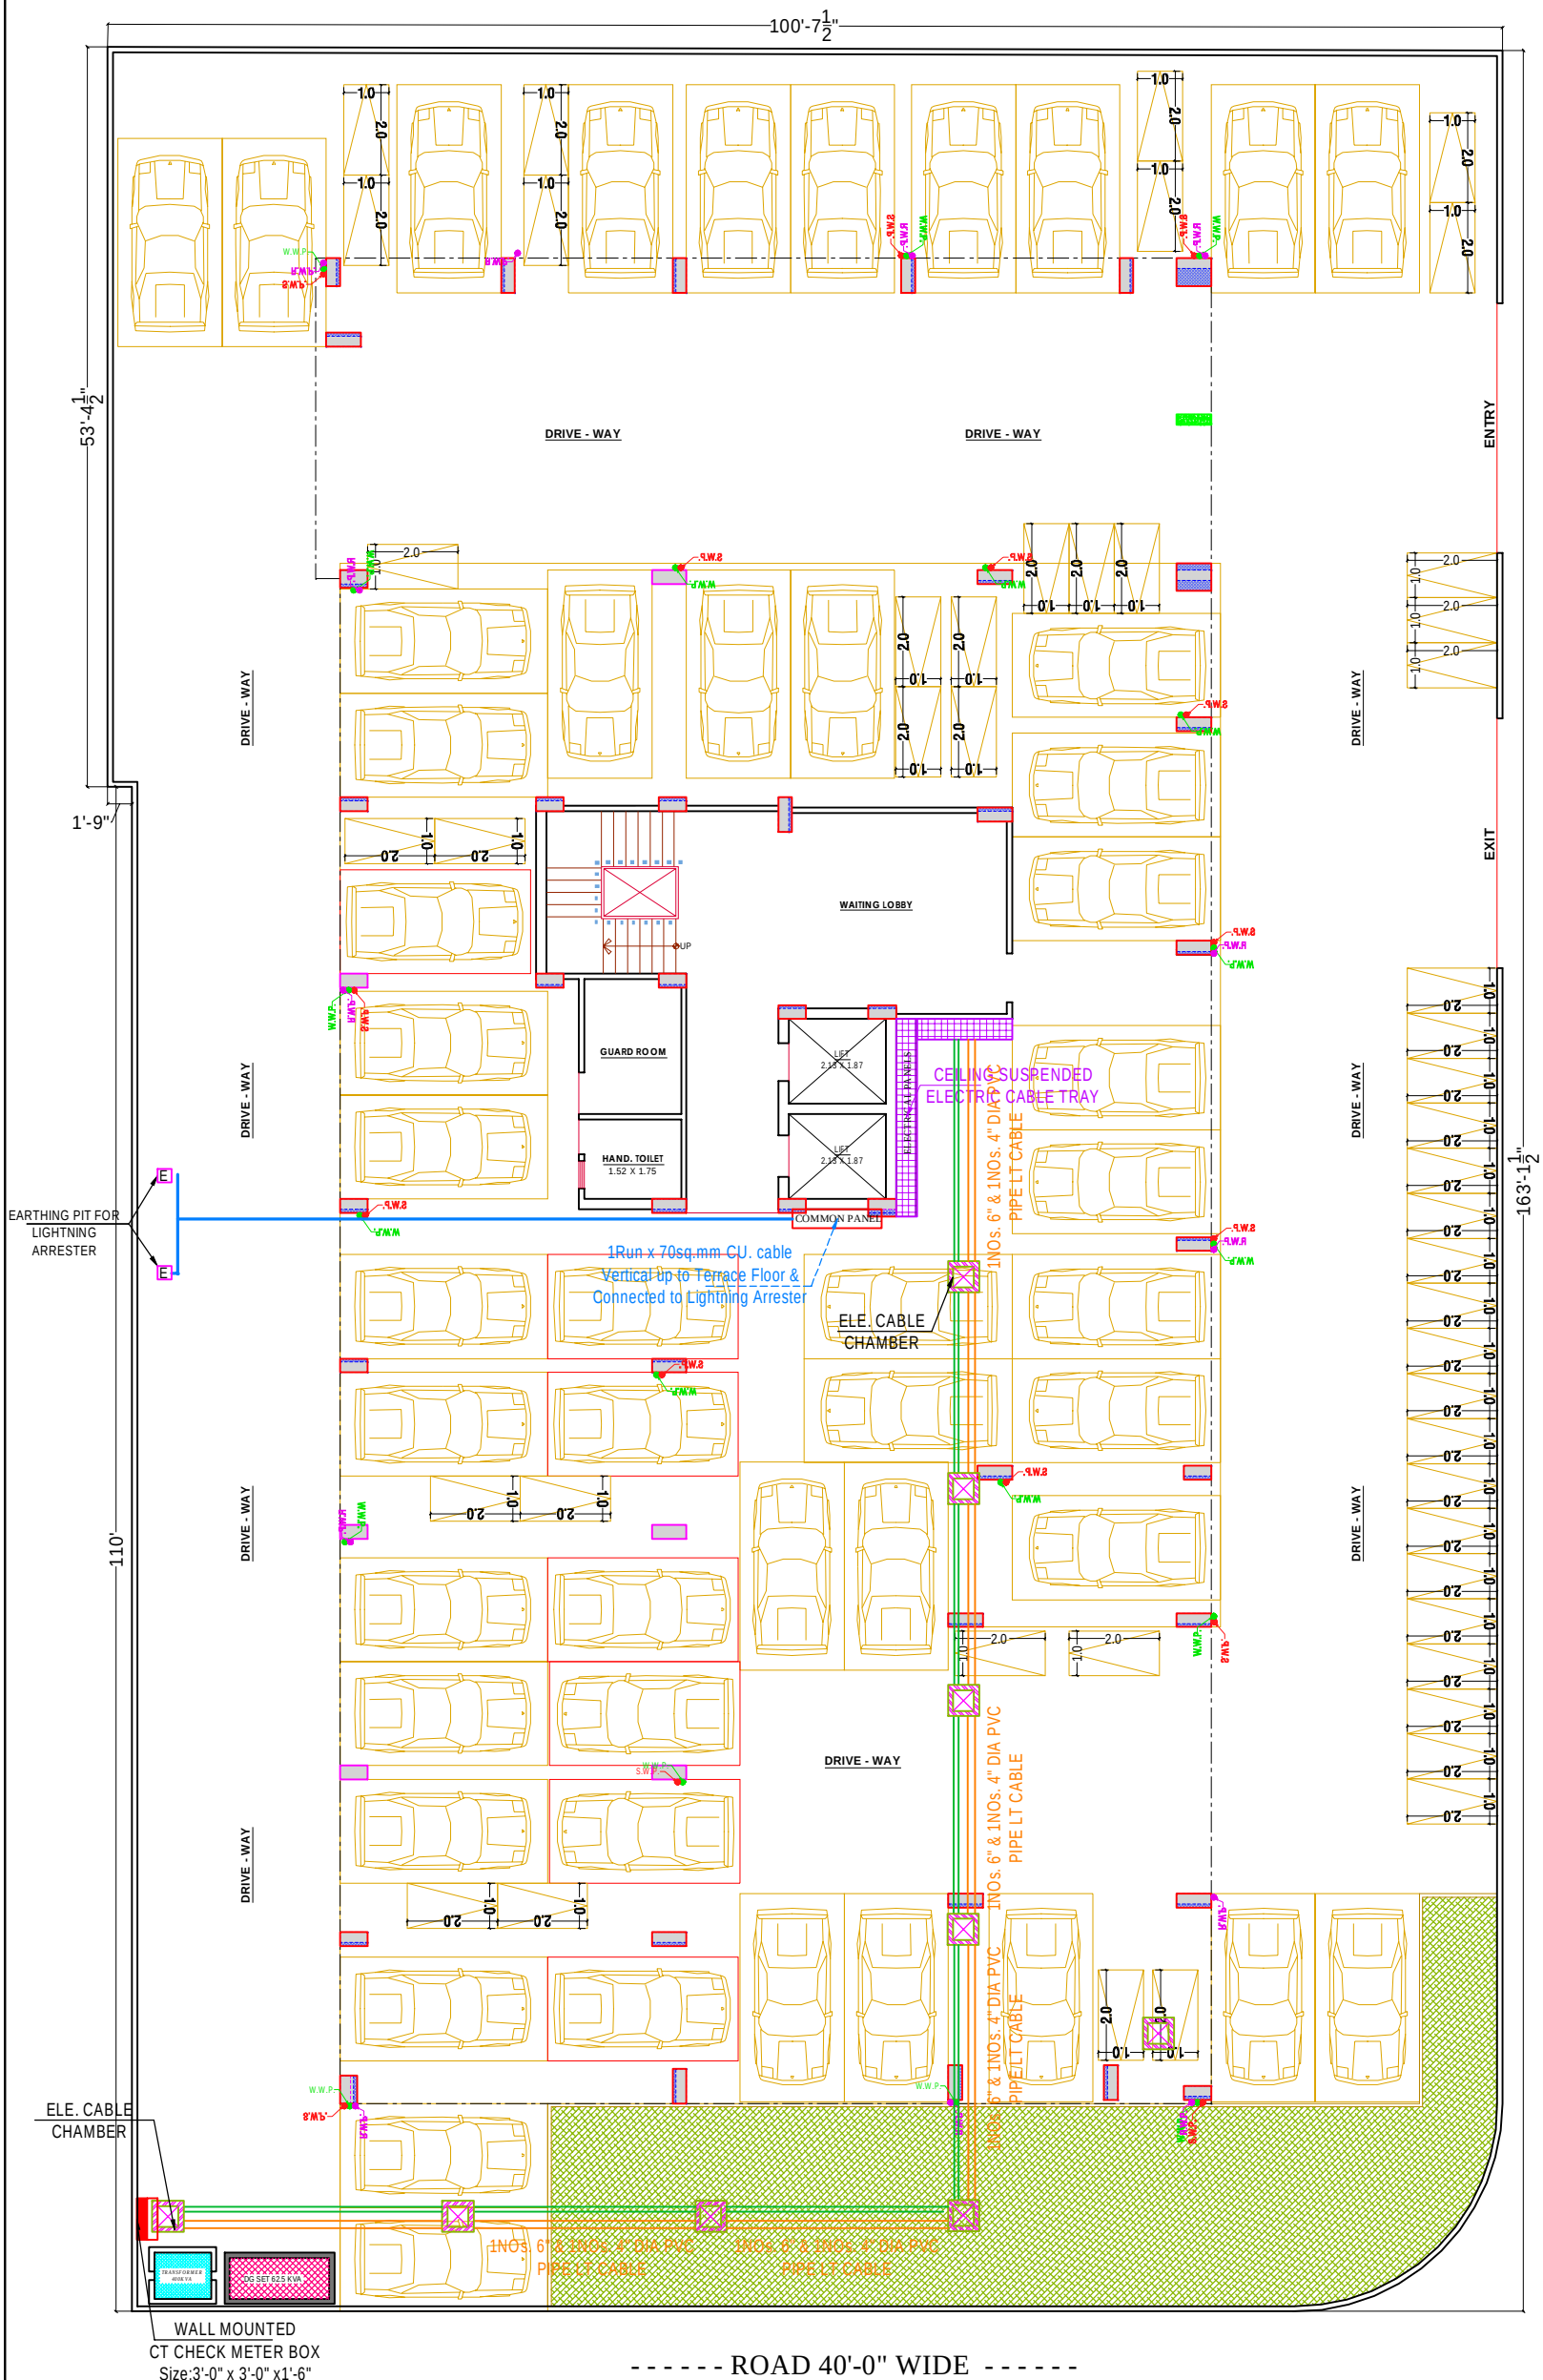

STILT FLOOR PLAN

PROJECT:

THE SHYAM HAVELI
PROPOSED RESIDENTIAL BUILDING AT PLOT
MO. 29, 30, 31, 32, 33 NORTH PART, SCHEME -
NAVJEEVAN GRIHA NIRMAN SHAKARI
SAMEETI, NIRMAN NAGAR A, B, JAIPUR (RAJ)

DRAWING:

STILT FLOOR
ELECTRIC SUB STATION, CABLE ROUTE
& LIGHTNING ARRESTER PLAN

ARCHITECT:


ARCHITECTS, INTERIOR DESIGNERS AND ENGINEERS

SERVICES CONSULTANT:


Naman Yadav
B.Tech (Service Consultant)

344,Mansarovar plaza,Jaipur

 
WORKING LAYOUT PLAN

PROPOSAL PLAN

SH.NO.

01

SCALE: NTS



NOTE

THIS DRAWING IS THE SOLE PROPERTY OF SPACE EDGE ARCHITECTS AND IS NOT TO BE COPIED, USED OR REPRODUCED FOR ANY PURPOSE OTHER THAN FOR WHICH IT HAS BEEN LOANED.



STILT FLOOR PLAN

PROJECT:

THE SHYAM HAVELI

PROPOSED RESIDENTIAL BUILDING AT PLOT
MO. 29, 30, 31, 32, 33 NORTH PART, SCHEME -
NAVJEEVAN GRIHA NIRMAN SHAKARI
SAMEETI, NIRMAN NAGAR A, B, JAIPUR (RAJ)

DRAWING:

STILT FLOOR
TRANS FORMER &
D.G. SET LAOUT PLAN

ARCHITECT:



space
edgeArchitects

ARCHITECTS, INTERIOR DESIGNERS AND ENGINEERS

SERVICES CONSULTANT:



NAMAN YADAV

Naman Yadav
B.Tech (Service Consultant)

 
344,Mansarovar plaza,Jaipur

WORKING LAYOUT PLAN

PROPOSAL PLAN

SH.NO.
01


SCALE: NTS



NOTE

THIS DRAWING IS THE SOLE PROPERTY
OF SPACE EDGE ARCHITECTS AND IS NOT
TO BE COPIED, USED OR REPRODUCED
FOR ANY PURPOSE OTHER THAN FOR
WHICH IT HAS BEEN LOANED.

MAIN PANEL

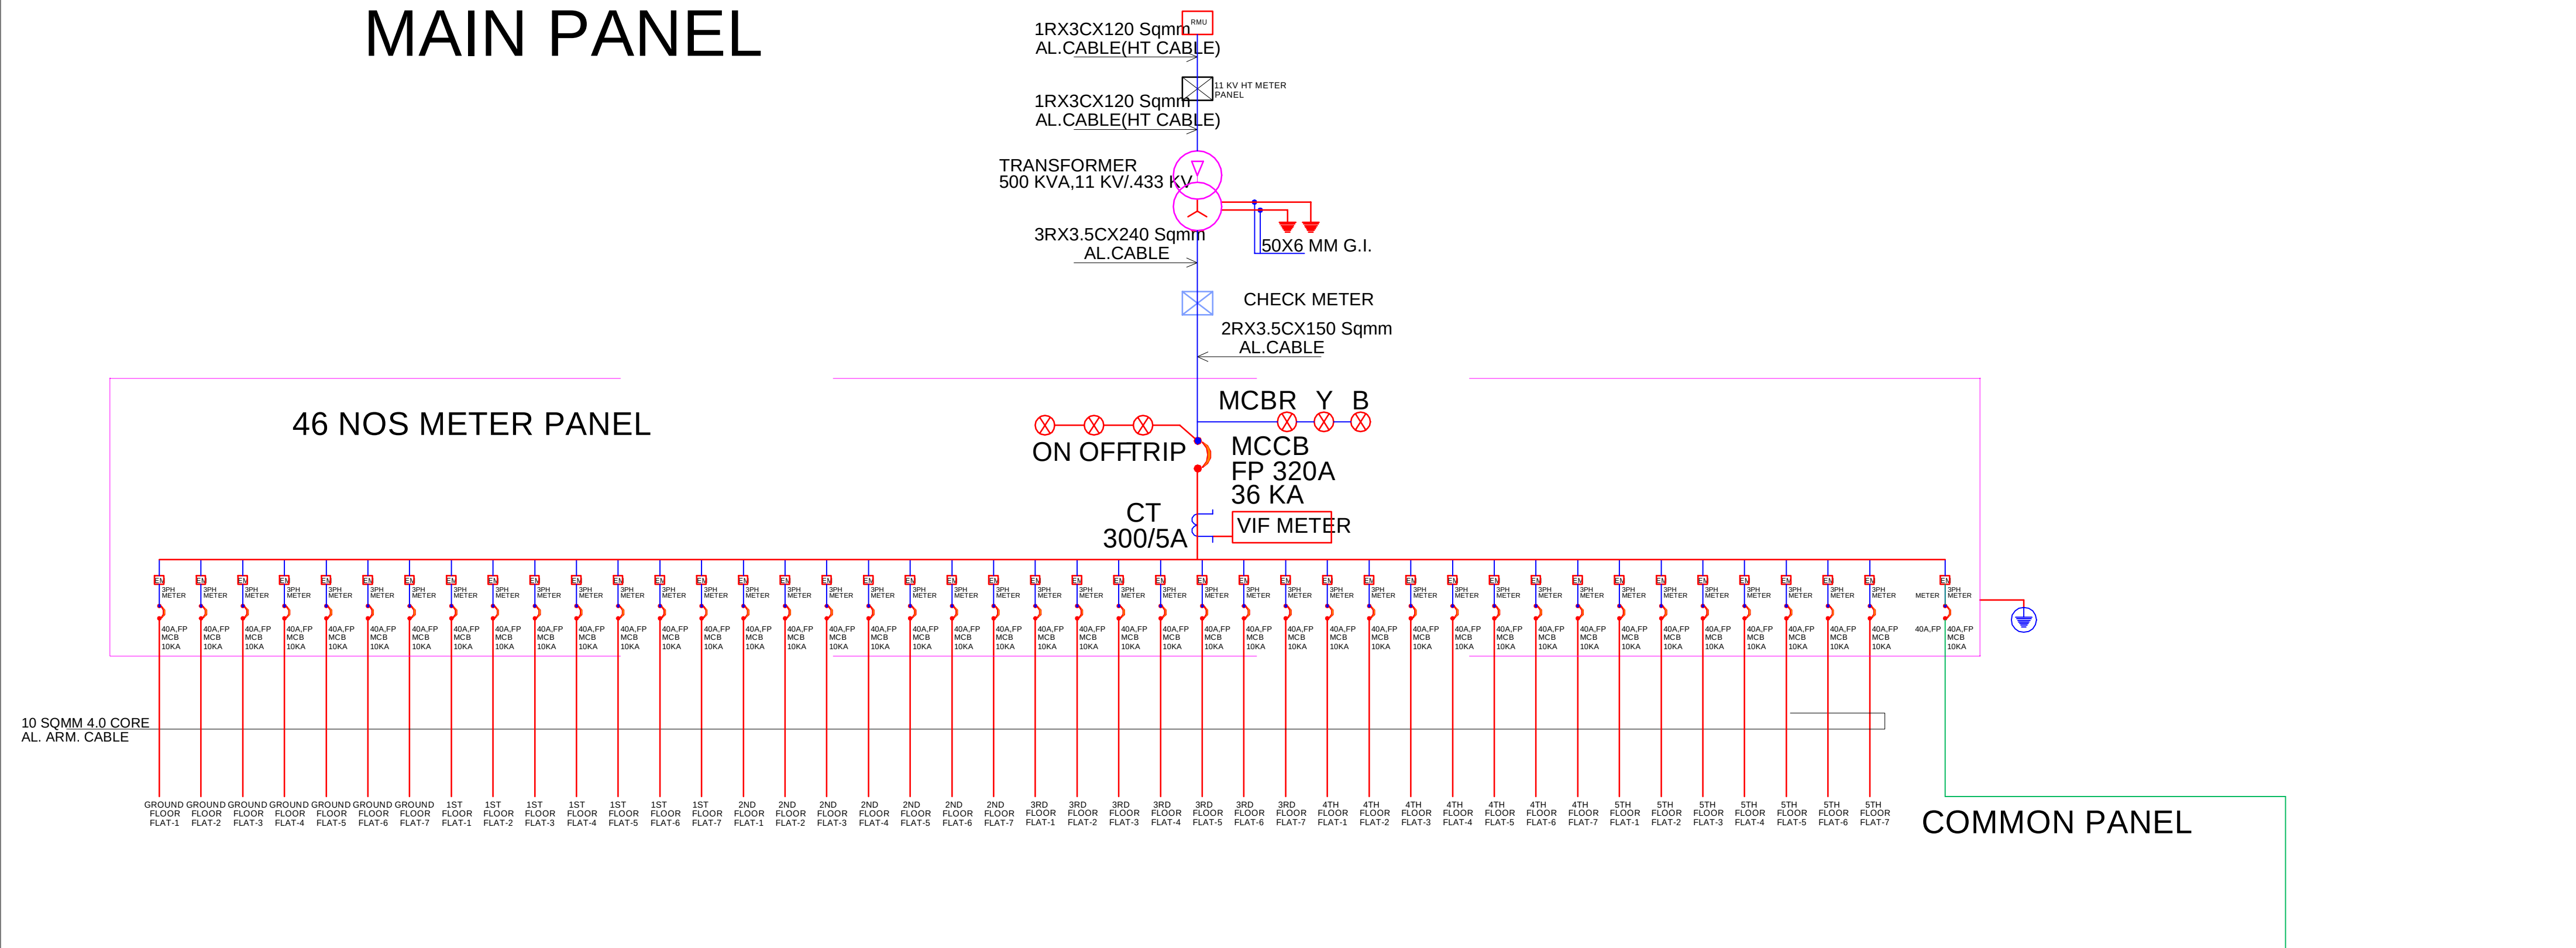

PROJECT:-
THE SHYAM HAVELI
PROPOSED RESIDENTIAL BUILDING AT PLOT NO. 29,
30, 31, 32, 33 NORTH PART, SCHEME - NAVJEEVAN
GRIHA NIRMAN SHAKARI SAMEETI, NIRMAN NAGAR A,
B, JAIPUR (RAJ)

TITLE:-
ELECTRICAL SLD LAY OUT

SERVICE CONSULTANT:-

NAMAN YADAV
Naman Yadav
B.Tech (Service Consultant)

344, Mansarovar plaza, Jaipur

ARCHITECT:-

ARCHITECTS, INTERIOR DESIGNERS AND ENGINEERS

B-6, Moti Marg, Bapu Nagar, Jaipur.
Ph.: 0141-4062903 , +91-9314510603
E-Mail: spaceedgejpr@gmail.com

