


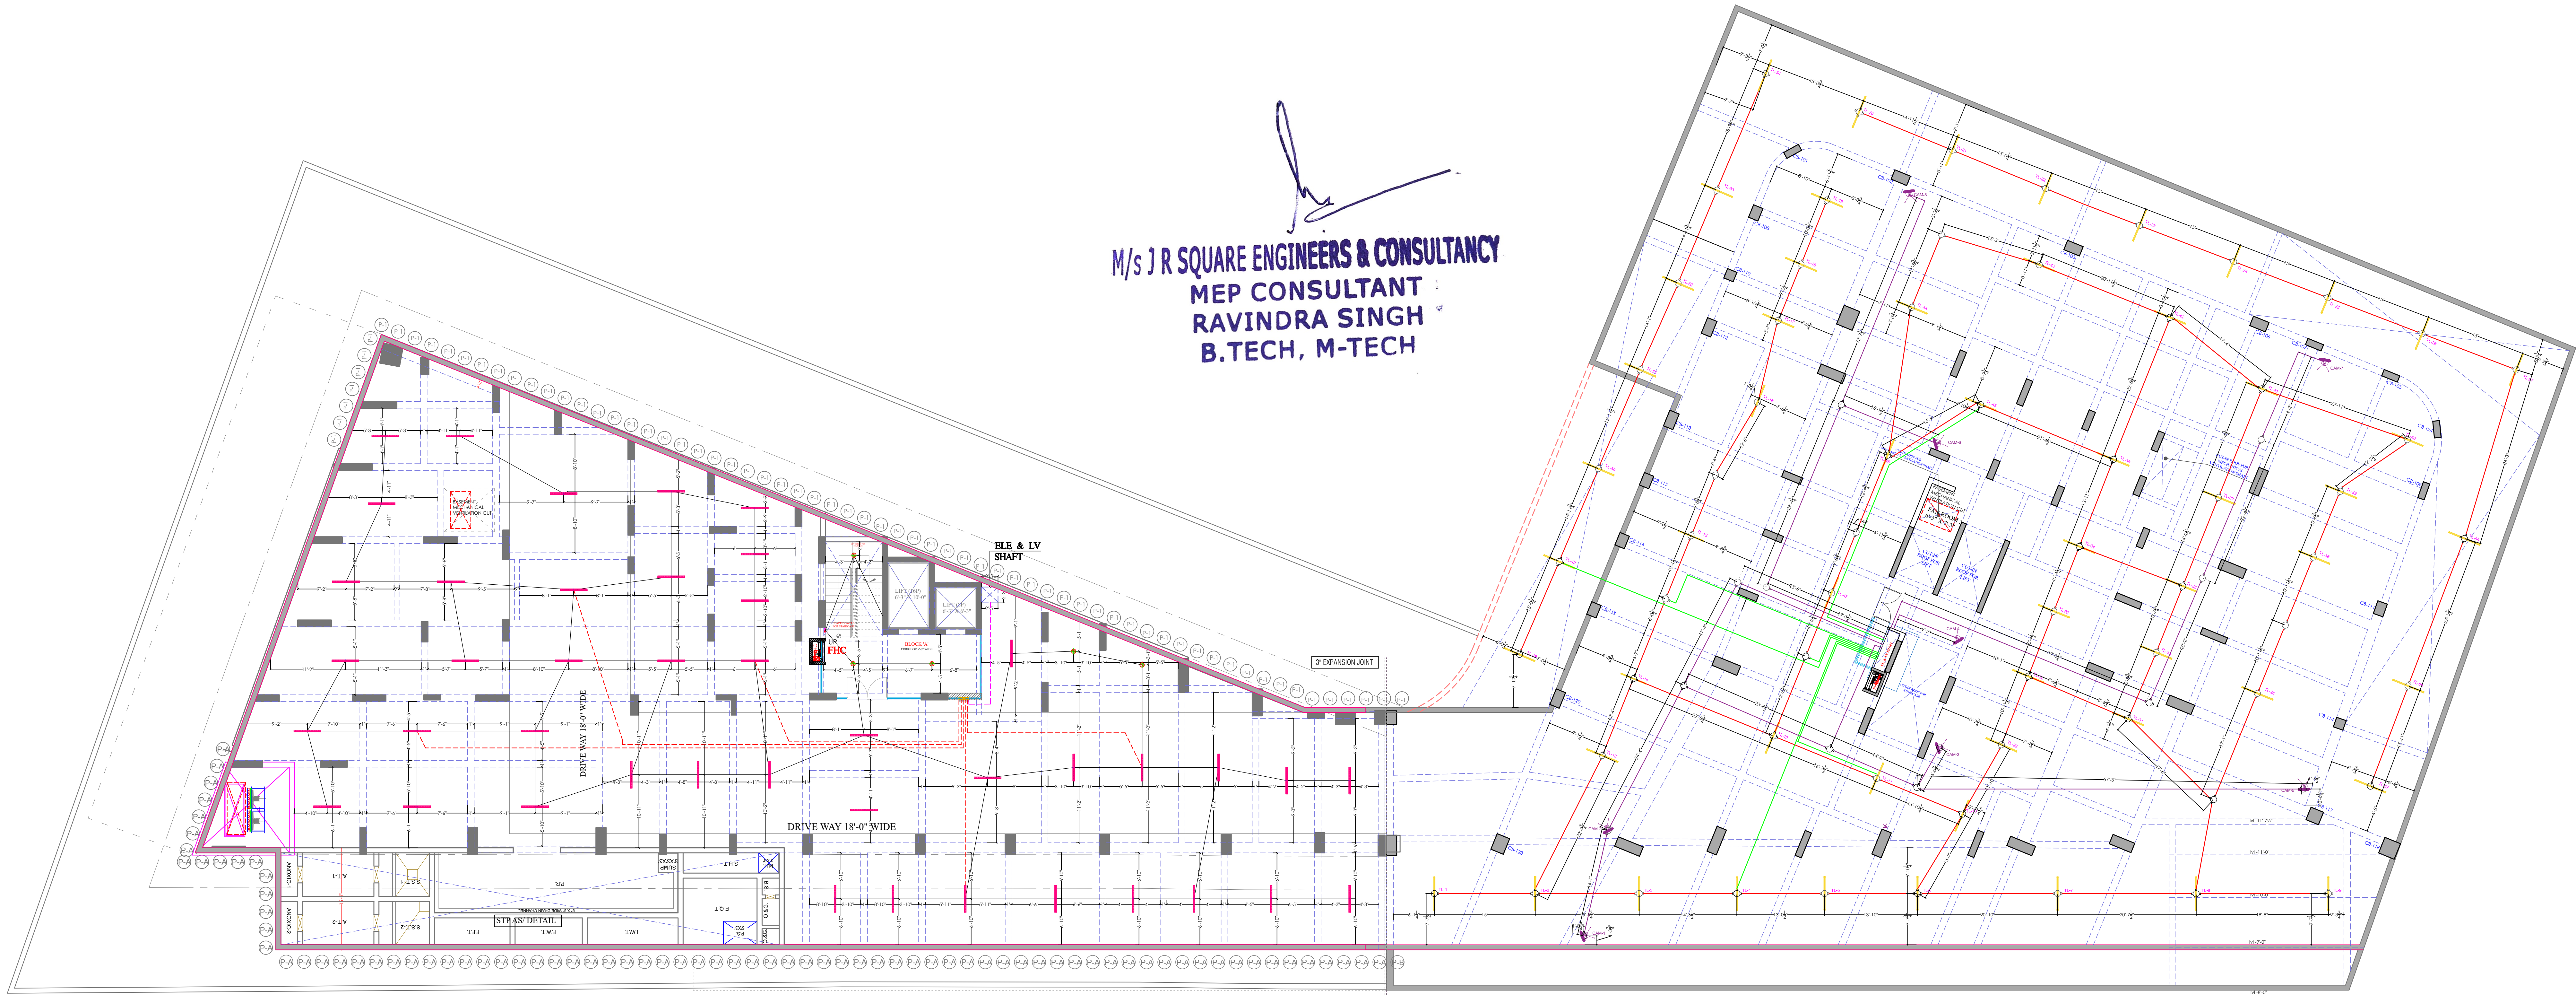

M/s J R SQUARE ENGINEERS & CONSULTANCY
MEP CONSULTANT
RAVINDRA SINGH
B.TECH, M-TECH

DEVELOPER

ARCHITECT

CONSULTANTS

LANDSCAPE ARCHITECT

STRUCTURE CONSULTANT

Vijaytech Consultants Pvt. Ltd.

LEGENDS

Symbol	No.	ICD	Description
SWGR	100	100	SWGR
TRANS	101	101	TRANS
SWGR	102	102	SWGR
TRANS	103	103	TRANS
SWGR	104	104	SWGR
TRANS	105	105	TRANS
SWGR	106	106	SWGR
TRANS	107	107	TRANS
SWGR	108	108	SWGR
TRANS	109	109	TRANS
SWGR	110	110	SWGR
TRANS	111	111	TRANS
SWGR	112	112	SWGR
TRANS	113	113	TRANS
SWGR	114	114	SWGR
TRANS	115	115	TRANS
SWGR	116	116	SWGR
TRANS	117	117	TRANS
SWGR	118	118	SWGR
TRANS	119	119	TRANS
SWGR	120	120	SWGR
TRANS	121	121	TRANS
SWGR	122	122	SWGR
TRANS	123	123	TRANS
SWGR	124	124	SWGR
TRANS	125	125	TRANS
SWGR	126	126	SWGR
TRANS	127	127	TRANS
SWGR	128	128	SWGR
TRANS	129	129	TRANS
SWGR	130	130	SWGR
TRANS	131	131	TRANS
SWGR	132	132	SWGR
TRANS	133	133	TRANS
SWGR	134	134	SWGR
TRANS	135	135	TRANS
SWGR	136	136	SWGR
TRANS	137	137	TRANS
SWGR	138	138	SWGR
TRANS	139	139	TRANS
SWGR	140	140	SWGR
TRANS	141	141	TRANS
SWGR	142	142	SWGR
TRANS	143	143	TRANS
SWGR	144	144	SWGR
TRANS	145	145	TRANS
SWGR	146	146	SWGR
TRANS	147	147	TRANS
SWGR	148	148	SWGR
TRANS	149	149	TRANS
SWGR	150	150	SWGR
TRANS	151	151	TRANS
SWGR	152	152	SWGR
TRANS	153	153	TRANS
SWGR	154	154	SWGR
TRANS	155	155	TRANS
SWGR	156	156	SWGR
TRANS	157	157	TRANS
SWGR	158	158	SWGR
TRANS	159	159	TRANS
SWGR	160	160	SWGR
TRANS	161	161	TRANS
SWGR	162	162	SWGR
TRANS	163	163	TRANS
SWGR	164	164	SWGR
TRANS	165	165	TRANS
SWGR	166	166	SWGR
TRANS	167	167	TRANS
SWGR	168	168	SWGR
TRANS	169	169	TRANS
SWGR	170	170	SWGR
TRANS	171	171	TRANS
SWGR	172	172	SWGR
TRANS	173	173	TRANS
SWGR	174	174	SWGR
TRANS	175	175	TRANS
SWGR	176	176	SWGR
TRANS	177	177	TRANS
SWGR	178	178	SWGR
TRANS	179	179	TRANS
SWGR	180	180	SWGR
TRANS	181	181	TRANS
SWGR	182	182	SWGR
TRANS	183	183	TRANS
SWGR	184	184	SWGR
TRANS	185	185	TRANS
SWGR	186	186	SWGR
TRANS	187	187	TRANS
SWGR	188	188	SWGR
TRANS	189	189	TRANS
SWGR	190	190	SWGR
TRANS	191	191	TRANS
SWGR	192	192	SWGR
TRANS	193	193	TRANS
SWGR	194	194	SWGR
TRANS	195	195	TRANS
SWGR	196	196	SWGR
TRANS	197	197	TRANS
SWGR	198	198	SWGR
TRANS	199	199	TRANS
SWGR	200	200	SWGR

KEY PLAN :- NORTH :-

PROJECT:- 14 WOODLAND PARK
AT SHIPRA PATH
MANSAROVAR, JAIPUR

CLIENT:- MANGALAM


DRAWING TITLE:- LOWER BASEMENT
ELECTRIC CONDUIT PLAN

09-10-2021

CHECKED BY:- SANJAY DRG.NO.

DEALT BY:- RAJENDER

DRAWN BY:-

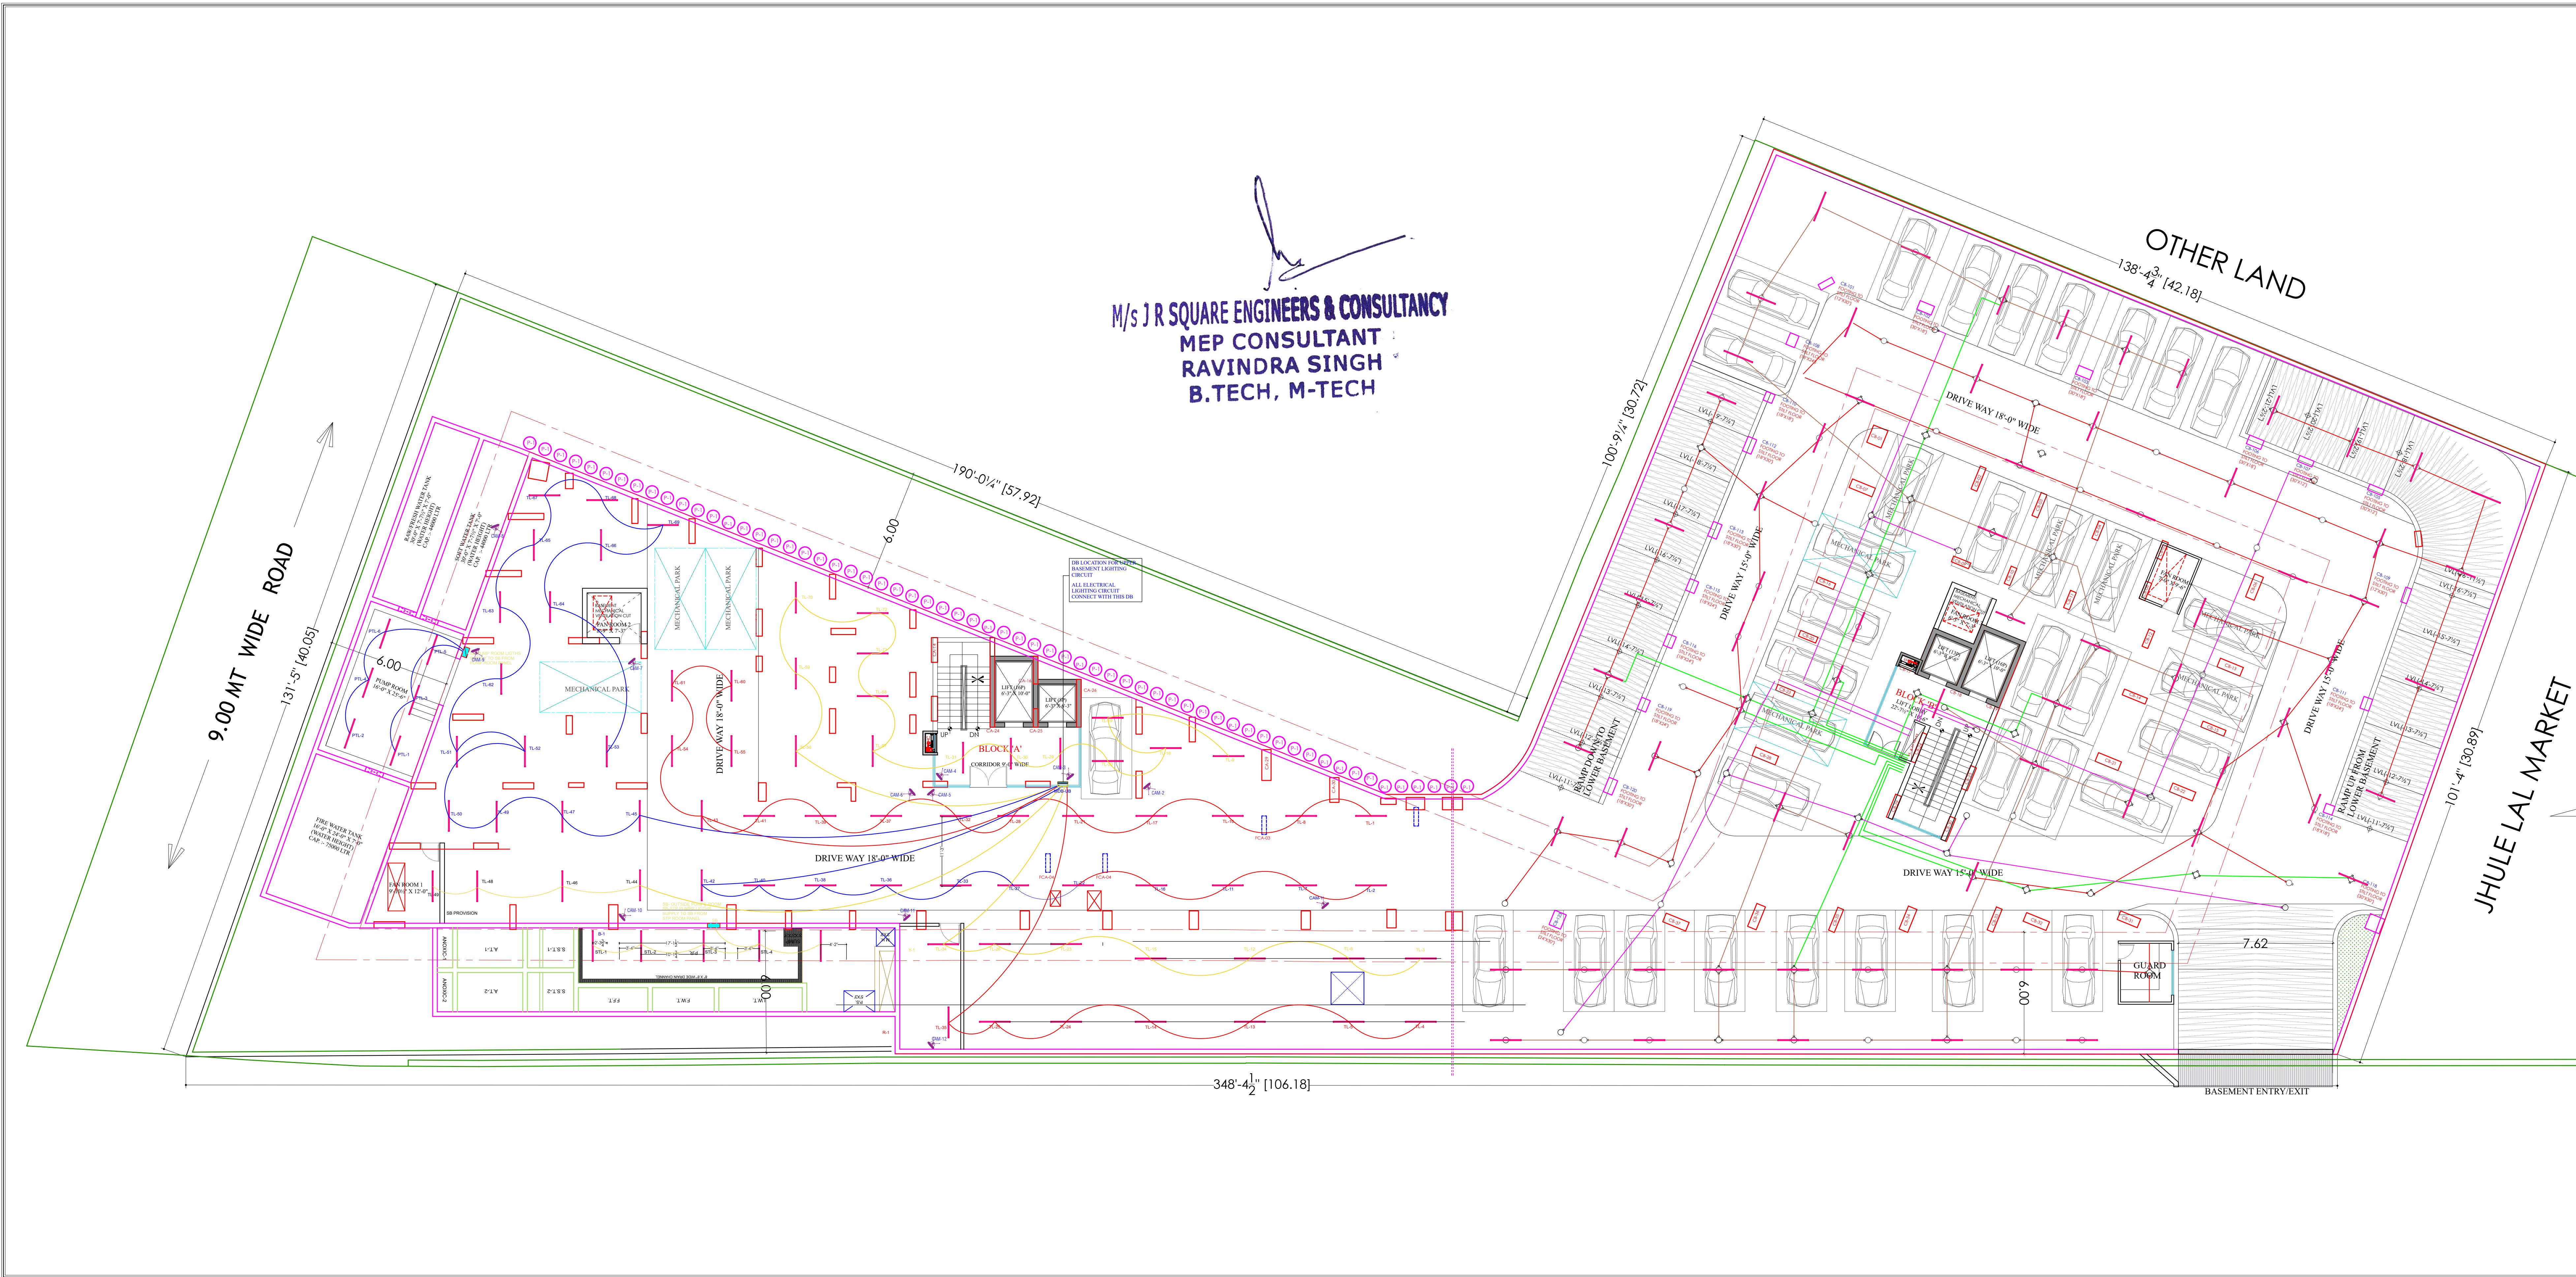



आपका सपना हमारा प्रयास

ARCHITECT

124, HIMMAT NAGAR, TONK ROAD, JAIPUR
PHONE - 0141-2706227, 2712377
email- ideasjaipur@gmail.com, web- www.ideasjaipur.com

MEP CONSULTANT :

NOTE:- MEP COMMENT

- (1) THE DRIVE WAY LIGHTING SHOULD BE ON ALTERNATE CIRCUIT.
- (2) EVERY CIRCUIT CANNOT CONNECT WITH THE DB AT LCA OR IN BASEMENT IN THE WAY.
- (3) 2000 MM. HIGH PVC CONDUIT SHOULD BE USED IN RCC SLAB.
- (4) USE 25 MM DEEP EMBEDMENT BOX IN RCC SLAB FOR LIGHTING FIXTURE.
- (5) CONDUIT DETAILS SHALL BE SHOWN IN OTHER DRAWING.
- (6) PARKING AREA LIGHTS SHOULD BE CONTROLLED BY SEPARATE CIRCUIT OR ALTERNATELY.
- (7) CAMERA CORDIT SHOULD BE TAKEN TO LIFT LOBBY AREA AS SHOWN IN SHEET. THE SAME SHALL BE LATER CONNECT WITH CCTV ROOM.

LEGENDS:

Mounting	Qty.	Symbol	Description
RECON SLAB	72		RED LIGHT FIBER CABLE W/POWERS
RECON SLAB	8		GREEN CABLES - RECON CABLES
IN RCC			BLUE WIRE PVC CONDUIT CABLES
IN RCC			YELLOW WIRE PVC CONDUIT CABLES
IN RCC			ORANGE WIRE PVC CONDUIT CABLES
IN RCC	32		BLACK WIRE PVC CONDUIT CABLES
IN RCC	21		GREY WIRE PVC CONDUIT CABLES
IN RCC	08		LIGHT BLUE WIRE PVC CONDUIT CABLES
IN RCC	48		DARK BLUE WIRE PVC CONDUIT CABLES
IN RCC	15		PURPLE WIRE PVC CONDUIT CABLES

MEP CONSULTANT :



Engineers & Consultancy Pvt. Ltd.

53 & 54, 2nd Floor Jaipur Electronic Market, Radhi Sidhi Circle, Gopal pura by Pass Road, Jaipur (Raj)
Ph: 8696311408, 9971998408
Email:- ravisingh72@gmail.com ;
ravis@jrsquareengineers.com

NOTES :-

- 1) THIS DRAWING IS PROPERTY OF IDEAS, JAIPUR.
- 2) UNAUTHORIZED USE OF THIS DRAWING WITHOUT PERMISSION IS STRICTLY PROHIBITED.
- 3) ALL DIMENSIONS ARE IN MM. UNLESS NOTED OTHERWISE.
- 4) ANY DISCREPANCY ARISING SHOULD BE INFORMED TO THE ARCHITECT IMMEDIATELY.

NO.	DATE	PRINT ISSUED TO

REVISIONS:-

S.No.	DATE	REMARKS
R-01	04.04.2022	GFC

KEY PLAN :-

PROJECT:-	14 WOODLAND PARK AT SHIPRA PATH MANSAROVAR, JAIPUR
CLIENT:-	MANGALAM
DRAWING TITLE	UPPER BASEMENT FLOOR LIGHTING & CCTV LAYOUT BLOCK-B
DATE:-	04.04.2022
CHECKED BY:-	RAVI
DEALT BY:-	DEVENDRA
DRAWN BY:-	DEVENDRA