


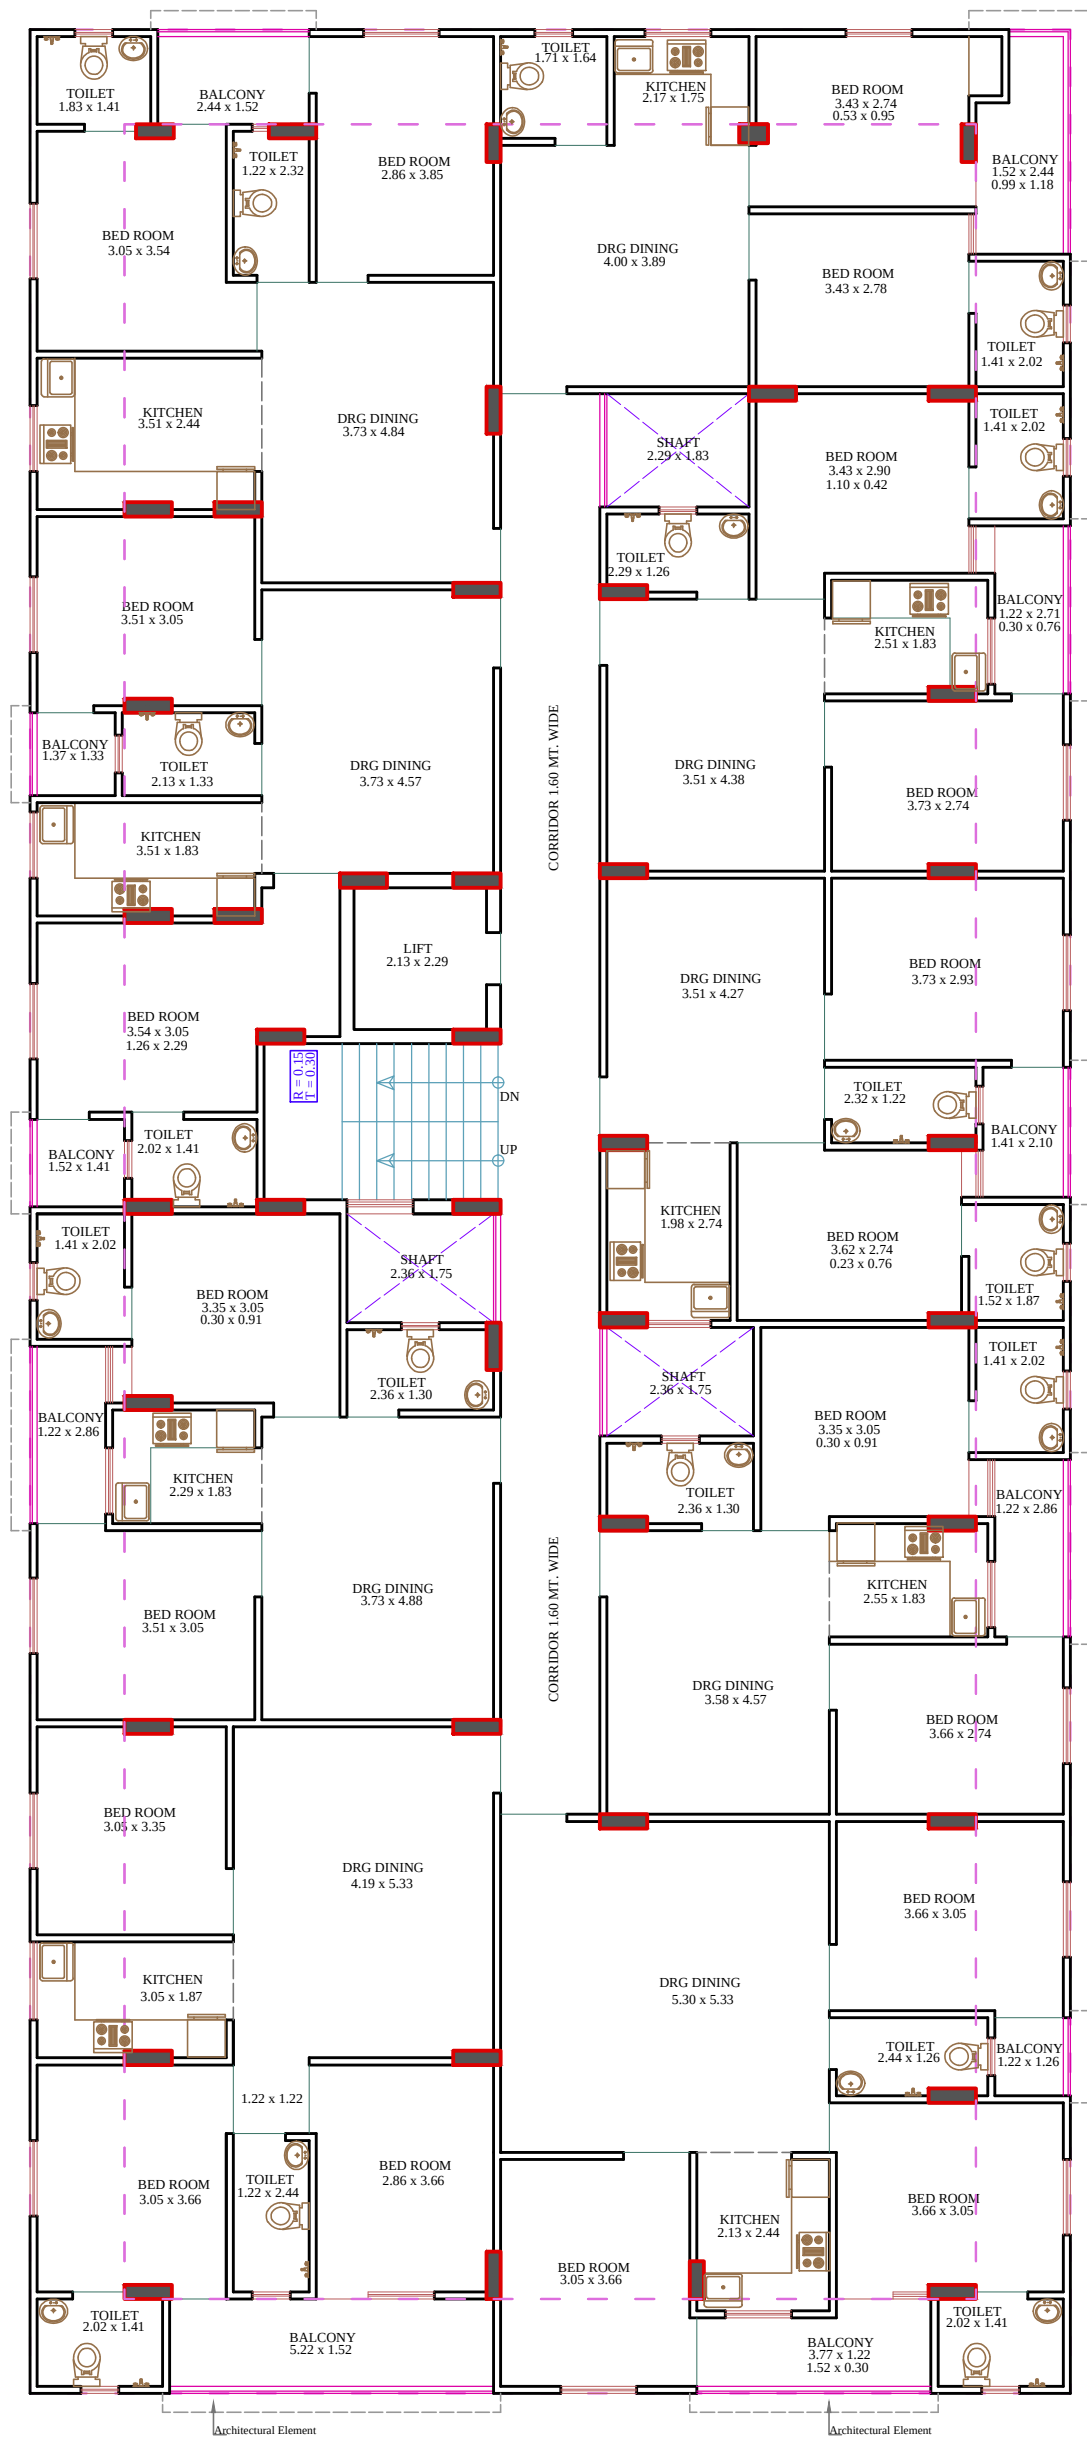


GROUND, 1st to 5th Floor Plan

All Heights For Finish Floor Lvl	SYMBOL	SYMBOL	DESCRIPTION
+1000MM			Ø 20MM CWS PIPE THRU WALL CHASE TO SINK
			Ø 20MM HWS PIPE THRU WALL CHASE TO SINK
+1950MM			Ø 20MM CWS PIPE THRU WALL CHASE TO GEYSER
			Ø 20MM HWS PIPE THRU WALL CHASE FROM GEYSER
+1500MM			Ø 20MM CWS PIPE THRU WALL CHASE TO AQUAGUARD
+450MM			Ø 20MM CWS PIPE THRU WALL CHASE TO BASIN ANGLE VALVE
+800MM			Ø 20MM HWS PIPE THRU WALL CHASE TO BASIN ANGLE VALVE
+2100MM			Ø 20MM CWS PIPE THRU WALL CHASE TO CONCEALED STOP COCK
+300MM			Ø 20MM CWS PIPE THRU WALL CHASE TO FAUCET
+1000MM WALL MIXER DIVERTOR			Ø 20MM CWS PIPE THRU WALL CHASE TO WALL MIXER / DIVERTOR
+2025MM O.H.SHOWER			Ø 20MM HWS PIPE THRU WALL CHASE TO WALL MIXER / DIVERTOR
+600MM			Ø 20MM CWS PIPE THRU WALL CHASE TO TAP
+450MM			Ø 20MM CWS PIPE THRU WALL CHASE TO CISTERN ANGLE VALVE
+1200MM			Ø 20MM CWS PIPE THRU WALL CHASE TO URINAL ANGLE VALVE
+450MM			Ø 20MM CWS PIPE THRU WALL CHASE TO BASIN ANGLE VALVE
+1000MM	AS PER/ARCHL		SOAP DISH
+1500MM	AS PER/ARCHL		TOWEL RAIL
+450MM	AS PER/ARCHL		PAPER HOLDER
			COLD WATER SUPPLY LINE
			HOT WATER SUPPLY LINE

RAMESH KUMAWAT
M.E.P. CONSULTANT
B.E. CIVIL

PROJECT TITLE :- PROPOSED BUILDING AT PLOT NO. C-8,9,10, SHREE RAM VIHAR-C, JAIPUR	DRAWING TITLE :- TYPICAL FLOOR PLUMBING	SPACE CONSULTANT PLOT-A-173, JAGDAMBA NAGAR, HEERAPURA POWER HOWER, JAIPUR (RAJ) 302024	DRN. BY		DATE	NORTH
			APPD. BY		REVISION	
			SCALE	N.T.S		

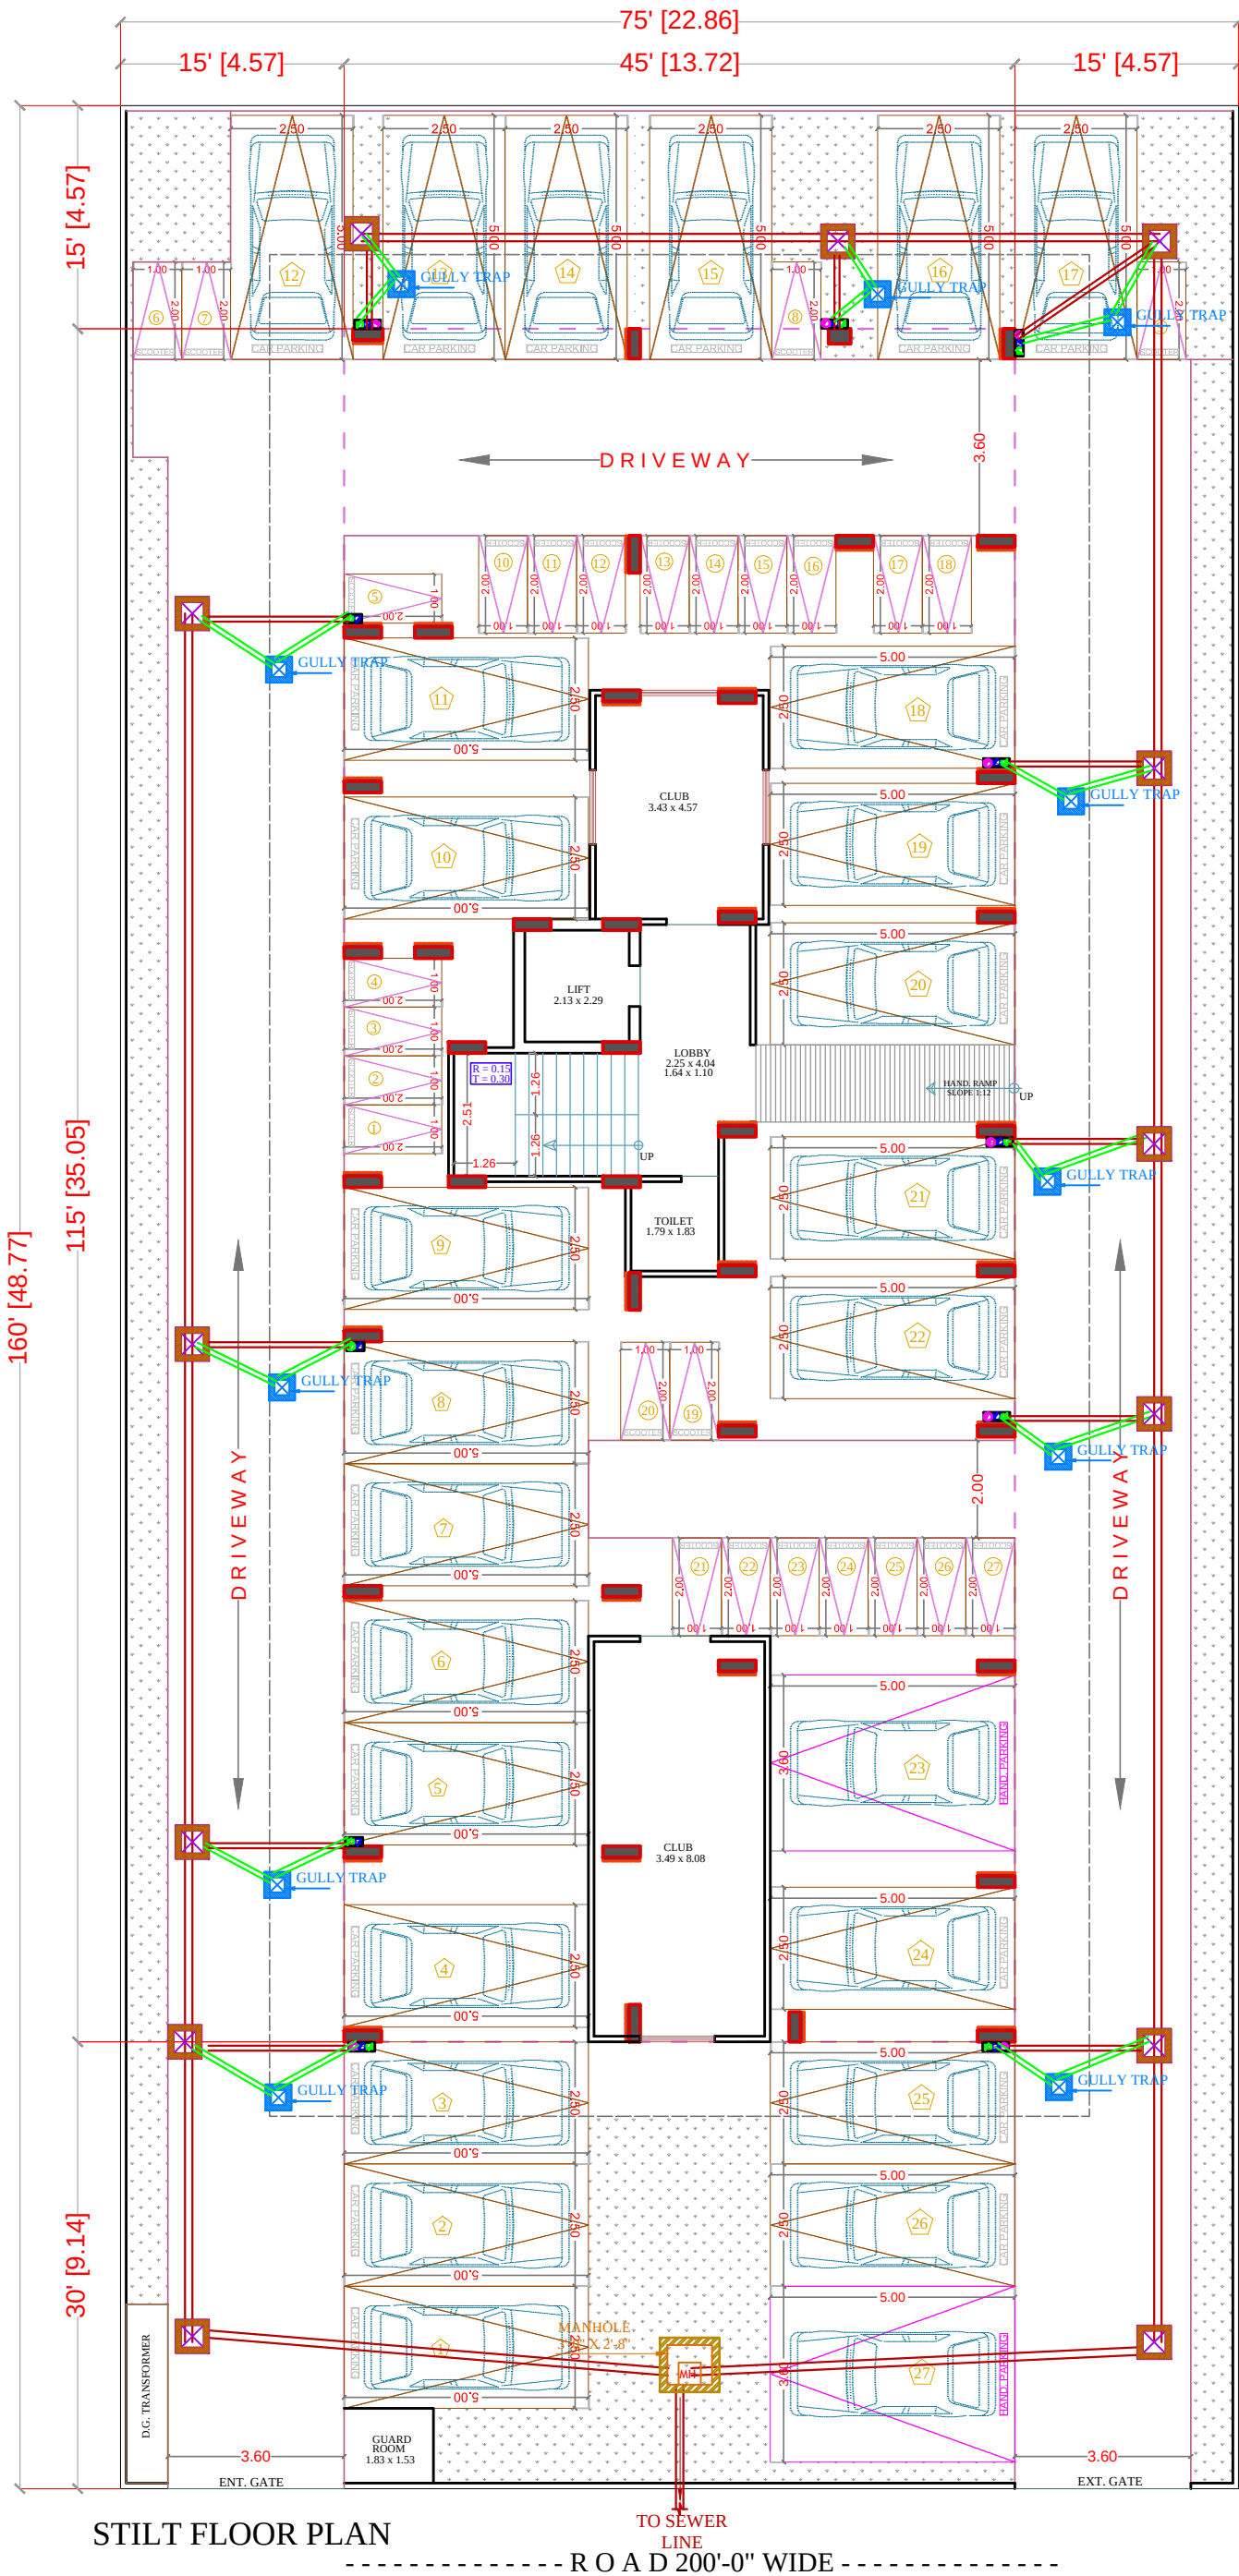

SYMBOL	DESCRIPTION
	Ø 110 mm Soil Waste Water Pipe
	Ø 110 mm Waste Water Pipe
	Ø 110 mm Rain Water Pipe
	Ø 160 mm Soil Waste Water Pipe Slope 1:150
	Ø 110 mm Soil Waste Water Pipe Slope 1:150
	Ø 110 mm Waste Water Pipe Slope 1:150
	Ø 75 mm Waste Water Pipe Slope 1:150
	50mm Waste Water Pipe Bottle Trap
	Floor Trap
	P-Trap Required
	Gully Trap-12"X12" Depth According to Slope
	Main Hole-18"X18" Depth According to Slope
	Main Hole-24"X24" Depth According to Slope
	Main Hole-36"X32" Depth According to Slope
	Flow Direction

RAMESH KUMAWAT
M.E.P. CONSULTANT
B.E. CIVIL

SPACE CONSULTANT

PLOT-A-173, JAGDAMBA NAGAR, HEERAPURA
POWER HOWER, JAIPUR (RAJ.) 302024

ARCHITECT :-

FRANK SQUARE
C-49 VIDYA APARTMENT PARAS MARG,
BAPU NAGAR JAIPUR, (RAJ.)
Email-afranksquare@gmail.com
Mobile-9461302542

PROJECT :-

PROPOSED BUILDING AT PLOT
NO. C-8,9,10, SHREE RAM
VIHAR-C, JAIPUR

DRAWING:
STILT FLOOR
EXTERNAL SEWERAGE
CHAMBER & PIPE ROUTE FOR
RERA SUBMISSION PLAN

DATE
SCALE:-
N.T.S.