



PROPOSED COMMERCIAL @ GOVIND MARG
GROUND FLOOR PLAN

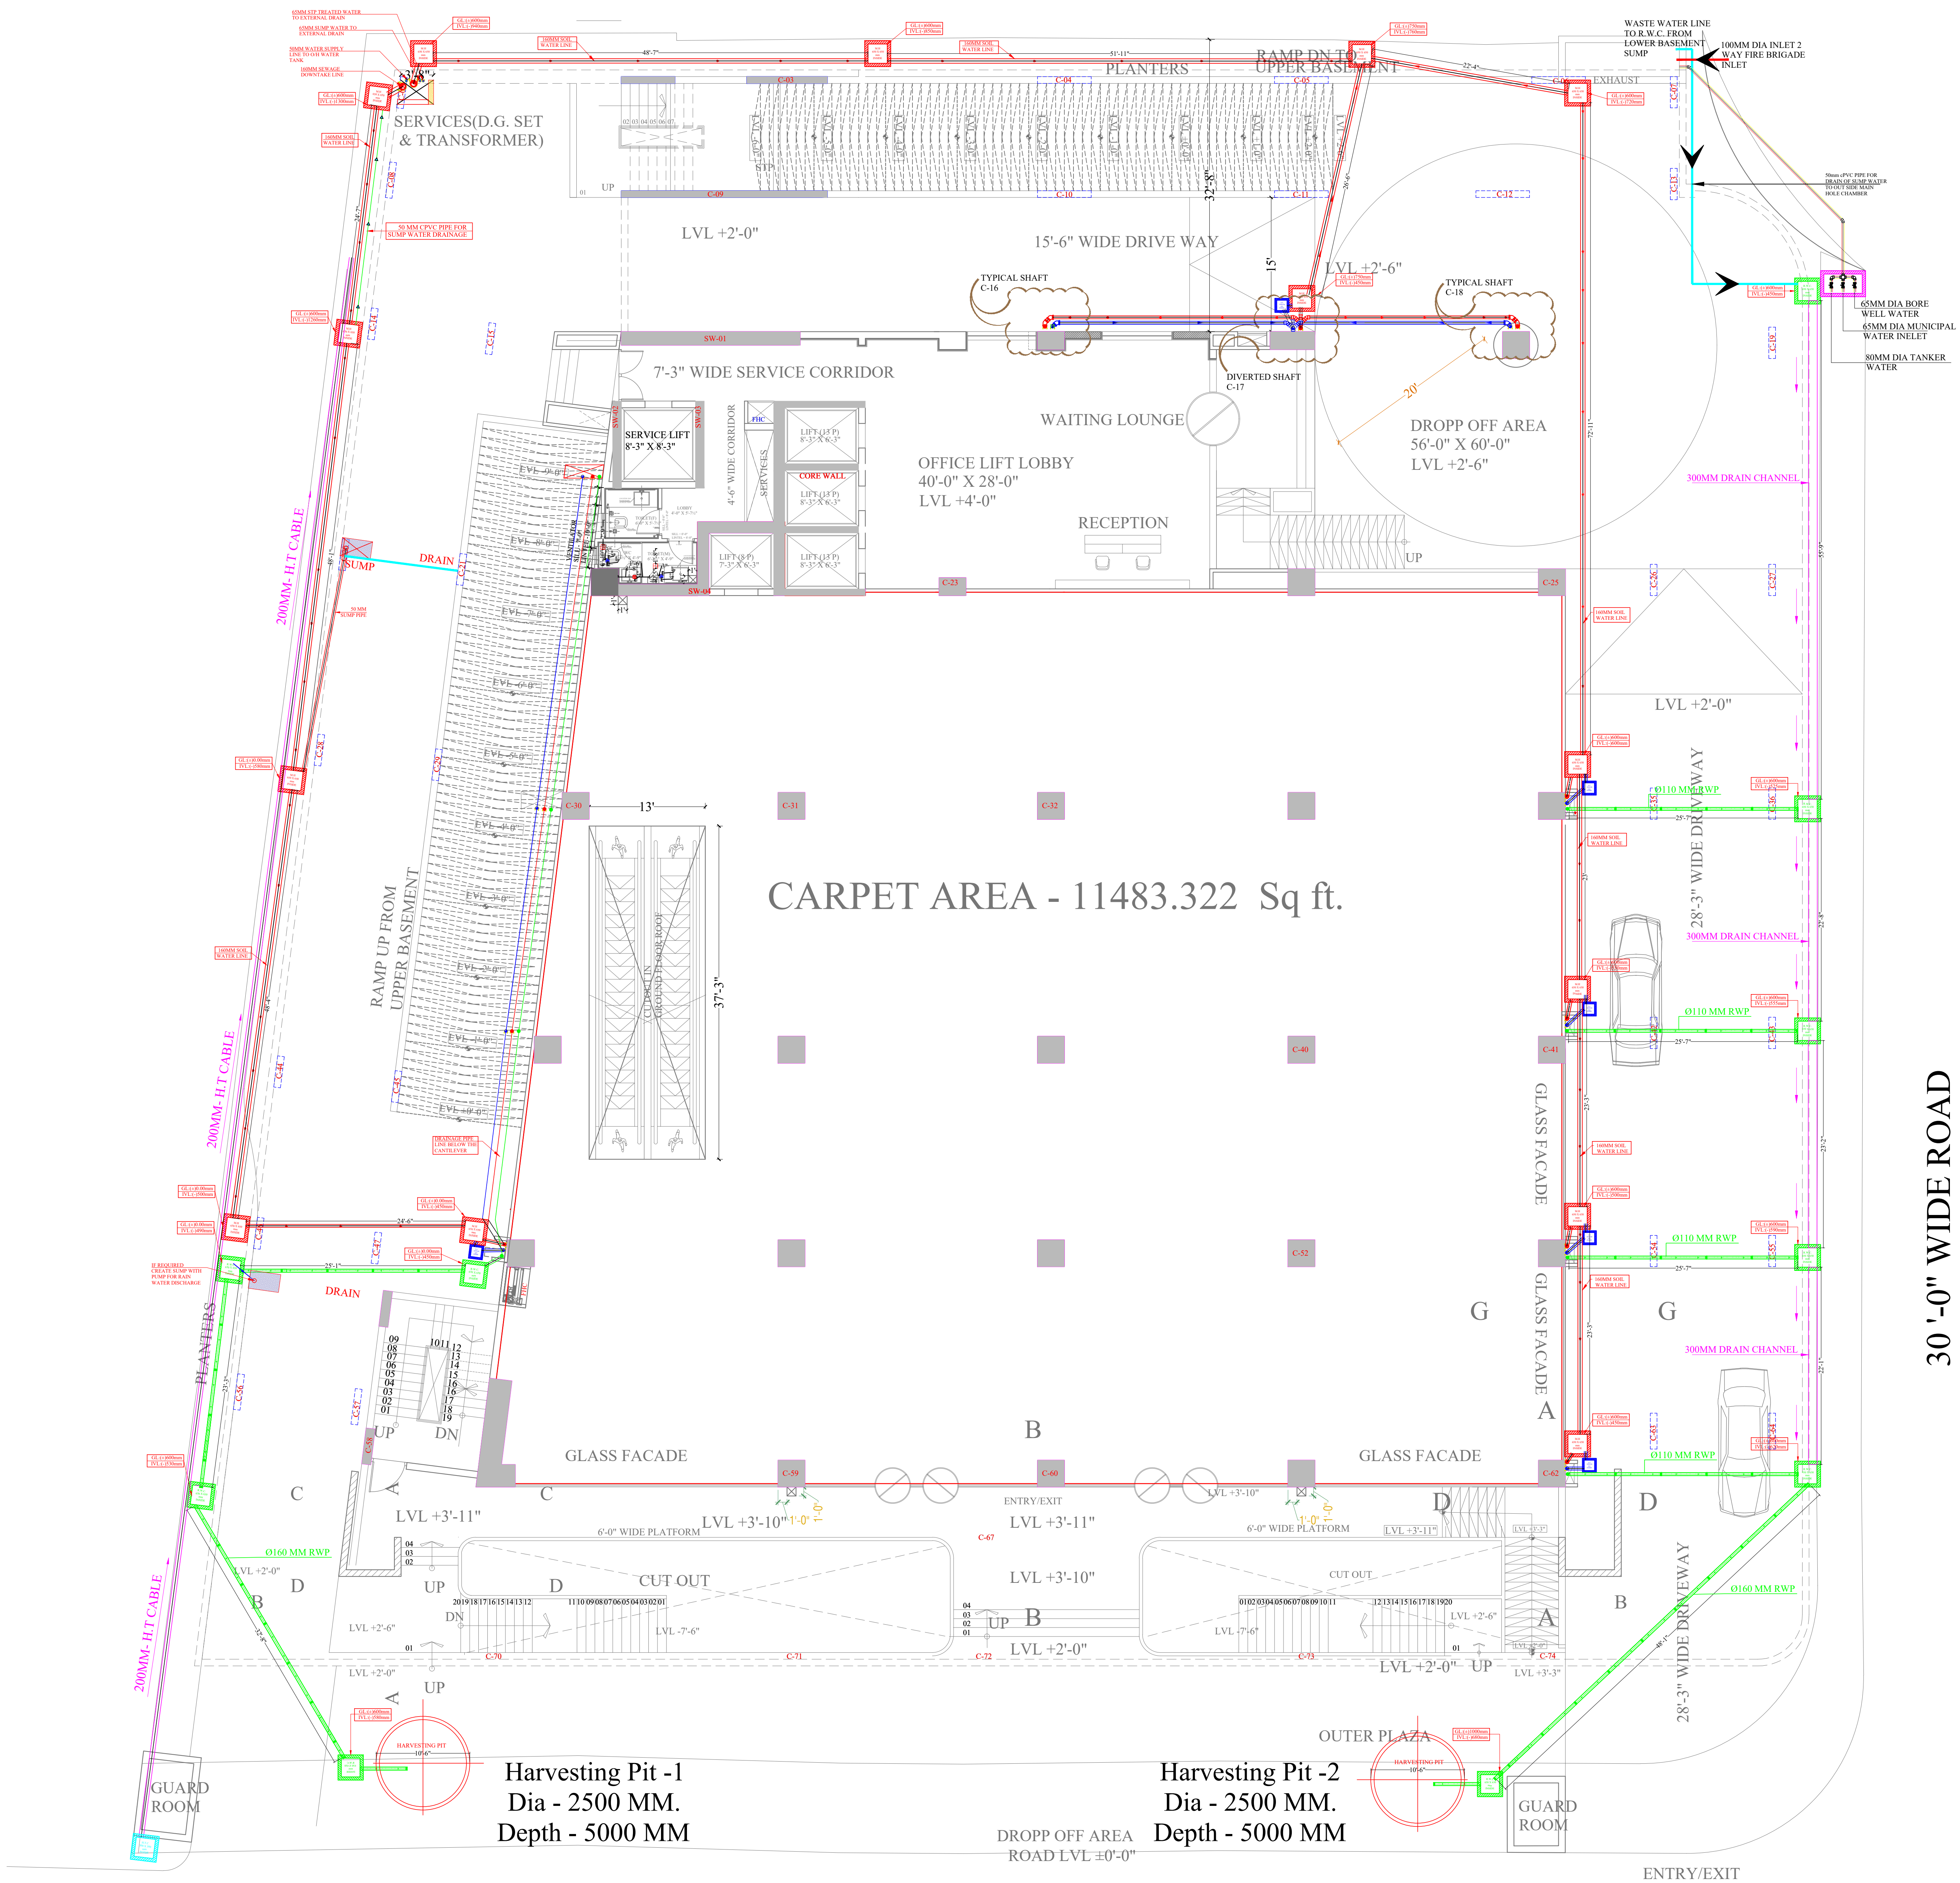


100 '-0" WIDE ROAD GOVIND MARG

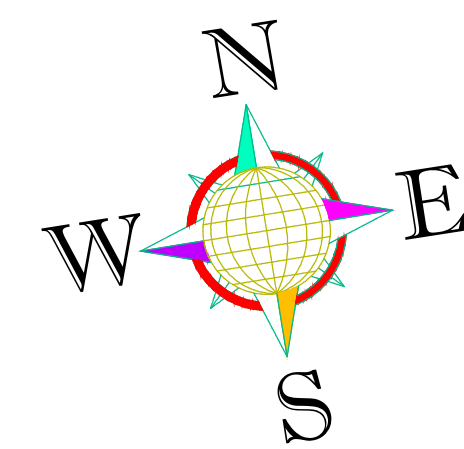

DEVELOPER

DEVELOPER
M/S SIGNATURE ELITE DEVELOPERS
6TH FLOOR, APEX MALL, LAL KOTHI,
TONK ROAD, JAIPUR, RAJASTHAN

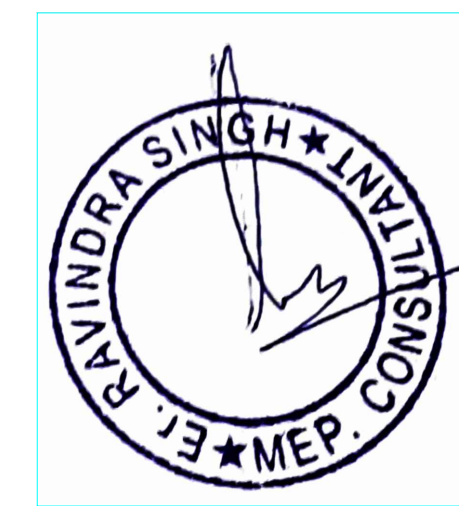

ARCHITECT

ideas
ARCHITECTURE | URBAN PLANNING | INTERIORS


I 24, HIMMAT NAGAR , TONK ROAD , JAIPUR
PHONE - 0141-2706227, 2712377
email: studio@ideasjaipur.com, web: www.ideasjaipur.com

CONSULTANTS

LANDSCAPE ARCHITECT:-

INTERIOR CONSULTANT :

STRUCTURE CONSULTANT :

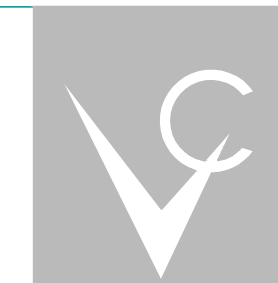

Vijaytech Consultants Pvt. Ltd.
CONSULTING ENGINEERS
H-17, GAUTAM MARG, SHYAM NAGAR, JAIPUR-302019 INDIA
Phone : 91-141-2294432, 3257592, Fax : 91-141-4023198
Email : vijaytech.jr@gmail.com

MEP CONSULTANT :

JR Square
Engineers & Consultancy Pvt. Ltd.
UG-16 Jaipur Electronic Market, Ridhi Sidhi
Circle, Gopal pura by Pass Road , Jaipur (Raj)
Ph: 8696311408, 9971998408
Email: - ravi@jrsquareengineers.com ;
ravi@jrsquareengineers.com


NOTES :-

- 1) THIS DRAWING IS PROPERTY OF IDEAS - JAIPUR
- 2) UNAUTHORIZED USE OF THIS DRAWING WITHOUT PERMISSION IS STRICTLY PROHIBITED
- 3) ALL DIMENSIONS ARE IN MM, UNLESS NOTED OTHERWISE
- 4) ANY DISCREPANCY ARISING SHOULD BE INFORMED TO THE ARCHITECT IMMEDIATELY

Nos.	DATE	PRINT ISSUED TO
1	02-06-2023	TO SITE

REVISIONS:-		
S.No.	DATE	REMARKS
R0	02-06-2023	

KEY PLAN :-

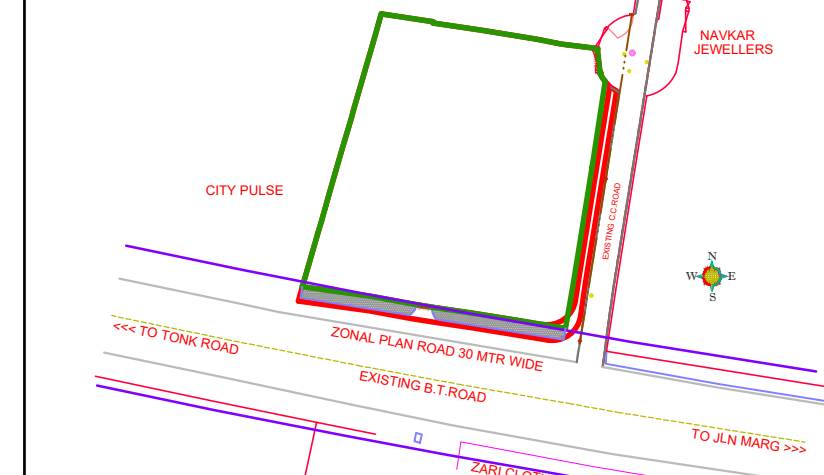

PROJECT:- SIGNATURE ELITE
SIGNATURE ELITE, 1-7 GOVIND MARG
NARAYAN SINGH CIRCLE -RAJA PARK

DRAWING TITLE FILLING PLAN GROUND FLOOR PLAN
J7- MANGLAM SIGNATURE ELITE

DATE:- 02-06-2023

CHECKED BY:- RAVI

DEALT BY:- SAURABH

DRAWN BY:- SAURABH

DRG.NO.
LG/AR/05/05



DEVELOPER

M/S SIGNATURE ELITE DEVELOPERS
6TH FLOOR, APEX MALL, LAL KOTHI,
TONK ROAD, JAIPUR, RAJASTHAN

LEGEND

S.NO.	SYMBOL / PUMP	QTY	HEAD / LPM
1	DIESEL PUMP	1	
2	HYDRANT / SPRINKLER	2	
3	JOCKEY PUMP	1	
4	RAW WATER PUMP	1W + 1S	
5	SOFT WATER PUMP	1W + 1S	
6	BUTTERFLY VALVE	14	
7	NON RETURN VALVE	10	
8	RUBBER BELOW	4	
9	STRAINER	3	
10	GATE VALVE	1	
10	BALL VALVE	11	
10	P.G	5	

ARCHITECT

124, HIMMAT NAGAR , TONK ROAD, JAIPUR
PHONE - 0141-2706227, 2712377
email: studio@ideasjaipur.com, web: www.ideasjaipur.com

STRUCTURE CONSULTANT :

Vijaytech Consultants Pvt. Ltd.
CONSULTING ENGINEERS
PLOT 1, GAUTAM MARG, SHYAM NAGAR, JAIPUR-32. INDIA
Phone : 91-141 2294432, 3257592 , Fax : 91-141-4023198
E-mail : vijaytech.jpr@gmail.com

MEP CONSULTANT :

JR Square
Engineers & Consultancy Pvt. Ltd.
UG-16 Floor Jaipur Electronic Market, Ridhi
Sidhi Circle, Gopal pura by Pass Road , Jaipur
(Raj)
Ph:- 8696311408, 9971998408
Email:- ravisongira72@gmail.com ;
ravi@jrsquareengineers.com


NOTES :-

1) THIS DRAWING IS PROPERTY OF IDEAS , JAIPUR
2) UNAUTHORIZED USE OF THIS DRAWING WITHOUT PERMISSION IS
STRICTLY PROHIBITED.
3) ALL DIMENSIONS ARE IN MM UNLESS NOTED OTHERWISE.
4) ANY DISCREPANCY ARISING SHOULD BE INFORMED TO THE ARCHITECT
IMMEDIATELY.

Nos.	DATE	PRINT ISSUED TO
	06-04-2023	TO SITE

REVISIONS:-

R.No.	DATE	REMARKS
	06-04-2023	

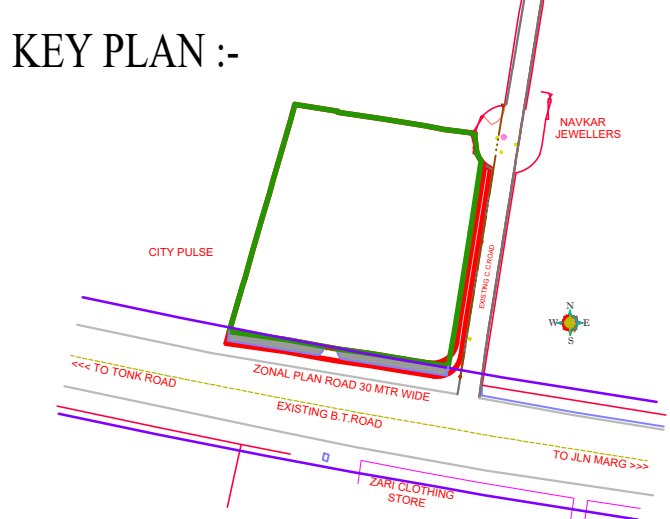




PROJECT:-	SIGNATURE ELITE
	SIGNATURE ELITE, J-7 GOVIND MARG NARAYAN SINGH CIRCLE -RAJA PARK
CLIENT:-	MANGLAM BUILD-DEVELOPERS LIMITED
DRAWING TITLE	PUMP ROOM DETAIL
DATE:- 17-10-2023	DRG.NO.
CHECKED BY:- RAVI	JRS/EL/FF/R/05
DEALT BY:- SAURABH	
DRAWN BY:- SAURABH	

100 '-0" WIDE ROAD GOVIND MARG

Diagram illustrating a Zone Control Station. The station includes the following components:

- Ø6" FIRE RISER
- Ø2" DRAIN RISER
- Ø6" OS & Y GATE VALVE WITH TAMPER SWITCH
- Ø6" FLOW SWITCH
- Ø6" PRESSURE GAUGE
- Ø6" CHECK VALVE
- Ø1" DRAIN & TEST LINE WITH INSPECTOR TEST

A cloud callout provides a detailed view of the valve assembly, showing the gate valve, flow switch, pressure gauge, and check valve connected to the fire riser and drain riser.

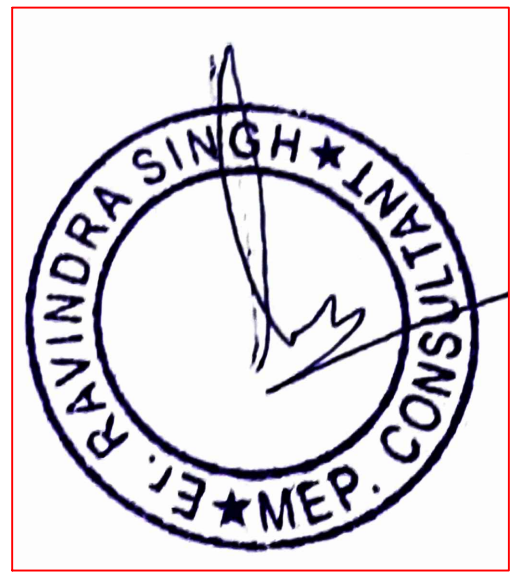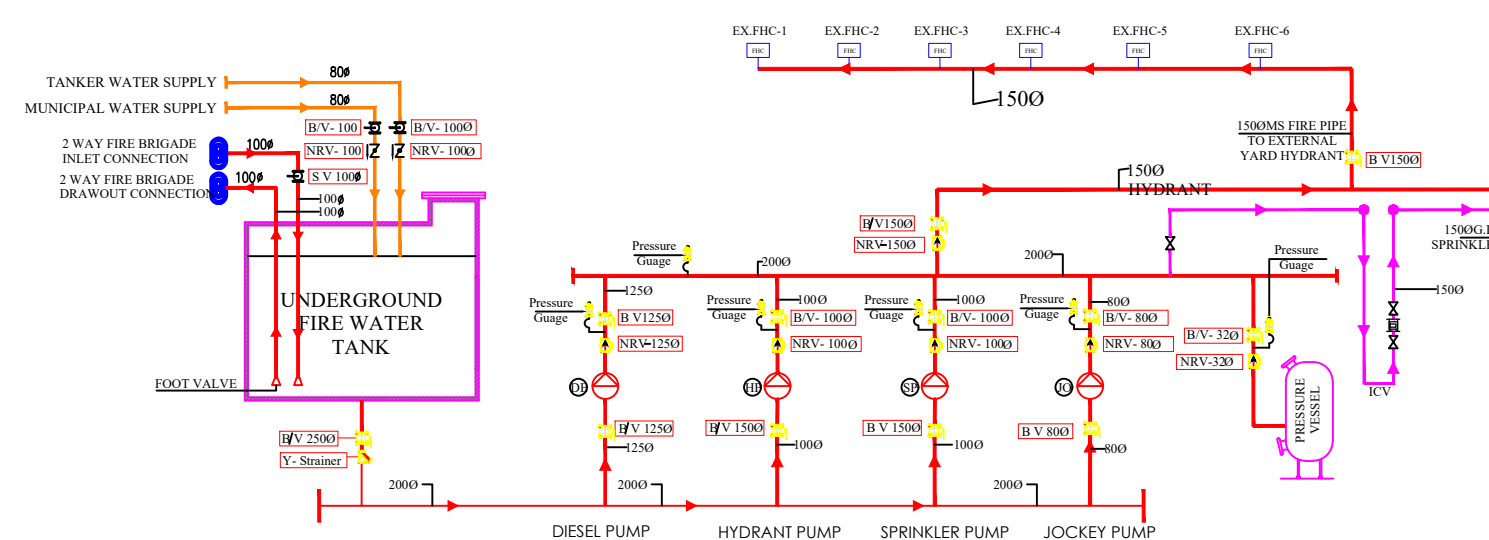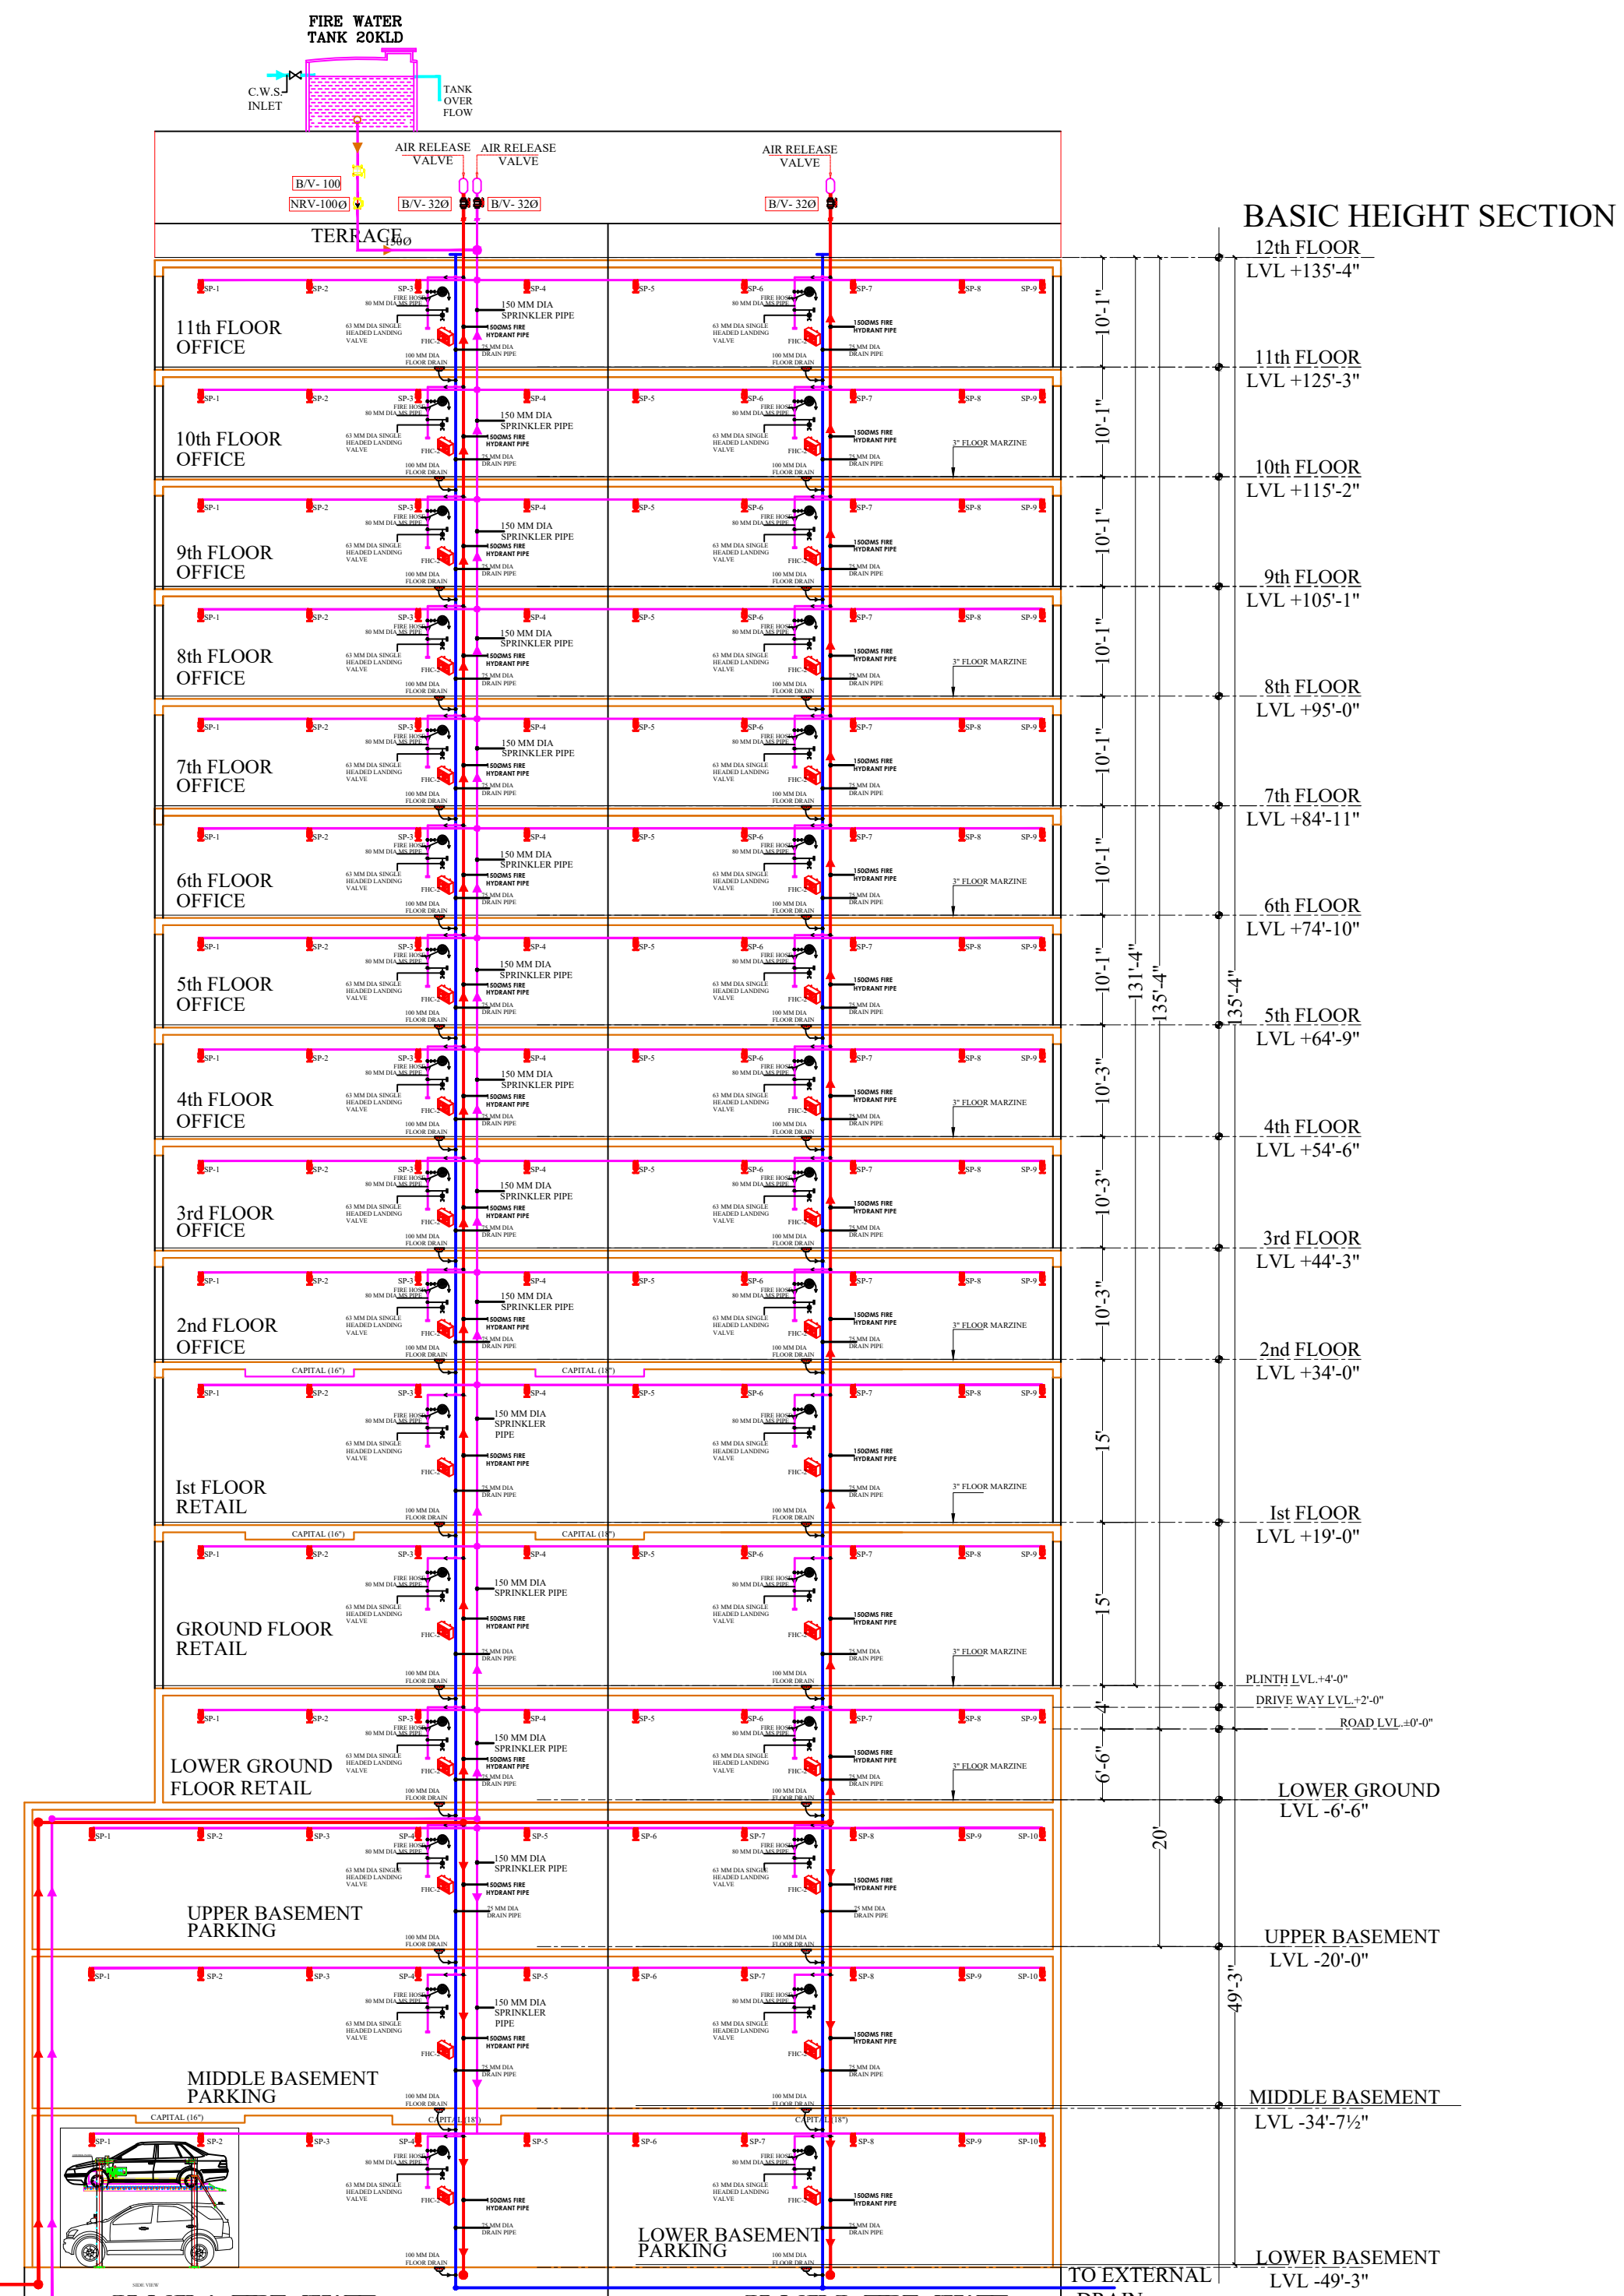

MEP CONSULTANT :

 **JR Square**
Engineers & Consultancy Pvt. Ltd.

UG- 16 Floor Jaipur Electronic Market,
Ridhi Sidhi Circle, Gopal pura by Pass
Road , Jaipur (Raj)

Ph;- 8696311408, 9971998408
Email;- ravisongira72@gmail.com ;
ravi@jrssquareengineers.com

- (1) THE DRIE WAY LIGHTING SHOULD BE ON ALTERNATE CIRCUIT.
- (2) EVERY CIRCUIT CONDUIT CONNECT WITH THE DB AT LOCATION SHOWN IN DRAWING.
- (3) 25MM HEAVY DUTY PVC CONDUIT SHOULD BE USED IN RCC SLAB.
- (4) USED 25 MM DEEP JUNCTION BOX IN RCC SLAB FOR LIGHTING FIXTURE.
- (5) CIRCUIT DETAILS SHALL BE SHARE IN OTHER DRAWINGS.
- (6) PARKING AREA LIGHTS SHOULD BE CONTROLLED BY SEPARATE CIRCUIT ALTERNATELY.
- (7) CAMERA CONDUIT SHOULD BE TAKEN TO LIFT LOBBY AREA. THE SAME SHALL BE LATER CONNECT WITH CCTV ROOM.
- (8) SWITCH BOARD SUPPLY FOR PUMP ROOM AND STP BOARD SHALL BE TAKEN FROM PUMP ROOM PANEL.



Vijaytech Consultants Pvt. Ltd.

CONSULTING ENGINEERS

H-17, GAUTAM MARG, SHYAM NAGAR, JAIPUR-19 INDIA
 Phone : 91-141 2294332, 3257592 , Fax : 91-141-4023198
 E-mail : vijaytech.jpr@gmail.com

124, HIMMAT NAGAR , TONK
ROAD, JAIPUR PHONE -
0141-2706227,2712377 email:
ideasjaipur@gmail.com, web:
www.ideasjaipur.com