


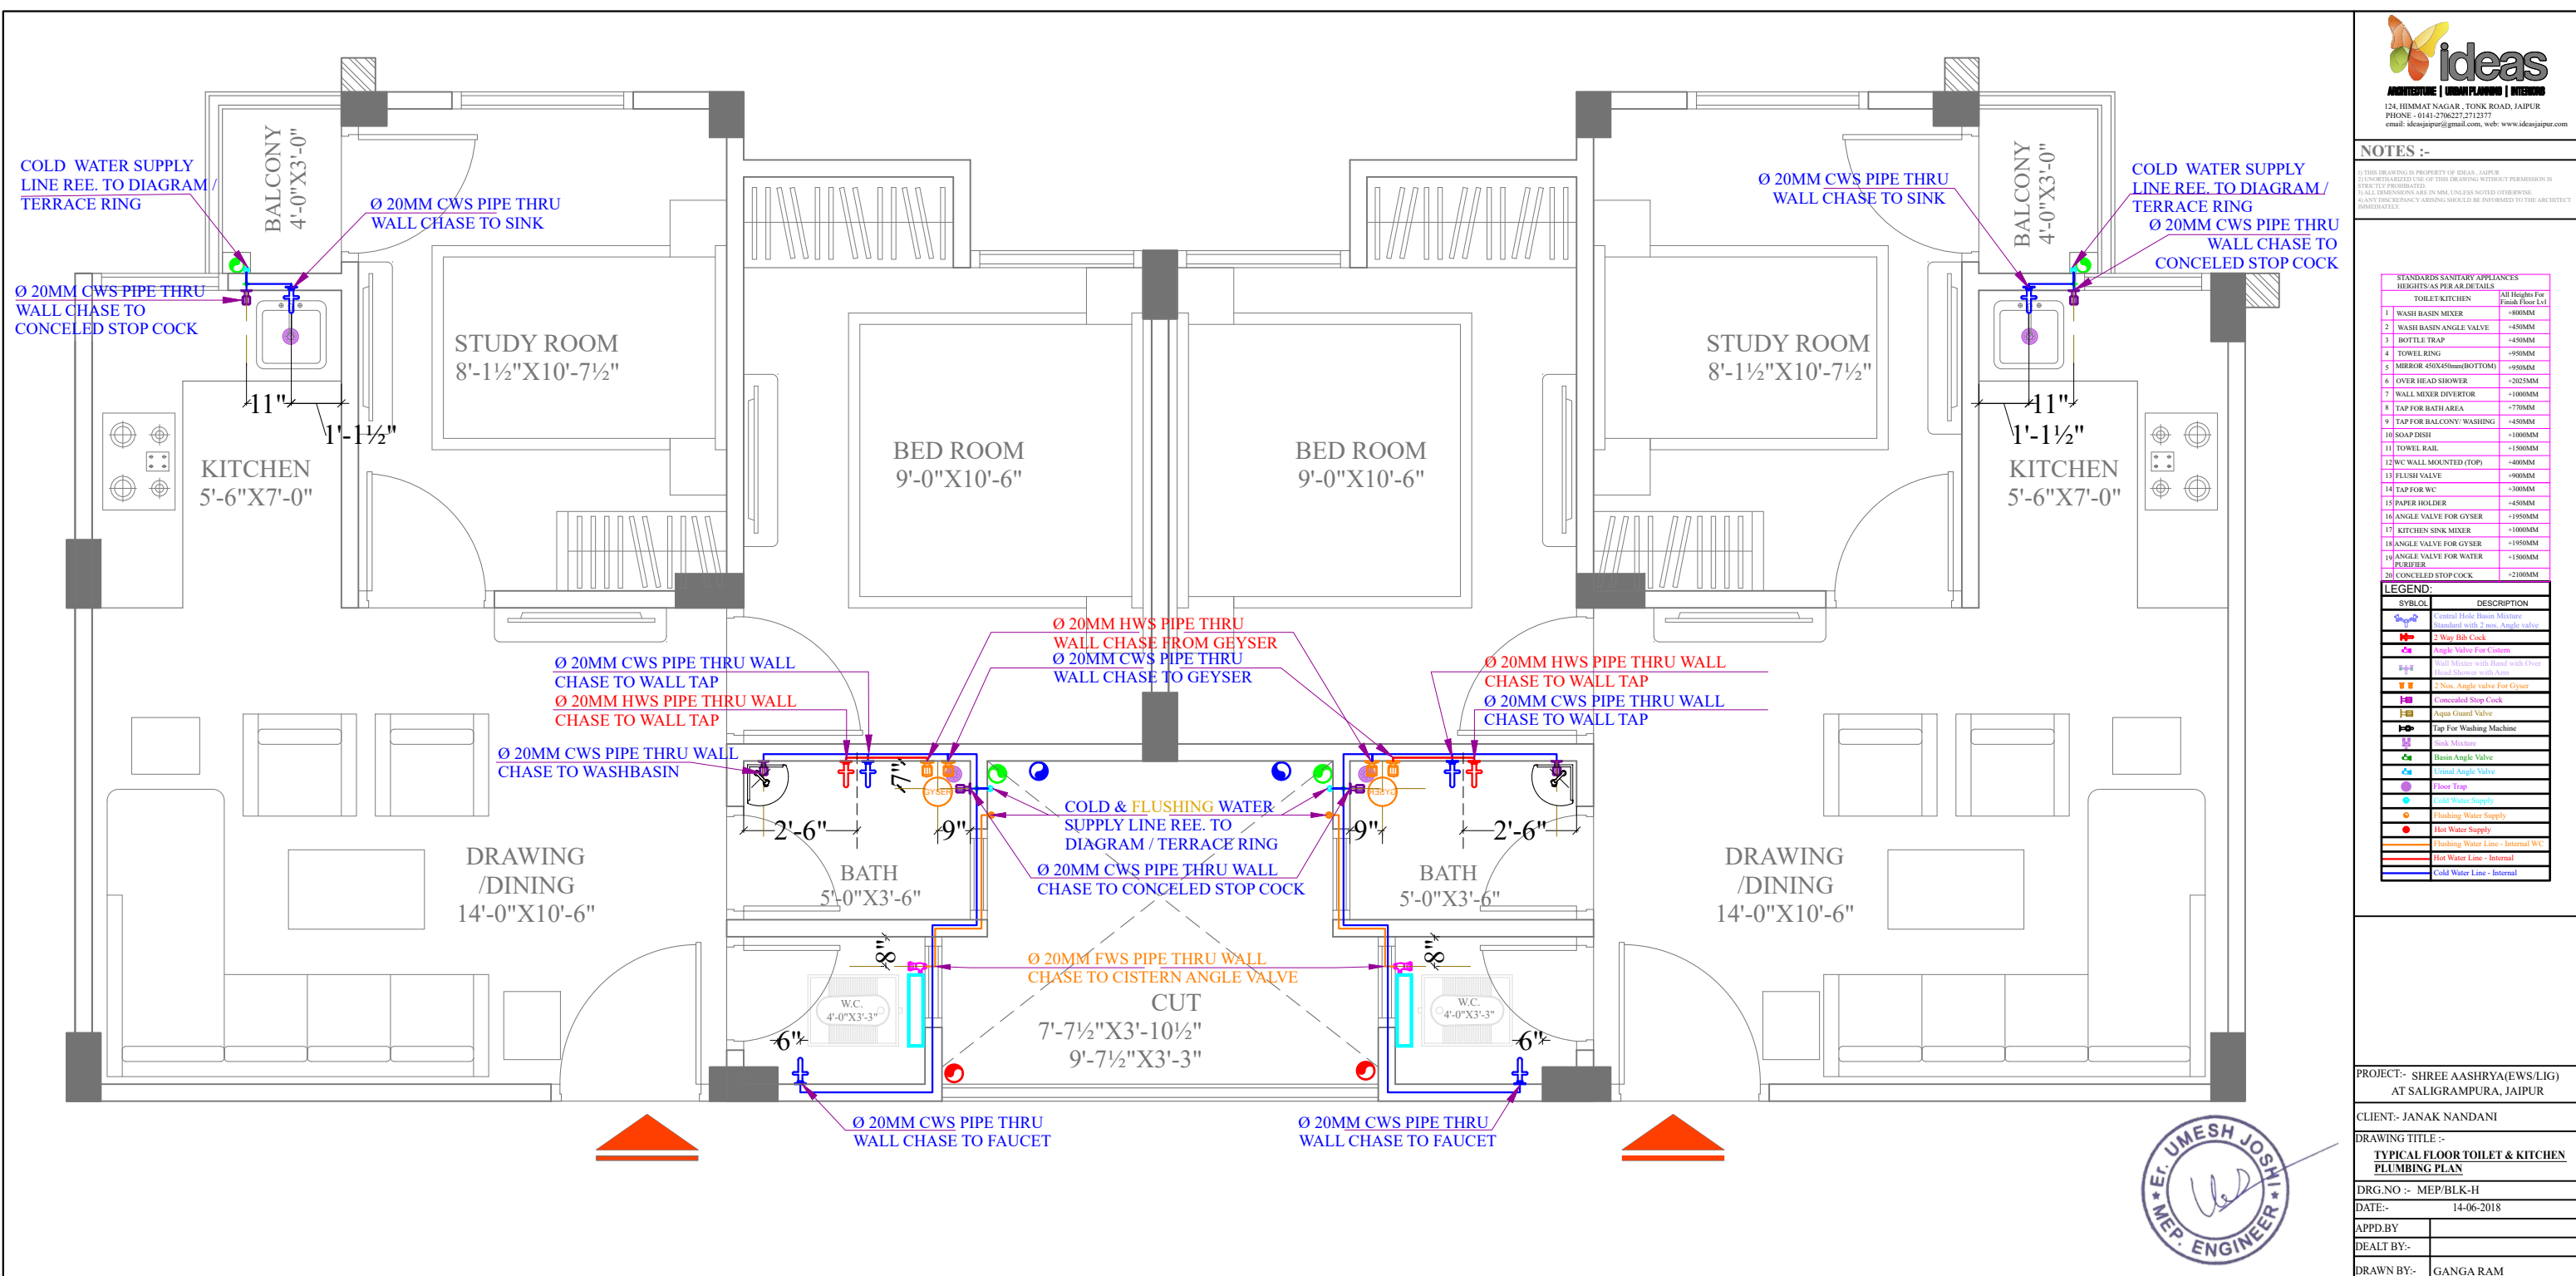

NOTES :-

- 1) THIS DRAWING IS PROPERTY OF IDEAS, JAIPUR.
- 2) UNAUTHORIZED USE OF THIS DRAWING WITHOUT PERMISSION IS PROHIBITED.
- 3) DIMENSIONS ARE IN MM, UNLESS NOTED OTHERWISE.
- 4) ANY DISCREPANCY ARISING SHOULD BE INFORMED TO THE ARCHITECT IMMEDIATELY.



SYMBOL	DESCRIPTION
	RAIN WATER CHAMBER 300X300MM
	GULLY TRAP 300X300MM
	SEWERAGE MANHOLE 450X450MM

SYMBOL	DESCRIPTION
	110 mm Soil Waste Water Pipe
	110 mm Waste Water Pipe
	110 mm Rain Water Pipe
	160 mm Soil Waste Water Pipe
	110 mm Soil Waste Water Pipe SLOPE 1:150
	110 mm Waste Water Pipe SLOPE 1:150
	110 mm Rain Water Pipe SLOPE 1:200
	75 mm Waste Water Pipe Internal Toilet
	50mm Waste Water Pipe Bottle Trap
	Floor Trap
	6" Platform Raise
	FLOW DIRECTION

PROJECT:- SHREE AASHRYA(EWS/LIG)
AT SALIGRAMPURA, JAIPUR

CLIENT:- JANAK NANDANI

DRAWING TITLE :-
**PLINTH BEAM DRAINAGE
PLAN OF BLOCK - G**


DRG.NO :- MEP/BLOCK-G/PB/DRA-01

DATE:-

APPD BY:-



DEALT BY:-

DRAWN BY:-

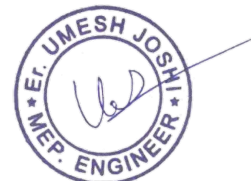

PART - A

PART - B

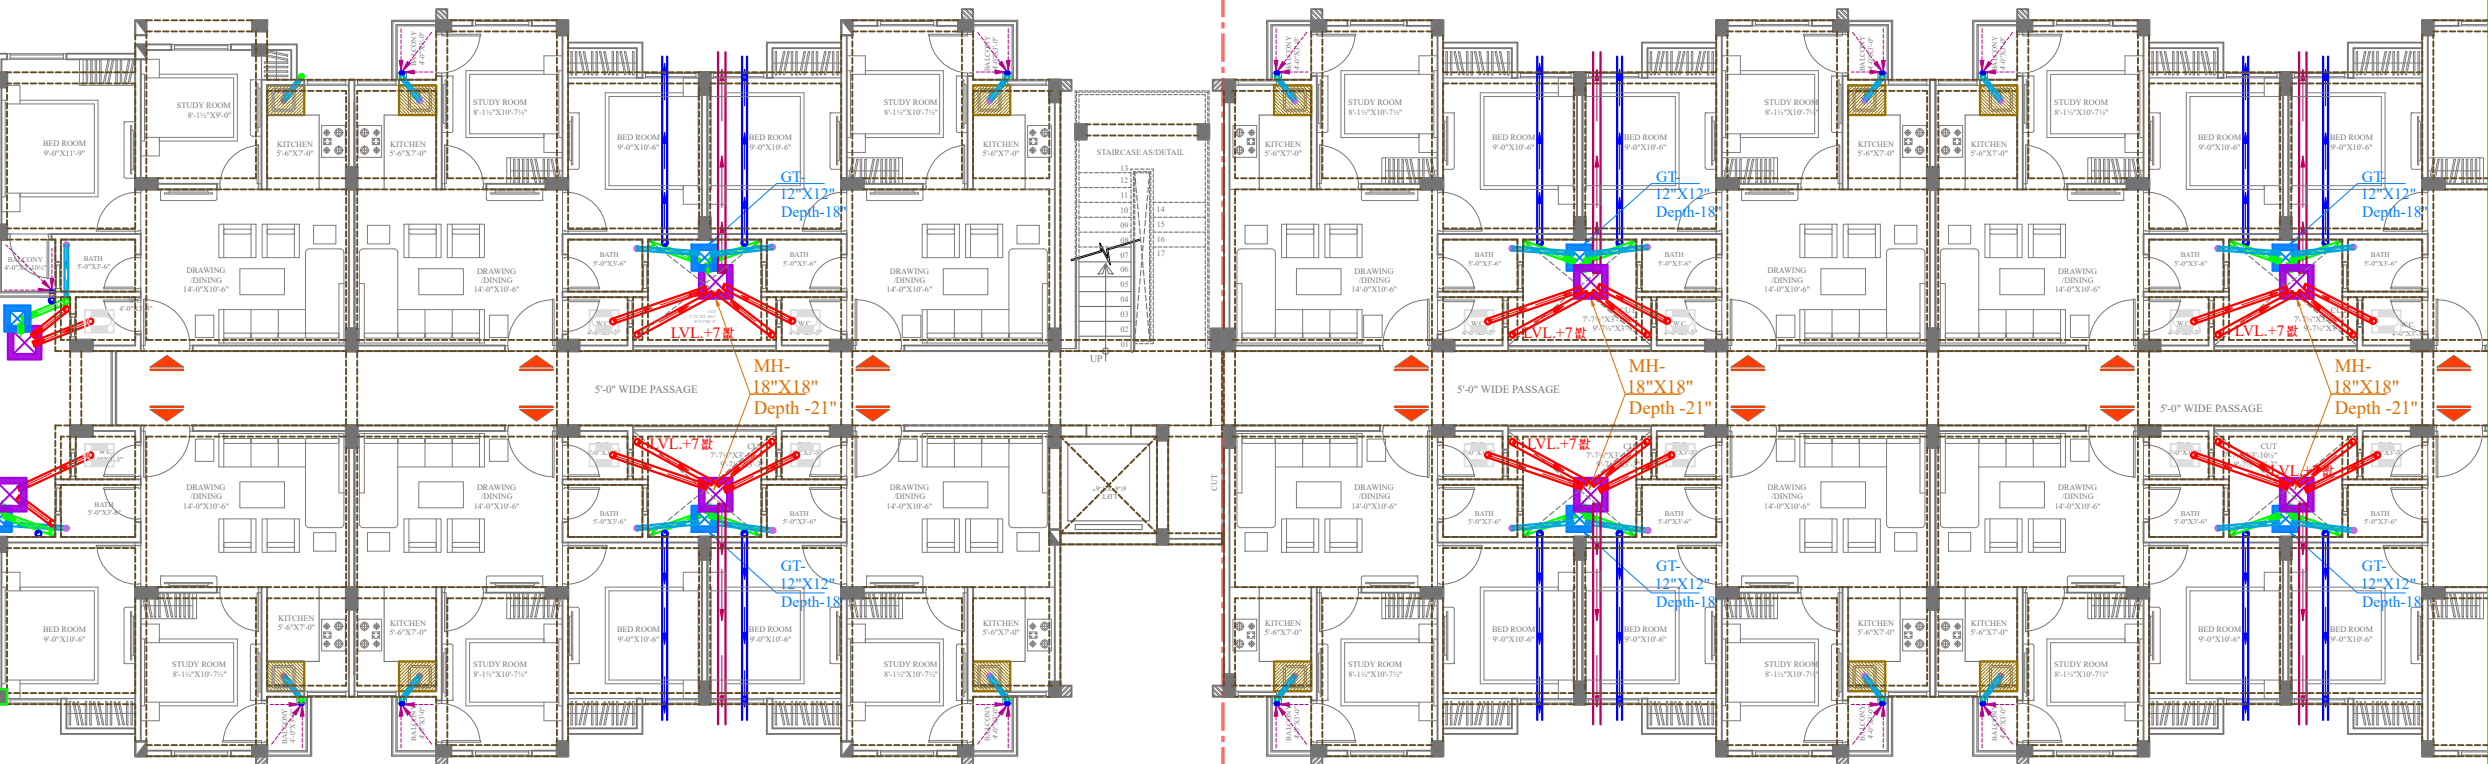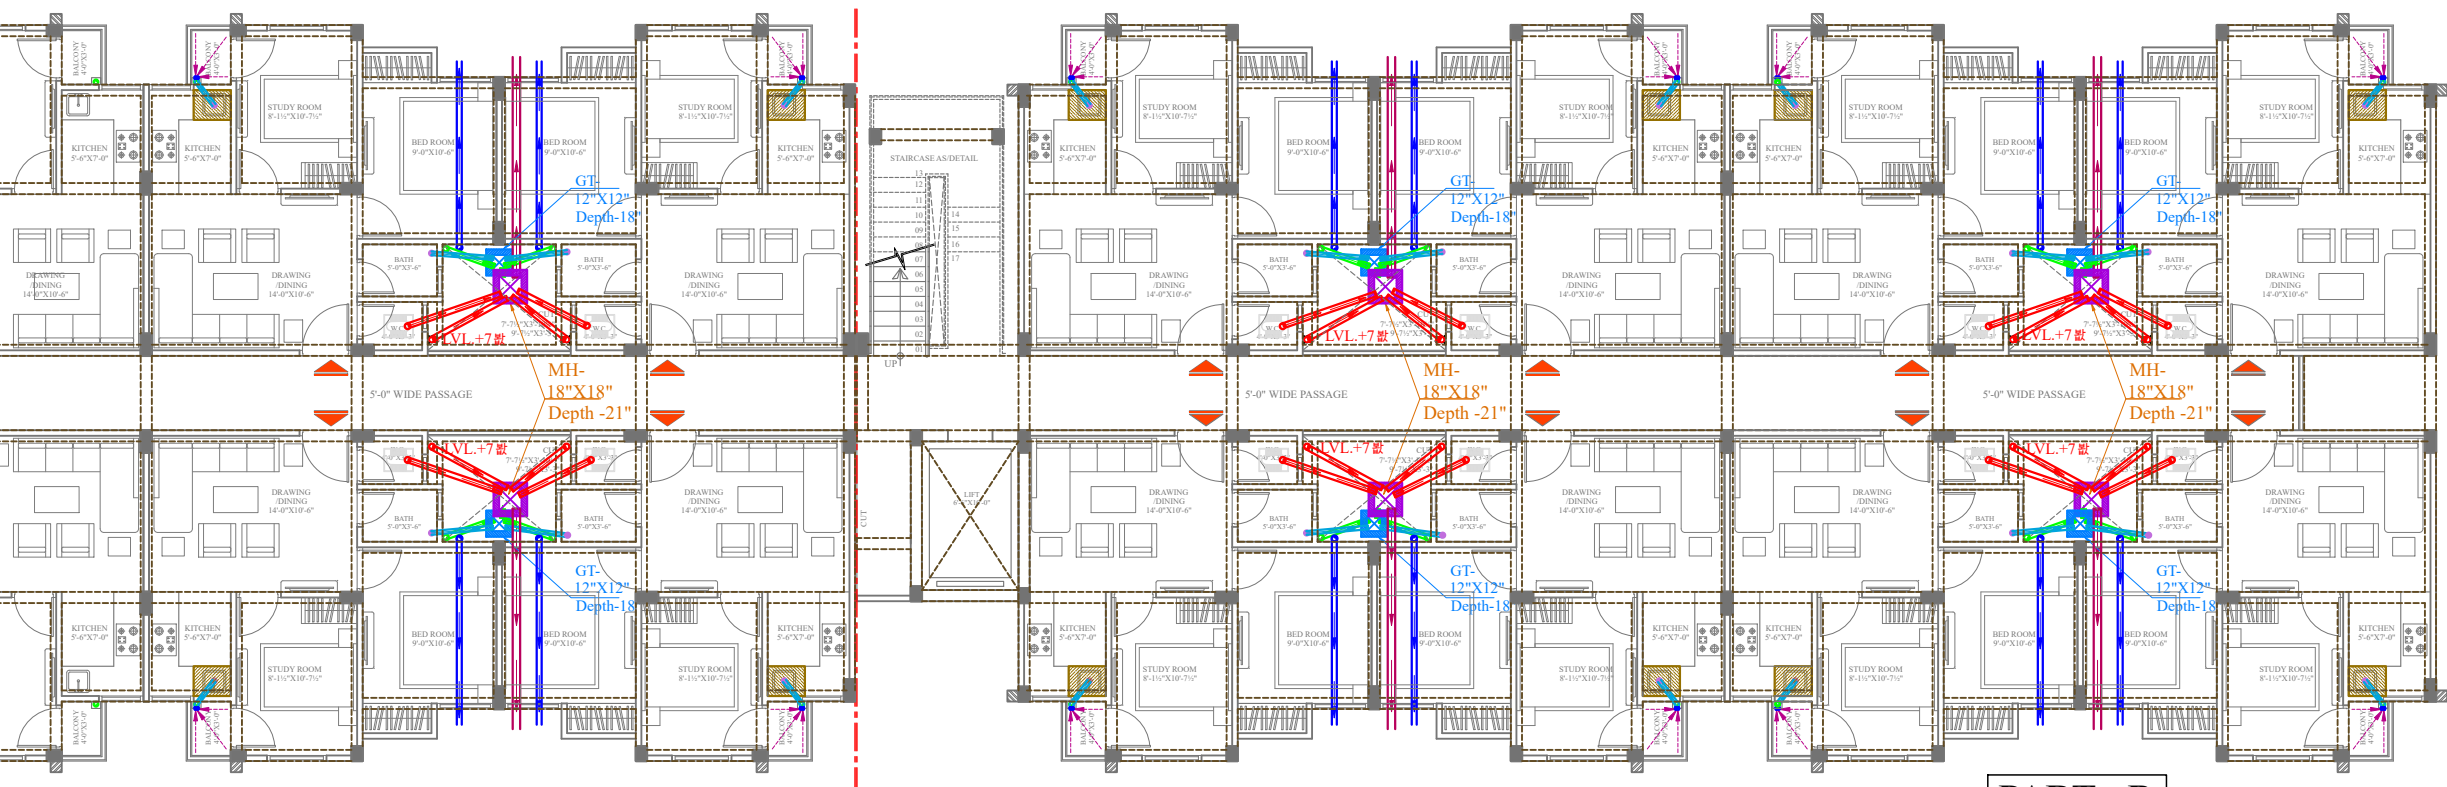

GROUND FLOOR PLINTH BEAM DRAINAGE PLAN OF BLOCK - G