


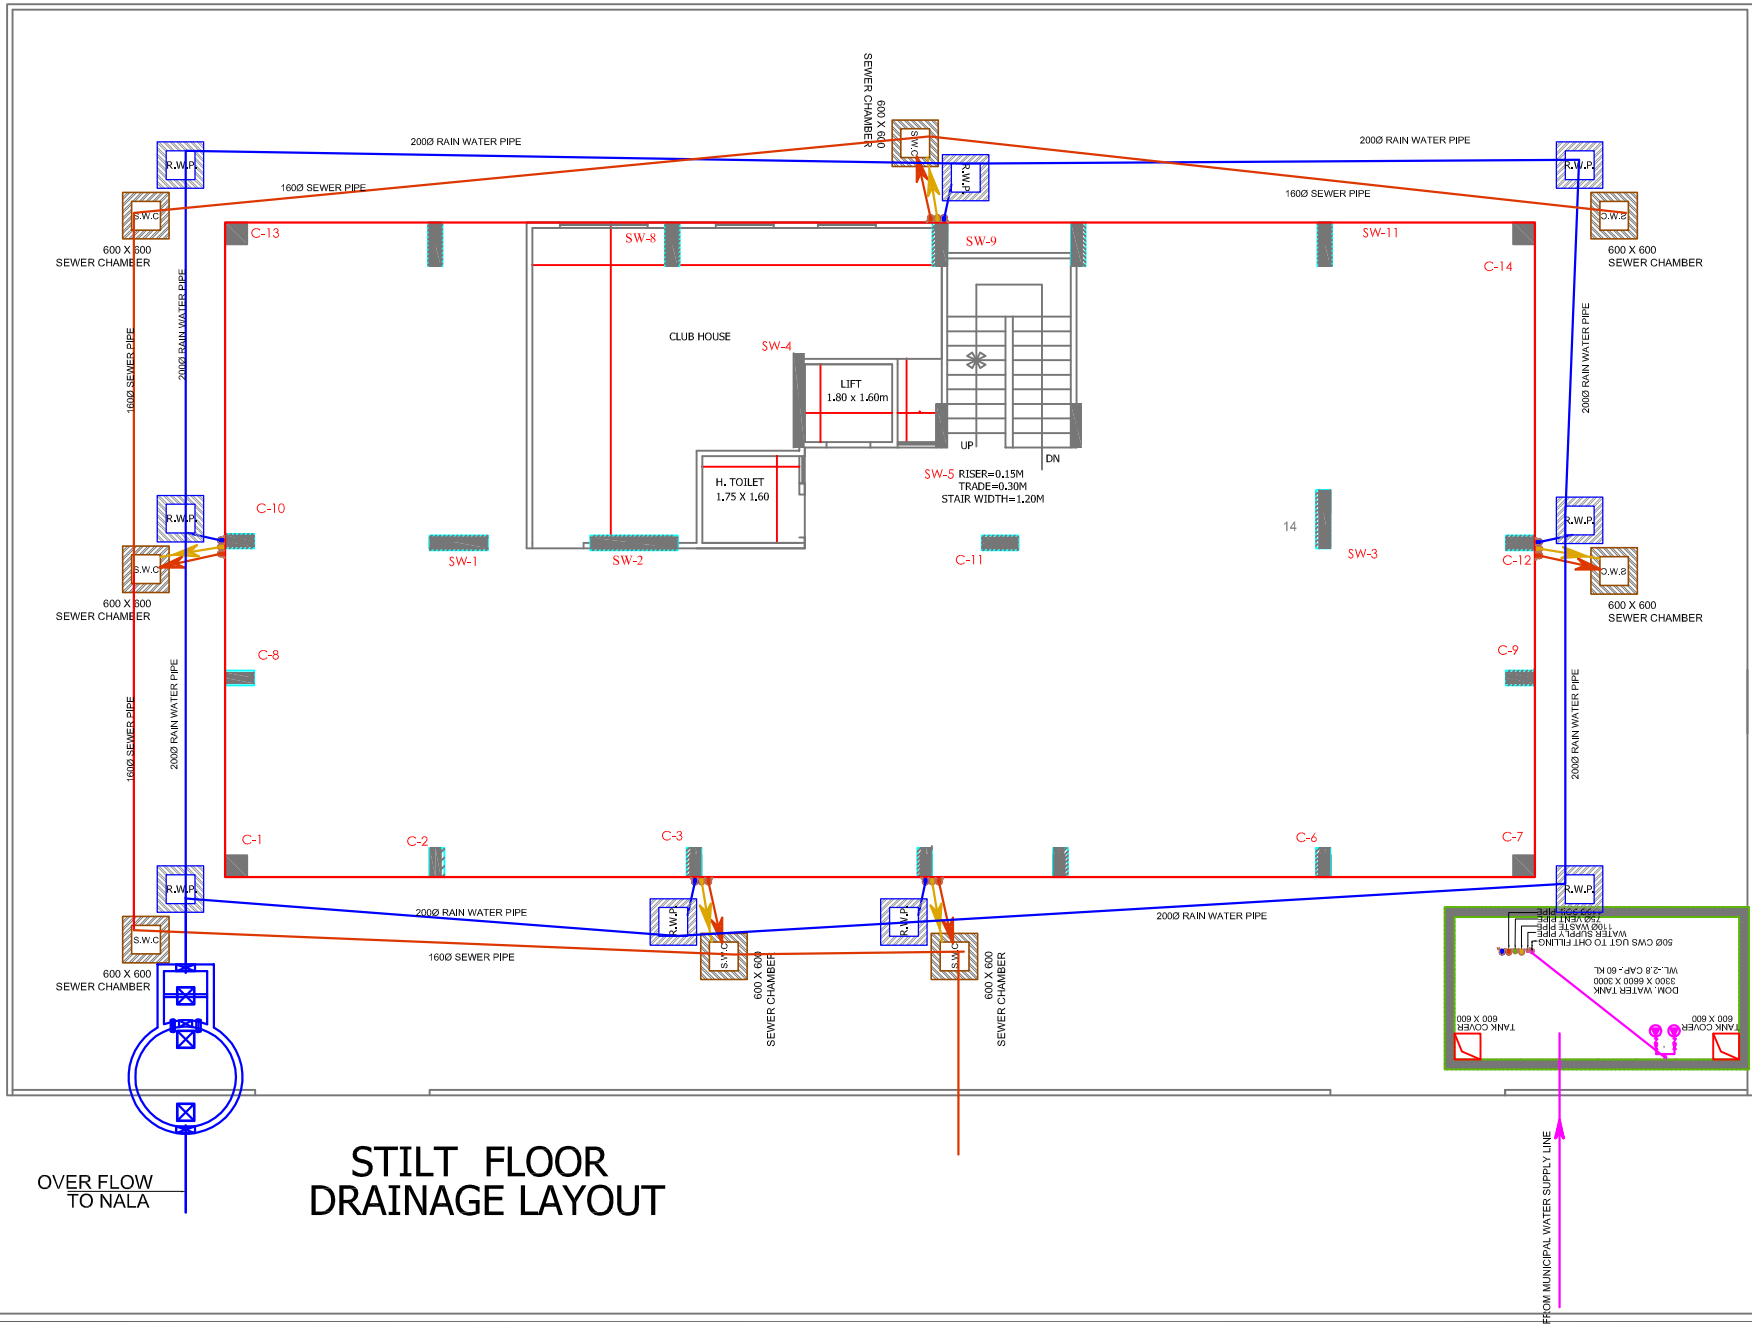

STILT FLOOR
DRAINAGE LAYOUT

Aman Gupta
M.E.P. Consultant
B.E. Electrical

LEGEND:-

1	ROB. PIPE	
2	WASTE PIPE	
3	VENT PIPE	
4	COLD WATER SUPPLY (CWS)	
5	HOT WATER SUPPLY (HWS)	
6	RAIN WATER PIPE	
7	SEWER LINE - EXTERNAL	
8	STORM WATER DRAINAGE PIPE	
9	SEWERAGE MANHOLE	M.S.
10	STORM WATER MANHOLE	M.S.
11	CHILLY TRAP	
12	WALL TRAP	
13	FLOOR TRAP	
14	FLOOR FLOOR DRAIN	
15	RAIN WATER COLLECTION CHAMBER	
16	EXTERNAL	

DRAWING TITLE
STILT FLOOR
DRAINAGE LAYOUT

SCALE:- 1:100 DATE:


PROJECT:-
PROPOSED RESIDENTIAL APARTMENT FOR
RED WOOD DEVELOPERS
AT PLOT NO-24/30,31,32,CENTRAL SPINE,
JAGATPURA,
JAIPUR.

ARCHITECT
M/S AKRITI AYOJAN

ARCHITECTS, INTERIOR DESIGNERS
E-47, THIRD FLOOR, MANGLAM TOWER, REDH360,
GOPALPURA, JAIPUR-302016, RAJASTHAN
suryprakash.arch@gmail.com : 9301154911

NORTH :

THIS DRAWING IS THE SOLE PROPERTY OF
M/S AKRITI AYOJAN AND IS NOT TO BE COPIED,
USED OR REPRODUCED FOR ANY PURPOSE
OTHER THAN FOR WHICH IT HAS BEEN LOANED.

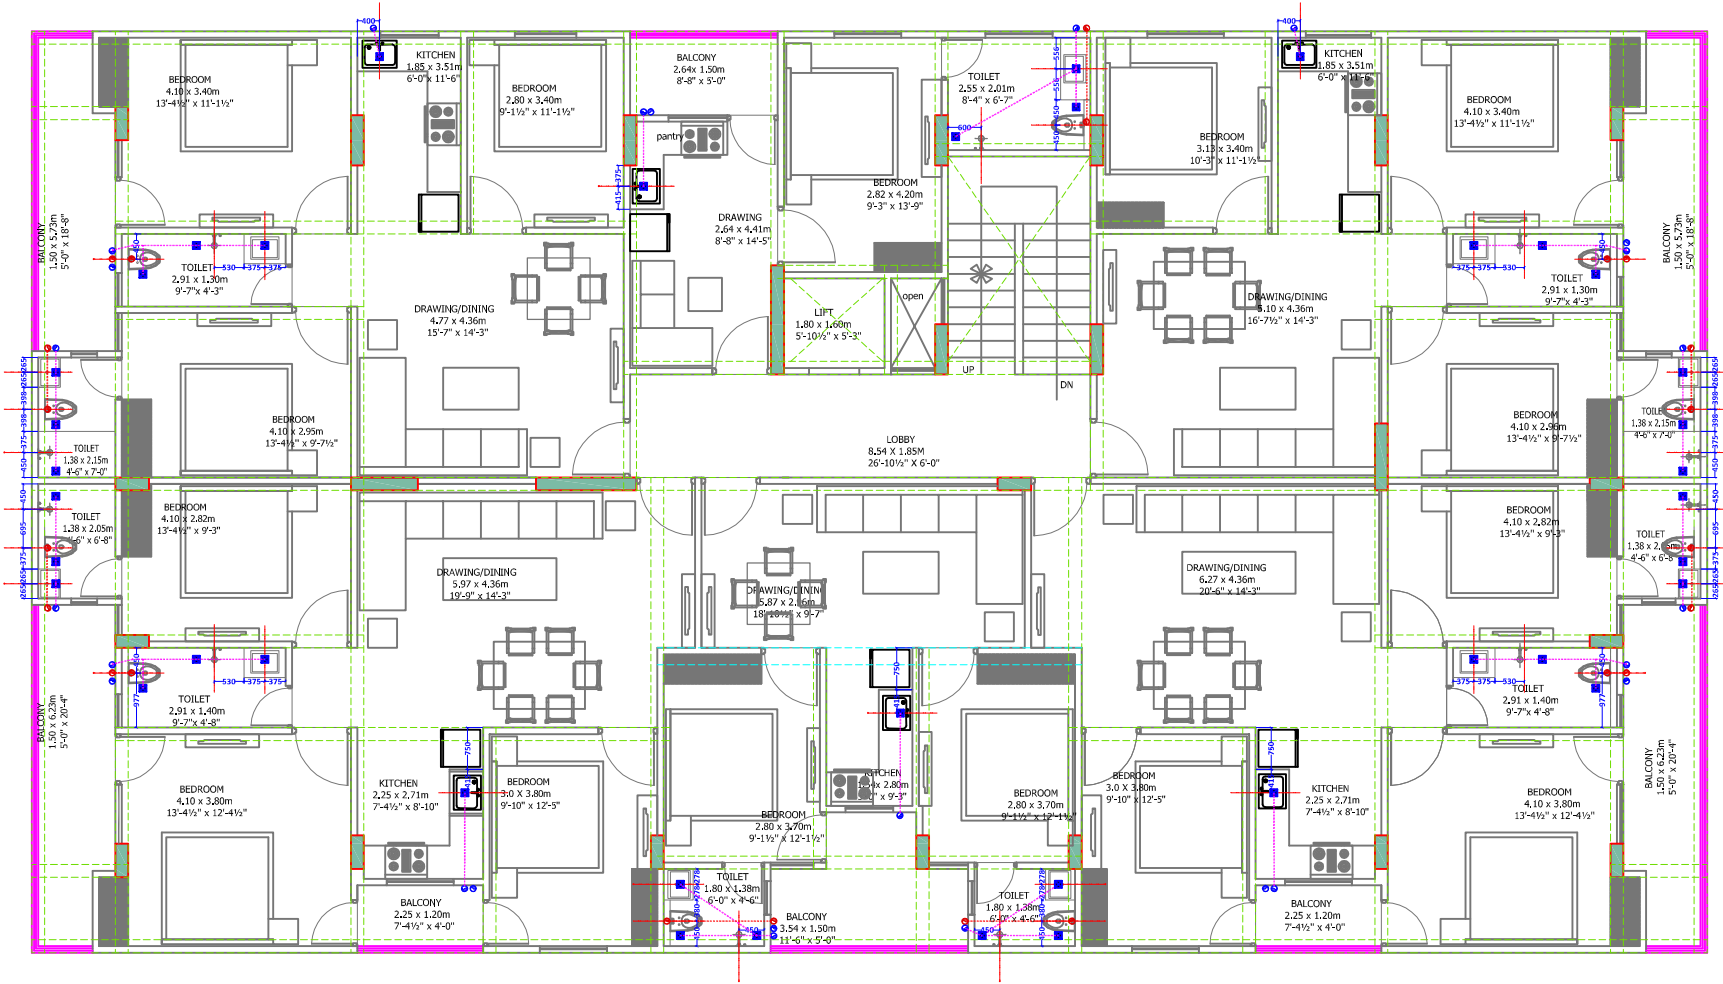

TYPICAL FLOOR DRAINAGE LAYOUT

Amish Gupta
M.E.P. Consultant
B.E. Electrical

LEGEND:-

1	SOL. PIPE	
2	WASTE PIPE	
3	VENT PIPE	
4	COLD WATER SUPPLY (CWS)	
5	HOT WATER SUPPLY (HWS)	
	RAIN WATER PIPE	
SW	SEWER LINE- EXTERNAL	
WF	STORM WATER DRAINAGE PIPE	
	RETENANCE MANHOLE	M.H.
	STORM WATER MANHOLE	M.H.
GT	GULLY TRAP	
BT	BALL VALVE	
FT	FLOOR TRAP	
FD	FLOOR FLOOR DRAIN	
	RAIN WATER COLLECTION CHAMBER	400X600MM
	KITCHEN	

DRAWING TITLE
TYPICAL FLOOR DRAINAGE LAYOUT

SCALE:- 1= 100 DATE: _____
PROJECT:-
PROPOSED RESIDENTIAL APARTMENT FOR
RED WOOD DEVELOPERS
AT PLOT NO=D-130,131,132,CENTRAL SPINEL,
JAGATPURA,
JAIPUR.

ARCHITECT
M/S AKRITI AYOJAN
ARCHITECTS, INTERIOR DESIGNERS,
E-87, THIRD FLOOR, MANGLAM TOWER, RIDHI SEDI,
GOPALPURA, JAIPUR, RAJASTHAN. 9351154101
suryaprakash.arch@gmail.com

NORTH :

THIS DRAWING IS THE SOLE PROPERTY OF
M/S AKRITI AYOJAN AND IS NOT TO BE COPIED,
USED OR REPRODUCED FOR ANY PURPOSE
OTHER THAN FOR WHICH IT HAS BEEN LOANED.