

LEGEND			
NO	DESCRIPTION	SYMBOL	QTY
1.	SELF LUMINOUS GLOW SIGN BOARD		01 NOS
2.	FIRE EXTINGUISHER		02 NOS
3.	FIRE BUCKETS		01 NOS

PRAVEEN KUMAR
BTECH (ELECT)

MEP CONSULTANT
SRAN ASSOCIATES
MEP CONSULTANT
C-35A, Lalpat Marg, C-Scheme, JAIPUR.
Email-id : snajaiipur@hotmail.com

DT.	NO.	ISSUED TO	CKD.

REVISIONS

DT.	NO.	ISSUED TO	CKD.

PRINTS DATA

PROJECT TITLE

PROPOSED RESIDENTIAL
APARTMENT (BUNGLOW 10)
AT J 4 & 5 NANDAN VIHAR
MAHAL JAGATPURA JAIPUR

DRAWING TITLE

STILT FLOOR
FIRE FIGHTING PLAN

ARCHITECTS :

MISHRA GARG & ASSOCIATES

C-35Bhehswat enclavajaiurat marg-c-schemajaiipur.
ph:+91-141-237-3274,5104986-e-mail: mishra.garg@gmail.com


DESIGN & CHECKED BY ARCHITECT ARCHITECT DATE 19-6-2024

3.301



STILT FLOOR PLAN

70'-0"

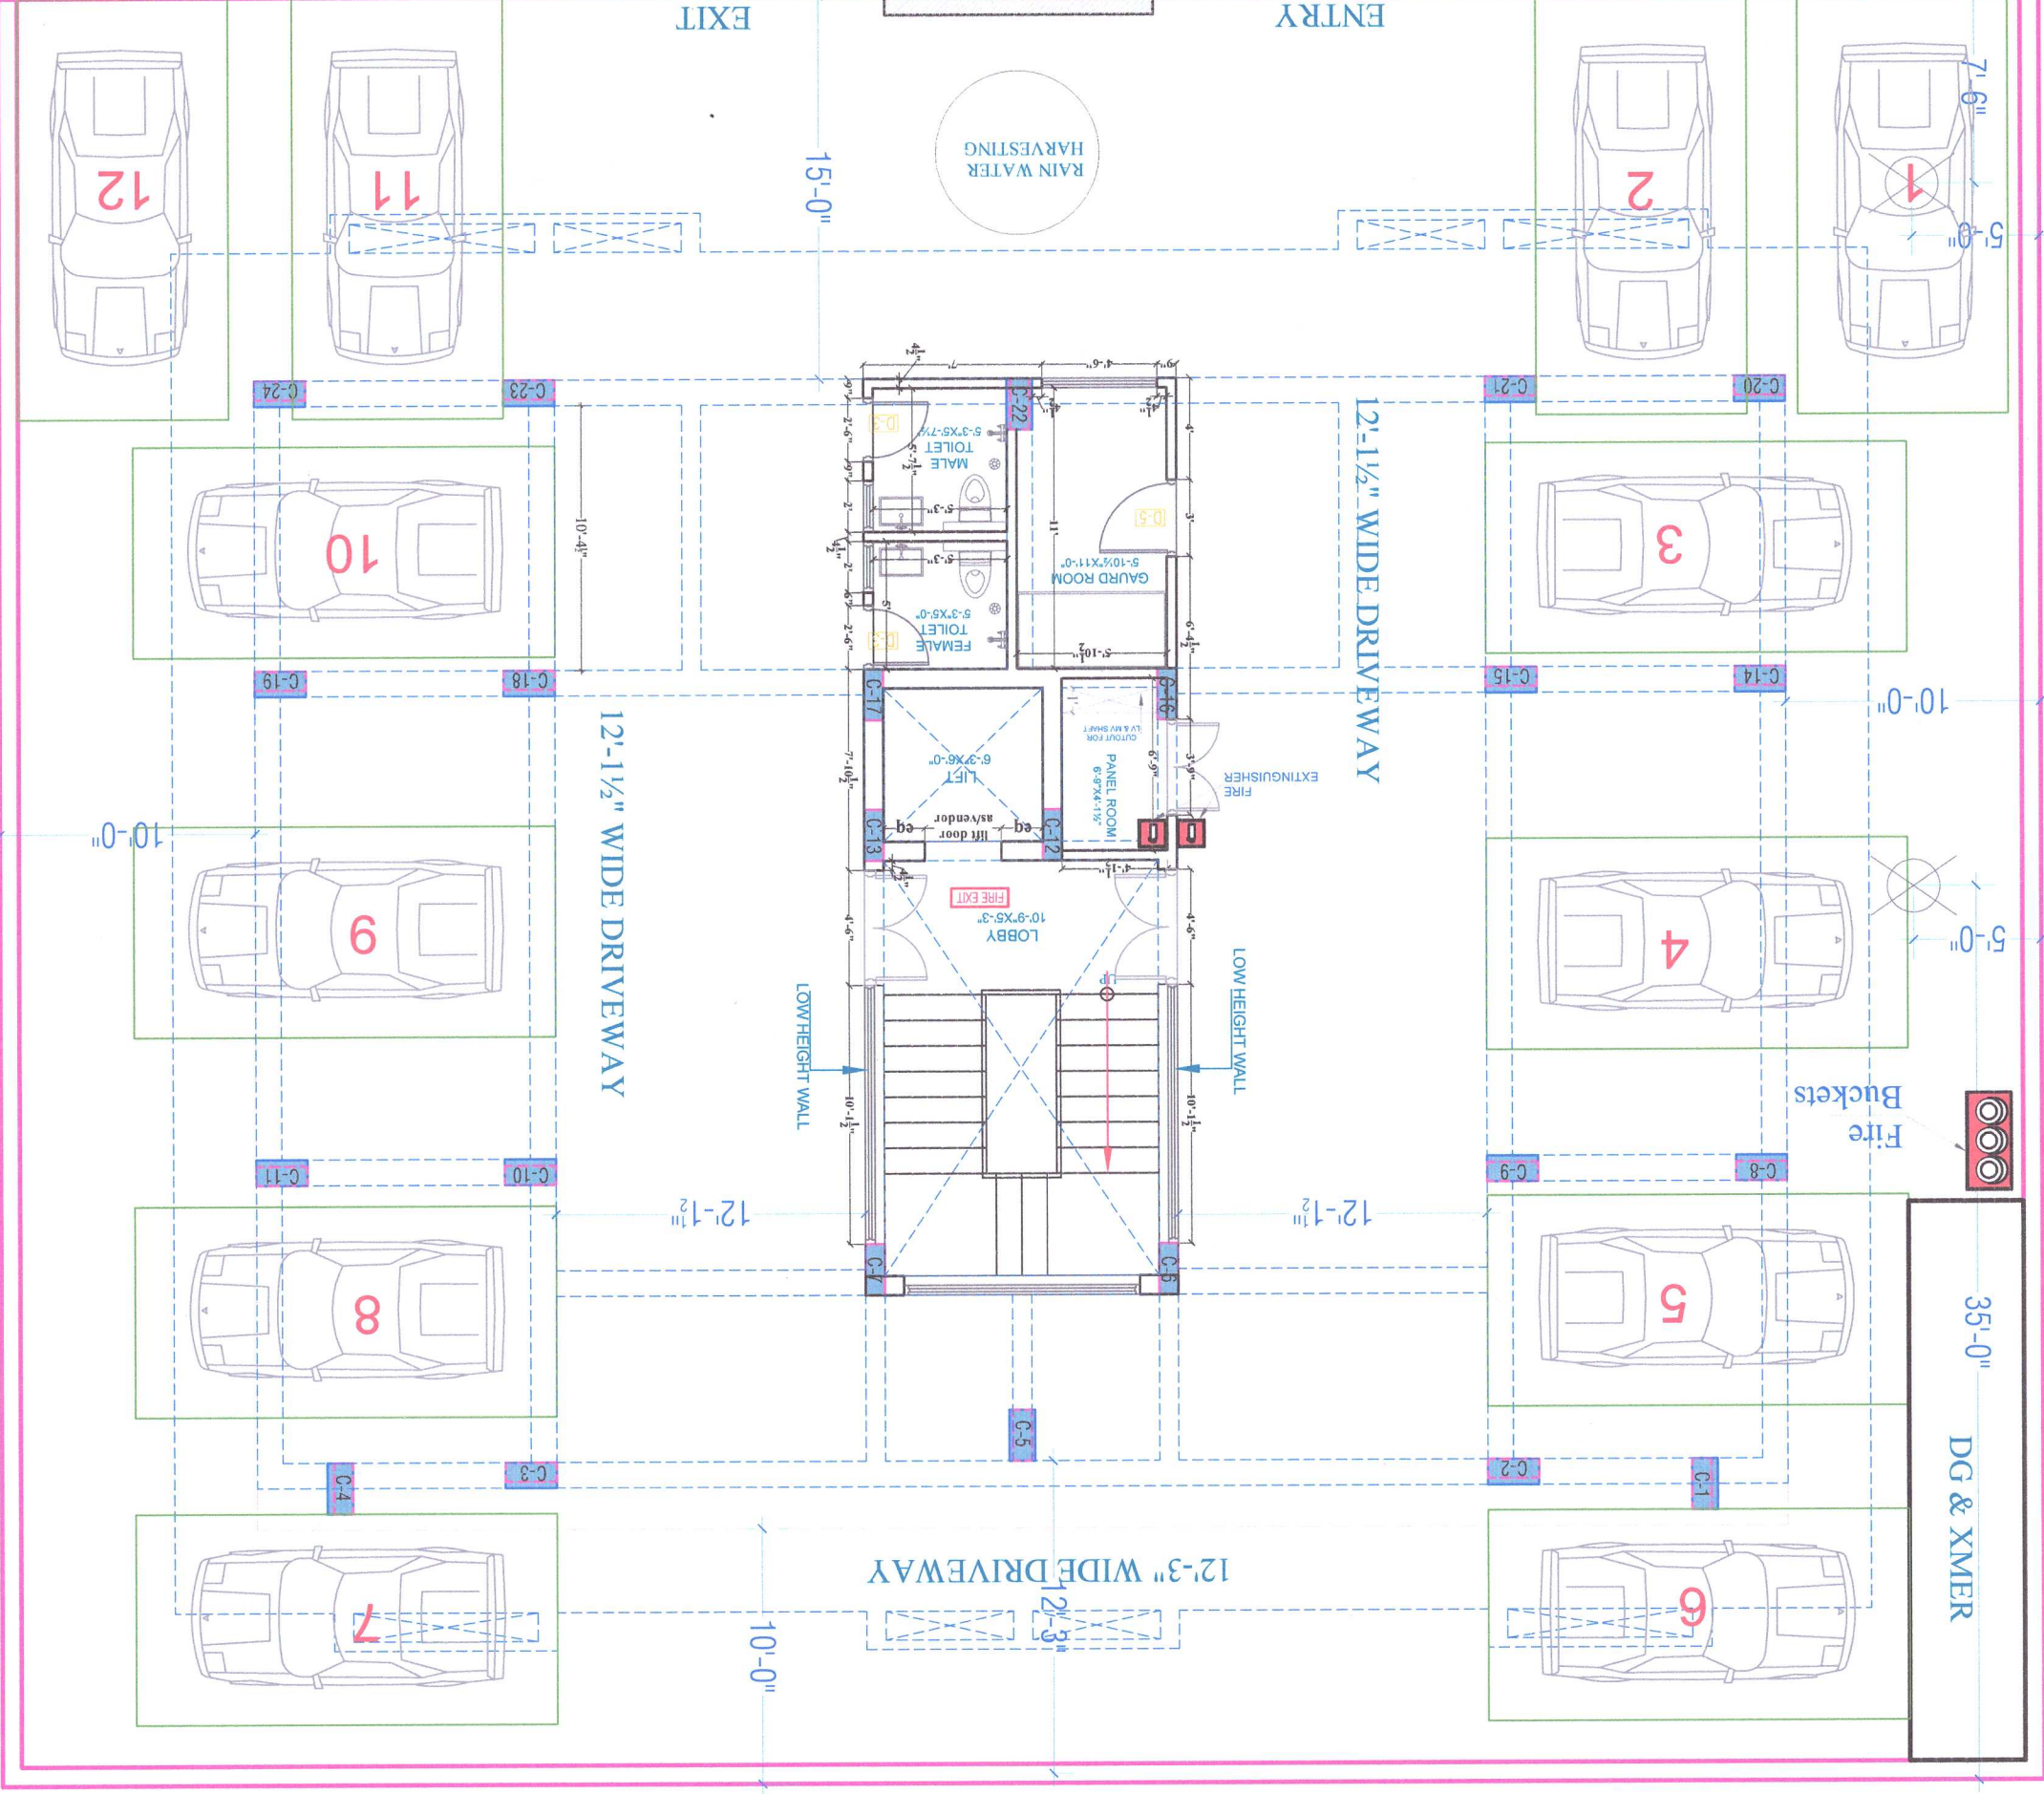

80'-0"

40'-0" WIDE ROAD

35'-0"

DG & XMER

FIRE FIGHTING DRAWING

LEGEND			
NO	DESCRIPTION	SYMBOL	QTY
1.	SELF LUMINOUS GLOW SIGN BOARD		01 NOS
2.	FIRE EXTINGUISHER		01 NOS
3.	FIRE BUCKETS		00 NOS

RAVEEN KUMAR
BTECH (ELECT)

MEP CONSULTANT
SRAJAN ASSOCIATES
C-35A, Lalpat Marg, C-Scheme, JAIPUR.
Email-id : snajaiipur@hotmail.com

DT.	NO.	ISSUED TO	CKD.

REVISIONS

DT.	NO.	ISSUED TO	CKD.

PRINTS DATA

PROJECT TITLE

PROPOSED RESIDENTIAL
APARTMENT (BUNGLOW 10)
AT J 4 & 5 NANDAN VIHAR
MAHAL JAGATPURA JAIPUR

DRAWING TITLE

TYPICAL FLOOR(1st-4th)
FIRE FIGHTING PLAN


ARCHITECTS

MISHRA GARG & ASSOCIATES

C-35A, Lalpat Marg, C-Scheme, Jaipur.
Email-id : snajaiipur@hotmail.com

DESIGN CHECKED BY	PROJECT	DATE
RAVEEN KUMAR	MAHAL JAGATPURA JAIPUR	19-6-2024

SCALE	DATE	NO.
1:1	19-6-2024	3.302

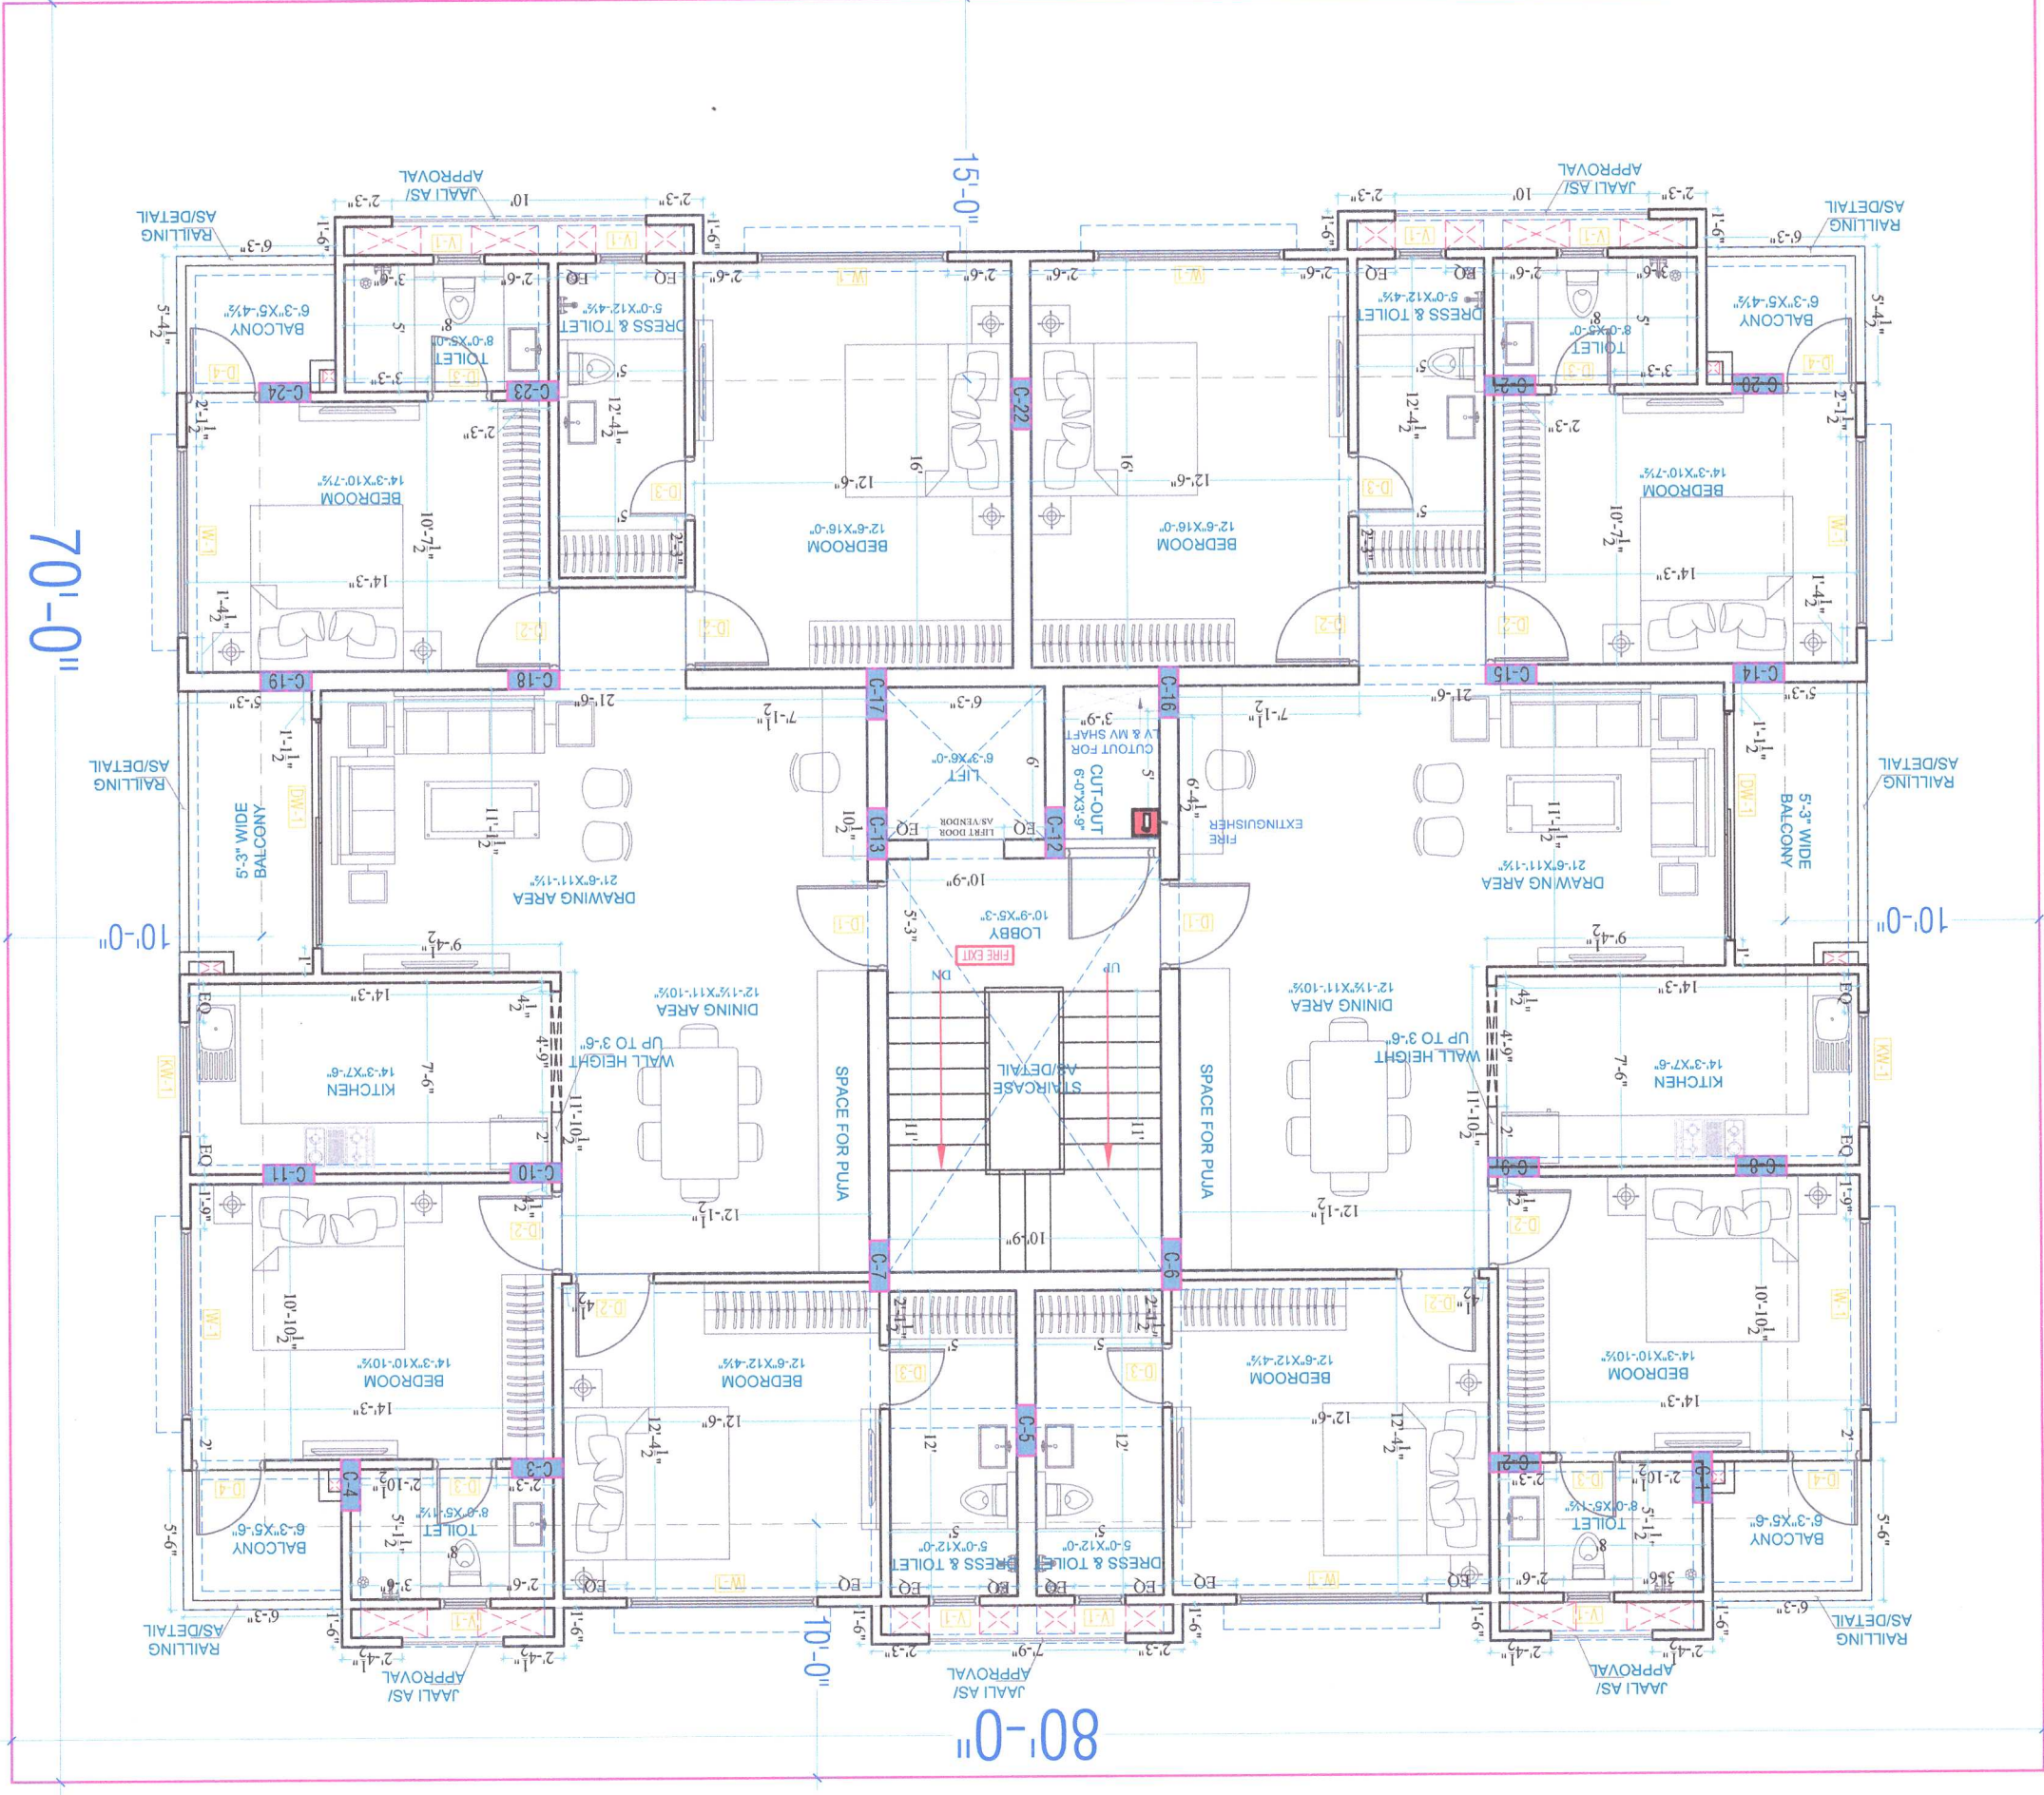

40'-0" WIDE ROAD

80'-0"

70'-0"

10'-0"

15'-0"

10'-0"

FIRE FIGHTING DRAWING

RAVEEN KUMAR
DTECH (ELECT)
Bawer

NO	DESCRIPTION	SYMBOL	QTY
1.	SELF LUMINOUS GLOW SIGN BOARD		01 NOS
2.	FIRE EXTINGUISHER		01 NOS
3.	FIRE BUCKETS		00 NOS

MEP CONSULTANT
SRAJAN ASSOCIATES
MEP CONSULTANT
C-35A, Lajpat Marg, C-Scheme, JAIPUR.
Email-id : snajapur@hotmail.com

REVISIONS

DT.	NO.	ISSUED TO	CKD

PRINTS DATA

PROJECT TITLE

PROPOSED RESIDENTIAL
APARTMENT (BUNGLOW 10)
AT J 4 & 5 NANDAN VIHAR
MAHAL JAGATPURA JAIPUR


DRAWING TITLE

FIFTH FLOOR
FIRE FIGHTING PLAN

ARCHITECTS :
MISHRA GARG & ASSOCIATES
C-35A, Lajpat Marg, C-Scheme, Jaipur.
ph: +91-141-237-3274, 5104986, e-mail: mishragarg@gmail.com

DESIGN & CHECKED BY	PROJECT	ARCHITECT	DATE
PRAVEEN	19-6-2024		

SCALE	DATE	NO.	NTS
3.303			

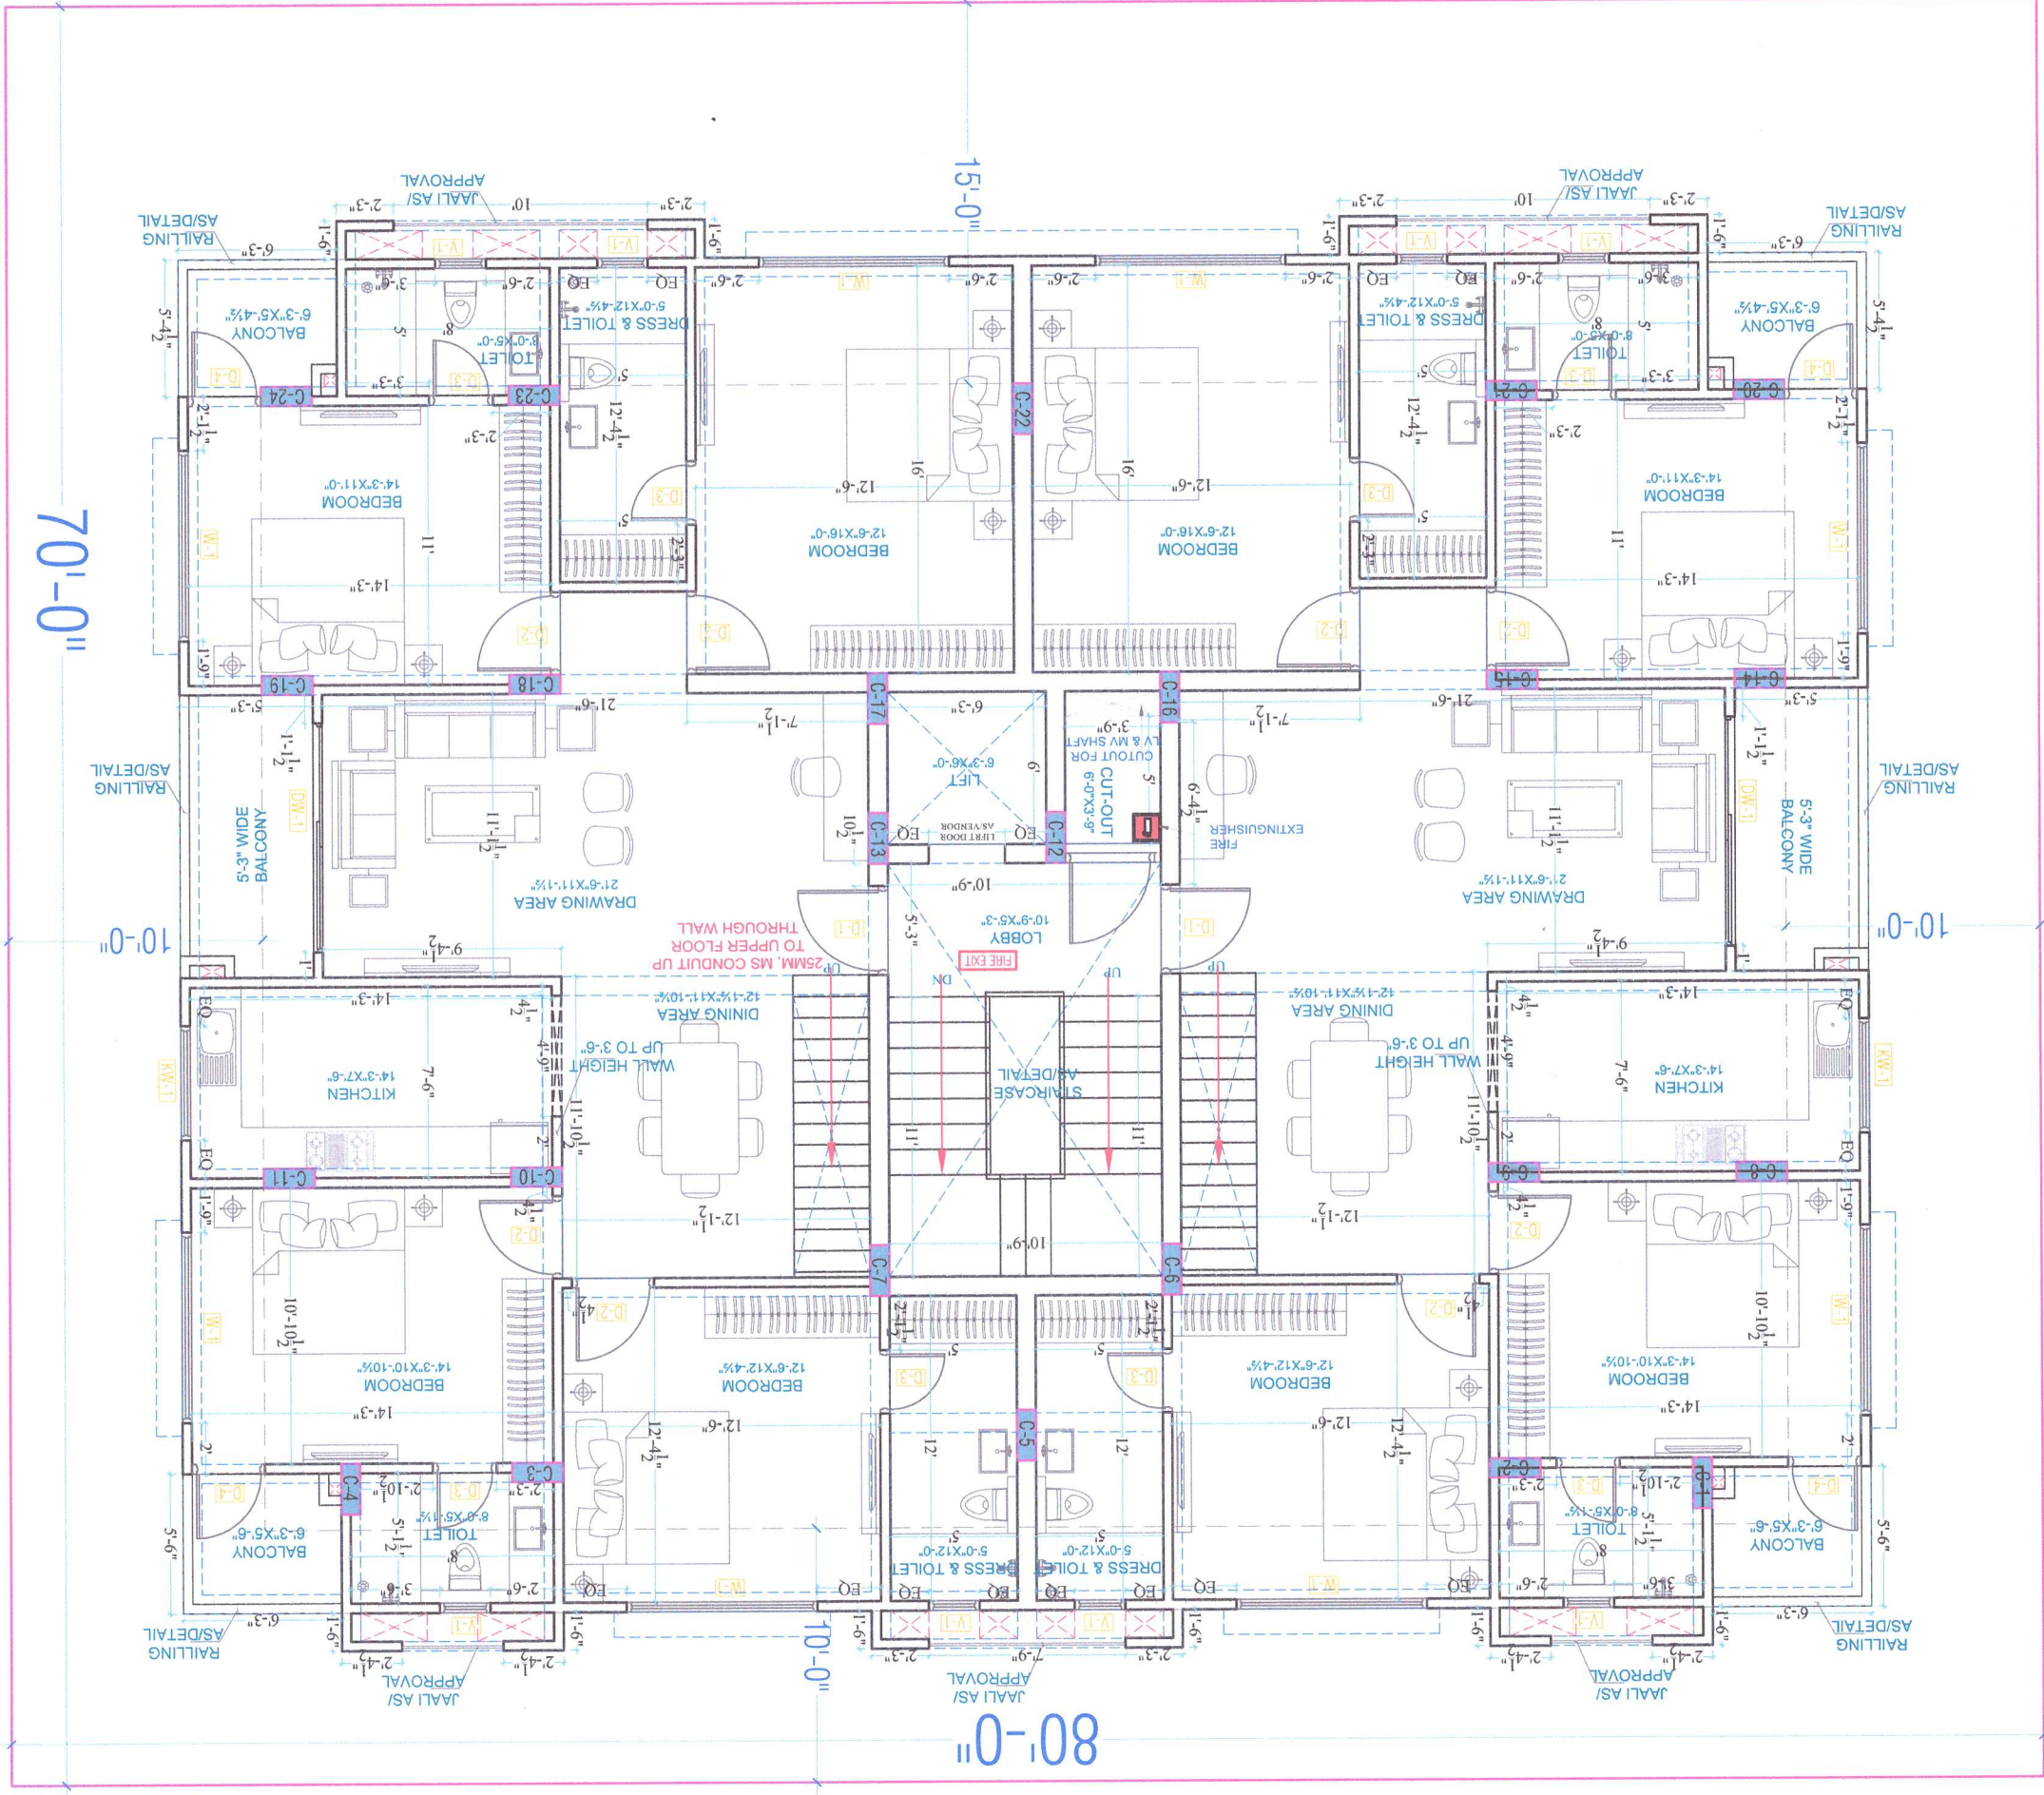

40'-0" WIDE ROAD

80'-0"

70'-0"

10'-0"

LEGEND	
NO	DESCRIPTION
QTY	SYMBOL
1.	SELF LUMINOUS GLOW SIGN BOARD
01 NOS	
2.	FIRE EXTINGUISHER
01 NOS	
3.	FIRE BUCKETS
00 NOS	

PRAVEEN KUMAR
BTECH (ELECT)

MEP CONSULTANT

SRAJAN ASSOCIATES
MEP CONSULTANT
C-35A, Lajpat Marg, C-Scheme, JAIPUR,
Email-id : snaajapur@hotmail.com

DT.	NO.	ISSUED TO	CKD.

REVISIONS

DT.	NO.	ISSUED TO	CKD.

PRINTS DATA

PROJECT TITLE

PROPOSED RESIDENTIAL
APARTMENT (BUNGLOW 10)
AT J 4 & 5 NANDAN VIHAR
MAHAL JAGATPURA JAIPUR

DRAWING TITLE

TERRACE FLOOR
FIRE FIGHTING PLAN

ARCHITECTS:

MISHRA GARG & ASSOCIATES

C-35A, Scheme, Lajpat Marg, Jagatpura, Jaipur.
ph: +91-141-237-3274, 5104986; e-mail: misha.garg@gmail.com

DESIGN & CHECKED BY: PROJECT ARCHITECT
DATE: 19-6-2024


N.T.S

SCALE:

PROJEN

JOIN NO.

3.304

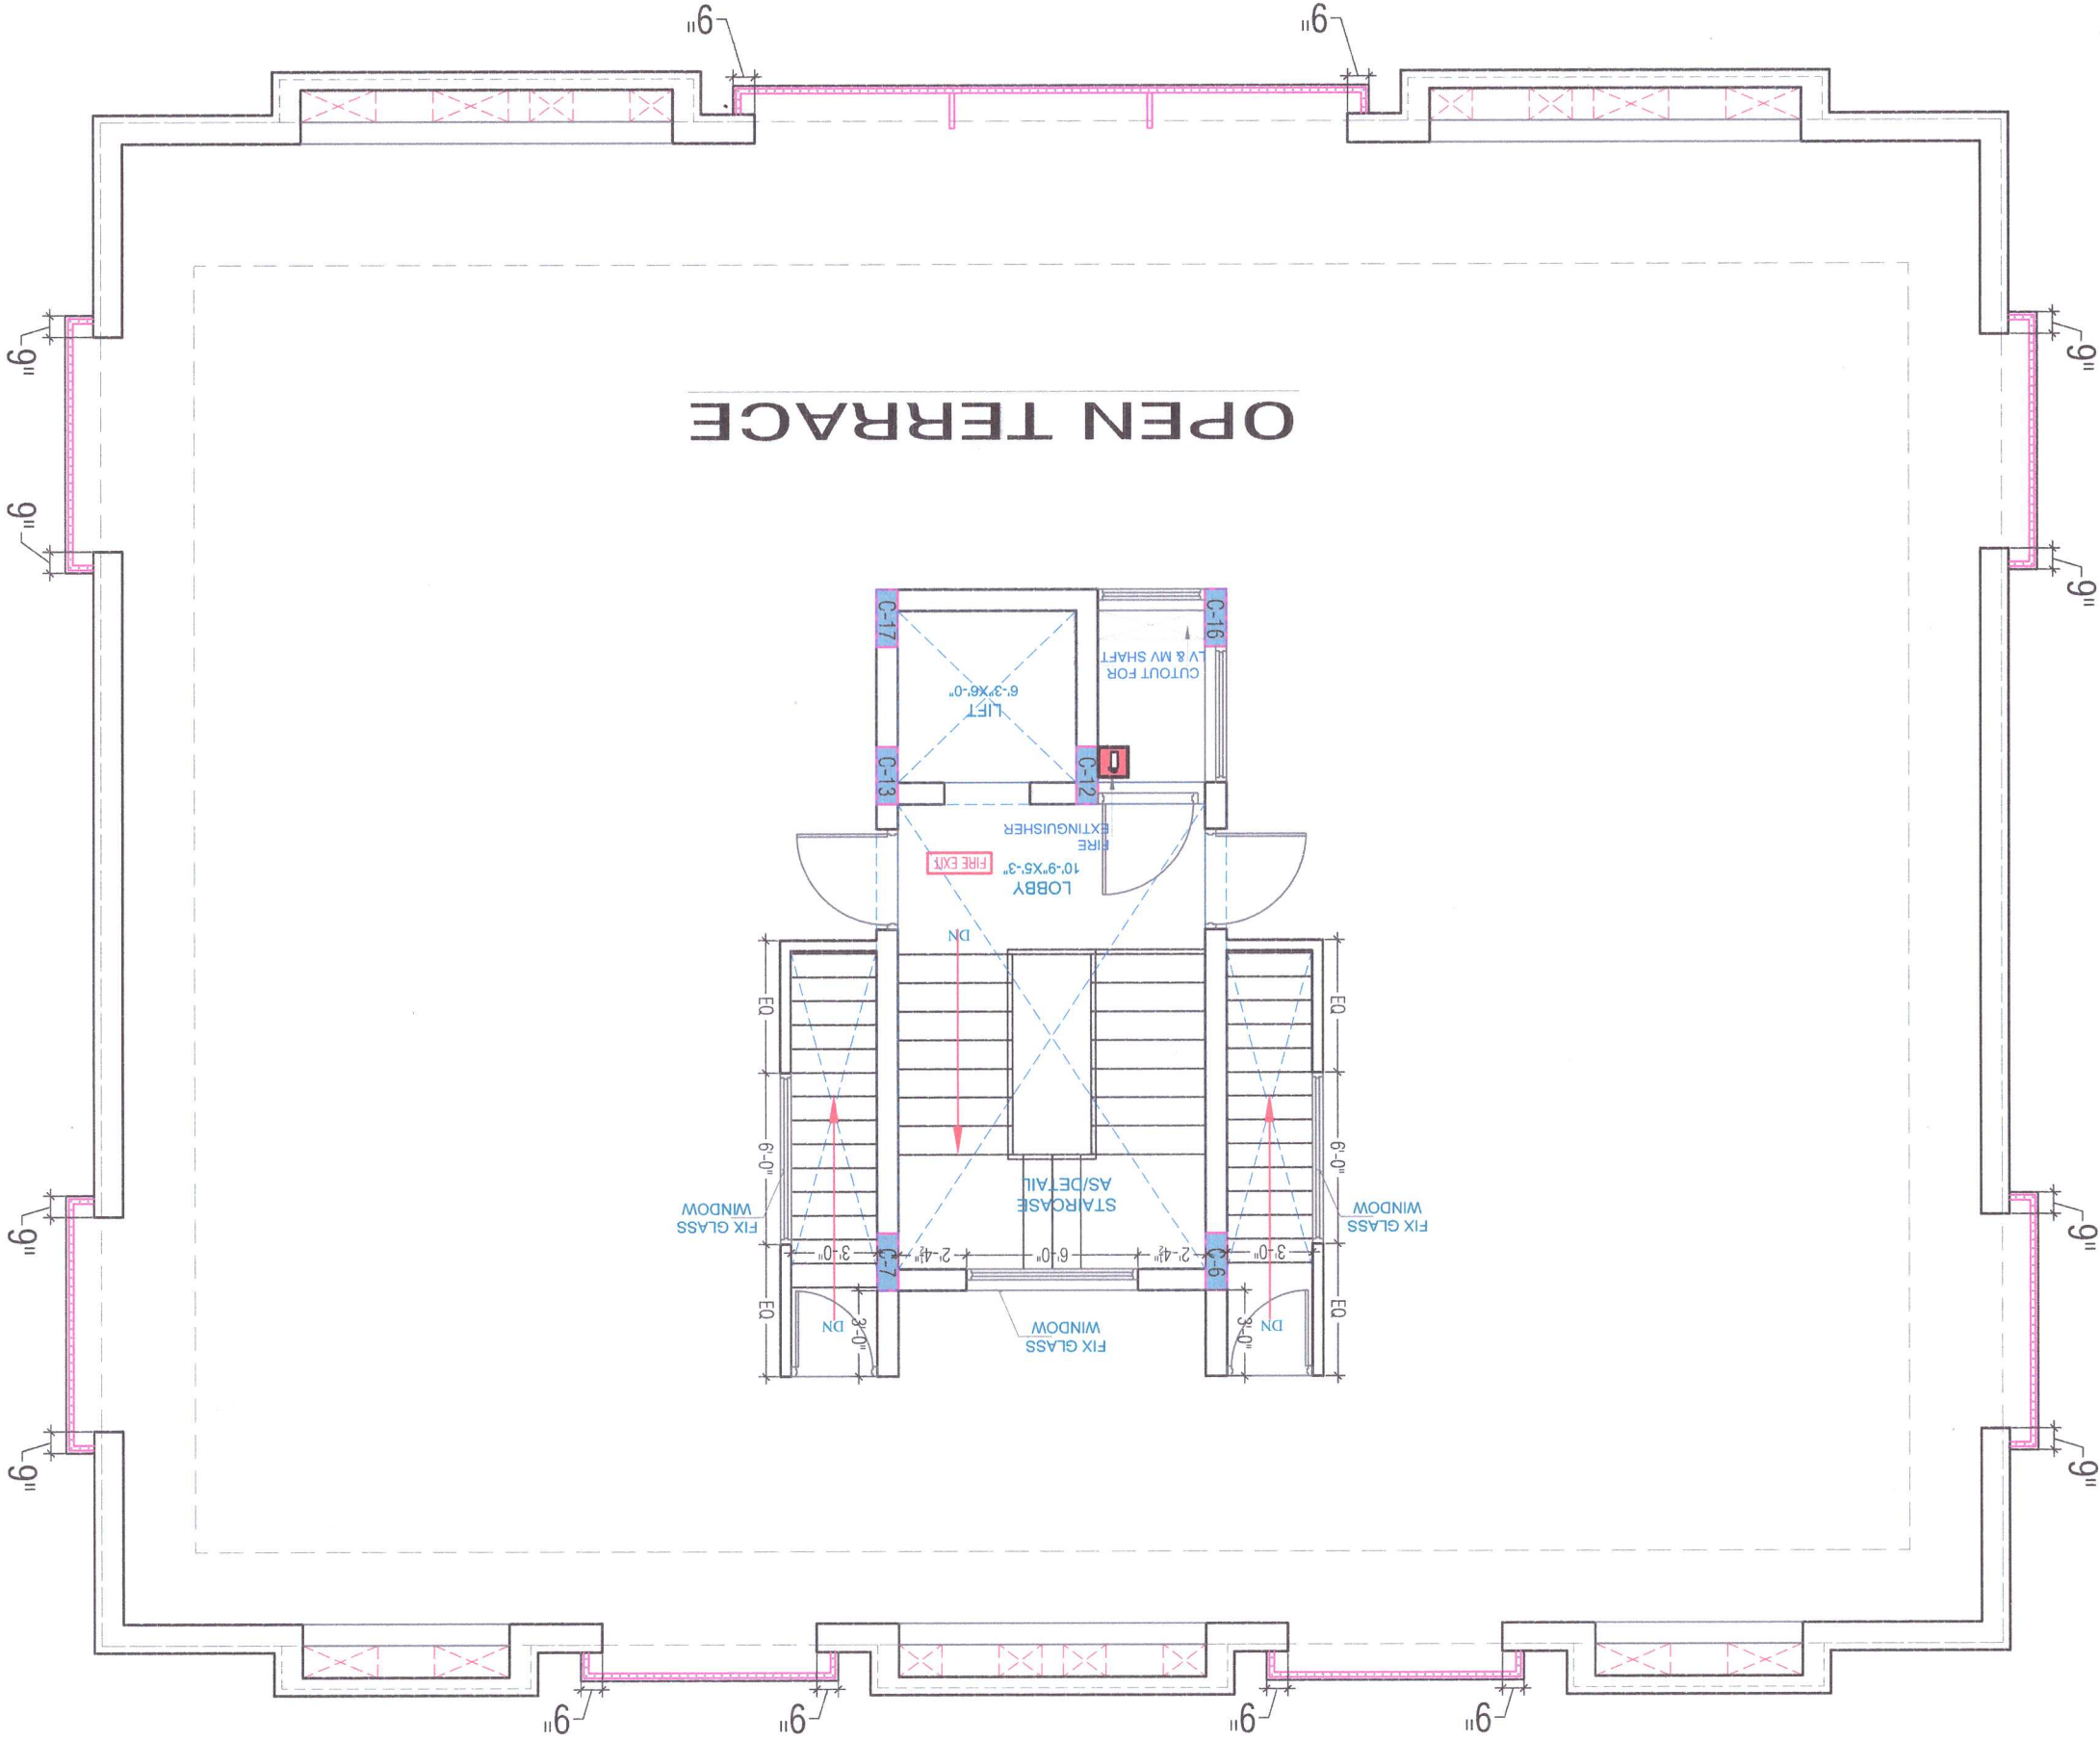

TERRACE