



BASEMENT FLOOR FIRE FIGHTING
LAYOUT PLAN

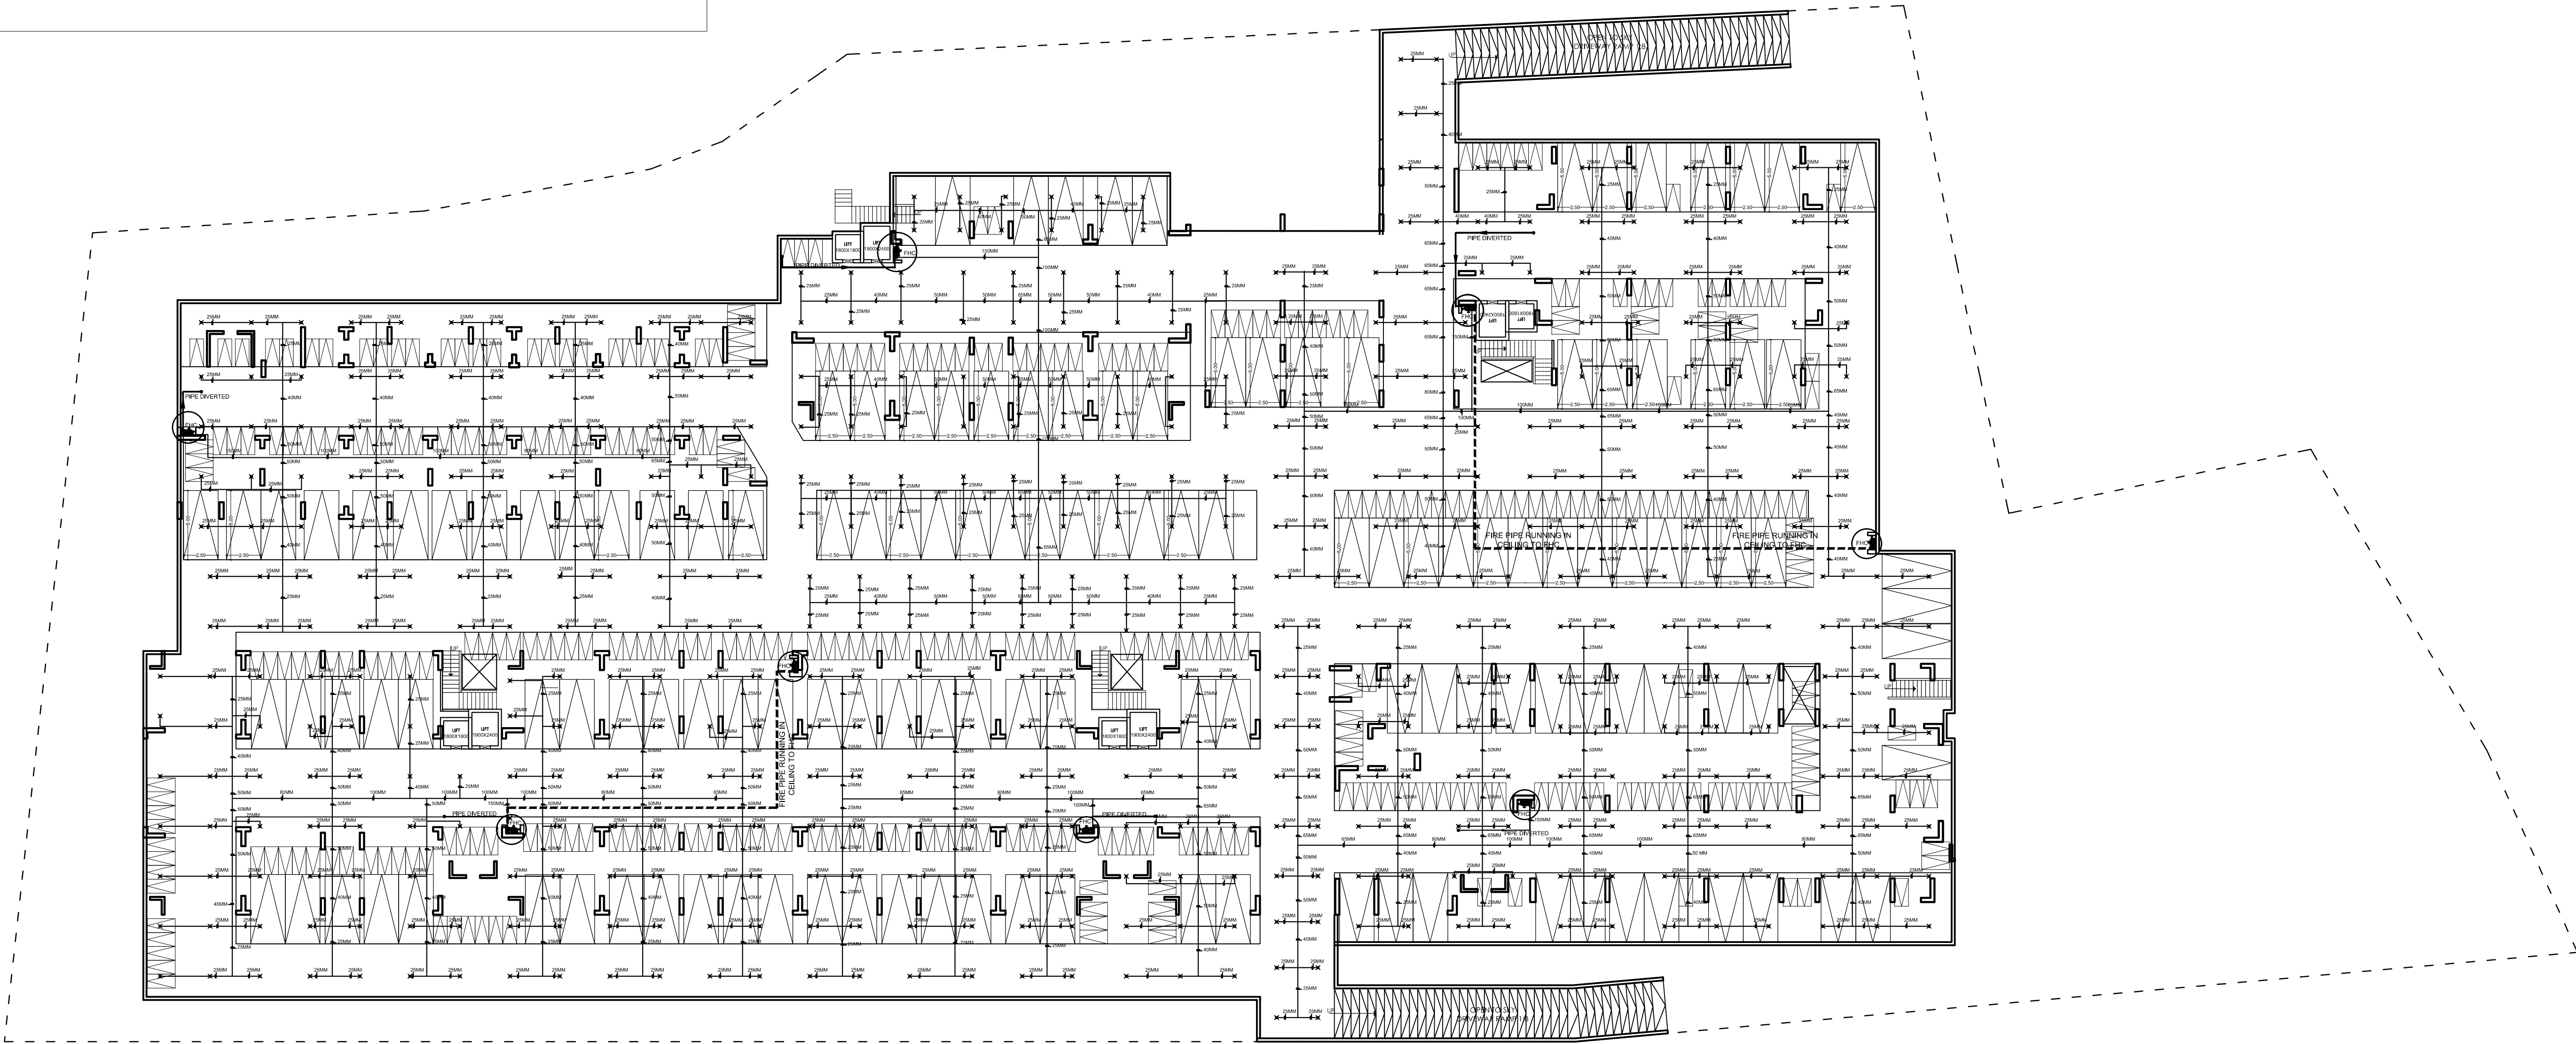

- LEGEND:-
- SPRINKLER PIPE
 - FIRE HYDRANT CABINET
 - PENDENT SPRINKLER

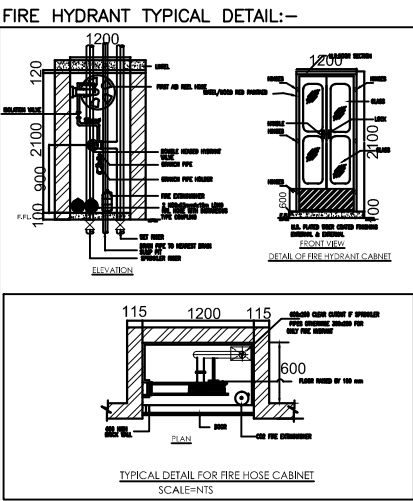

DWG TITLE:-

FIRE SUBMISSION LAYOUT
(BASEMENT FLOOR)

MEP CONSULTANT:-

SHRESHTHA
The Institute of your Success

B-4 MAHARANI APARTMENT
B-308, RAJENDRA MARG,
BAPU NAGAR, JAIPUR
PIN: 302005

Email: shreshthaconsultants@gmail.com
shreshthaconsultants@gmail.com

SEAL BY:-	PRASHANT
CHECKED BY:-	ANUSH
DATE:-	21.08.2019
DRAWING NO.:-	

SHEET NO. -02

PROJECT TITLE

PROPOSED CMJAY -2015 (PROVISION 3A)
PLOT NO. 1-A SIRSI ROAD JAIPUR

DRAWING TITLE

FLOOR PLAN

DATE	SCALE	NORTH
	1 : 250	N →

ARCHITECT'S SIGNATURE	OWNER'S SIGNATURE