


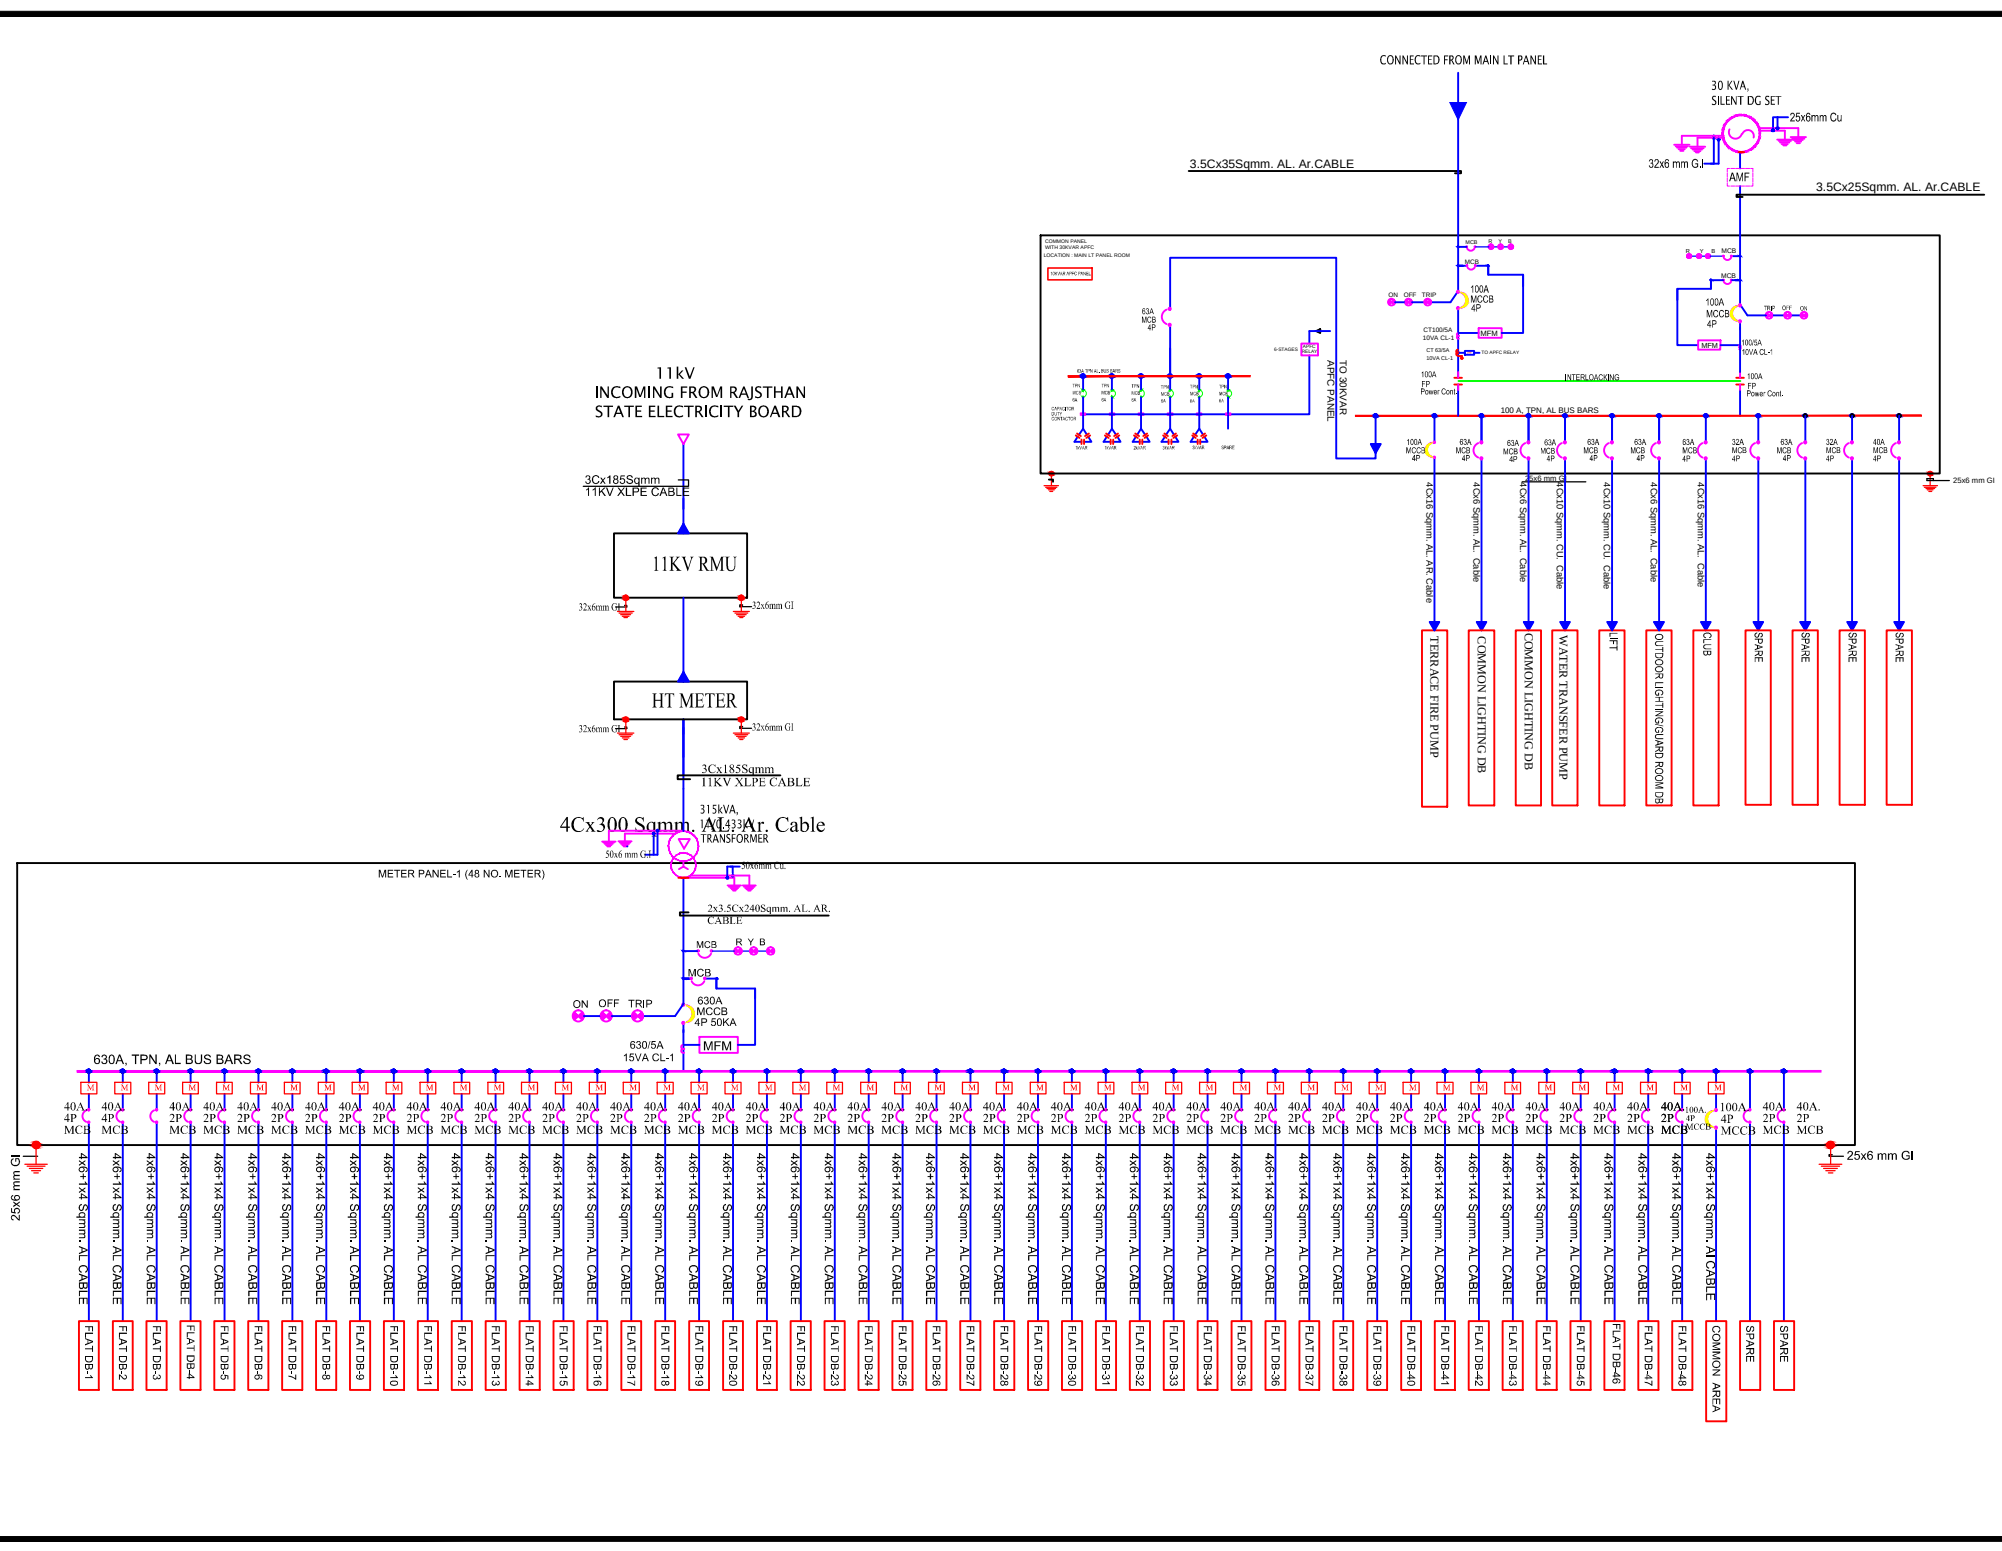

LEGEND

SYMB.	DESCRIPTION
[Symbol]	AMMETER
[Symbol]	VOLT METER
[Symbol]	POWER FACTOR METER
[Symbol]	VOLTMETER, AMMITER, FRICTION METER
[Symbol]	FREQUENCY METER
[Symbol]	KILOWATT HOUR METER
[Symbol]	KILOWATT METER
[Symbol]	AMMETER SELECTOR SWITCH
[Symbol]	VOLTMETER SELECTOR SWITCH
[Symbol]	LOCKOUT RELAY
[Symbol]	SUPERVISORY TRIP RELAY
[Symbol]	UNDER VOLTAGE DEVICE
[Symbol]	OVER VOLTAGE DEVICE
[Symbol]	REVERSE POWER PHASE DEVICE
[Symbol]	DIFFERENTIAL PROTECTION RELAY
[Symbol]	OVER CURRENT & EARTH FAULT RELAY
[Symbol]	MULTI FUCTION RELEY
[Symbol]	ELECTRICAL OPERATED MANUALLY DRAWOUT
[Symbol]	CONTROL FUSE
[Symbol]	CURRENT TRANSFORMER
[Symbol]	TRIVECTOR METER
[Symbol]	INDICATING LAMP
[Symbol]	OVER LOAD RELAY
[Symbol]	POWER CONTACTOR
[Symbol]	POTENTIAL TRANSFORMER
[Symbol]	DUAL SOURCE ELECTRONIC ENERGY METER
[Symbol]	GROUNDING
[Symbol]	MICRO PROCESSOR BASED RELEASE
[Symbol]	ELECTRONIC ENERGY METER
[Symbol]	AIR CIRCUIT BREAKER
[Symbol]	VACUUM CIRCUIT BREAKER
[Symbol]	MINIATURE CIRCUIT BREAKER
[Symbol]	MOULDED CASE CIRCUIT BREAKER
[Symbol]	MOTOR PROTECTION CIRCUIT BREAKER

REVISION - 00

GENERAL NOTES :

1. ALL THE DIMENSIONS ON THE DRAWING ARE IN WRITTEN.

2. ONLY WRITTEN DIMENSIONS ARE TO BE FOLLOWED.

3. ALL MEASUREMENTS MUST BE CHECKED AND VERIFIED BY THE CONTRACTORS PRIOR TO EXECUTION OF WORK AT THE SITE.

4. THIS DRAWING IS TO BE READ IN CONJUNCTION WITH ALL RELEVANT STRUCTURAL, ARCHITECTURAL & FACILITY PLANNING DRAWINGS.

5. ANY DISCREPANCIES MUST BE BROUGHT TO THE NOTICE OF THE ENGINEER IMMEDIATELY & PRIOR TO EXECUTION AT SITE.

6. CO-ORDINATION WITH SERVICES SUCH AS HVAC, PLUMBING & ELECTRICAL, ETC. IS THE RESPONSIBILITY OF THE CONTRACTORS.

7. FOR DETAILS, REFER RELEVANT LARGE SCALE DETAIL DRGS. AS INDICATED.

LIGHTING LEGEND

SR.NO.	SYMBOL	DESCRIPTION	HEIGHT FROM FFL
1	[Symbol]	CEILING TUBELIGHT POINT	CEILING
2	[Symbol]	LED CEILING LIGHT POINT	CEILING
3	[Symbol]	LED WALL BRACKET LIGHT POINT AT WALL	+7'-4"
4	[Symbol]	6A SOCKET WITH SWITCH	+2'-0"
5	[Symbol]	GENERAL POINT 16A SOCKET WITH SWITCH	+4'-0"
6	[Symbol]	MDP BOX	+5'-0"
7	[Symbol]	CEILING ROBE	+7'-4"
8	[Symbol]	SWITCH BOARD	+4'-0"
9	[Symbol]	EXHAUST FAN	VENT. HT.
10	[Symbol]	LIGHT & POWER DISTRIBUTION BOARD	+5'-4"
11	[Symbol]	Ø25MM POWER CIRCUIT CONDUIT	CEILING
12	[Symbol]	Ø25MM POWER CIRCUIT CONDUIT	CEILING FLOORING
13	[Symbol]	Ø25MM LIGHT CIRCUIT CONDUIT	CEILING FLOORING
14	[Symbol]	CEILING FAN	CEILING

ARCHITECT

ARCHITECT :-

FRANK SQUARE

ARCHITECTURE | PLANNER | DESIGNER

C-49 VIDYA APARTMENT PARAS MARG,

BAPU NAGAR JAIPUR, (RAJ.)

Email-afranksquare@gmail.com

Mobile-9461302542

PROJECT :-

Project Address: Plot No. 17, 18, 19 (West Part) Scheme Uday Nagar A (Arvind Nagar G.N.S.S), Near Mansarovar Metro Station, Mansarovar, Jaipur

BUILDER/DEVELOPER/CLIENT:-

DRAWING TITLE:- MAIN PANEL SLD

BUILDING NAME

PARTH CROWN

SUBMITTED FOR :-

PRELIMINARY

APPROVAL

PROPOSAL

FOR RERA

DATE :-

NORTH :-

DRAWN :-

APPROVED :-

DRAWING NO.:-

SCALE :-

CONSULTANT

AMP INFRA SERVICES

VILLA NO 16. SHUBHASIS GEETA

JAISINGHPURA, BHANKROTA & CHIMANPURA, JAIPUR 302026

EMAIL ID- ampinfrajpr@gmail.com

CONTACT NO. :- 9462866389

RAMESH KUMAR
M.E.P. CONSULTANT
B.E. CIVIL

For Parth Sarthi Build Estate (P) Ltd.
Director



BASEMENT FLOOR ELECTRICAL PLAN


For Parth Sarthi Build Estate (P) Ltd.

[Signature]
Director

[Signature]
DHARMESH SHARMA
B. TECH. (CIVIL)

[Signature]
LOKESH KUMAR GARG
Council of Architechtural
Regd. No. CA/2006/38811

PROJECT TITLE-	PARTH CROWN	DRAWING TITLE	BASEMENT FLOOR ELECTRICAL PLAN	ARCHITECTS
CLIENT:-	PARTH SARTHI BUILD ESTATE PVT. LTD. <small>RECONSTITUTED PLOT NO - 17, 18, 19 WEST PART UDM NAGAR 'A' JAIPUR RAJASTHAN</small>	NORTH		ALPUS ASSOCIATES <small>A UNIT OF ARCHITECTS E-68 HANUMAN PATH NEW SANGHER ROAD BEHIND SANJEEVANI HOSPITAL SHYAM NAGAR EXT. JAIPUR RAJASTHAN PH. 403253 alpusassociates@gmail.com</small>

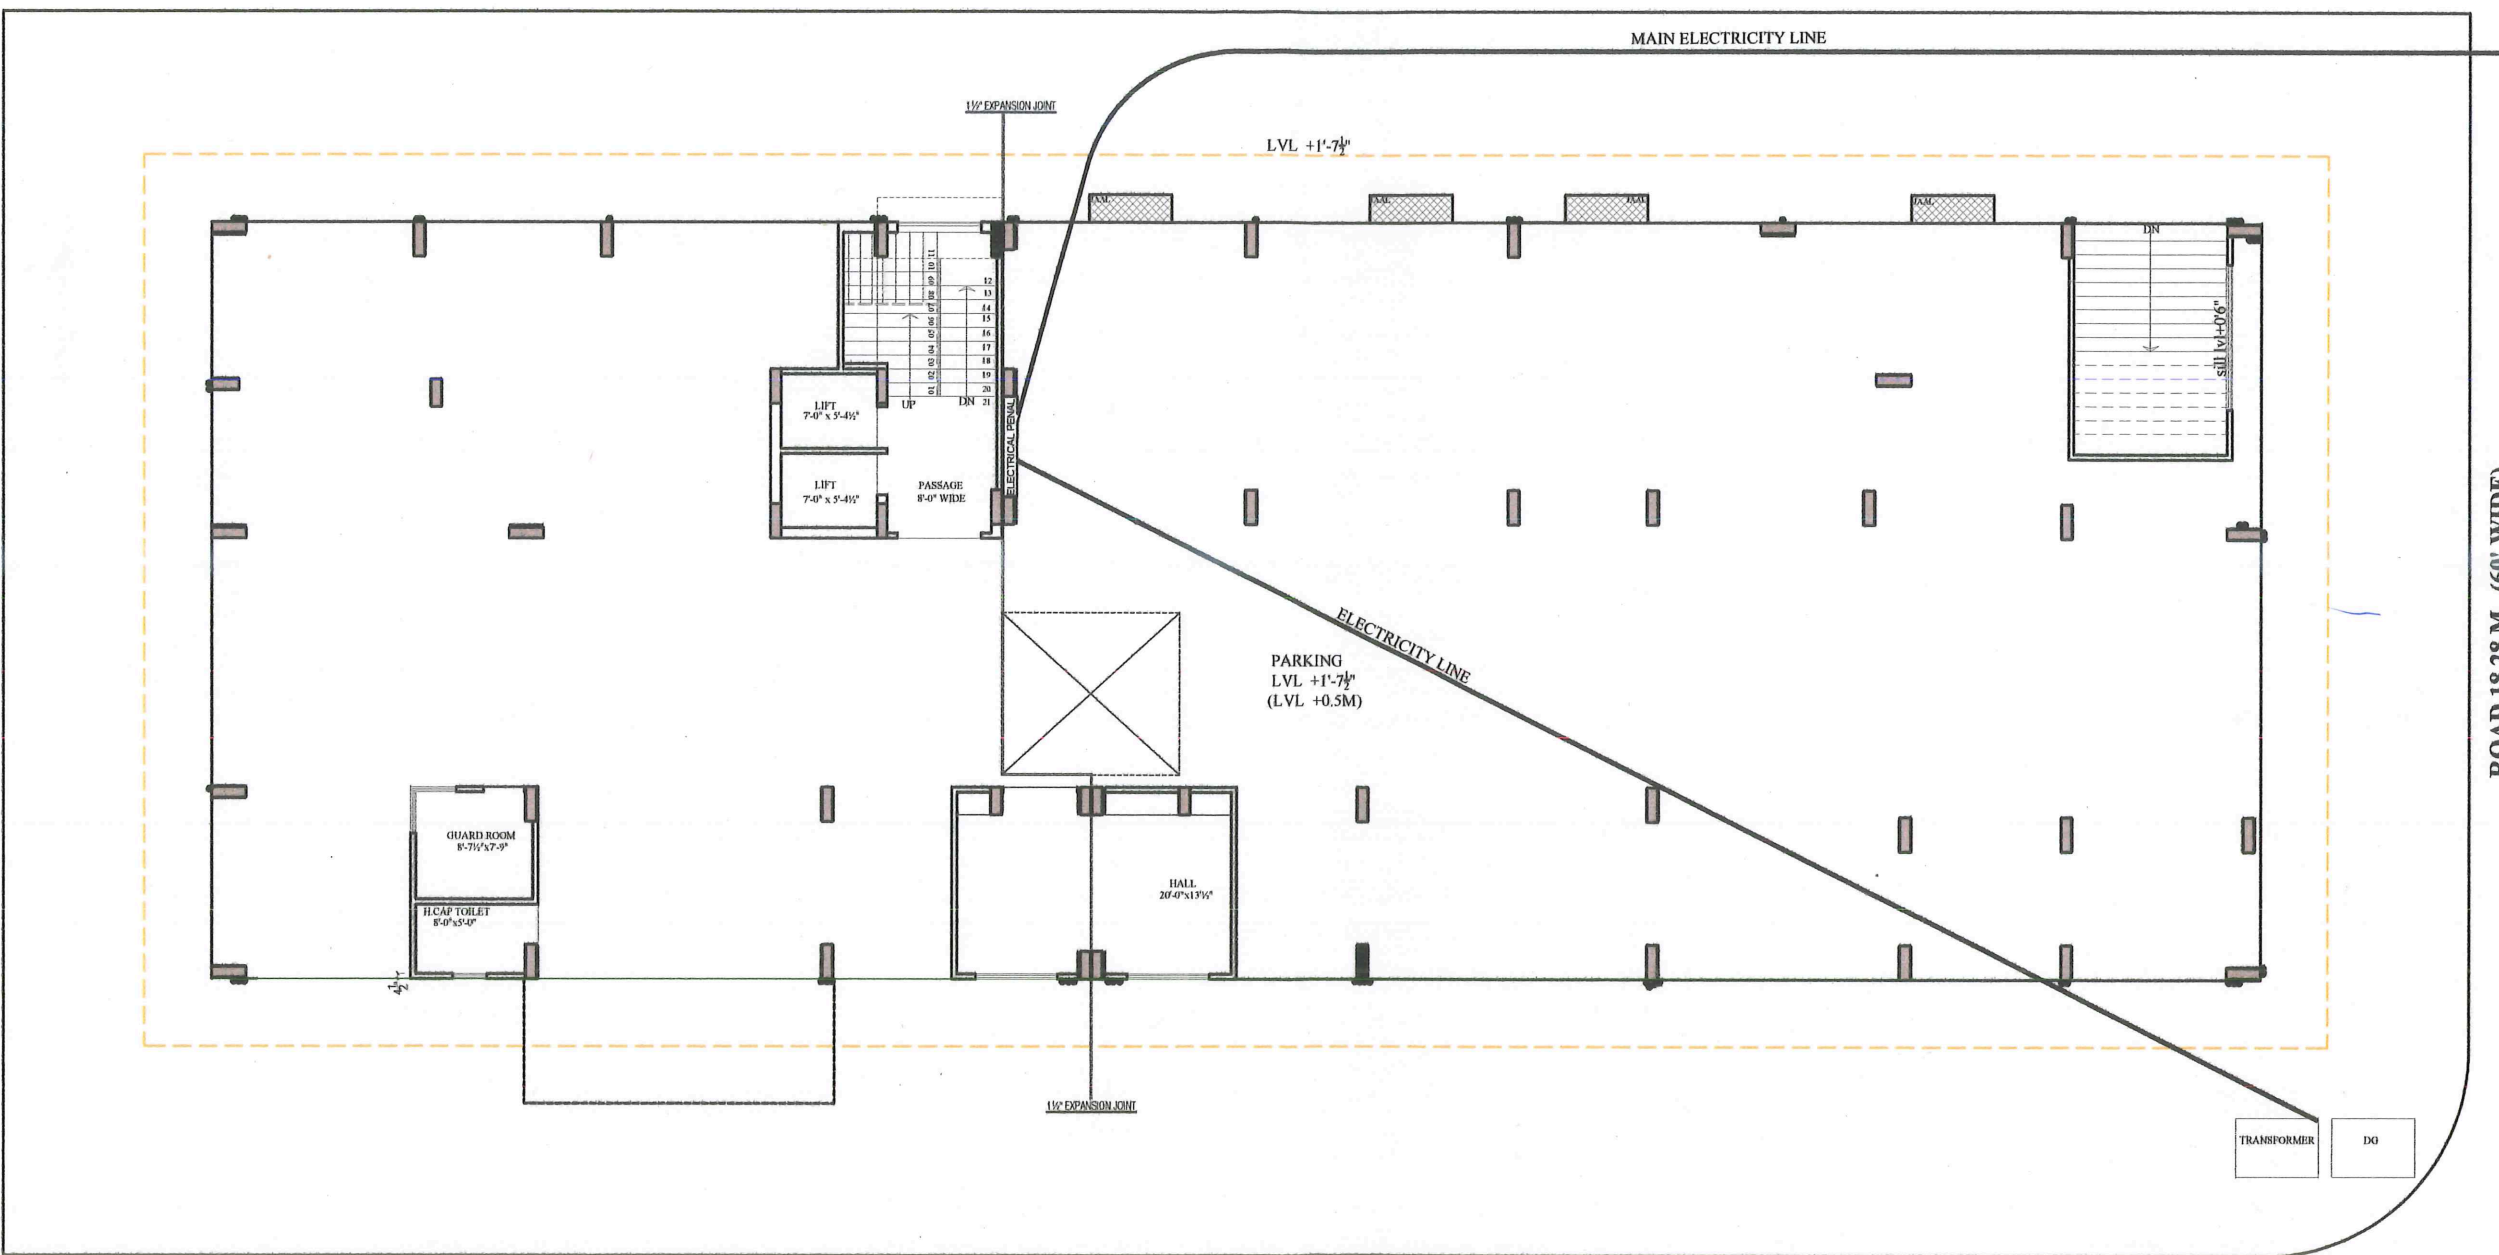

STILT FLOOR ELETRICITY SUPPLY PLAN

ROAD 9.14 M (30' WIDE)

ROAD 18.28 M (60' WIDE)


For Parth Sarthi Build Estate (P) Ltd.

Dharmesh
Director


Dharmesh
DHARMESH SHARMA
B. TECH. (CIVIL)

Prakash
LOKESH KUMAR GARG
Council of Architechtural
Regd. No. CA/2006/38811

PROJECT TITLE-	PARTH CROWN	DRAWING TITLE	STILT FLOOR ELECTRICITY SUPPLY PLAN	ARCHITECTS
CLIENT:	PARTH SARTHI BUILD ESTATE PVT. LTD. (RECONSTITUTED FLOT NO. - 17 IN 19 WEST PART OF UNMURDERED APURVE ESTATE)	NORTH		ALPUS ASSOCIATES UNIT OF ARCHITECTS E-40 HANUMAN PATTI, NEW DELHI 110068 BEHIND SANEERVA HOSPITAL, SYRIN DUGR EXT. INDIA 110068

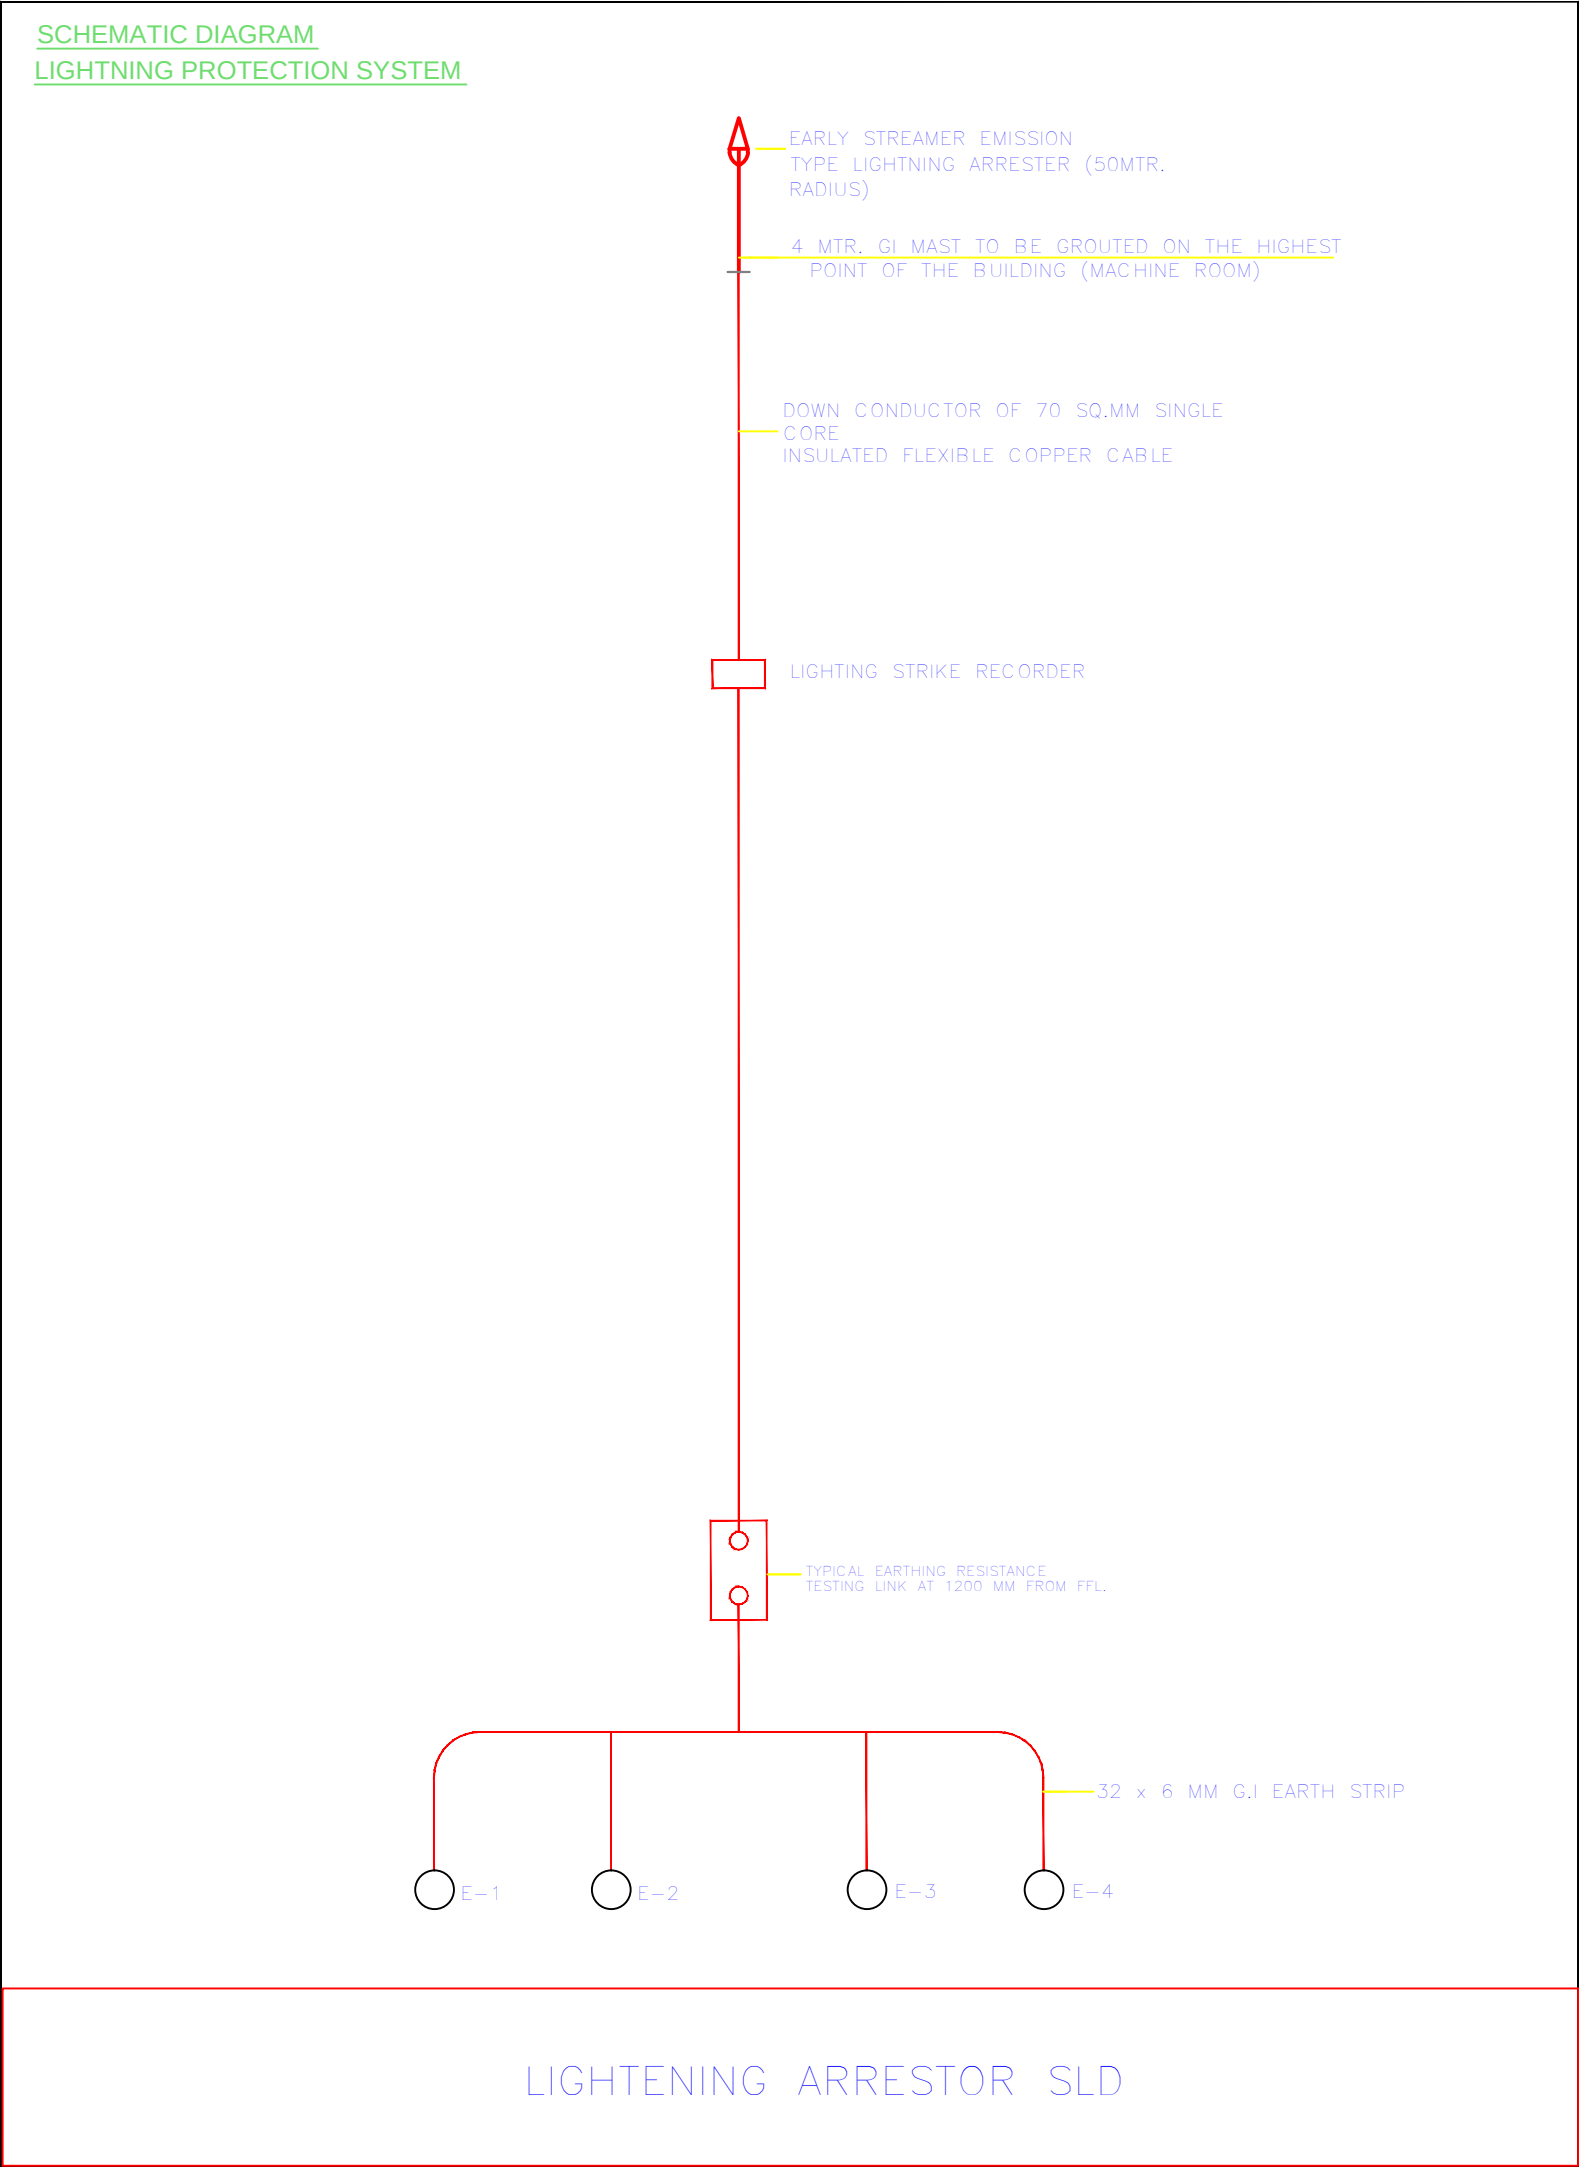

 
RAMESH KUMAWAT
M.E.P. CONSULTANT
B.E. CIVIL

For Parth Sarthi Build Estate (P) Ltd.

Director

PROJECT TITLE :- <u>Project Address: Plot No. 17, 18, 19 (West Part)Scheme Uday Nagar A (Arvind Nagar G.N.S.S), Near Mansarovar Metro Station, Mansarovar, Jaipur</u>	BUILDING NAME PARTH CROWN	DRAWING TITLE :- LIGHTENING ARRESTOR SLD	SPACE CONSULTANT <small>PLOT-A-173, JAGDAMBA NAGAR, HEERAPURA POWER HOWER, JAIPUR (RAJ) 302024</small>	DRN. BY		DATE	NORTH
				APPD. BY		REVISION	
				SCALE			