


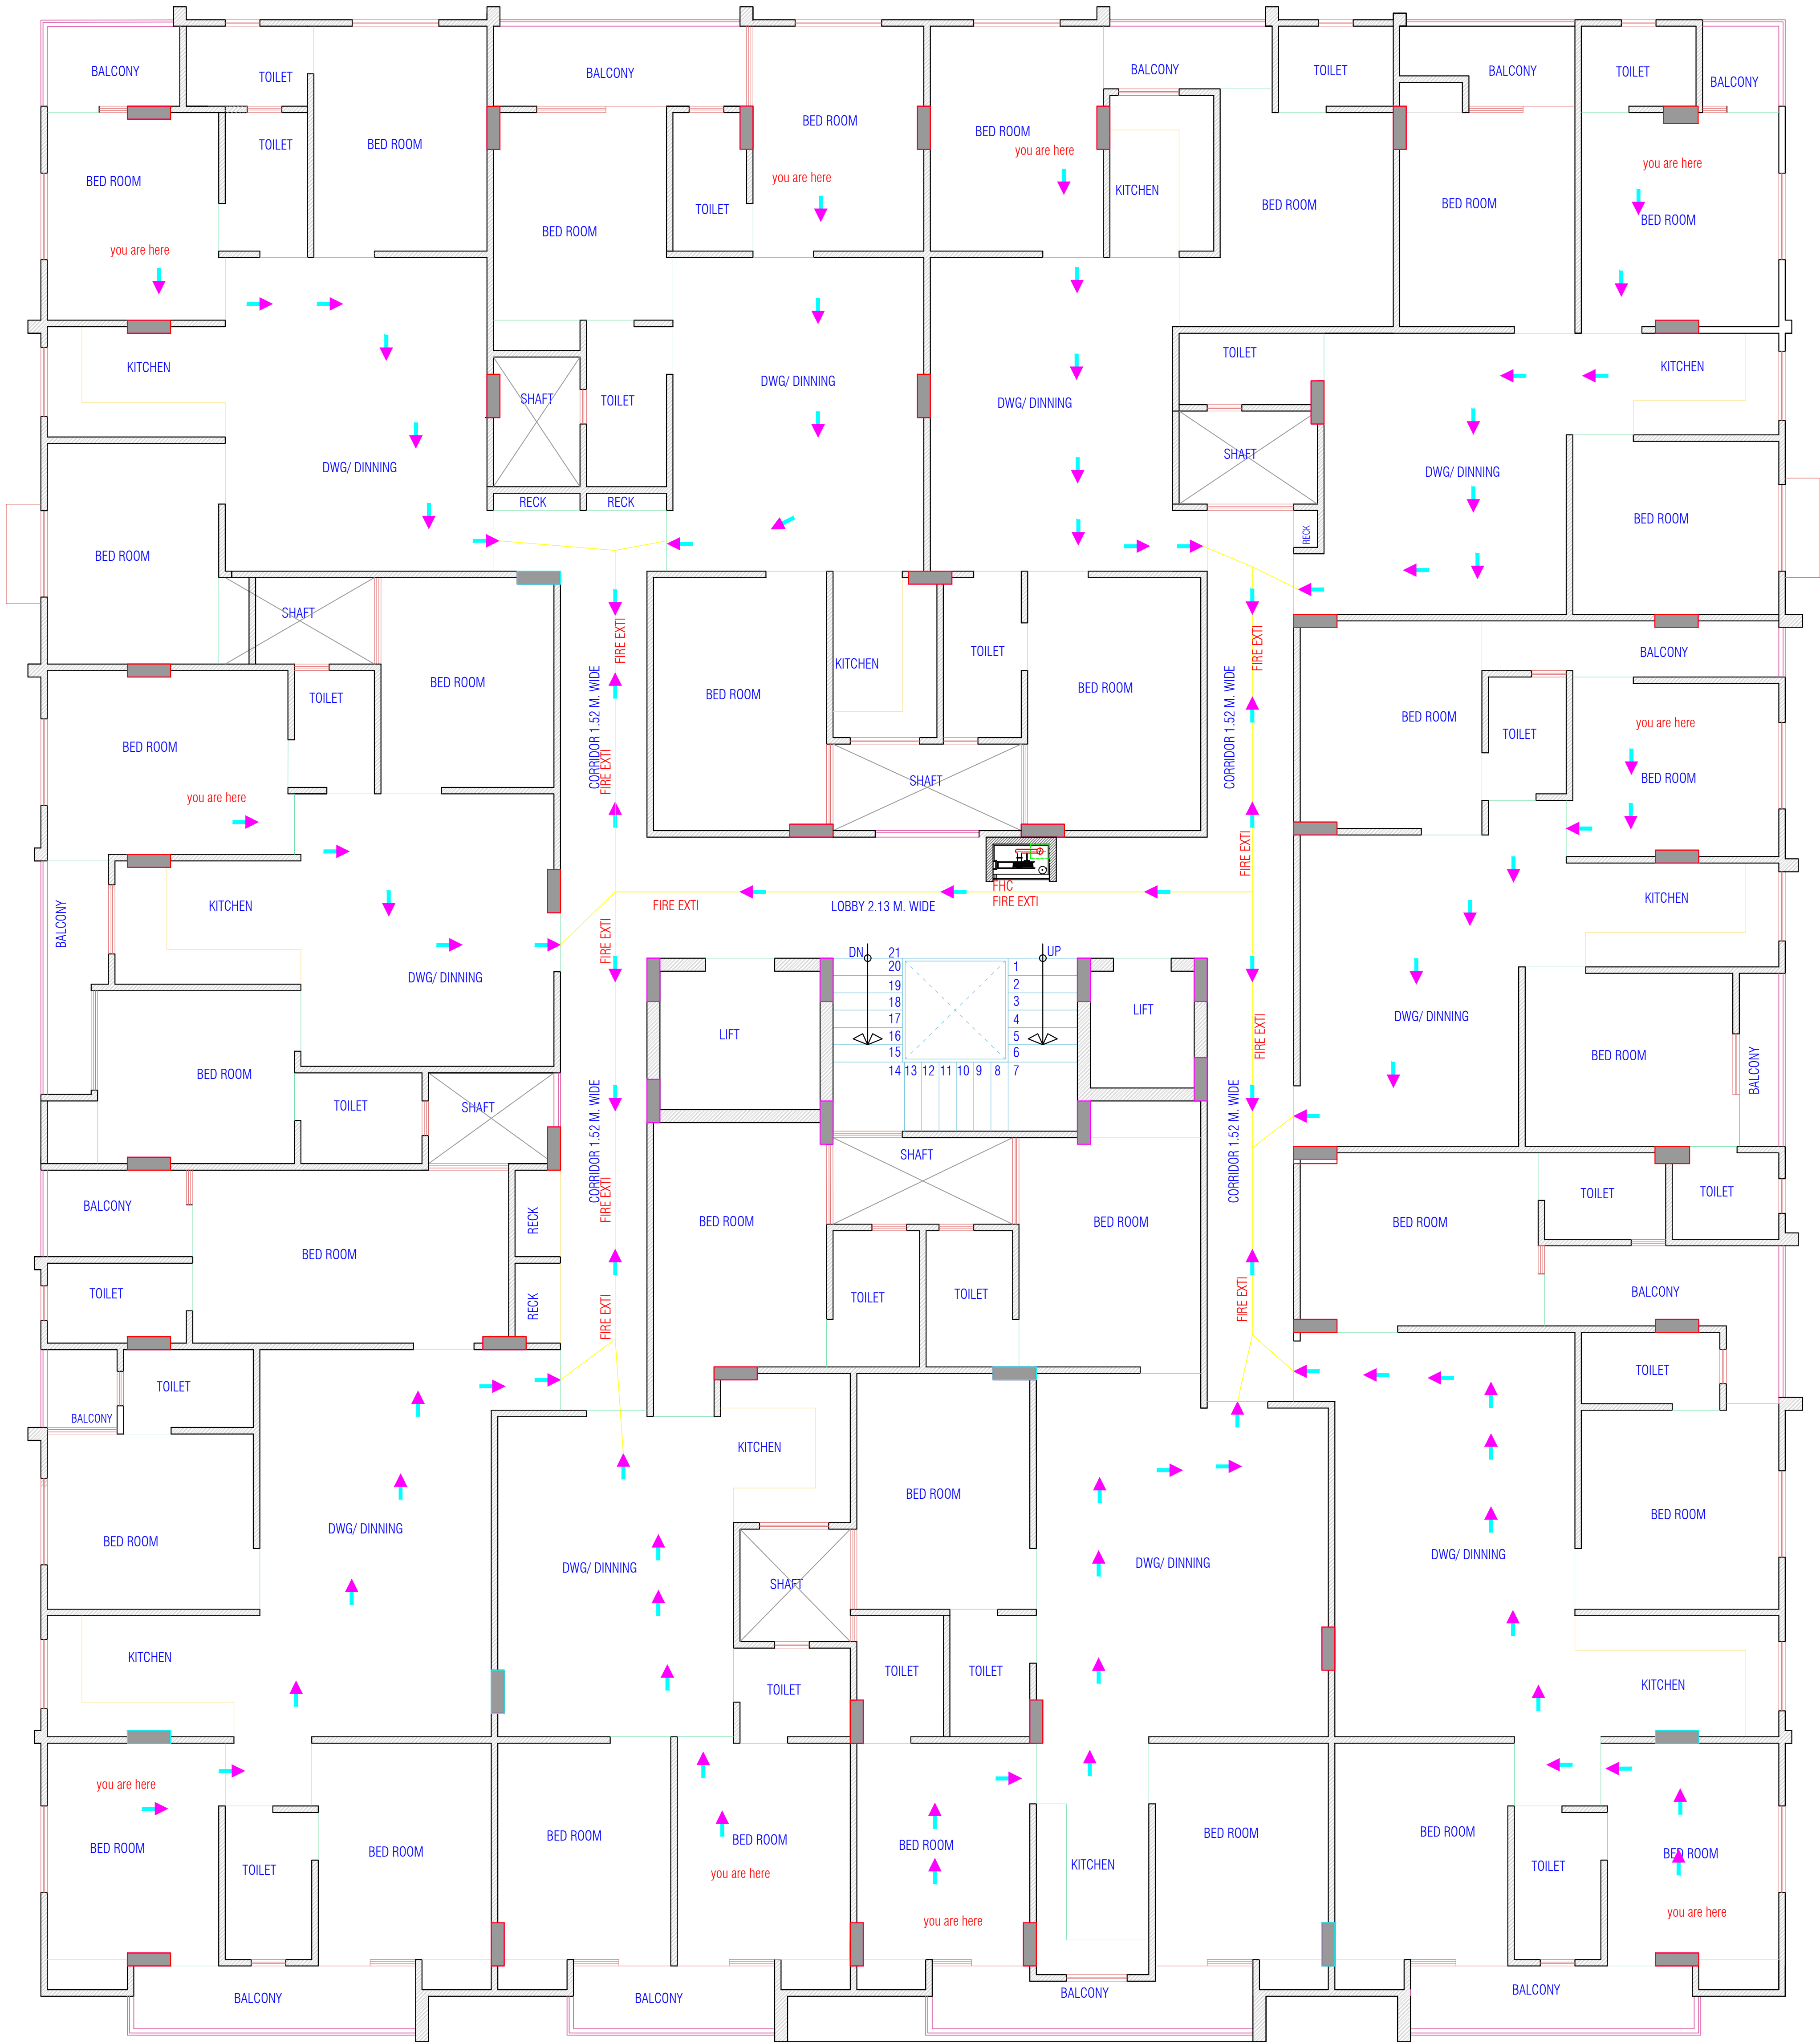


RAMESH KUMAWAT
M.E.P. CONSULTANT
B.E. CIVIL


TYPICAL FLOOR FHC LOCTION &FIRE FIGHTING

PROJECT :-
PROPOSED BUILDING AT PLOT NO. 1 & 2
(W.P.), SINGHANIYA GREENS, JAIPUR

SPACE CONSULTANT
PLOT-A-173, JAGDAMBA NAGAR, HEERAPURA
POWER HOWER, JAIPUR (RAJ) 302024

DRN. BY		DATE
APPD. BY		14-03-2024
SCALE	N.T.S	REVISION

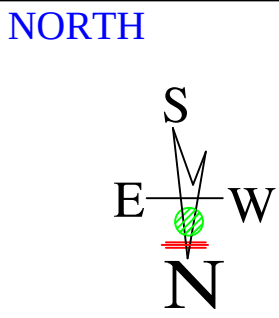

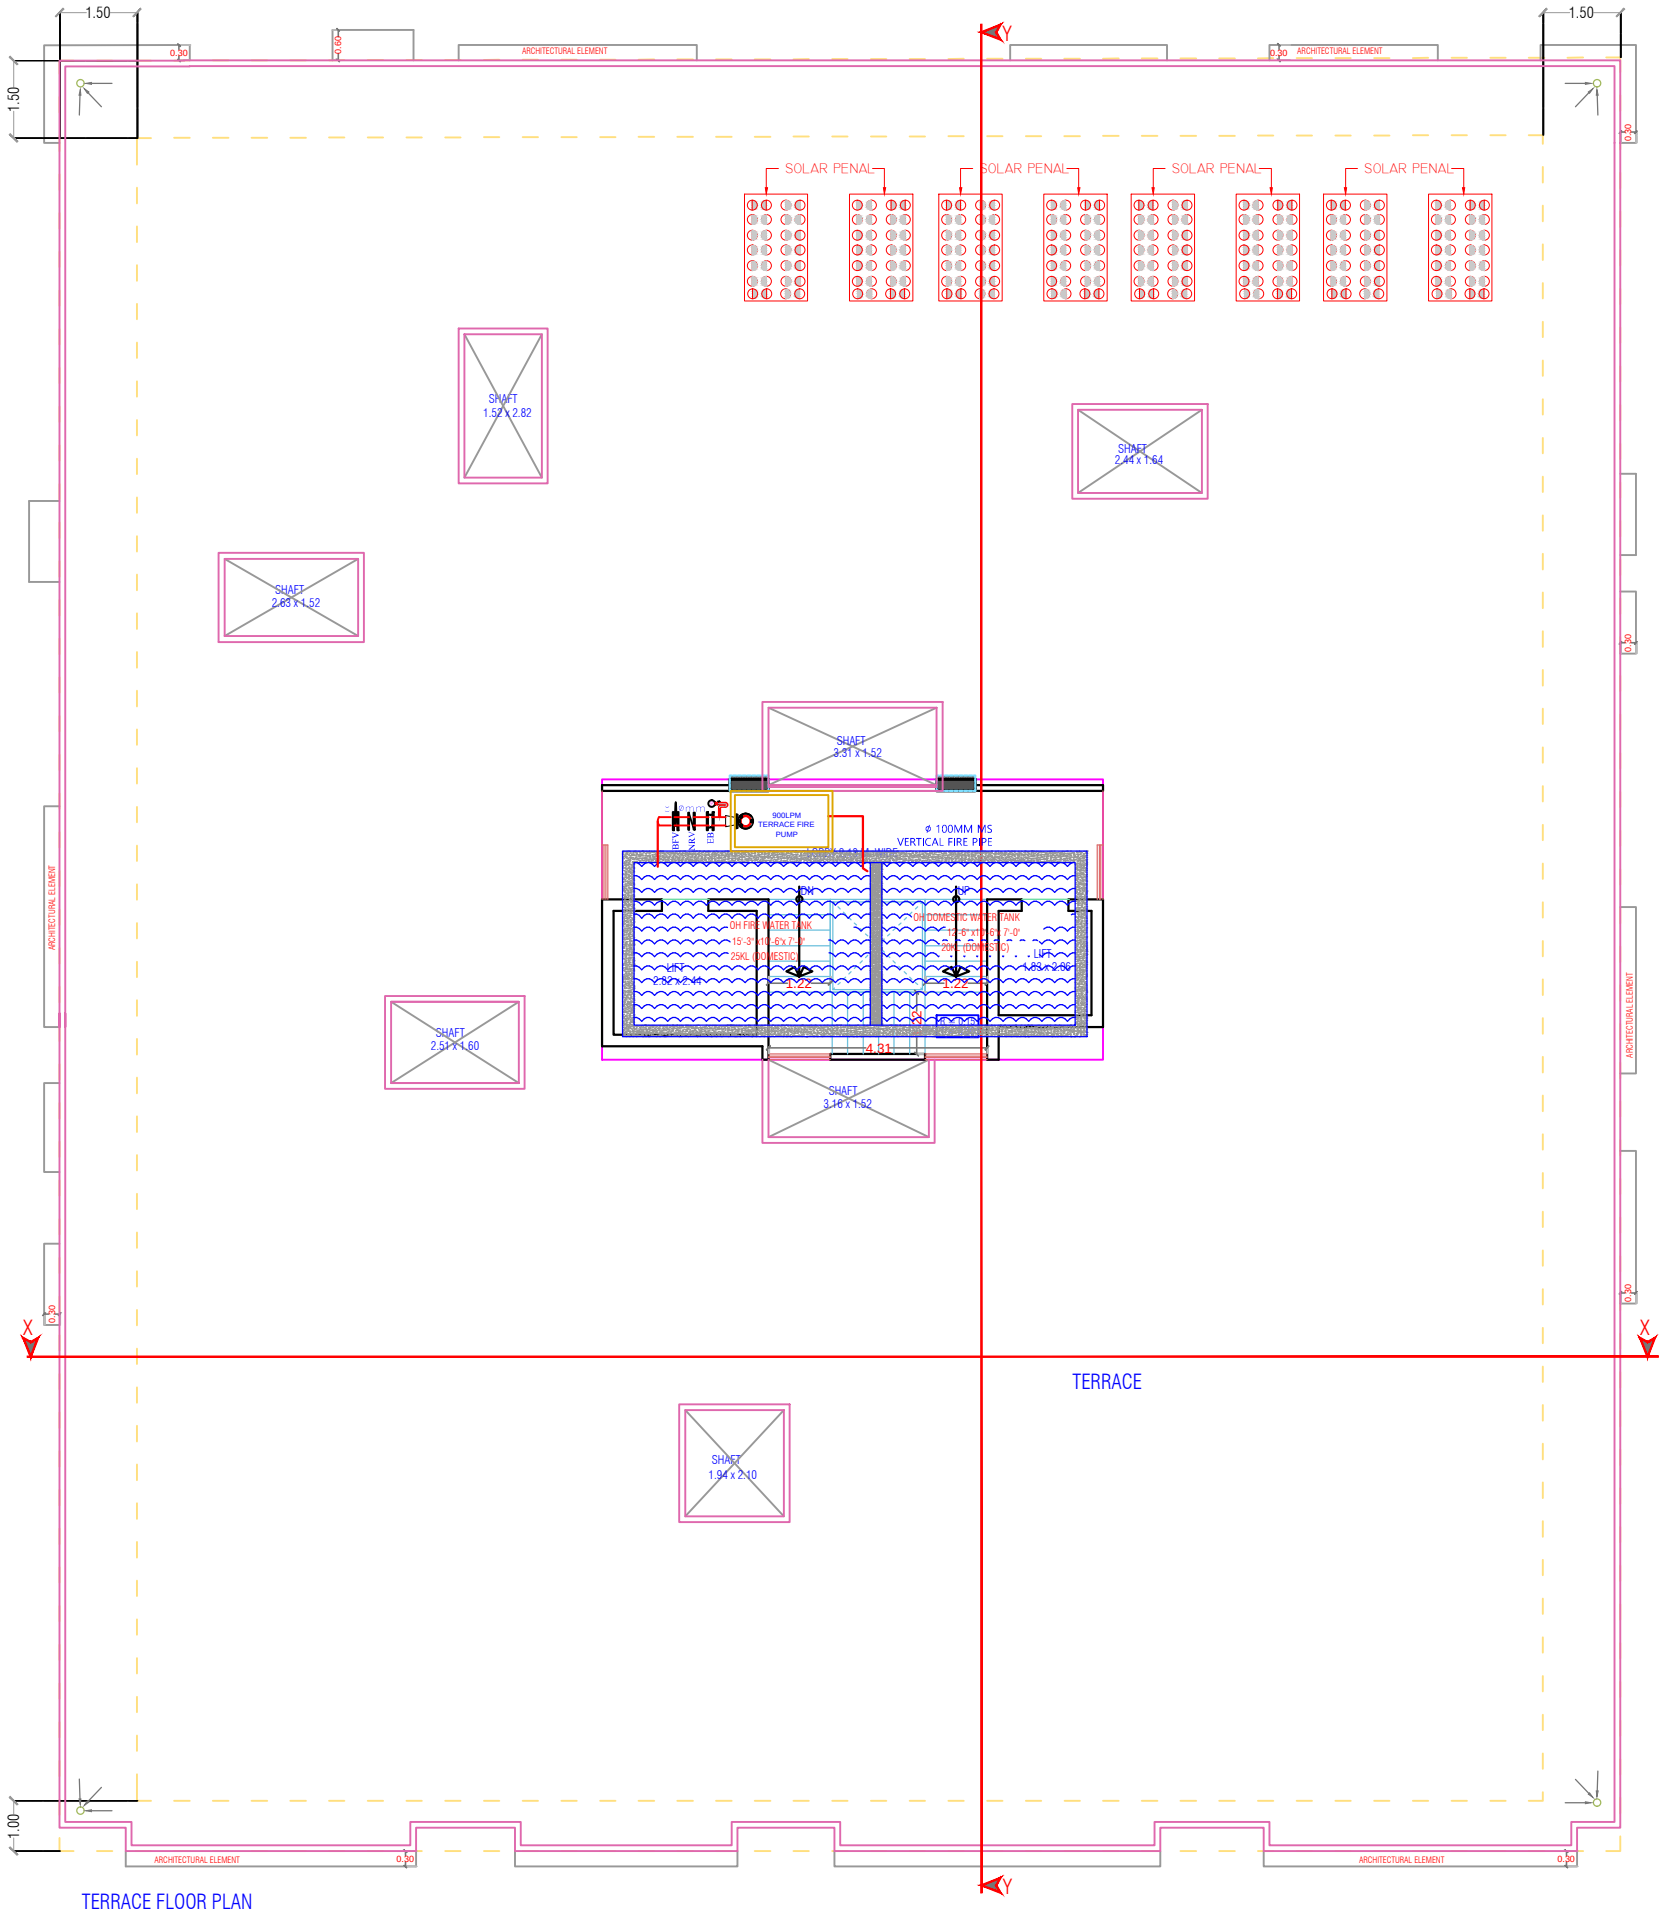


TERRACE FLOOR PLAN

RAMESH KUMAWAT
M.E.P. CONSULTANT
B.E. CIVIL

LEGENDS:			
SR NO.	Symbol	Description	Qty.
1.		HYDRANT	00
2.		HOSE REEL	00
3.		HOSE BOX	01
4.		FOUR WAY	00
5.		FIRE PUMP	01
6.		WATER TANK	01


PROJECT TITLE :- PROPOSED BUILDING AT PLOT NO. 1 & 2 (W.P.), SINGHANIYA GREENS, JAIPUR	DRAWING TITLE :- TARRACE FLOOR FIRE FIGHTING	SPACE CONSULTANT PLOT-A-173, JAGDAMBA NAGAR, HEERAPURA POWER HOWER, JAIPUR (RAJ) 302024	DRN. BY		DATE	NORTH
			APPD. BY		REVISION	
			SCALE			

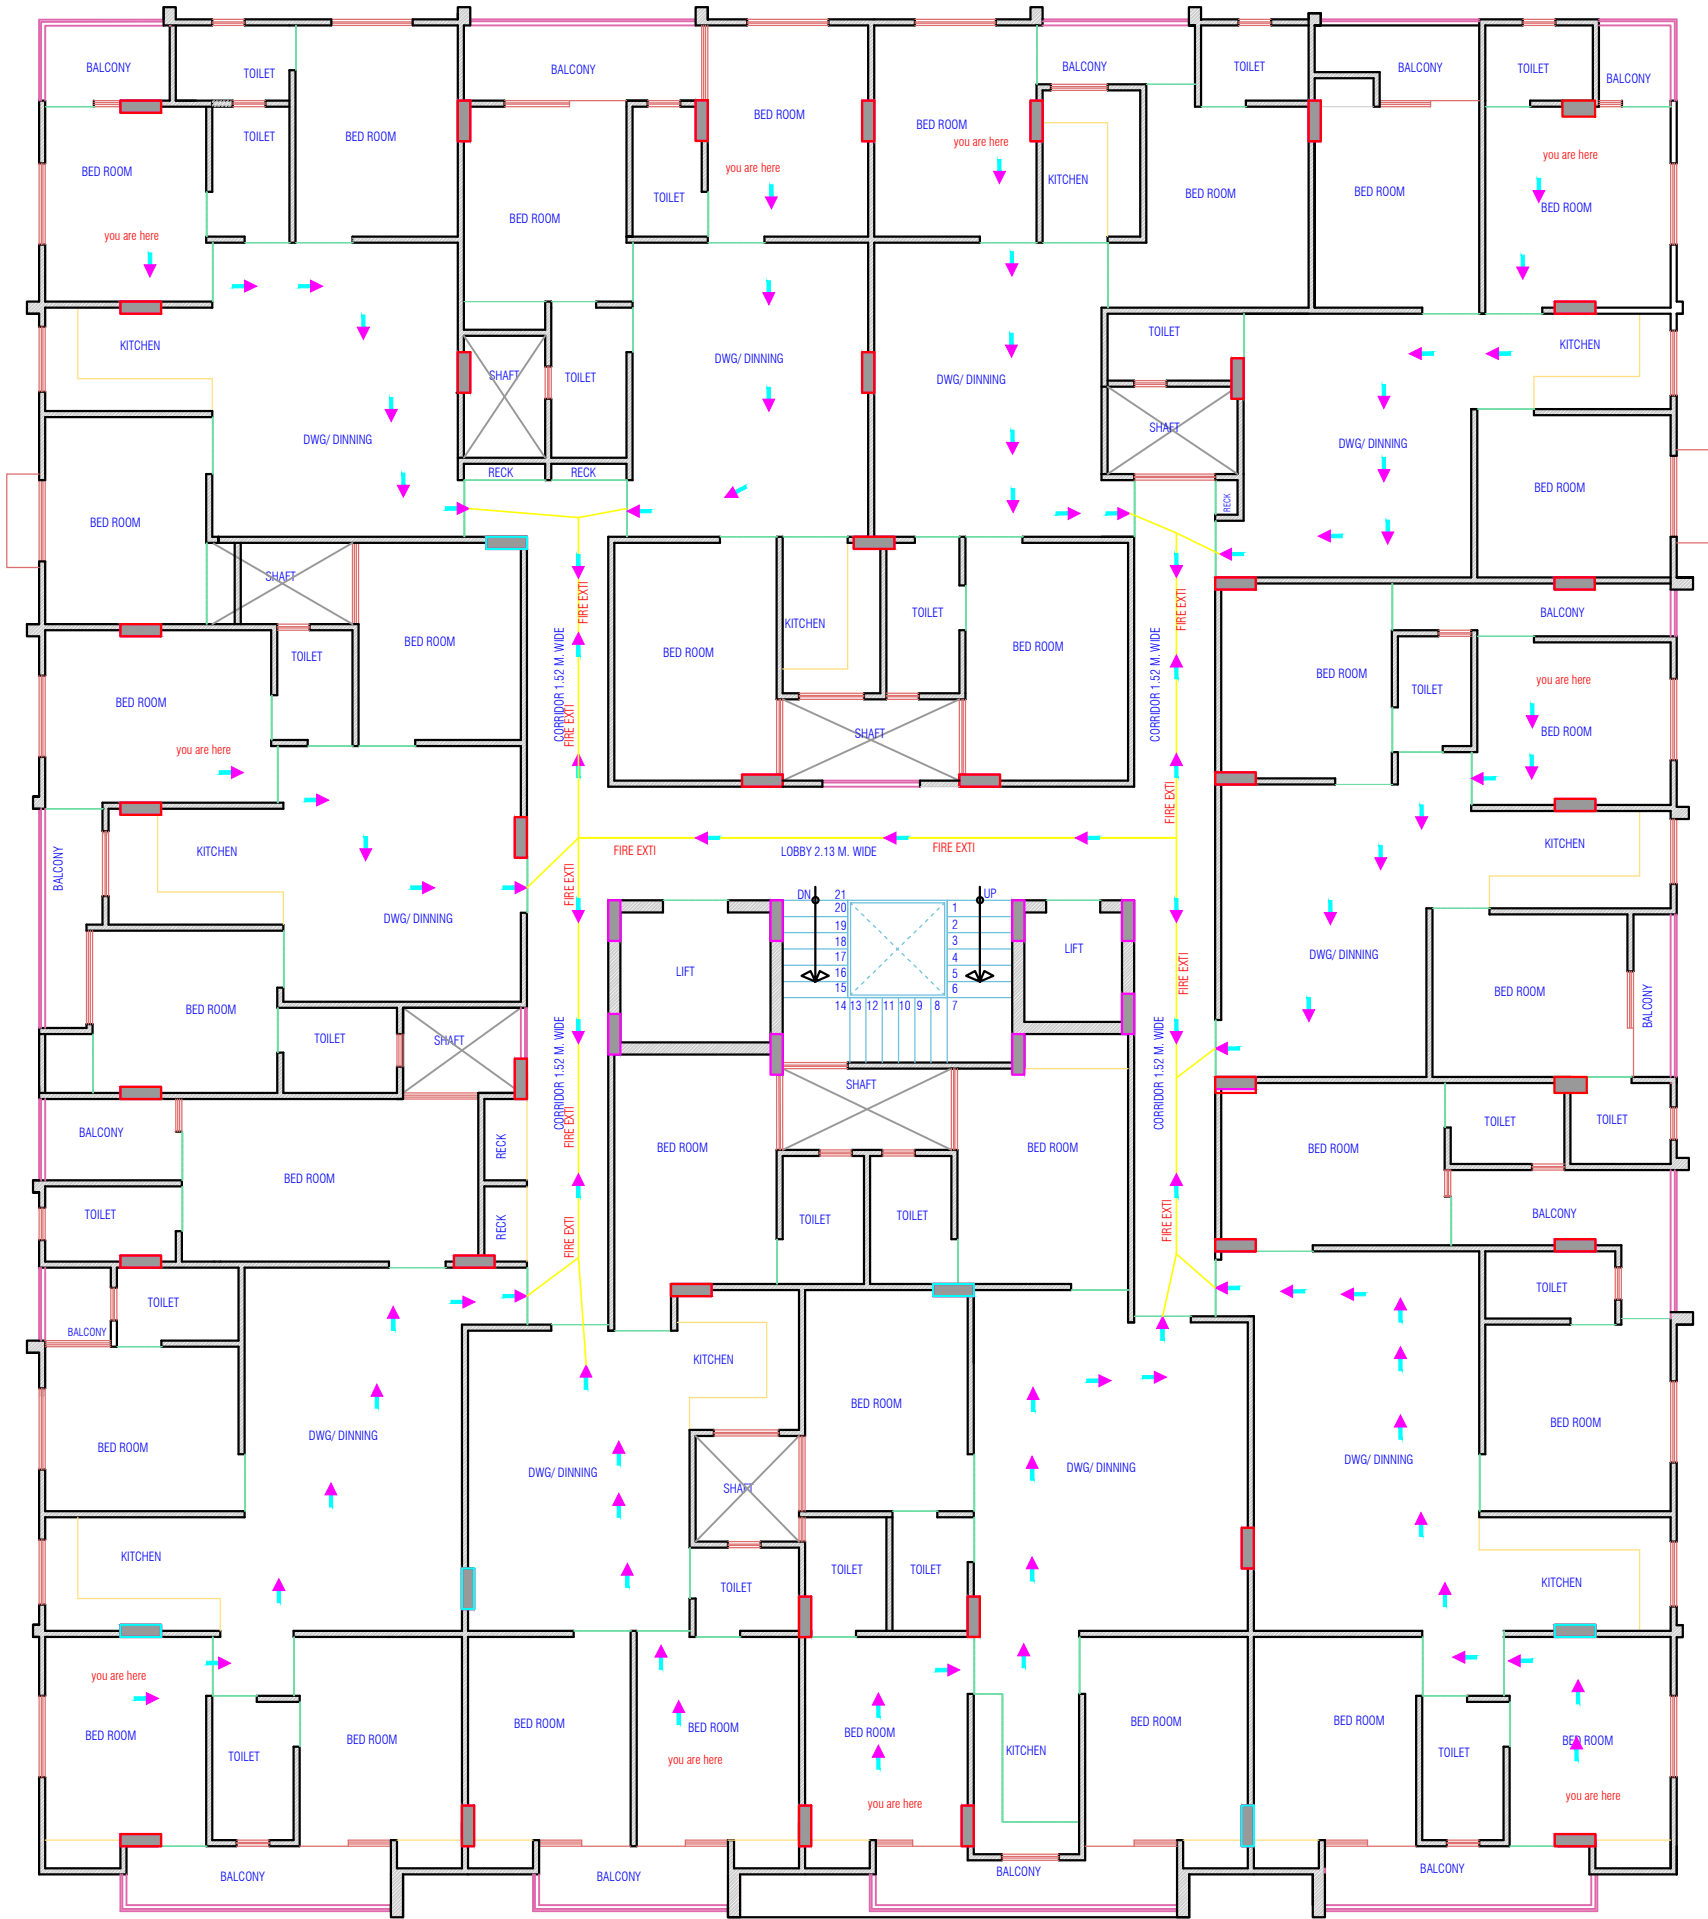

RAMESH KUMAWAT
M.E.P. CONSULTANT
B.E. CIVIL

TYPICAL FLOOR FIRE FIGHTING

PROJECT :- PROPOSED BUILDING AT PLOT NO. 1 & 2 (W.P.), SINGHANIYA GREENS, JAIPUR	SPACE CONSULTANT PLOT-A-173, JAGDAMBA NAGAR, HEERAPURA POWER HOWER, JAIPUR (RAJ) 302024	DRN. BY		DATE	<div>NORTH</div> <div><div>S</div><div>E</div><div>W</div><div>N</div></div>
		APPD. BY		14-03-2024	
		SCALE	N.T.S	REVISION	

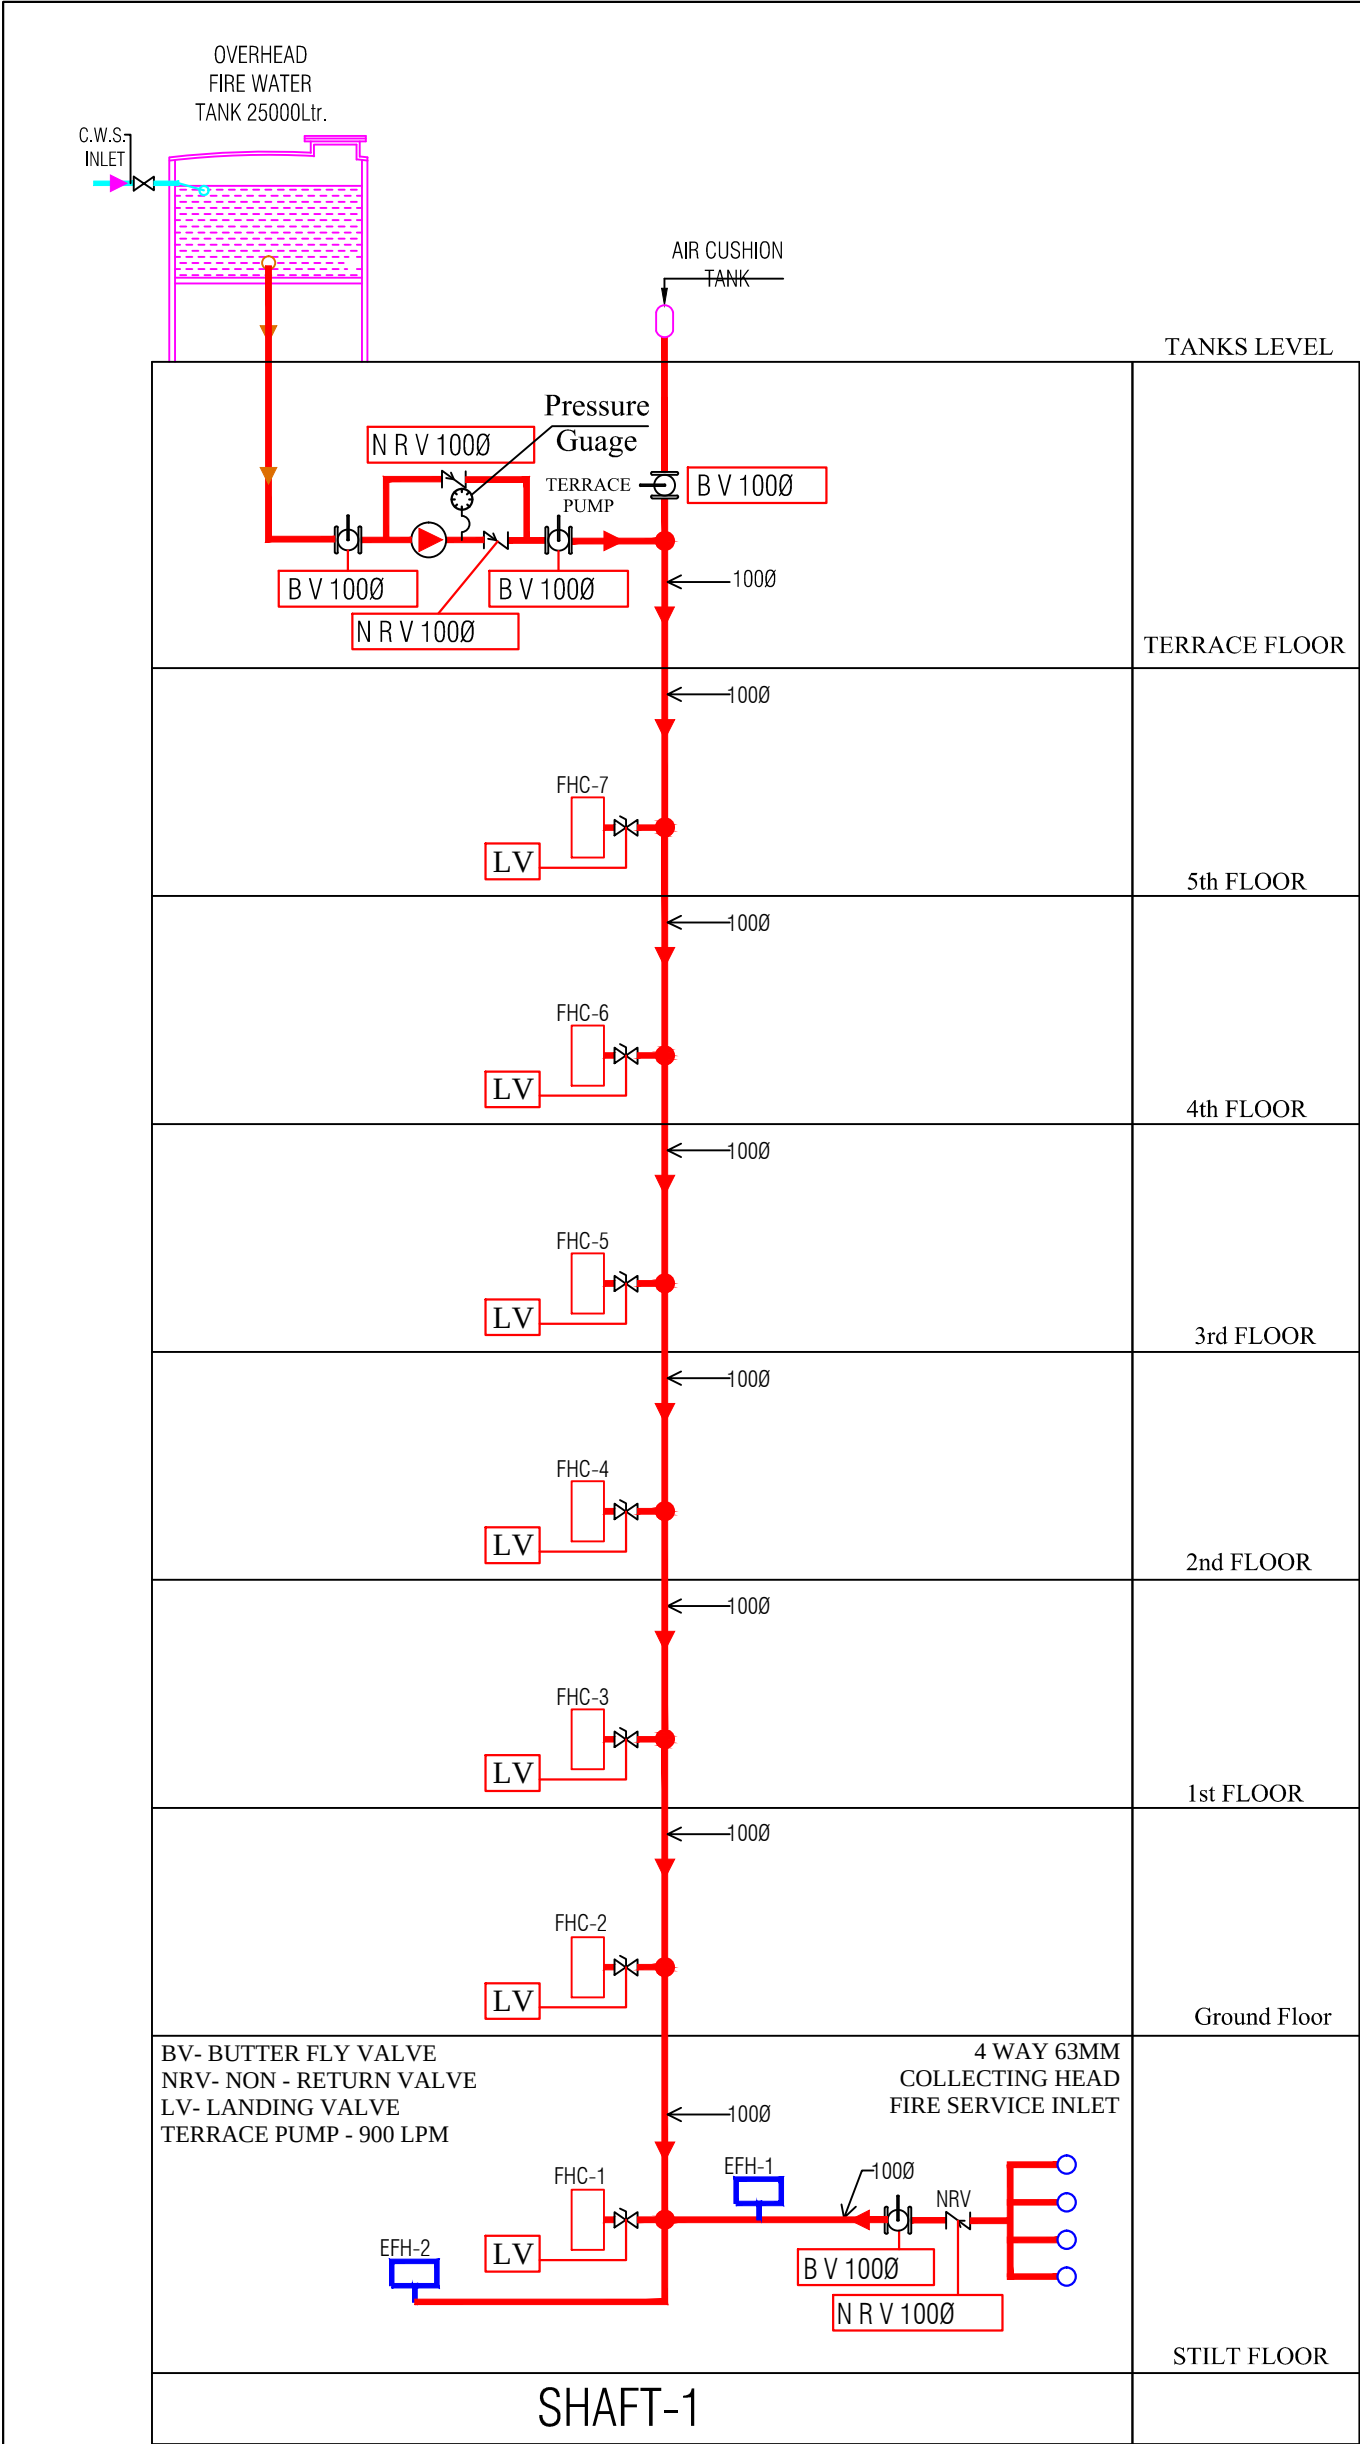

DRAWING:

TYPICAL DETAIL FOR FIRE HOSE CABINET-1

SCALE:-NTS

FIG-01

S.no.	Symbol	Description	Qty.	Size in mm
1.		Butter fly Valve	04	1000
2.		Non Return Valve	03	1000
3.		Landing Valve Single headed	09	630
4.		Pressure Guage	01	
5.		FHC	07	
6.		External Fire Hose Cabinet	02	

SIGN:-SEAL:-

RAMESH KUMAWAT
M.E.P. CONSULTANT
B.E. CIVIL

SPACE CONSULTANT
PLOT-A-173, JAGDAMBA NAGAR, HEERAPURA
POWER HOWER, JAIPUR (RAJ) 302024

PROJECT :-
PROPOSED BUILDING AT PLOT
NO. 1 & 2 (W.P.), SINGHANIYA
GREENS, JAIPUR

DRAWING:-
FIRE SCHEMATIC LAYOUT

