
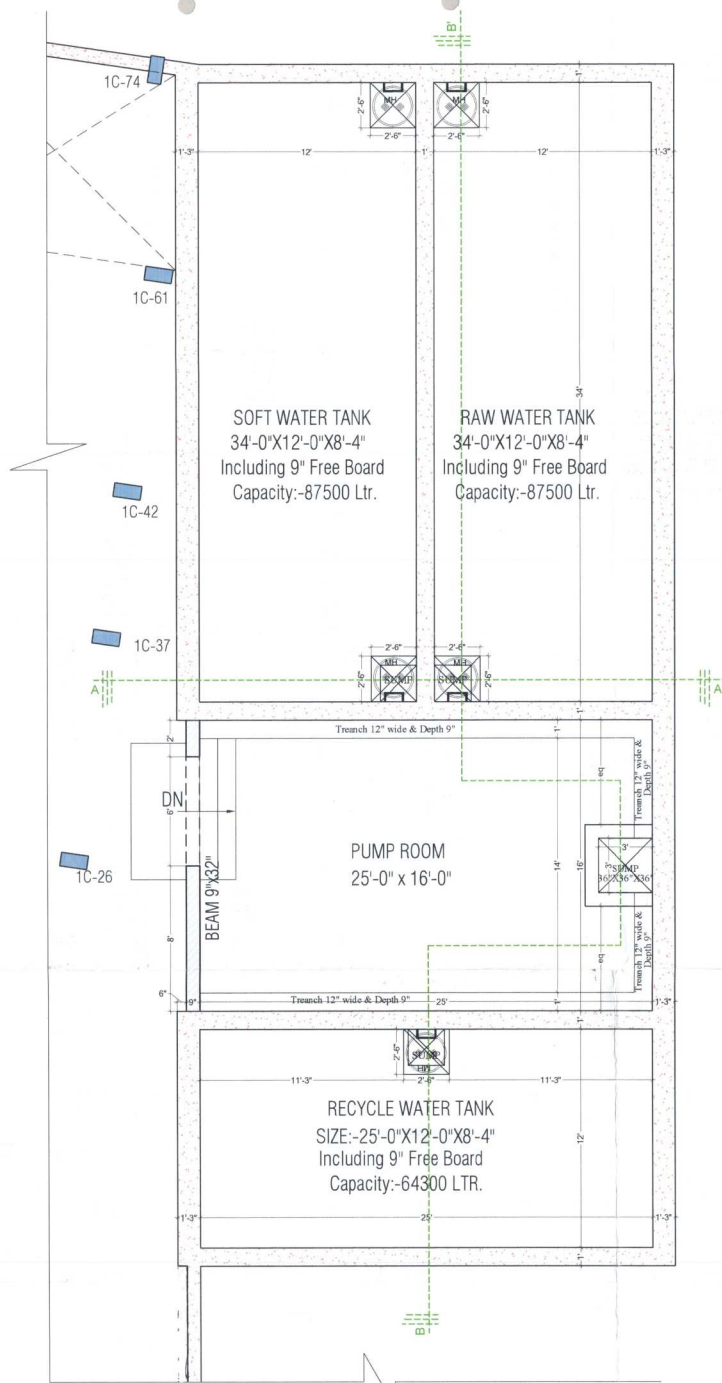
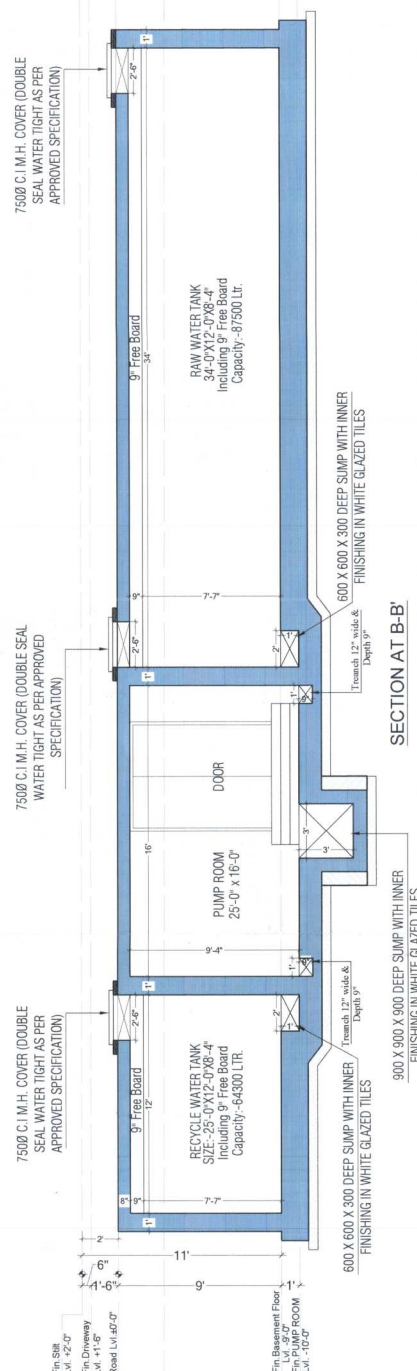


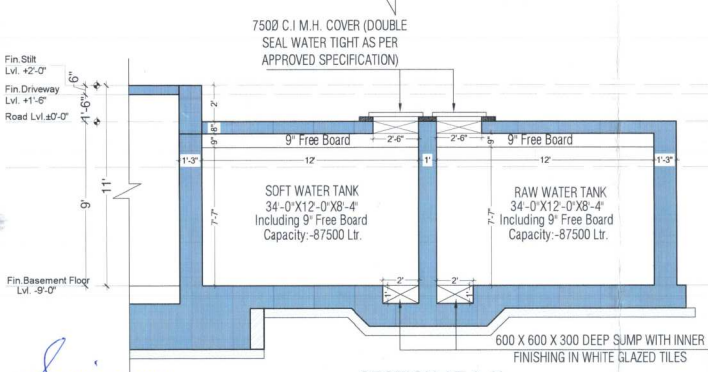




**SANJAY KADAV
B. TECH (CIVIL)**

SECTION AT A-A'

**SANJAY KADAV
B. TECH (CIVIL)**

CHKD. BY: *Prabhu*
Date: *21/05/15*

<p>GENERAL NOTES:</p> <ol style="list-style-type: none"> 1. All dimensions are in feet and inches. 2. All structural dimensions are to be finished unless otherwise indicated. 3. All dimensions are to be as shown. 4. All dimensions are to be as shown. 5. All dimensions are to be as shown. 6. All dimensions are to be as shown. 7. All dimensions are to be as shown. 8. All dimensions are to be as shown. 9. All dimensions are to be as shown. 10. All dimensions are to be as shown. 	<p>BUILDER/DEVELOPER:</p> <p>ARIHANT GROUP Builders & Developers 2nd Floor, "Class Of Pearl" Income Tax Colony, Durgapura, Tonk Road, Jaipur-302018 TEL: +91-141-2970900 email: info@arhantgroupjaipur.com website: www.arhantgroupjaipur.com</p>	<p>Architect:</p> <p>Tushar Sogani Designs Pvt. Ltd architects 'n' designers Studio: 400, F-72, "Suryodaya" Subhash Marg, Bagadaya Bhawan, C-Scheme, Jaipur-302001 Tel: +91-141-4004560, 4004537 email: studio@tsdplarch.com; website: www.tsdplarch.com</p> <p>THIS DRAWING IS THE PROPERTY OF TUSHAR SOGANI DESIGNS PVT. LTD. IT SHALL NOT BE COPIED OR USED WITHOUT THEIR WRITTEN PERMISSION OR MADE OVER TO A THIRD PARTY. THE INFORMATION IS ISSUED ON THE UNDERSTANDING THAT NO PART THEREOF SHALL BE REPRODUCED FOR THE PURPOSE OTHER THAN THE EXPRESSED PURPOSE.</p>	<p>STRUCTURAL CONS.:</p> <p>N.M. Roof Designers Ltd C-41, TARUN MARG, NEAR TILAK LODIYAN, TILAK NAGAR, JAIPUR-302004 TEL: +91-141-4041404, 4031304 (P) email: nmrdpr@yahoo.com</p> <p>SERVICES DONE:</p> <p>VIPUL CONSULTING, F 9 / 354, Chitrakut Scheme Jaipur 311014-93146-1141418, 9141-2440946 vipul8599@yahoo.com</p>	<p>SCALE:</p> <p>PROJECT:</p> <p>PROPOSED RESIDENTIAL APARTMENT "ARIHANT LEGACY" At Village Bhuva Kallan, Jaipur</p> <p>DATE: 19-03-2015</p> <p>NAME OF DRAWING: UNDER GROUND WATER TANKS DETAIL</p> <p>DEAL: PRABHU DAYAL</p> <p>CHKD. BY: ABHISHEK</p> <p>REV.: R.00</p> <p>DRAWING No.: ARIAL-WT-02</p>	<p>WORKING DRAWING</p>
--	---	--	---	--	-------------------------------

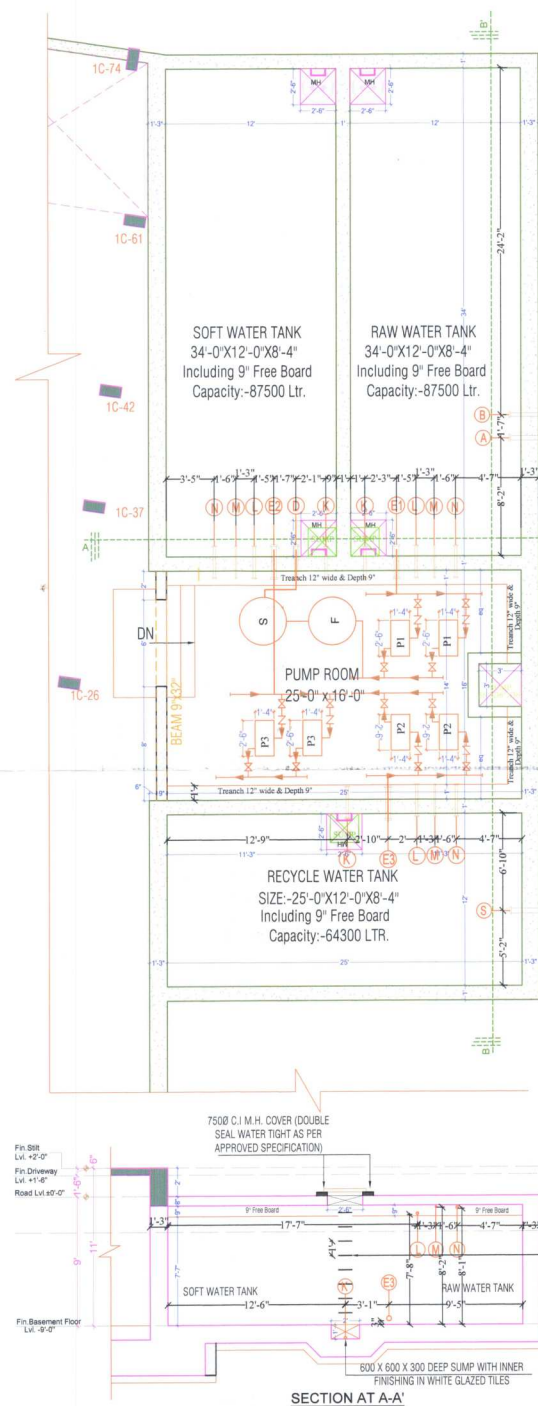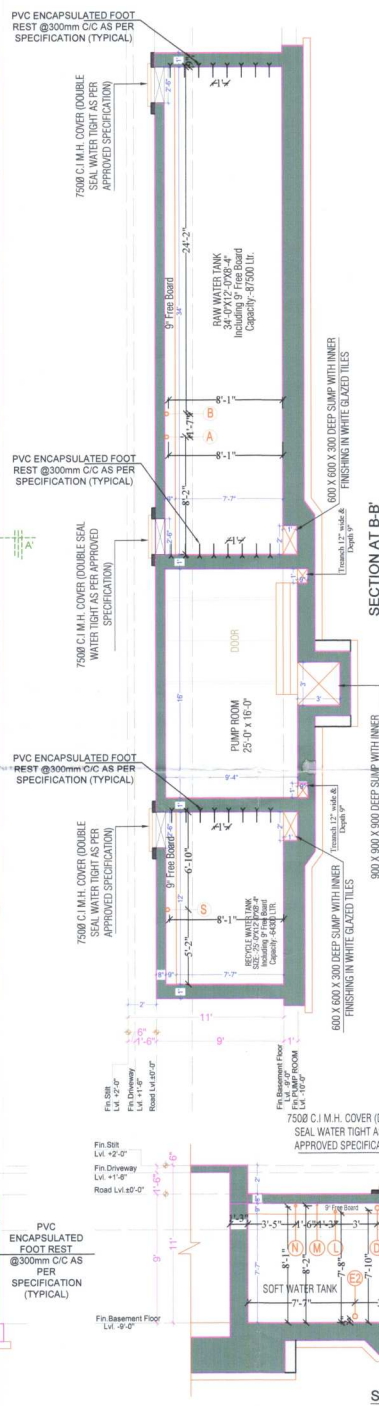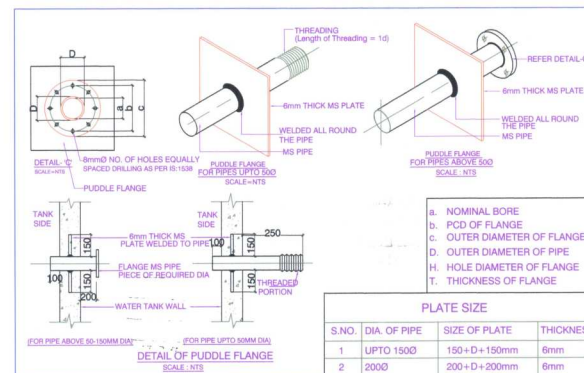

SYMBOL	DESCRIPTION	SIZE	IL. OF PIPES	NO. OF SLEEVES	LENGTH OF PIPE
A	INLET FROM TUBE WELL TO RAW WATER TANK	800	+8'-1"	1	24"
B	MUNICIPAL WATER INLET TO RAW WATER TANK	500	+8'-1"	1	24"
E1	SUCTION PIPE FROM RAW WATER TANK	1000	F.F.L.	1	24"
D	INLET TO TREATED WATER TANK	800	+7'-10"	1	24"
E2	SUCTION PIPE FROM TREATED WATER TANK	1000	F.F.L.	1	24"
K	DRAIN OUT PIPE LVL FROM PIT BOTTOM	500	F.F.L.	3	24" EACH
L	OVER FLOW PIPE	500	+7'-10"	3	24" EACH
M	SLEEVE FOR LEVEL CONTROLLER	250	+8'-2"	3	24" EACH
N	VENT PIPE	500	+8'-1"	3	24" EACH
E3	SUCTION PIPE FROM RECYCLE WATER TANK	1000	F.F.L.	1	24"
S	INLET FROM STP TO RECYCLE WATER TANK	800	+8'-1"	1	24"

A	FILTER FEED PUMP
F	FILTER
S	SOFTNER
P	PUMP
⊗	BUTTER FLY VALVE
⊘	NON RETURN VALVE
⌈	STRAINER

S.No.	DATE	REVISION DESCRIPTION	S.No.	DATE	ISSUED TO
01			01		
02			02		
03			03		
04			04		

GENERAL NOTES:
1. All Dimensions On This Drawing Are In Feet & Inches.
2. Only Vertical Dimensions Are To Be Followed Drawing Should Not Be Scaled Under Any Circumstances.
3. All Measurements Must Be Checked & Verified By The Contractors Prior To Execution Of Work At The Site.
4. This Drawing Is To Be Read In Conjunction With All Relevant Structural, Services & Facility Planning Drawings.
5. Architectural Drawings Are To Be Followed For The Location Of All Structural Members & Masonry Walls For Space & Reinforcement Details Of Structural Members Relevant Structural Drawings Are To Be Followed.
6. Any Discrepancies Between Architectural Structural & Services Drawing Must Be Brought To The Notice Of The Architects Immediately & Prior To Execution At Site.
7. Coordination With Services Such As HVAC, Plumbing & Electrical & The Responsibility Of The Contractors.
8. All Masonry Walls Should Be Aligned With The Columns As Indicated On The Plan.
9. Respective Of The Position As Calculated With The Dimensioning.
10. For Details Refer Relevant Large Scale Detail Drawings As Indicated.

BUILDER/DEVELOPER:-
ARIHANT GROUP
Builders & Developers
2nd Floor, "Class Of Pearl" Income Tax Colony,
Durgapura, Tonk Road, Jaipur-302018
TEL:-91-141-2970900
email : info@arihantgroupjaipur.com
website : www.arihantgroupjaipur.com

Architect:
Tushar Sogani Designs Pvt. Ltd.
architects 'n' designers
Studio: 400, F-72, "Suryodaya" Subhash Marg
Bagadiya Bhawan, C-Scheme, Jaipur-302001
Tel:-91-141-4004560, 4004537
email: studio@tsdplarch.com; website: www.tsdplarch.com
THIS DRAWING IS THE PROPERTY OF Tushar Sogani Designs Pvt. Ltd. IT SHALL NOT BE COPIED OR USED WITHOUT THEIR WRITTEN PERMISSION OR MADE KNOWN TO A THIRD PARTY. THE INFORMATION IS ISSUED ON THE UNDERSTANDING THAT NO PART THERE OF SHALL BE DUPLICATED FOR THE PURPOSE OTHER THAN THE EXPRESSED PURPOSE.

STRUCTURAL CONS.-
VIPUL CONSULTING,
F 9 / 440, Chitrakut Scheme, Jaipur
PH:91-0-93146-10438, 0141-2440946
Mail: vipul8599@yahoo.com
REV. NO. 01 DATE: 21.03.15


SCALE:-
1" = 10'-0"
DATE:-
21-03-2015
DEALT:-
PAWAN
CHD:-
SANJAY
APPD:-
VIPUL AGRAWAL

PROJECT:-
PROPOSED RESIDENTIAL APARTMENT
"ARIHANT LEGACY"
At Village Bilva Kallan, Jaipur
NAME OF DRAWING:-
UNDER GROUND WATER TANKS DETAILS. PLAN
REV:-
R-02
DRAWING No.:-

WORKING DRAWING
NORTH:-
N

SANJAY KADAV
P. TECH (CIVIL)

26-12-19

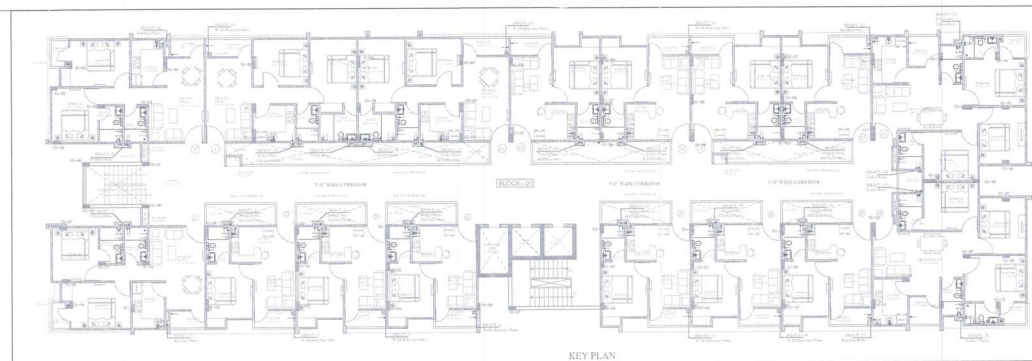

BUILDER/DEVELOPER:-

ARCHITECT:-

Tushar Sogani Designs Pvt. Ltd.
architects n designers
F-72, 105, "SURYODAY", '105', Subhash Marg,
Bagadiya Bhawan, C-Scheme, Jaipur.
TEL: +91-141-4004560, 4004537
email : studio@tedelarch.com website : www.tedelarch.com

STRUCTURAL CONS.:

N.M. Roof Designers Ltd.
C-41, TARUN MARG, NEAR TILAK
UDHYAN, TILAK NAGAR, JAIPUR-302004
TEL: +91-141-4041404, 4031304 (F)
email: nmdesigns@yahoo.com

SERVICES CONS:-

VIPUL CONSULTING
F 9 / 440 ,Chitrakut Scheme,Jaipur
PH:91-0-93146-10438 ,0141-2440946
Mail:vipul8599@yahoo.com

PROJECT: "ARIHANT LEGACY"

ADDRESS:- Khasra No. 644, Village Bitwa Kallan, Tehsil
Sanganer Lan no. 2940606 JAIPUR

DATE:- 09-04-2019

DEALT	03-04-2010
-------	------------

PAWAN

CHD: SANJAY

APPD:-

VIPUL AGARWAL

CWS
DRAWING

NORTH: