


PROJECT
NAME: ROYAL TOWN

PROMOTER
NAME:
Shri Ram Builders Group

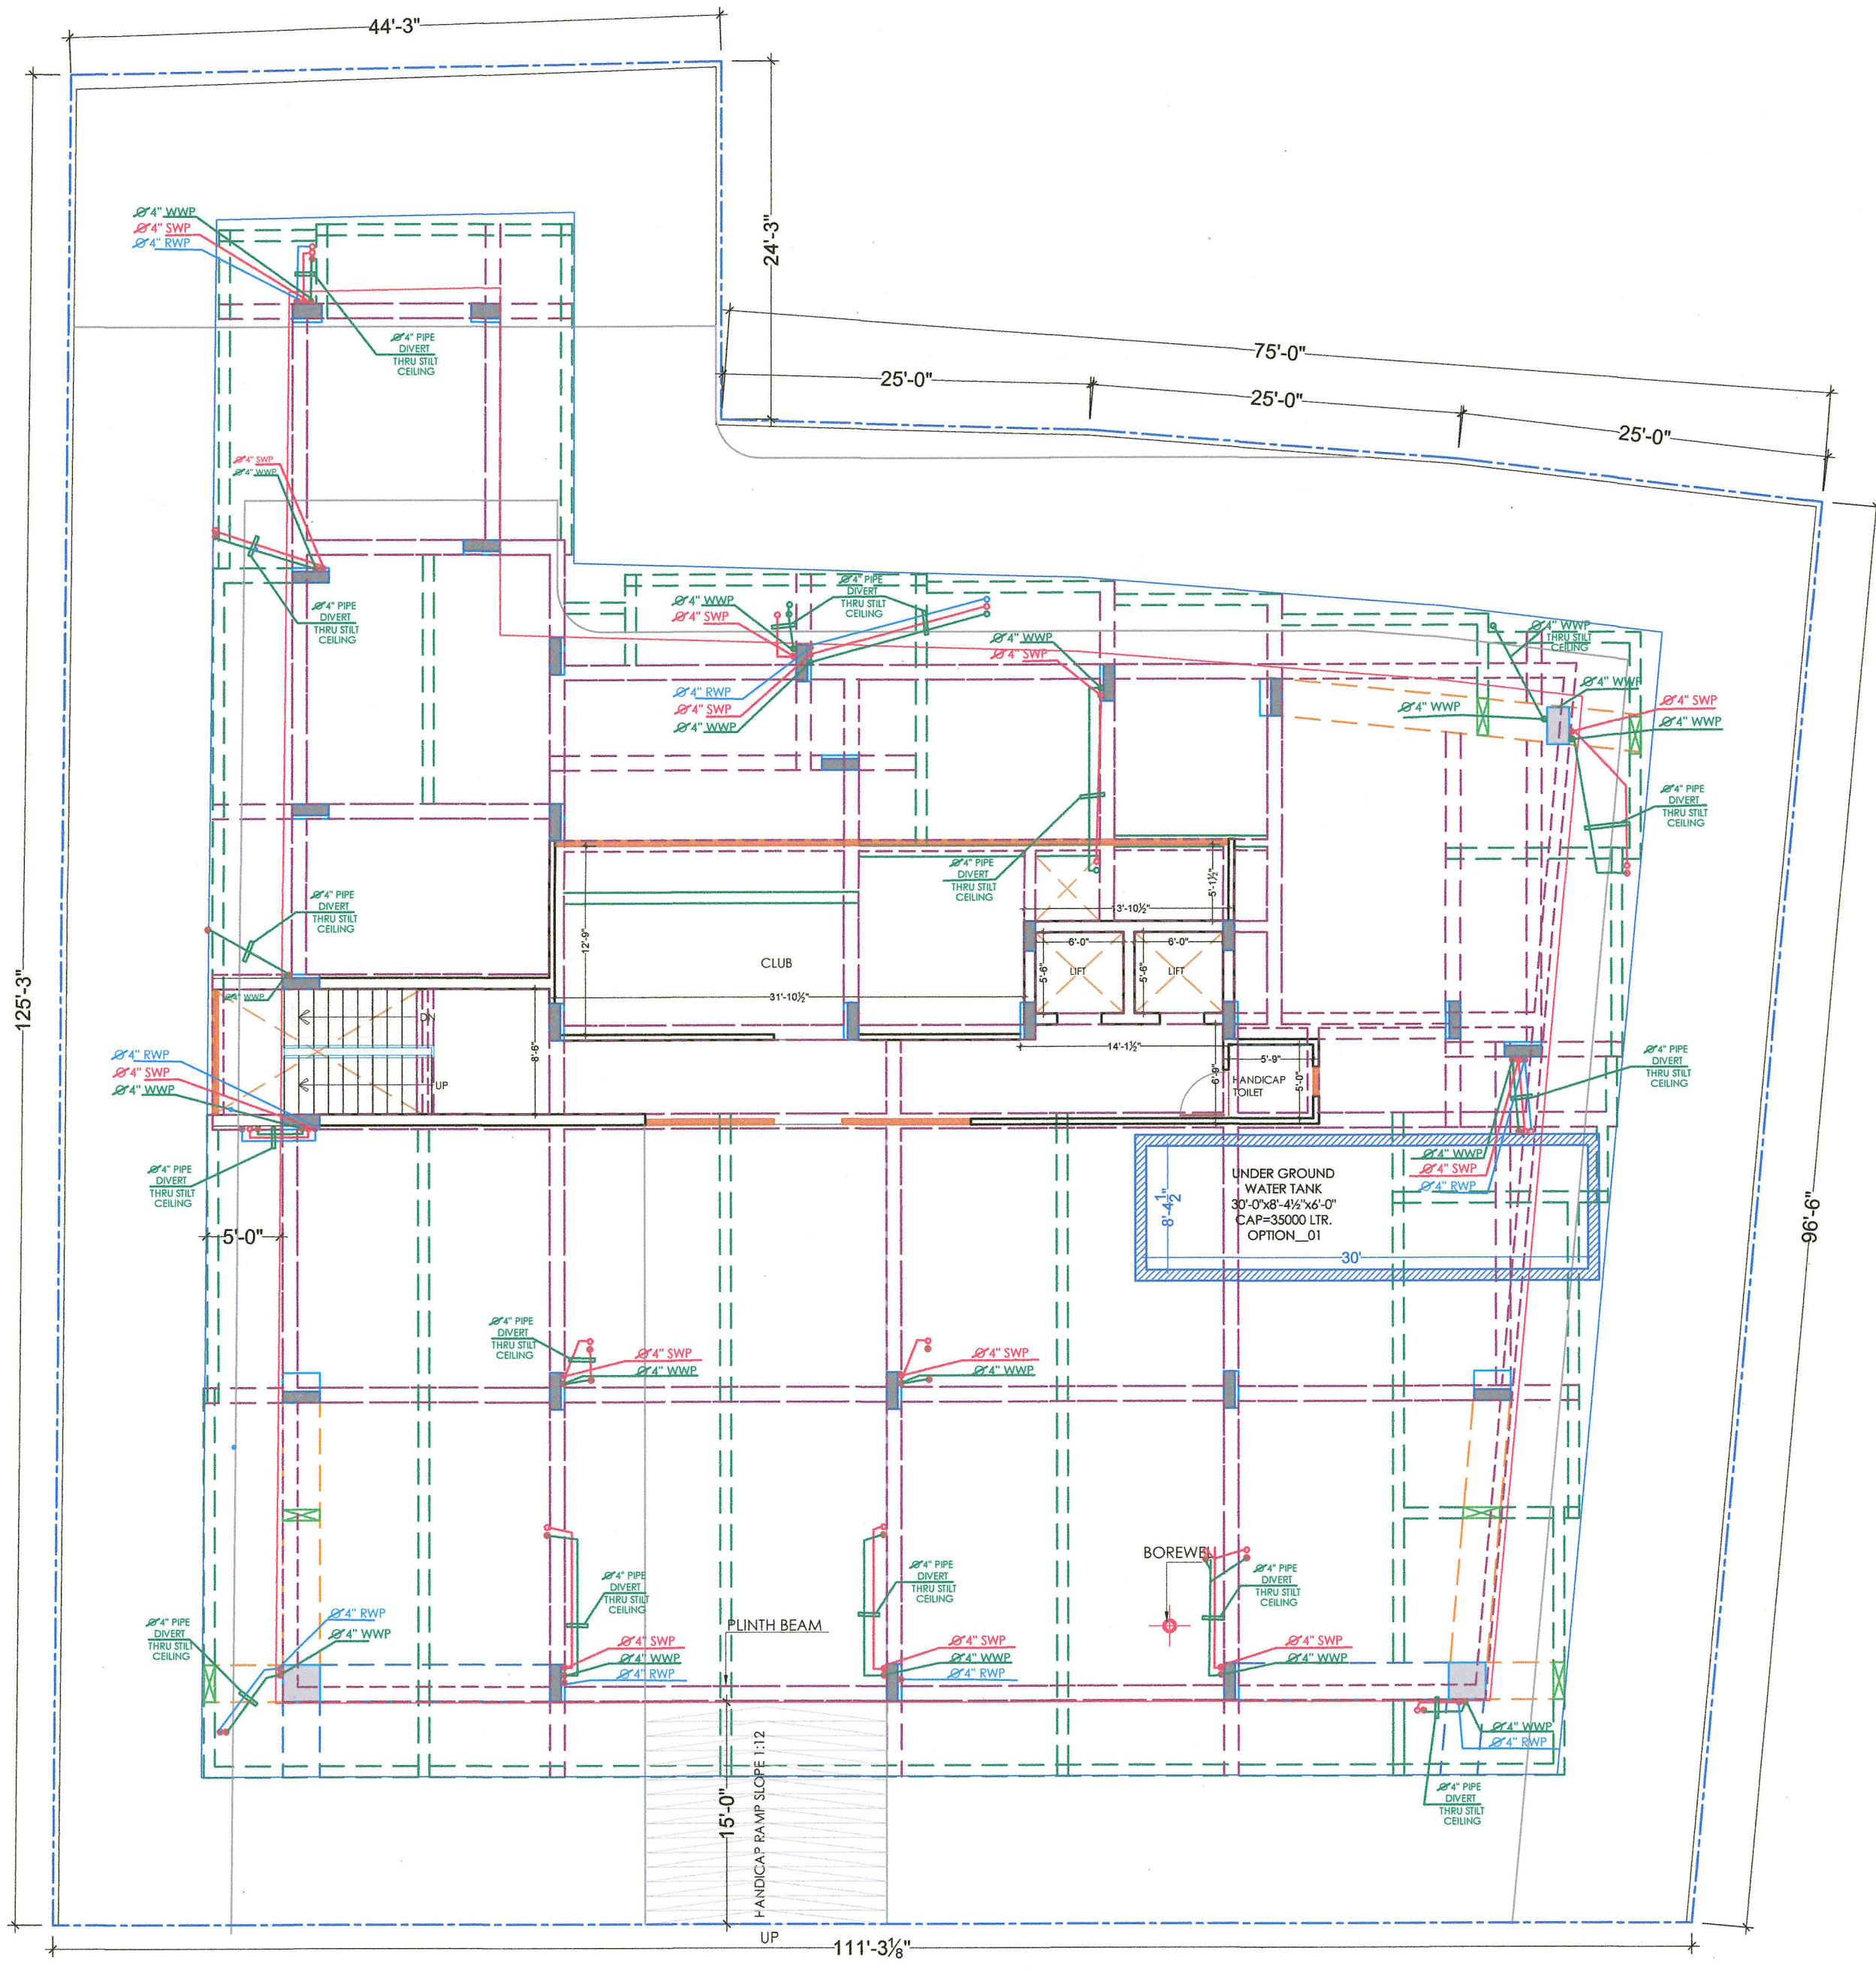

- GENERAL NOTES :
1. All dimension on this drawing are in MKS System Only written dimensions are to be followed. drawing should not be scaled.
 2. All measurements must be checked and verified by the contractors prior to execution of work at the site.
 3. This drawing is to be read in conjunction with all relevant structural, services & facility planning drawings.
 4. Architectural drawings are to be followed for the location of all structural members & masonry walls. for sizes & reinforcement details of structural members, relevant structural drawings are to be referred.
 5. Any discrepancies between architectural, structural and services drawings must be brought to the notice of the architects immediately & prior to execution at site.
 6. Co-ordination with services such as hvac, plumbing & electrical, etc. is the responsibility of the contractor.
 7. All masonry walls should be aligned with the columns as indicated on the plan, irrespective of the position as calculated with the dimensioning.
 8. For details, refer relevant large scale detail dpgs. as indicated.

PROJECT:
**PROPOSED RESIDENTIAL
FLATS ON PLOT NO.- 6,16,17,18
SCHEME - RAGHUNATH VIHAR**

NAME OF DRAWING:
**STILT FLOOR CEILING
DRAINAGE LAYOUT PLAN**

DRAWN BY:
Banwari Lal

APPROVED BY:
JITENDRA SHARMA

DRAWING
WORKING DRAWING

NORTH:

PROJECT NO. :
NTS

DATE :
15-02-2023

SCALE :
NTS

REV NO. :
R-0

DRAWING NO. :
A-02

PROJECT CATEGORY BLOCK FLOOR TYPE NUMBER

← 40'-0" WIDE ROAD →

SHRI RAM BUILDERS GROUP
Partner

Sharma
Er. SANJEY SHARMA
B.E (Electrical)

STILT FLOOR CEILING DRAINAGE LAYOUT PLAN