



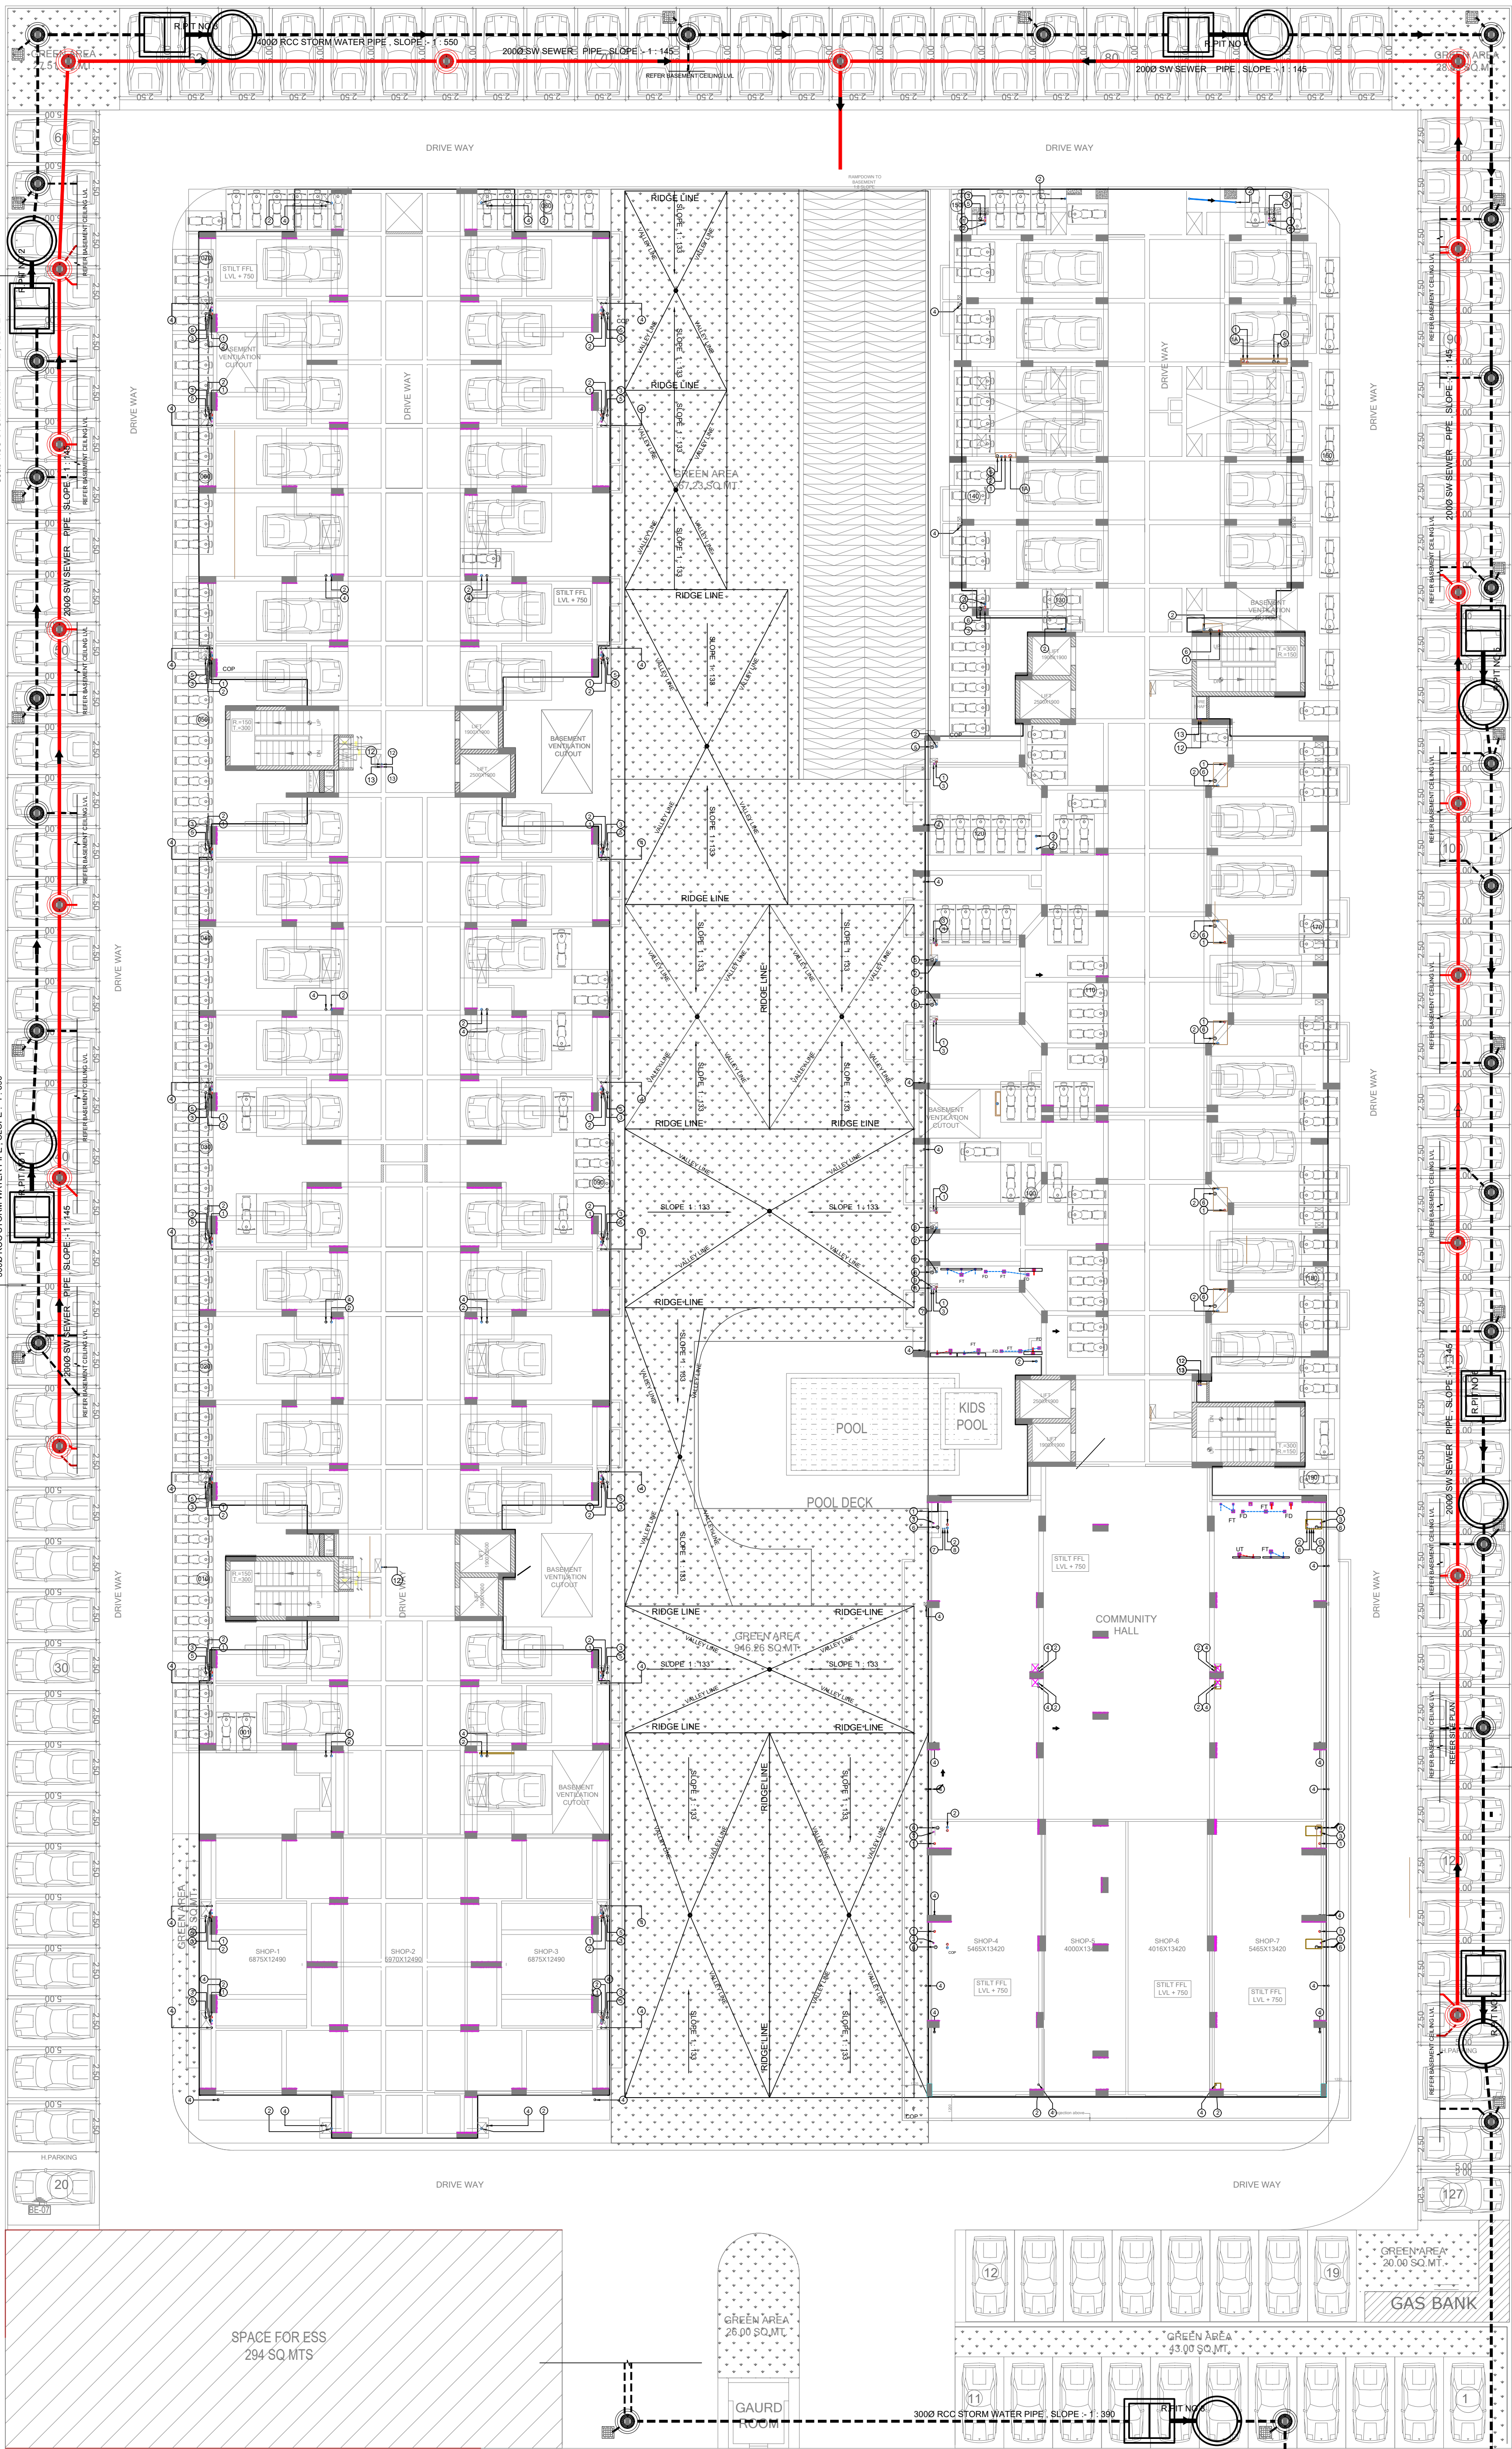

PLUMBING LEGEND	
①	110 OD uPVC (SWR) SOIL & VENT PIPE
①A	160 OD uPVC (SWR) SOIL & VENT PIPE
②	110 OD uPVC (SWR) WASTE & VENT PIPE
③	90 OD uPVC ANTISIPHONAGE
④	90 OD uPVC RAIN WATER PIPE
⑤	110 OD uPVC RAIN WATER PIPE
⑥	160 OD uPVC RAIN WATER PIPE
⑦	DOMESTIC WATER SUPPLY DOWN TAKE
⑧	DOMESTIC WATER SUPPLY DOWN TAKE FOR UPPER TWO FLOOR
⑨	FLUSHING WATER SUPPLY DOWN TAKE
⑩	HOT WATER SUPPLY DOWN TAKE
⑪	HOT WATER SUPPLY DOWN TAKE FOR UPPER TWO FLOOR
⑫	DOMESTIC WATER SUPPLY RISER
⑬	FLUSHING WATER SUPPLY RISER
H	BALL / BUTTER FLY VALVE
FT	FLOOR TRAP (110 x 110 MM)
FD	FLOOR DRAIN (110 x 63 MM)
---	DOMESTIC WATER SUPPLY LINE
---	FLUSHING WATER SUPPLY LINE
---	HOT WATER SUPPLY LINE
R.P.T	RECHARGE PIT
SIZE	7.0 x 1.7 M

- NOTES :-
- ALL SOIL WASTE & VENT PIPES SHALL BE SWR TYPE - B AS PER IS 13592 PIPES WITH RUBBER RING JOINTS ON VERTICAL & SOLVENT CEMENT ON HORIZONTAL.
 - ALL RAIN WATER PIPES SHALL BE SWR TYPE - A AS PER IS 13592 PIPES WITH RUBBER RING JOINTS.
 - SOIL, WASTE & RAIN WATER PIPES > 160 OD SHALL BE uPVC CLASS III (6 KG / SQ.M) AS PER IS 4985 WITH SOLVENT CEMENT.
 - WATER SUPPLY PIPES WITH IN TOILETS (HOT & COLD WATER) SHALL BE uPVC GRADE CTS SDR - 11
 - WATER SUPPLY PIPES IN SHAFTS ON TERRACE EXPOSED LOCATION SHALL BE GI.
 - WATER SUPPLY PIPES FROM SOLAR SYSTEM TO TOILETS PIPE SHALL BE uPVC GRADE CTS SDR - 11
 - PIPE FROM FD TO FT = 63 OD uPVC WASTE PIPE
 - PIPE FROM WC TO VERTICAL STACK = 110 OD SWR SOIL PIPE
 - PIPE FROM FT TO VERTICAL STACK = 110 OD SWR WASTE PIPE
 - THE MOUNTING HEIGHT OF DIFFERENT APPLIANCES / TAPS SHALL BE AS UNDER :-
 - WALL MIXTURE (FOR BATHING) 900 M.M.
 - SHOWER 2000 M.M.
 - ANGLE VALVE FOR HEALTH SPRAY(FOR WC) 450 M.M.
 - ANGLE VALVE (FOR WASH BASIN) 450 M.M.
 - WASH BASIN (TOP OF RIM) 780MM OR AS/ARCH.
 - KITCHEN SINK MIXER TABLE MOUNTED 800 M.M
 - KITCHEN SINK MIXER WALL MOUNTED 150mm FROM SINK TOP
 - ANGLE VALVE (FOR GEYSER) 1500 M.M / OR AS SPECIFIED
 - ANGLE VALVE (FOR WASHING MACHINE) 750 M.M.
 - ANGLE VALVE (FOR WATER PURIFIER) 950 M.M.

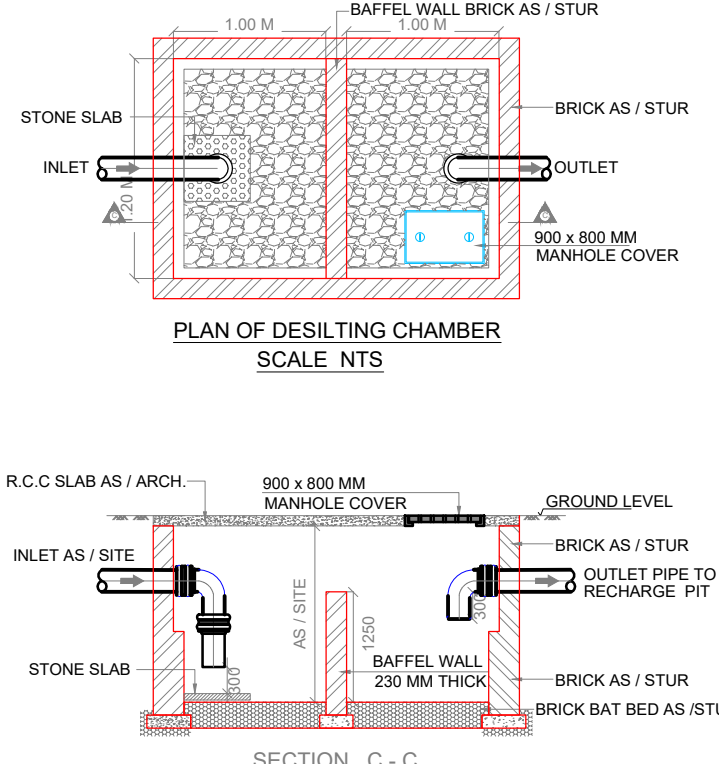

ABHA GUPTA B Tech Civil				
DATE	NO.	ISSUED TO	FOR	REVISION
08.06.18	4	CLIENT	CONSTRUCTION	R0
29.08.18		KUSHWAHA JI	CONSTRUCTION	R1
07.10.24		KUSHWAHA JI	CONSTRUCTION	R1
CLIENT				
29.08.18		REVISED FHC LV & ELECTRICAL SHAFT		R1
PLUMBING CONSULTANT				
SONI CONSULTANTS Plumbing & Fire Suppression Consultants B-2A/139, Janak Puri, New Delhi - 110058 PH - 011 - 25503781, 41403781 e-mail : info@soniconsultants.in Website : www.soniconsultants.in				

ELECTRICAL CONSULTANT	
SS CONSULTANT D-69 CHATTERPUJ ENCLAVE NEW DELHI-110074 Tel.-011-26302571 E-mail.-ssconsultant2006@gmail.com	

OWNER :
DIVINITY BUILD ESTATE Pvt. Ltd.

PROJECT
ARG ANANTA-II WESTWAY HEIGHTS
PROPOSED GROUP HOUSING
AT PLOT NO-G-18 WEST WAY
HEIGHTS (TRUCK TERMINAL
SCHEME BHANKROTA)
SCHEME, JAIPUR

TITLE:-
Rain Water Harvesting Drawing

ELECTRICAL CONSULTANT	PLUMBING CONSULTANT
SS CONSULTANT D-69 CHATTERPUJ ENCLAVE NEW DELHI-110074 Tel.-011-26302571 E-mail.-ssconsultant2006@gmail.com	SONI CONSULTANTS Plumbing & Fire Suppression Consultants B-2A/139, Janak Puri, New Delhi - 110058 PH - 011 - 25503781, 41403781 e-mail : info@soniconsultants.in Website : www.soniconsultants.in

ARCHITECTS
GIAN P. MATHUR AND ASSOCIATES (P) LTD.
C - 55, East Of Kailash, New Delhi-110065
T:- 46595599 / 46595512
E:- info@gpmindia.com / W:- www.gpmindia.com

SCALE : 1 : 125 @A1	DWG. NO.	REV. NO.
DATE : 20.05.2025	ARG-ANT-II-	
DEALT : NITIN	SITE -PL-ST-01	
CHK : P.SONI		



ABHA GUPTA
B Tech Civil

PLUMBING CONSULTANT

 **SONI CONSULTANTS**
Plumbing & Fire Suppression Consultants

B-2A/139, Janak Puri, New Delhi - 110058
PH - 011 - 25503781, 41403781
e-mail : info@soniconsultants.in
Website : www.soniconsultants.in

 **SS CONSULTANT**
D-69 CHATTERPUR ENCLAVE
NEW DELHI-110074
Tel.-011-26302571
E-mail.-ssconsultant2006@gmail.com

PROJECT
ARG ANANTA-II WESTWAY HEIGHTS
PROPOSED GROUP HOUSING
AT PLOT NO-G-18 WEST WAY
HEIGHTS (TRUCK TERMINAL
SCHEME , BHANKROTA)
SCHEME, JAIPUR

TITLE;;-
RAIN WATER HARVESTING DETAIL

ARCHITECTS	
 ARCHITECTS & PLANNERS	GIAN P. MATHUR AND ASSOCIATES (P) LTD. C - 55, East Of Kailash, New Delhi-110065 T : 46599599 F 46599512 E : info@gpindia.com W : www.gpindia.com

SCALE : 1 : 125 @A1	DWG. NO.	REV. NO.
DATE : 20.05.2025	ARG-ANT-II- SITE -PL-ST-RWP-01	
DEALT : NITIN		
CHK : P.SONI		