
 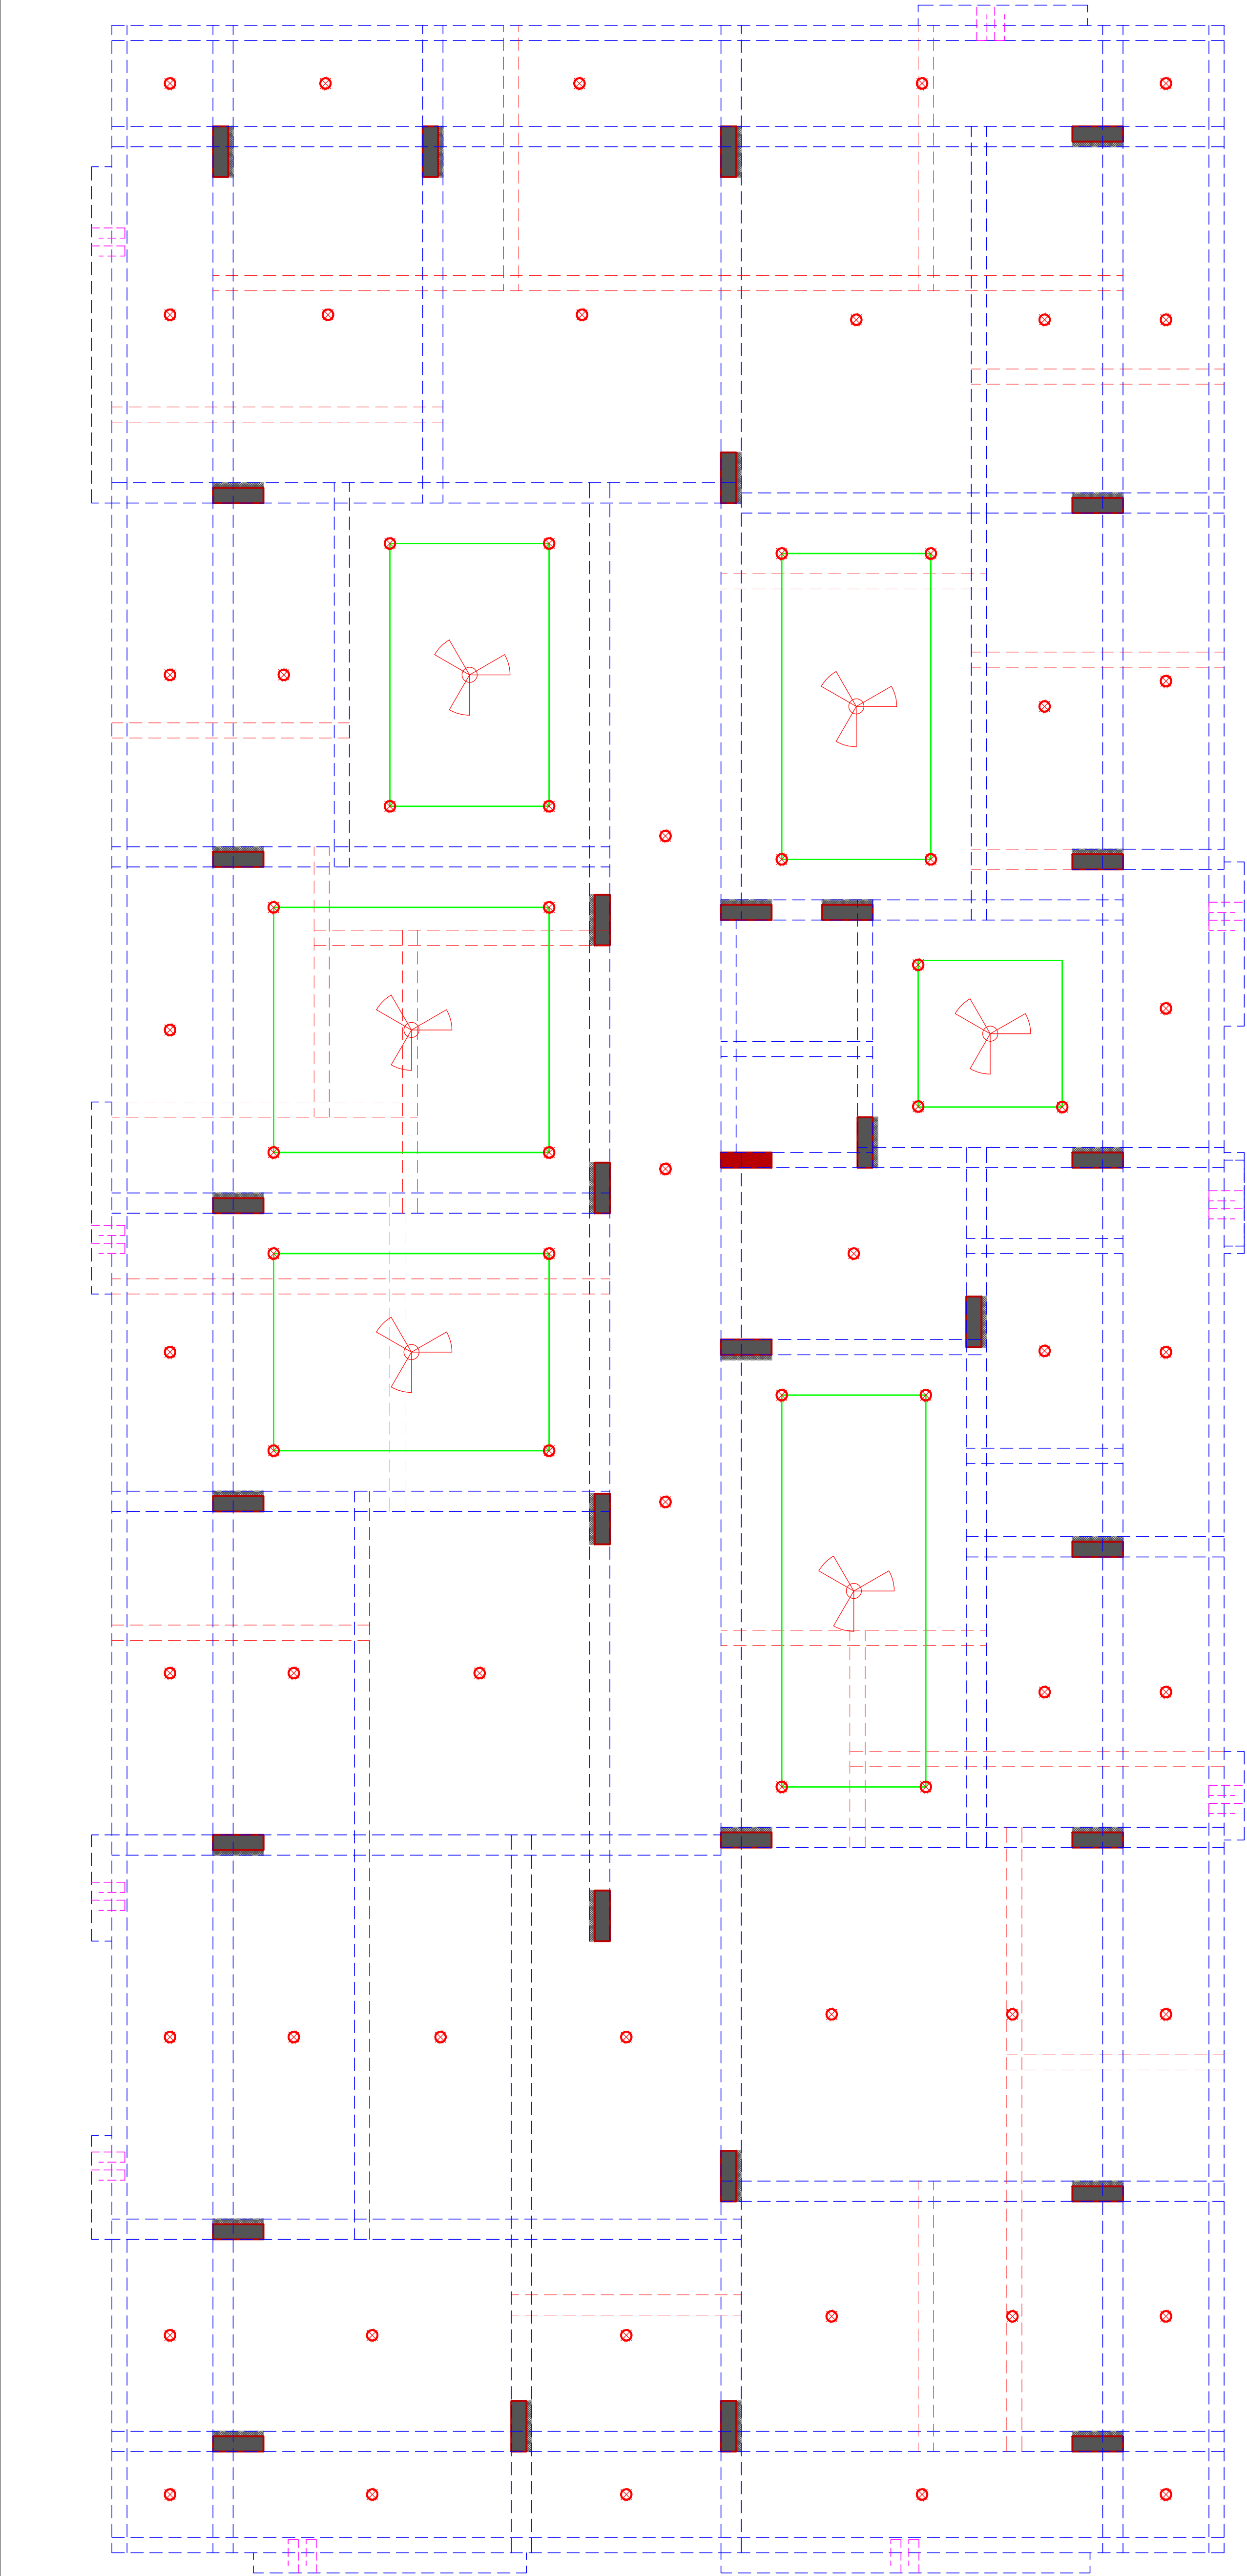




NO	ITEM	SYMBOL
1	CEILING FAN	ROOF
2	TUBE LIGHT	+8'6"
3	BULB	+8'6"
4	POWER POINT	+1'6"
5	BED POINT	+4'3"
6	CEILING LIGHT	ROOF
7	A.C. POINT	+6'6"
8	SWITCH BOARD	+4'3"
9	EXHAUST	VENT
10	TELEPHONE	+1'6"
11	GYSER	+6'0"
12	BELL POINT	+8'6"
13	T.V.	+1'6"
14	M.BOX	+6'6"
15	M.C.B.	+6'6"
16	FANCY LIGHT	+8'6"
17	HANGING LIGHT	ROOF


RAMESH KUMAWAT
M.E.P. CONSULTANT
B.E. CIVIL

STILT FLOOR LIGHT PLAN

PROJECT TITLE :- PROPOSED BUILDING AT PLOT NO.C-14, C-15 & C-16, SHRI RAM VIHAR, JAIPUR	SPACE CONSULTANT PLOT-A-173, JAGDAMBA NAGAR, HEERAPURA POWER HOWER, JAIPUR (RAJ) 302024	DRN. BY		DATE	NORTH
		APPD. BY		REVISION	
		SCALE	N.T.S		




TERRACE FLOOR PLAN

RAMESH KUMAWAT
M.E.P. CONSULTANT
B.E. CIVIL

LEGEND	
Symbole	DESCRIPTION
1.	HOSEREEL
2.	FIRE PIPE
3.	FIRE PIPE
4.	FIRE EXTINGUISHER
5.	EXTERNAL YARD HYDRANT

PROJECT TITLE :-	PROPOSED BUILDING AT PLOT NO.C-14, C-15 & C-16, SHRI RAM VIHAR, JAIPUR	DRAWING TITLE :- TARRACE FLOOR LIGHTING ARRESTER LOCATION	SPACE CONSULTANT PLOT-A-173, JAGDAMBA NAGAR, HEERAPURA POWER HOWER, JAIPUR (RAJ) 302024	DRN. BY		DATE	NORTH
				APPD. BY		REVISION	
				SCALE			

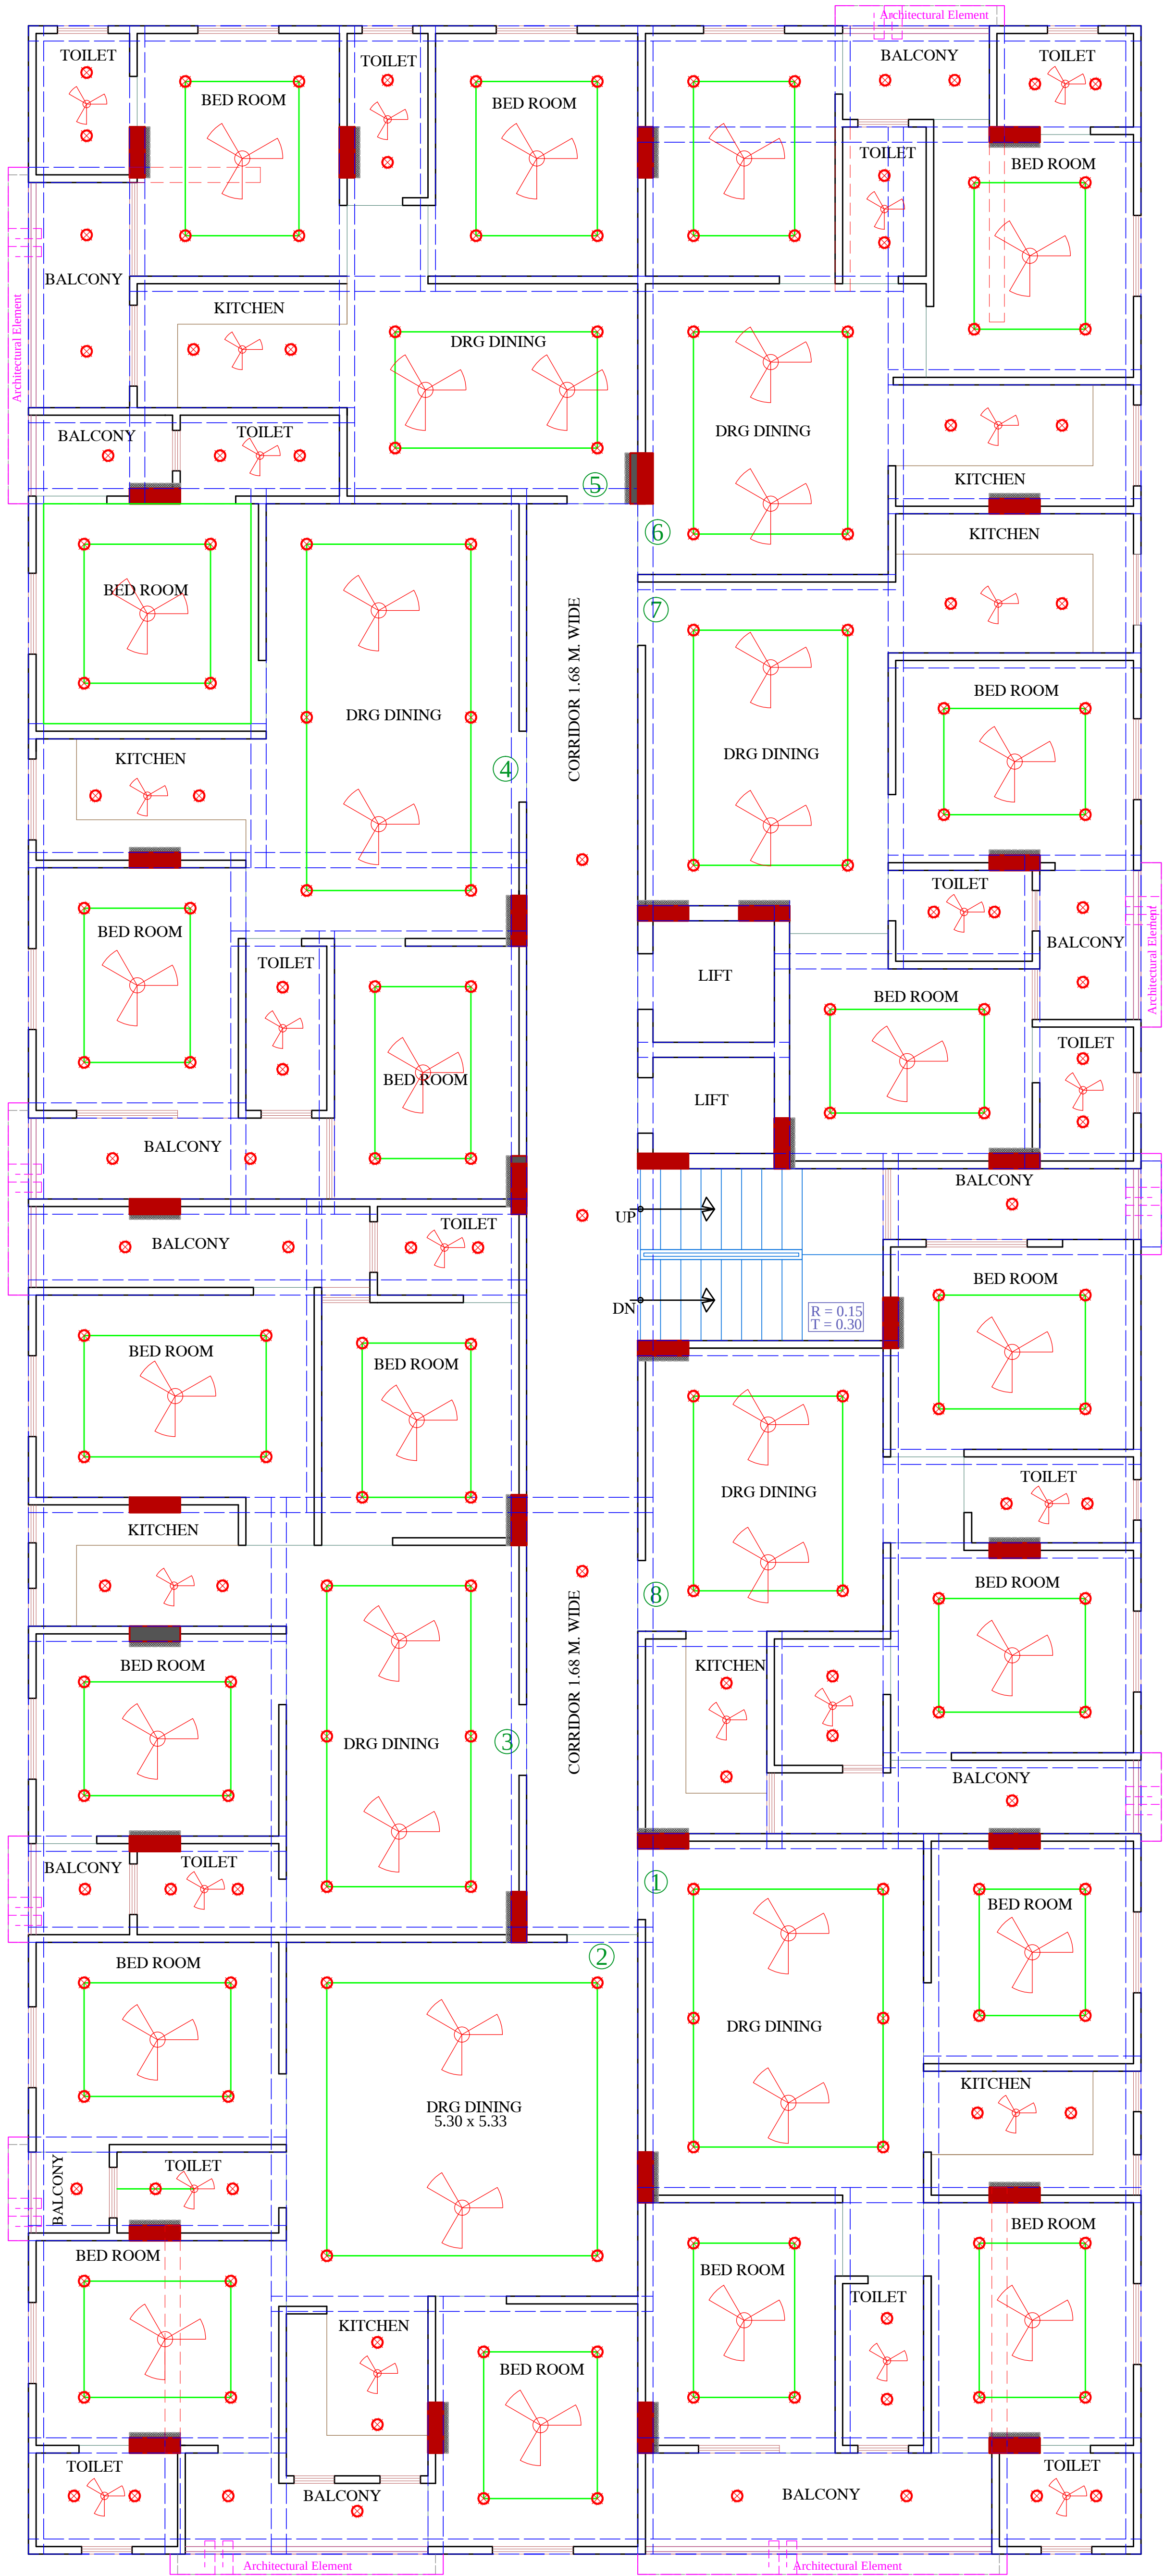


GROUND, 1st TO 5th FLOOR PLAN


RAMESH KUMAWAT
M.E.P. CONSULTANT
B.E. CIVIL

TYPICAL FLOOR LIGHT PLAN


PROJECT TITLE :- PROPOSED BUILDING AT PLOT NO.C-14, C-15 & C-16, SHRI RAM VIHAR, JAIPUR	SPACE CONSULTANT PLOT-A-173, JAGDAMBA NAGAR, HEERAPURA POWER HOWER, JAIPUR (RAJ) 302024	DRN. BY		NORTH	
			DATE		
		APPD. BY			REVISION
		SCALE	N.T.5		

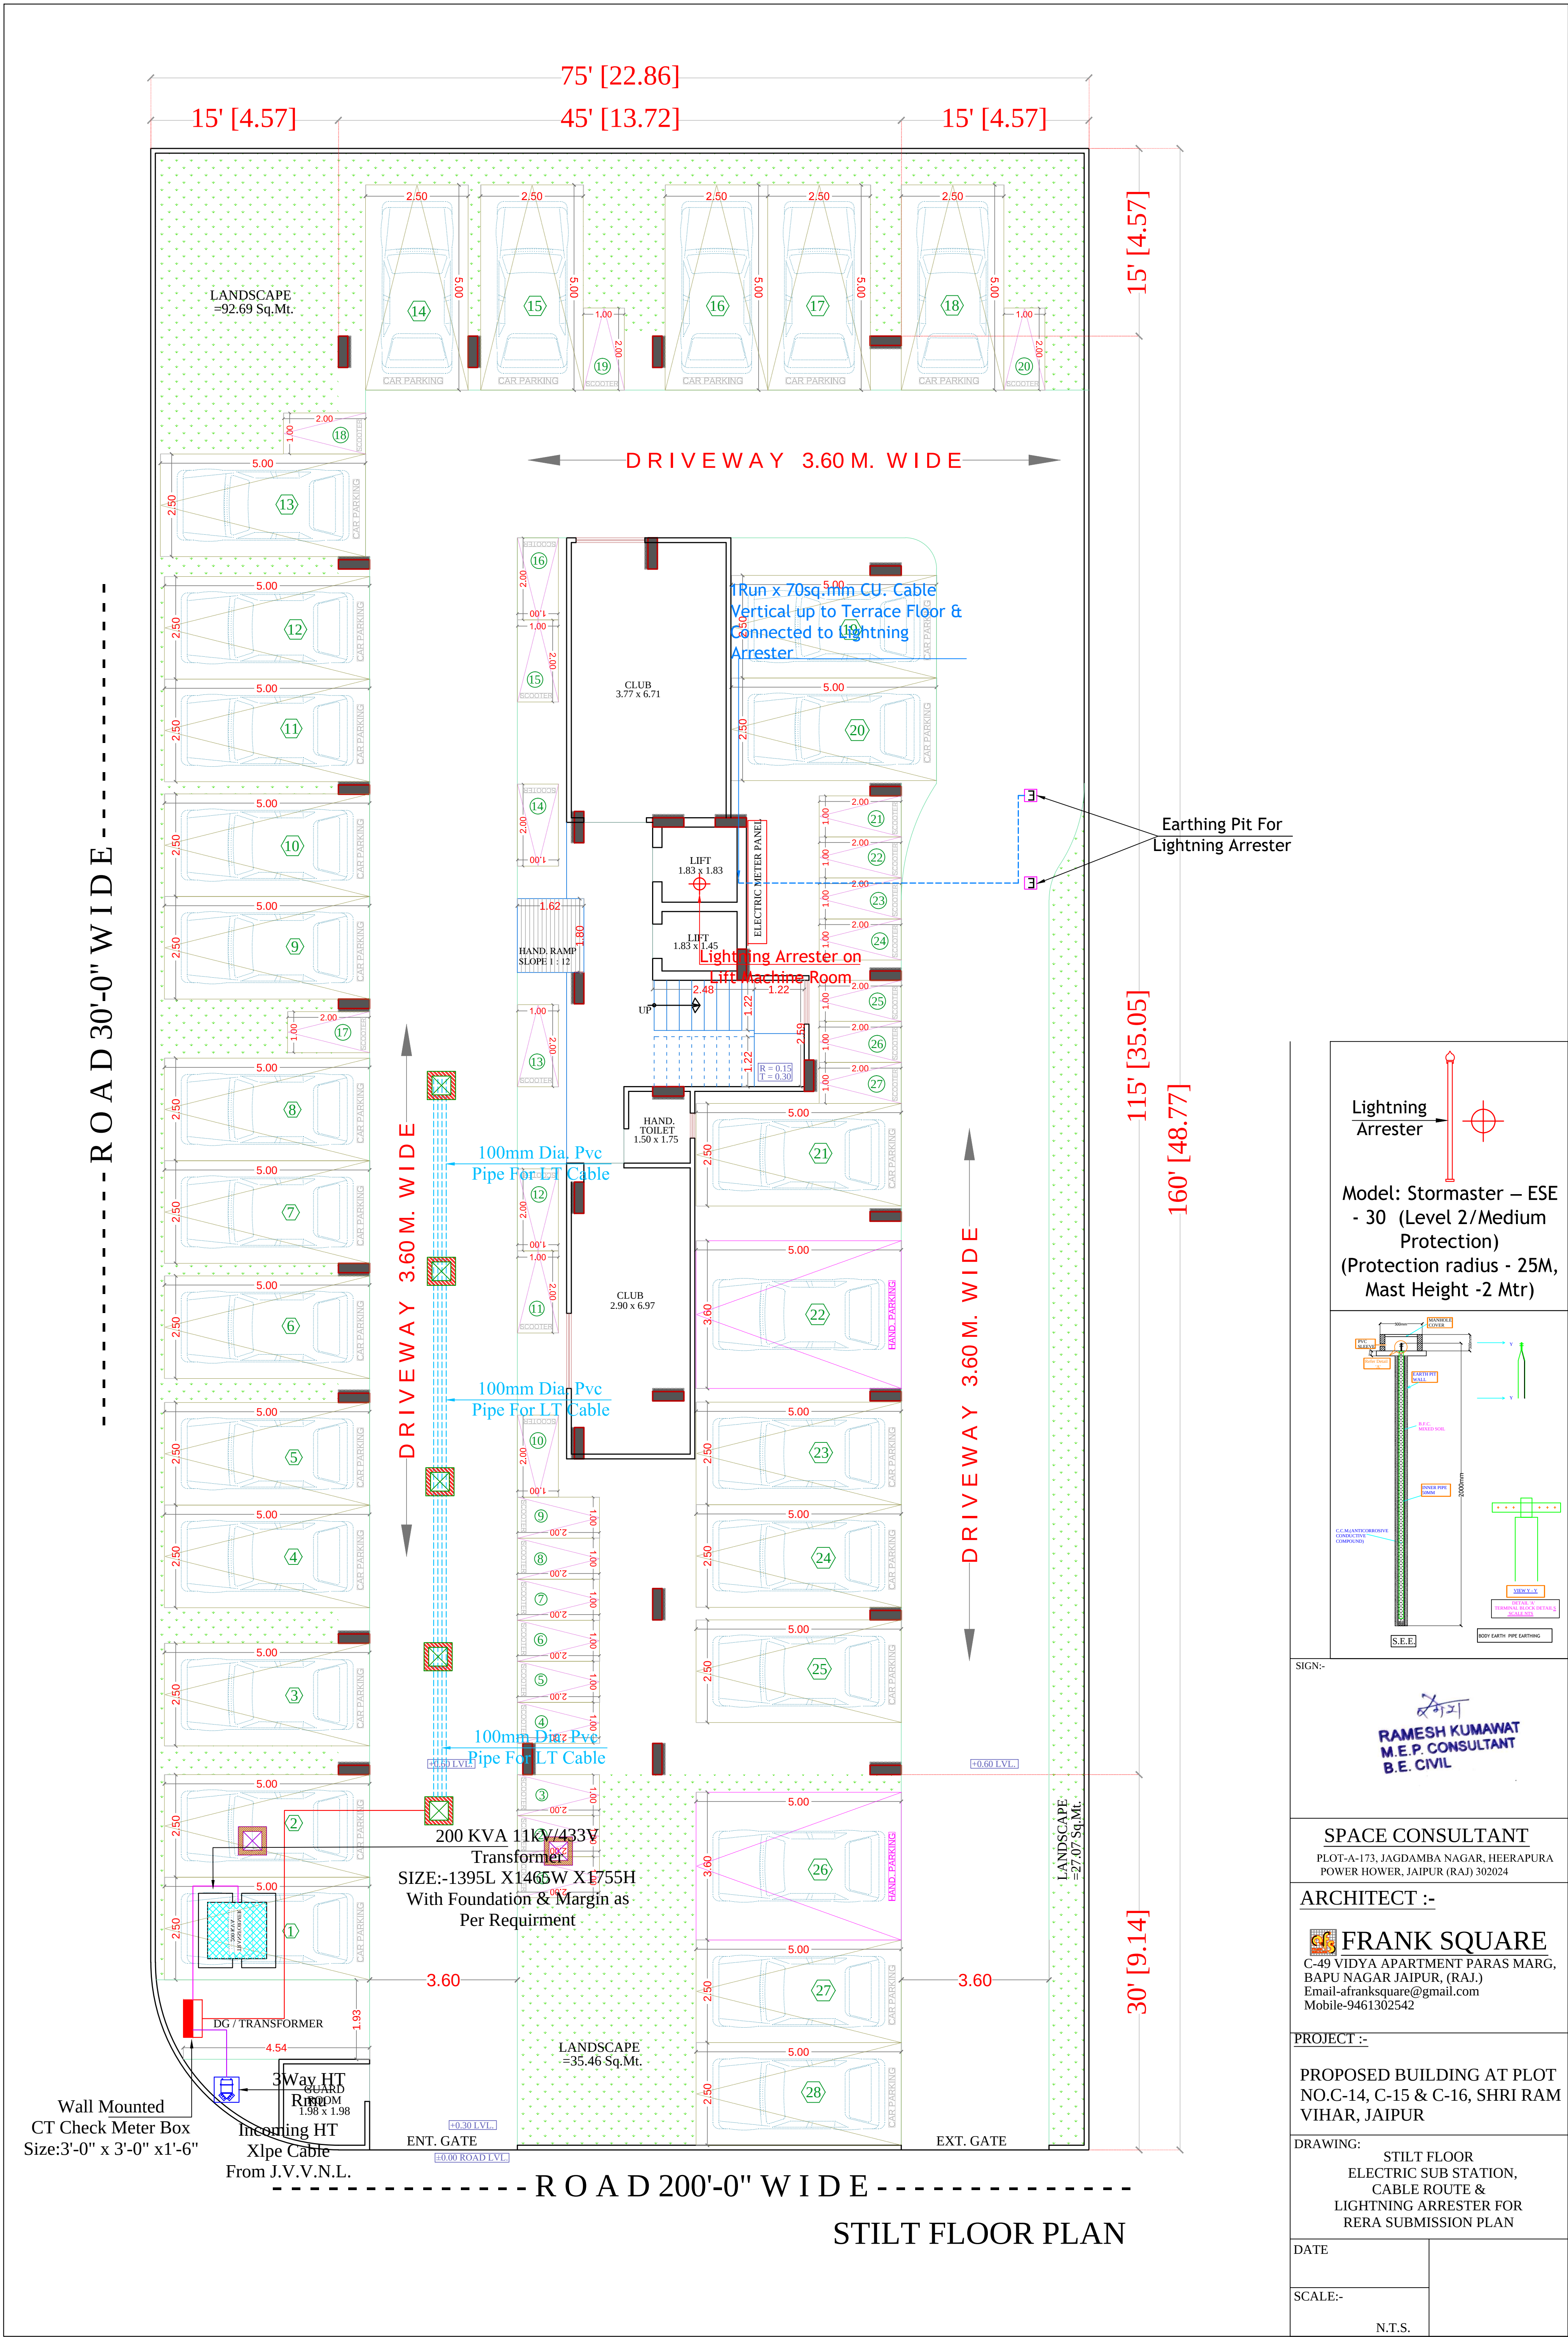

 

LEGENDS:			
Qty.	I D	Symbol	Description
14	PL		STREET LIGHT
SIGN:- 			
<u>SPACE CONSULTANT</u> PLOT-A-173, JAGDAMBA NAGAR, HEERAPURA POWER HOWER, JAIPUR (RAJ) 302024			
<u>ARCHITECT :-</u>  FRANK SQUARE C-49 VIDYA APARTMENT PARAS MARG, BAPU NAGAR JAIPUR, (RAJ.) Email-afranksquare@gmail.com Mobile-9461302542			
<u>PROJECT :-</u> PROPOSED BUILDING AT PLOT NO.C-14, C-15 & C-16, SHRI RAM VIHAR, JAIPUR			
DRAWING: <p style="text-align: center;">STILT FLOOR EXTERNAL STREET LIGHT FOR RERA SUBMISSION PLAN</p>			
DATE			
SCALE:-			
		N.T.S.	


SCHEMATIC DIAGRAM
LIGHTNING PROTECTION SYSTEM

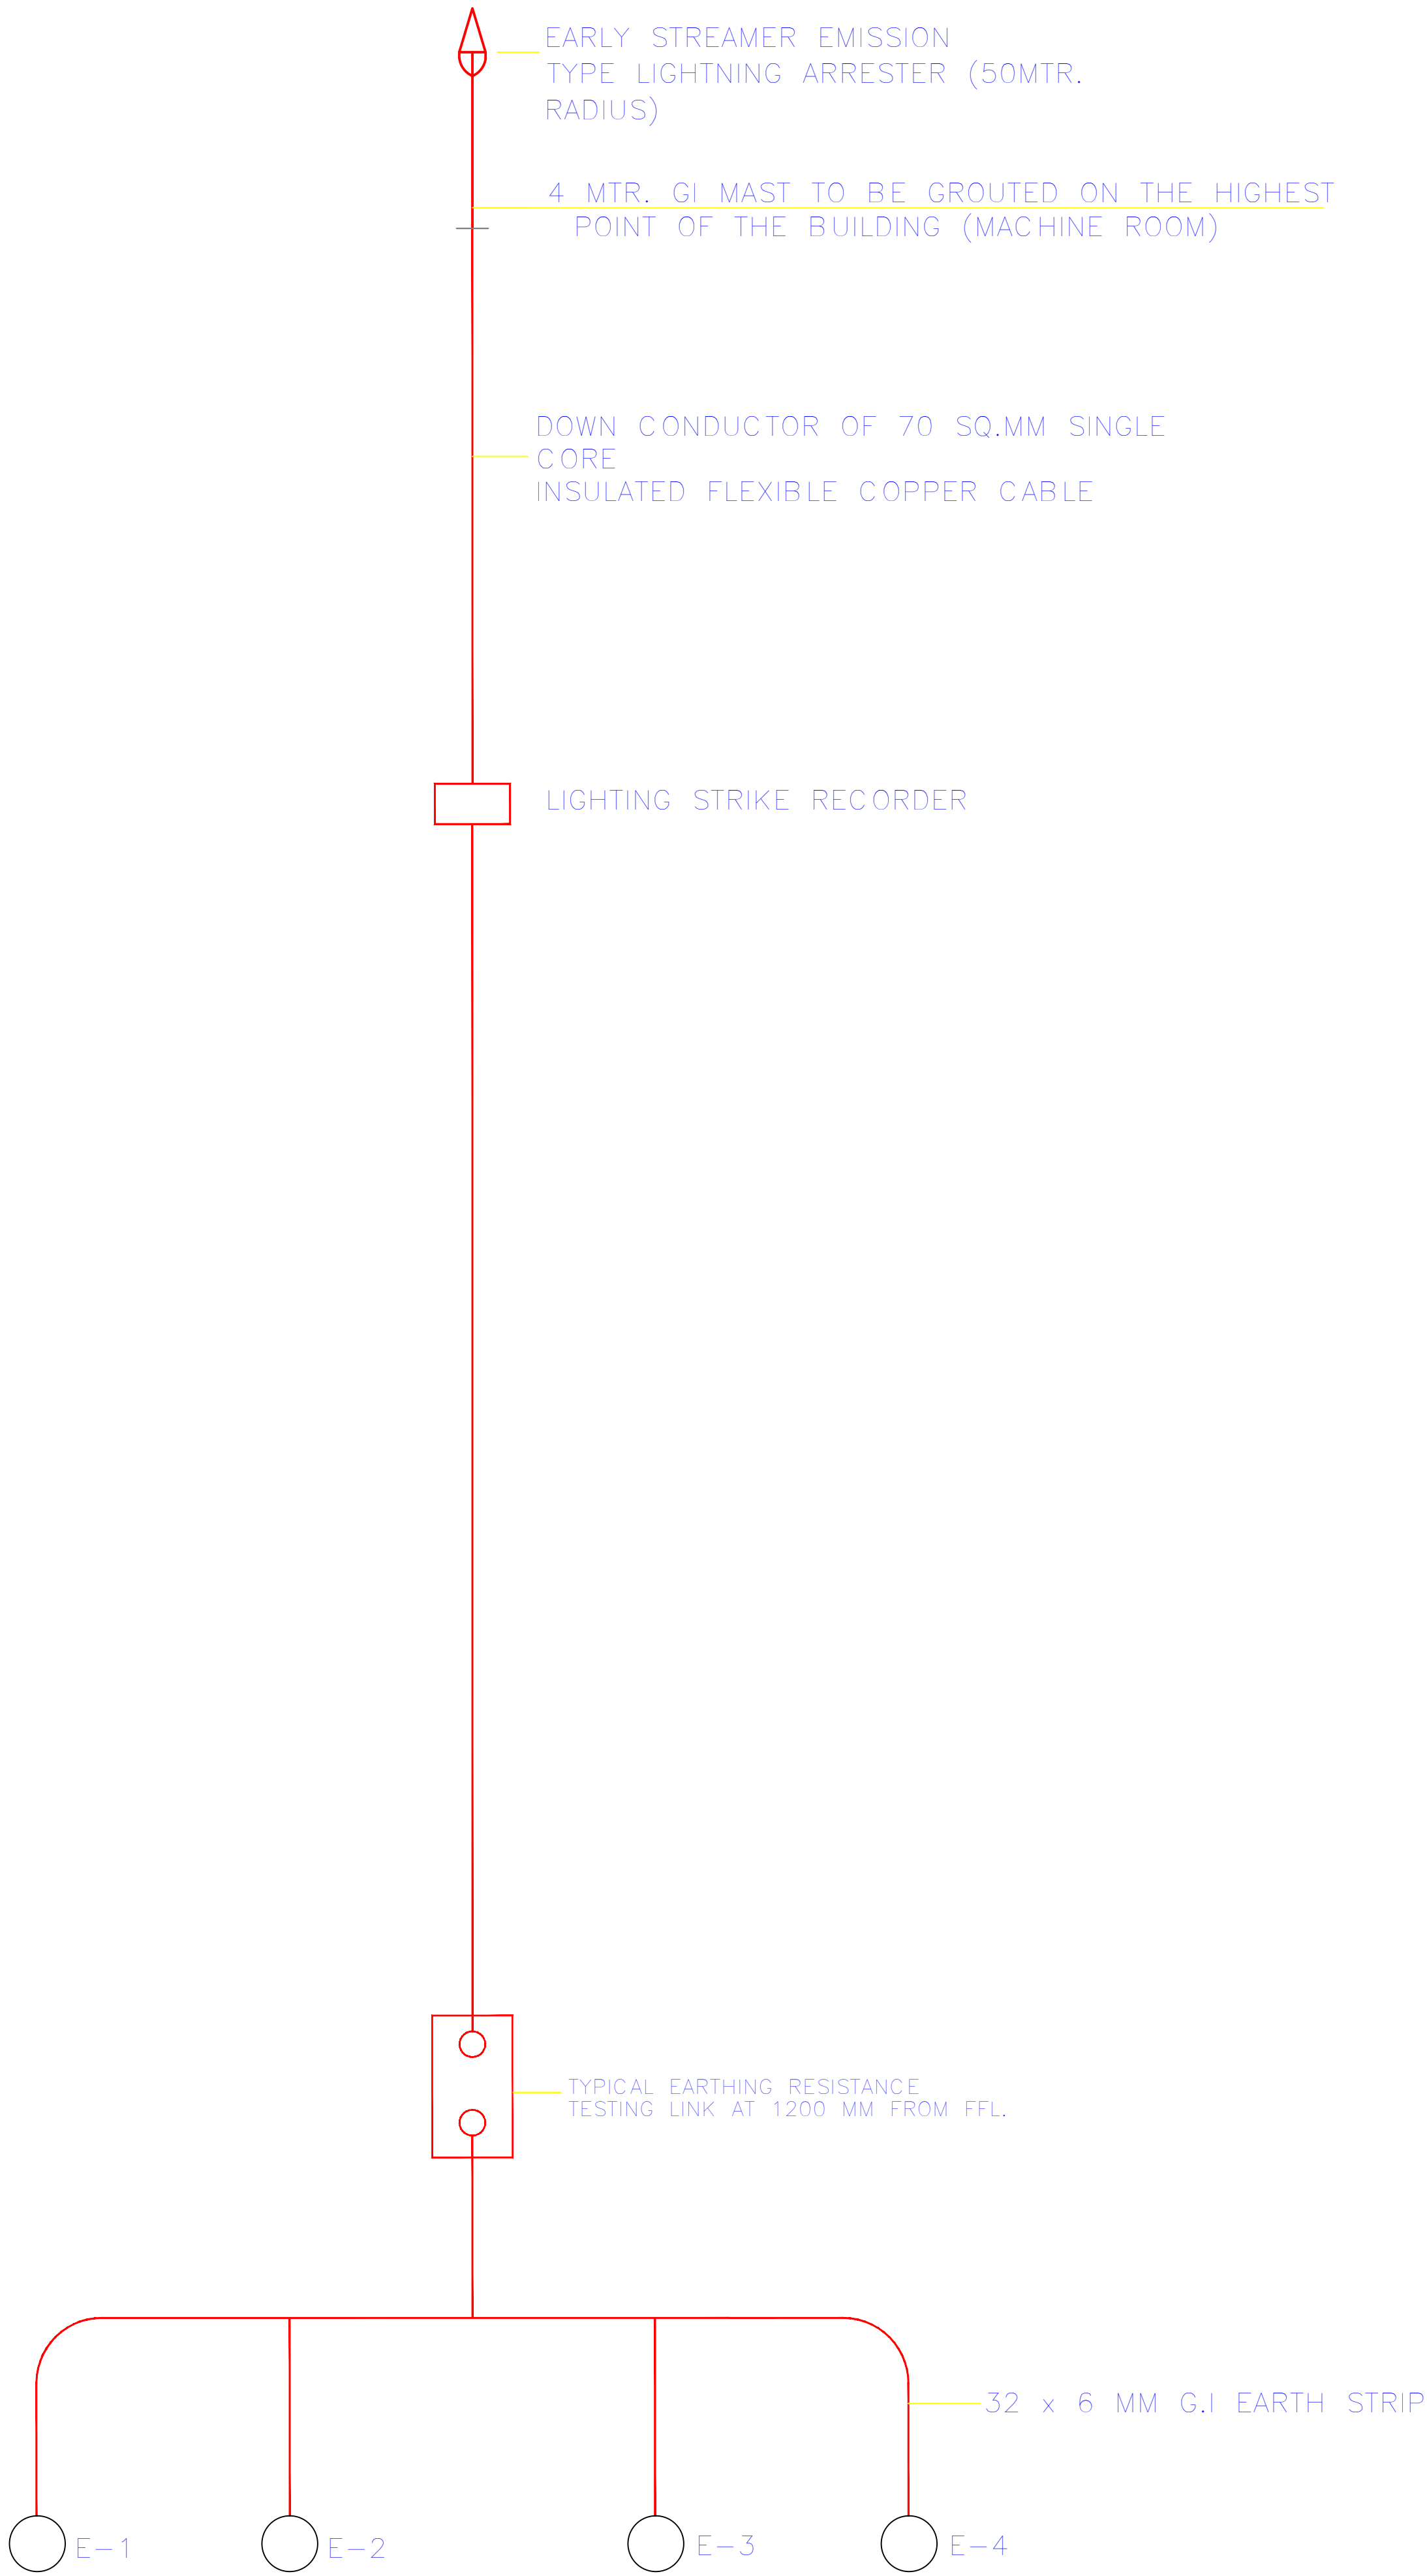

LIGHTENING ARRESTOR SLD


RAMESH KUMAWAT
M.E.P. CONSULTANT
B.E. CIVIL

PROJECT TITLE :- PROPOSED BUILDING AT PLOT NO.C-14, C-15 & C-16, SHRI RAM VIHAR, JAIPUR	DRAWING TITLE :- LIGHTENING ARRESTOR SLD	SPACE CONSULTANT PLOT-A-173, JAGDAMBA NAGAR, HEERAPURA POWER HOWER, JAIPUR (RAJ) 302024	DRN. BY		DATE	NORTH
			APPD. BY		REVISION	
			SCALE			

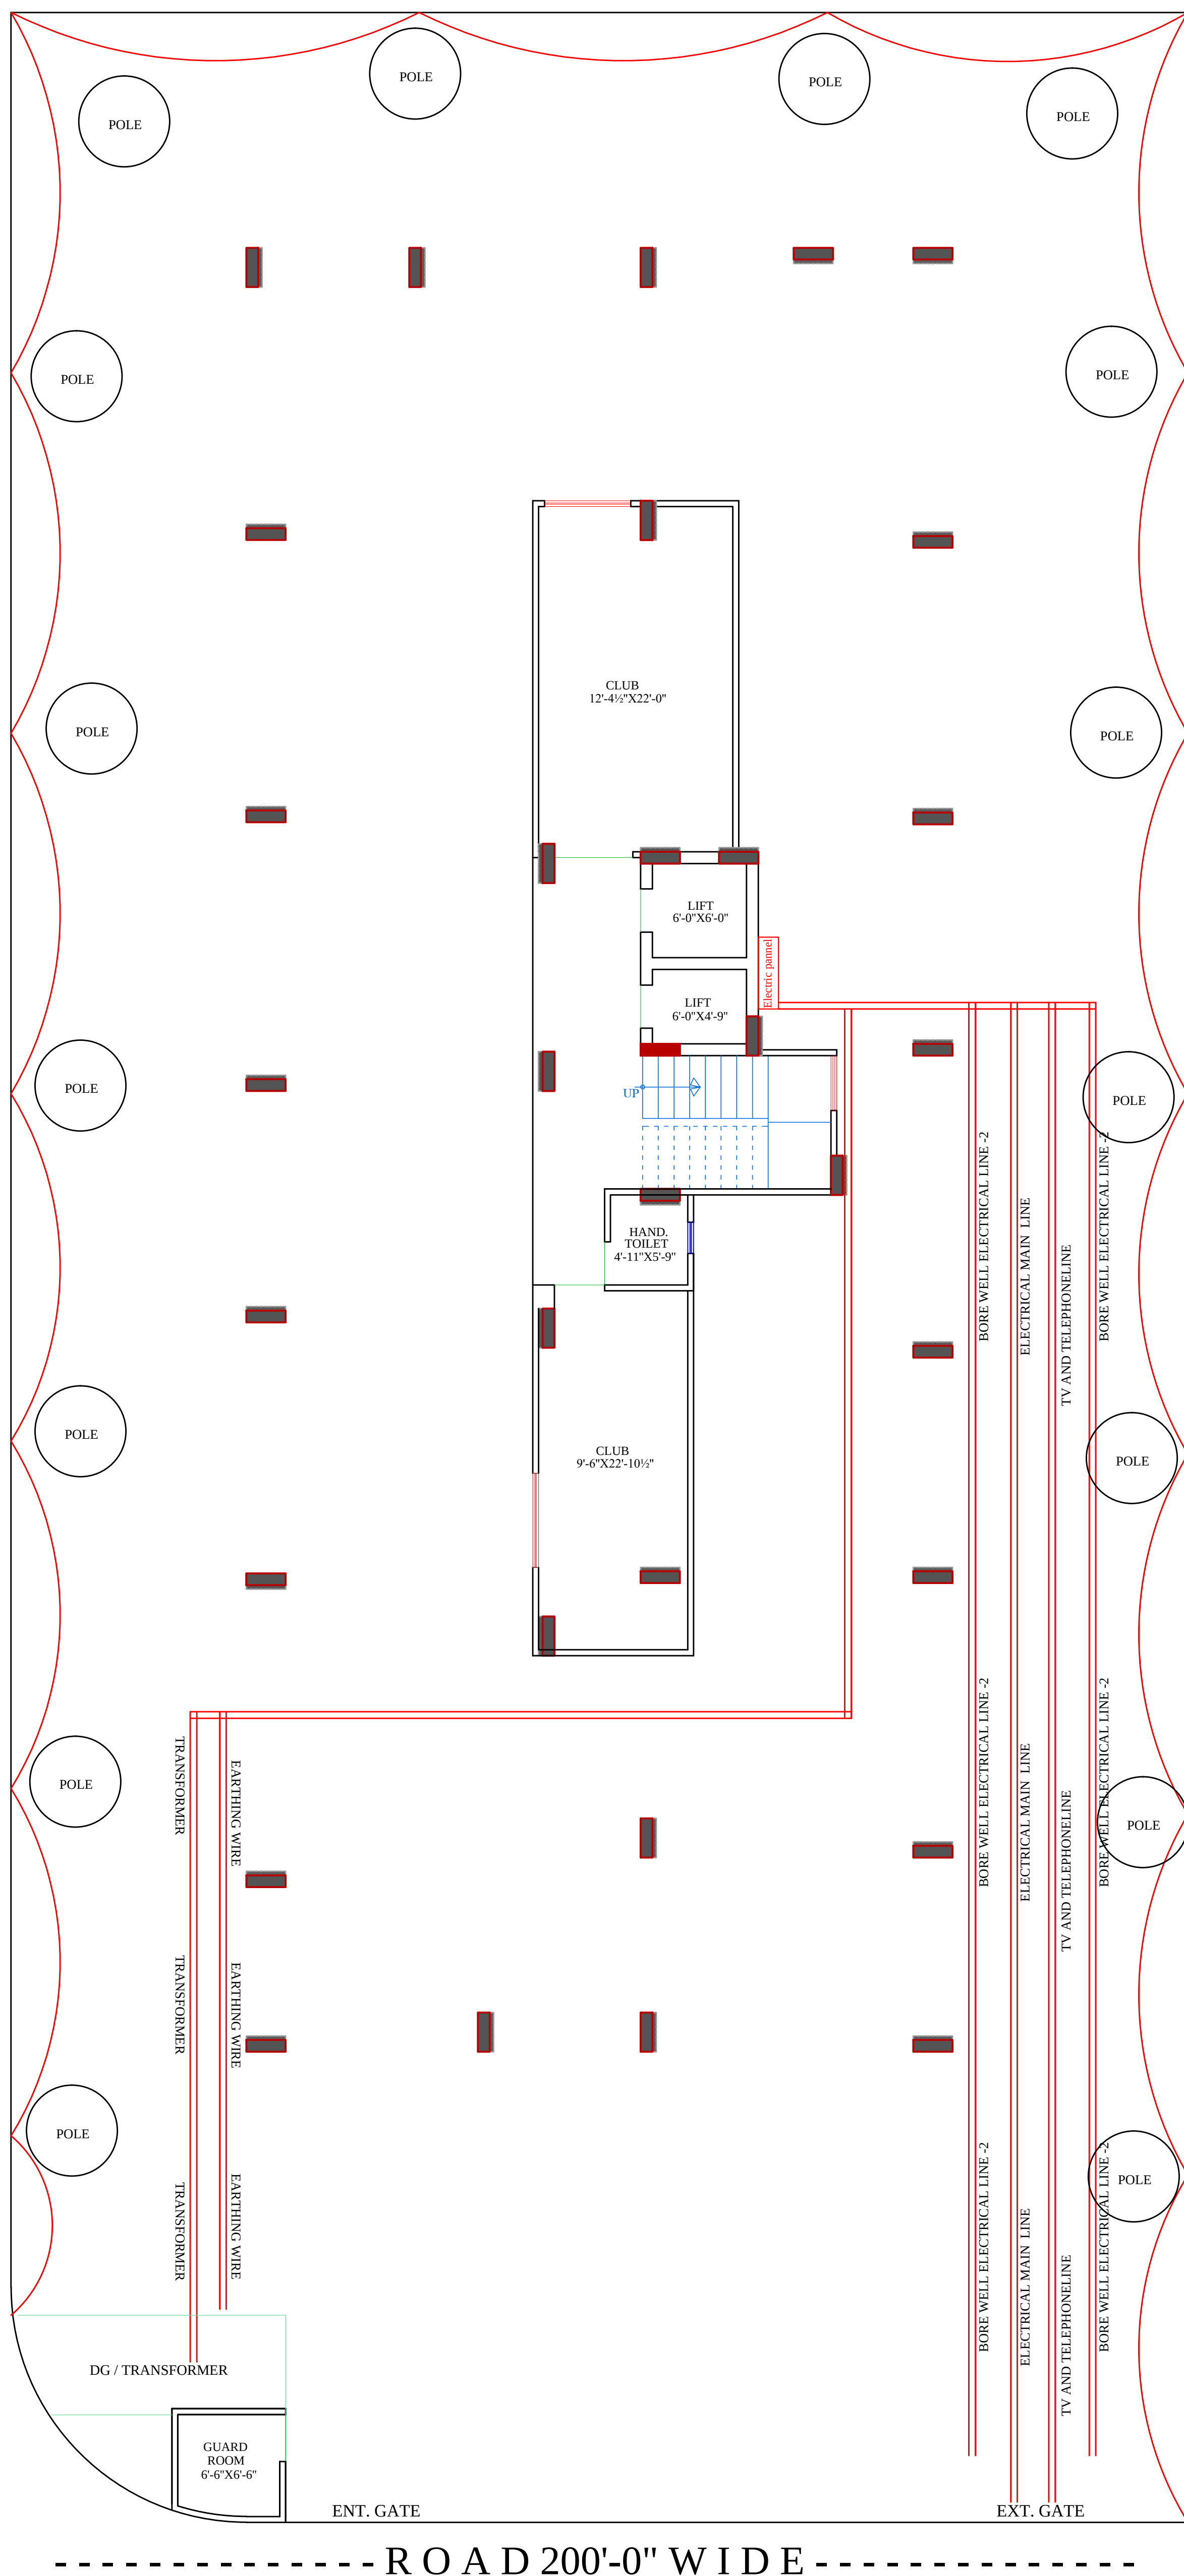

NO	ITEM	SYMBOL
1	CEILING FAN	 ROOF
2	TUBE LIGHT	 +8'6"
3	BULB	 +8'6"
4	POWER POINT	 +1'6"
5	BED POINT	 +4'3"
6	CEILING LIGHT	 ROOF
7	A.C.POINT	 +6'6"
8	SWITCH BOARD	 +4'3"
9	EXHAUST	 VENT
10	TELEPHONE	 +1'6"
11	GYSER	 +6'0"
12	BELL POINT	 +8'6"
13	T.V.	 +1'6"
14	M.BOX	 +6'6"
15	M.C.B.	 +6'6"
16	FANCY LIGHT	 +8'6"
17	HANGING LIGHT	 ROOF


RAMESH KUMAWAT
M.E.P. CONSULTANT
B.E. CIVIL

STILT (PARKING) FLOOR PLAN

PROJECT TITLE :- PROPOSED BUILDING AT PLOT NO.C-14, C-15 & C-16, SHRI RAM VIHAR, JAIPUR	DRAWING TITLE :- SERVICE DRAWING SLD/DISTRIBUTION AFTER LT PANEL, EARTHING LAYOUT,EXTERNAL LIGHTING PLAN, TV & TELEPHONE RISER,LIGHTING ARRESTR, & PIT LOCATION COMMON AREA TRANSFORMER	<div> <div>SPACE CONSULTANT</div> <div> PLOT-A-173, JAGDAMBA NAGAR, HEERAPURA POWER HOWER, JAIPUR (RAJ) 302024 </div> </div>	DRN. BY			NORTH
					DATE	
			APPD. BY		REVISION	
			SCALE	N.T.5		

