



For Mohit Real Estate & Builders Pvt. Ltd.
M. R. D. D. D.



STANDARDS SANITARY APPLIANCES		
S.NO	SYMBOL DESCRIPTION	All Heights For Finish Floor Lev
1	WASH BASIN MIXER	+800MM
2	WASH BASIN ANGLE VALVE	+450MM
3	BOTTLE TRAP	+450MM
4	MIRROR (40X50mm(BOTTOM))	+950MM
5	OVER HEAD SHOWER	+2055MM
6	WALL MIXER DIVERTOR	+1000MM
7	TAP FOR BATH AREA	+770MM
8	SOAP DISH	+1000MM
9	AS PER ARCHT. TOWEL RAIL	+1500MM
10	Health Faucet Hand Shower	+300MM
11	PAPER HOLDER	+450MM
12	ANGLE VALVE FOR CISTER	+1950MM
13	CONCEALED STOP COCK	+2100MM
14	CISTERN ANGLE VALVE	+450MM
15	KITCHEN SINK MIXER	+1000MM
15	ANGLE VALVE FOR WATER PURIFIER	+1500MM

	Floor Trap
	Cold Water Supply
	Hot Water Line - Internal
	Cold Water Line - Internal

SERVICES CONSULTANT:
ASHI ASSOCIATES
F 9 / 440 . Keshav Marg Chitrakut Scheme,Jaipur
Ph:91-093146-10438 0141-2460946 Mail:vp@ashis99@yahoo.com
REV. NO. 000 DATE: 20-11-2018

ARCHITECTS:
SPACE GRID
C-49,VIDYA APARTMENT,PARKS MARK,
BAPU NAGAR,JAIPUR - 302015,
PHONE: 9314918766,9314510603

Developer Name:-
Mojika Real Estate And
Developer Pvt. Ltd.

Director:- Nagarnal Agarwal




Project Name:- Dream Point

Address:- 1156 Khandela House
Jhoitware Road Chandepol Jaipur

DRAWING:
TYPICAL FLOOR PLUMBING PLAN

DRN	CKD	DATE:-	REV:-
GANGA RAM	SANJAY	20-11-2018	00
APPD		SCALE:-	
VPPL AGARWAL		N.T.S	



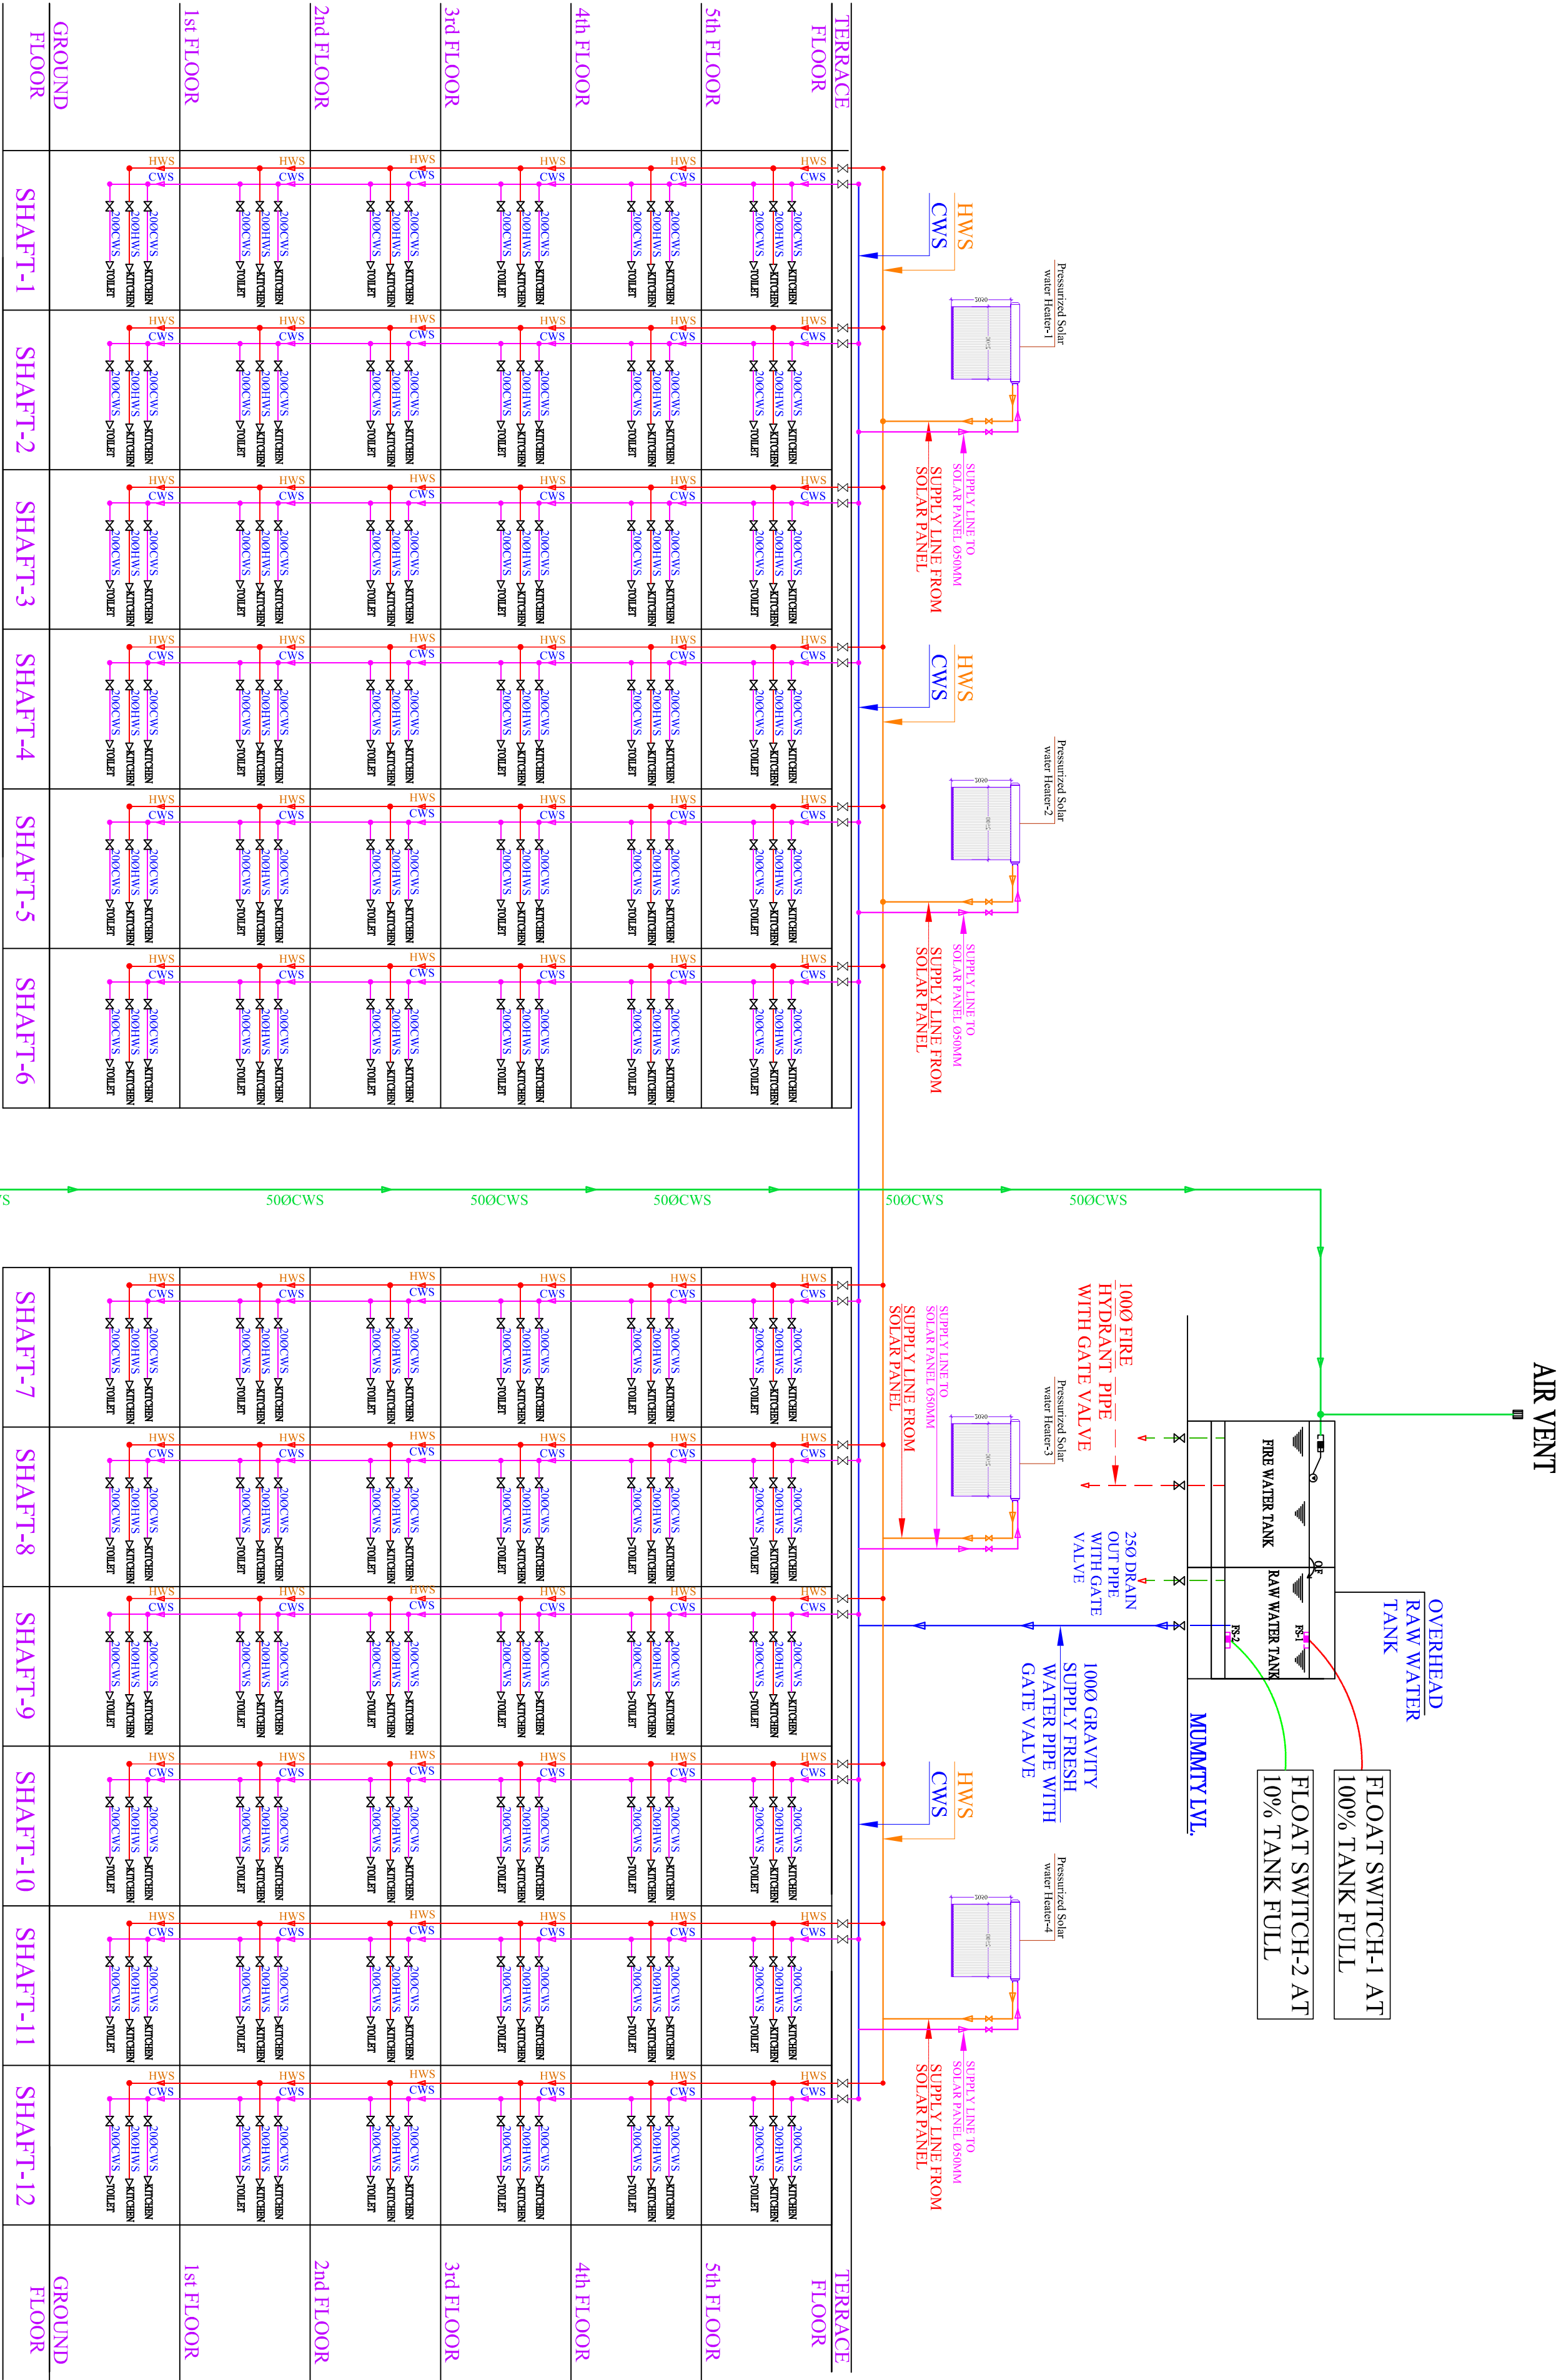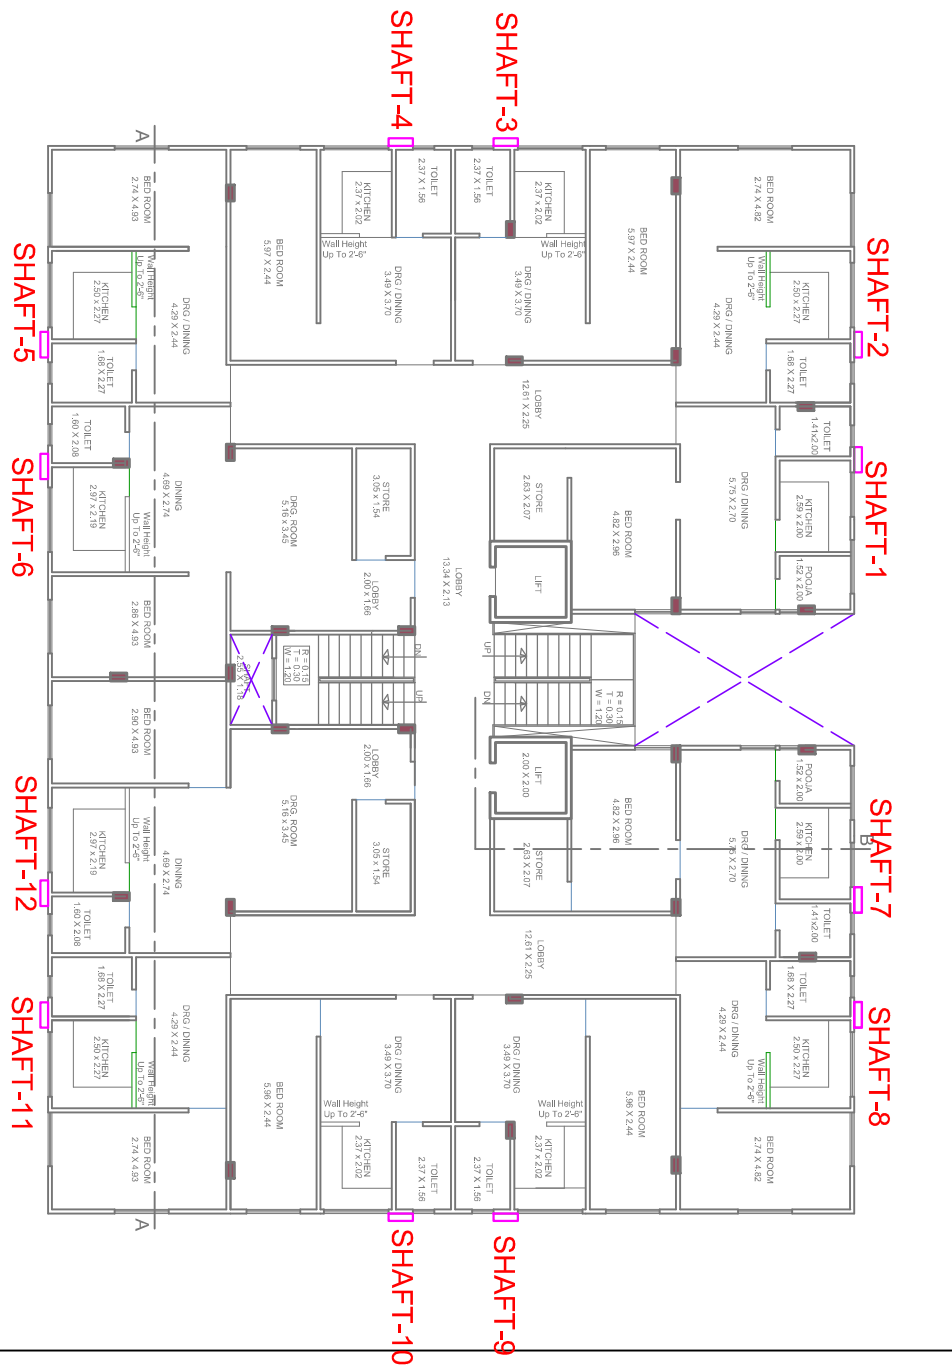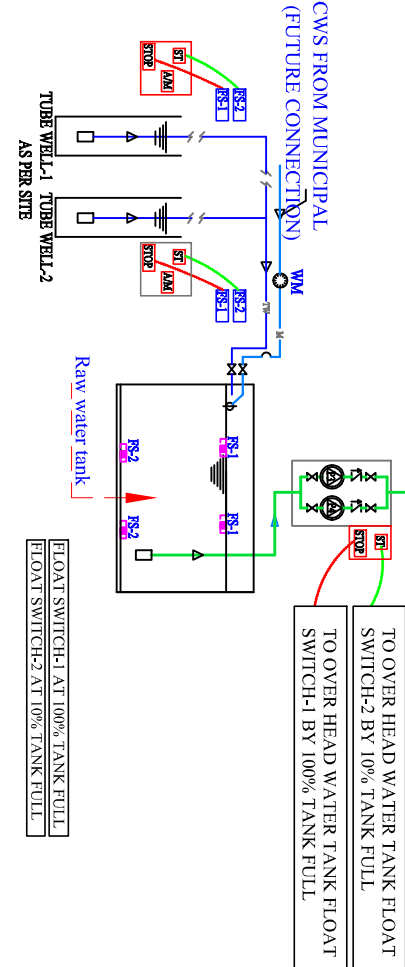

For Mojika Real Estate & Developers Pvt. Ltd.



KEY PLAN

WATER SUPPLY DIAGRAM

DRAWING TITLE:-

ARCHITECTS:-

APPD BY:-

DATE:-

NORTH:-

SERVICES CONSULTANT:

ASHI ASSOCIATES

REV. NO. 00/DATE:-30-01-2018

Developer Name:-

Mojika Real Estate And Developer Pvt. Ltd.

Director:- Nagamal Agarwal

Project Name:- Dream Point

Address:- 1156 Khandela House Jhotware Road Chandepol Jaipur

VPIL AGARWAL

DEALT BY:-

SCALE:-

SAUNAY

N.T.S.

REV:-

VPIL AGARWAL

DEALT BY:-

SCALE:-


SAUNAY

N.T.S.

REV:-

[illegible]

NOTE:- ALL INVERT LVL FROM WATER TANK UNFINISHED FLOOR LVL

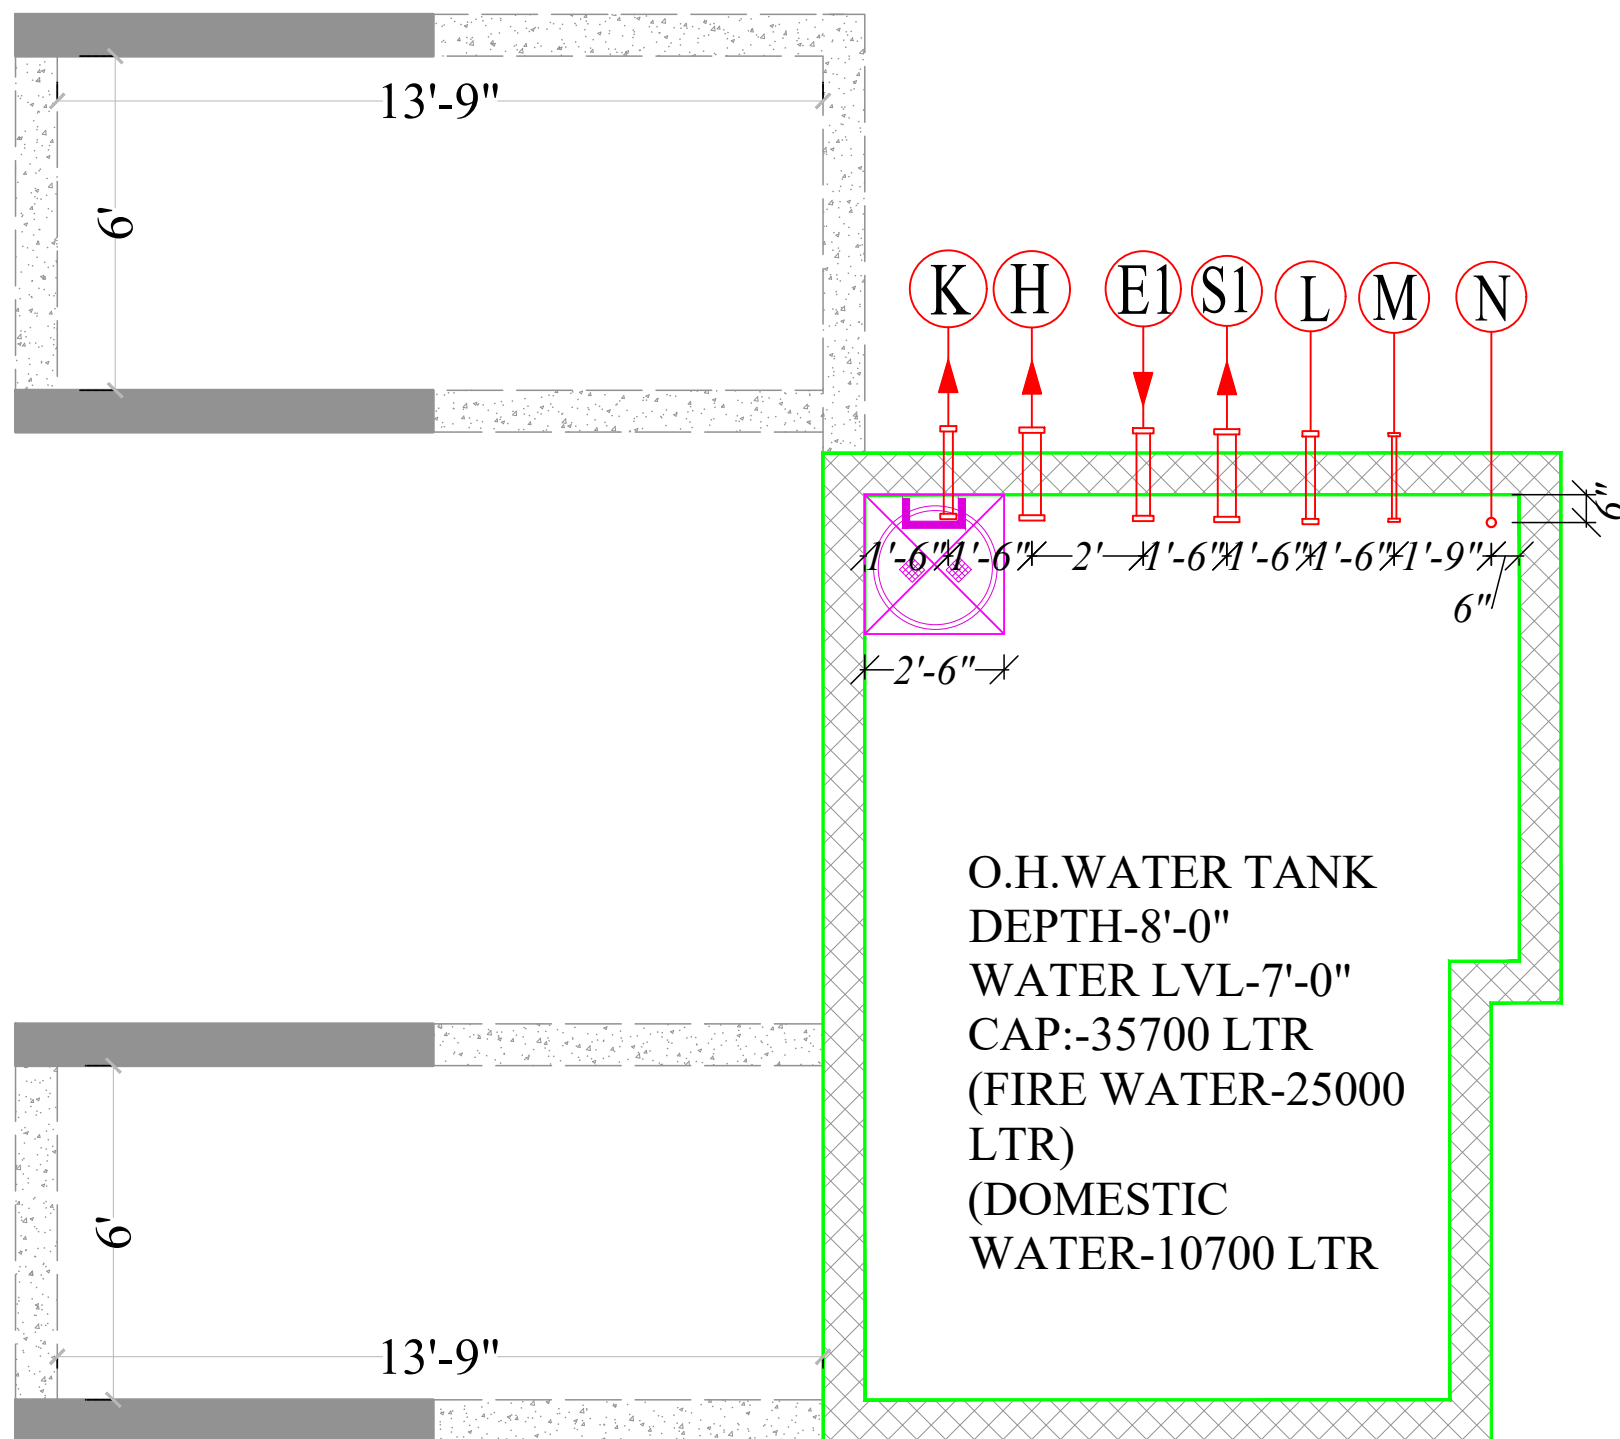

Vipul
VIPUL AGARWAL
M.E.P. CONSULTANT
B.E. ELECTRICAL

2nd LEVEL SHUTTERING (WATER TANK & MACHINE ROOM TOP)

