

SECTOR RØD 80'0" WIDE

SHEET NO. 03

GROUND FLOOR PLAN

GUARD ROOM				
CKT. NO.	SYMBOL	DESCRIPTION	QUANTITY	WATT
1.		STREET LIGHT	08 NOS	560 WATT
2.		STREET LIGHT	08 NOS	560 WATT
3.		STREET LIGHT	10 NOS	700 WATT
4.		STREET LIGHT	10 NOS	700 WATT
5.		STREET LIGHT	10 NOS	700 WATT
6.		STREET LIGHT	10 NOS	700 WATT
7.		STREET LIGHT	10 NOS	700 WATT
8.		STREET LIGHT	10 NOS	700 WATT
9.		STREET LIGHT	07 NOS	490 WATT
10.		STREET LIGHT	09 NOS	630 WATT
TOTAL LOAD IN WATT			6440 WATT	
TOTAL LOAD IN KW			6.440 KW	

EXTERNAL LIGHTING LEGEND			
	Street light	3-4/6M	Glowmac
	CCTV CAMERA		

LEGEND

	TRANSFORMER
	FEEDER PILLER (Distribution board)
	FEEDER PILLER (Phone)
	11KV HT CABLE
	LT CABLE
	TELEPHONE CABLE
	3" Pipe Foil Cable For Street Light
	4" Pipe Foil Home Connection
	6" Pipe Foil Home Connection
	8" Pipe Foil Home Connection
	3" Pipe Foil Cable
	4" Pipe Foil Cable
	6" Pipe Foil Cable
	2" Pipe Foil Cable

ARCHITECT

m l a architects
ARCHITECTS, ENGINEERS AND INTERIOR DESIGNERS
PLOT No.-1, OFF SAHAKAR MARG,
LAL KOTHI SCHEME, JAIPUR - 302015
TEL. 91-0141-2741232, 91-0141-2743619
TELE FAX. 91-0141-2741664
email - studio@maarchitects.in, maarchitects@gmail.com
web - www.maarchitects.in

PROJECT

REGALIA BUILDERS
ASHADEEP RAINBOW - PHASE-IV
GROUP HOUSING-1
Village Jirota, The. Sanganer, Jaipur

MEP CONSULTANTS :-

SRAJAN ASSOCIATES


C-35A, NAKSHATRA, LAMP MARG,
C-SCHEME, JAIPUR
PH:- 0141-4040129, E-MAIL: snajaiipur@hotmail.com

DRAWING TITLE

EXTERNAL ELECTRICAL
& EXTERNAL FIRE FIGHTING PLAN

scale :	N.TS	drawn by :	SAMEER
date :	25-06-2021	checked by :	SHARWAN
rev no :	R - 10	approved by :	PG
drawing no :	SA/MAS/9333	NORTH:	


OTHERS LAND




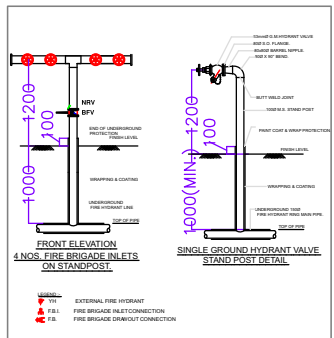


LEGEND			
NO	DESCRIPTION	SYMBOL	QTY.
1.	MS PIPE FOR HYDRANT MAIN		AS PER SITE
2.	BIF VALVE		03 NOS
3.	NRV VALVE		01 NOS
4.	EXTERNAL FIRE HYDRANT		14 NOS
5.	FIRE BRIGADE INLET CONNECTION		01 NOS
6.	FIRE BRIGADE DRAWOUT CONNECTION		01 NOS

OTHERS LAND

Praveen Kumar
BTECH (ELECT)

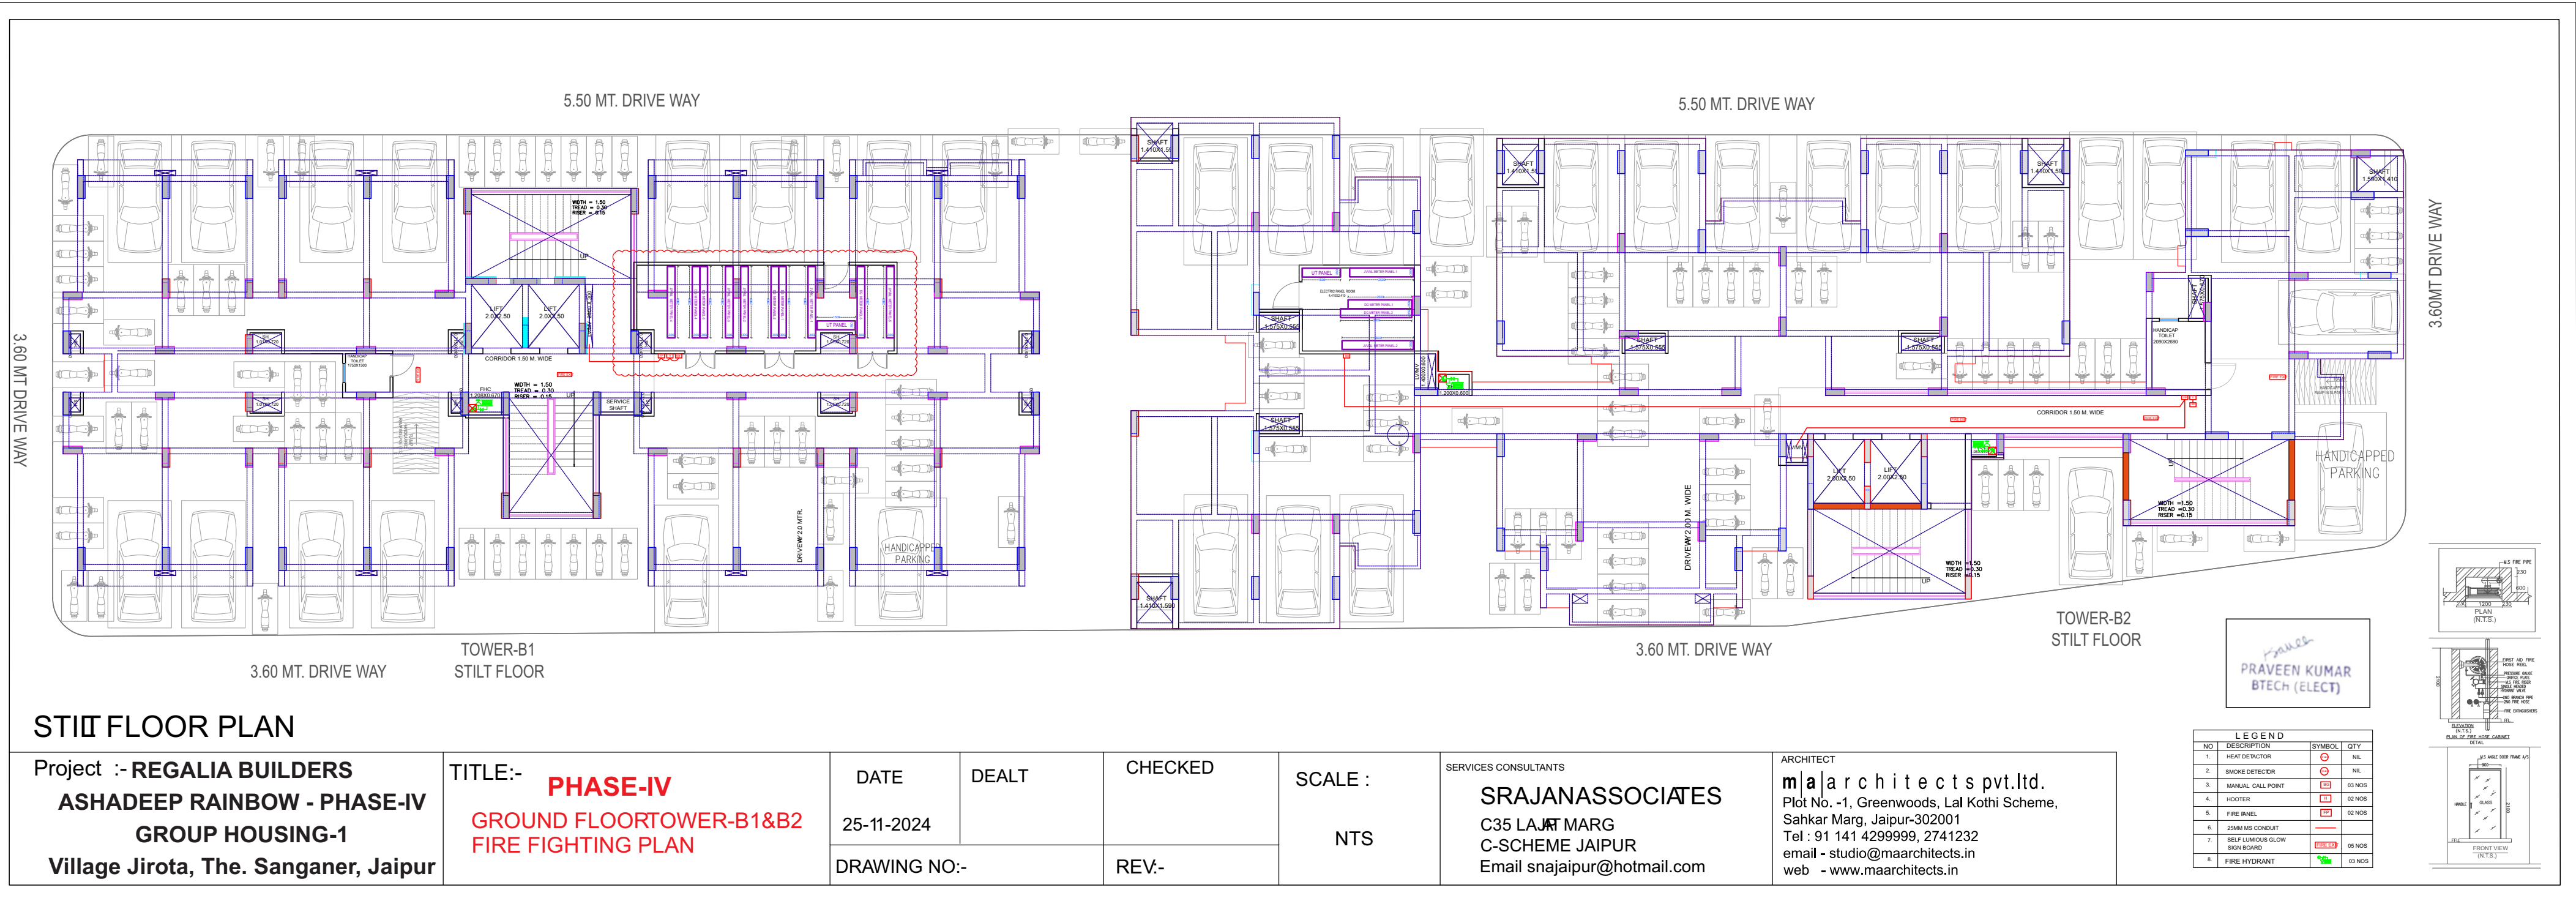

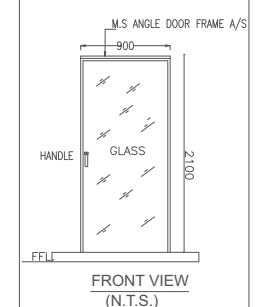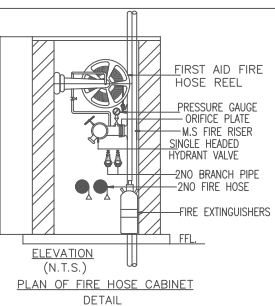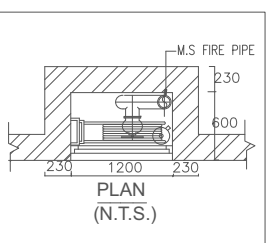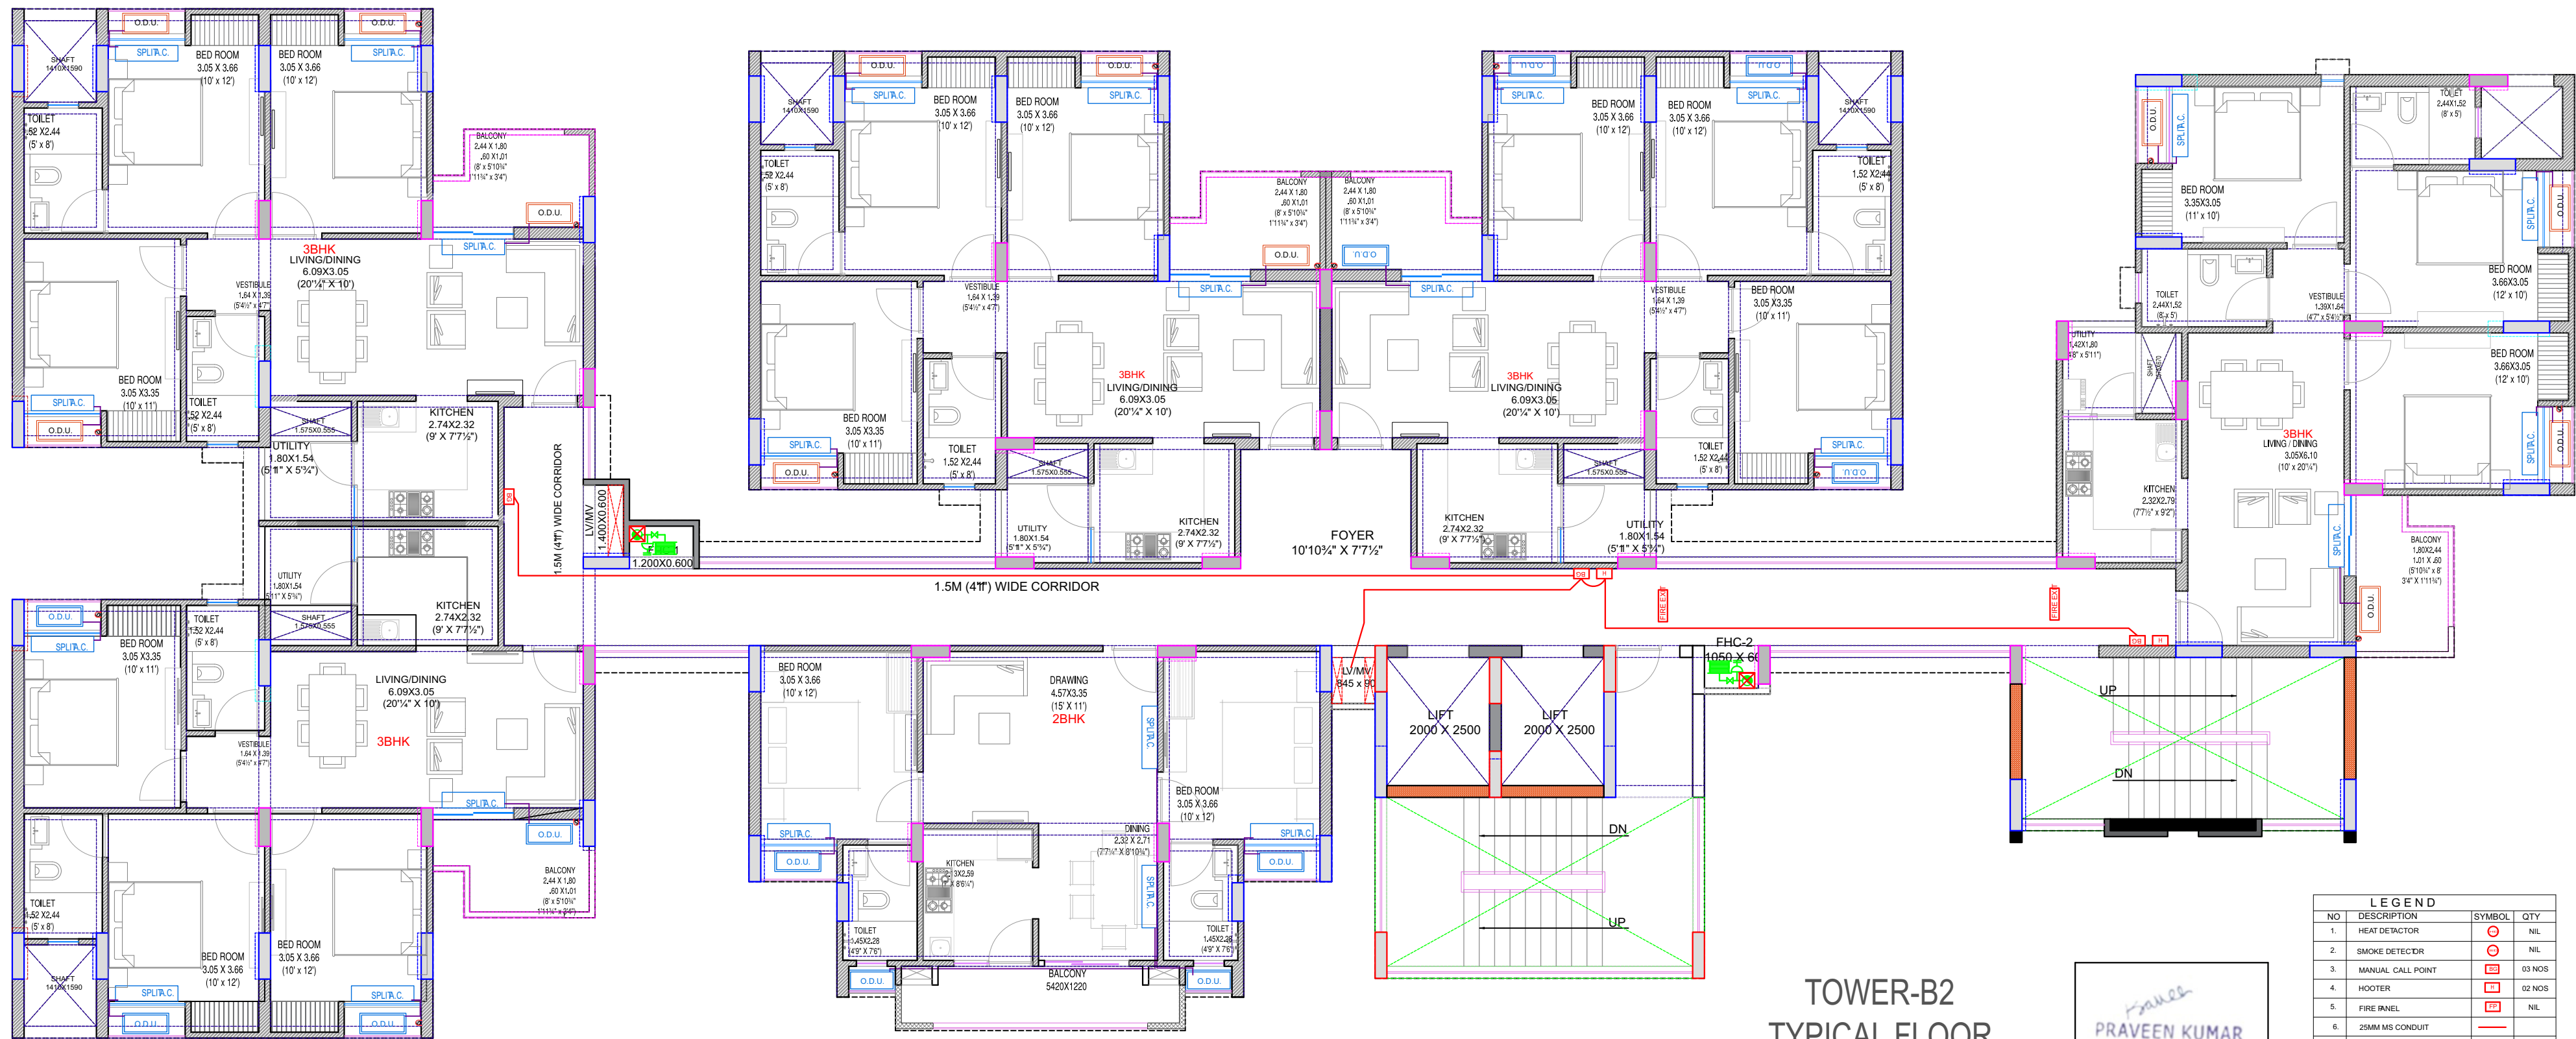

LEGEND			
NO	DESCRIPTION	SYMBOL	QTY
1.	HEAT DETECTOR		NIL
2.	SMOKE DETECTOR		NIL
3.	MANUAL CALL POINT		03 NOS
4.	HOOTER		02 NOS
5.	FIRE INEL		NIL
6.	25MM MS CONDUIT		
7.	SELF LUMINOUS GLOW SIGN BOARD		02 NOS
8.	FIRE HYDRANT		02 NOS

TOWER-B2
TYPICAL FLOOR

Praveen
PRAVEEN KUMAR
BTECH (ELECT)


Project :-
REGALIA BUILDERS
ASHADEEP RAINBOW - PHASE-IV
GROUP HOUSING-1
Village Jirota, The. Sanganer, Jaipur

TITLE:-
TYPICAL FLOOR TOWER-B-2
FIRE FIGHTING PLAN




DATE	DEALT	CHECKED
25-11-2024		
DRAWING NO:-		REV:-

SERVICES CONSULTANTS
SRAJAN ASSOCIATES
C35 LAJAT MARG
C-SCHEME JAIPUR
Email snajaipur@hotmail.com

ARCHITECT
m | a | r | c | h | i | t | e | c | t | s pvt.ltd.
Plot No. -1, Greenwoods, Lal Kothi
Scheme, Sahkar Marg,
Jaipur-302001
Tel : 91 141 4299999, 2741232
email - studio@maarchitects.in
web - www.maarchitects.in

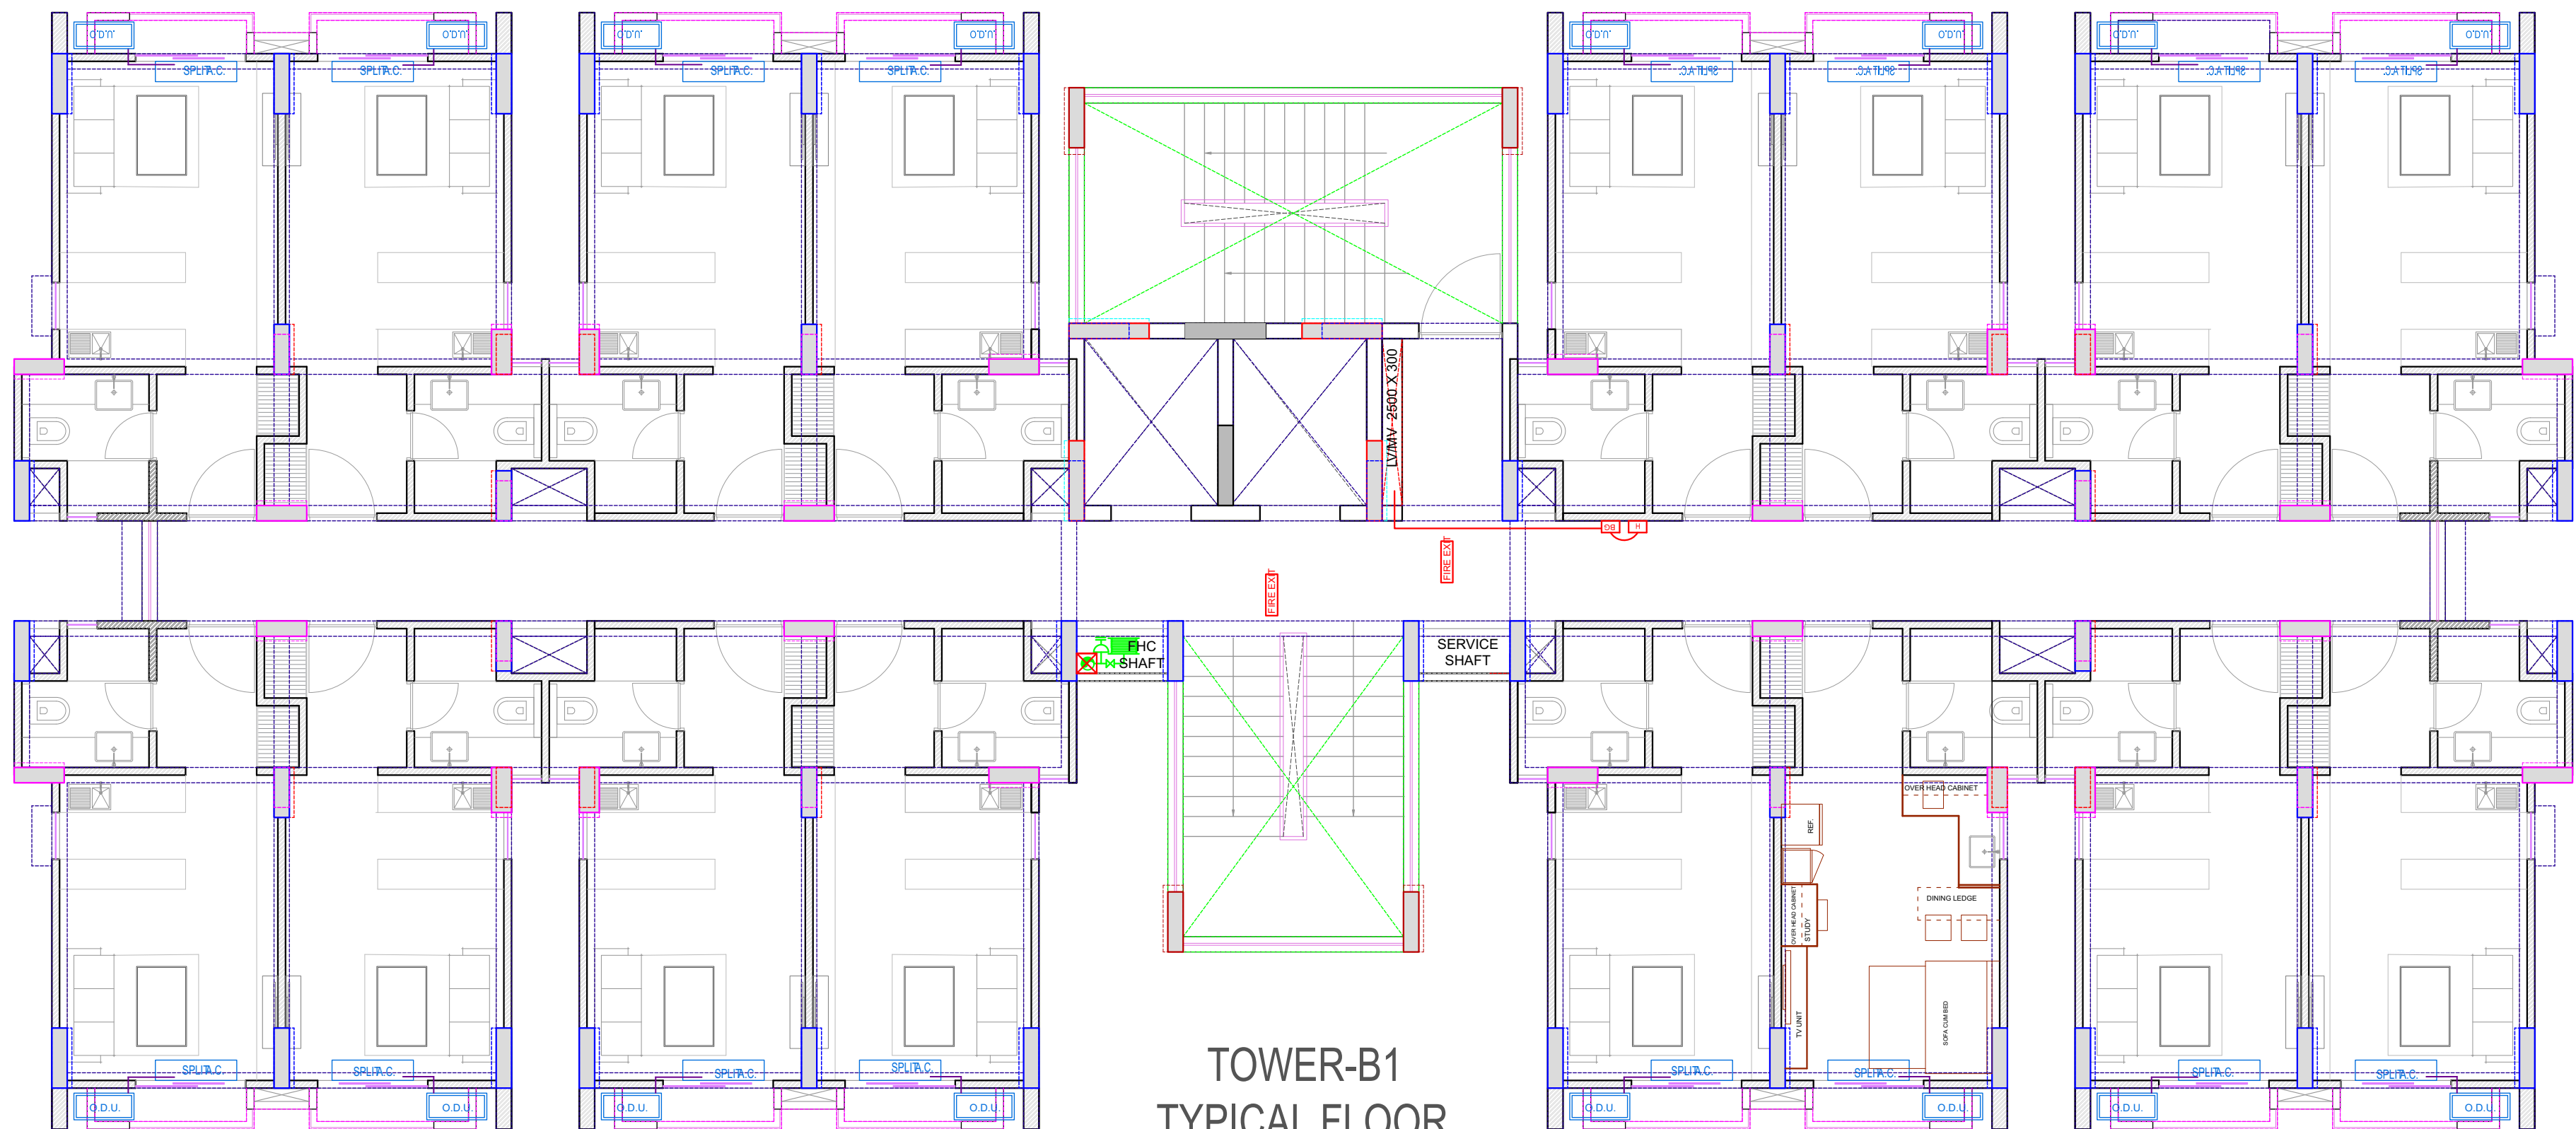

Praveen
PRAVEEN KUMAR
BTECH (ELECT)

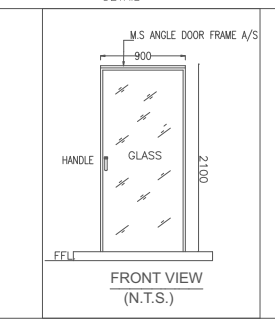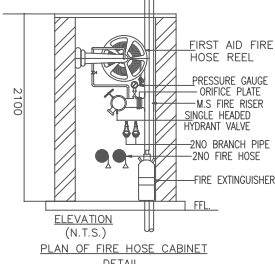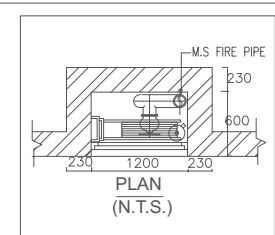

LEGEND			
NO	DESCRIPTION	SYMBOL	QTY
1.	HEAT DETECTOR		NIL
2.	SMOKE DETECTOR		NIL
3.	MANUAL CALL POINT		01 NOS
4.	HOOTER		01 NOS
5.	FIRE PANEL		NIL
6.	25MM MS CONDUIT		
7.	SELF LUMINOUS GLOW SIGN BOARD		02 NOS
8.	FIRE HYDRANT		01 NOS


Project :-
REGALIA BUILDERS
ASHADEEP RAINBOW - PHASE-IV
GROUP HOUSING-1
Village Jirota, The. Sanganer, Jaipur

TITLE:-
TYPICAL FLOOR TOWER-B-1
FIRE FIGHTING PLAN

DATE	DEALT	CHECKED
25-11-2024		
DRAWING NO:-		REV:-

SERVICES CONSULTANTS
SRAJAN ASSOCIATES
C35 LAJPT MARG
C-SCHEME JAIPUR
Email snajaipur@hotmail.com

ARCHITECT
m|a|a r c h i t e c t s pvt.ltd.

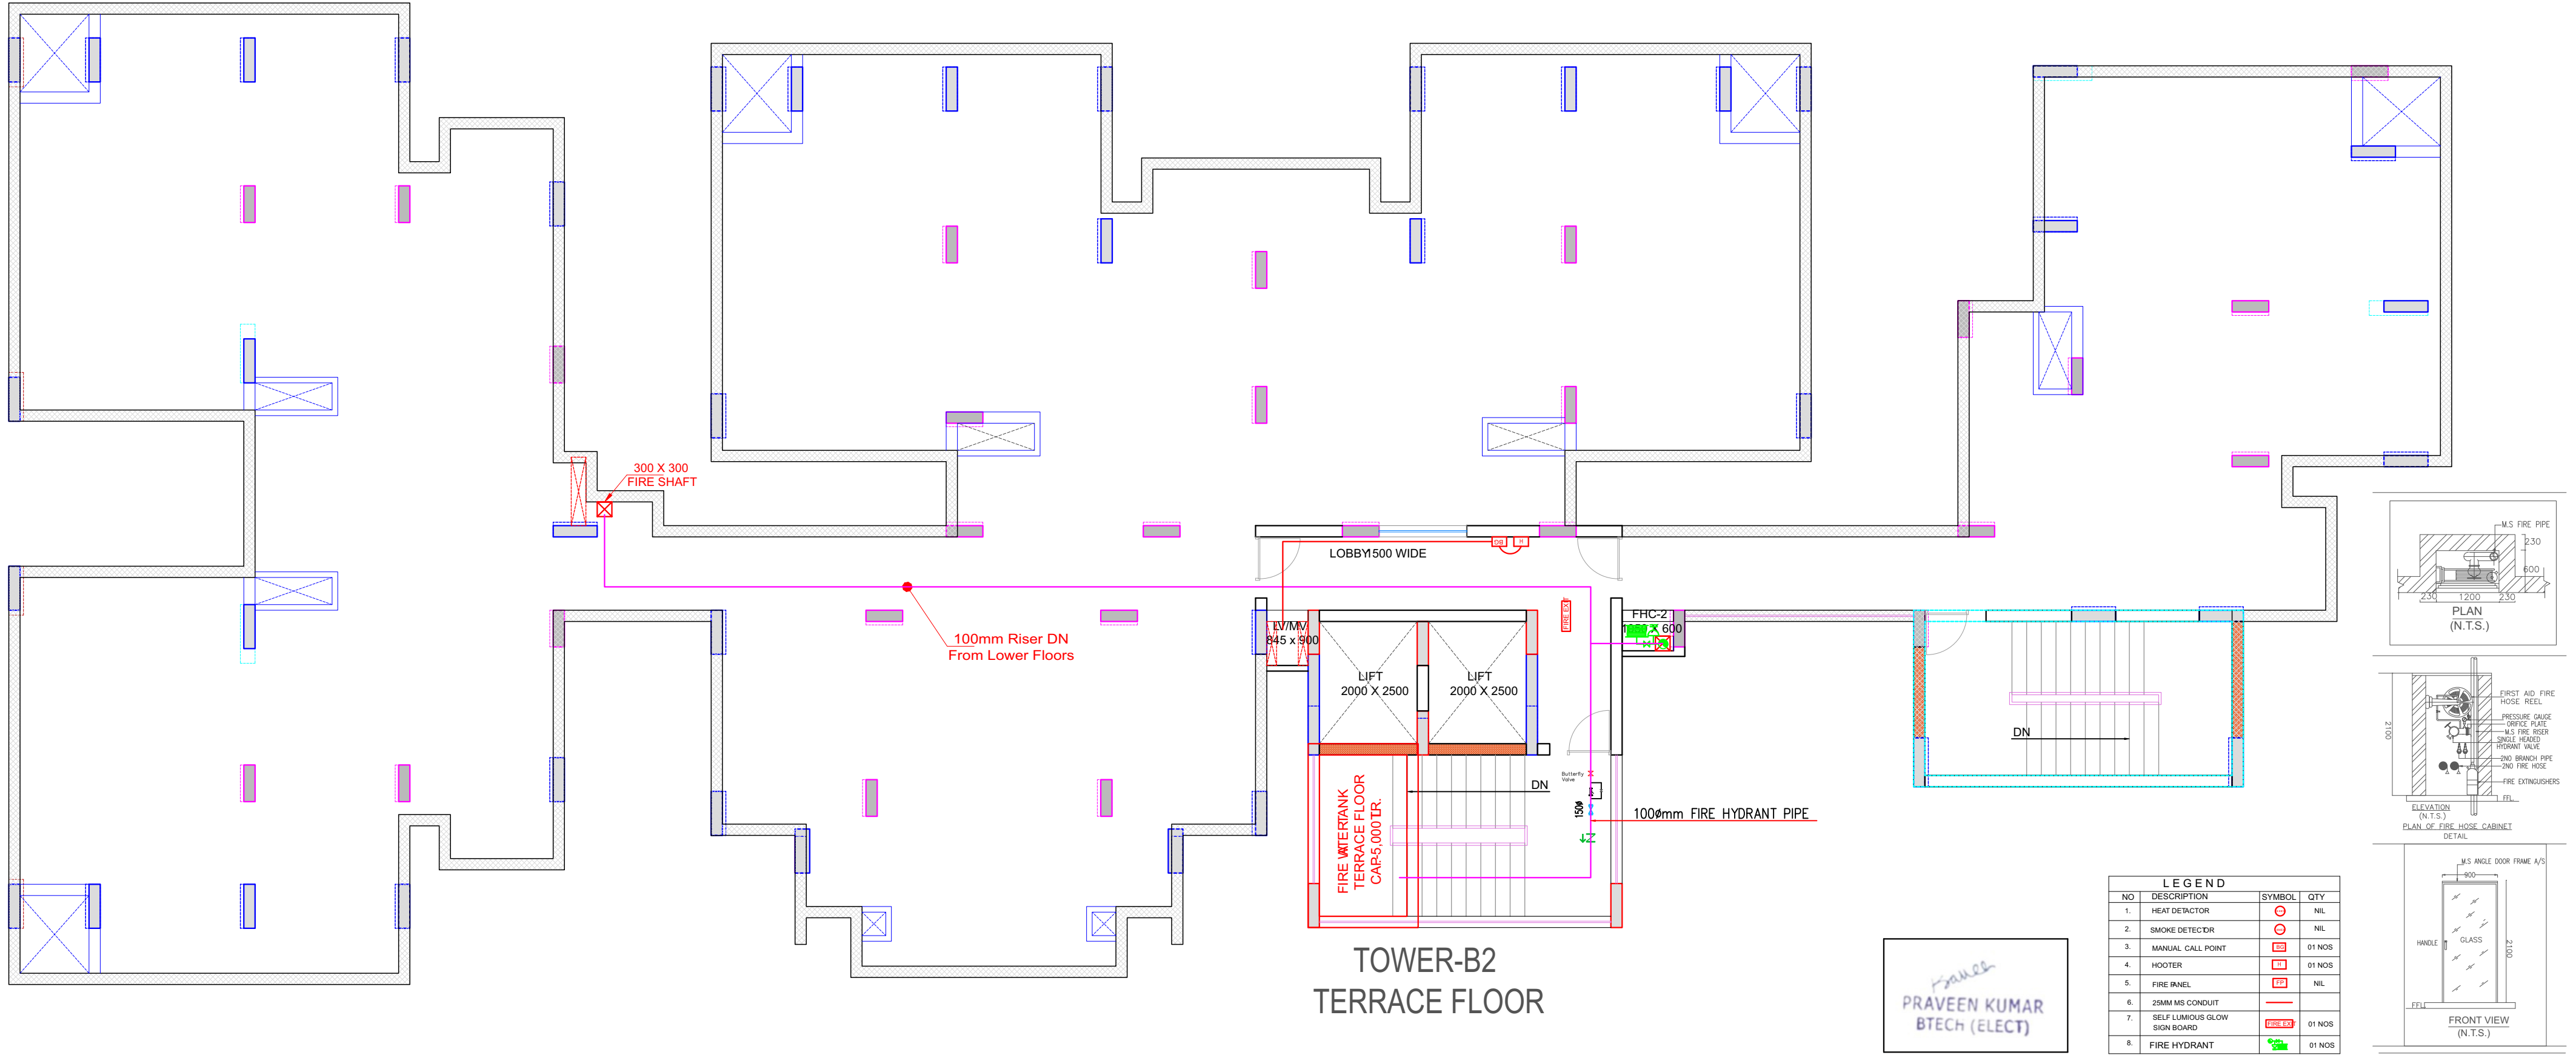


Project :- **REGALIA BUILDERS**
ASHADEEP RAINBOW - PHASE-IV
GROUP HOUSING-1
Village Jirota, The. Sanganer, Jaipur

TITLE:-
TERRACE FLOOR TOWER-B-2
FIRE FIGHTING PLAN

DATE	DEALT	CHECKED
25-11-2024		
DRAWING NO:-		REV:-

SERVICES CONSULTANTS
SRAJAN ASSOCIATES
C35 LAJPT MARG
C-SCHEME JAIPUR
Email snajaipur@hotmail.com

ARCHITECT
maarchitects pvt.ltd.
Plot No. -1, Greenwoods, Lal Kothi
Scheme, Sahkar Marg, Jaipur-302001
Tel : 91 141 4299999, 2741232
email - studio@maarchitects.in
web - www.maarchitects.in

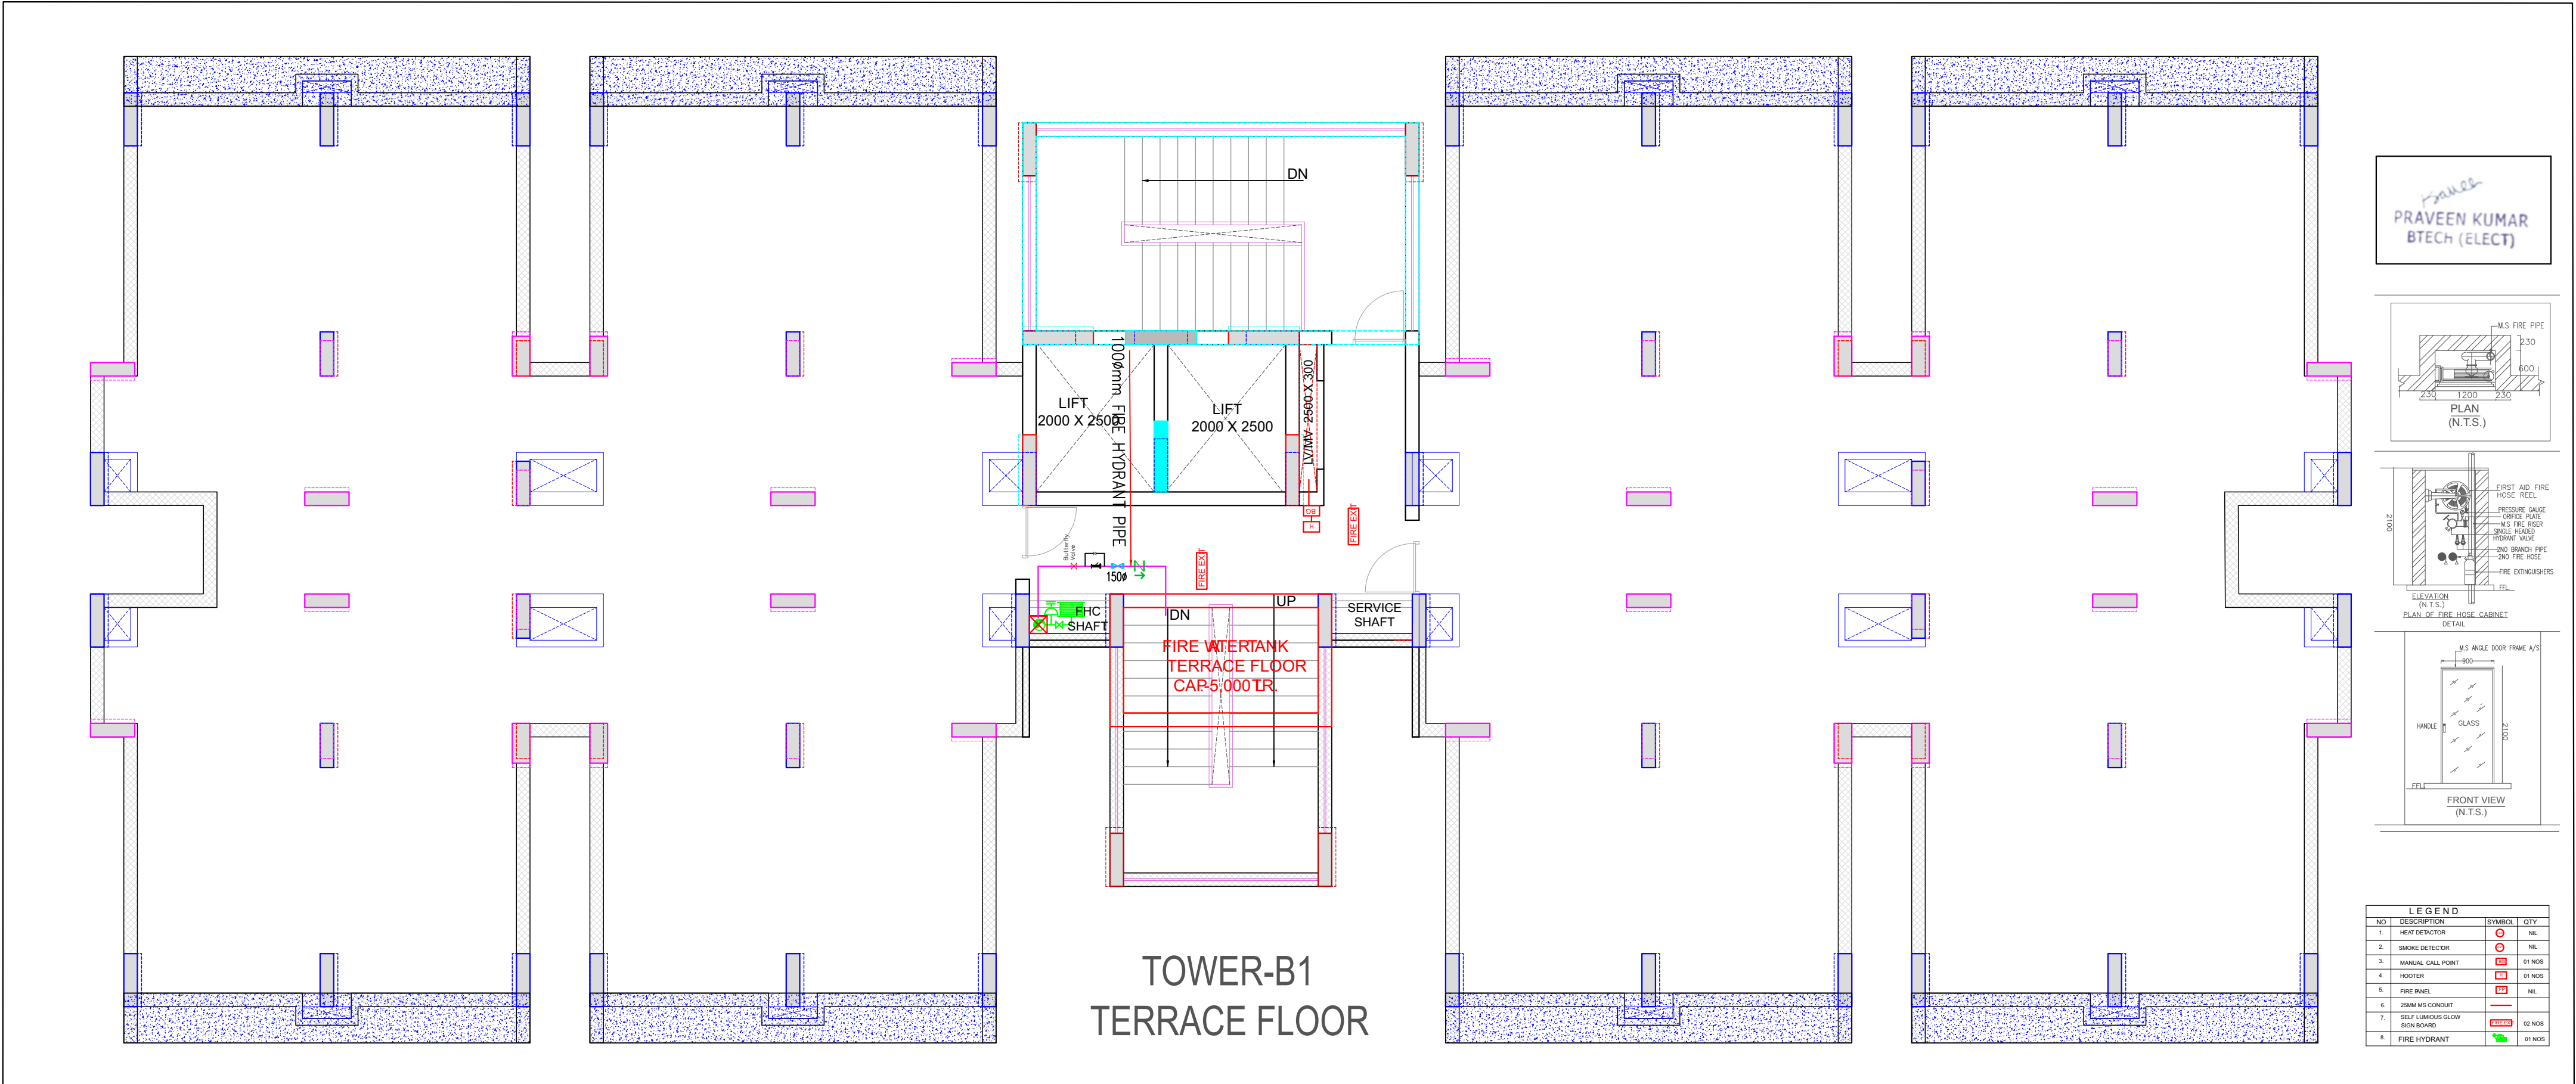

Project :-
REGALIA BUILDERS
ASHADEEP RAINBOW - PHASE-IV
GROUP HOUSING-1
Village Jirota, The. Sanganer, Jaipur

TITLE:-
TERRACE FLOOR TOWER-B-1
FIRE FIGHTING PLAN






DATE
25-11-2024
DRAWING NO:-

DEALT
CHECKED
REV:-

SERVICES CONSULTANTS
SRAJAN ASSOCIATES
C35 LAJPT MARG
C-SCHEME JAIPUR
Email snajaipur@hotmail.com


ARCHITECT
ma architects pvt.ltd.
Plot No. -1, Greenwoods, Lal Kothi Scheme,
Sahkar Marg, Jaipur-302001
Tel : 91 141 4299999, 2741232
email - studio@maarchitects.in
web - www.maarchitects.in

LEGEND	
SYMBOL	DESCRIPTION
	YARD HYDRANT (SINGLE HEADED)
	BUTTERFLY VALVE 1500
	LANDING VALVE
	HOSE REEL
	PRESSURE SWITCH
	PRESSURE GAUGE
	NON RETURN VALVE (CHECK VALVE)
	Y TYPE STRAINER
	SPRINKLER
	FLOW SWITCH
	EXPANSION BELLOW
	INLET CONNECTION
	DRAW OFF CONNECTION

 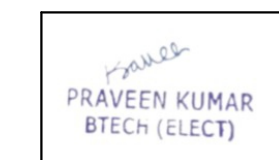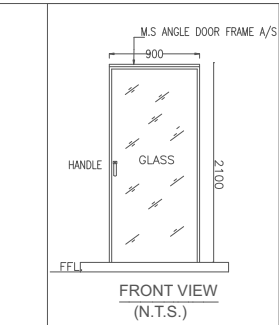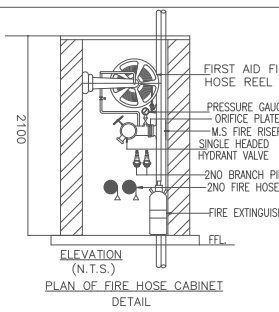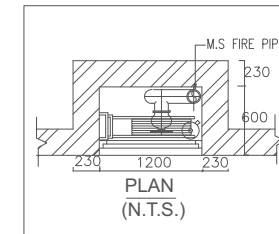

DATE : 25/11/2024

 SCALE:- NS



PROJECT	9
---------	---


REGALIA BUILDERS
ASHADEEP RAINBOW - PHASE
GROUP HOUSING-1
Village Jirota, T
he. Sanganer, Jaipur

SERVICES CONSULTANT

SRAJAN ASSOCIATES
C-35A LAJPAT MARG
JAIPUR
email - snajaipur@hotmail.com

ARCHITECTS:-

ma architects pvt.
Jaipur - Bangalore - Hyderabad
Plot No. -1, Greenwoods Lal Kothi
Scheme, Sakhar Marg, Jaipur-302001
Tel : 91 141 4299999 , 2741232
email - studio@maarchitects.in
web - www.maarchitects.in

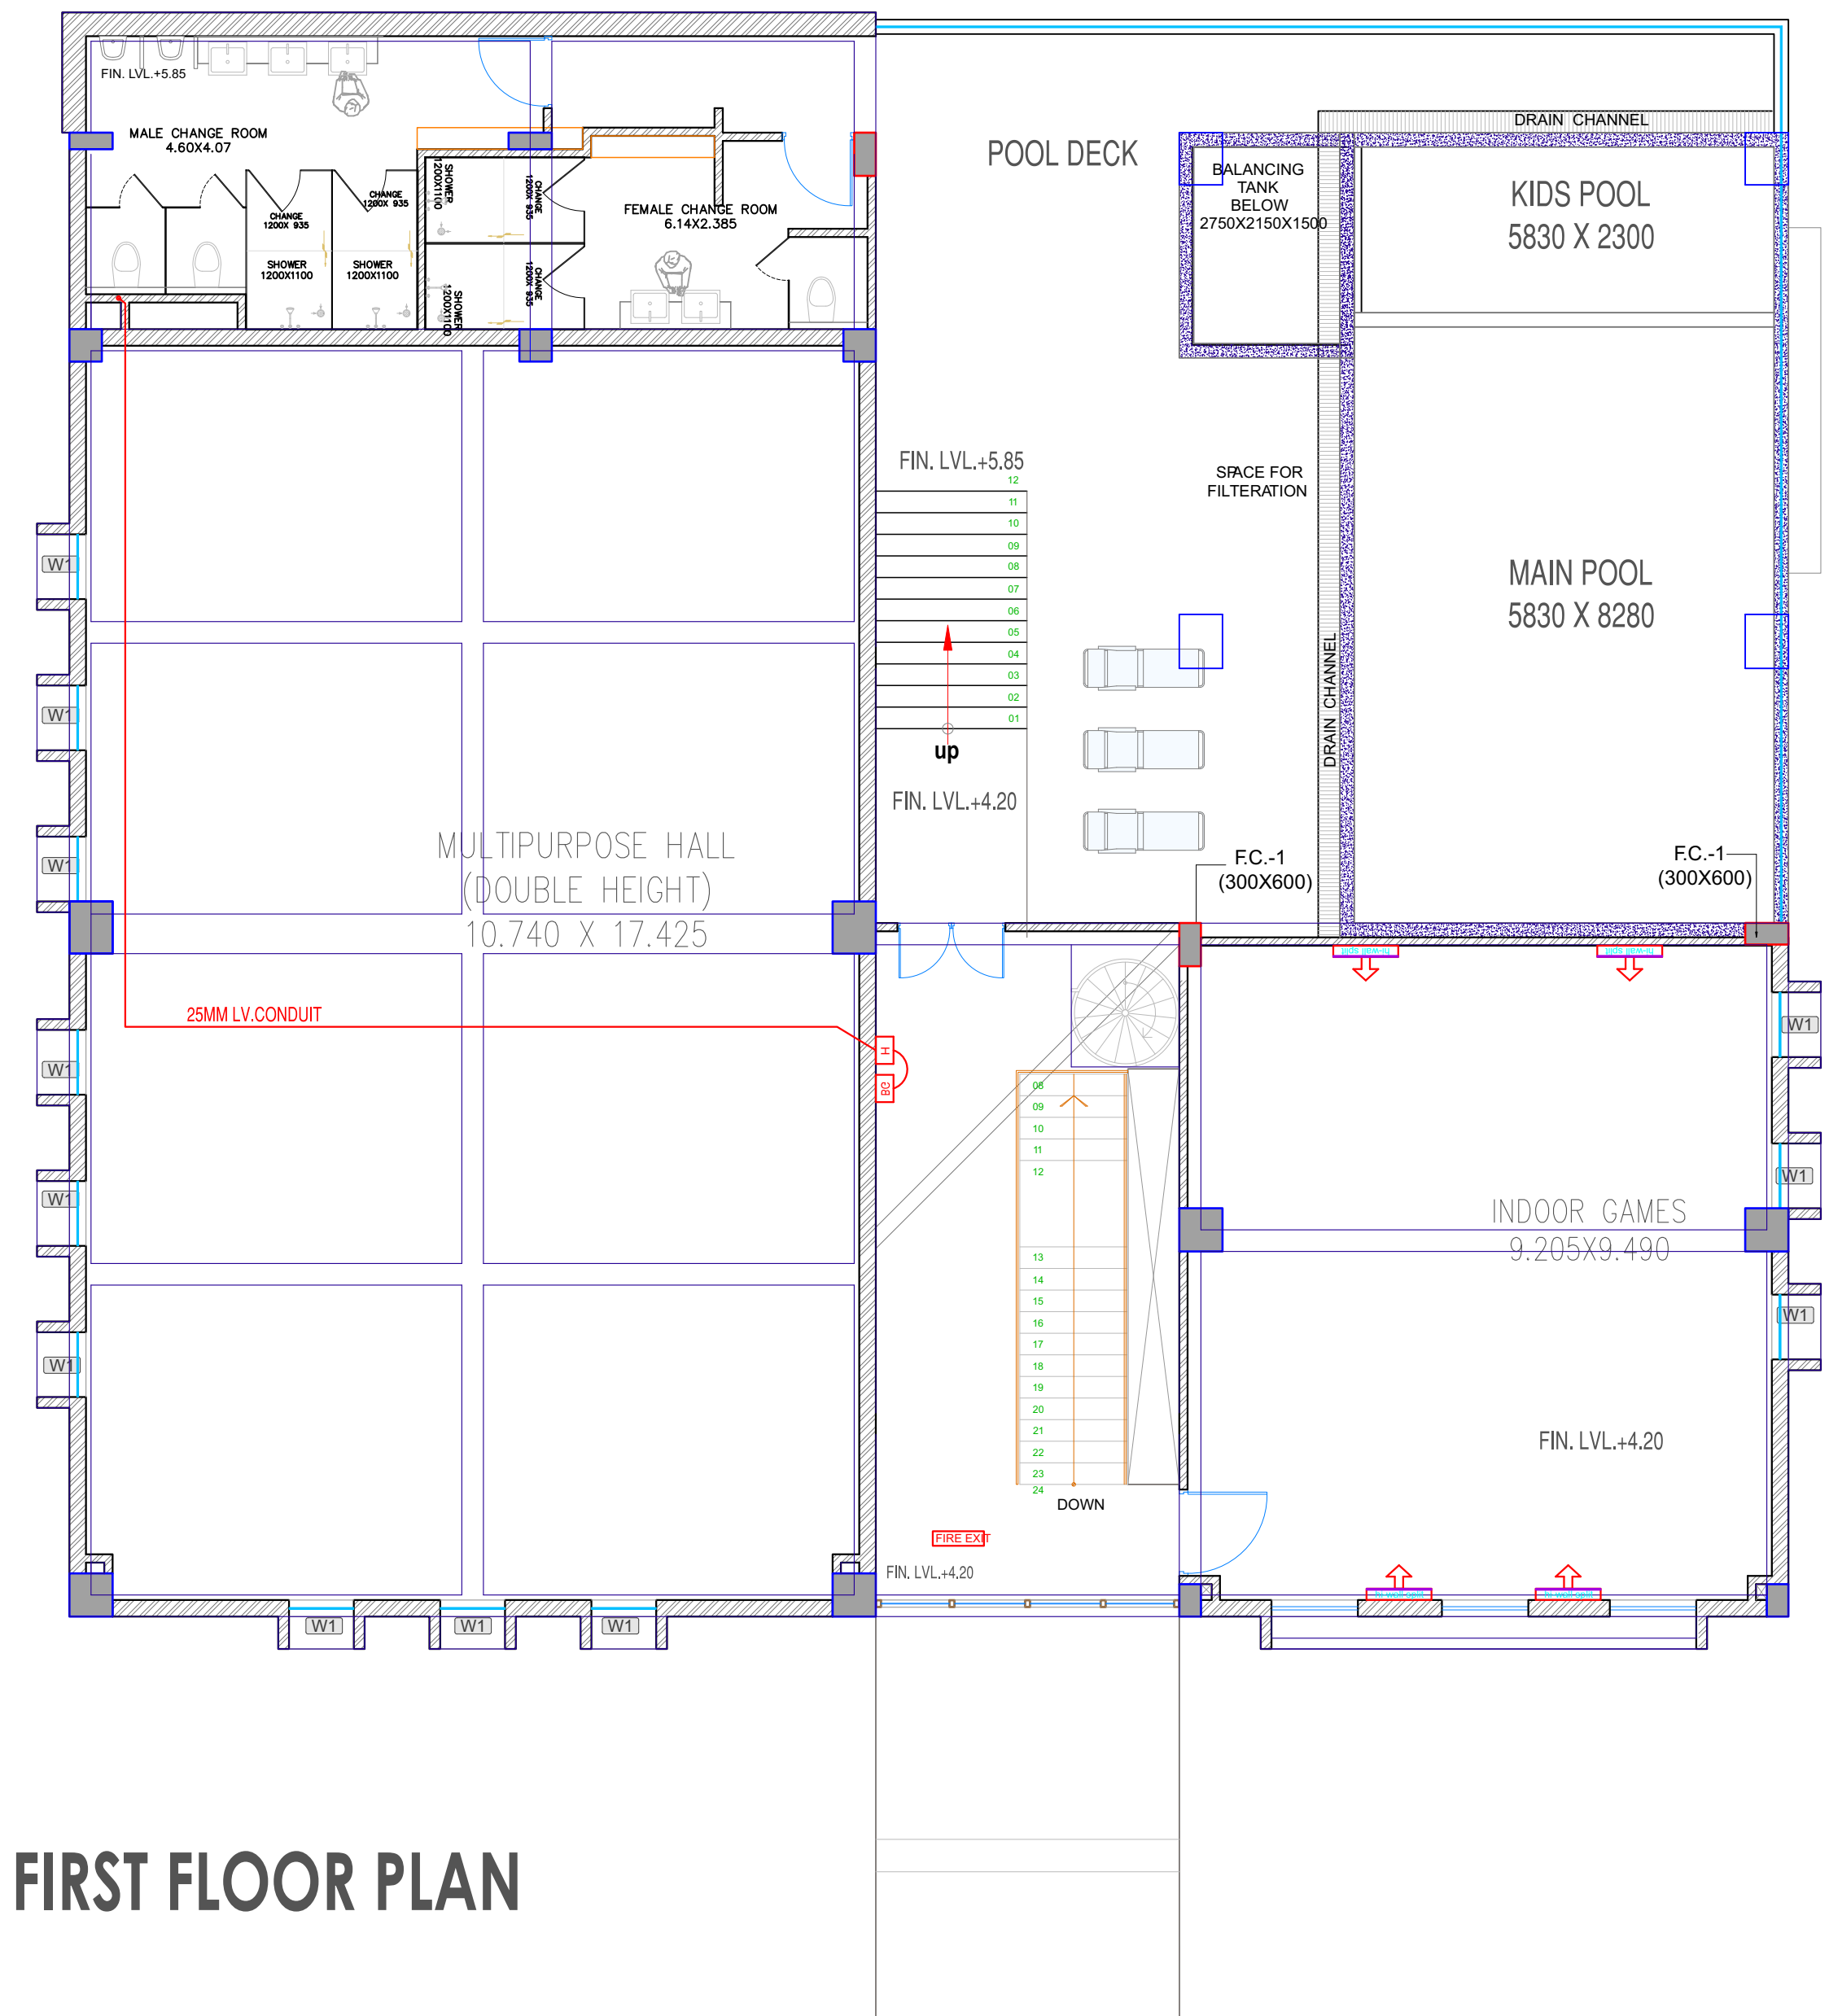

FIRST FLOOR PLAN

PROJECT
"ASHADEEP RAINBOW"
RESIDENTIAL GH-01

CLIENT
REGALIA BUILDERS
ASHADEEP RAINBOW - PHASE-IV
GROUP HOUSING-1
Village Jirota, The. Sanganer, Jaipur

ARCHITECT
m|a|r|c|h|i|t|e|c|t|s pvt. ltd.
Jaipur - Bangalore - Hyderabad
Plot No. -1, Greenwood Lal Kothi Scheme,
Sahkar Marg Jaipur-302001
Tel : 91 141 4299999
email - studio@maarchitects.in,
web - www.maarchitects.in

LEGEND			
NO	DESCRIPTION	SYMBOL	QTY
1.	HEAT DETECTOR	○	NIL
2.	SMOKE DETECTOR	○	NIL
3.	MANUAL CALL POINT	□	01 NOS
4.	HOOTER	□	01 NOS
5.	FIRE BELL	□	NIL
6.	25MM LV.CONDUIT	—	NIL
7.	SELF LUMINOUS GLOW SIGN BOARD	□	01 NOS

Praveen
PRAVEEN KUMAR
BTECH (ELECT)

SERVICES CONSULTANT :
SRAJAMSSOCIETIES
C-SCHEME, JAIPUR
snajaipur@hotmail.com

DRAWN BY
CHECKED BY

NORTH:

SCALE :
25-1-2024

DRAWING TITLE :
FIRST FLOOR FIRE FIGHTING PLAN

PROJECT NO. :
GC-5007

REV NO :
DRAWING NO. :

