


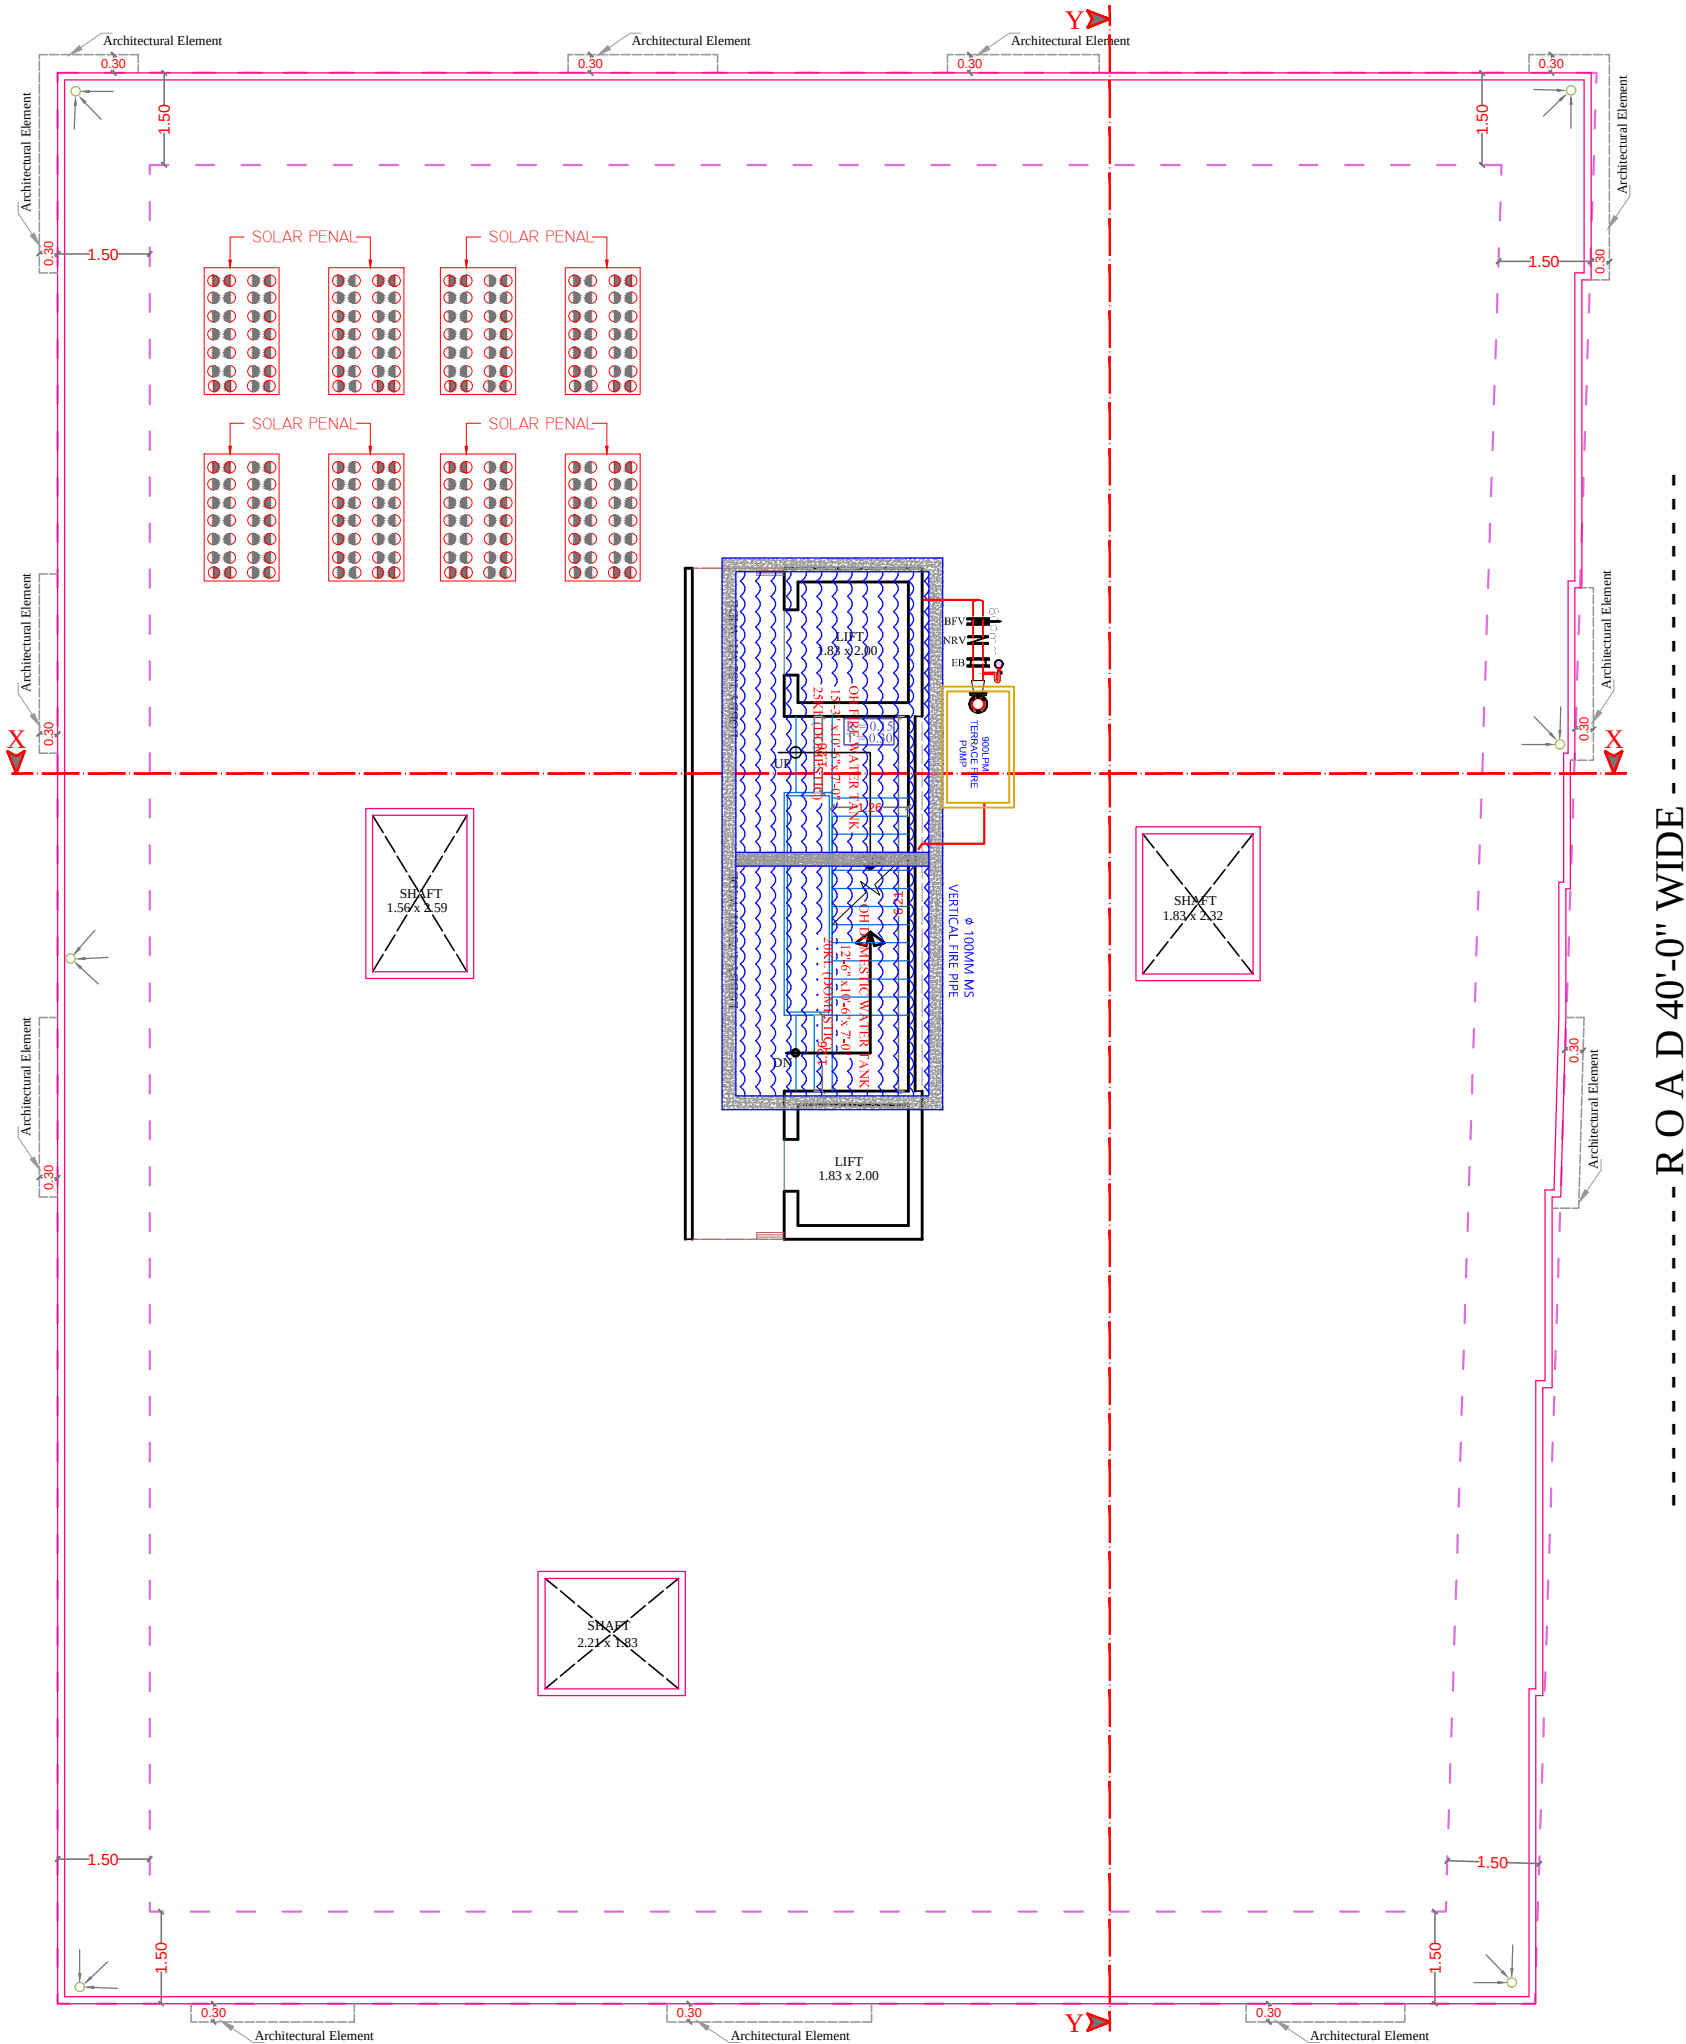


TERRACE FLOOR PLAN

RAMESH KUMAWAT
M.E.P. CONSULTANT
B.E. CIVIL

LEGENDS:			
SR NO.	Symbol	Description	Qty.
1.		HYDRANT	00
2.		HOSE REEL	00
3.		HOSE BOX	01
4.		FOUR WAY	00
5.		FIRE PUMP	01
6.		WATER TANK	01

PROJECT TITLE :- PROPOSED BUILDING AT PLOT NO.16,17,18,19,20 &21 GANGA VIHAR ENCLAVE, JAIPUR	DRAWING TITLE :- TARRACE FLOOR FIRE FIGHTING	SPACE CONSULTANT PLOT-A-173, JAGDAMBA NAGAR, HEERAPURA POWER HOWER, JAIPUR (RAJ) 302024	DRN. BY			NORTH
					DATE	
			APPD. BY		REVISION	
			SCALE			

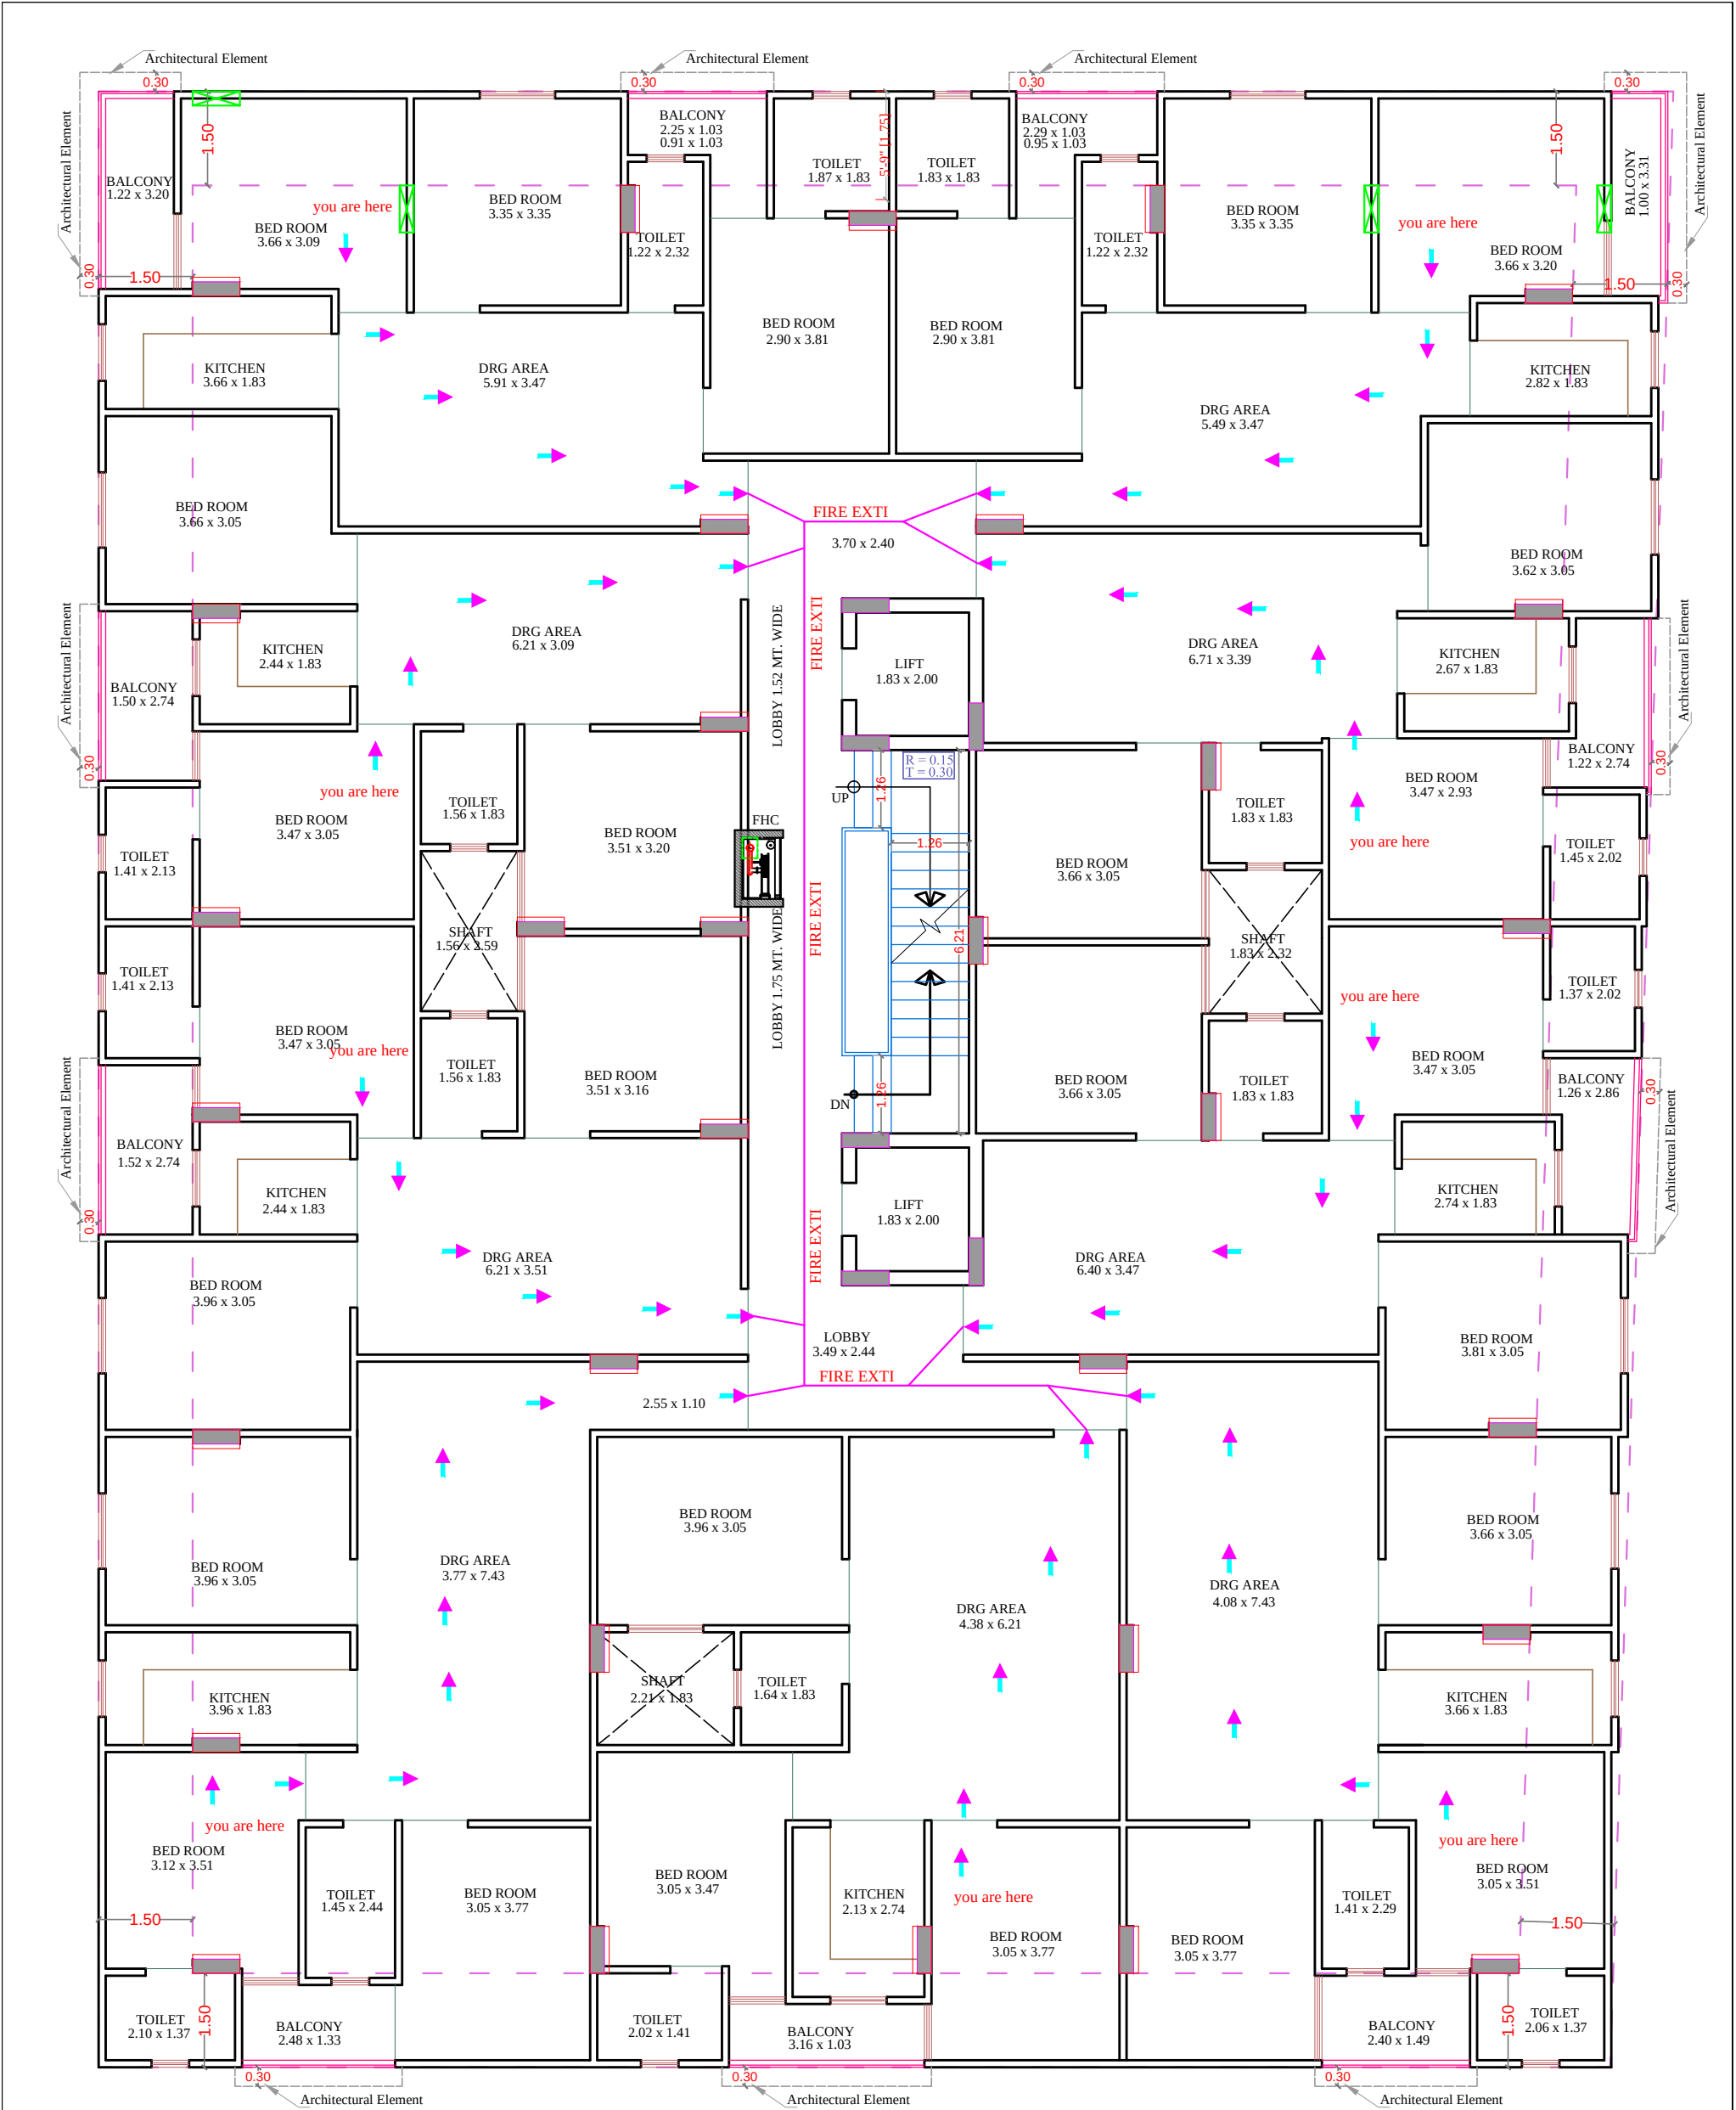

Ramesh Kumawat
RAMESH KUMAWAT
M.E.P. CONSULTANT
B.E. CIVIL

PROJECT TITLE :-
PROPOSED BUILDING AT PLOT
NO.16,17,18,19,20 &21 GANGA
VIHAR ENCLAVE, JAIPUR

DRAWING TITLE :-
TYPICAL FLOOR
FIRE FIGHTING LAYOUT

SPACE CONSULTANT

PLOT-A-173, JAGDAMBA NAGAR, HEERAPURA
POWER HOWER, JAIPUR (RAJ) 302024

DRN. BY

APPD. BY

SCALE

DATE

REVISION

N.T.S

NORTH