
 
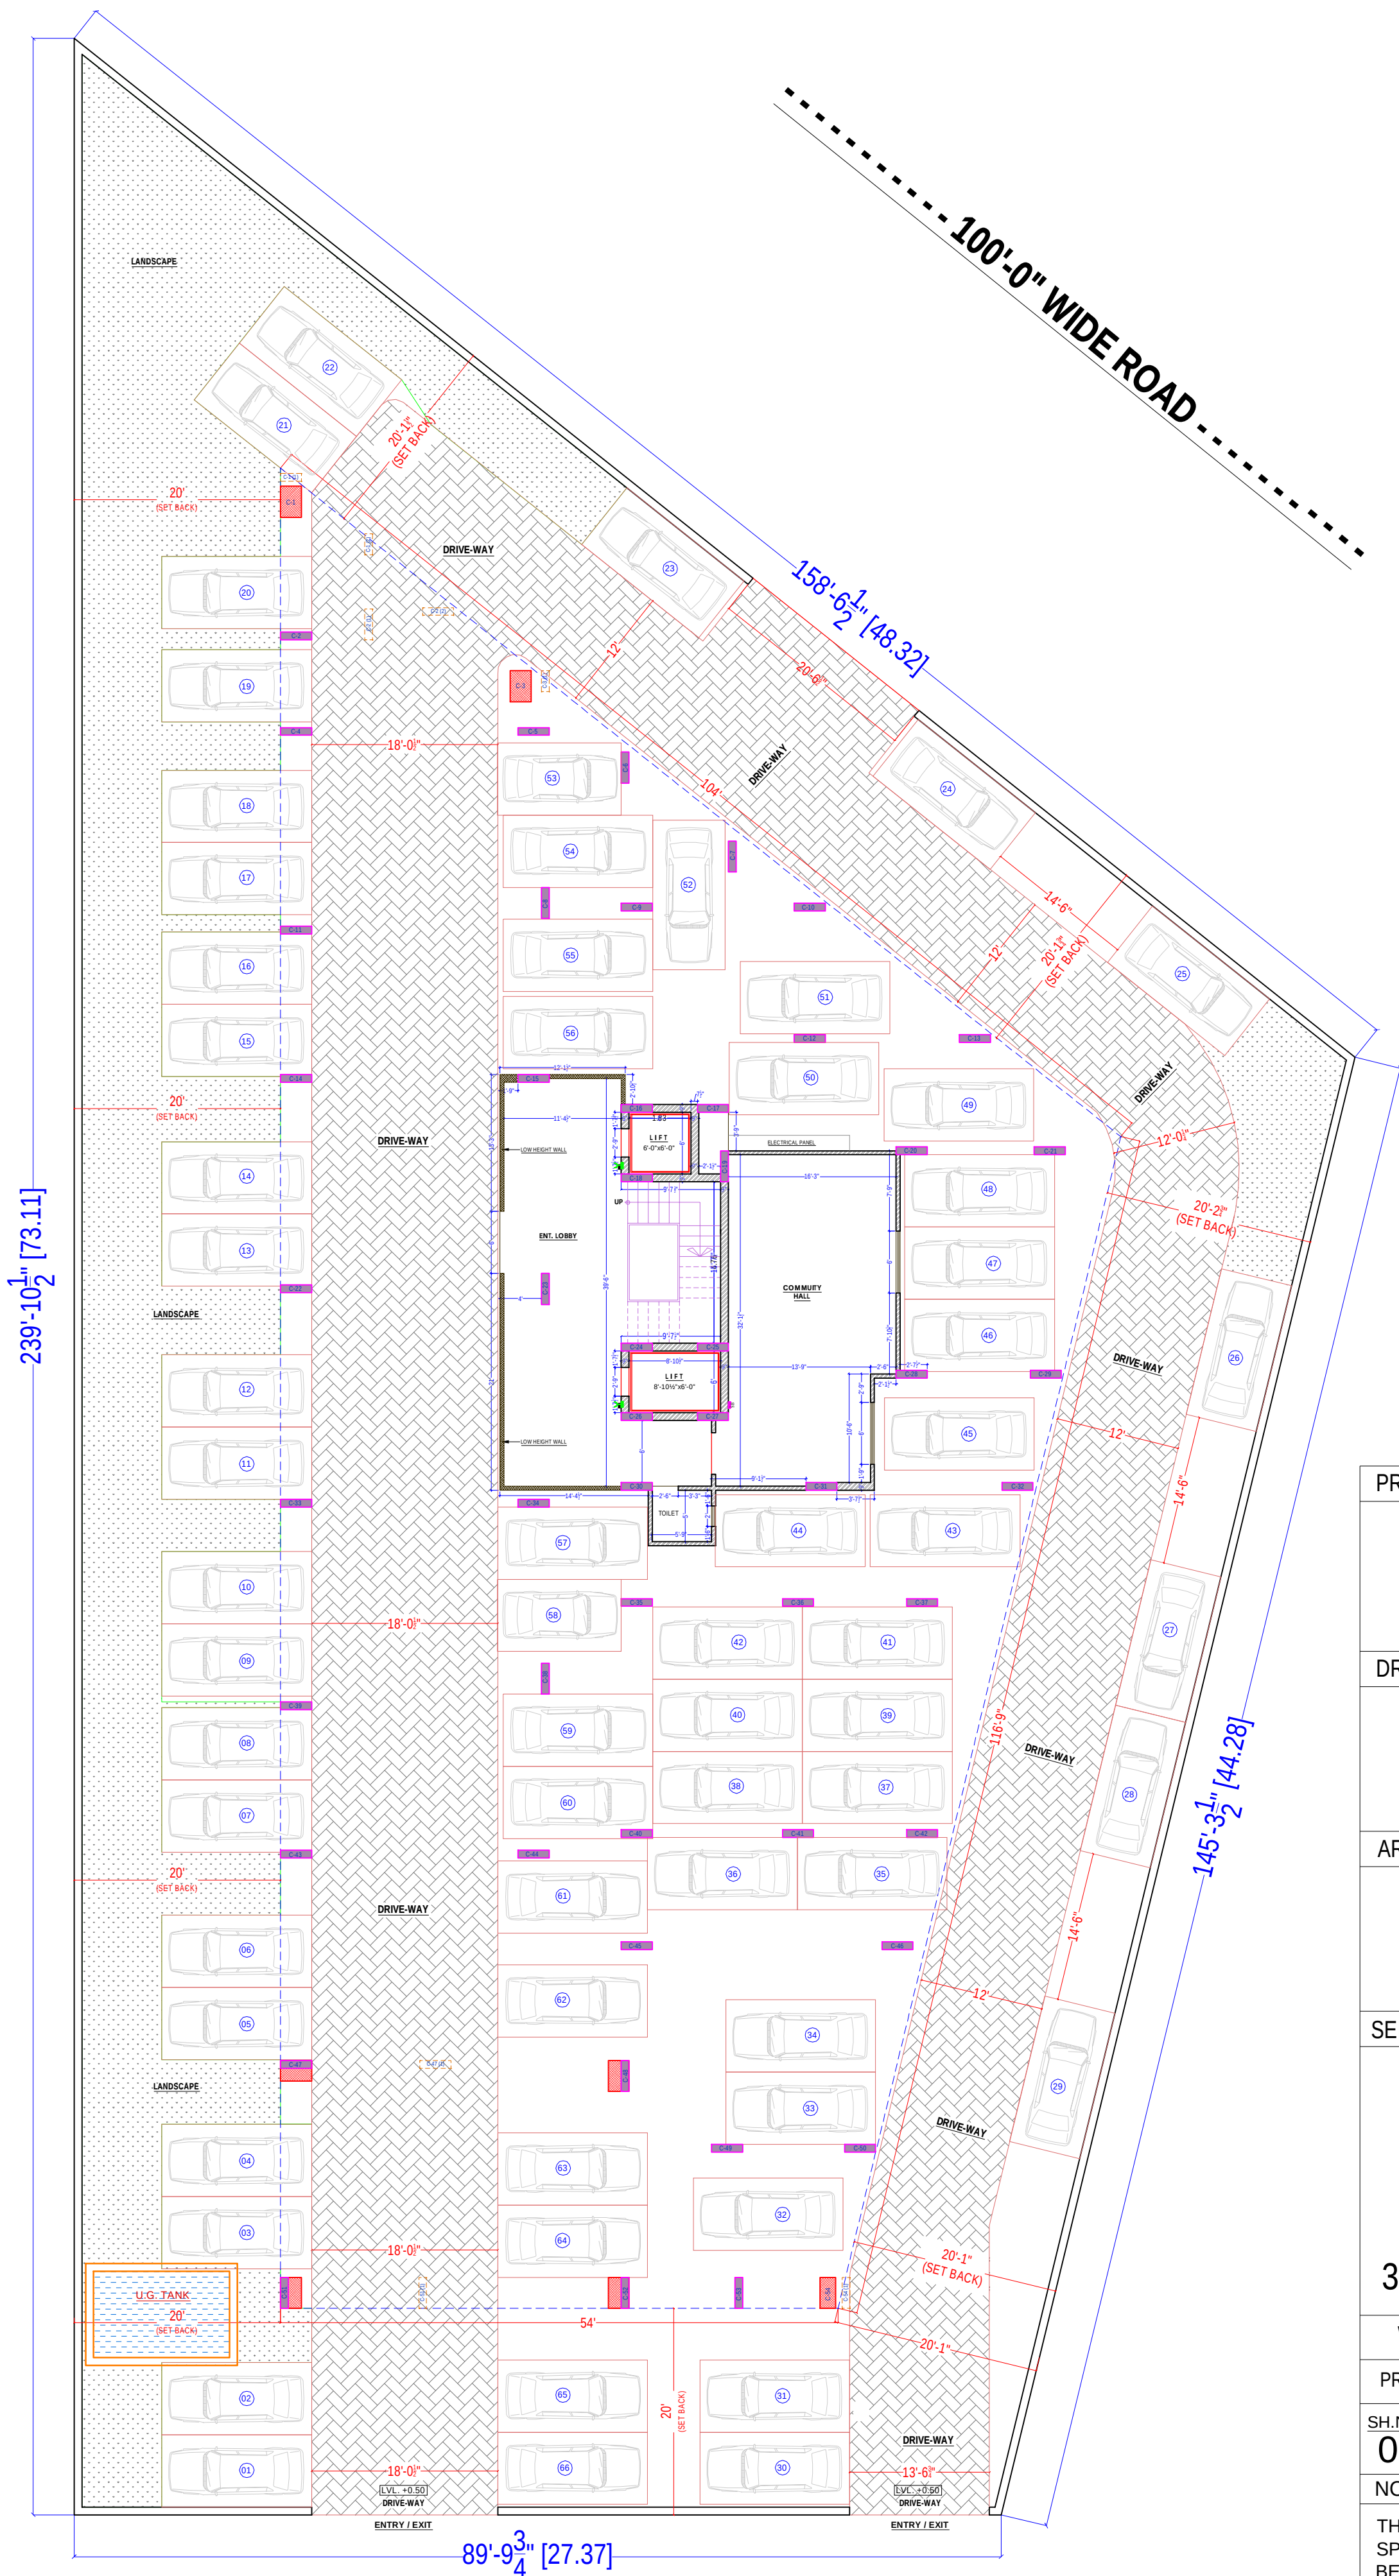




STILT FLOOR PLAN

SECTOR ROAD 30.00 M WIDE

PROJECT:	
THE PEAK PROPOSED RESIDENTIAL BUILDING AT KHASRA NO. - 29/1, AT VILLAGE - GRIDHARIPURA, JAIPUR.	
DRAWING:	
UNDER GROUND TANK LOCATION PLAN	
ARCHITECT:	
 ARCHITECTS, INTERIOR DESIGNERS AND ENGINEERS	
SERVICES CONSULTANT:	
 Naman Yadav B.Tech (Service Consultant)	
344,Mansarovar plaza,Jaipur	
WORKING LAYOUT PLAN	
PROPOSAL PLAN	
SH.NO. 01	SCALE: NTS
NOTE	
THIS DRAWING IS THE SOLE PROPERTY OF SPACE EDGE ARCHITECTS AND IS NOT TO BE COPIED, USED OR REPRODUCED FOR ANY PURPOSE OTHER THAN FOR WHICH IT HAS BEEN LOANED.	

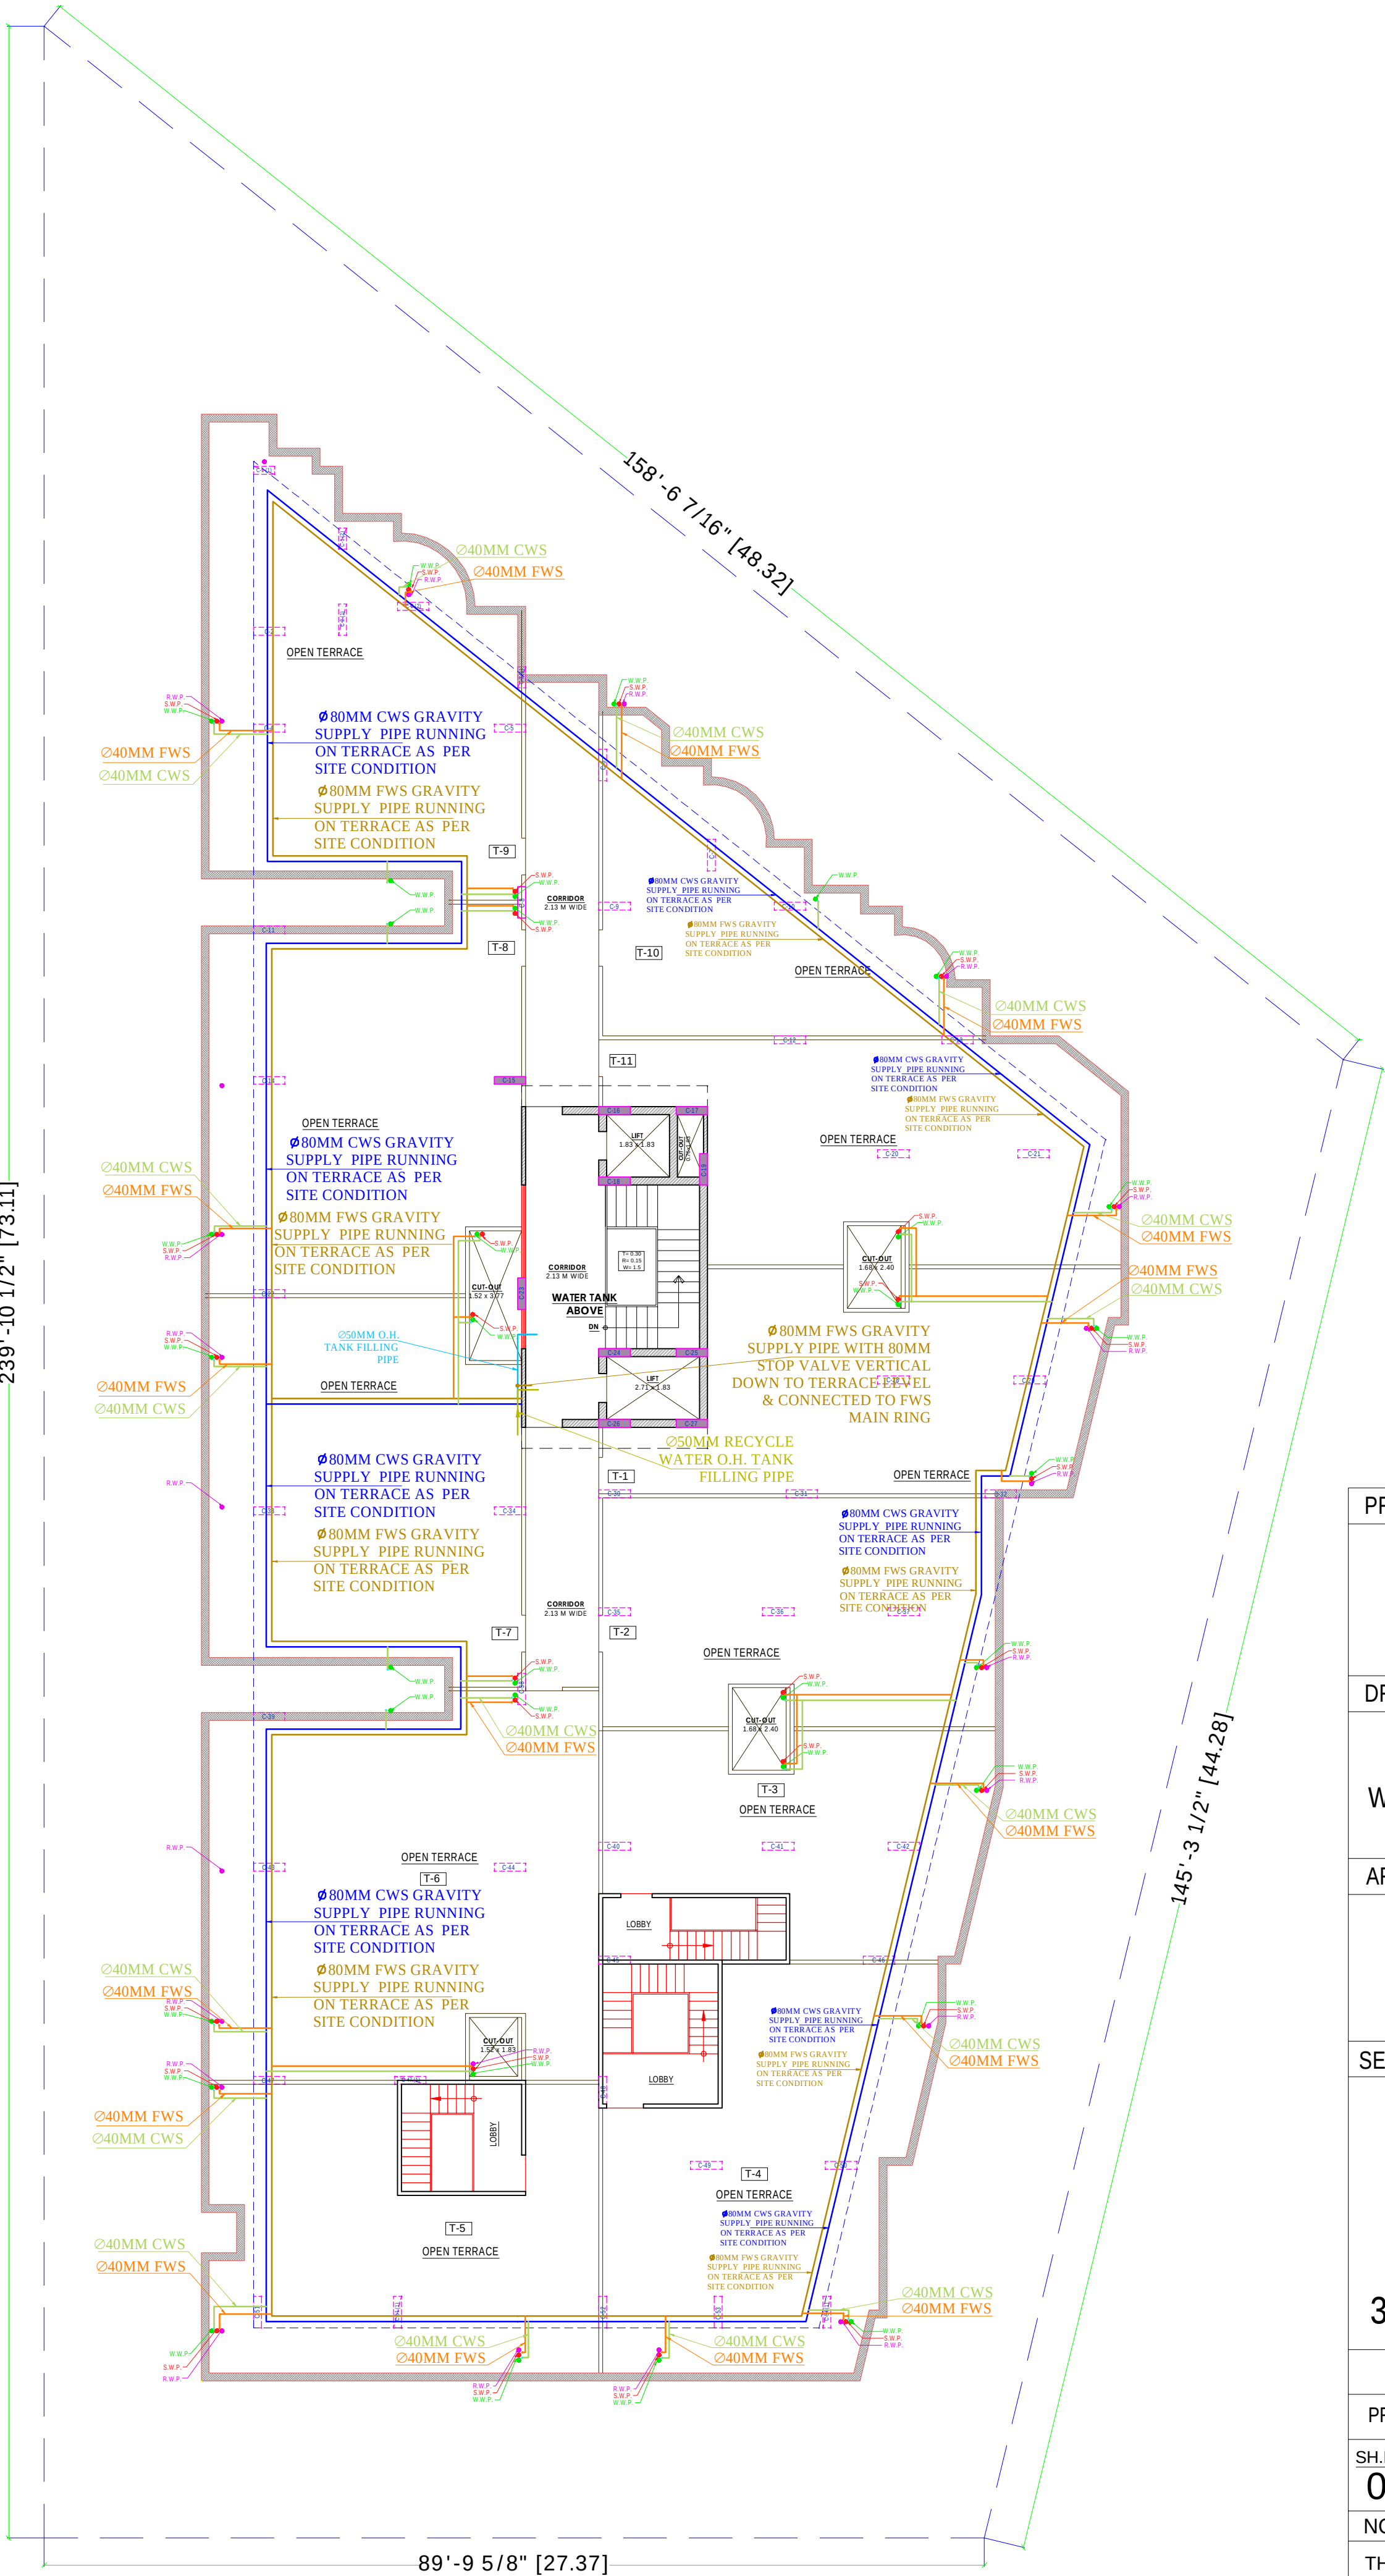

TERRACE FLOOR - WATER SUPPLY PIPE ROUTE PLAN

TOILET- 6NOS	
CWS DOWNTAKE DETAIL 40MM-5TH &4TH FLOOR 32MM-3RD, 2ND& 1ST FLOOR 25MM-GRD FLR ONLY	
FWS DOWNTAKE DETAIL 40MM- 5TH FLR 32MM-4TH,3RD, 2ND& 1ST FLR 25MM- GRD FLR ONLY	
KITCHEN- 6NOS	
CWS DOWNTAKE DETAIL 40MM- 5TH &4TH FLR 32MM- 3RD, 2ND & 1ST FLR 25MM- GRD FLR ONLY	
TOILET- 12NOS	
CWS DOWNTAKE DETAIL 40MM-5TH,4TH & 3RD FLOOR 32MM- 2ND,1ST & GRD FLOOR	
FWS DOWNTAKE DETAIL 40MM- 5TH FLR 32MM-4TH,3RD, 2ND& 1ST FLR 25MM- GRD FLR ONLY	
SYMBOL	DESCRIPTION
	Valve According to Pipe Size
	Ø80 MM CWS PIPE
	Ø40 MM CWS PIPE
	Ø80 MM FWS PIPE
	Ø40 MM FWS PIPE
	Ø50 MM RAW OHT FILLING PIPE
	Ø50 MM RECYCLE OHT FILLING PIPE

PROJECT:

THE PEAK

PROPOSED RESIDENTIAL BUILDING AT
KHASRA NO. - 29/1, AT VILLAGE -
GRIDHARIPURA, JAIPUR.

DRAWING:

TERRACE FLOOR
WATER SUPPLY PIPE ROUTE PLAN

ARCHITECT:

ARCHITECTS, INTERIOR DESIGNERS AND ENGINEERS

SERVICES CONSULTANT:

Naman Yadav
B.Tech (Service Consultant)

344,Mansarovar plaza,Jaipur

WORKING LAYOUT PLAN

PROPOSAL PLAN

SH.NO.
01

SCALE: NTS

NOTE

THIS DRAWING IS THE SOLE PROPERTY OF
SPACE EDGE ARCHITECTS AND IS NOT TO
BE COPIED, USED OR REPRODUCED FOR
ANY PURPOSE OTHER THAN FOR WHICH IT
HAS BEEN LOANED.