


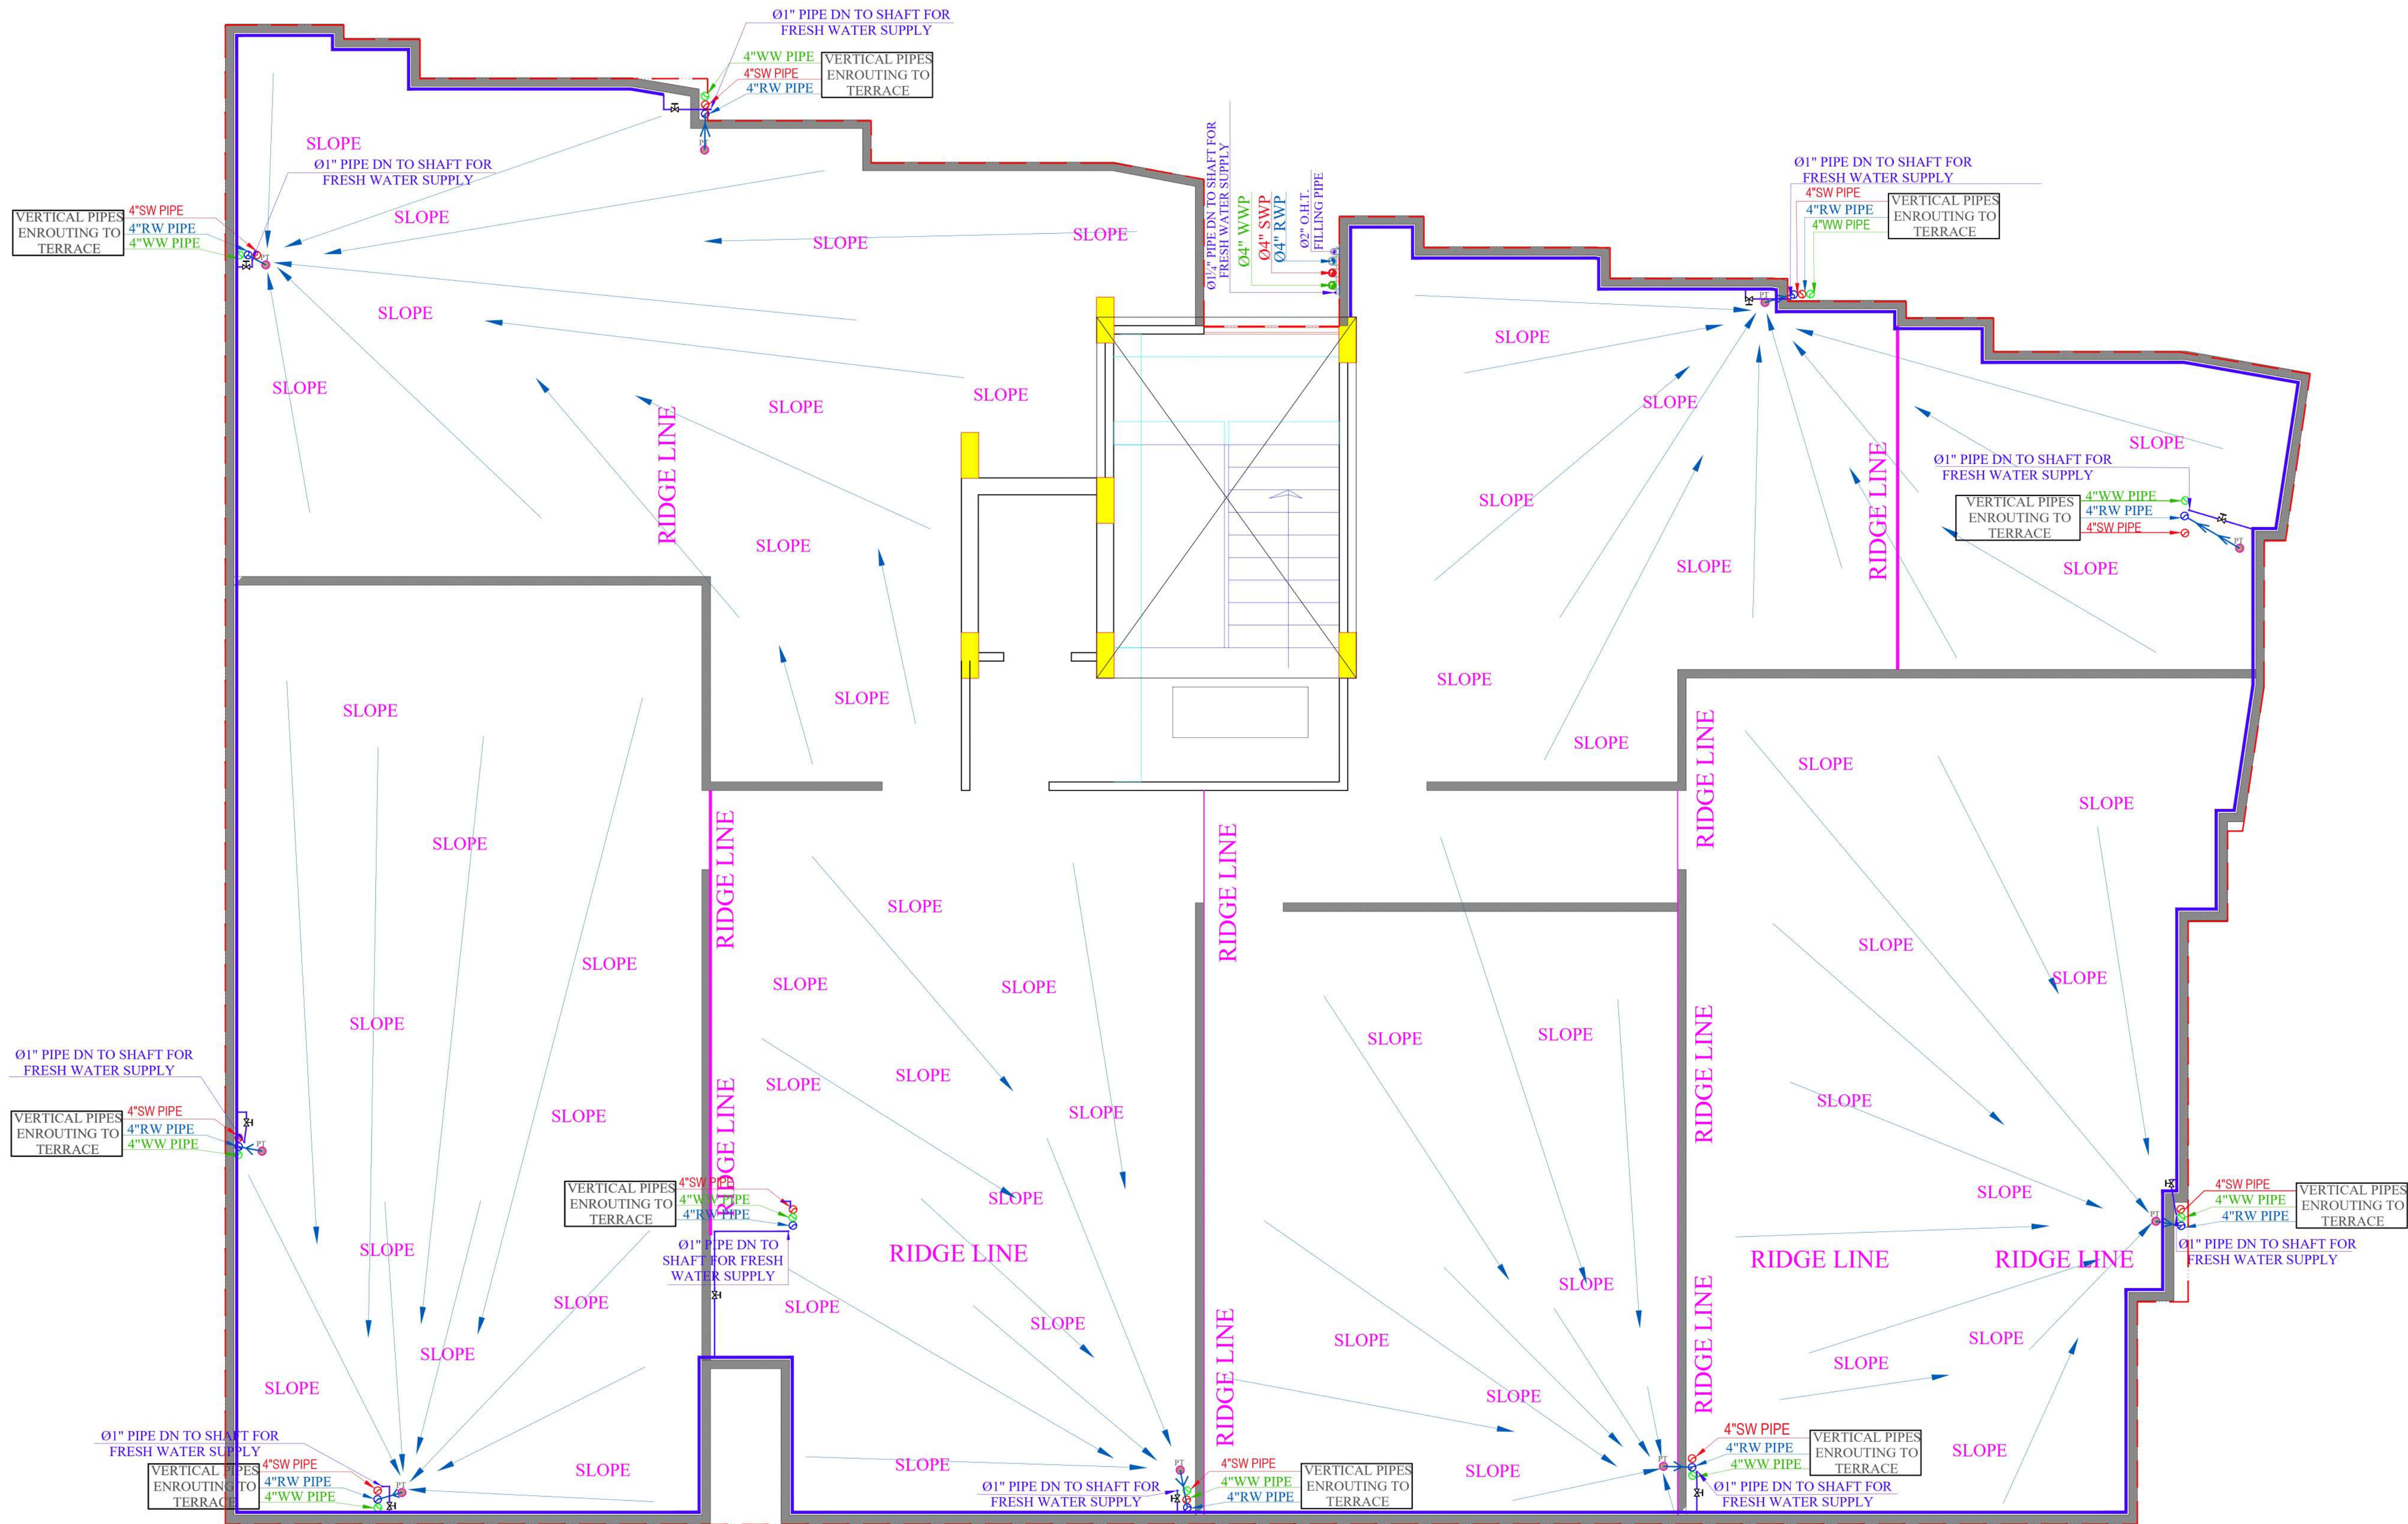

TERRACE FLOOR PLAN

SPECIFICATION:-

1. THIS DRAWING IS THE PROPERTY OF AND SHALL NOT BE USED OR PRODUCE IN ANY MANNER WITHOUT HIS WRITTEN PERMISSION.
2. DIMENSIONS ON THE DRAWINGS ARE TO BE READ NOT SCALED.
3. THE EXECUTING AGENCY IS REQUIRED TO CORRELATE ALL RELEVANT DRAWINGS AND ANY ERRORS OR DISCREPANCIES ARE TO BE BROUGHT TO THE NOTICE OF BEFORE COMMENCE OF WORK

PROJECT TITLE:-

JC HEIGHTS 09
C-11 & C-12(NORTH)
NARAYAN PURI 'C',
JAIPUR , RAJASTHAN

CONSULTANTS:-

Er. Sanjay Yadav

CHECKED BY:-

Ar. Vikram Jangid

SIGNATURE:-


DRAWN BY:-

Vivek

SCALE:- DATE:-

N.T.S. 01/05/2026


NORTH SHEET:-

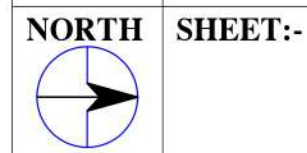

SHEET TITLE:-
TERRACE DRAINAGE AND WATER SUPPLY
ROUTE PLAN

SIGNATURES:-

Sanjay Yadav
B.TECH (CIVIL)

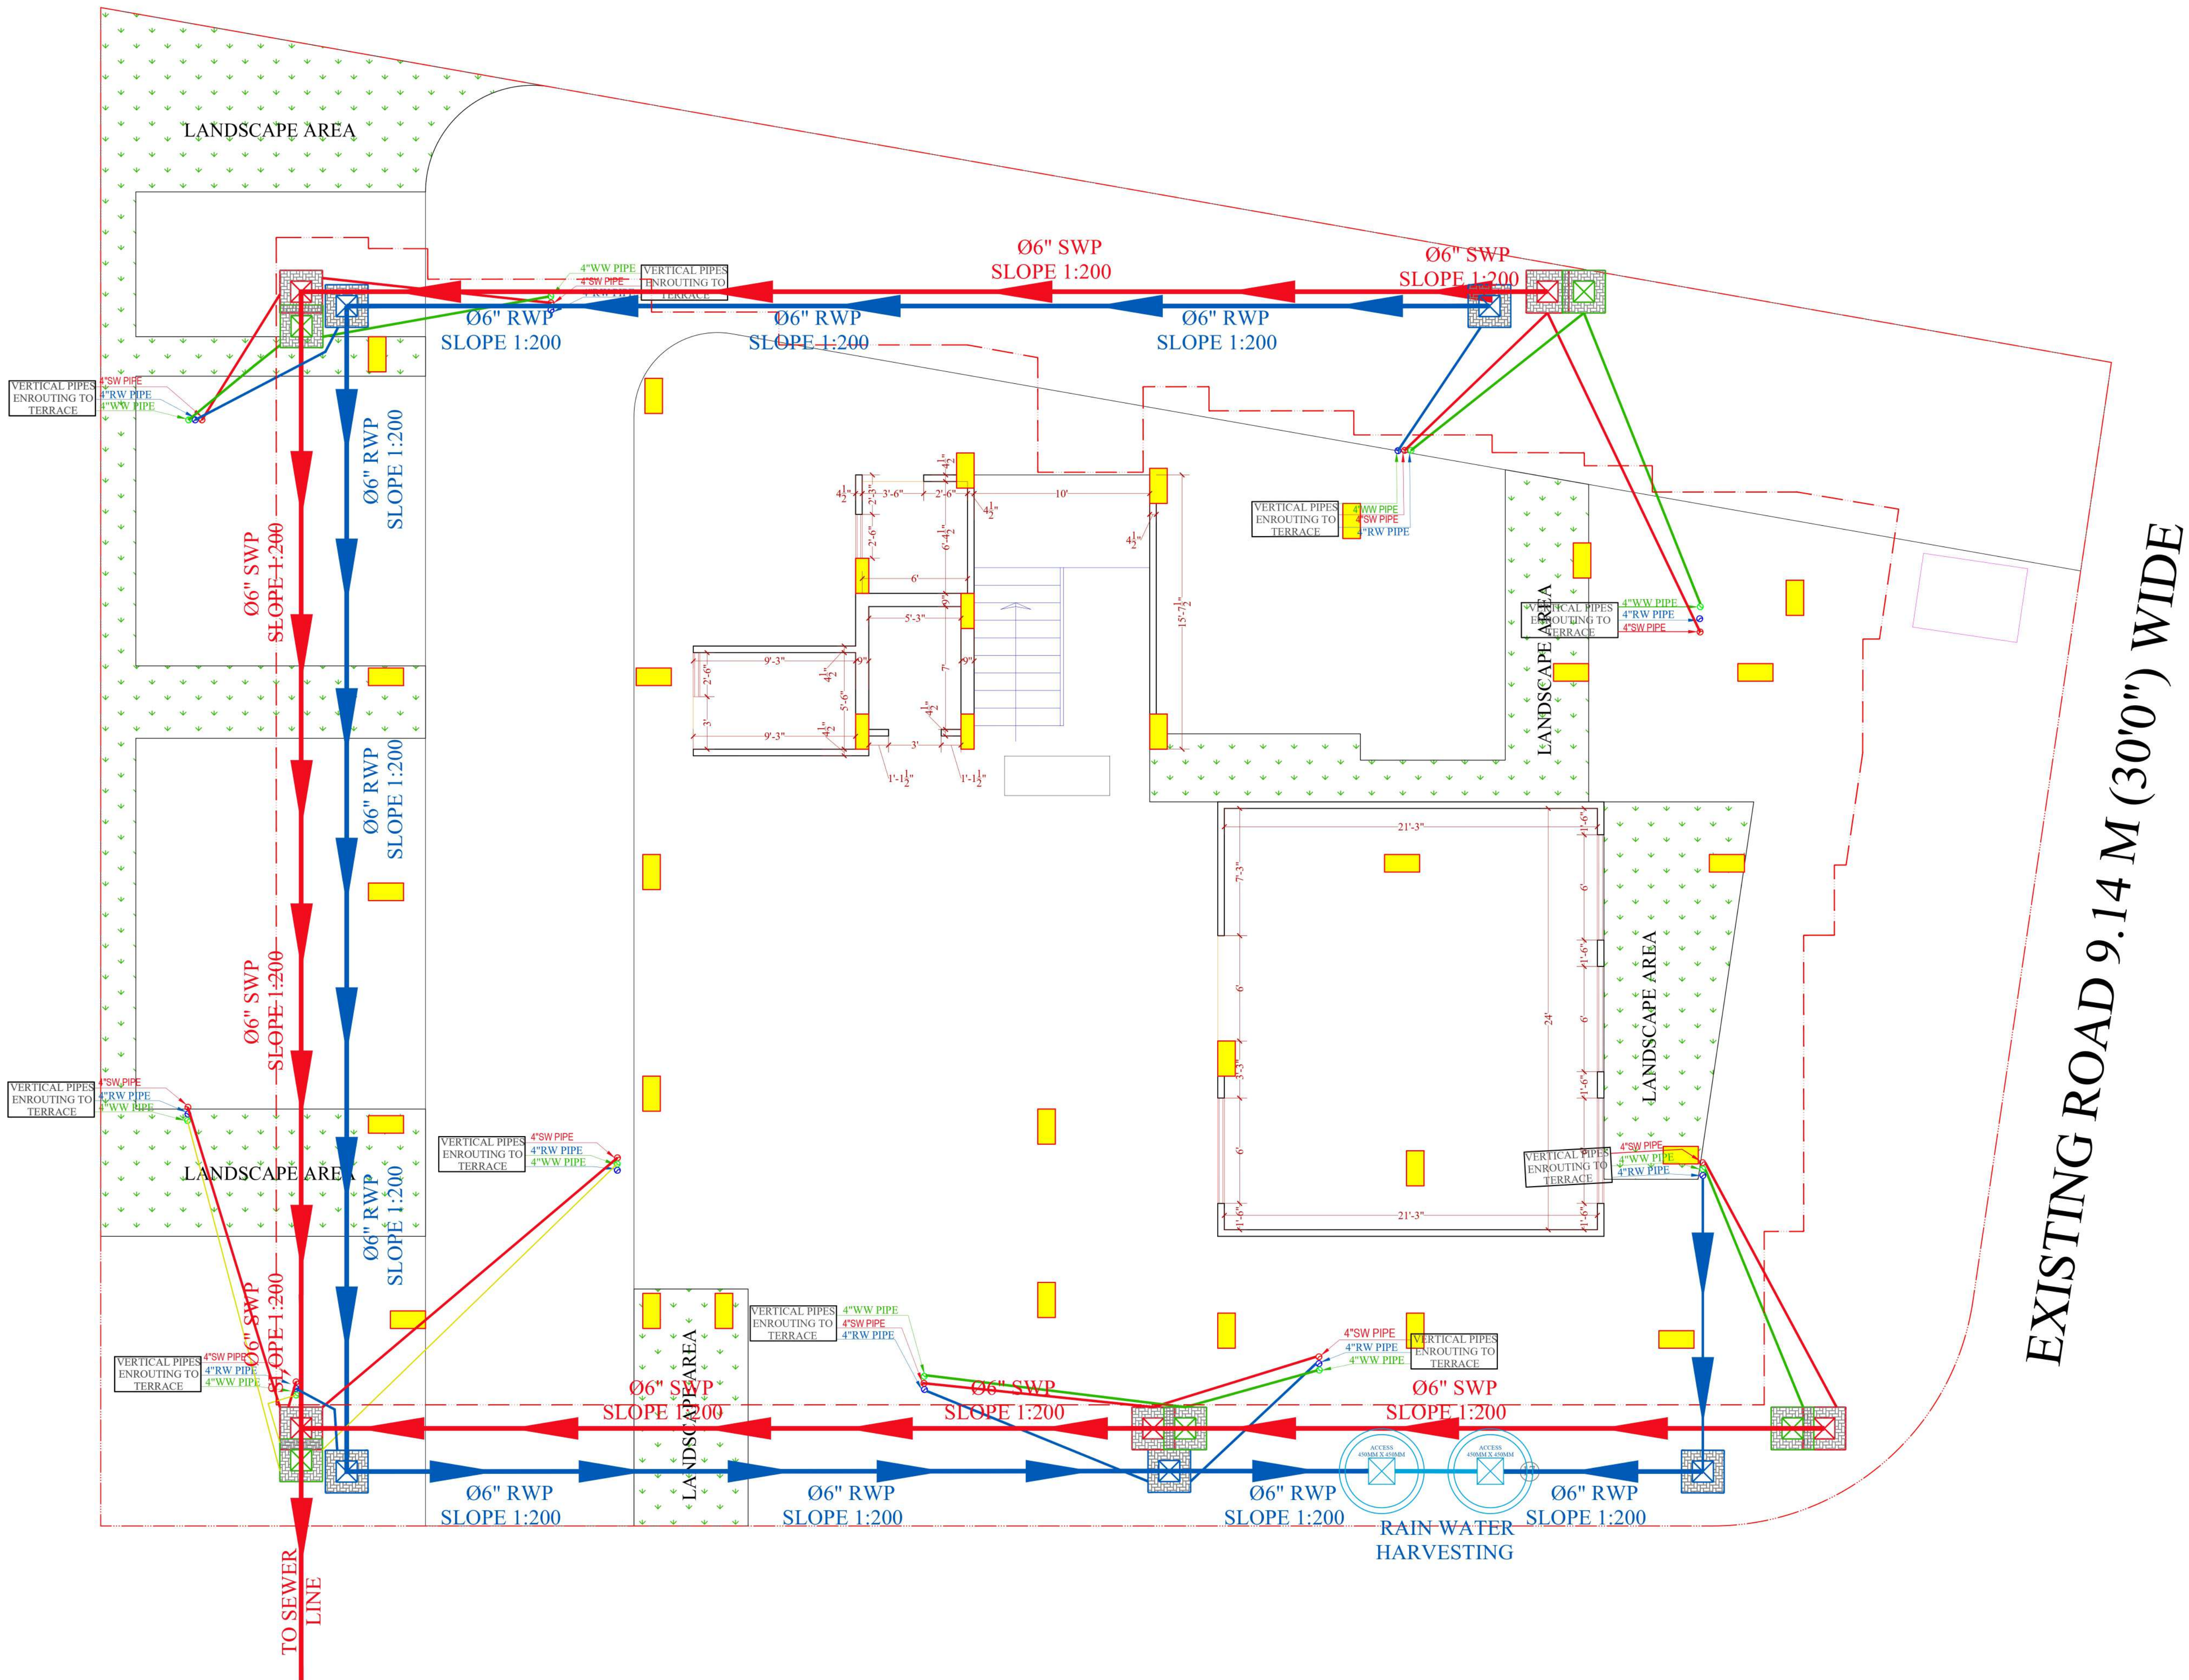

SPECIFICATION:-

1. THIS DRAWING IS THE PROPERTY OF AND SHALL NOT BE USED OR PRODUCE IN ANY MANNER WITHOUT HIS WRITTEN PERMISSION.
2. DIMENSIONS ON THE DRAWINGS ARE TO BE READ NOT SCALED.
3. THE EXECUTING AGENCY IS REQUIRED TO CORRELATE ALL RELEVANT DRAWINGS AND ANY ERRORS OR DISCREPANCIES ARE TO BE BROUGHT TO THE NOTICE OF BEFORE COMMENCE OF WORK

LEGEND:-	
	SWP Ø110MM SOIL WASTE WATER PIPE
	WWP Ø110MM WASTE WATER PIPE
	RWP Ø110MM RAIN WATER PIPE
	Ø110MM & 160MM SOIL WATER PIPE
	Ø110MM & 160MM WASTE WATER PIPE
	Ø110MM & 160MM RAIN WATER PIPE
	Ø75MM WASTE WATER PIPE
	P.T. P-TRAP
	INSPECTION CHAMBER
	GULLY TRAP CHAMBER
	RAIN WATER CHAMBER

PROJECT TITLE:-
JC HEIGHTS 09
C-11 & C-12(NORTH)
NARAYAN PURI 'C',
JAIPUR , RAJASTHAN

CONSULTANTS:-
Er. Sanjay Yadav

CHECKED BY:- Ar. Vikram Jangid	DRAWN BY:- Vivek
SIGNATURE:-	SCALE:- N.T.S.
	DATE:- 01 05 2026
	NORTH
	SHEET:-

SHEET TITLE:-
EXTERNAL DRAINAGE AND RAIN WATER HARVESTING PLAN
SIGNATURES:-

SANJAY YADAV
B.TECH (CIVIL)