


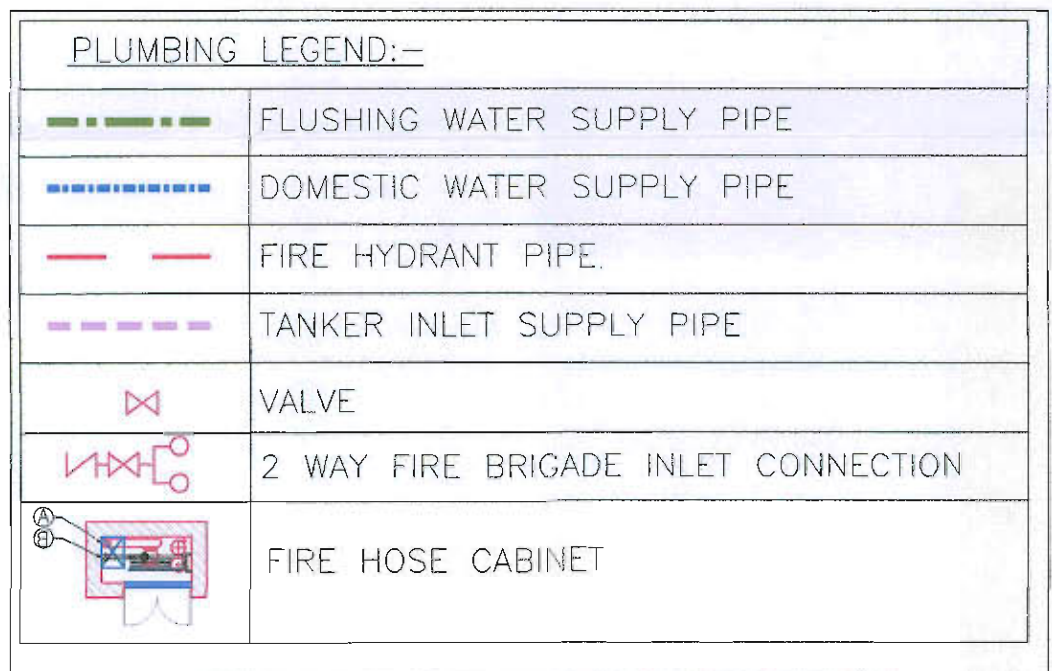

KAPIL DEV

[illegible]

GOOD FOR CONSTRUCTION

Architect's Signature	Client's Signature For Ashiana Housing Limited  Authorised Signatory
-----------------------	--

Key Plan

Project Name
ASHIANA - EKANSI

Project Address
JAIPUR, RAJASTHAN

Drawing Title

SITE PLAN WATER SUPPLY & FIRE FIGHTING LAYOUT

Project No	22.43.R
------------	---------

Scale 1:300

Date 04/04/2024

Drawing No	Revision
------------	----------

PC-AEI-SITE-MEP-WS-100 RO

10-1125 ONE YEAR TWO YEAR	RO
---------------------------	----



FIRE FIGHTING LEGEND:-	
	FIRE HYDRANT PIPE
	TANKER INLET SUPPLY PIPE
	VALVE
	2 WAY FIRE BRIGADE INLET CONNECTION
	FIRE HOSE CABINET

1 SITE PLAN
1:100

FIRE SUBMISSION

PROJECT FILE:
PROPOSED GROUP HOUSING AT
KHASRA NO-
1790,1791,1792,1793,1794,1795,
REVENUE VILLAGE-BHANKROTA
KALAN, TEH-SANGANER, JAIPUR
CLIENT:

ARCHITECTS

Ricky Mathur & Associates
architects interior designers planners
33, Chakraborty Garden,
Jaipur (RAJ) India-302 001
Tel: 91-141-236 2686, 4004700
Fax: 91-141-400 8700
e-mail: ricky@rickymathur.com

SERVICES CONSULTANT

Prion Consultants Private Limited
Building Services - MEP Consulting
B2, Sakdev Vihar,
New Delhi-110 025, India
Tel: 011-26344501 www.prion.net

DRAWING FILE:-

**SITE PLAN
FIRE FIGHTING LAYOUT**

SCALE DATE 04-05-2025

DEALT BY KAPIL STATUS SUBMISSION

ARCHITECTS SIGN.

For BASHARCHITECTURE

BYED BHOND NARAN
CA 93 119955

CLIENT'S SIGN.

For Ashiana Housing Limited

Authorized Signatory

SHEET NO.-02 NORTH