


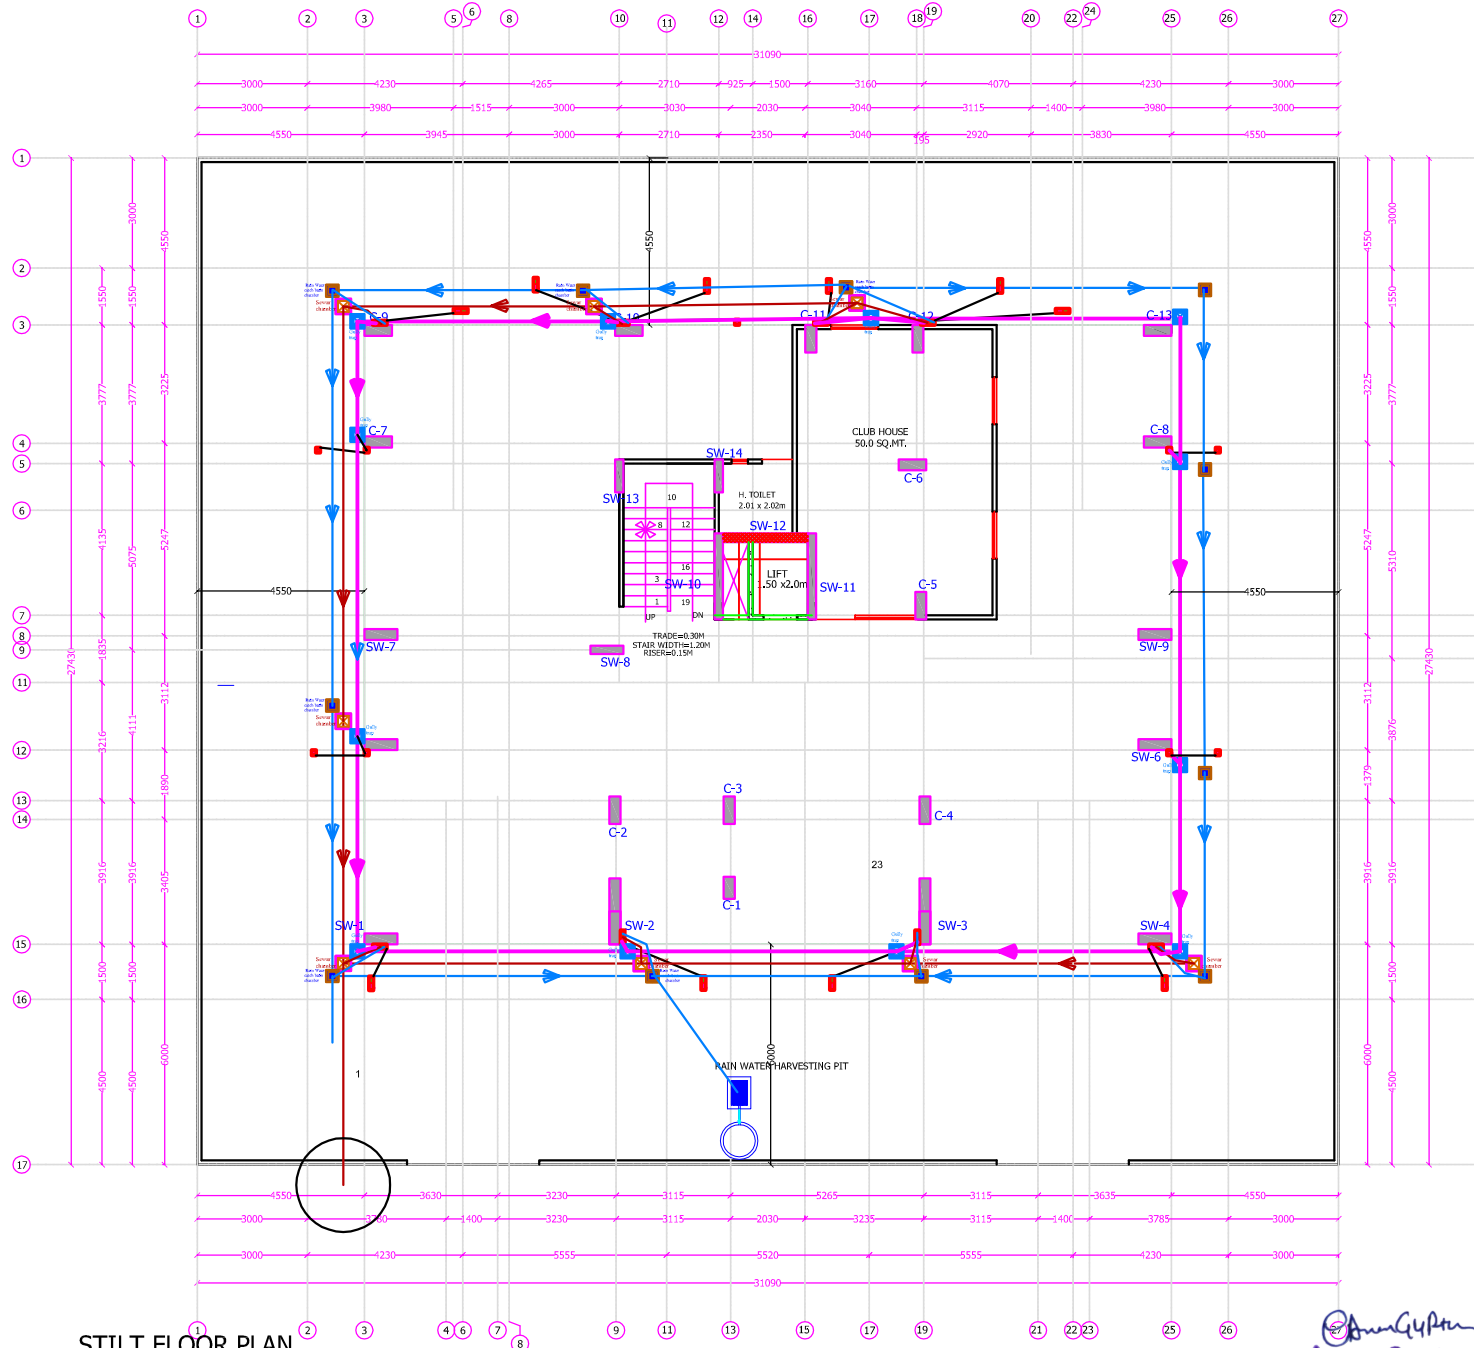

STILT FLOOR PLAN
PROPOSED EXTERNAL SEWERAGE & RAIN
WATER HARWASTING ROUTE PLAN

Aman Gupta
M.E.P. Consultant
B.E. Electrical

GENERAL NOTES

1. ALL DIMENSIONS ARE IN MM, UNLESS SPECIFIED OTHERWISE.
2. THE DIMENSIONS ARE TO BE READ ONLY AND NOT TO BE MEASURED.
3. ANY DISCREPANCY IN THE DRAWING SHOULD BE BROUGHT IN THE NOTICE OF THE ARCHITECT.

SYMBOL	DESCRIPTION
	110 mm Soil Waste Water Pipe
	110 mm Waste Water Pipe
	110 mm Rain Water Pipe
	160 mm Soil Waste Water Pipe
	110 mm Soil Waste Water Pipe
	110 mm Waste Water Pipe
	110 mm Rain Water Pipe
	160 mm Rain Water Pipe
	Flow Direction
	GULLY TRAP 12"x12"
	MANHOLE 18"x18"
	MANHOLE 24"x24"
	MANHOLE 36"x32"
	RAIN WATER CHAMBER 12"x12"
	RAIN WATER CHAMBER 450x450 MM
	RAIN WATER CHAMBER 600x600 MM
	RAIN WATER CHAMBER 30"x24"
	RAIN WATER HARVESTING PIT

TITLE:-

STILT FLOOR PLAN
PROPOSED EXTERNAL SEWERAGE & RAIN
WATER HARWASTING ROUTE PLAN

SCALE:- 1= 100

DATE:

PROJECT:-
PROPOSED RESIDENTIAL APARTMENT FOR
DIVINE RESIDENCY
AT PLOT No(91), 192, KRISHNA SAROVAR
MANSAROVAR, JAIPUR.

CLIENT NAME:-

GURUSAIKUPA BUILDERS LLP
(MR. HARSH KUMAR CHODHARY (Director))

ARCHITECT


M/S AKRITI AYOJAN

ARCHITECTS, INTERIOR DESIGNERS,
E-47, THIRD FLOOR, MANGLAM TOWER, ARBHU BUDA,
GOPAL PURA, JAIPUR-302006, RAJASTHAN. 9051154911
suryaprakash.arch@gmail.com

DATE:

NORTH :



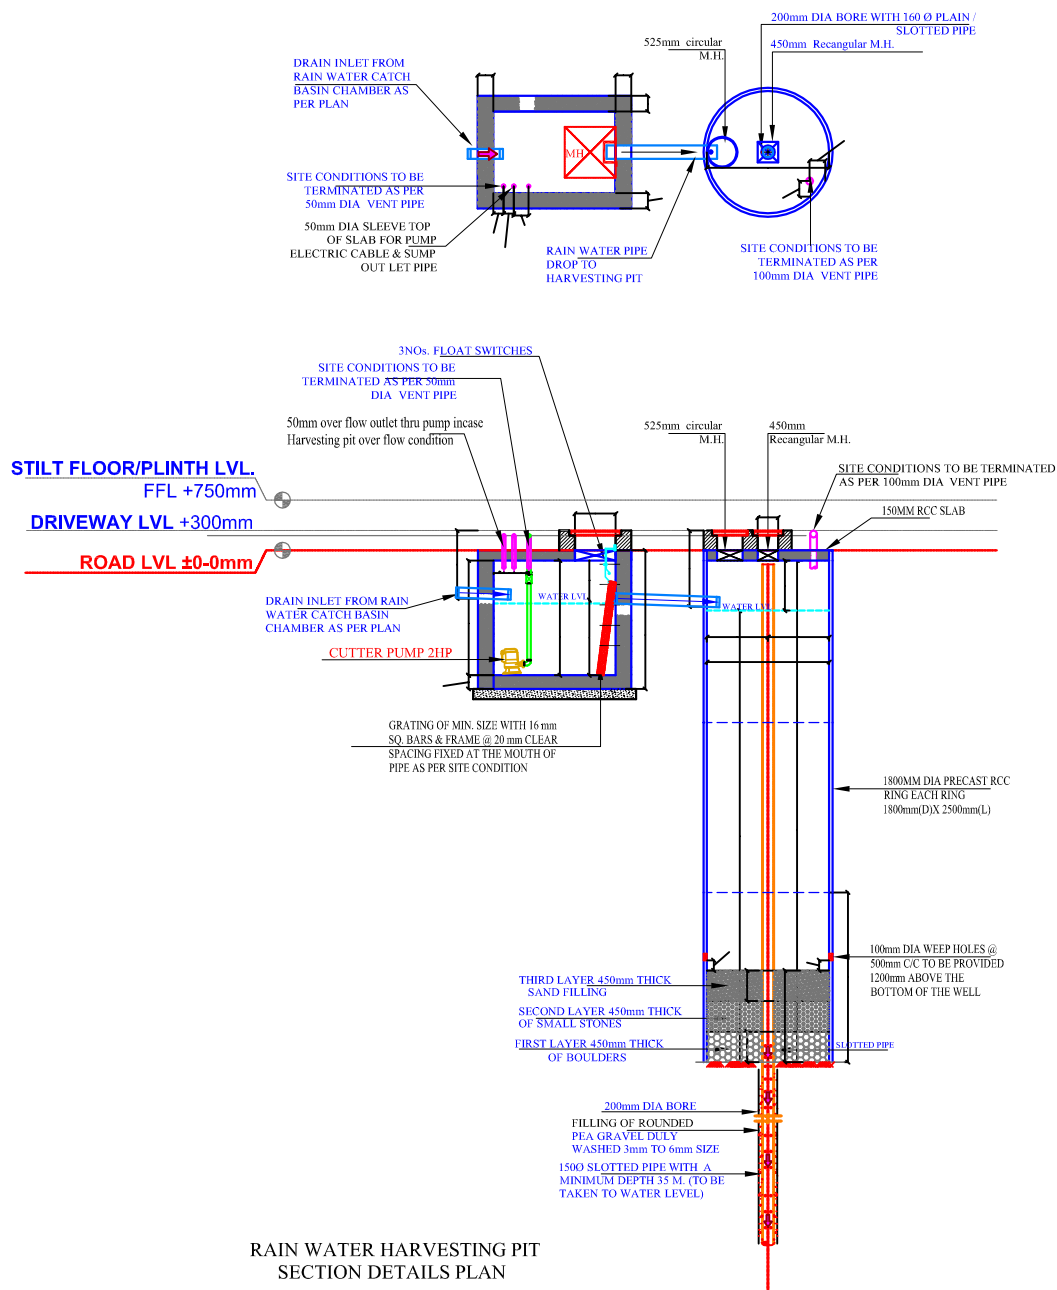

ARCHITECT
SURYA PRAKASH
CA/2006/37839

DRAWING TITLE

RAIN WATER HARVESTING PIT
SECTION DETAILS PLAN

SCALE:- 1= 100

PROJECT:-
PROPOSED RESIDENTIAL APARTMENT FOR
DIVINE RESIDENCY
AT PLOT NO-191,192,KRISHNA SAROVAR
MANSAROVAR,
JAIPUR.

CLIENT NAME:-

GURUSAIKRIPA BUILDERS LLP
(MR. HARISH KUMAR CHOUDHARY(Director))

ARCHITECT

M/S AKRITI AYOJAN

ARCHITECTS, INTERIOR DESIGNERS.

E-87, THIRD FLOOR, MANGLAN TOWER, RDH SECTOR,
GOPALPURA, JAIPUR-46, RAJASTHAN 305115/101
suryaprakash.arch@gmail.com ; 9351154101